

CORNING-PAINTED POST ASD

2025 ERWIN VALLEY ELEM & ADMIN BUILDING ALTERATIONS

16 BEARTOWN ROAD, PAINTED POST, NY 14870

CONSTRUCTION DOCUMENTS

LIST OF DRAWINGS:

ERWIN VALLEY

GENERAL DRAWINGS

EV-G1.1 SYMBOLS AND ABBREVIATIONS
EV-G2.1 FIRST FLOOR PHASING PLAN
EV-G3.1 SITE STAGING AND PHASING PLAN

CODE COMPLIANCE DRAWINGS

EV-CO1.1 CODE COMPLIANCE PLANS

ASBESTOS DRAWINGS

EV-AB1.1 FIRST FLOOR ASBESTOS PLAN - AREA B

SITE DRAWINGS

EV-L0.1 SITE EXISTING CONDITIONS PLAN
EV-L1.1 SITE DEMOLITION PLAN
EV-L2.1 SITE IMPROVEMENT PLAN
EV-L3.1 SITE LAYOUT PLAN
EV-L4.1 SITE GRADING PLAN
EV-L5.1 SITE UTILITY PLAN
EV-L6.1 SITE DETAILS
EV-L6.2 SITE DETAILS
EV-L7.1 SITE E&S CONTROL PLAN
EV-L8.1 SITE E&S CONTROL DETAILS

ARCHITECTURAL DRAWINGS

EV-A0.1 FIRST FLOOR DEMOLITION PLAN - AREA A
EV-A0.2 FIRST FLOOR DEMOLITION PLAN - AREA B
EV-A0.3 FIRST FLOOR DEMOLITION PLAN - AREA C
EV-A0.4 FIRST FLOOR DEMOLITION PLAN - AREA D
EV-A0.5 ROOF DEMOLITION PLAN
EV-A1.1 FIRST FLOOR PLAN - AREA A
EV-A1.2 FIRST FLOOR PLAN - AREA B
EV-A1.3 FIRST FLOOR PLAN - AREA C
EV-A1.4 FIRST FLOOR PLAN - AREA D
EV-A1.5 ROOF PLAN - AREA B & AREA D
EV-A1.6 ROOF DETAILS
EV-A2.1 REFLECTED CEILING PLAN - AREA B
EV-A2.2 REFLECTED CEILING PLAN - AREA D
EV-A4.1 WALL SECTIONS
EV-A5.1 ENLARGED T.R. PLANS + DETAILS
EV-A6.1 DOOR & GLAZING SCHEDULE AND DETAILS
EV-A6.2 STAIR PLANS & DETAILS
EV-A7.1 PARTITION TYPES & DETAILS
EV-A8.1 FIRST FLOOR AND WALL FINISH PLAN - AREA A
EV-A8.2 FIRST FLOOR AND WALL FINISH PLAN - AREA B
EV-A8.3 FIRST FLOOR AND WALL FINISH PLAN - AREA D
EV-A9.1 INTERIOR FINISH SCHEDULES

THEATRICAL DRAWINGS

EV-TR1.1 THEATRICAL RIGGING P.LAN, SECTION & ELEVATION - AREA B
EV-TR1.2 THEATRICAL RIGGING DETAILS - AREA B
EV-TR1.3 THEATRICAL RIGGING DETAILS - AREA B
EV-TR1.4 THEATRICAL RIGGING DETAILS - AREA B
EV-TS1.1 CAFETERIUM AV SYSTEM PLAN
EV-TS2.1 CAFETERIUM AV SYSTEM SINGLE LINE DIAGRAM DETAILS

FOOD SERVICE EQUIPMENT DRAWINGS

EV-FS1.1 KITCHEN EQUIPMENT PLAN
EV-FS1.2 KITCHEN EQUIPMENT ELECTRIC CONNECTION PLAN
EV-FS1.3 KITCHEN EQUIPMENT PLUMBING CONNECTION PLAN
EV-FS1.4 KITCHEN EQUIPMENT MECHANICAL SCHEDULE

PLUMBING DRAWINGS

EV-P0.1 FIRST FLOOR DEMOLITION PLANS - AREA D
EV-P1.1 FIRST FLOOR PLANS - AREA D
EV-P1.2 BASEMENT DOMESTIC PLAN- AREA B
EV-P2.1 SCHEDULES & DETAIL

MECHANICAL DRAWINGS

EV-H0.1 MECHANICAL HVAC DEMOLITION PLAN AREA B AND D
EV-H0.2 MECHANICAL ROOF PLAN AREA B AND D
EV-H1.1 FIRST FLOOR HVAC PLAN - AREA B
EV-H1.2 MECHANICAL ROOF NEW WORK PLAN AREAS B & D
EV-H1.3 FIRST FLOOR NEW WORK PLAN- AREA A AND D
EV-H3.1 SCHEDULES & DETAILS

ELECTRICAL DRAWINGS

EV-E0.1 BASEMENT DEMOLITION PLAN - AREA B
EV-E0.2 FIRST FLOOR DEMOLITION PLAN - AREA B
EV-E0.3 FIRST FLOOR DEMOLITION PLAN - AREA D
EV-E1.1 BASEMENT POWER PLAN - AREA B
EV-E1.2 FIRST FLOOR POWER PLAN - AREA B
EV-E1.3 FIRST FLOOR POWER PLAN - AREA D
EV-E1.4 ROOF POWER PLAN - AREA D
EV-E2.1 FIRST FLOOR LIGHTING & FA PLAN - AREA B
EV-E2.2 FIRST FLOOR LIGHTING & FA PLAN - AREA D
EV-E4.1 SITE ELECTRICAL UTILITY PLAN
EV-E5.1 SCHEDULES & DETAILS

TECHNOLOGY DRAWINGS

EV-T0.1 FIRST FLOOR TECHNOLOGY DEMO KEYPLAN
EV-T0.2 FIRST FLOOR TECHNOLOGY DEMO PLAN - AREA A
EV-T0.3 FIRST FLOOR TECHNOLOGY DEMO PLAN - AREA B
EV-T0.4 FIRST FLOOR TECHNOLOGY DEMO PLAN - AREA C
EV-T0.5 FIRST FLOOR TECHNOLOGY DEMO PLAN - AREA D
EV-T1.1 FIRST FLOOR TECHNOLOGY KEYPLAN
EV-T1.2 FIRST FLOOR TECHNOLOGY PLAN - AREA A
EV-T1.3 FIRST FLOOR TECHNOLOGY PLAN - AREA B
EV-T1.4 FIRST FLOOR TECHNOLOGY PLAN - AREA C
EV-T1.5 FIRST FLOOR TECHNOLOGY PLAN - AREA D
EV-T2.1 TECHNOLOGY DETAILS

ADMIN BUILDING

ARCHITECTURAL DRAWINGS

AD-A3.1 EXTERIOR PAINTING FLOOR PLAN AND ELEVATION
AD-A3.2 EXTERIOR PAINTING ELEVATIONS

PLUMBING DRAWINGS


AD-P0.1 BASEMENT DEMOLITION PLAN
AD-P1.1 BASEMENT PLANS

ELECTRICAL DRAWINGS

AD-E1.1 GROUND FLOOR ELECTRICAL PLAN


































































CORNING-PAINTED POST
AREA SCHOOL DISTRICT

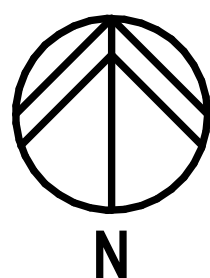


ISSUED FOR BID: 10/12/2026
ISSUED DATE: 03/17/2026
HUNT PROJECT NUMBER: 2649.160
ERWIN VALLEY SED #: 57-10-00-01-0-009-027
ADMIN BUILDING SED #: 57-10-00-01-1-001-013

THIS IS TO CERTIFY THAT TO THE BEST OF OUR KNOWLEDGE, INFORMATION AND BELIEF - THESE PLANS AND SPECIFICATIONS ARE IN ACCORDANCE WITH APPLICABLE REQUIREMENTS OF THE BUILDING CODE, FIRE CODE, AND ENERGY CONSERVATION CONSTRUCTION CODE OF NEW YORK STATE.

HUNT ENGINEERS | ARCHITECTS | SURVEYORS

                                                               
SITEWORK SYMBOLS	SITEWORK SYMBOLS	PLUMBING SYMBOLS	HVAC SYMBOLS	ELECTRICAL SYMBOLS	TECHNOLOGY SYMBOLS	ARCHITECTURAL SYMBOLS	ARCHITECTURAL SYMBOLS
 CONTROL POINT  UTILITY POLE W/ ANCHOR  SIGN  EXG. WATER VALVE  NEW WATER VALVE  UTILITY POLE W/ LIGHT  STREET LIGHT  EXG. FIRE HYDRANT  NEW FIRE HYDRANT  CATCH BASIN/ DRYWELL  CURB BOX VALVE  EXISTING DECIDUOUS TREE  EXG. ELEVATION  NEW ELEVATION  GAS LINE  EXISTING MANHOLE  NEW MANHOLE  NEW CONTOUR  EXISTING ELECTRIC  WATER LINE  SANITARY LINE  TELEPHONE LINE  STORM SEWER  OVERHEAD UTILITY  UNDERGROUND ELECTRIC  ROAD CENTER LINE	 EDGE OF STREAM OR SWALE  SHRUBBERY, WOODS  EXISTING CULVERT  NEW CULVERT WITH END SECTION  TEST PIT  TEST HOLE  RIP RAP  COORDINATE POINT LOCATION  5/8" REBAR WITH SURVEY CAP SET  EXISTING IRON ROD  EXISTING IRON PIPE  UTILITY POLE  ORIGINAL LOT LINE  DEED LINE  PROPERTY LINE  EXISTING FENCE  NEW FENCE  GUARD RAIL  EASEMENT LINE  CONCRETE MONUMENT	 NATURAL GAS PIPING  BELOW SLAB SANITARY PIPING  ABOVE SLAB SANITARY PIPING  BELOW SLAB STORM/ROOF (DRAINAGE) PIPING  ABOVE SLAB STORM/ROOF (DRAINAGE) PIPING  SANITARY VENT PIPING  CONDENSATE DRAIN PIPING  EXISTING PIPING TO REMAIN  EXISTING PIPING AND EQUIPMENT TO BE REMOVED  CHECK VALVE  FLOOR PENETRATION  ACID WASTE  ACID VENT  HOT WATER SUPPLY PIPING  HOT WATER RETURN PIPING  CONDENSATE DRAIN PIPING  REFRIGERANT SUCTION PIPING  REFRIGERANT LIQUID PIPING  EXG. PIPING & EQUIPMENT TO REMAIN  SHUT-OFF VALVE  BALANCING VALVE/ AUTOMATIC FLOW CONTROL FITTING/ SPRINKLER UPRIGHT	 NON-FUSED DISCONNECT SWITCH  FUSED DISCONNECT SWITCH  MAGNETIC STARTER  COMBINATION MAGNETIC MOTOR STARTER AND FUSED DISCONNECT SWITCH  FLUSH WALL MOUNTED POWER PANEL  SURFACE MOUNTED POWER PANEL  MOTOR TYPE ELECTRICAL LOAD  HAND DRYER / HAIR DRYER ELEC. LOAD  UV-UNIT VENT  AHU-AIR HANDLING UNIT  FC-FAN COIL UNIT  P-PUMP  EF-EXHAUST FAN  CU-CONDENSING UNIT  DUPLEX RECEPTACLE WALL MOUNTED GFI-GROUND FAULT CIRCUIT INTERRUPTER  IG-ISOLATED GROUND TYPE WP-GROUND FAULTY TYPE IN WATERPROOF CAST ALUMINUM HOUSING  AC-MNT. ABOVE COUNTER BACKSPLASH  BC-MNT. BELOW COUNTER  SPECIAL RECEPTACLE WITH NEMA CONFIGURATION SHOWN	 LARGE CAPACITY COMMUNICATIONS BOX WITH 2-GANG OPENING  QUAD RECEPTACLE  TOGGLE SWITCH  KEYED TYPE TOGGLE SWITCH  0-10V DIMMING SWITCH  VACANCY SENSOR TYPE SWITCH  CEILING MOUNTED DOWN LIGHT FIXTURE  TRACK LIGHTING WITH FIXTURES  STRIP TYPE LIGHT FIXTURE  RECESSED LIGHT FIXTURE  2'X4' RECESSED LIGHT FIXTURE EM-DENOTED EMERGENCY FIXTURE, CONNECTED TO EMERGENCY CIRCUIT; NL-DENOTES WITE LIGHT CKT. TYPES VARY REFER TO FIXTURE SCHEDULE  PENDANT MOUNTED LIGHT FIXTURE  CEILING MOUNTED EXIT SIGN (SINGLE FACE)  WALL MOUNTED EXIT SIGN (DUAL FACE)  ARROWS FOR EGRESS PATH DIRECTION  EXTERIOR EALL MOUNTED LIGHT FIXTURE  EMERGENCY EGRESS BATTERY BACKUP LIGHT FIXTURE  CEILING MOUNTED VACANCY SENSOR  FIRE ALARM ANNUNCIATOR  FIRE ALARM CONTORL PANEL  *AREA OF RESCUE ASSISTANCE* MAIN CONTROL STATION  *AREA OF RESCUE ASSISTANCE* INTERCOM STATION  ILLUMINATED *AREA OF RESCUE ASSISTANCE* SIGNAGE  MANUAL FIRE ALARM PULL STATION  RATE OF RISE HEAT DETECTOR  FIXED HEAT DETECTOR  SMOKE DETECTOR  DUCT SMOKE DETECTOR  FIRE ALARM VISUAL ANNUNCIATOR  FIRE ALARM AUD-VIS. ANNUNCIATOR  MAGNETIC DOOR HOLDER  HOME RUN OF WIRE AND CONDUIT	 CABLE TRAY  FIBER OPTICAL CABLING  FLOOR POKE-THRU  MULTI COMPARTMENT POWER POLE  PULL BOX  MULTI COMPARTMENT SURFACE RACEWAY  CATEGORY 6 DATA OUTLET  # = QTY. OF DATA OUTLETS IN FACEPLATE IF GREATER THAN ONE  WIRELESS ACCESS POINT WITH CAT. 6 CABLING  WALL MOUNT STYLE CAT. 6 TELEPHONE OUTLET  CATEGORY 6 TELEPHONE OUTLET  # = QTY. OF OUTLETS IF GREATER THAN ONE  IP TELEPHONE LOCATION  PHONE TYPE  CEILING MOUNT SPEAKER  WALL MOUNT SPEAKER  HORN TYPE SPEAKER  SPEAKER VOLUME CONTROL  CLOCK/SPEAKER  CLOCK  TELEVISION OUTLET  PROJECTOR  INTERACTIVE BOARD  AUDIO/VIDEO CONNECTIONS TO PROJECTOR  SECURITY CAMERA  CARD READER  INTERCOM  DOOR CONTRACT SWITCH  REQUEST TO EXIT SENSOR  ELECTRIC DOOR LOCK DEVICE (DOOR STRIKE)  LIGHTNING ARRESTOR  GENERAL SYMBOL ANNOTATIONS  "E" =EXISTING TO REMAIN  "R" =EXISTING TO BE REPLACED  "RE" =EXISTING TO BE RELOCATED  "WG" =PROVIDE WIRE GUARD  "W-MT" =WALL MOUNT COMMUNICATIONS RACEWAY DEVICE LOCATION  COMMUNICATIONS BACKBOX LOCATION	 Room name 101 150 SF  BUILDING SECTION CALLOUT  WALL SECTION/ DETAIL SECTION  INTERIOR ELEVATION CALLOUT  EXTERIOR ELEVATION CALLOUT  DETAIL/TITLE NUMBER  COLUMN GRID LINE  CUT LINE  MATCH LINE  CENTERLINE  ELEVATION MARK OR COORDINATE POINT  ROOF DRAIN  SLOPE  VENT PIPE  EXHAUST HOOD	 EXISTING WALL/ CONSTRUCTION TO REMAIN  DEMOLITION WORK  NEW MASONRY WALL CONSTRUCTION  NEW STUD WALL CONSTRUCTION  ARCHITECTURAL MATERIAL SYMBOLS  EARTH/COMPACT FILL  POROUS FILL/GRAVEL  CONCRETE/ STRUCTURAL CONCRETE  SAND/ ARCHITECTURAL PRECAST CONCRETE  BRICK/BRICK PAVERS  CONCRETE MASONRY  STEEL  FINISH WOODWORK  NOMINAL CUT LUMBER, CONTINUOUS BLOCKING  BLOCKING SHIM  PLYWOOD/ PARTICLEBOARD  PLASTIC/ SOLID SURFACE  BATT INSULATION  RIGID INSULATION  FIREPROOFING  GLAZING  LATH AND PLASTER  CARPET  TERRAZZO  CERAMIC TILE - SECTION  GYPSUM WALL BOARD
<p>*LINES SHOWN AS SCREENED (GRAY) DENOTE EXISTING</p>							

A/C	AREA	CIP	CAST-IN PLACE CONCRETE	EOD	EVERY OTHER COURSE	GVL	GRAVEL	LTL	LINTEL	PCF	POUNDS PER CUBIC FOOT	RPM	REVOLUTIONS PER MINUTE	TPTN	TOILET PARTITION
AB	ANCHOR BOLTS	CIR	CIRCLE	EOD	EDGE OF DECK	GWB	GYPSUM WALL BOARD	LVR	LOUVER	PE	PORCELAIN ENAMEL	RT	RUBBER TILE	TR	TRANSOM
AC	ALTERNATING CURRENT	CJ	CONTROL JOINT	EOS	EDGE OF SLAB	GYP	GYPSUM			PEN	PENETRATION	RTE	ROUTE	TV	TELEVISION, CABLE
AD	AREA DRAIN	CLG	CEILING	EQ	EQUAL	HB	HOSE BIB	MAINT	MAINTENANCE	PERF	PERFORATE(D)	RWC	RAINWATER CONDUCTOR	TYP	TYPICAL
ACT	ACoustical TILE	CLO	CLOSET	EQP	EQUIPMENT	HC	HVAC CONTRACTOR	MATL	MATERIAL	PERM	PERMANENT	SAN	SANITARY, SANITARY SEWER	TZ	TERRAZZO
AD	AREA DRAIN	CLR	CLEARANCE(	EST	ESTIMATE(D)	HCP	HANDICAP	MAX	MAXIMUM	PERP	PERPENDICULAR	SB	SPLASHBLOCK		
ADD	ADDENDUM	CLS	CLOSURE	EW	EACH WAY	HD	HEAVY DUTY	MBF	1000 BOARD FEET	PFB	PREFABRICATED(	SC	SOLIDCORE	UIG	UNDERGROUND
ADH	ADHESIVE	CMP	CORRUGATED METAL PIPE	EWG	ELECTRICAL WATER COOL	HDR	HEADER	MBR	PREFINISHED	PM	PLATE GLASS	SCH	SCHEDULE	UC	UNDERCUT
ADJ	ADJACENT	CMU	CONCRETE MASONRY UNIT	EWF	ELECTRIC WALL FAN	HDW	HARDWARE	MC	MECHANICAL CONTRACTOR(OR)	SCN	SCREEN	SCN	SCREEN	UN	UNIT HEATER
AESS	ARCHITECTURAL EXPOSED STRUCTURAL STEEL	CO	CLEANOUT, COMPANY	EXC	EXCAVATE	HH	HANDHOLE	MECH	MECHANICAL	PKG	PARKING	SD	STORM DRAIN	UNF	UNFINISHED
AGG	AGGREGATE	COL	COLUMN	EXG	EXISTING	HI	HEIGHT OF INSTRUMENT	MED	MEDIUM	PL	PLATE	SDG	SIDING	UNO	UNLESS NOTED OTHERWISE
AHU	AIR HANDLER	COMB	COMBINATION	EXH	EXHAUST	HDJT	HEAD JOINT	MFD	MANUFACTURED	PLAM	PLASTIC LAMINATE	SGC	SECTION	UNP	UNPAINTED
ALU	ALUMINUM	COMP	COMPRESS (ED), (ION), (IBLE)	EXP	EXPOSED	HK	HOOK, HOOKS	MFG	MANUFACTURING	PLAST	PLASTER	SF	SQUARE FOOT	UR	URINAL
ALIGN	ALIGNMENT	CONC	CONCRETE	EXT	EXTERIOR	HMB	HOLLOW METAL	MFR	MANUFACTURE(R)	PFB	POUNDS PER LINEAR FOOT	SEGL	SAFETY GLASS	UV	UNIT VENTILATOR
ALLOW	ALLOWANCE	CON	CONNECTOR, CONNECTION			HOR	HORIZONTAL	MGR	MANAGER	PLS	PLASTIC	SGT	STRUCTURAL GLAZED TILE		
ALT	ALTERNATE	CONST	CONSTRUCTION	FA	FIRE ALARM/FRESH AIR	HP	HORSEPOWER	MH	MANHOLE	PNL	PANEL	SH	SHELF, SHELVE	V	VOLT
AMP	AMPERAGE	CONT	CONTINUOUS, CONTINUE	FAI	FRESH AIR INTAKE	HR	HANDRAIL	MIN	MINIMUM	PNT	POINT(ED)	SHT	SHEET	V	VINYL/RUBBER BASE
ANC	ANCHORAGE(	CONTR	CONTRACTOR(	FAS	FASTENER	HT	HEIGHT	MIR	MIRROR	POB	POINT OF BEGINNING	SHG	SHEATHING	VCP	VITRIFIED CLAY PIPE
ANOD	ANODIZED	COORD	COORDINATE	FB	FACE BRICK	HTG	HEATING	MBGB	MARKERBOARD	PAIR	PAIR	SHWR	SHOWER	VCT	VINYL COMPOSITION TILE
APPROX	APPROXIMATE	CP	CLAY PIPE	FBD	FIBERBOARD	HTR	HEATER	MLD	MOULDING, MOLDING	PRF	PREFORMED	SIM	SIMILAR	VENT	VENTILATOR
ARCH	ARCHITECTURAL	CPG	COPING	FBO	FINISHED BY OTHERS	HTX	HEAT EXCHANGER	MMB	MEMBRANE	PROJ	PROJECT	SKL	SKYLIGHT	VERT (OR V)	VERTICAL
ASB	ASBESTOS	CPR	COPPER	FC	FAN COIL	HVAC	HEATING, VENTILATION, & AIR CONDITIONING	MO	MASONRY OPENING	HRT	PRESERVATIVE TREATED	SL	SLEEVE	VEST	VESTIBULE
ASBC	ASBESTOS CONTRACTOR	CPT	CARPET(ED)	FCU	FAN COIL UNIT	HW	HOT WATER	MOD	MODULAR	PSC	PRE-STRESSED CONCRETE	SMT	SEALANT	VF	VINYL FABRIC
ASPH	ASPHALT	FO	COLD ROLL-ED	FD	FLOOR DRAIN	HWN	HOT WATER HEATER	MON	MONUMENT	PSF	POUNDS PER SQUARE FOOT	SP	SOUND PROOF	VIF	VERIFY IN FIELD
AUX	AUXILIARY	CRS	COURSE(S)	FR	FOLDING DOOR	HYD	HYDRANT	MOV	MOVABLE	PSI	POUNDS PER SQUARE INCH	SPC	SPACER	VIN	VINYL
AVG	AVERAGE	CSMT	CASEMENT	FE	FIRE EXTINGUISHER	MRB	MARBLE	PT	POINT	MRB	MARBLE	PT	POINT	SPEC	SPECIFICATION(S)
AWG	AMERICAN WIRE GAGE	CST	CAST STONE	FEC	FIRE EXTINGUISHER CABINET	ID	INSIDE DIAMETER	MRO	METAL ROOF DECKING	PTD	PAPER TOWEL DISPENSER	SPKR	SPEAKER	VOL	VOLUME
BCU	BLOWER COIL UNIT	CTR	CERAMIC TILE	FF	FINISH FLOOR	INCH")	INCH")	MNT	MOUNT, MOUNTED, MOUNTING	PTN	PARTITION	SPL	SPEAKER	VWC	VINYL WALL COVER
BCJ	BRICK CONTROL JOINT	CU	CUBIC	FFE	FINISH FLOOR ELEVATION	INCIN	INCINERATOR	MTR	METAL FURRING	PTR	PAPER TOWEL RECEPTOR	SQL	SQUARE	W	WIDE, WIDTH
BD	BOARD	CULV	CULVERT	FGL	FIBERGLASS	INCL	INCLUDE, INCLUDED, INCLUDING	MTL	METAL	PV	PAVE(D), PAVING	SSK	SERVICE SINK	WI	WITH
BEJ	BRICK EXPANSION JOINT	CV	CHECK VALVE	FIG	FIGURE	INFO	INFORMATION	MULL	MULLION	PVC	POLYVINYL CHLORIDE	SS	STAINLESS STEEL	WO	WITHOUT
BEL	BELOW	CW	COLD WATER	FIN	FINISHED(	INS	INSULATE, INSULATED	MULT	MULTIPLE	PVCP	PVC PIPE	STA	STATION	WIO	WITHOUT
BEV	BEVELED	CY	CUBIC YARD	FLCO	FLOOR CLEANOUT	INT	INTERIOR	MWK	MILLWORK	PVMT	PAVEMENT	STC	SOUND TRANSMISSION COEFFICIENT	WB	WOODBASE
BF	BOARD FEET			FLX	FLEXIBLE	INT	INTERIOR			PWD	PLYWOOD	STD	STANDARD	WC	WATER CLOSET
BIT	BITUMINOUS	DBL	DOUBLE	FLG	FLASHING	IP	IRON PIPE/IRON PIPE SIZE	NA	NOT AVAILABLE/APPLICABLE			STL	STEEL	WCO	WALL CLEANOUT
BLDG	BUILDING	DC	DIRECT CURRENT	FLOR	FLOURESCENT	NAT	NATURAL	QTY	QUANTITY	QT	QUARRY TILE	STN	STAIN(ED)	WD	WOOD
BLK	BLOCK	DEG	DEGREE	FLR	FLOOR,FLOORING	JC	JANITORS CLOSET	QTR	QUARTER	QTY	QUANTITY	STOR	STORAGE	WF	WALL FIN RADIATION
BLKG	BLOCKING	DEM	DEMOLITION	FND	FOUNDATION	JF	JOINT FILLER	NEG	NEGATIVE	QTR	QUARTER	STR	STRUCTURAL	WG	WIRE(D) GLASS
BM	BENCH MARK	DIA	DIAMETER	FO	FRAMES OPENING	JST	JOIST	NF	NOT FORMERLY	R	RISER(	SUBSTR	SUBSTRUCTURE	WH	WALL HYDRANT
BOF	BOTTOM OF FOOTING	FO	FACE OF CONCRETE	FOC	FACE OF CONCRETE	JNT	JOINT	NIC	NOT IN CONTRACT	SUPT	SURF	SURF	SURF	WHB	WHEEL BUMPER
BOT	BOTTOM	DIA	DIAGONAL	NL	NAILABLE	RC	REINFORCED CONCRETE	NMT	NON-METALLIC	RC	REINFORCED CONCRETE	SUSP	SUSPENDED	WM	WIRE MESH
BPL	BEARING PLATE	FOM	FACE OF MASONRY	KIT	KITCHEN	KNO	KNOCKOUT	NOM	NOMINAL	RA	RETURN AIR	SW	SWITCH	WN	WINDOW
BRG	BEARING	FOS	FACE OF STUDS	KO	KNOCKOUT	KPL	KICKPLATE	NOS	NOISE REDUCTION COEFFICIENT	RAD	RADIUS	RY	RADIUS	WP	WATERPROOF(ED), (ING)
BRK	BRICK	FP	FIREPROOF	NS	NEAR SIDE	NRT	NOT TO SCALE	RBT	RABBIT	RS	RUBBER	SYS	SYSTEM	WS	WATERSTOP
BRKT	BRACKET	FR	FRAME, FRAMED, FRAMING	L	LENGTH	LAB	LABORATORY	OA	OVERALL	RCP	REINFORCED CONCRETE PIPE, REFLECTED CEILING PLAN	T	TREAD	WSCT	WAINSCOT
BS	BOTH SIDES	FRT	FIRE-RETARDANT	LAD	LADDER	LAM	LAMINATE(D)	OBS	OBSCURE	REF	REFERENCE	TAB	TAB	WTW	WALL TO WALL
BTU	BRITISH THERMAL UNITS	DOZ	DOZEN	LAT	LATTICE	LAV	LAVATORY	OC	ON CENTER(S)	REF	REFRIGERANT-(OR), (ED)	TAB	TAB	WWF	WELDED WIRE FABRIC
BUR	BUILT-UP ROOF	FTG	FOOTING	LAV	LAVATORY	LBL	LABEL	OFF	OFFICE	REG	REGISTER	TC	TERRA COTTA	WWM	WELDED WIRE MESH
BW	BOTH WAYS	FUR	FURRED, FURRING	LAV	LAVATORY	LAD	LADDER	REF	REFLECTED(	REIN	REINFORCED(	TEL	TELEPHONE		
C	CHANNEL	DS	DOWNSPOT	LBN	LINEAL	LH	LEFT HAND	OBS	OBSCURE	REQ	REQUIRED	TEMP	TEMPERARY, TEMPERATURE	XSECT	CROSS SECTION
C-C	CENTER TO CENTER	DT	DRAIN TILE	LNG	LONG LEG HORIZONTAL	LQ	LIQUID	OPG	OPPOSITE	REV	REVISED, REVISION(S)	THR	THRESHOLD	YD	YEAR
CAB	CABINET	DTA	DOVETAIL ANCHOR	LQ	LIQUID	OPG	OPPOSITE	REV	REVISED, REVISION(S)	THR	THRESHOLD	TKBD	TACKBOARD		
CAP	CAPACITY	DTA	DOVETAIL ANCHOR	GAS	GAS	GAS	GAGE, GAUGE	LQ	LIQUID	OPG	OPPOSITE	REV	REVISED, REVISION(S)	THR	THRESHOLD
CB	CATCH BASIN	DWG	DRAWING	GALV	GALVANIZED	GB	GRAB BAR	LQ	LIQUID	OPG	OPPOSITE	REV	REVISED, REVISION(S)	THR	THRESHOLD
CBF	HUNDRED BOARD FEET	EA	EACH	GC	GENERAL CONTRACTOR(	OCMU	GLAZED CMU	LL	LONG LEG HORIZONTAL	LLH	LONG LEG HORIZONTAL	PA	PUBLIC ADDRESS	PAR	PARALLEL
CD	COLD DRAWN	EJ	ELECTRICAL CONTRACTOR	GLZ	GLAZING	LL	LONG LEG HORIZONTAL	LLH	LONG LEG HORIZONTAL	PA	PUBLIC ADDRESS	PAR	PARALLEL	TOF	TOP OF FOOTING
CEM	CEMENT	EC	ELECTRICAL CONTRACTOR	GLZ	GLAZING	LL	LONG LEG HORIZONTAL	LLH	LONG LEG HORIZONTAL	PA	PUBLIC ADDRESS	PAR	PARALLEL	TOJ	TOP OF JOIST
CER	CERAMIC	EJ	ELECTRICAL CONTRACTOR	GLZ	GLAZING	LL	LONG LEG HORIZONTAL	LLH	LONG LEG HORIZONTAL	PA	PUBLIC ADDRESS	PAR	PARALLEL	TOF	TOP OF FOOTING
CF	CUBIC FOOT	EL	ELEVATION	GFI	GROUND FAULT INTERRUPTER	LLV	LONG LEG VERTICAL	PA	PUBLIC ADDRESS	PAR	PARALLEL	TOJ	TOP OF JOIST	TOF	TOP OF FOOTING
CFLG	COUNTER FLASHING	ELEC	ELECTRICIAL)	LMS	LIMESTONE	LLV	LONG LEG VERTICAL	PA	PUBLIC ADDRESS	PAR	PARALLEL	TOJ	TOP OF JOIST	TOF	TOP OF FOOTING
CFM	CUBIC FOOT/MINUTE	ELEV	ELEVATOR	GL	GLASS, GLAZING	LP	LIGHT PANEL	PBG	PARTICLE BOARD	PLG	PLUMBING	ROW	ROUGH OPENING	RO	ROUGH OPENING
CFM	COLD-FORMED METAL FRAMING	EMER	EMERGENCY	ENG	ENGINEER	ENG	ENGINEER	ENG	ENGINEER	ENG	ENGINEER	ENG	ENGINEER	ENG	ENGINEER
CFMS	CUBIC FEET/SECOND	ENC	ENCLOSURE	ENG	ENGINEER	ENG	ENGINEER	ENG	ENGINEER	ENG	ENGINEER	ENG	ENGINEER	ENG	ENGINEER
CH	CABINET HEATER	ENG	ENGINEER	ENG	ENGINEER	ENG	ENGINEER	ENG	ENGINEER	ENG	ENGINEER	ENG	ENGINEER	ENG	ENGINEER
CHBD	CHALKBOARD	ENT	ENTRANCE	ENG	ENGINEER	ENG	ENGINEER	ENG	ENGINEER	ENG	ENGINEER	ENG	ENGINEER	ENG	ENGINEER
CI	CAST IRON	ENT	ENTRANCE	ENG	ENGINEER	ENG	ENGINEER	ENG	ENGINEER	ENG	ENGINEER	ENG	ENGINEER	ENG	ENGINEER

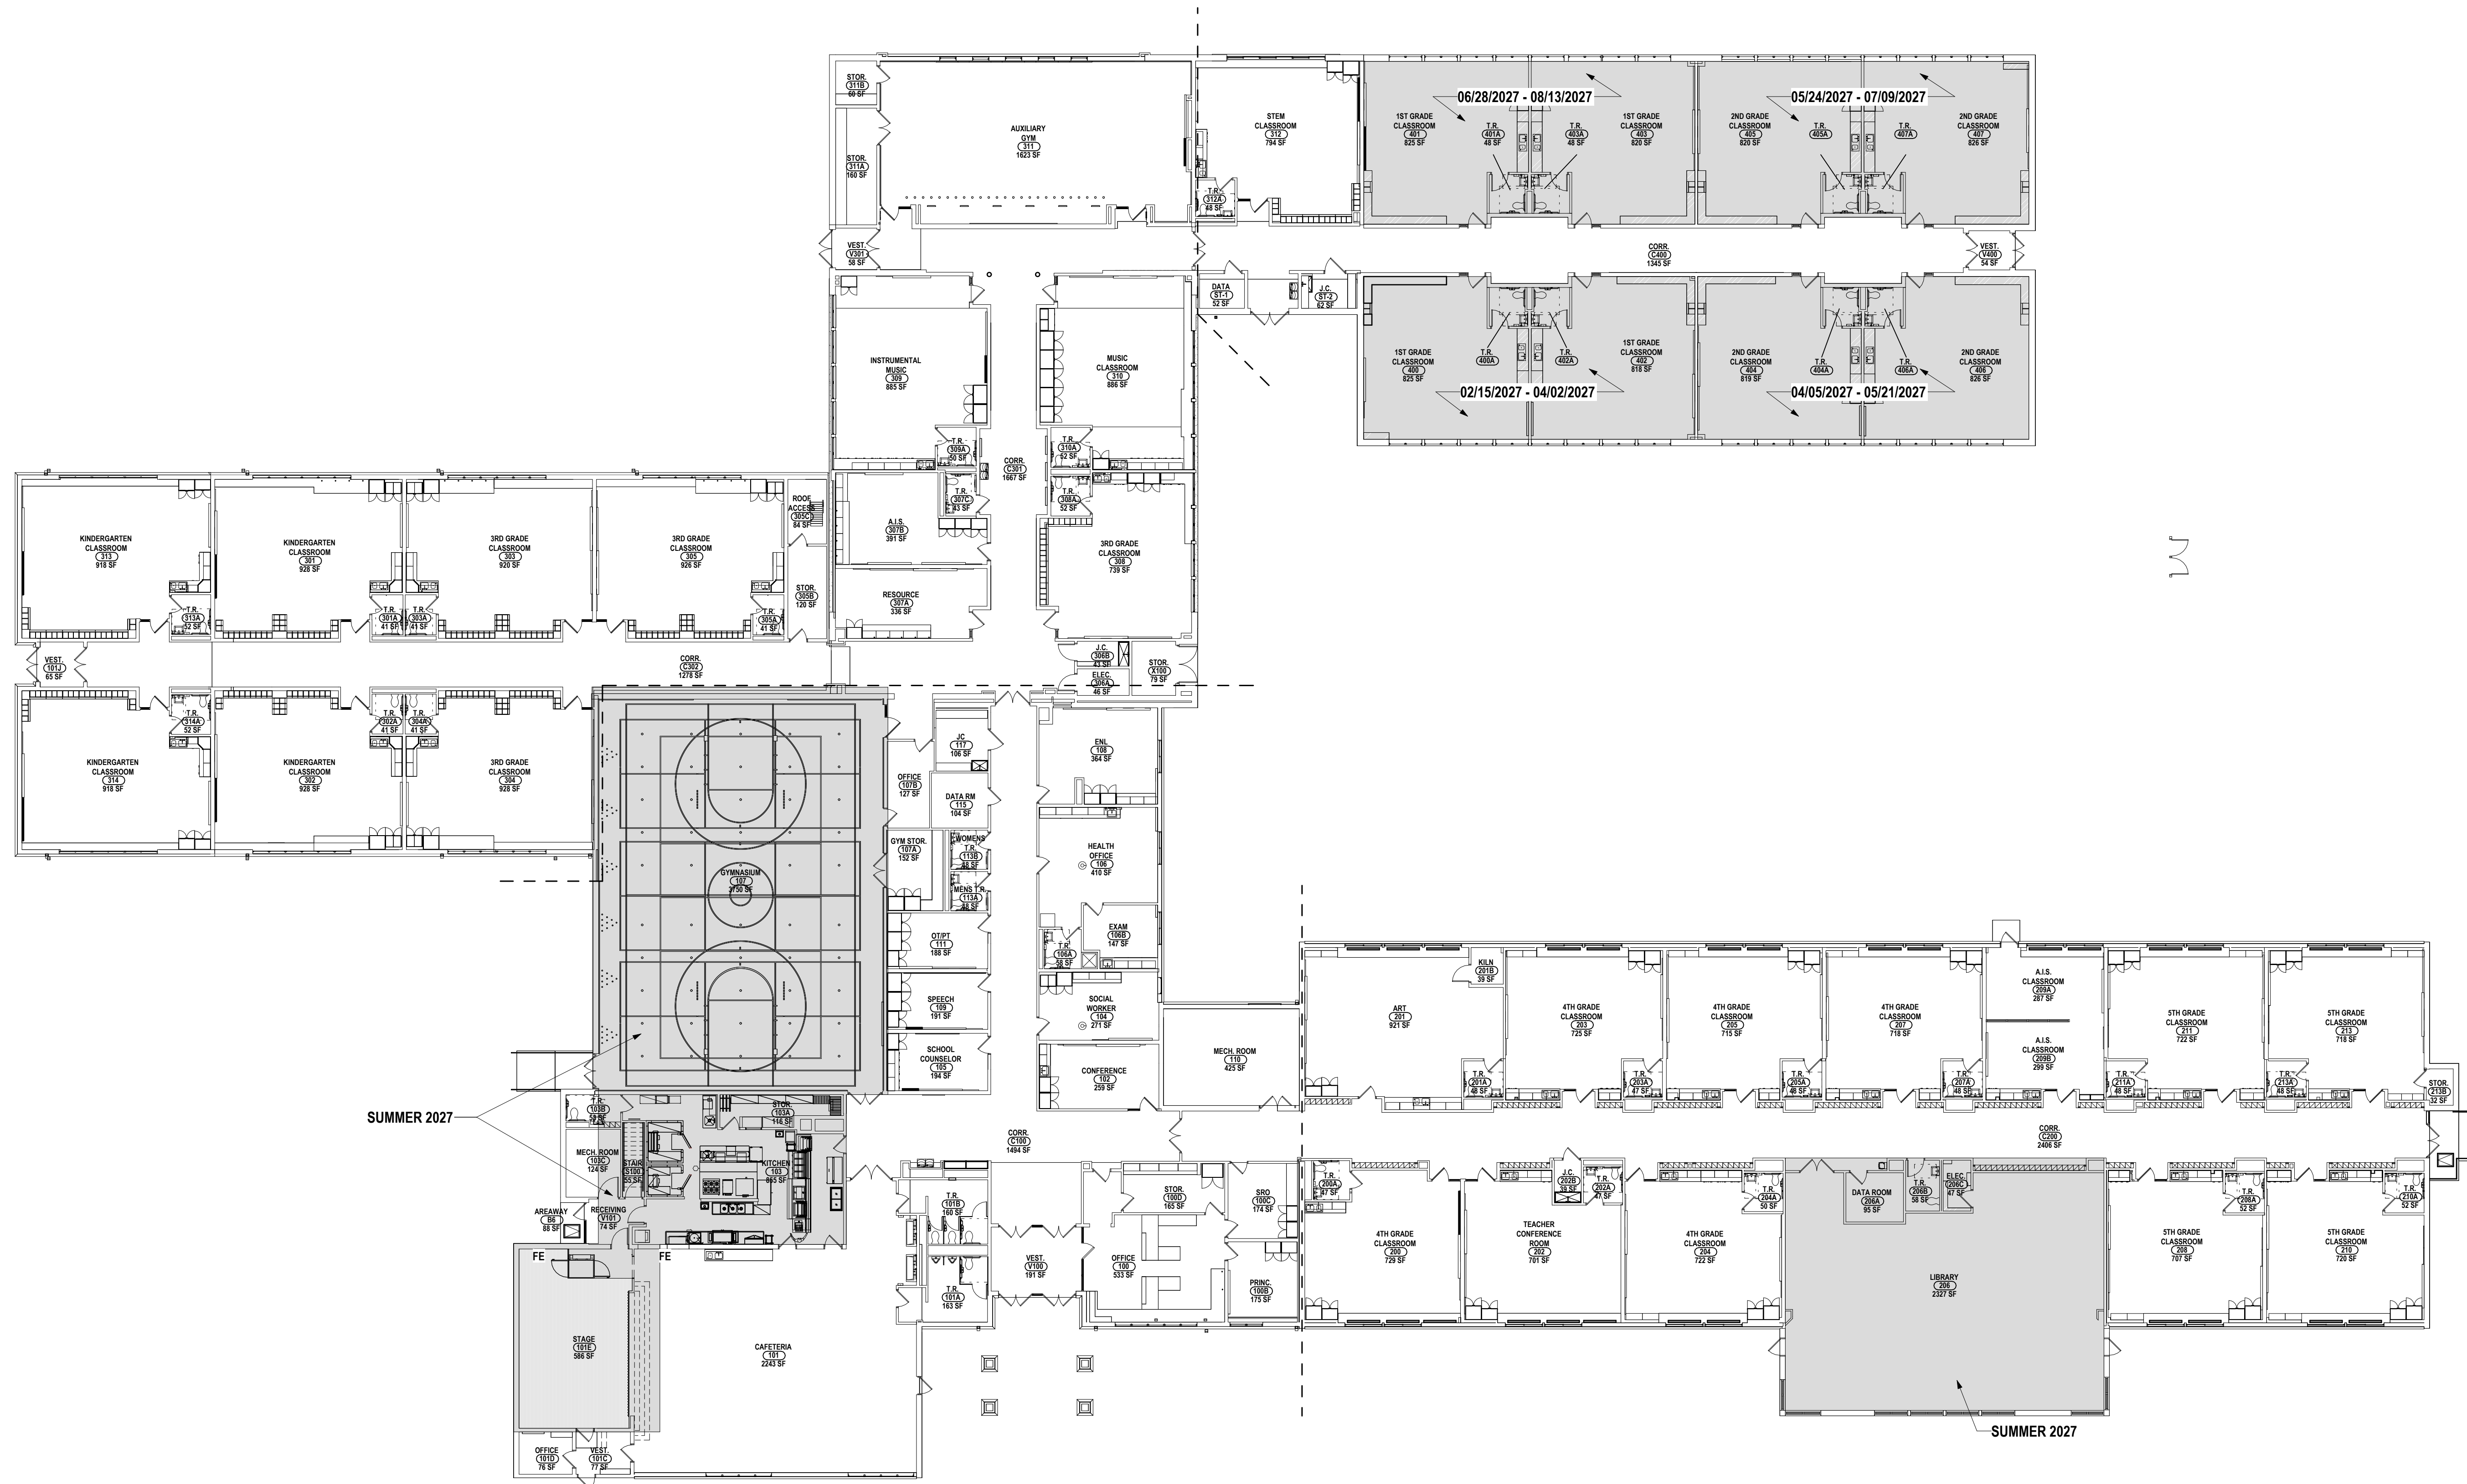

PHASING KEY
UNDER CONSTRUCTION

1 FIRST FLOOR PLAN PHASING
1/16" = 1'-0"

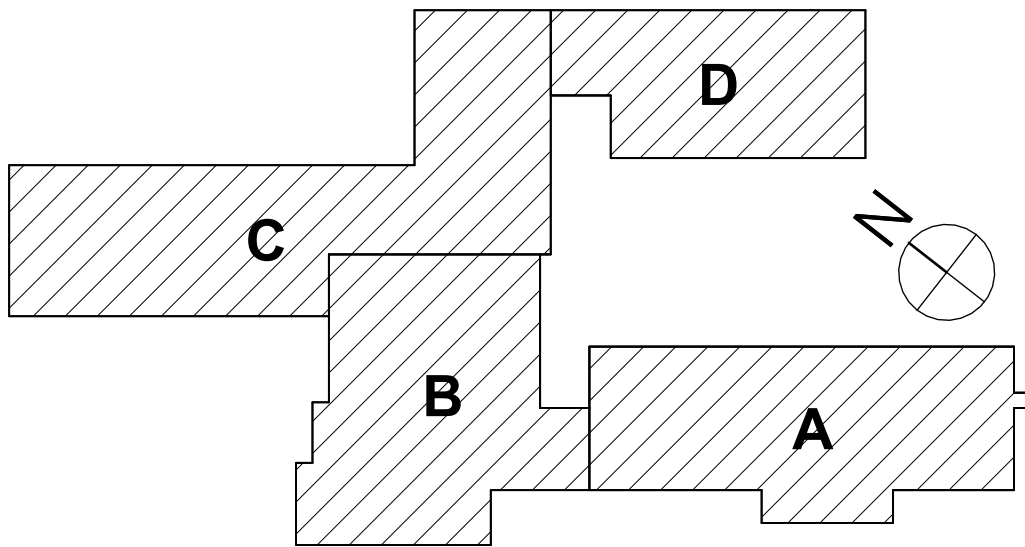

SED #ERWIN VALLEY 1510-0001-0-000-027; ADMIN BUILDING 1510-0001-1-001-013

FIRST FLOOR PHASING PLAN
2025 ERWIN VALLEY ELEM & ADMIN BUILDING ALTERATIONS
CORNING-PAINTED POST ASD
16 BEARTOWN ROAD, PAINTED POST NY 14870

EV-G2.1

PROJECT NO: 2649-160

HUNT ENGINEERS | ARCHITECTS | SURVEYORS
ALBANY, NY • BINGHAMTON, NY • HORSESHOE FALLS, NY • ROCHESTER, NY
100 STATE STREET, SUITE 200 • BINGHAMTON, NY 13902
WWW.HUNT-EAS.COM • 807-358-1000
NY CERTIFICATE NO. 0016320 PA CERTIFICATE NO. TSC2202031464-1

#	DATE:	REVISION:	DRAWN BY:	CAM
1	10/22/2026	ISSUE FOR BID	CHECKED BY:	SZ
			DATE:	03/17/2026
			PHASE:	CD
"IT IS A VIOLATION OF THE LAW FOR ANY PERSON TO MAKE UNAUTHORIZED ALTERATIONS OR ADJUSTMENTS TO PLANS BEARING A LICENSED ENGINEER'S ARCHITECT'S OR SURVEYOR'S SEAL."				



EV-G3.1

PROJECT NO: 2649-160

SITE STAGING AND PHASING PLAN

2025 ERWIN VALLEY ELEM & ADMIN BUILDING ALTERATIONS

CORNING-PAINTED POST AREA SCHOOL DISTRICT

16 BEARTOWN ROAD · PAINTED POST, NY 4870

HUNT ENGINEERS | ARCHITECTS | SURVEYORS
HORSEHEADS, NY 607-369-1090 ROCHESTER, NY 585-537-7940 TOWNANDA, PA 270-205-4668
BINGHAMTON, NY 607-758-5081 ALBANY, NY 607-738-0981
WWW.HUNT-EAS.COM
NY CERTIFICATE NO. 0018220 PA CERTIFICATE NO. TSC220313464-1

DRAWN BY: DD											
CHECKED BY: LG											
DATE: 03/17/2008											
PHASE: CD											
<table><tr><td colspan="3">IT IS A VIOLATION OF THE RULES OF PROFESSIONAL CONDUCT FOR AN ALTERNATE OR ADDITION TO A PROFESSIONAL ENGINEER TO SIGN ANY SET OF CONTRACT DOCUMENTS FOR A PROJECT FOR WHICH HE OR SHE IS NOT LICENSED. VIOLATION OF THIS RULE MAY BE CAUSE FOR DISCIPLINARY ACTION BY THE BOARD OF ENGINEERING PROFESSIONALS.</td></tr><tr><td>#</td><td>DATE</td><td>DESCRIPTION OF REVISION: ISSUE FOR BID</td></tr><tr><td>1</td><td>10/12/2008</td><td></td></tr></table>			IT IS A VIOLATION OF THE RULES OF PROFESSIONAL CONDUCT FOR AN ALTERNATE OR ADDITION TO A PROFESSIONAL ENGINEER TO SIGN ANY SET OF CONTRACT DOCUMENTS FOR A PROJECT FOR WHICH HE OR SHE IS NOT LICENSED. VIOLATION OF THIS RULE MAY BE CAUSE FOR DISCIPLINARY ACTION BY THE BOARD OF ENGINEERING PROFESSIONALS.			#	DATE	DESCRIPTION OF REVISION: ISSUE FOR BID	1	10/12/2008	
IT IS A VIOLATION OF THE RULES OF PROFESSIONAL CONDUCT FOR AN ALTERNATE OR ADDITION TO A PROFESSIONAL ENGINEER TO SIGN ANY SET OF CONTRACT DOCUMENTS FOR A PROJECT FOR WHICH HE OR SHE IS NOT LICENSED. VIOLATION OF THIS RULE MAY BE CAUSE FOR DISCIPLINARY ACTION BY THE BOARD OF ENGINEERING PROFESSIONALS.											
#	DATE	DESCRIPTION OF REVISION: ISSUE FOR BID									
1	10/12/2008										

BUILDING INFORMATION

GENERAL BUILDING INFORMATION:	1993
ORIGINAL YEAR BUILT:	1999, 2002 & 2016
ADDITIONS:	IB
EXISTING CONSTRUCTION TYPE:	E - EDUCATIONAL
NEW CONSTRUCTION TYPE:	1
OCCUPANCY CLASSIFICATION:	YES IN ACCORDANCE WITH NFPA 13
NUMBER OF STORIES:	YES IN ACCORDANCE WITH NFPA 13
EXISTING SPRINKLERED:	
ADDITIONS SPRINKLERED:	

SQUARE FOOTAGE	
BASIC ALLOWABLE BUILDING AREA:	14,500 PER FLOOR FOR TYPE IIB; 58,000 PER FLOOR WITH SPRINKLER 54,114 FIRST FLOOR + 2,917 BASEMENT = 56,161
EXISTING BUILDING AREA:	58,000+10,397 = 68,397 PER FLOOR
ALLOWABLE AREA W/ FRONTAGE INCREASE:	
GROSS SQ. FT. OF BUILDING W/ ADDITIONS:	56,161 SF + 4,683 SF ADDITION = 60,764 SF

BUILDING FIRE RESISTANCE REQUIREMENTS:	
EXTERIOR BEARING WALLS:	NON-COMBUSTIBLE
NON BEARING WALLS:	NON-COMBUSTIBLE
INTERIOR BEARING WALLS OF PARTITIONS:	NON-COMBUSTIBLE
PARTITIONS ENCLOSING SHAFTS:	1 HR
PARTITIONS ENCLOSING CORRIDORS:	1 HR
COLUMNS & BEAMS:	NON-COMBUSTIBLE
FLOOR CONSTRUCTION:	NON-COMBUSTIBLE
ROOF CONSTRUCTION:	NON-COMBUSTIBLE

FIRST FLOOR CORRIDOR TRAVEL DISTANCE:	144 FT. ACTUAL / 150 MAX TRAVEL DISTANCE ALLOWED
BUILDING TRAVEL DISTANCE:	

EGRESS REQUIREMENTS

RESCUE WINDOW:
MINIMUM SIZE: NET CLEAR OPENING OF 6 SQ FT
MINIMUM DIMENSIONS: NET CLEAR HEIGHT SHALL BE 36" NET CLEAR OPENING WIDTH DIMENSION SHALL BE 24"

DOOR WIDTH:
EGRESS WIDTH PER OCCUPANT SERVED .15" (W/ SPRINKLER)

GENERAL NOTES
(APPLIES TO ALL CONTRACTORS U.N.O)

- ALL CORRIDOR, STAIRWELL, MECHANICAL ROOM & SHAFT WALLS ARE TO BE PROVIDED A ONE-HOUR FIRE SEPARATION. (FIRE PARTITION AT CORRIDORS AND FIRE BARRIERS AT STAIRWELLS)
- PROVIDE ONE HOUR UL ASSEMBLY. ALL PENETRATIONS ARE TO BE SEALED WITH ONE HOUR FIRE STOPPING.
- SQUARE FOOT AREA NUMBERS SHALL NOT BE USED IN CALCULATION MATERIAL QUANTITIES. CONTRACTOR IS RESPONSIBLE FOR ALL SQUARE FOOTAGE CALCULATIONS.
- PROVIDE FIRESTOPPING AT ALL NEW AND EXISTING OPENINGS & PENETRATIONS THROUGH ALL FIRE RATED WALLS.
- INDICATED RESEQUE WINDOWS (R.W.) SHALL CONFORM TO NYS EDUCATION DEPARTMENT PLANNING STANDAEAD S104-7.

CONSTRUCTION NOTES
(APPLIES TO GENERAL TRADES CONTRACTORS)

- PROVIDE SIGNAGE IDENTIFYING ALL EXIT PATHS DURING CONSTRUCTION, NEW, EXISTING, AND TEMPORARY.
- MAINTAIN ALL CONSTRUCTION BARRIERS UNTIL NEW OR RENOVATED WORK IS COMPLETE, AND NEW EXIT WAYS ARE APPROVED FOR USE.
- MAINTAIN EXISTING DOORS UNTIL NEW OR TEMPORARY EXISTS ARE IN PLACE.
- PROVIDE TEMPORARLY PARTITIONS WHERE REQUIRED TO SEPARATE WORK AREAS FROM OWNER OCCUPIED AREAS. LOCATIONS OF TEMPORARY PARTITIONS ARE SUBJECT TO APPROVAL BY ARCHITECT. MEANS OF EGRESS SHALL BE MAINTAINED.
- PROVIDE TEMPORARY WALL CONSTRUCTION - 3 5/8" MTL STUD. W/ 5/8" TYPE "X" GWS BOTH SIDES. PARTITION TO BE FULLY EXTENDED TO DECK ABOVE
- PROVIDE TEMPORARY "CONSTRUCTION ZONE, RESTRICTED ACCESS" SIGNAGE IN ALL AREAS UNDER CONSTRUCTION

PLUMBING FIXTURE COUNT

FIXTURE NAME	# REQUIRED (NYS)	# REQUIRED (MPS)	# PROVIDED
GIRLS WATER CLOSETS	15	22	22
BOYS WATER CLOSETS	15	8	19 (+ 2 URINALS)
TOTAL WATER CLOSETS	30	30	41 (+ 2 URINALS)
GIRLS LAVATORIES	15	15	21
BOYS LAVATORIES	15	15	20
TOTAL LAVATORIES	30	30	41
DRINKING FOUNTAINS	15	10	36

1 ADA ACCESSIBLE BATHROOM PROVIDED ON EVERY FLOOR
1 MOP SINK PROVIDED PER FLOOR

ENERGY CONSERVATION
CONSTRUCTION INFORMATION

ENERGY CONSERVATION & CONSTRUCTION CODE OF NEW YORK STATE:
SECTION C402.1.3 INSULATION COMPONENT R-VALUE BASE METHOD

BUILDING ENVELOPE REQUIREMENTS:
(APPLIES TO NEW CONSTRUCTION)
CLIMATE ZONE: 5

ROOF
INSULATION ENTIRELY ABOVE DECK REQUIRED: R-33ci / U-0.030

WALLS ABOVE GRADE
WOOD FRAMED REQUIRED: R-11 + R19ci OR R-19 + R5ci OR R-21 + R-4ci / U0.048

WALLS BELOW GRADE
REQUIRED: R-7.5 ci / C-0.119

FLOORS, SLAB ON GRADE
REQUIRED: R-15 FOR 24" BELOW / F-0.52

DOORS
REQUIRED: UNINSULATED METAL U1.20
INSULATED METAL U0.90
WOOD U0.50

WINDOWS
REQUIRED: METAL U1.20
METAL W/ THERMAL BREAK U1.10
NONMETAL OR METAL CLAD U0.95



WINDOWS (U-FACTOR):
FIXED WINDOW: 0.34<36 (CODE)
SLIDING WINDOW: 0.40<.43 (CODE)

DOORS (U-FACTOR):
ENTRANCE DOORS: 0.4<77

GRAPHIC KEY - CODE COMPLIANCE

- EXISTING TO REMAIN
- NEW CONSTRUCTION
- R.W. RESCUE WINDOW + LABEL U.N.O.
- HANDICAP ACCESSIBLE
- FIRE EXTINGUISHER CABINET
- F.E.C. NEW FIRE EXTINGUISHER & CABINET
- D.F. DRINKING FOUNTAIN
- SMOKE PARTITION W/ DOOR CLOSERS & SMOKE DAMPERS
- 1 HOUR FIRE BARRIER
- PATH OF EGRESS
- EXIT ACCESS TRAVEL DISTANCE. DENOTES THE MAXIMUM DISTANCE TRAVELED TO A BUILDING EXIT OR STAIRWELL ENCLOSURE IN EACH DIRECTION
- COMMON PATH OF EGRESS TRAVEL. DENOTES THE TOTAL DISTANCE TRAVELED BETWEEN EXITS
- 26 OCCUPANT LOAD (MAXIMUM ALLOWABLE OCCUPANT LOAD, ACTUAL OCCUPANCY BASED ON HOME ROOM & STAFF OCCUPANCY)
- EXIT DOOR OCCUPANT CAPACITY
EXIT WIDTH @ 0.2" OCC. = OCCUPANT CAPACITY
STAR WIDTH @ 0.3" OCC. = OCCUPANT CAPACITY
- CORRIDOR OCCUPANT CAPACITY
CORRIDOR WIDTH @ 0.2" OCC. = OCCUPANT CAPACITY
- EXISTING TO REMAIN 57,202 SQ. FT.
- RENOVATIONS AND ALTERATIONS 3,202 SQ. FT.
ALTERATION LEVEL 1: 2,460 SQ. FT.
ALTERATION LEVEL 2: 742 SQ. FT.

BUILDING ALTERATION LEVELS OVERALL

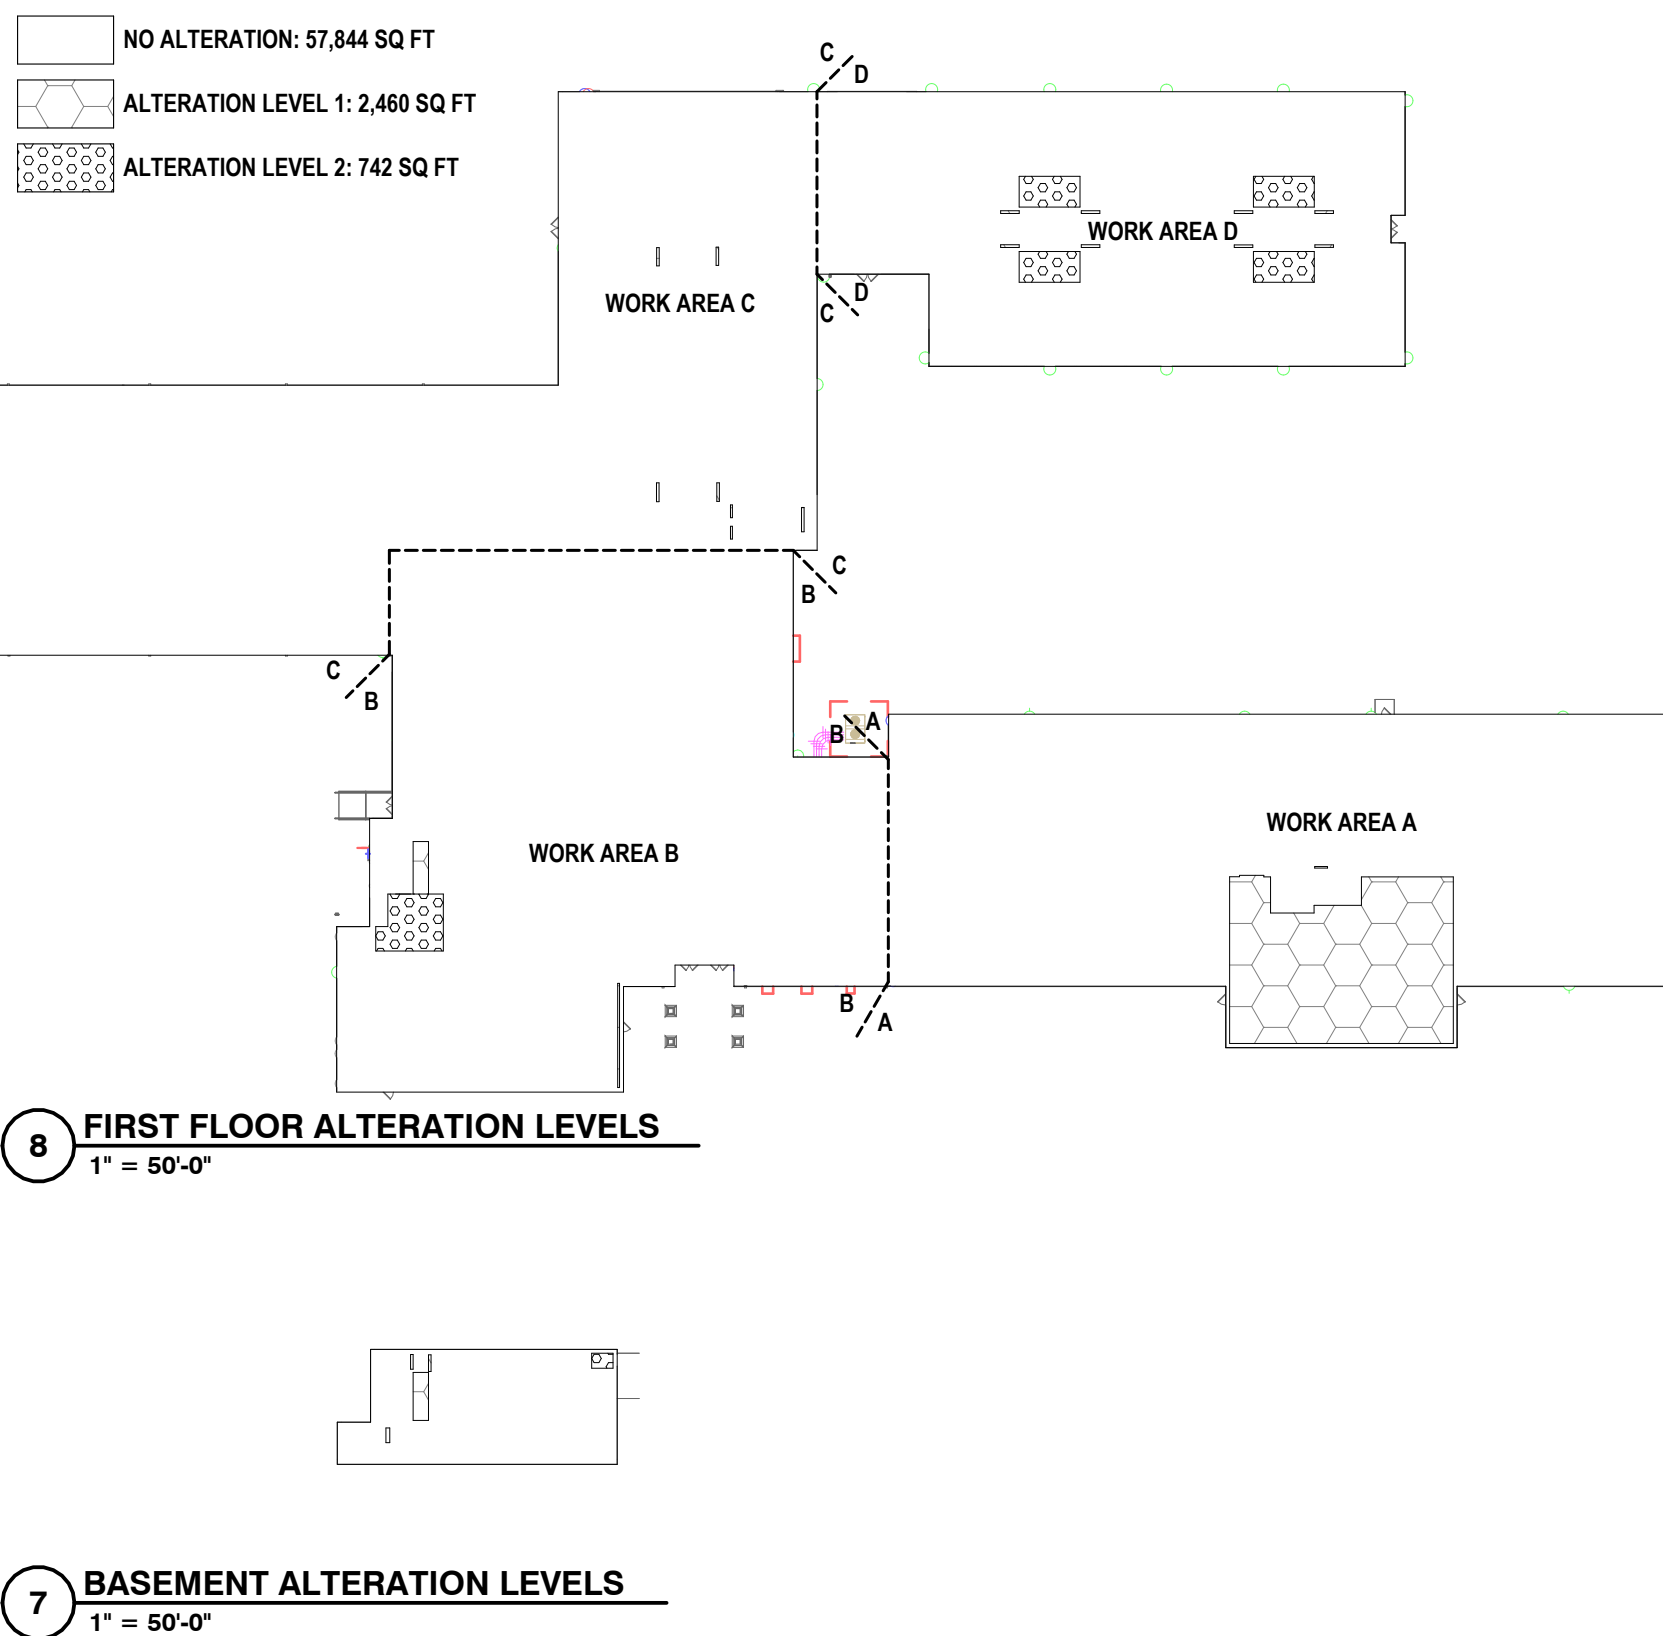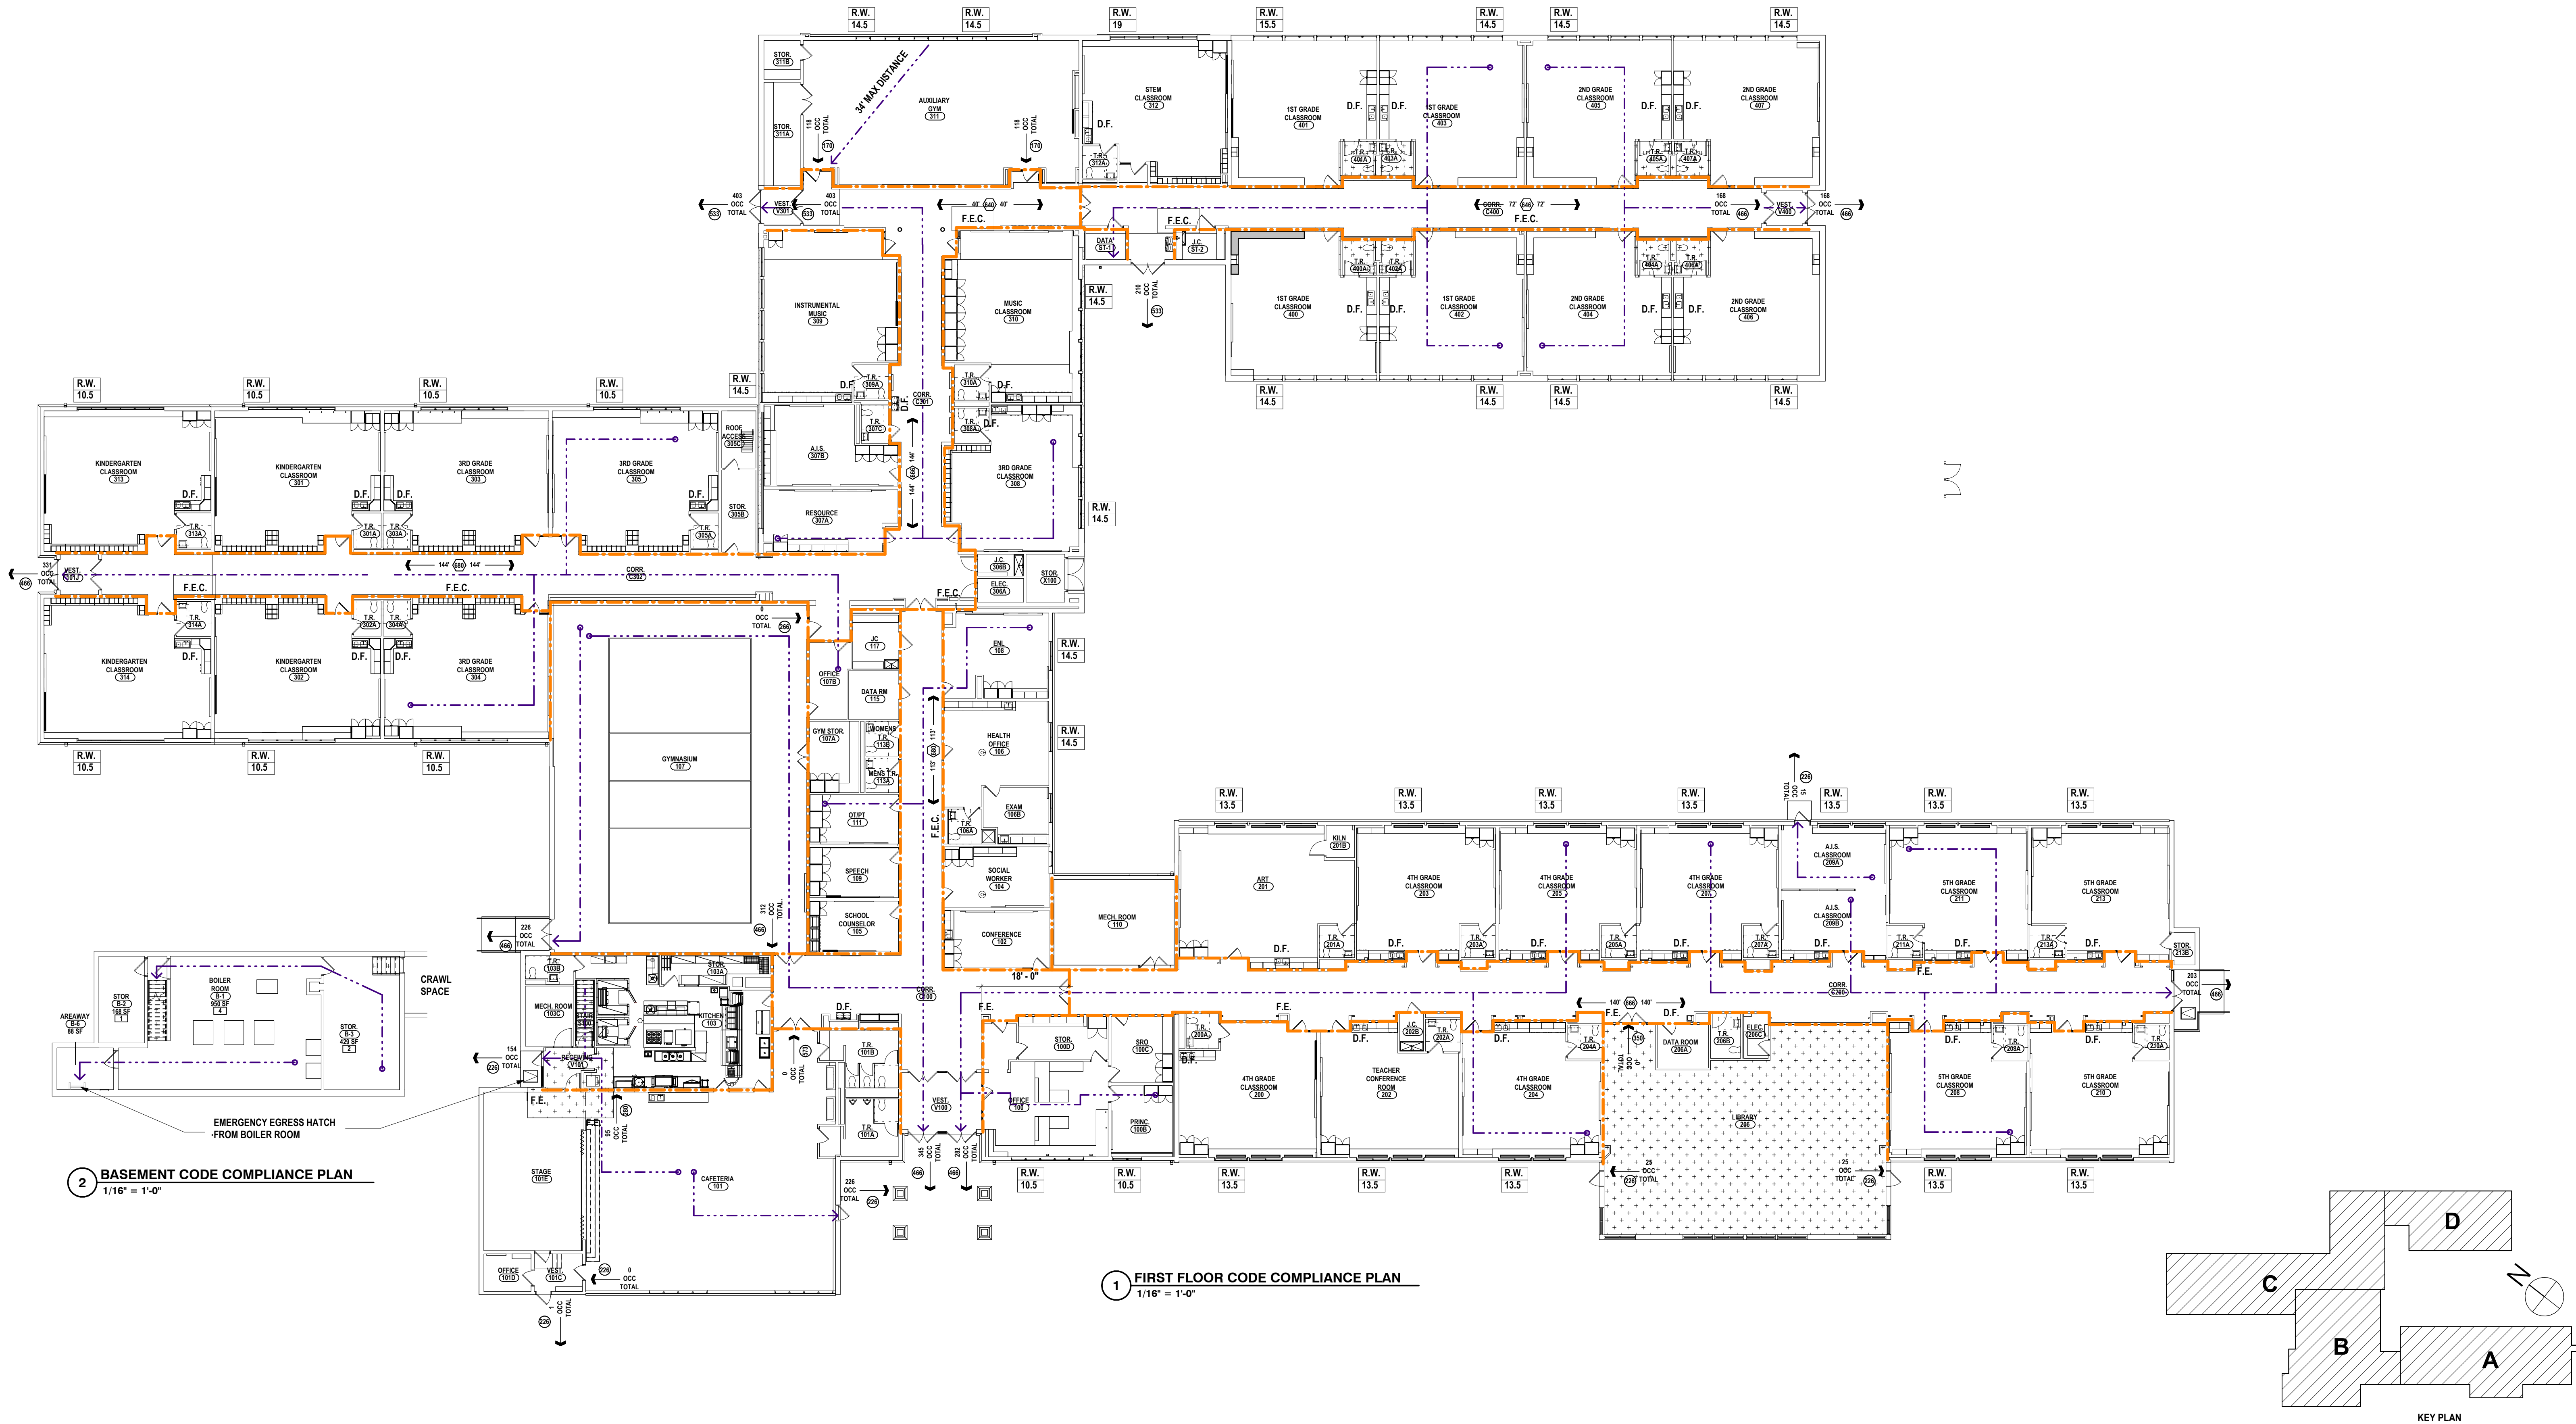

SED #ERWIN VALLEY 15-10-2014-0004-07; ADMIN BUILDING 15-10-2014-1001-031

CODE COMPLIANCE PLANS

2025 ERWIN VALLEY ELEM & ADMIN BUILDING ALTERATIONS

CORNING-PAINTED POST ASD

16 BEARTOWN ROAD, PAINTED POST NY 14870


HUNT ENGINEERS | ARCHITECTS | SURVEYORS

ALBANY, NY - BINGHAMTON, NY - HORSESHOE FALLS, NY - ROCHESTER, NY


WWW.HUNT-EAS.COM 887-358-1000

NY CERTIFICATE NO. 0016320 PA CERTIFICATE NO. TSC220313464-1

EV-CO1.1
PROJECT NO: 2649-160

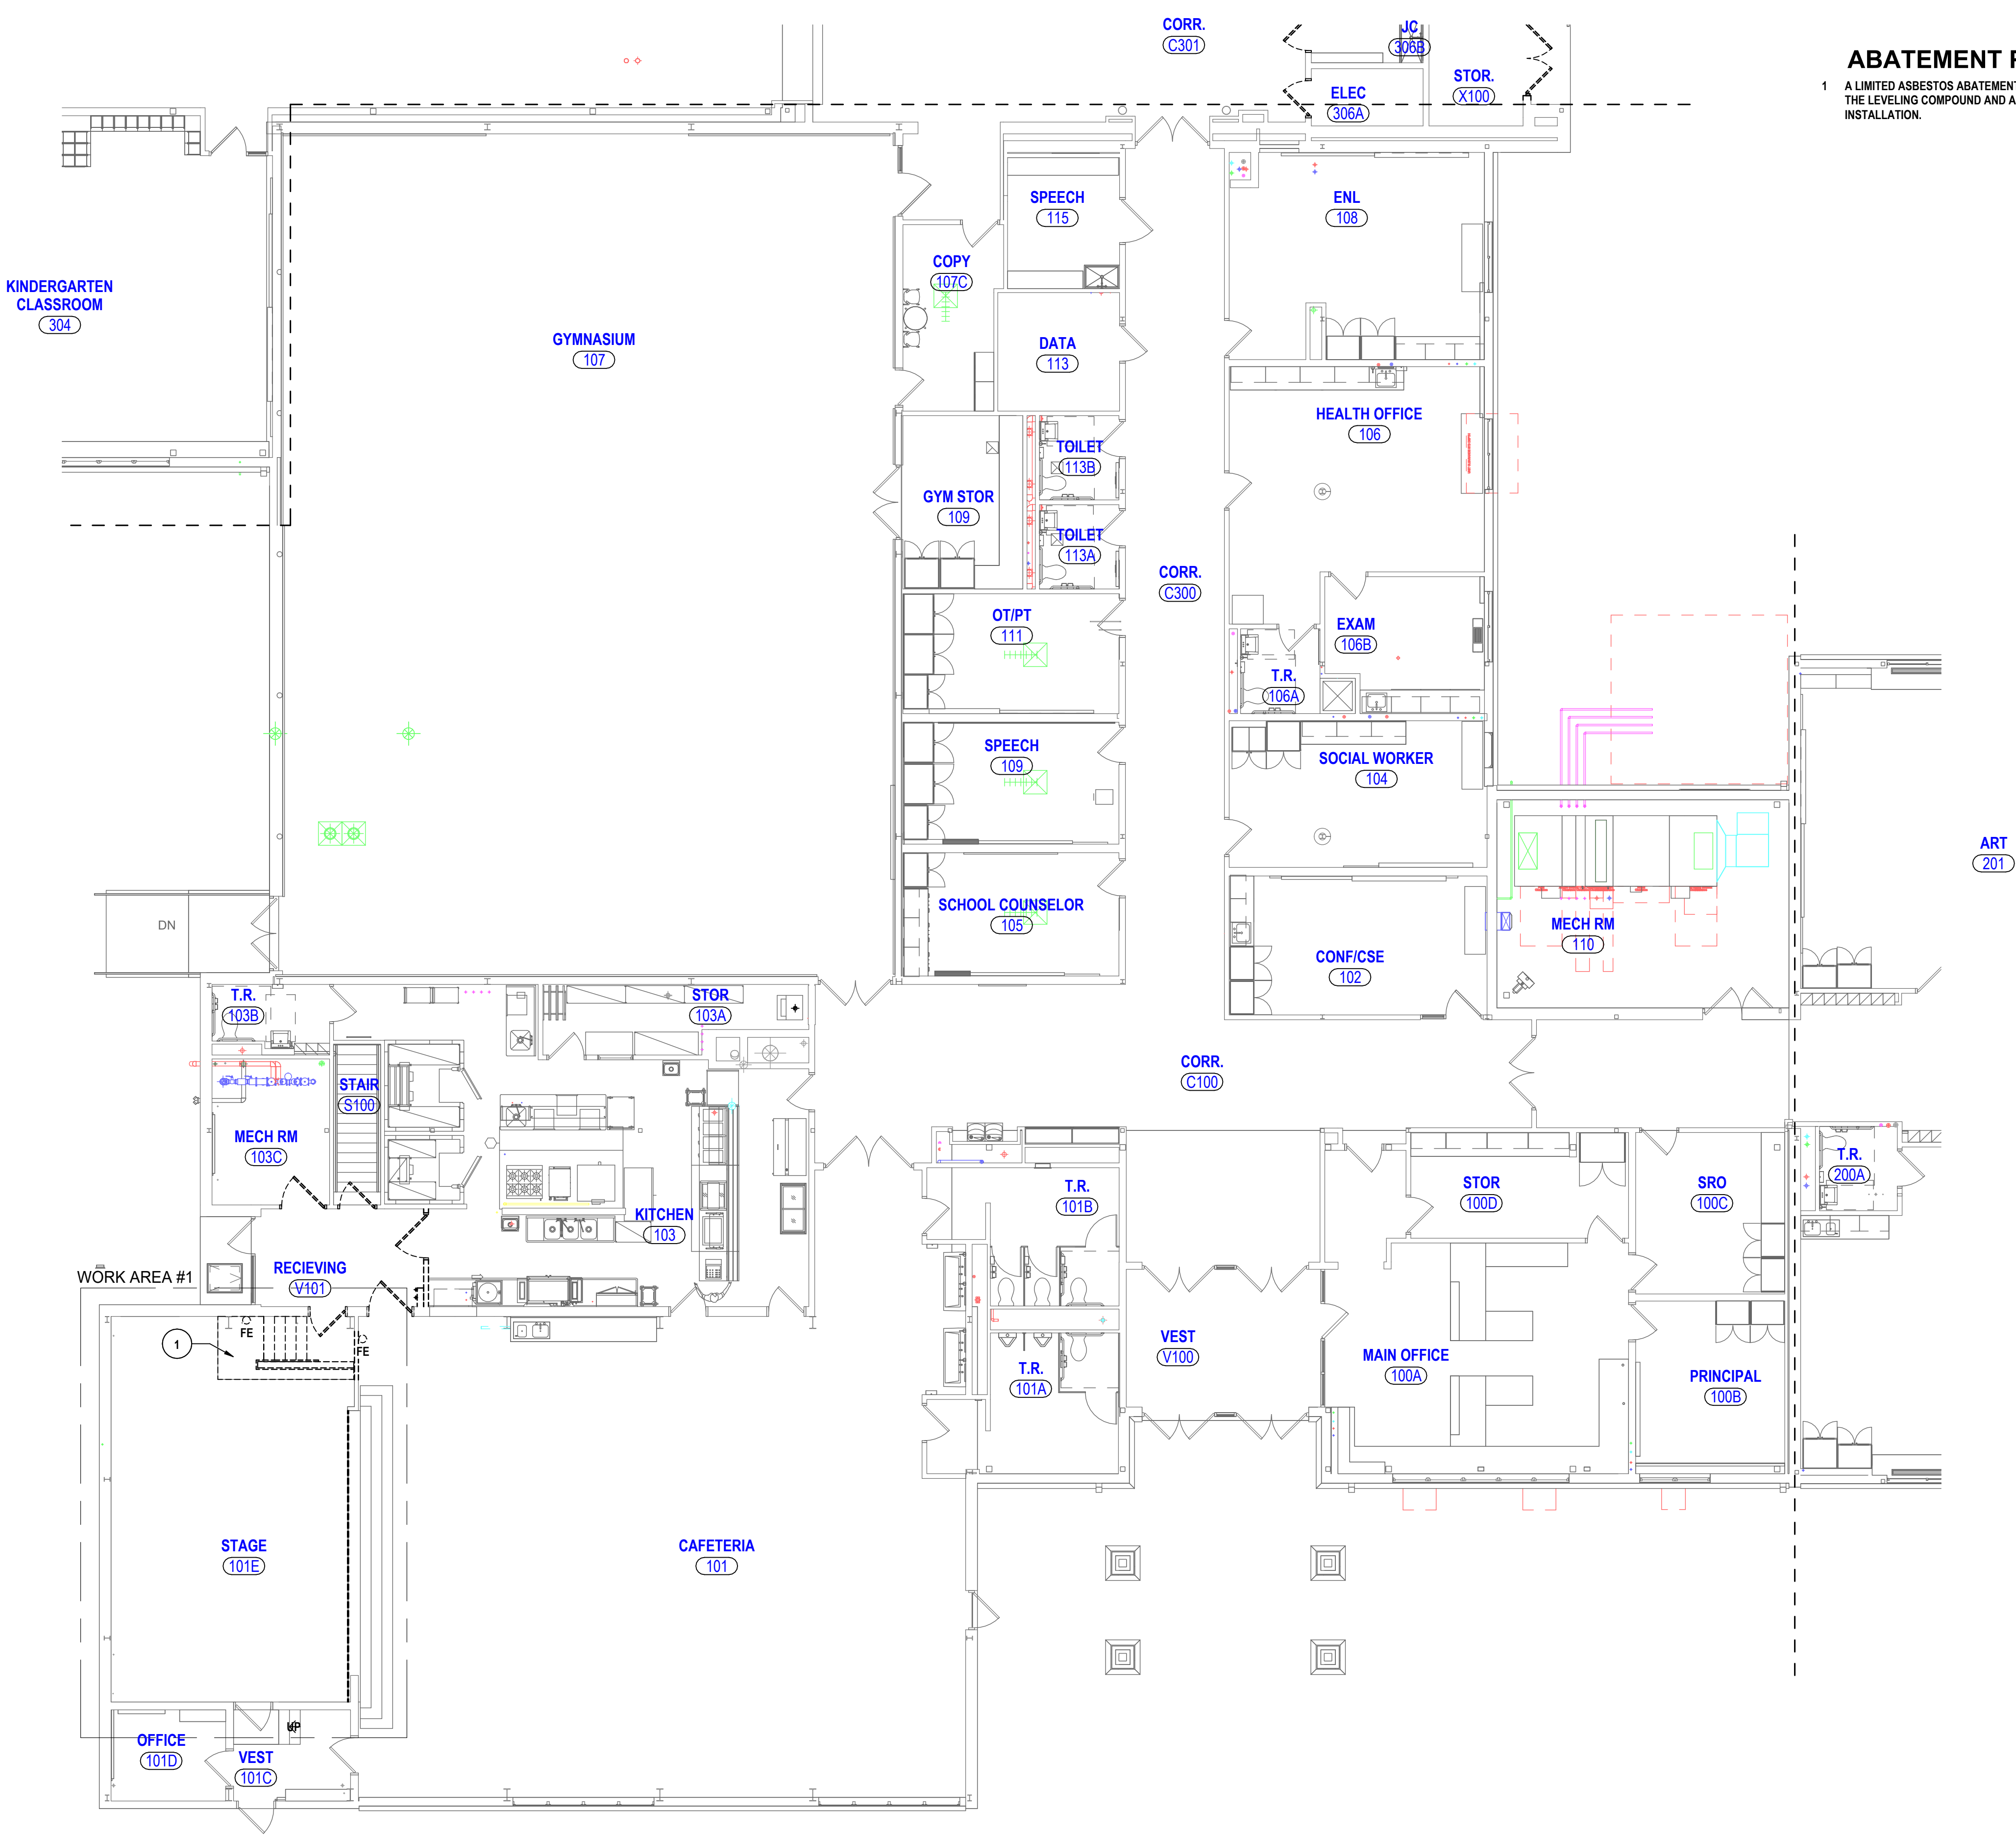

1 FIRST FLOOR ABATEMENT PLAN - AREA B
1/8" = 1'-0"

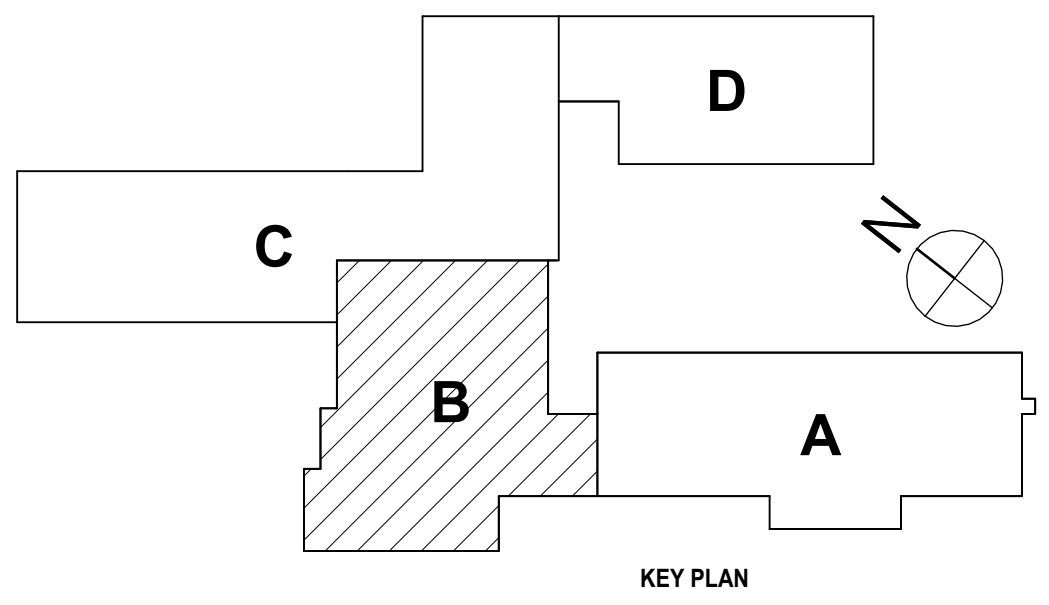

GENERAL ASBESTOS ABATEMENT NOTES:

- A REFER TO SPECIFICATION 02 21 10 ASBESTOS ABATEMENT FOR ADDITIONAL INFORMATION.
- B ALL WORK IS TO COMPLY WITH NYS CODE RULE 56 REQUIREMENTS OR HIGHER. SITE SPECIFIC VARIANCES MAY BE IMPLEMENTED IF APPROVED BY THE ARCHITECT.
- C ASBESTOS SURVEY WAS CONDUCTED AND THE REPORT IS ON FILE WITH THE ARCHITECT.
- D THE REGULATED ABATEMENT WORK AREA SHALL BE VACATED BY THE OCCUPANTS AND NON-CERTIFIED PERSONNEL PRIOR TO WORK AREA PREPARATION, AND SHALL REMAIN VACATED UNTIL THE ASBESTOS PROJECT IS COMPLETE.
- E THE PERSONAL AND WASTE DECONTAMINATION SYSTEM ENCLOSURE(S) SHALL BE PROVIDED OUTSIDE THE REGULATED ABATEMENT WORK AREA AND ATTACHED TO THE BUILDING AT ENTRY/EXIT LOCATION AS PER SECTION 567.5. THESE LOCATIONS SHALL BE REVIEWED AND APPROVED BY THE OWNER/OWNERS REPRESENTATIVE PRIOR TO COMMENCEMENT OF WORK. THE DECONTAMINATION UNIT(S) SHALL BE CORDONED OFF AT A DISTANCE OF TWENTY-FIVE (25) FEET IN ALL DIRECTIONS TO SEPARATE IT FROM PUBLIC AREAS. THE CONTRACTOR SHALL ESTABLISH, MARK AND MAINTAIN PROPER EXITS WITHIN EACH WORK AREA FOR NORMAL AND EMERGENCY USE AND MAINTAIN A CLEAR EGRESS PATH.
- F ALL TOOLS AND EQUIPMENT SHALL BE REMOVED FROM SITE AFTER DECONTAMINATION.
- G AFTER ALL REGULATED ABATEMENT WORK AREAS HAVE BEEN DISMANTLED ANY REMAINING REMOTE DECONTAMINATION ENCLOSURES MUST BE DISMANTLED AND REMOVED FROM SITE. ALL PLASTIC SHEETING SHALL BE REMOVED AND DISPOSED OF ASBESTOS WASTE.
- H ALL WASTE GENERATED AS PART OF ASBESTOS PROJECT SHALL BE REMOVED FROM THE SITE WITHIN TEN (10) CALENDAR DAYS AFTER SUCCESSFUL COMPLETION OF PHASE 11 C FOR ALL REGULATED WORK AREAS.
- I ALL WASTE GENERATED AS PART OF THE ASBESTOS PROJECT SHALL BE LEGALLY DISPOSED OF AT ANY APPROVED LANDFILL FACILITY. ALL GENERATED WASTE REMOVED SHALL BE DOCUMENTED, ACCOUNTED FOR AND DISPOSED OF IN COMPLIANCE WITH REQUIREMENTS OF EPA NESHAP.
- J THE CONTRACTOR SHALL REMOVE THE MASTIC UTILIZING A BIODEGRADABLE MASTIC REMOVER. NO OPEN CANS OF MASTIC REMOVAL WILL BE ALLOWED TO BE BROUGHT ON SITE.

ABATEMENT PLAN DRAWING NOTES:

- 1 A LIMITED ASBESTOS ABATEMENT WILL BE PERFORMED WHICH INCLUDES THE REMOVAL OF THE WOOD FLOOR AND BOTH THE LEVELING COMPOUND AND ASBESTOS CONTAINING MASTIC IN THE LOCATION OF THE PROPOSED CHAIR LIFT INSTALLATION.

DRAWN BY: CAM	
CHECKED BY: SZ	
DATE: 03/17/2026	
PHASE: CD	
#	REVISION:
1	10/22/2026
ISSUE FOR BID	
"IT IS A VIOLATION OF THE LAW FOR ANY PERSON TO MAKE UNAUTHORIZED ALTERATIONS OR ADDITIONS TO PLANS BEARING A LICENSED ENGINEER, ARCHITECT'S OR SURVEYOR'S SEAL."	

HUNT

ENGINEERS | ARCHITECTS | SURVEYORS

ALBANY, NY • BINGHAMTON, NY • HORSENEADS, NY • ROCHESTER, NY
ROSELAND, NY • SUNY AT BUFFALO, NY • SUNY AT ESSEX, NY
WWW.HUNT-EAS.COM 807-358-1000
NY CERTIFICATE NO. 0016320 PA CERTIFICATE NO. TSC220313464-1

FIRST FLOOR ASBESTOS PLAN - AREA B

2025 ERWIN VALLEY ELEM & ADMIN BUILDING ALTERATIONS


CORNING-PAINTED POST ASD

16 BEARTOWN ROAD, PAINTED POST, NY 14870

EV-AB1.1

PROJECT NO: 2649-160

SED #ERWIN VALLEY 15-10-00-01-0-004-027 ADMIN BUILDING 15-10-00-01-1-001-013

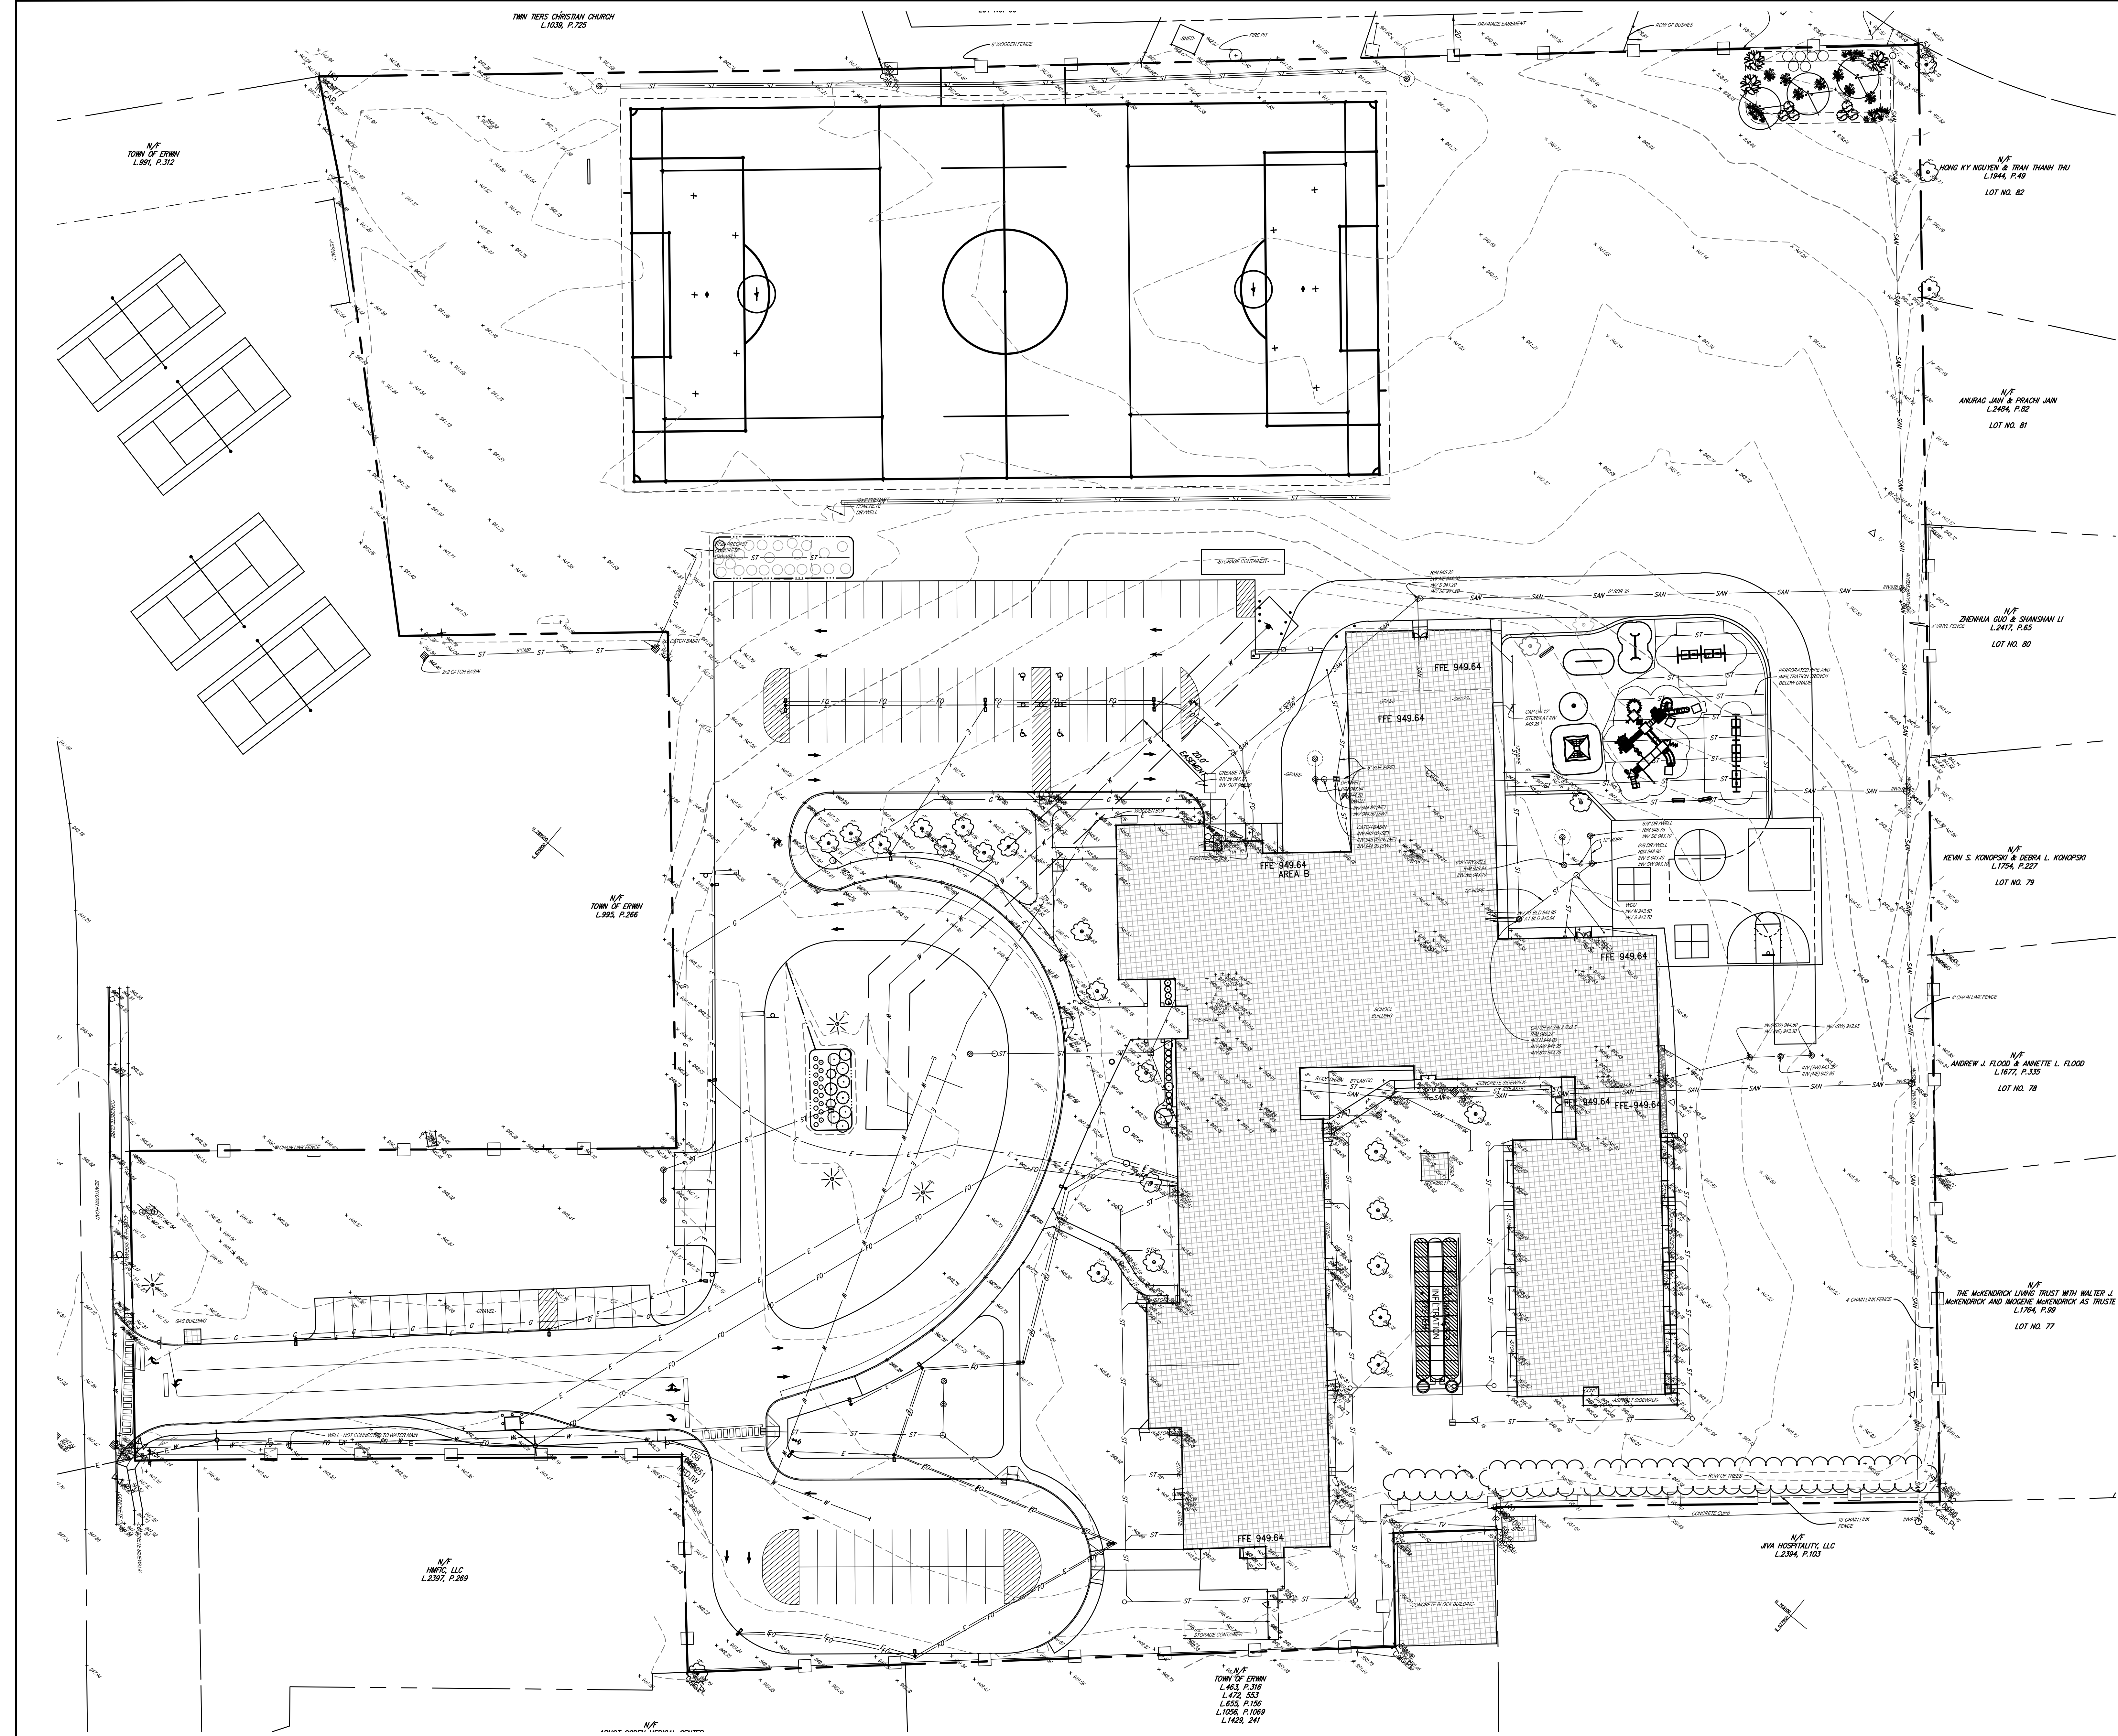

UNDERGROUND UTILITIES NOTE:

UNDERGROUND UTILITIES SHOWN WERE MAPPED USING A COMBINATION OF FIELD LOCATED EXISTING AND EXISTING UTILITY MAPS. THE ACCURACY OF THESE UTILITY LOCATIONS CANNOT BE GUARANTEED. ALL UNDERGROUND UTILITIES SHOULD BE FIELD VERIFIED BEFORE EXCAVATING. CALL 800 SAFELY NEW YORK 1-800-862-7862.

HORIZONTAL/VERTICAL DATUM NOTE:

VERTICAL CONTROL IS REFERENCED TO THE NORTH AMERICAN VERTICAL DATUM OF 1985 (NAVD 85). HORIZONTAL CONTROL IS REFERENCED TO THE NORTH AMERICAN DATUM OF 1983 (NAD 83).

LEGEND:

- CONCRETE MONUMENT
- EXISTING IRON PIN
- EXISTING IRON PIPE
- 5/8" REBAR WITH SURVEY CAP SET
- MANHOLE
- CATCH BASIN
- WATER OR GAS VALVE
- UTILITY POLE
- UTILITY POLE W/STREET LIGHT
- UTILITY POLE ANCHOR
- FIRE HYDRANT
- STREET SIGN
- BOLLARD
- BURIED CABLE MARKER
- TRAFFIC SIGNAL BOX
- DELIMITER
- SURVEY CONTROL POINT
- SANITARY SEWER
- STORM SEWER
- GAS PIPELINE
- WATER PIPELINE
- BURIED TELEPHONE CABLE
- BURIED ELECTRIC CABLE
- OVERHEAD UTILITY LINES
- DECIDUOUS TREE
- CONIFEROUS TREE

SURVEY CONTROL POINT TABLE

POINT NO.	NORTHING	EASTING	ELEVATION	DESCRIPTION
2	783526.2130	677193.9890	942.14	CP-R
3	783219.5967	677476.1889	946.10	CP-R
4	783074.6002	677322.3811	948.73	CP-R
5	782941.3661	677302.3285	948.69	CP-R
7	783526.2130	677193.9890	942.14	CP-R
9	783219.5967	677476.1889	946.10	CP-R
10	783074.6002	677322.3811	948.73	CP-R

SHOWN TOPOGRAPHIC INFORMATION MAY NOT REFLECT THE BUILT ENVIRONMENT DUE TO CONSTRUCTION ON THIS SITE SINCE THE LAST SURVEY WAS COMPLETE. CONFIRM ALL PROPOSED ELEVATIONS ARE ACCURATE IN RELATION TO EXISTING CONDITIONS.

DRAWN BY: DD
CHECKED BY: LC
DATE: 03/17/2026
PHASE: CD

DESCRIPTION OF REVISION:
ISSUE FOR BID

DATE: 10/22/2026
1


IT IS A VIOLATION OF THE LAW FOR ANY PERSON TO MAKE UNAUTHORIZED ALTERATIONS OR ADDITIONS TO PLANS BEARING A LICENSED ENGINEER'S ARCHITECT'S OR SURVEYOR'S SEAL.

NY CERTIFICATE NO. 0016220 PA CERTIFICATE NO. 1SC220313464-1

HUNT ENGINEERS | ARCHITECTS | SURVEYORS
HORSEHEADS, NY 10803
800-758-5800
BROOKLYN, NY 11201
WWW.HUNTEAS.COM

2025 ERWIN VALLEY ELEM & ADMIN BUILDING ALTERATIONS
CORNING-PAINTED POST AREA SCHOOL DISTRICT
16 BEARTOWN ROAD, PAINTED POST, NY 14870

EV-L0.1
PROJECT NO. 2649-160

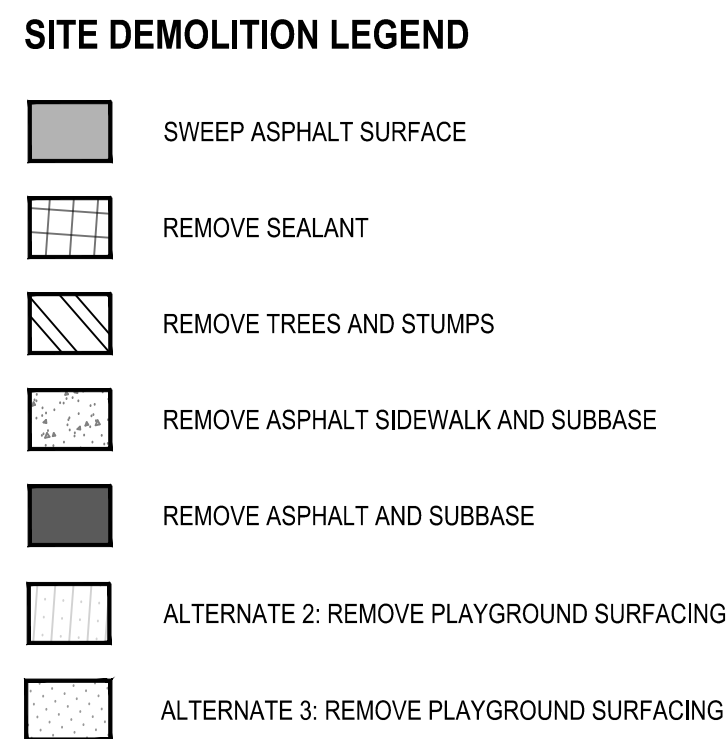

2025 ERWIN VALLEY ELEM & ADMIN BUILDING ALTERATIONS
CORNING-PAINTED POST AREA SCHOOL DISTRICT
16 BEARTOWN ROAD, PAINTED POST, NY 14870




SED# EV:57-10-00-01-0-009-027 AD: 57-10-00-01-1-001-013

16 BEARTOWN ROAD, PAINTED POST, NY 14870


NY CERTIFICATE NO. 0018220 PA CERTIFICATE NO. TSC2203131464-1
WWW.HUNT-EAS.COM

PROJECT NO: 2649-160

DRAWN BY: DD		THIS IS A DECLARATION OF THE CANDIDATE FOR ANY VIOLATION OF THE MODEL LAW AND PRACTICE ACT, STATUTES OR ORDINANCES OF ANY STATE OR LOCAL GOVERNMENT, OR ANY OTHER APPLICABLE LAW, BY SIGNING A LICENSE AS ENGINEER, ARCHITECT OR SURVEYOR, ETC.
CHECKED BY: LC		
DATE: 03/17/2026		
PHASE: CD		
#	DESCRIPTION OF REMISSON	
1	10/12/2008 ISSUE FOR BID	

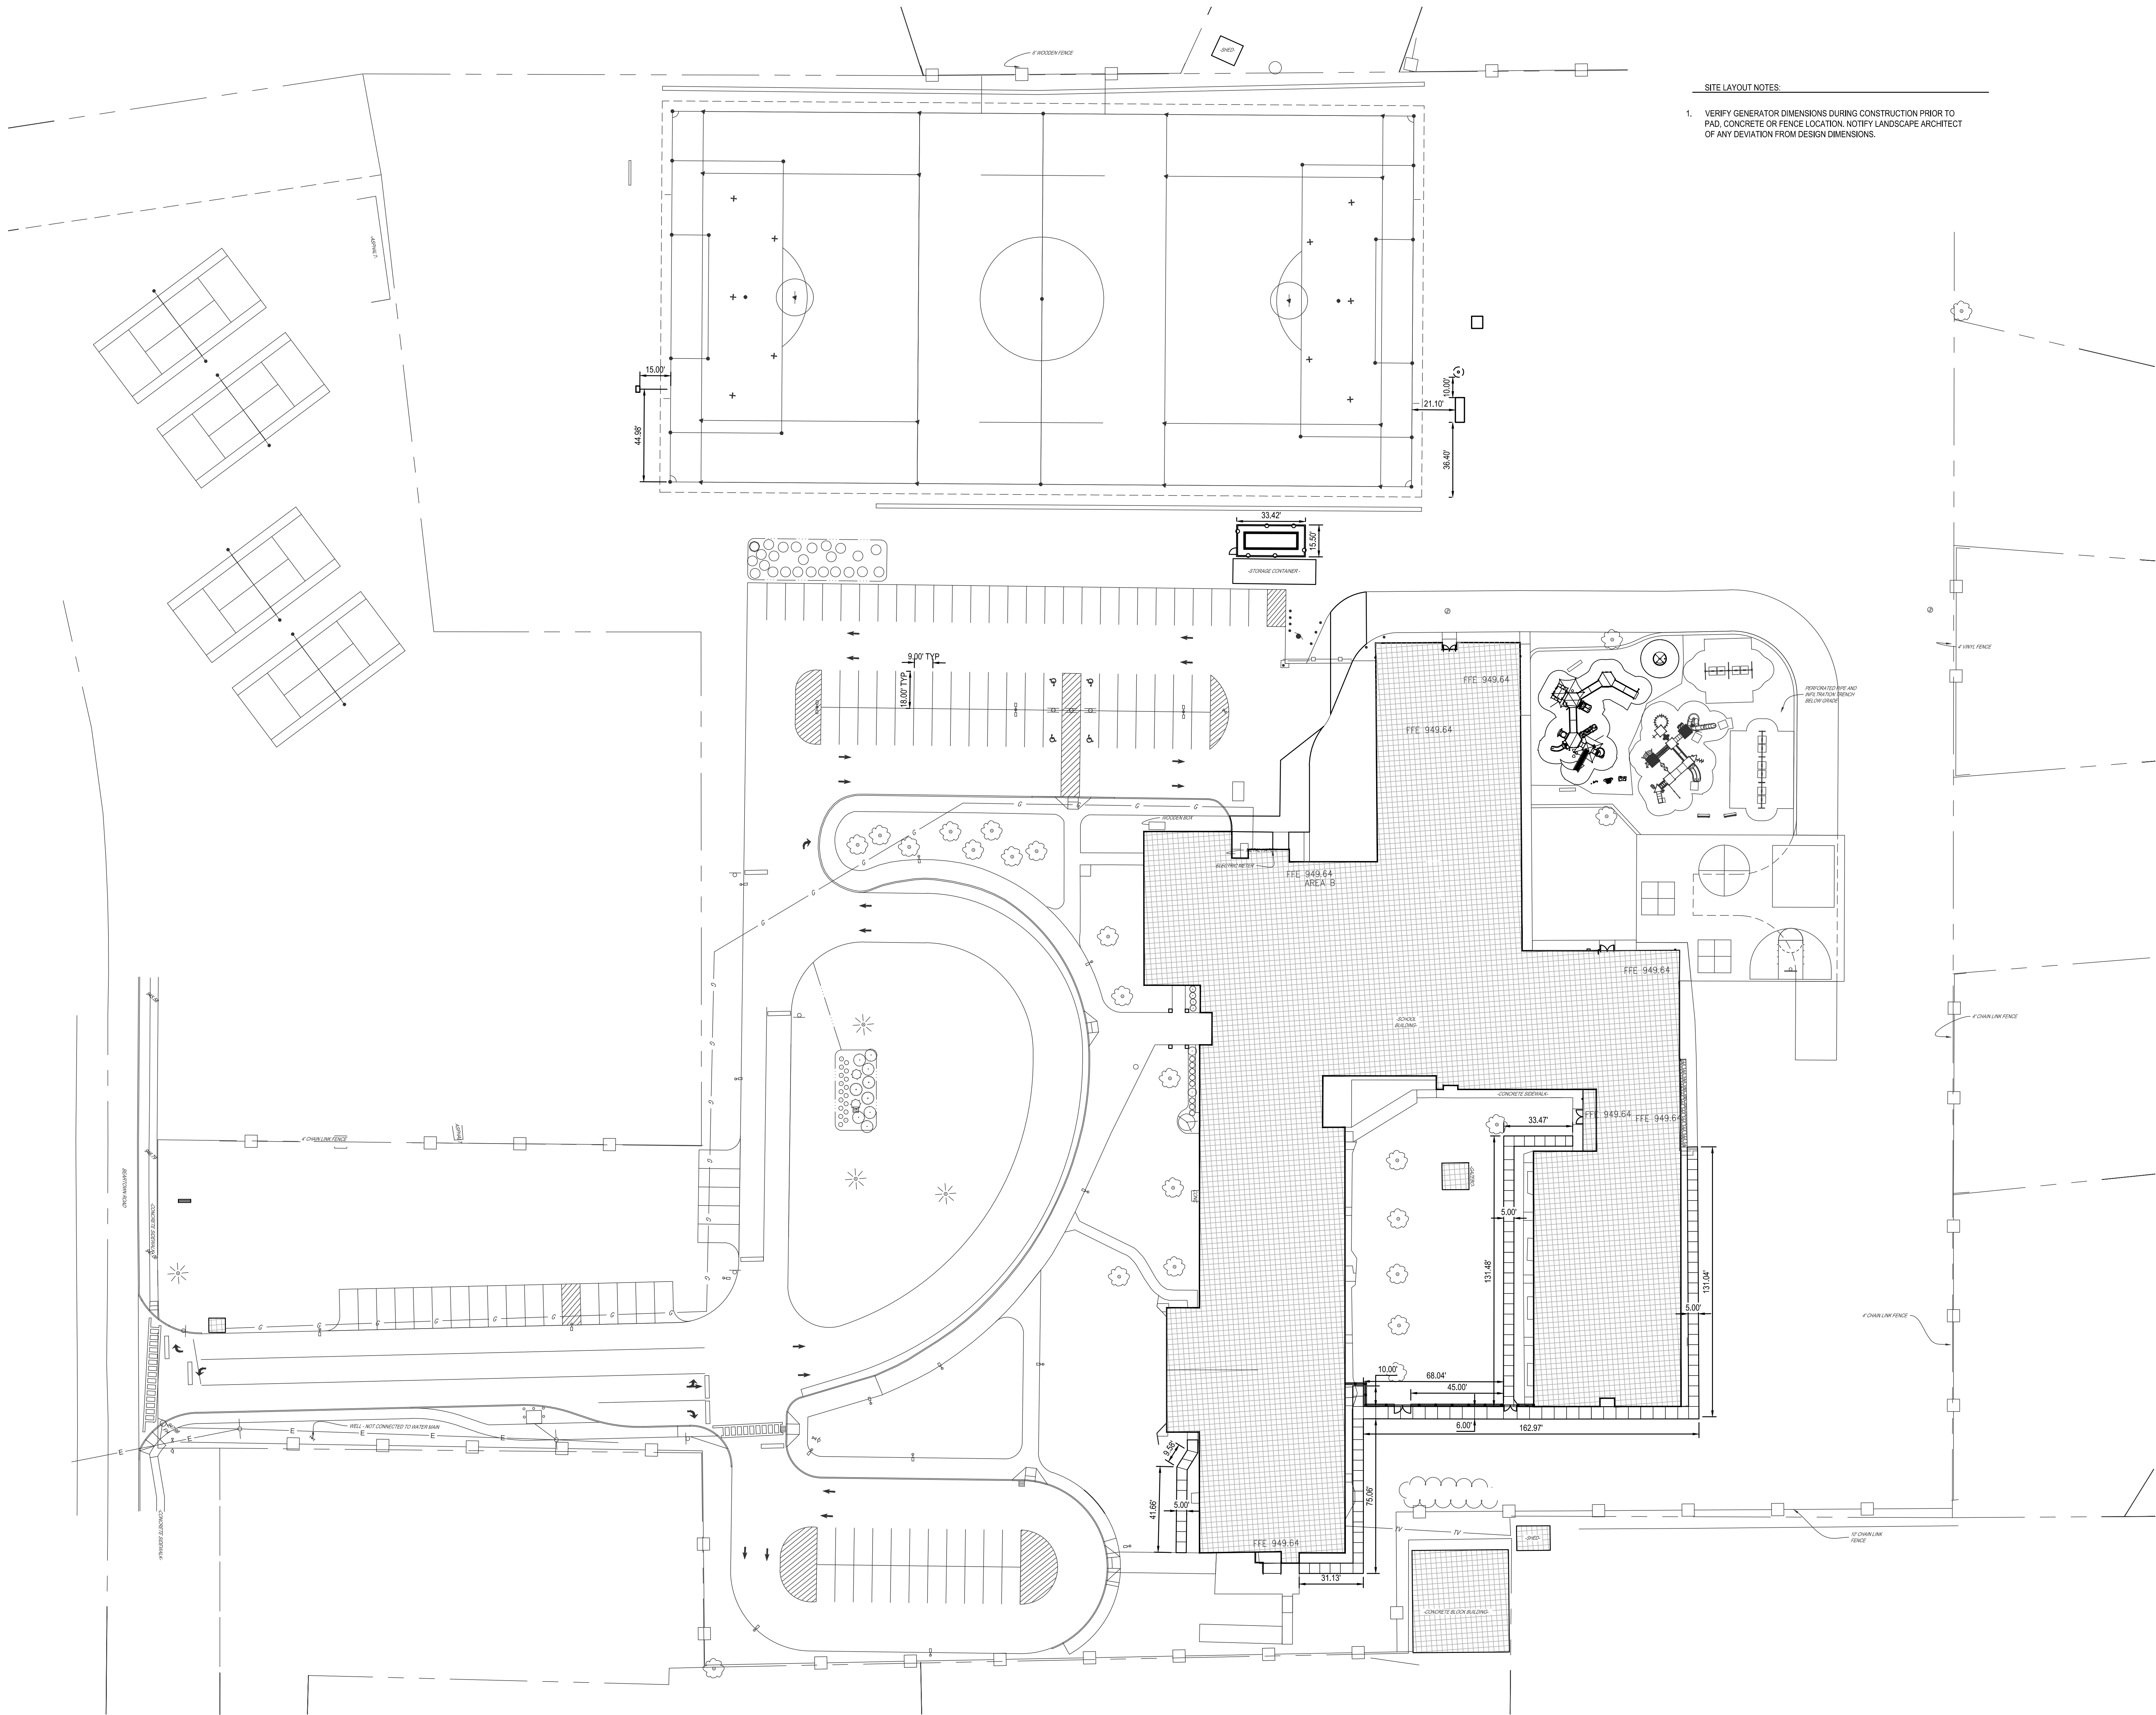

#	DATE	DESCRIPTION OF REVISION
1	10/22/2026	ISSUE FOR BID

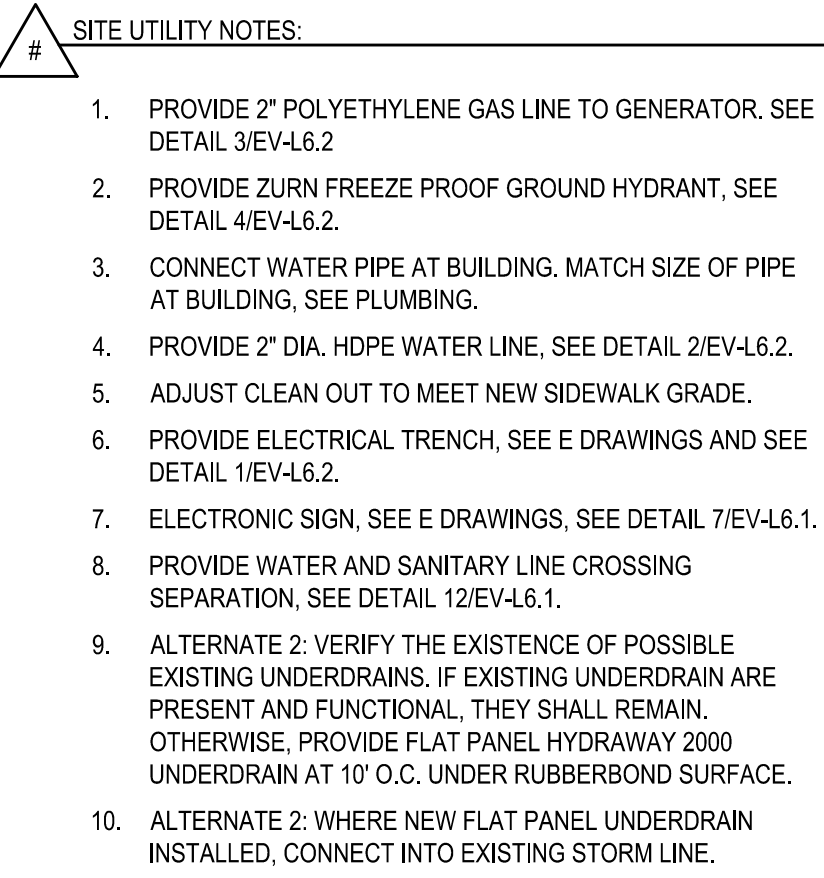

DRAWN BY:	DD	
CHECKED BY:	LG	
DATE:	03/17/2026	
PHASE:	CD	
#	DATE	DESCRIPTION OF REVISION
1	10/22/08	ISSUE FOR BID

THIS IS A PORTION OF THE ALLOW ANY PERSON TO HAVE AN UNPUBLISHED LISTINGS OR ADVERTISEMENTS IN PLANS
BEING A LICENSED ENGINEER, ARCHITECT OR SURVEYOR.

HUNT ENGINEERS | ARCHITECTS | SURVEYORS
HORSEHEADS, NY 607-338-1000 ROCHESTER, NY 585-327-7949 TOWNSEND, NY 570-265-4888
UNIONTOWN, NY 716-697-7330 5081
WWW.HUNT-EAS.COM
NY CERTIFICATE NO. 010820 PA CERTIFICATE NO. TSC202013464-1

SITE UTILITY PLAN

2025 ERWIN VALLEY ELEM & ADMIN BUILDING ALTERATIONS
CORNING-PAINTED POST AREA SCHOOL DISTRICT

16 BEARTOWN ROAD, PAINTED POST, NY 14870

EV-L5.1


SED# EV:57-10-00-01-0-009-027 AD: 57-10-00-01-1-001-013

PROJECT NO: 2649-160


SITUATION	SCHEMATIC	REQUIREMENTS
I WATER LINE ABOVE SEWER LINE		1. WATER AND SEWER PIPE LENGTHS TO BE CENTERED AT CROSSING. EACH LENGTH OF PIPE TO BE 10' MIN.
II WATER LINE ABOVE SEWER LINE		1. WATER AND SEWER PIPE LENGTHS TO BE CENTERED AT CROSSING. EACH LENGTH OF PIPE TO BE 10' MIN. 2. WHEN BOTH WATER AND SEWER ARE NEW, SEWER PIPE SHALL BE SLEEVED IN HDPE OR STEEL CASING PIPE THAT EXTENDS FOR 10' ON EITHER SIDE OF THE CROSSING. 3. WHEN ONLY ONE PIPE IS NEW, SLEEVE PIPE BEING INSTALLED WITH HDPE OR STEEL FOR 10' ON EITHER SIDE OF THE CROSSING.
III WATER LINE BELOW SEWER LINE		1. WATER AND SEWER PIPE LENGTHS TO BE CENTERED AT CROSSING. EACH LENGTH OF PIPE TO BE 10' MIN. 2. WHEN BOTH WATER AND SEWER ARE NEW, SEWER PIPE SHALL BE SLEEVED IN HDPE OR STEEL CASING PIPE THAT EXTENDS FOR 10' ON EITHER SIDE OF THE CROSSING. 3. WHEN ONLY ONE PIPE IS NEW, SLEEVE PIPE BEING INSTALLED WITH HDPE OR STEEL FOR 10' ON EITHER SIDE OF THE CROSSING.

- NOTES:
- IN NO CASE SHALL WATER AND SEWER PIPES BE CLOSER THAN 12" APART VERTICALLY. DISTANCES MEASURED BETWEEN OUTSIDES OF PIPES.
 - IF LESS THAN 18" OF SEPARATION, PROVIDE 6" OF 2,000 PSI CONCRETE ENCASEMENT AROUND SEWER PIPE FOR 5' ON EITHER SIDE OF CROSSING. WRAP SEWER PIPE IN 8 MIL POLYETHYLENE FILM PRIOR TO ENCASEMENT.


12 WATER MAIN CROSSING OPTIONS
SCALE: 1" = 1'-0"

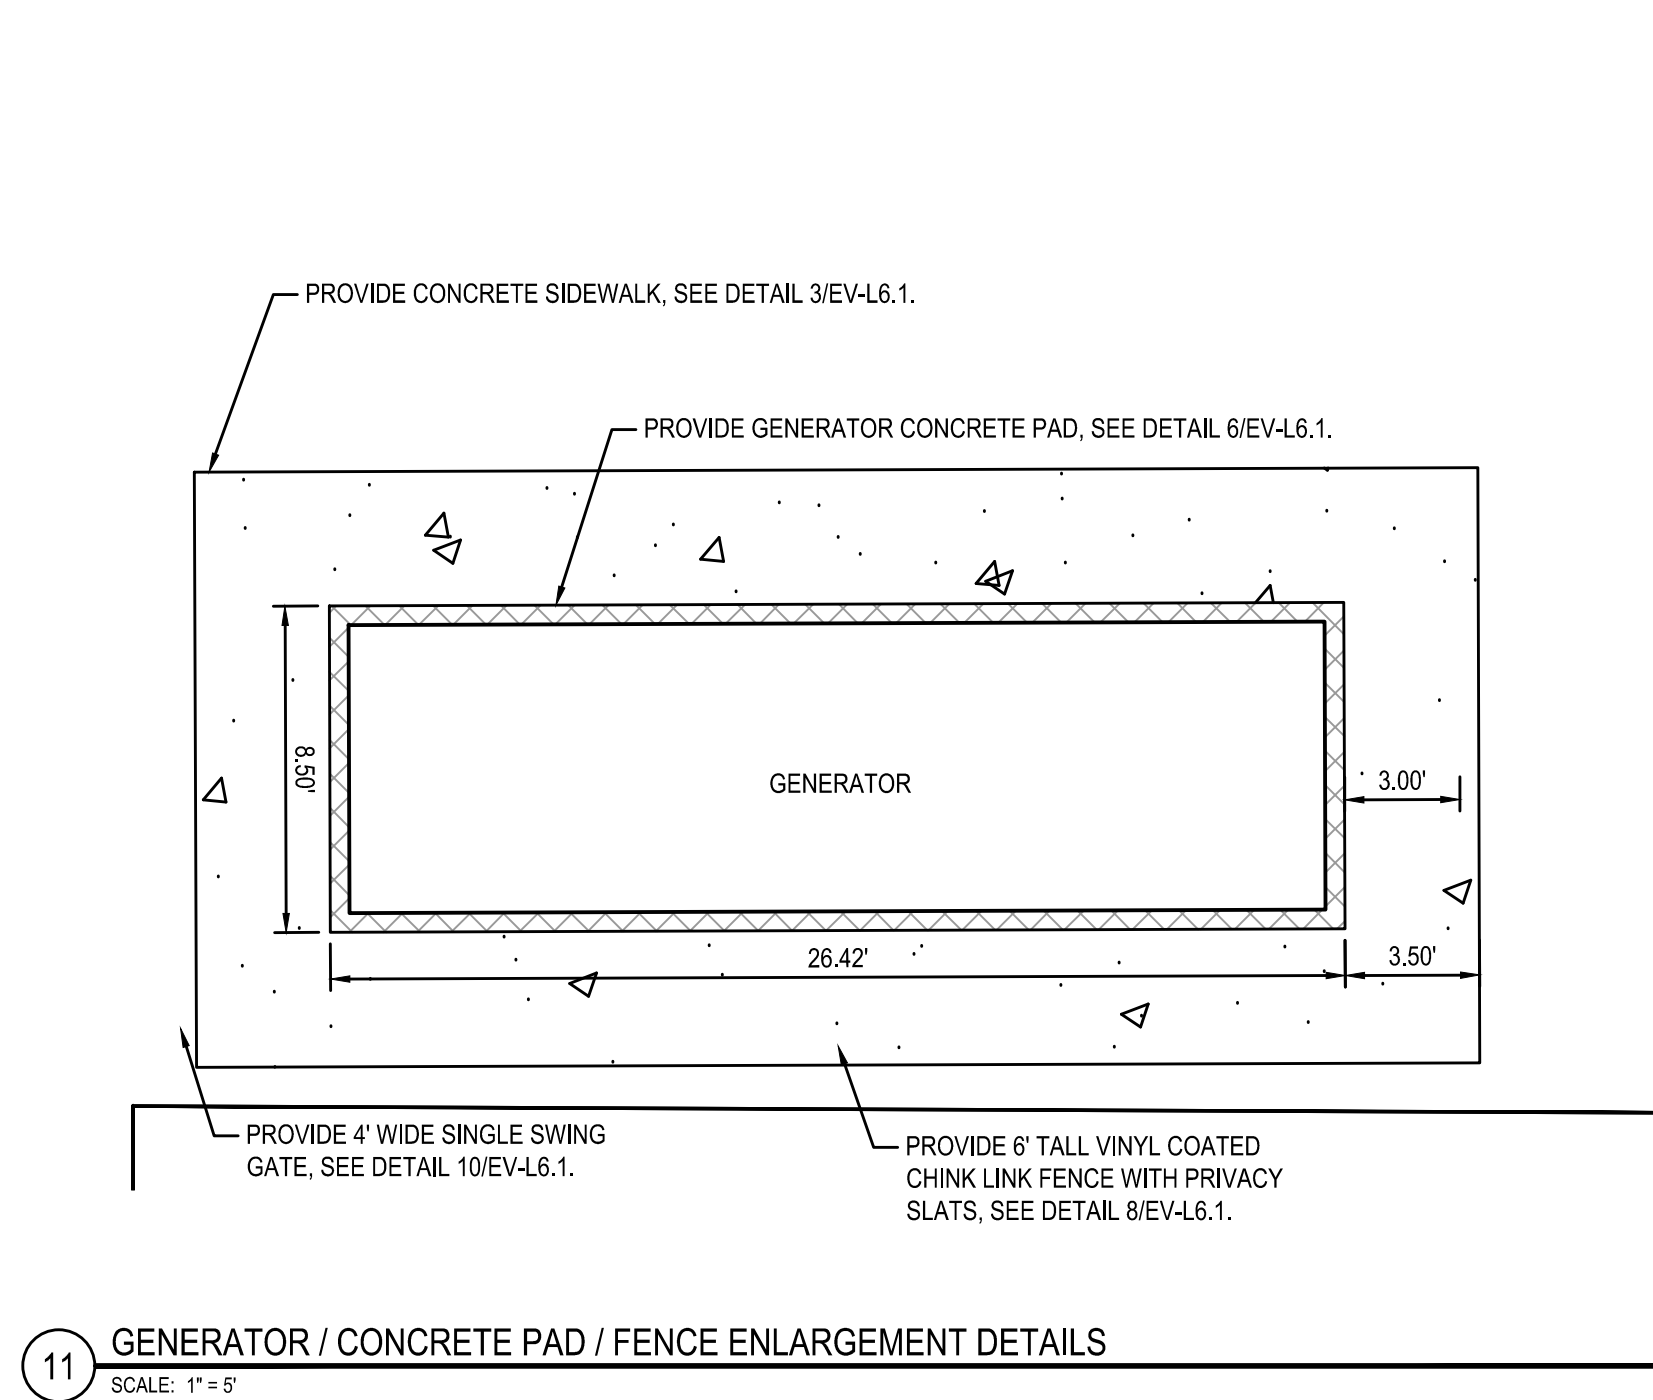


11 GENERATOR / CONCRETE PAD / FENCE ENLARGEMENT DETAILS
SCALE: 1" = 5'

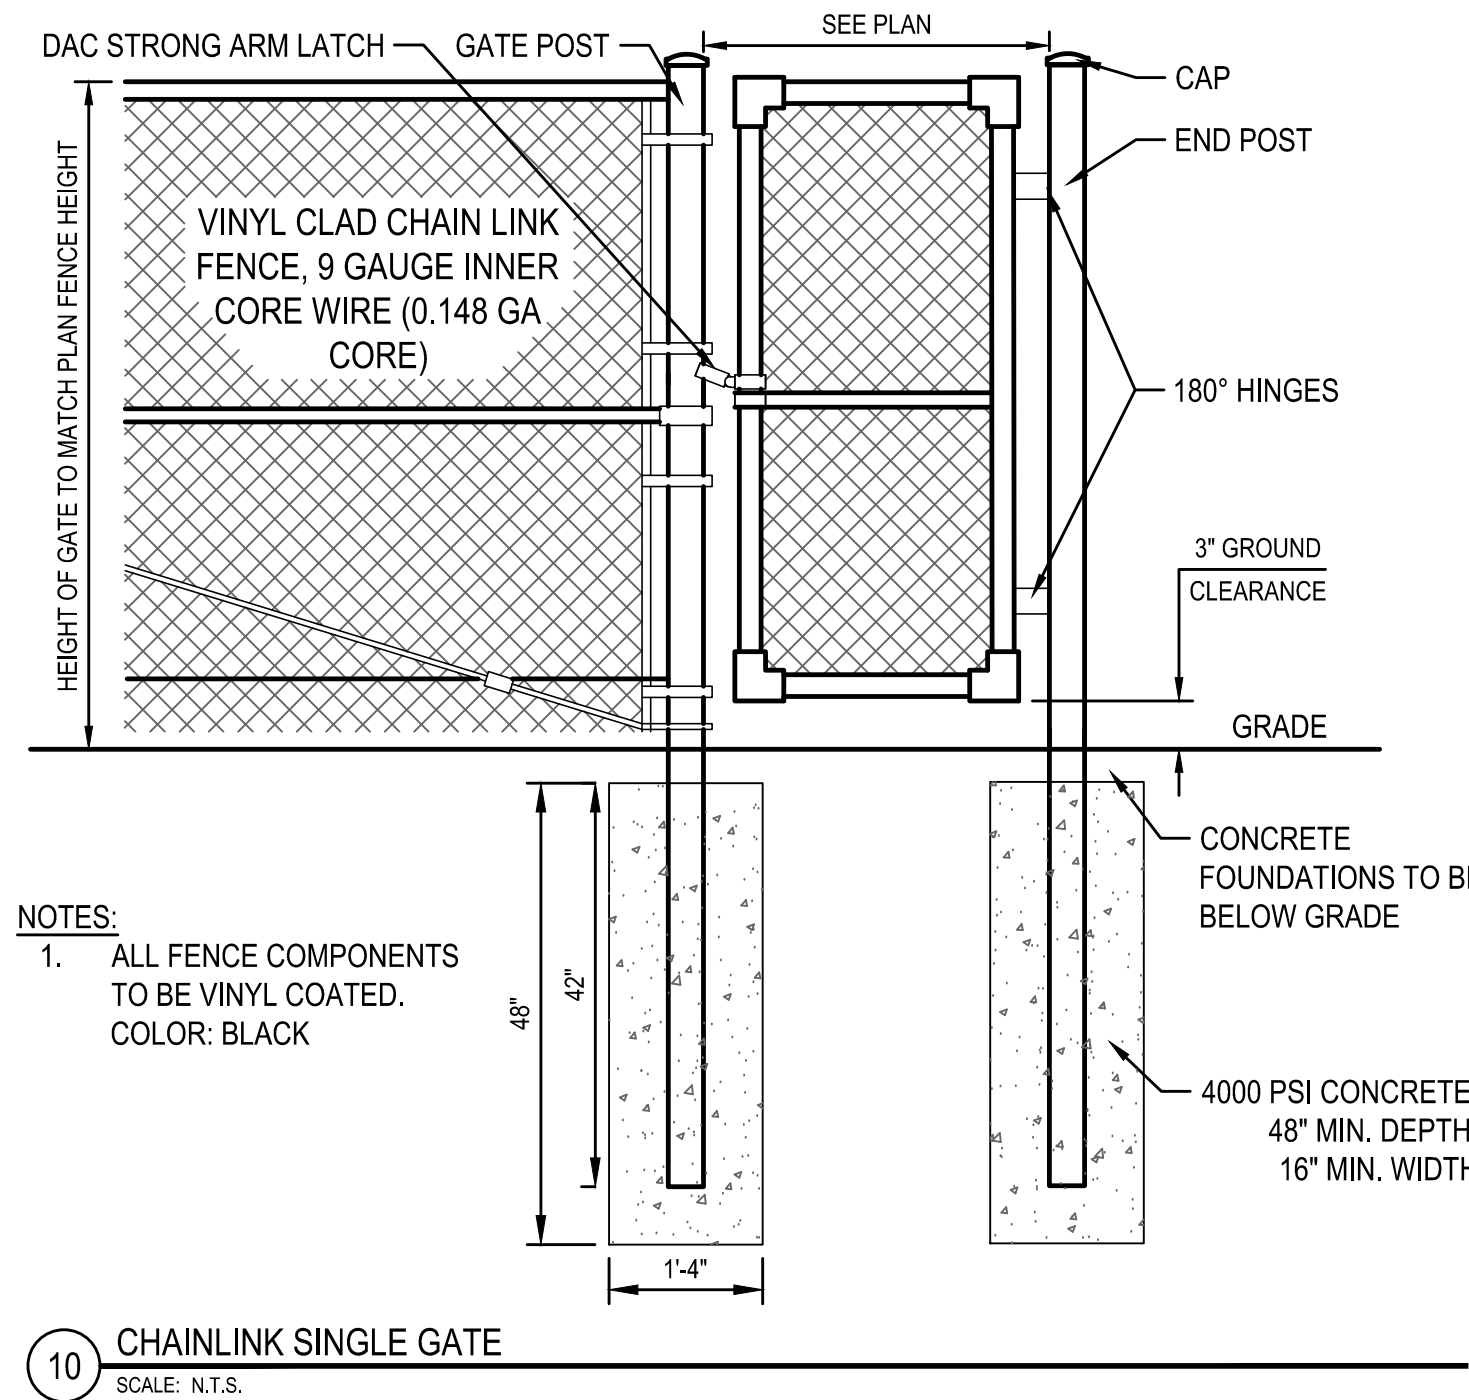


10 CHAINLINK SINGLE GATE
SCALE: N.T.S.

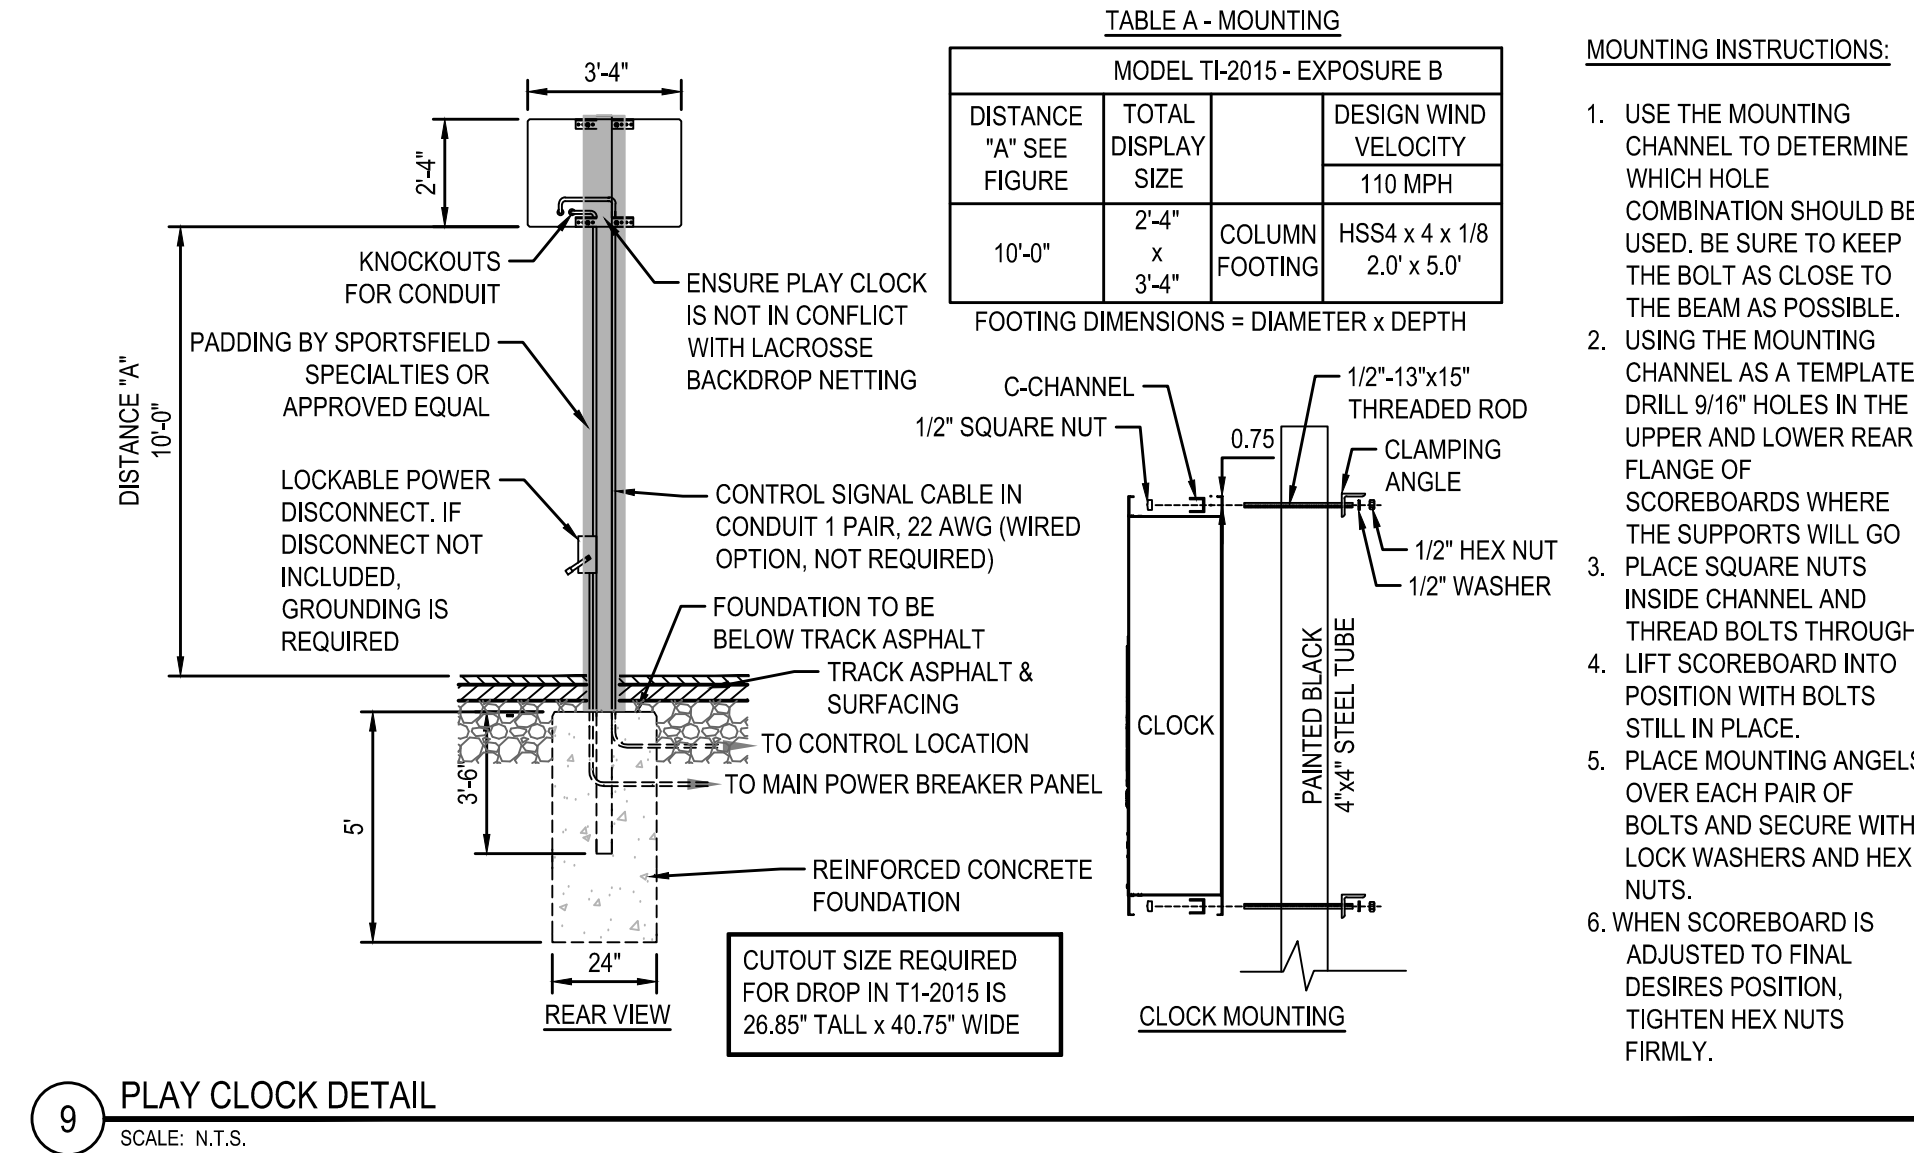


9 PLAY CLOCK DETAIL
SCALE: N.T.S.

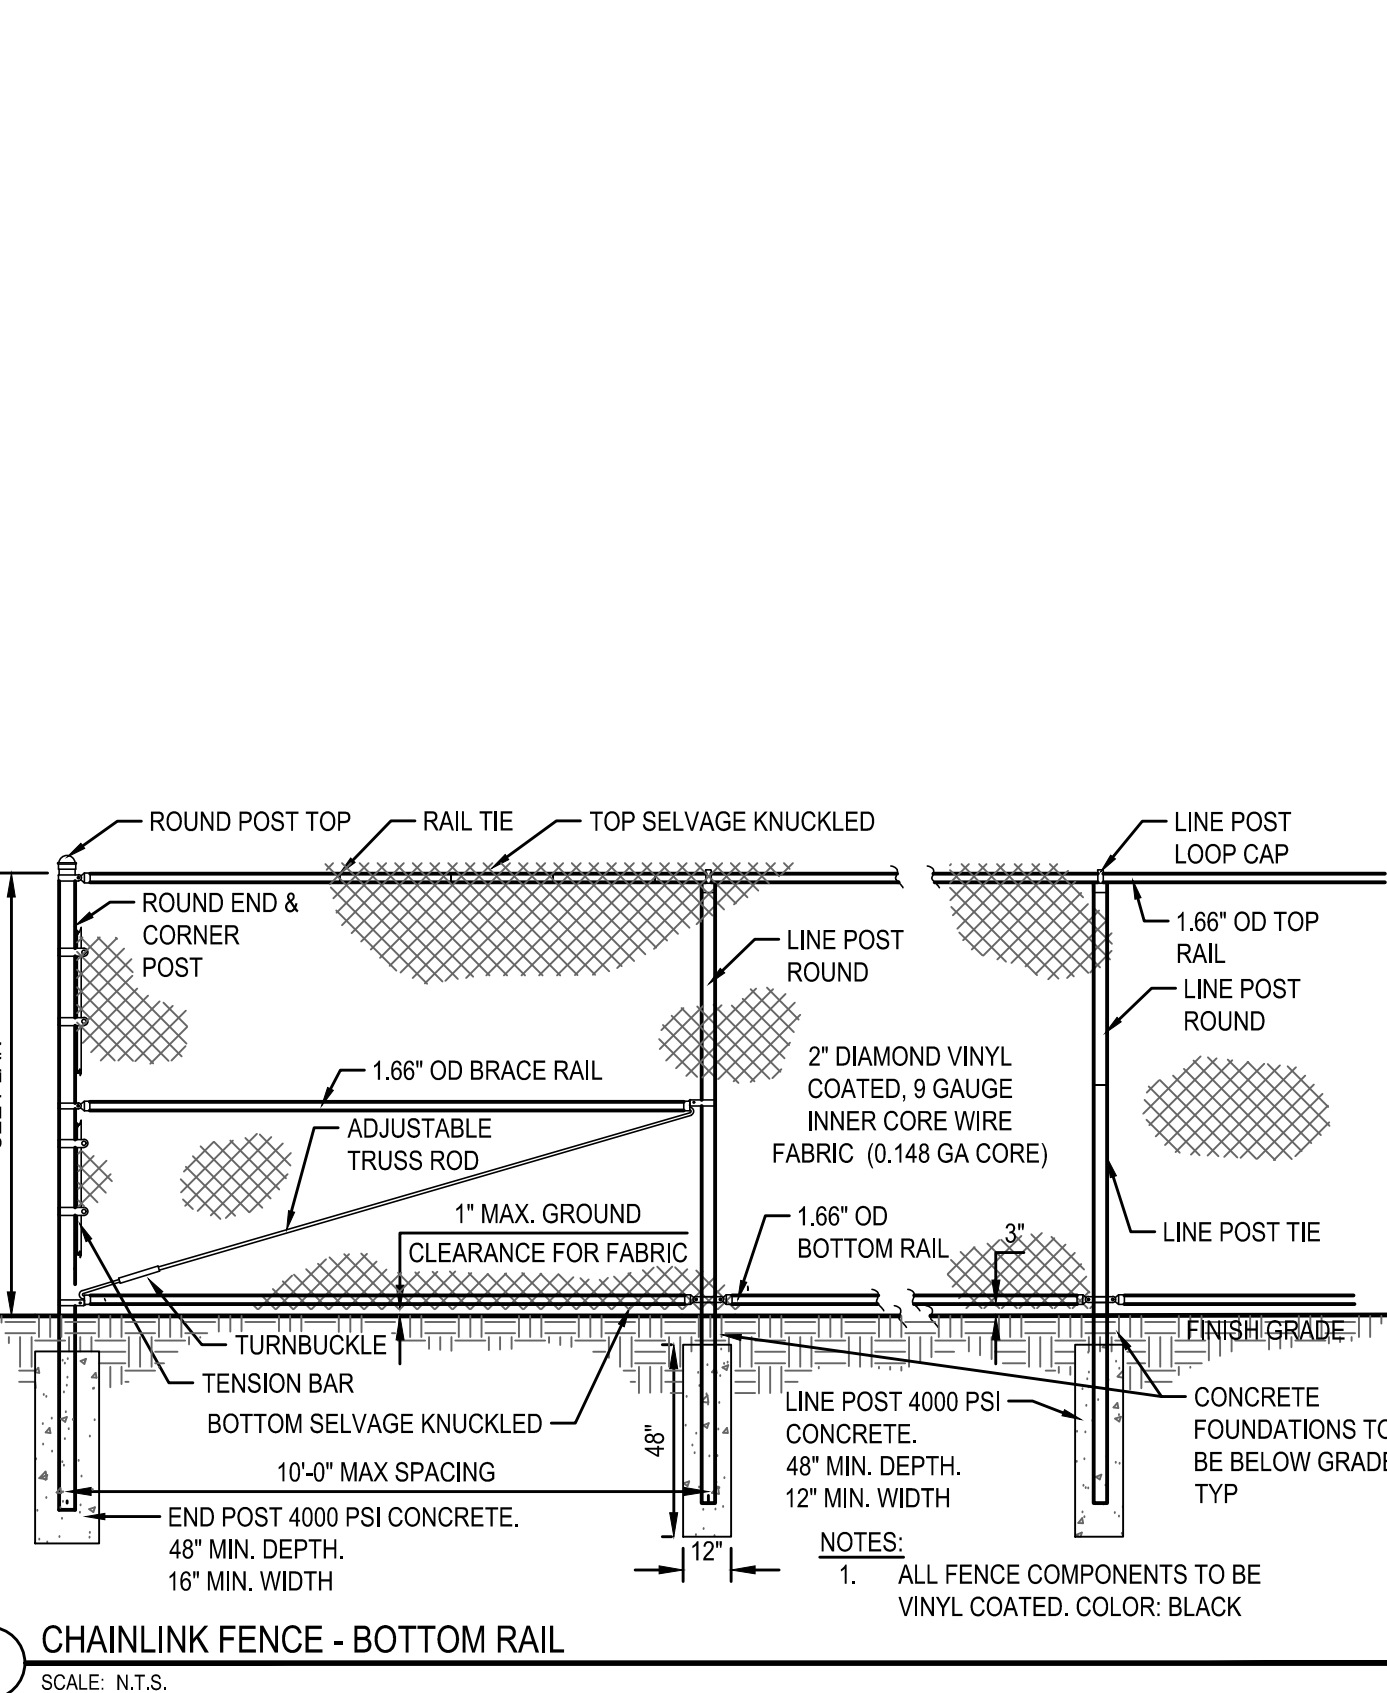


8 CHAINLINK FENCE - BOTTOM RAIL
SCALE: N.T.S.

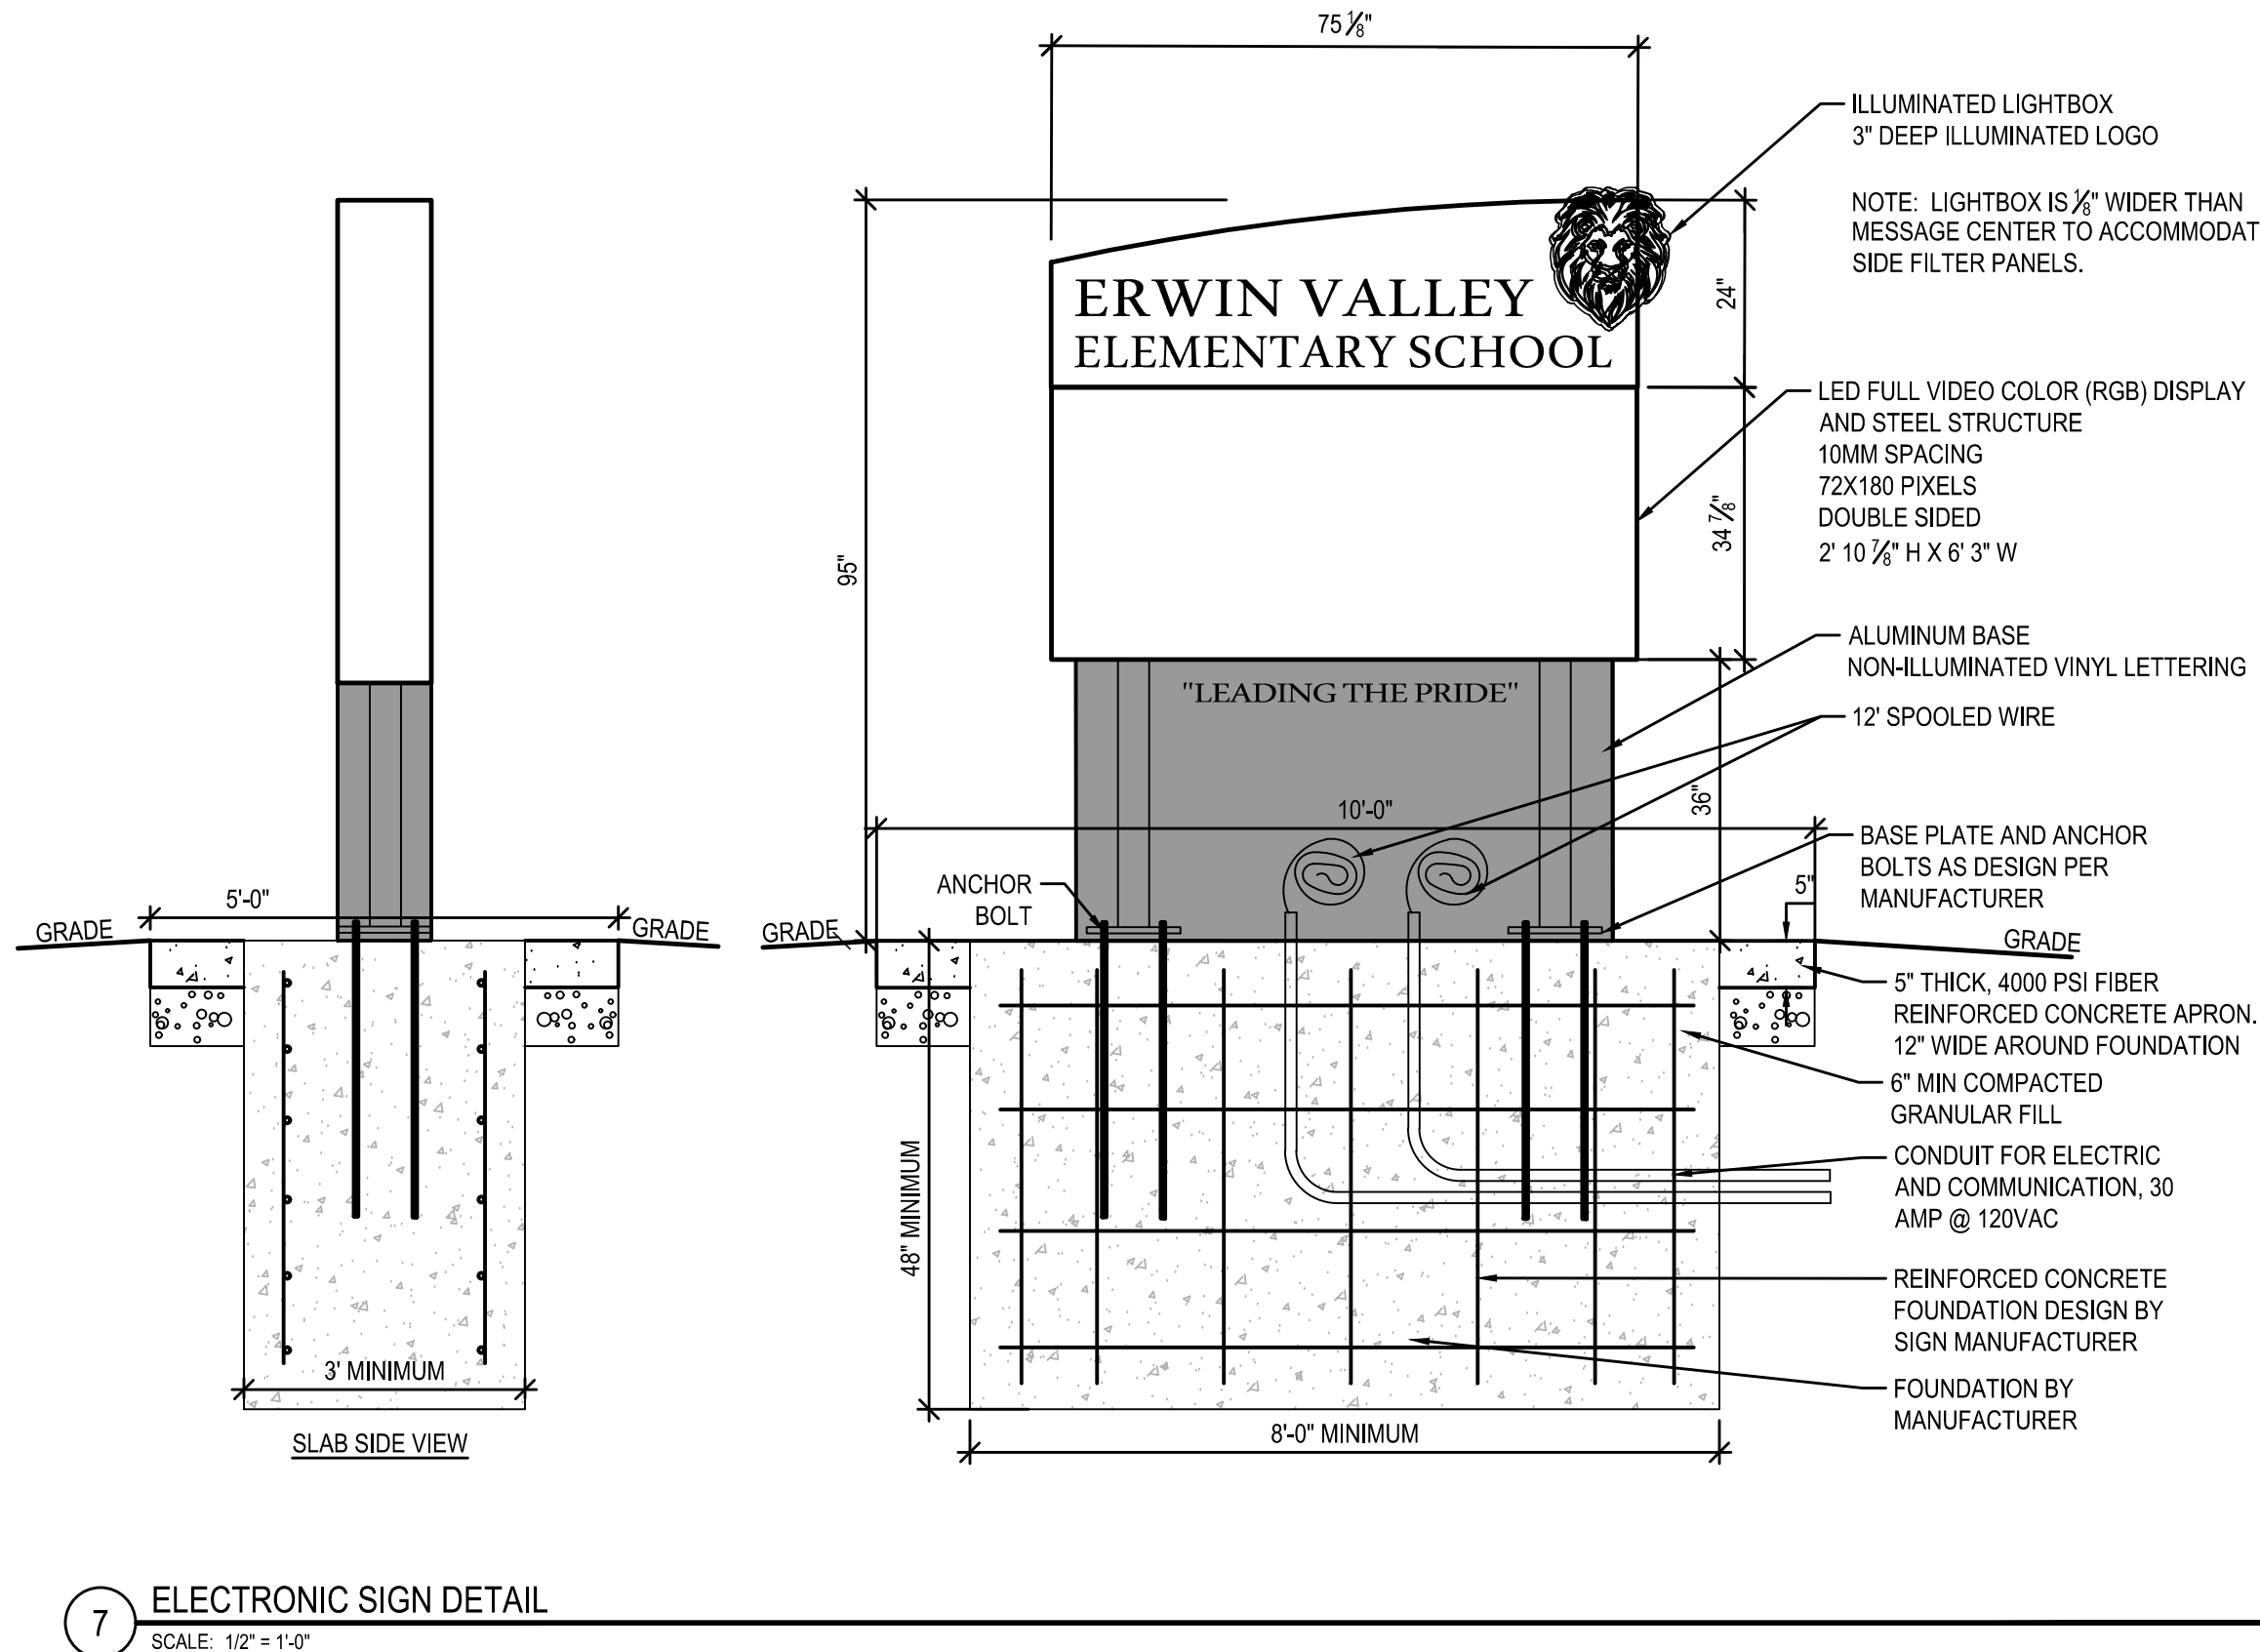


7 ELECTRONIC SIGN DETAIL
SCALE: 1/2" = 1'-0"

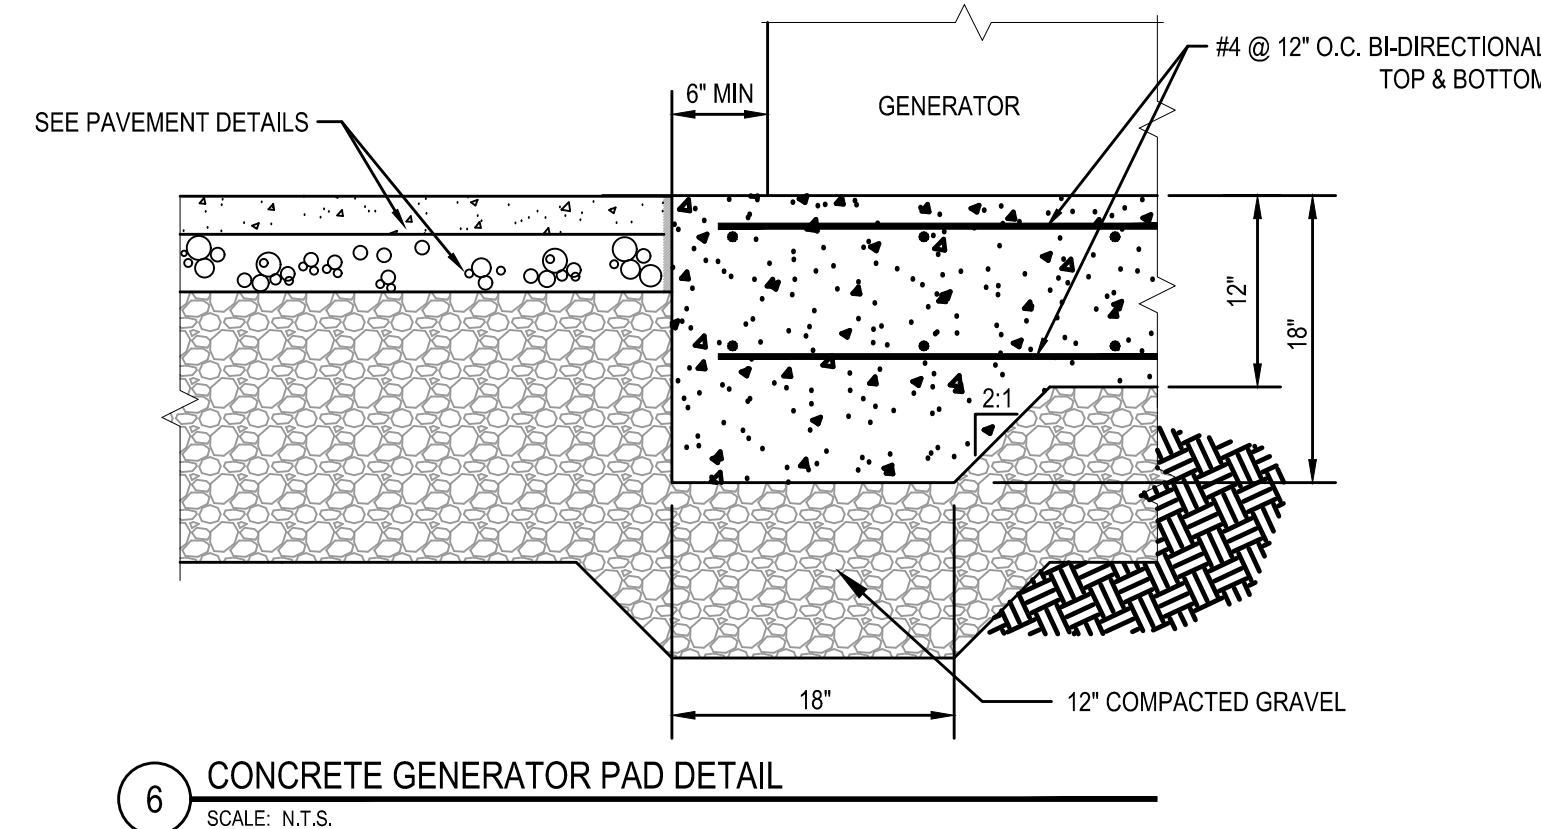


6 CONCRETE GENERATOR PAD DETAIL
SCALE: N.T.S.

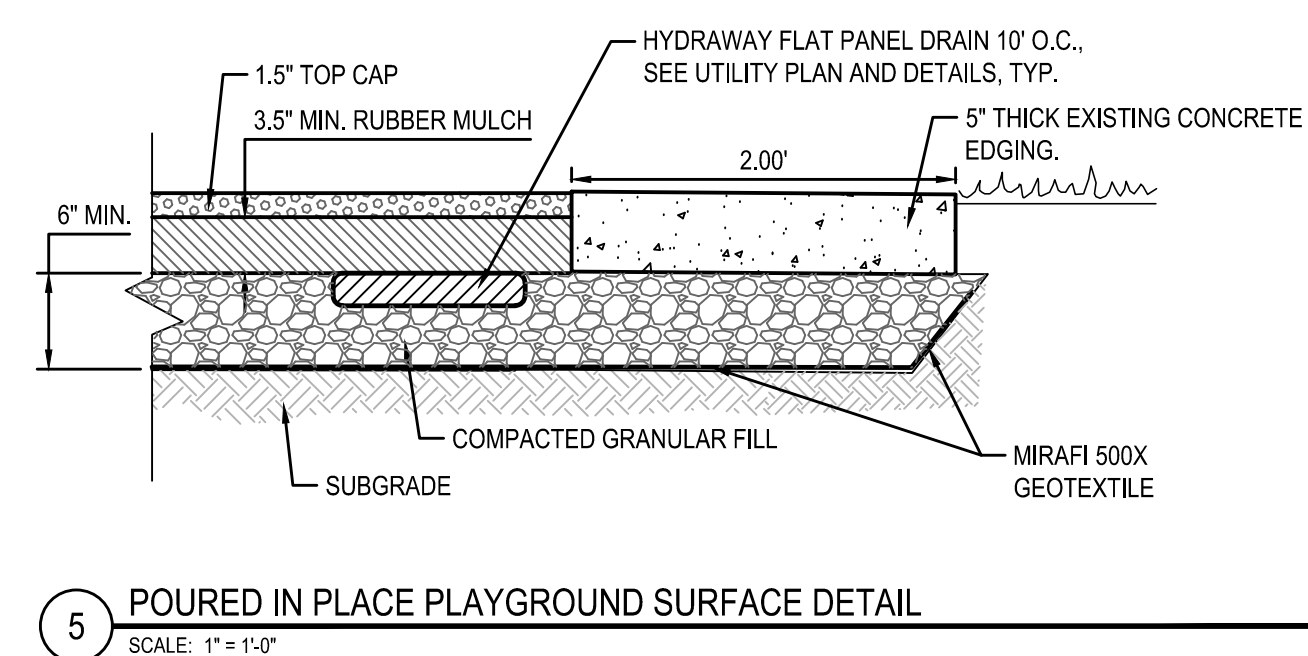


5 POURED IN PLACE PLAYGROUND SURFACE DETAIL
SCALE: 1" = 1'-0"

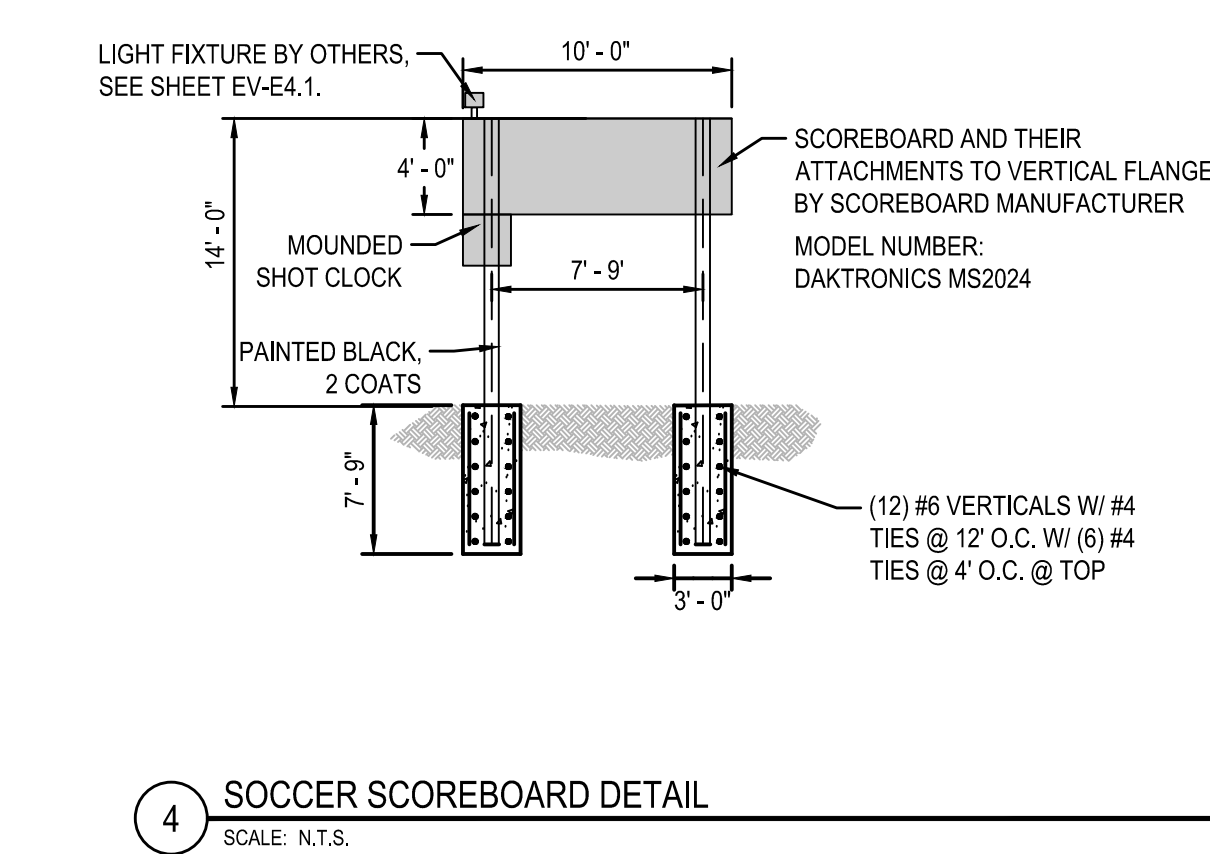


4 SOCCER SCOREBOARD DETAIL
SCALE: N.T.S.

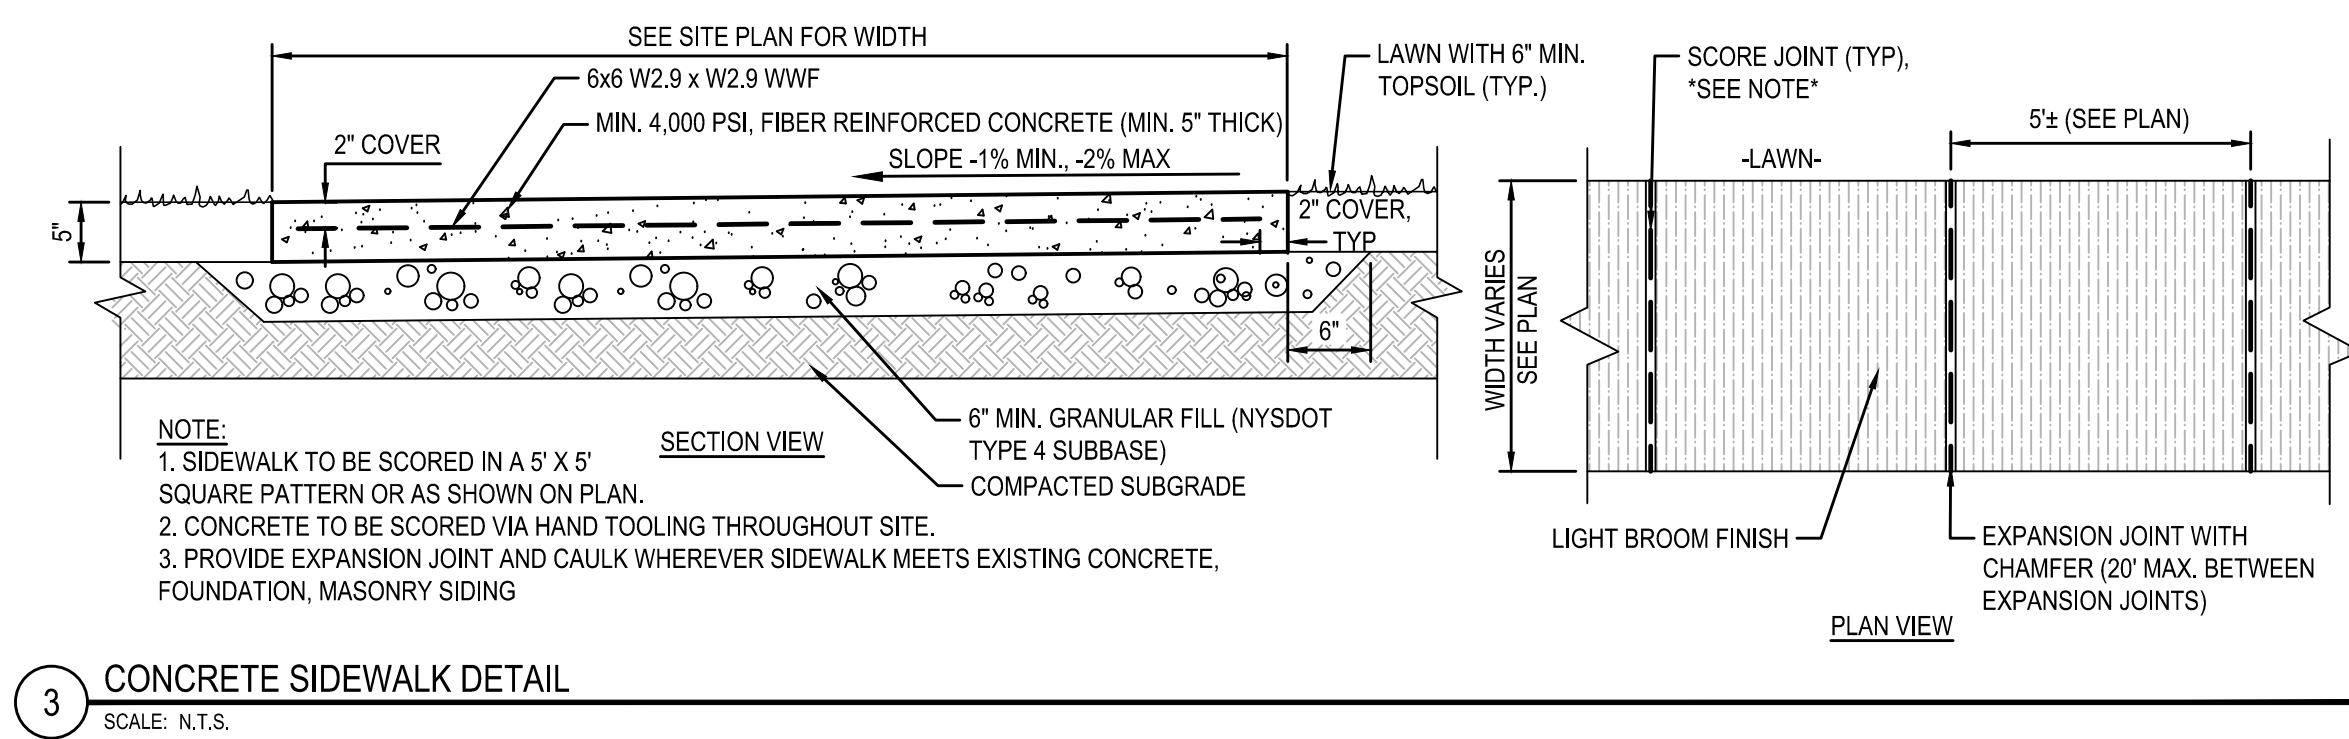

3 CONCRETE SIDEWALK DETAIL
SCALE: N.T.S.

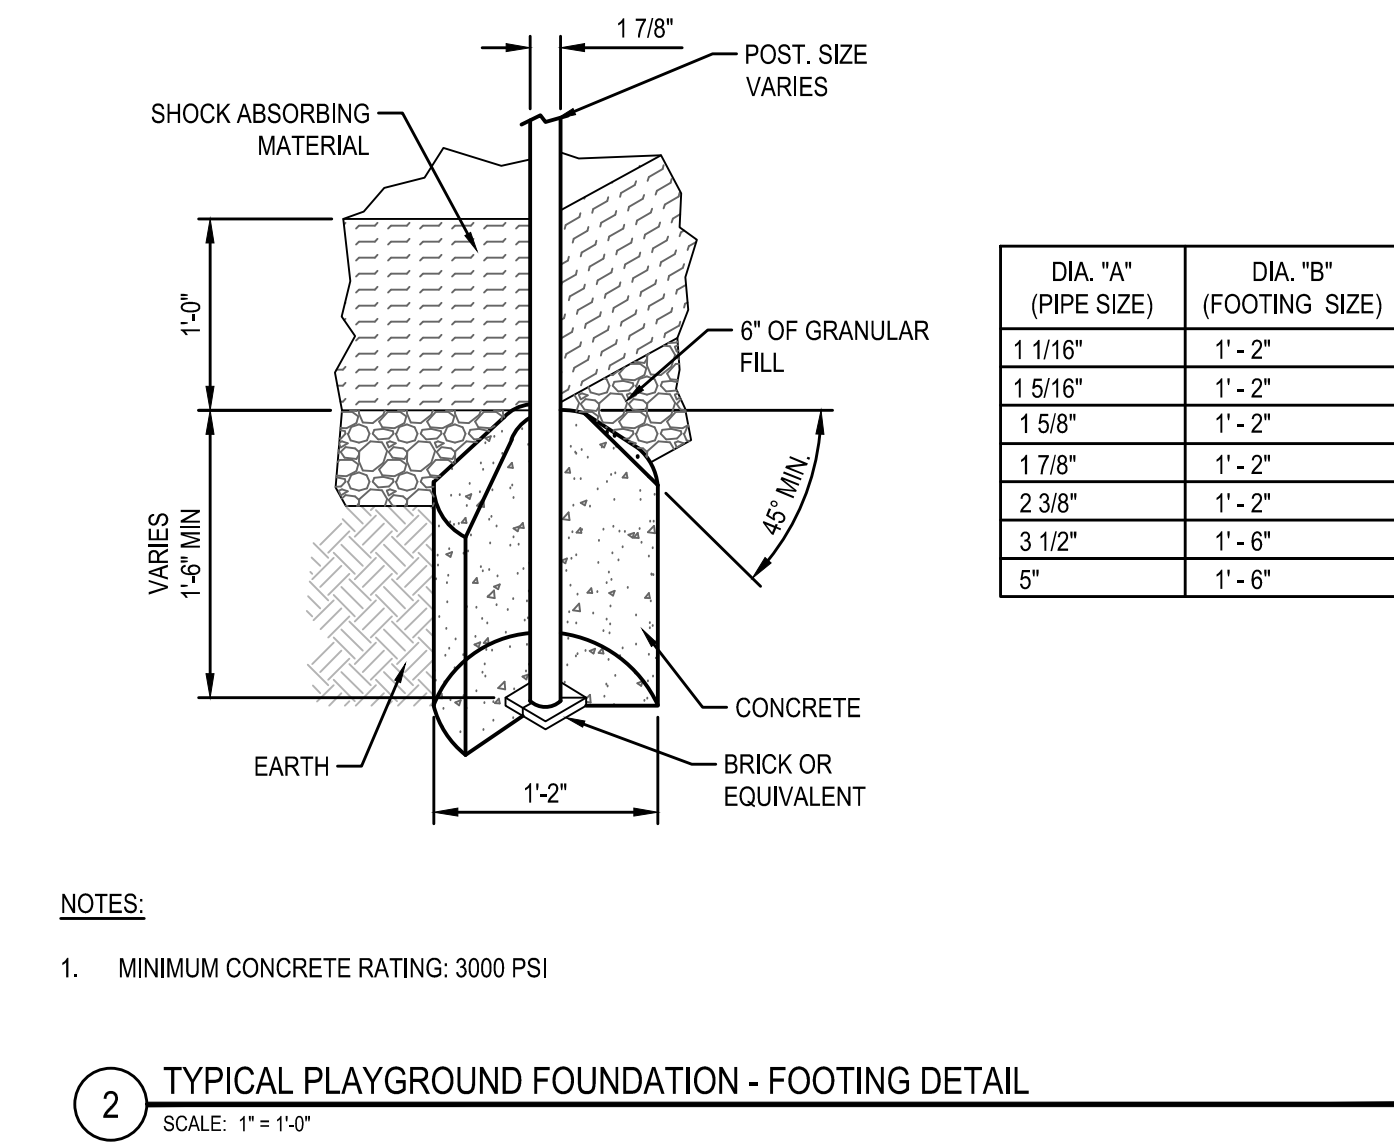

2 TYPICAL PLAYGROUND FOUNDATION - FOOTING DETAIL
SCALE: 1" = 1'-0"

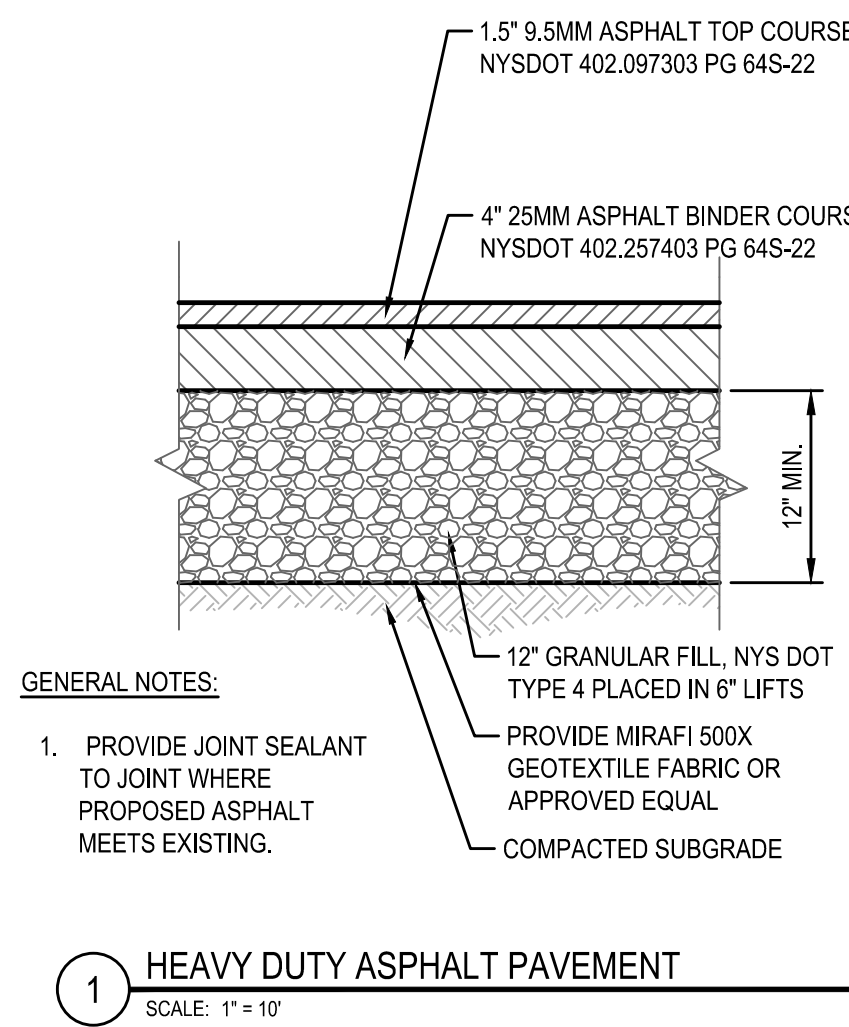

1 HEAVY DUTY ASPHALT PAVEMENT
SCALE: 1" = 10'

HUNT
ENGINEERS | ARCHITECTS | SURVEYORS
807-363-1100
BROOKLYN, NY 11201
BIRMINGHAM, AL 35203
WWW.HUNTEAS.COM

PA CERTIFICATE NO. 15C220313464-1
PA CERTIFICATE NO. 001820

EV-L6.1
PROJECT NO. 2649-160

2025 ERWIN VALLEY ELEM & ADMIN BUILDING ALTERATIONS
CORNING-PAINTED POST AREA SCHOOL DISTRICT
16 BEARTOWN ROAD, PAINTED POST, NY 14870

SITE DETAILS

DRAWN BY: DD
CHECKED BY: LC
DATE: 03/17/2026
PHASE: CD

8 CONCRETE MOW STRIP UNDER FENCE
SCALE: N.T.S.

7 SLEF-CLOSING ORNAMENTAL DOUBLE GATE NO LATCH
SCALE: N.T.S.

6 ORNAMENTAL FENCE
SCALE: N.T.S.

5 FLAG POLE DETAIL (35' TALL)
SCALE: N.T.S.

NOTES:	17	O-RING	2
<p>ENCASED, NON-FREEZE GROUND HYDRANT FOR FLUSH WITH GRADE OR FINISHED FLOOR INSTALLATION. COMPLETE WITH GALVANIZED STEEL CASING, ALL BRONZE INTERIOR PARTS, BRONZE SEAT AND REPLACEABLE SEAT WASHER, AND NON-TURNING OPERATING ROD WITH FREE-FLOATING COMPRESSION CLOSURE VALVE WITH 1-1/4" - 1/2" OR "T" CONNECTION, DURA-COATED CAST IRON BOD AND HINGED SCORRIATED COVER WITH OPERATING "T" HANDLE KEY LOCK AND "WATER" CAST ON COVER. HYDRANT IS EQUIPPED WITH A TAPPED 1/4" DRAIN PORT IN VALVE HOUSING.</p>			

IMPORTANT: HYDRANT MUST BE OPENED ONE TURN MINIMUM TO SEAL DRAIN PORT DURING USE.

3 GAS PIPE TRENCH DETAIL
SCALE: 1" = 1' 0"

NOTES:

1. ALL TRENCHING TO CONFORM TO OSHA STANDARDS.
2. WATER MAIN PIPE SHALL BE HDPE, PVC, OR DUCTILE IRON (DIP). PIPING SHALL CONFORM TO CURRENT ASTM STANDARDS. DUCTILE IRON PIPE SHALL BE POLY-WRAPPED IF REQUIRED.
3. 6-INCH WIDE DETECTABLE WARNING TAPE SHALL BE USED DURING INSTALLATION OF ALL PIPES. INSTALL A MINIMUM OF 2'-0" ABOVE WATER MAIN PIPE.
4. COATED TRACER WIRE SHALL BE USED DURING INSTALLATION OF ALL NON-METALLIC PIPES. INSTALL DIRECTLY ABOVE PIPE.
5. COMPACTION AND COMPACTION TESTING SHALL BE PERFORMED IN ACCORDANCE WITH THE SPECIFICATIONS.

2 WATER MAIN TRENCH DETAIL
SCALE: 3/4" = 1'-0"


1 ELECTRIC CONDUIT TRENCH DETAIL
SCALE: N.T.S.

#	DATE:	DESCRIPTION OF VIOLATION:
1	10/12/2026	ISSUE FOR BID

HUNT ENGINEERS | ARCHITECTS | SURVEYORS
HORSEHEADS, NY 607-338-1000 ROCHESTER, NY 585-327-7949 TOWANDA, PA 570-265-4888
BINGHAMTON, NY 607-733-8888
WWW.HUNTEAM.COM
NY CERTIFICATE NO. 0018221 PA CERTIFICATE NO. TSC2203131664-1


SITE EROSION AND SEDIMENT CONTROL DETAILS
0025 ERWIN VALLEY ELEM & ADMIN BUILDING ALTERATIONS
CORNING-PAINTED POST AREA SCHOOL DISTRICT
 5 BEARTOWN ROAD, PAINTED POST, NY, 4870

EV-L8.1

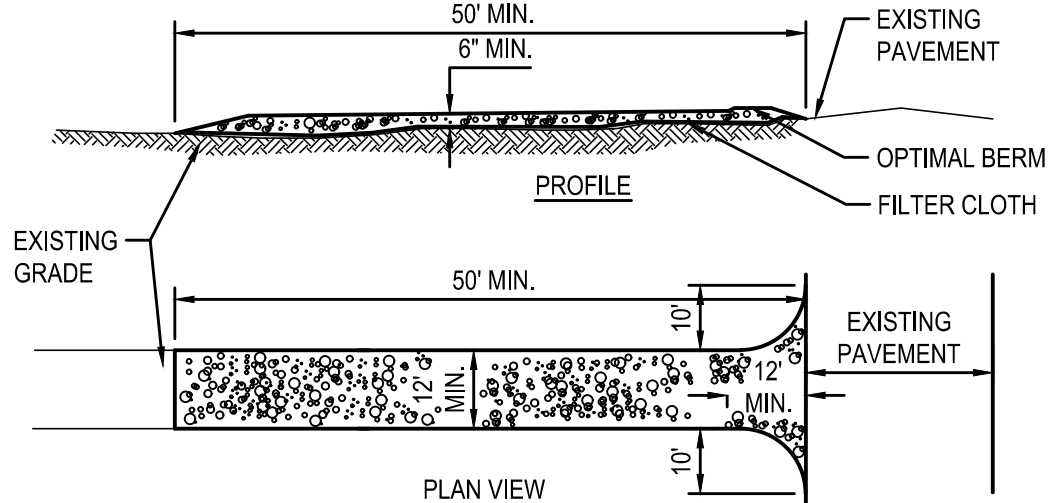


1. STONE SIZE - USE A STONE, OR RECLAIMED OR RECYCLED CONCRETE EQUIVALENT, THAT IS:
 - LENGTH - AS REQUIRED, BUT NOT LESS THAN 50 FEET
 - THICKNESS - NOT LESS THAN 6 INCHES.
 - WIDTH - 12" MINIMUM, BUT NOT LESS THAN THE FULL WIDTH AT THE POINTS WHERE THERE IS INCREASE OR DECREASE OCCURRING
2. FILTER CLOTH - WILL BE PLACED OVER SINGLE AREA PRIOR TO PLACING OF STONE. FILTER CLOTH WILL NOT BE REQUIRED ON AN ENTIRE RESIDENCE LOT.
3. PIPING - AFTER ALL SURFACING IS COMPLETED, PIPING SHALL BE TOWARD CONSTRUCTION ENTRANCES SHALL BE PIPED ACROSS THE ENTRANCE. IF PIPING IS IMPRACTICAL, A MOUNTABLE BERM WITH 5' SLOPES WILL BE PERMITTED.
4. MAINTENANCE - THE ENTRANCE SHALL BE MAINTAINED IN A CONDITION WHICH WILL PREVENT TRACKING OF LOOSE MATERIAL ONTO PUBLIC RIGHTS-OF-WAY. THIS MAY REQUIRE PERIODIC TOP DRESSING WITH ADDITIONAL STONE AS CONDITIONS DEMAND AND REPAIR AND/OR CLEANEST OF ANY MEASURES USED TO TRAP SEDIMENT, ALL SEDIMENT SPILLED, DROPPED, OR DISCHARGED ONTO PUBLIC RIGHTS-OF-WAY SHALL BE REMOVED IMMEDIATELY.
5. WASHING - WHEELS SHALL BE CLEANED TO REMOVE SEDIMENT PRIOR TO ENTRANCE ONTO PUBLIC RIGHTS-OF-WAY. WHEN WASHING IS REQUIRED, IT SHALL BE DONE ON AN AREA THAT IS NOT A HIGH TRAFFIC AREA. APPROVED SEDIMENT TRAPPING DEVICES MAY BE USED.
6. PERIODIC INSPECTION AND NEEDED MAINTENANCE SHALL BE PROVIDED AFTER EACH RAIN.

6 SOIL STOCKPILE AREA DETAIL
SCALE: N.T.S.

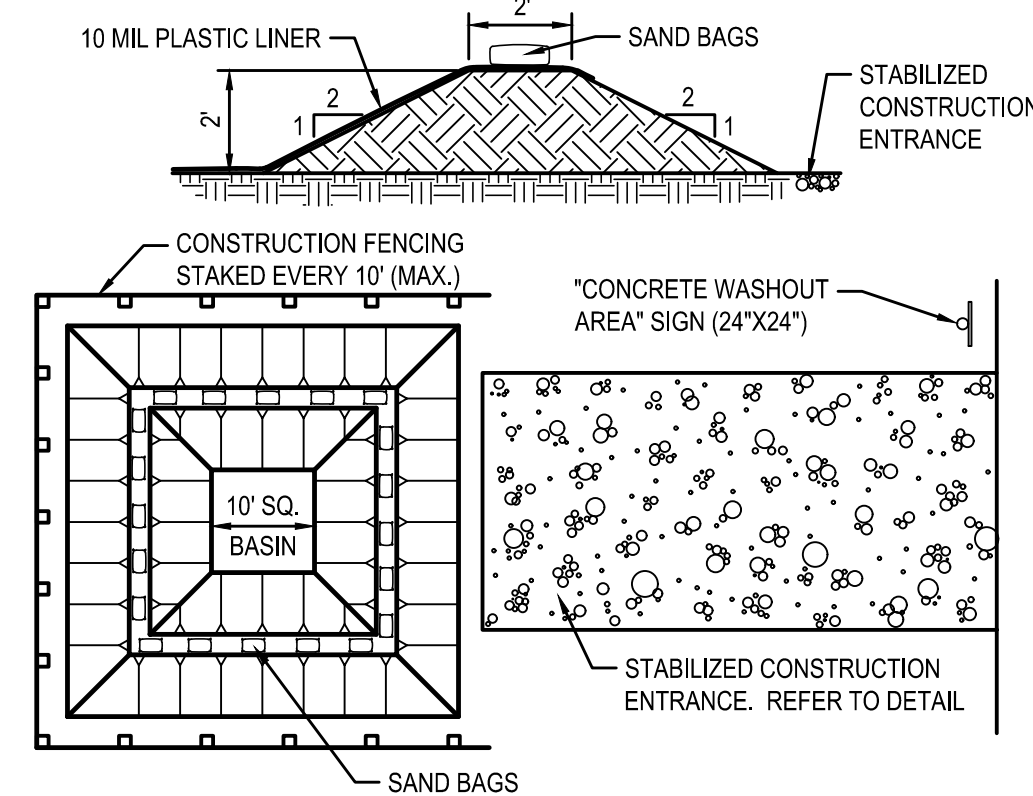



- NOTES:**
1. ALL TOOLS AND EQUIPMENT UTILIZED DURING ANY CONCRETE CONSTRUCTION, INCLUDING HAND TOOLS, WHEELBARROWS, TRUCKS, CHUTES SHALL UTILIZE THE CONCRETE WASHOUT AREA.
 2. WASHOUT AREA TO BE MAINTAINED AND CLEANED OUT PERIODICALLY TO PREVENT WASHWATER AND/OR SOLIDS FROM EXITING THE WASHOUT TRAP.

5 CONCRETE WASHOUT DETAIL
SCALE: N.T.S.

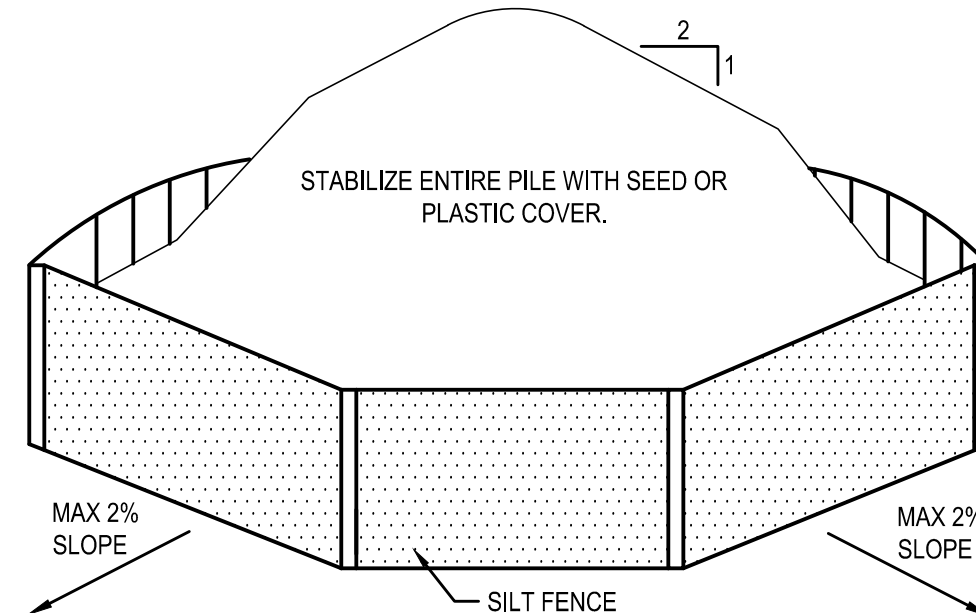SOIL STOCKPILING NOTES:


1. AREA CHOSEN FOR STOCKPILING OPERATIONS SHALL BE DRY AND STABLE.
2. MAXIMUM SLOPE OF STOCKPILE SHALL BE 1:2.
3. UPON COMPLETION OF SOIL STOCKPILING, EACH PILE SHALL BE SURROUNDED WITH SILT FENCING AND THEN STABILIZED WITH SEED OR SECURED IMPERVIOUS COVER.
4. SEE SILT FENCE INSTALLATION DETAIL.

4 SOIL STOCKPILE AREA DETAIL
SCALE: N.T.S.

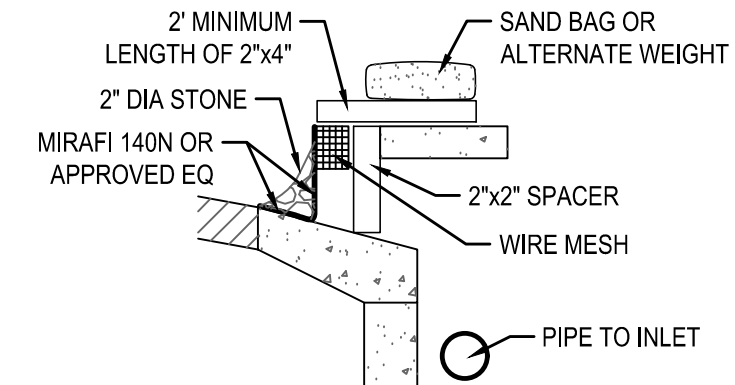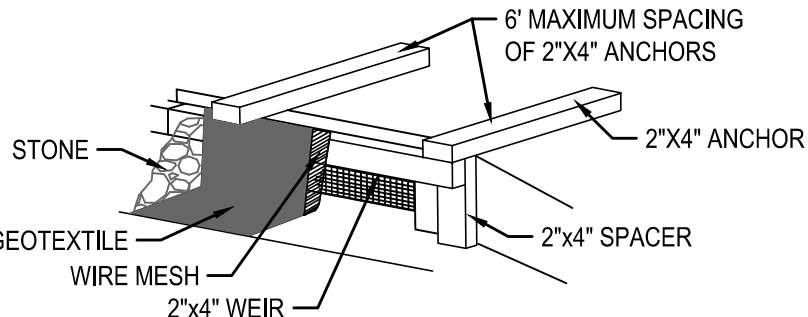


- NOTES:**
1. FILTER FABRIC SHALL HAVE AN EOS OF 40-85.
 2. WOODEN FRAME SHALL BE CONSTRUCTED OF 2"x4" CONSTRUCTION GRADE LUMBER.
 3. WIRE MESH ACROSS THROAT SHALL BE A CONTINUOUS PIECE 30 INCH MINIMUM WIDTH WITH A LENGTH 4 FEET LONGER THAN THE THROAT. IT SHALL BE SHAPED AND SECURELY NAILED TO A 2"x4" WEIR.
 4. THE WEIR SHALL BE SECURELY NAILED TO 2"x4" SPACERS 9 INCHES LONG SPACED NO MORE THAN 6 FEET APART.
 5. THE ASSEMBLY SHALL BE PLACED AGAINST THE INLET AND SECURED BY 2"x4" ANCHORS 2 FEET LONG EXTENDING ACROSS THE TOP OF THE INLET AND HELD IN PLACE BY SAND OR ALTERNATE WEIGHTS.
 6. MAXIMUM DRAINAGE AREA IS 1 ACRE.

3 CURB INLET PROTECTION
SCALE: N.T.S.

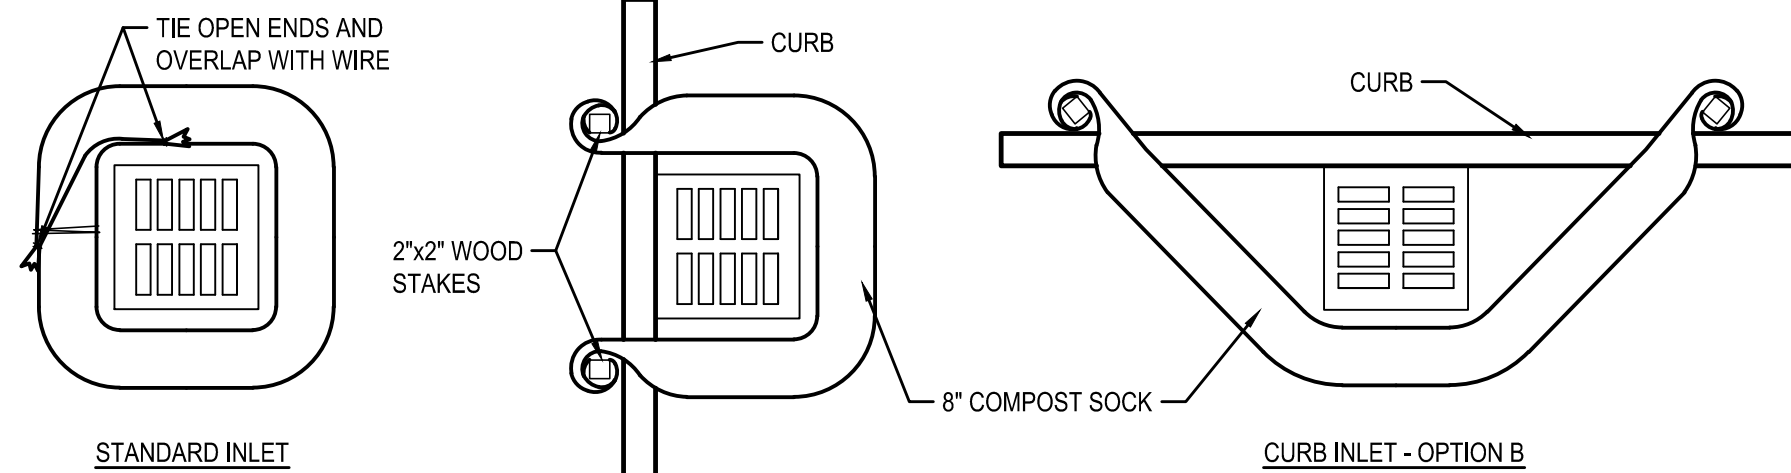

INSTALLATION NOTES

1. COMPOST SOCKS SHALL BE INSTALLED PRIOR TO ANY LAND-DISTURBING ACTIVITIES.
2. COMPOST SOCKS SHALL BE "SILT SOCK", "FILTEROCK" OR OTHER APPROVED FILTER FABRIC SOCK.
3. COMPOST SOCKS SHALL BE FILLED WITH WOOD CHIPS OR COMPOST. SEE SPECIFICATIONS FOR APPROVED COMPOSITION OF WOOD CHIPS OR COMPOST.
4. COMPOST SOCKS SHALL BE INSTALLED PER MANUFACTURERS SPECIFICATIONS.
5. COMPOST SOCK SHALL BE IN CONSTANT CONTACT WITH THE GROUND SURFACE.
6. WOOD STAKES SHALL BE USED TO SECURE THE WATTLES, 1/2" TO 5/8" REBAR OR ISO ACCEPTABLE DUTY STAKE. STAKES SHALL BE LONG ENOUGH TO PROTRUDE SEVERAL INCHES ABOVE THE WATTLE.
7. EXCESS FABRIC SHALL BE WRAPPED AROUND THE STAKES.
8. FOR INLETS NOT ON A CURB THE COMPOST SOCK SHALL BE TIED OFF AT BOTH ENDS WITH THE WIRE AND OVERLAPPED TO PROVIDE SURFACE PROTECTION.

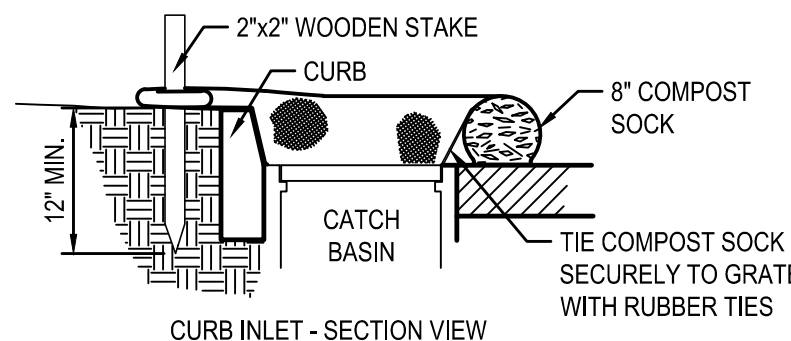

MAINTENANCE:
SEDIMENT ACCUMULATED BEHIND WATTLE SHALL BE REMOVED
WHEN SEDIMENT HAS ACCUMULATED TO ONE-HALF THE DIAMETER
OF THE SILT/COMPOST SOCK.

- NOTES:**
- INSTALLATION:**
WHEN INSTALLING RUNNING LENGTHS OF COMPOST SOCKS, BUTT THE SECOND SOCK TIGHTLY AGAINST THE FIRST, DO NOT OVERLAP THE ENDS. STAKE THE SOCKS AT EACH END AND FIVE FOOT ON CENTER.


STAKES SHOULD BE DRIVEN THROUGH THE MIDDLE OF THE SOCK, LEAVING 2 - 3 INCHES OF THE STAKE PROTRUDING ABOVE THE SOCK AND AT LEAST 12" IN THE GROUND. WHEN COMPOST SOCKS ARE USED FOR FLAT GROUND APPLICATIONS, DRIVE THE STAKES STRAIGHT DOWN; WHEN INSTALLING WATTLES ON SLOPES, DRIVE THE STAKES PERPENDICULAR TO THE SLOPE.

DRIVE THE FIRST END STAKE OF THE SECOND SOCK AT AN ANGLE TOWARD THE FIRST SOCK IN ORDER TO HELP ABUT THEM TIGHTLY TOGETHER.

INSTALLATION NOTES:

1. COMPOST SOCKS SHALL BE INSTALLED PRIOR TO ANY LAND-DISTURBING ACTIVITIES.
2. COMPOST SOCKS SHALL BE "SILT SOCK", "FILTER SOCK" OR OTHER APPROVED FILTER FABRIC SOCK.
3. COMPOST SOCKS SHALL BE FILLED WITH WOOD CHIPS OR COMPOST. SEE SPECIFICATIONS FOR APPROVED COMPOSITION OF WOOD CHIPS OR COMPOST.
4. NOT FOR USE IN CONCENTRATED FLOW AREAS.
5. COMPOST SOCKS SHALL BE INSTALLED PER MANUFACTURER'S SPECIFICATIONS.
6. ON SLOPES, COMPOST SOCKS SHOULD BE INSTALLED CONTOUR WITH A SLIGHT DOWNWARD ANGLE AT THE END OF THE ROW IN ORDER TO PREVENT PONDING AT THE MID SECTION.
7. RUNNING LENGTH OF SOCKS SHOULD BE ADJUSTED FURTHER TO ENSURE NO LEAKAGE AT THE ABUTMENTS.
8. COMPOST SOCK SHALL BE IN CONSTANT CONTACT WITH THE GROUND SURFACE.
9. WOOD STAKES SHALL BE USED TO SECURE THE WATTLES. 12" TO 50" REBAR IS ALSO RECOMMENDED. BE SURE TO USE A STAKE THAT IS LONG ENOUGH TO PENETRATE THE SOIL.

MAINTENANCE:
SEDIMENT ACCUMULATED BEHIND WATTLE SHALL BE REMOVED WHEN SEDIMENT HAS ACCUMULATED TO ONE-HALF THE DIAMETER OF THE WATTLE.

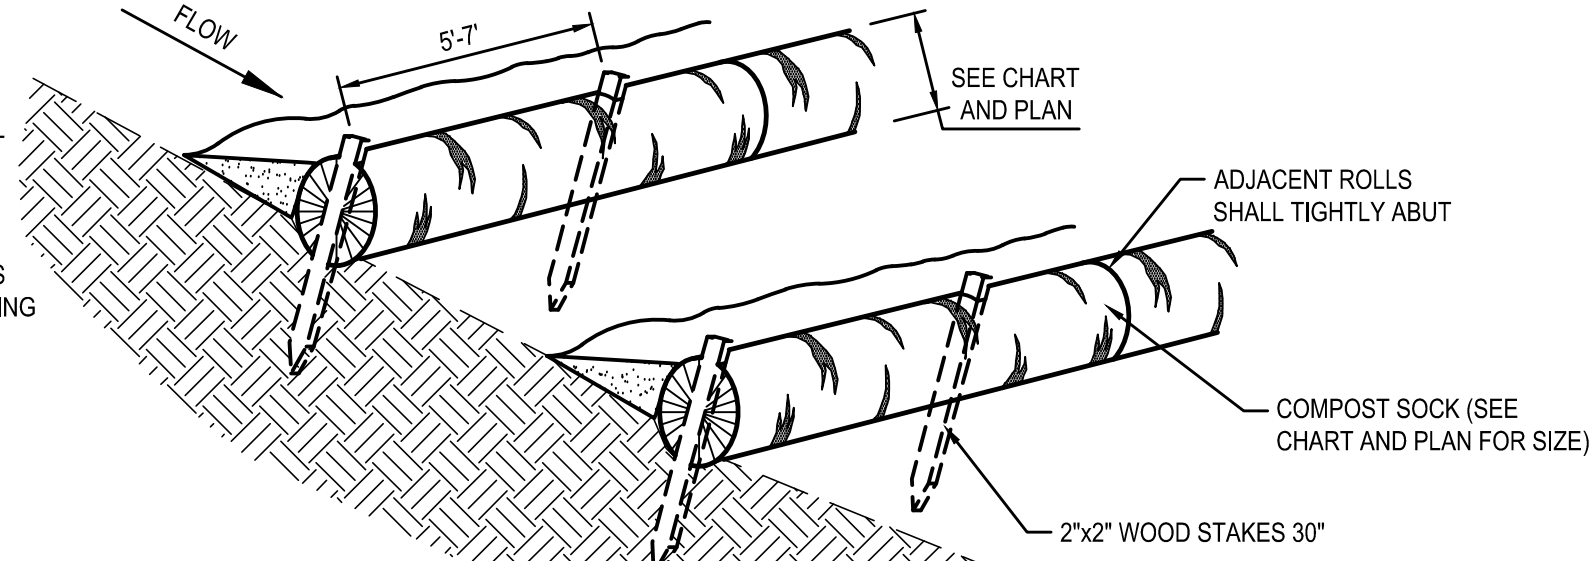

COMPOST SOCK DIAMETER CHART							
DIA. (IN)	SLOPE %						
	2	5	10	20	25	33	50
8	225*	200	100	50	20	—	—
12	250	225	125	65	50	40	25
18	275	250	150	70	55	45	30
24	350	275	200	130	100	60	35
32	450	325	275	150	120	75	50

*LENGTH IN FEET

- 1 COMPOST OR SILT SOCK INSTALLATION DETAIL
SCALE: N.T.S.


AREA B
AREA A

AREA B
AREA A



1 FIRST FLOOR DEMOLITION PLAN - AREA A
1/8" = 1'-0"

WET SPRINKLER SYSTEM IS PRESENT IN THIS BUILDING; CARE SHOULD BE TAKEN AT ALL TIMES TO NOT DISTURB THIS SYSTEM

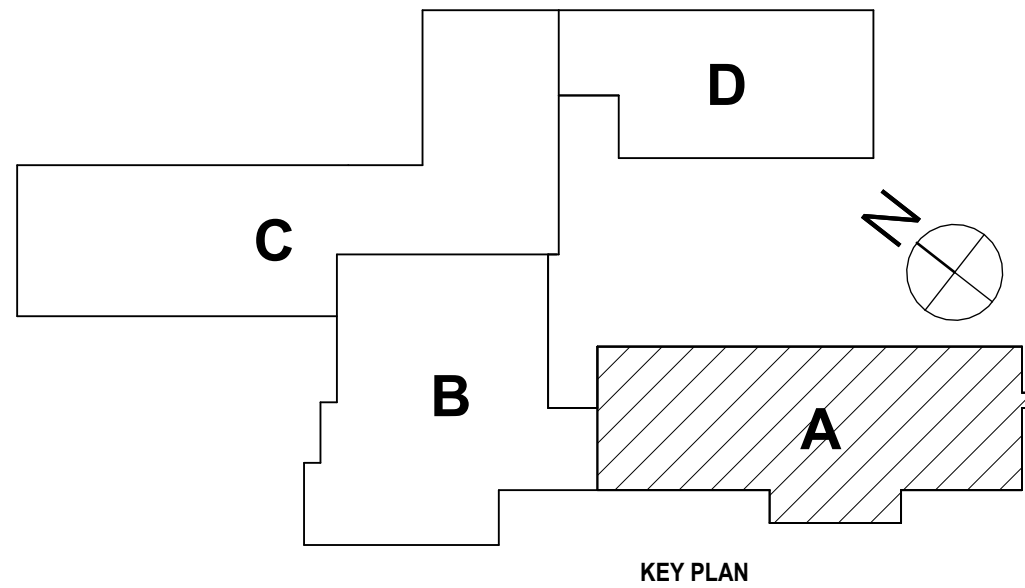

KEY PLAN

GENERAL DEMO NOTES:

- ASBESTOS ABATEMENT IS BEING PERFORMED. ASBESTOS CONTAINING MATERIALS ARE PRESENT IN THE EXISTING BUILDING. REFER TO SPECIFICATIONS FOR LOCATIONS AND SCHEDULE. THE OWNER HAS REPORTS IDENTIFYING ACM MATERIALS AND WILL HAVE THESE AVAILABLE FOR CONTRACTORS REFERENCE. IF SUSPECT MATERIAL NOT SCHEDULED IS ENCOUNTERED, STOP WORK IMMEDIATELY, DO NOT DISTURB THE MATERIAL AND NOTIFY THE OWNER'S REPRESENTATIVES.
- MAINTAIN EXISTING STRUCTURAL SYSTEMS AT ALL TIMES. PROVIDE TEMPORARY SHORING AND BRACING AT LOCATIONS WHERE THE EXISTING STRUCTURE IS BEING MODIFIED. PROTECT THE EXISTING STRUCTURE SCHEDULED TO REMAIN, FROM DAMAGE DURING DEMOLITION. MAINTAIN SHORING AND BRACING UNTIL THE NEW STRUCTURE IS INSTALLED AND READY TO ACCEPT LOADS.
- CONTRACTOR TO PROVIDE PROTECTIVE BARRIER AT ALL AREAS OF DEMOLITION. KEEP ALL EXITS FREE AND CLEAR AT ALL TIMES DURING SCHOOL OPERATIONS.
- THE OWNER RESERVES THE RIGHT TO RETAIN ANY REMOVED ITEMS AFTER CONTRACTOR REMOVAL. THE CONTRACTOR SHALL REMOVE FROM THE SITE AND DISPOSE OF ALL REMOVED ITEMS THE OWNER DOES NOT WISH TO RETAIN.
- FLOOR CONC. AND GRINDING OF SUBSTRATES OF DIFFERENT HEIGHTS IN THE SAME AREA IS REQUIRED AT WALL REMOVALS AND NEW DOORS IN EXG. WALLS TO ALLOW THE NEW FINISHES TO ALIGN BETWEEN ADJACENT ROOMS AND ADJACENT ROOMS THAT BECOME ONE ROOM.
- PATCH, REPAIR, PAINT OR RE-FINISH EXG. CONSTRUCTION MATERIALS AND FINISHES DAMAGED DURING DEMOLITION OR NEW CONSTRUCTION.
- DIMENSIONS SHOWN FOR ALL NEW OPENINGS IN EXISTING CONSTRUCTION SHOULD BE COORDINATED WITH THE NEW PLANS AND EXISTING CONDITIONS IN THE FIELD.
- ROOM NUMBERS INDICATED ARE EXISTING BUILDING NUMBERS. REFER TO NEW FLOOR PLANS (A-1 DRAWING SERIES FOR NEW ROOM NUMBERING).
- REMOVE EXISTING WOOD BLOCKING FOR EXISTING PENCIL SHARPENERS, BULLETIN BOARDS ETC. THAT INTERFERE WITH NEW LOCATIONS OR NEW ROOM FINISHES AND WALL TREATMENTS. TYPICAL FOR ALL AREAS.
- ALL EXISTING BRICK VENEER SCHEDULED FOR DEMOLITION IS TO BE REMOVED WITH CARE, SALVAGED, CLEANED AND STORED FOR RE-USE (TOOTH-N-PATCHING) IN DIFFERENT LOCATIONS OF THE EXISTING BUILDING.
- COORDINATE ANY WALL REPAIR/INFILL THAT IS CAUSED BY THE REMOVAL OF EQUIPMENT IN THE "H", "P", "E", AND "T" DWGS. AND PREPARE SURFACE TO RECEIVE NEW FINISHES.
- WET SPRINKLER SYSTEM IS PRESENT IN THIS BUILDING. CARE SHOULD BE TAKEN AT ALL TIMES TO NOT DISTURB THIS SYSTEM
- ITEMS SHOWN ARE INTENDED TO GIVE APPROXIMATE QUANTITY, LOCATION AND TYPE. CONTRACTOR IS RESPONSIBLE FOR VERIFYING ACTUAL QUANTITIES AND EXISTING FIELD CONDITIONS, IN ORDER TO COMPLETE NEW WORK.

DEMOLITION NOTES:

- REMOVE WIRE GLASS FROM DOOR AND SIDELIGHT ASSEMBLIES AND PREPARE FOR IMPACT SAFETY GLASS TO BE INSTALLED.
- REMOVE EXISTING ACCORDIAN PATRITION ASSEMBLY, TRACK AND ASSOCIATED ACCESSORIES IN ITS ENTIRETY. PATCH AND REPAIR AS NEEDED.
- PREPARE FOR NEW FINISH
- REMOVE COUNTERTOP AND SINK IN THE ENTIRETY.
- REMOVE DOOR KNOB ASSEMBLY FROM DOOR. DOOR TO BE PATCHED & REPAIRED AS NEEDED. PREPARE FOR NEW ACCESSIBLE DOOR HANDLE ASSEMBLY.
- REMOVE EXISTING CARPET FLOORING AND BASE IN ITS ENTIRETY. PREPARE EXISTING CONCRETE SLAB FOR NEW FLOORING.
- REMOVE DOOR, FRAME, AND HARDWARE IN ITS ENTIRETY TO EXTENTS SHOWN ON PLAN.
- REMOVE SUSPENDED CEILING SYSTEMS AND SOFFITS IN ITS ENTIRETY.
- REMOVE CASEWORK ONLY TO EXTENTS IMPACTED BY NEW TOILET ROOM PARTITION WALL. THIS INCLUDES TWO BAYS OF CASEWORK, ADJACENT CASEWORK SHALL REMAIN IN ITS EXISTING CONDITION. NEW TOILET ROOM PARTITION SHALL NOT IMPEDE OPERATION OF CASEWORK TO REMAIN.
- REMOVE STUD PARTITION COMPLETELY UP TO EXISTING DECK OR STRUCTURE ABOVE TO EXTENTS SHOWN ON PLAN. DEMOLITION TO INCLUDE BASE, DOORS, FRAMES GLAZING AND ALL WALL MOUNTED/RECESSED ACCESSORIES, CASEWORK AND EQUIPMENT.
- REMOVE PAIR OF CUBBIES AND STORAGE CASEWORK ABOVE WITH CARE. PROTECT AND STORE FOR REINSTALLATION. COORDINATE WITH PROPOSED FLOOR PLAN.
- REMOVE TALL CABINET WITH CARE. PROTECT AND STORE FOR REINSTALLATION IN A DIFFERENT LOCATION.
- REMOVE EXISTING CLERESTORY WINDOW IN ITS ENTIRETY. PREPARE ROOF EDGE AND EXISTING WALL FOR NEW CLERESTORY WINDOW.
- REMOVE EXTERIOR WALL SYSTEM UNDER CLERESTORY WINDOW TO EXTENTS SHOWN ON DEMO WALL SECTION (3/EV-A.02).
- PROVIDE NEW OPENING IN MASONRY WALL FOR NEW PASSAGE, DOOR/WINDOW FRAME, BLOCKING, LINTEL OR STEEL COLUMN. REFER TO LINTEL SCHEDULE FOR SIZE AND TYPE. FINISH CUT EDGES OF WOOD PANELING. PTM AS NEEDED.
- PORTION OF STAGE FLOOR IS ABATED TO EXTENTS SHOWN. FINISH CUT EDGES OF WOOD FLOOR, PTM AS NEEDED. PREPARE FOR NEW CHAIR LIFT.
- REMOVE STAGE STAIR ASSEMBLY INCLUDING RAILINGS IN ITS ENTIRETY. PREPARE FLOOR AND EDGE OF STAGE FLOOR FOR NEW CHAIR LIFT.
- DISPOSE EXISTING FREE STANDING WOOD STAIR.
- REMOVE TOILET ROOM SIGNAGE WITH CARE AND STORE FOR REINSTALLATION.
- REMOVE FIRE EXTINGUISHER WITH CARE AND STORE FOR REINSTALLATION.
- REMOVE ACT SYSTEM TO EXTENTS SHOWN IMPACTED BY NEW PARTITION WALLS. COORDINATE WITH PROPOSED RCP PLANS
- DOOR AND FRAME ASSEMBLY TO BE REMOVED WITH CARE. PROTECT AND STORE IN A SAFE PLACE FOR REINSTALLATION IN A DIFFERENT LOCATION.
- REMOVE MARBLE THRESHOLD WITH CARE. PROTECT AND STORE TO BE REINSTALLED AT NEW TOILET ROOM DOOR.
- REMOVE MASONRY PARTITION COMPLETELY UP TO EXISTING DECK OR STRUCTURE ABOVE TO EXTENTS SHOWN ON PLAN. DEMOLITION TO INCLUDE BASE, DOORS, FRAMES, GLAZING AND WALL MOUNTED/RECESSED ACCESSORIES, CASEWORK AND EQUIPMENT.
- REMOVE ACT SYSTEM FROM KITCHEN. REMOVE CEILING TILES WITH CARE AND STORE FOR REINSTALLATION IN NEW GRID. COORDINATE WITH PROPOSED RCP PLANS
- REMOVE WALL TILE FROM PARTITION SCHEDULED TO REMAIN. PREPARE WALL TO RECEIVE NEW FINISHES.
- REMOVE FLOOR TILE IN ENTIRETY OF TOILET ROOM. PREPARE SLAB TO RECEIVE NEW FINISHES.
- REMOVE ACT SYSTEM ONLY TO EXTENTS NEEDED FOR NEW TOILET ROOM PARTITIONS. ASSUME 140SF BASE BID; ALT. #1 ADD 140SF.

SED #ERWIN VALLEY 15-10-00-01-0-00-027; DOWN BUILDING 15-10-00-01-1-001-013

FIRST FLOOR DEMOLITION PLAN - AREA A

2025 ERWIN VALLEY ELEM & ADMIN BUILDING ALTERATIONS
CORNING-PAINTED POST ASD

16 BEARTOWN ROAD, PAINTED POST NY 14870

HUNT ENGINEERS | ARCHITECTS | SURVEYORS

ALBANY, NY - BINGHAMTON, NY - HORSESHOE FALLS, NY - ROCHESTER, NY
NEW YORK, NY - SENECA FALLS, NY - SYRACUSE, NY

WWW.HUNT-EAS.COM 807-358-1000
NY CERTIFICATE NO. 0016320 PA CERTIFICATE NO. TSC220313464-1


EV-A0.1

PROJECT NO: 2649-160


DRAWN BY: CAM
CHECKED BY: SZ
DATE: 03/17/2026
PHASE: CP

REVISION:
DATE: 1 10/2/2026
ISSUE FOR BID


"IT IS A VIOLATION OF THE LAW FOR ANY PERSON TO MAKE UNAUTHORIZED ALTERATIONS OR ADDITIONS TO PLANS BEARING A LICENSED ENGINEER'S ARCHITECT'S OR SURVEYOR'S SEAL."

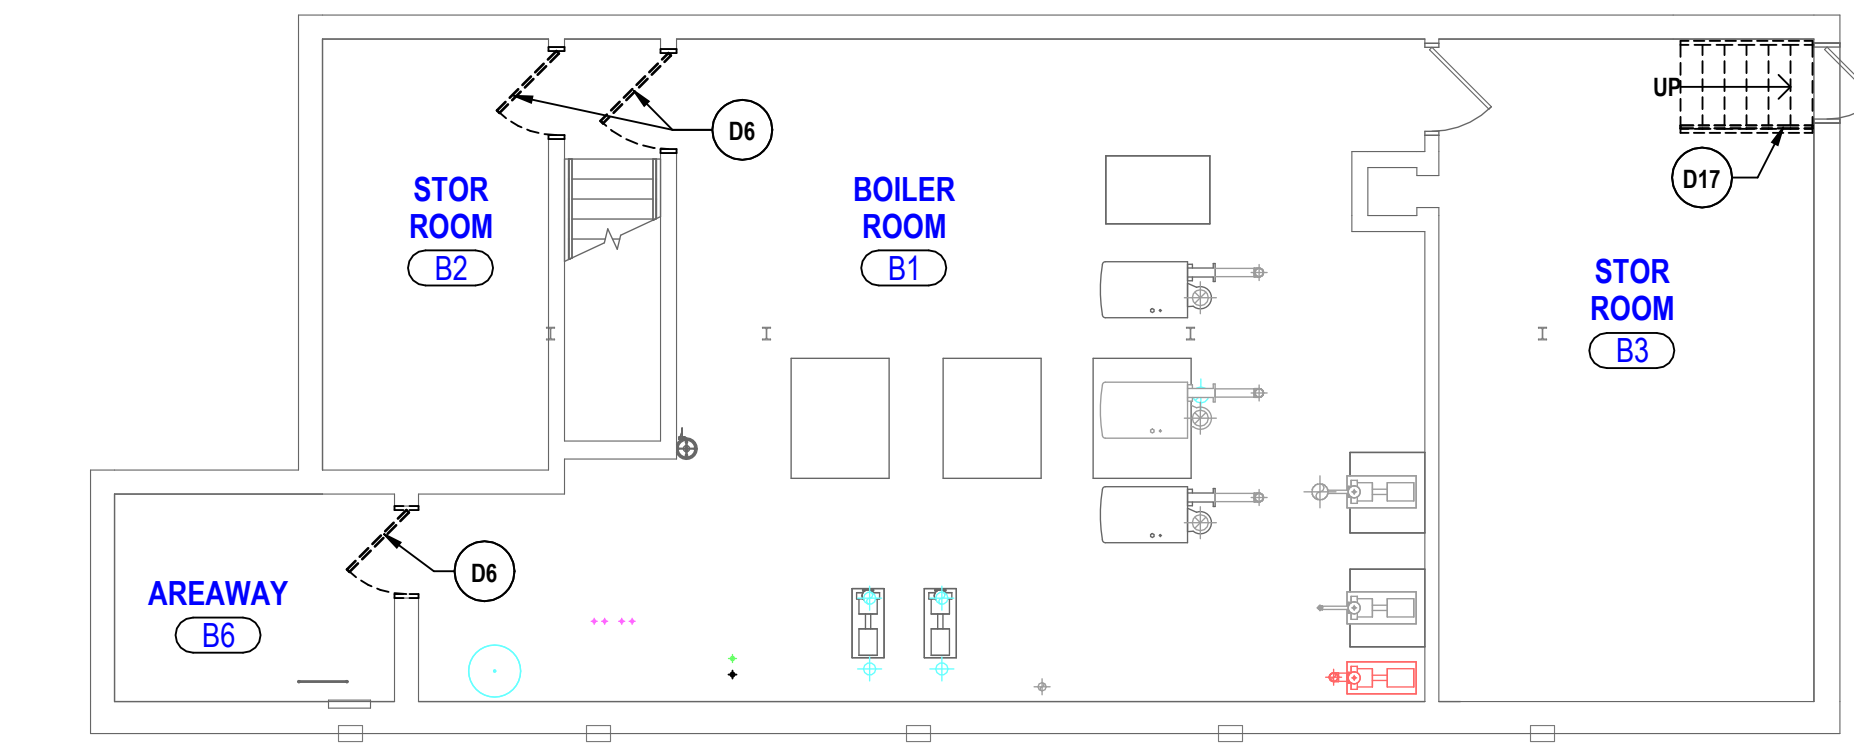

1 BASEMENT DEMOLITION PLAN - BOILER RM.
1/8" = 1'-0"

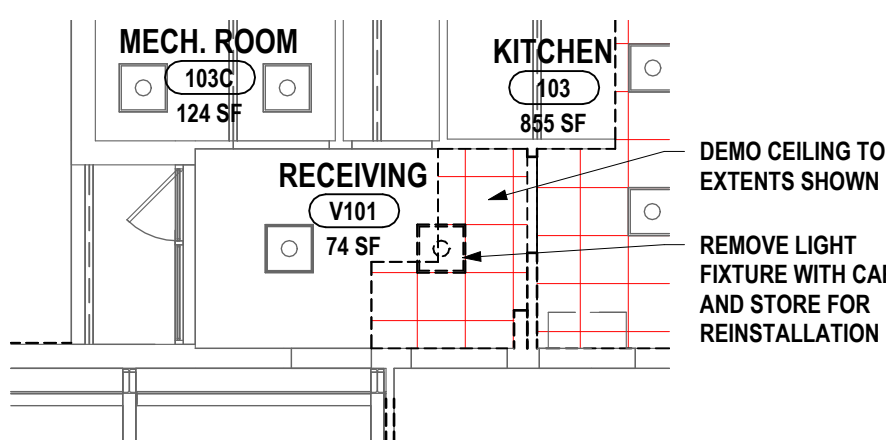


4 RECEIVING CEILING DEMO PLAN
1/8" = 1'-0"

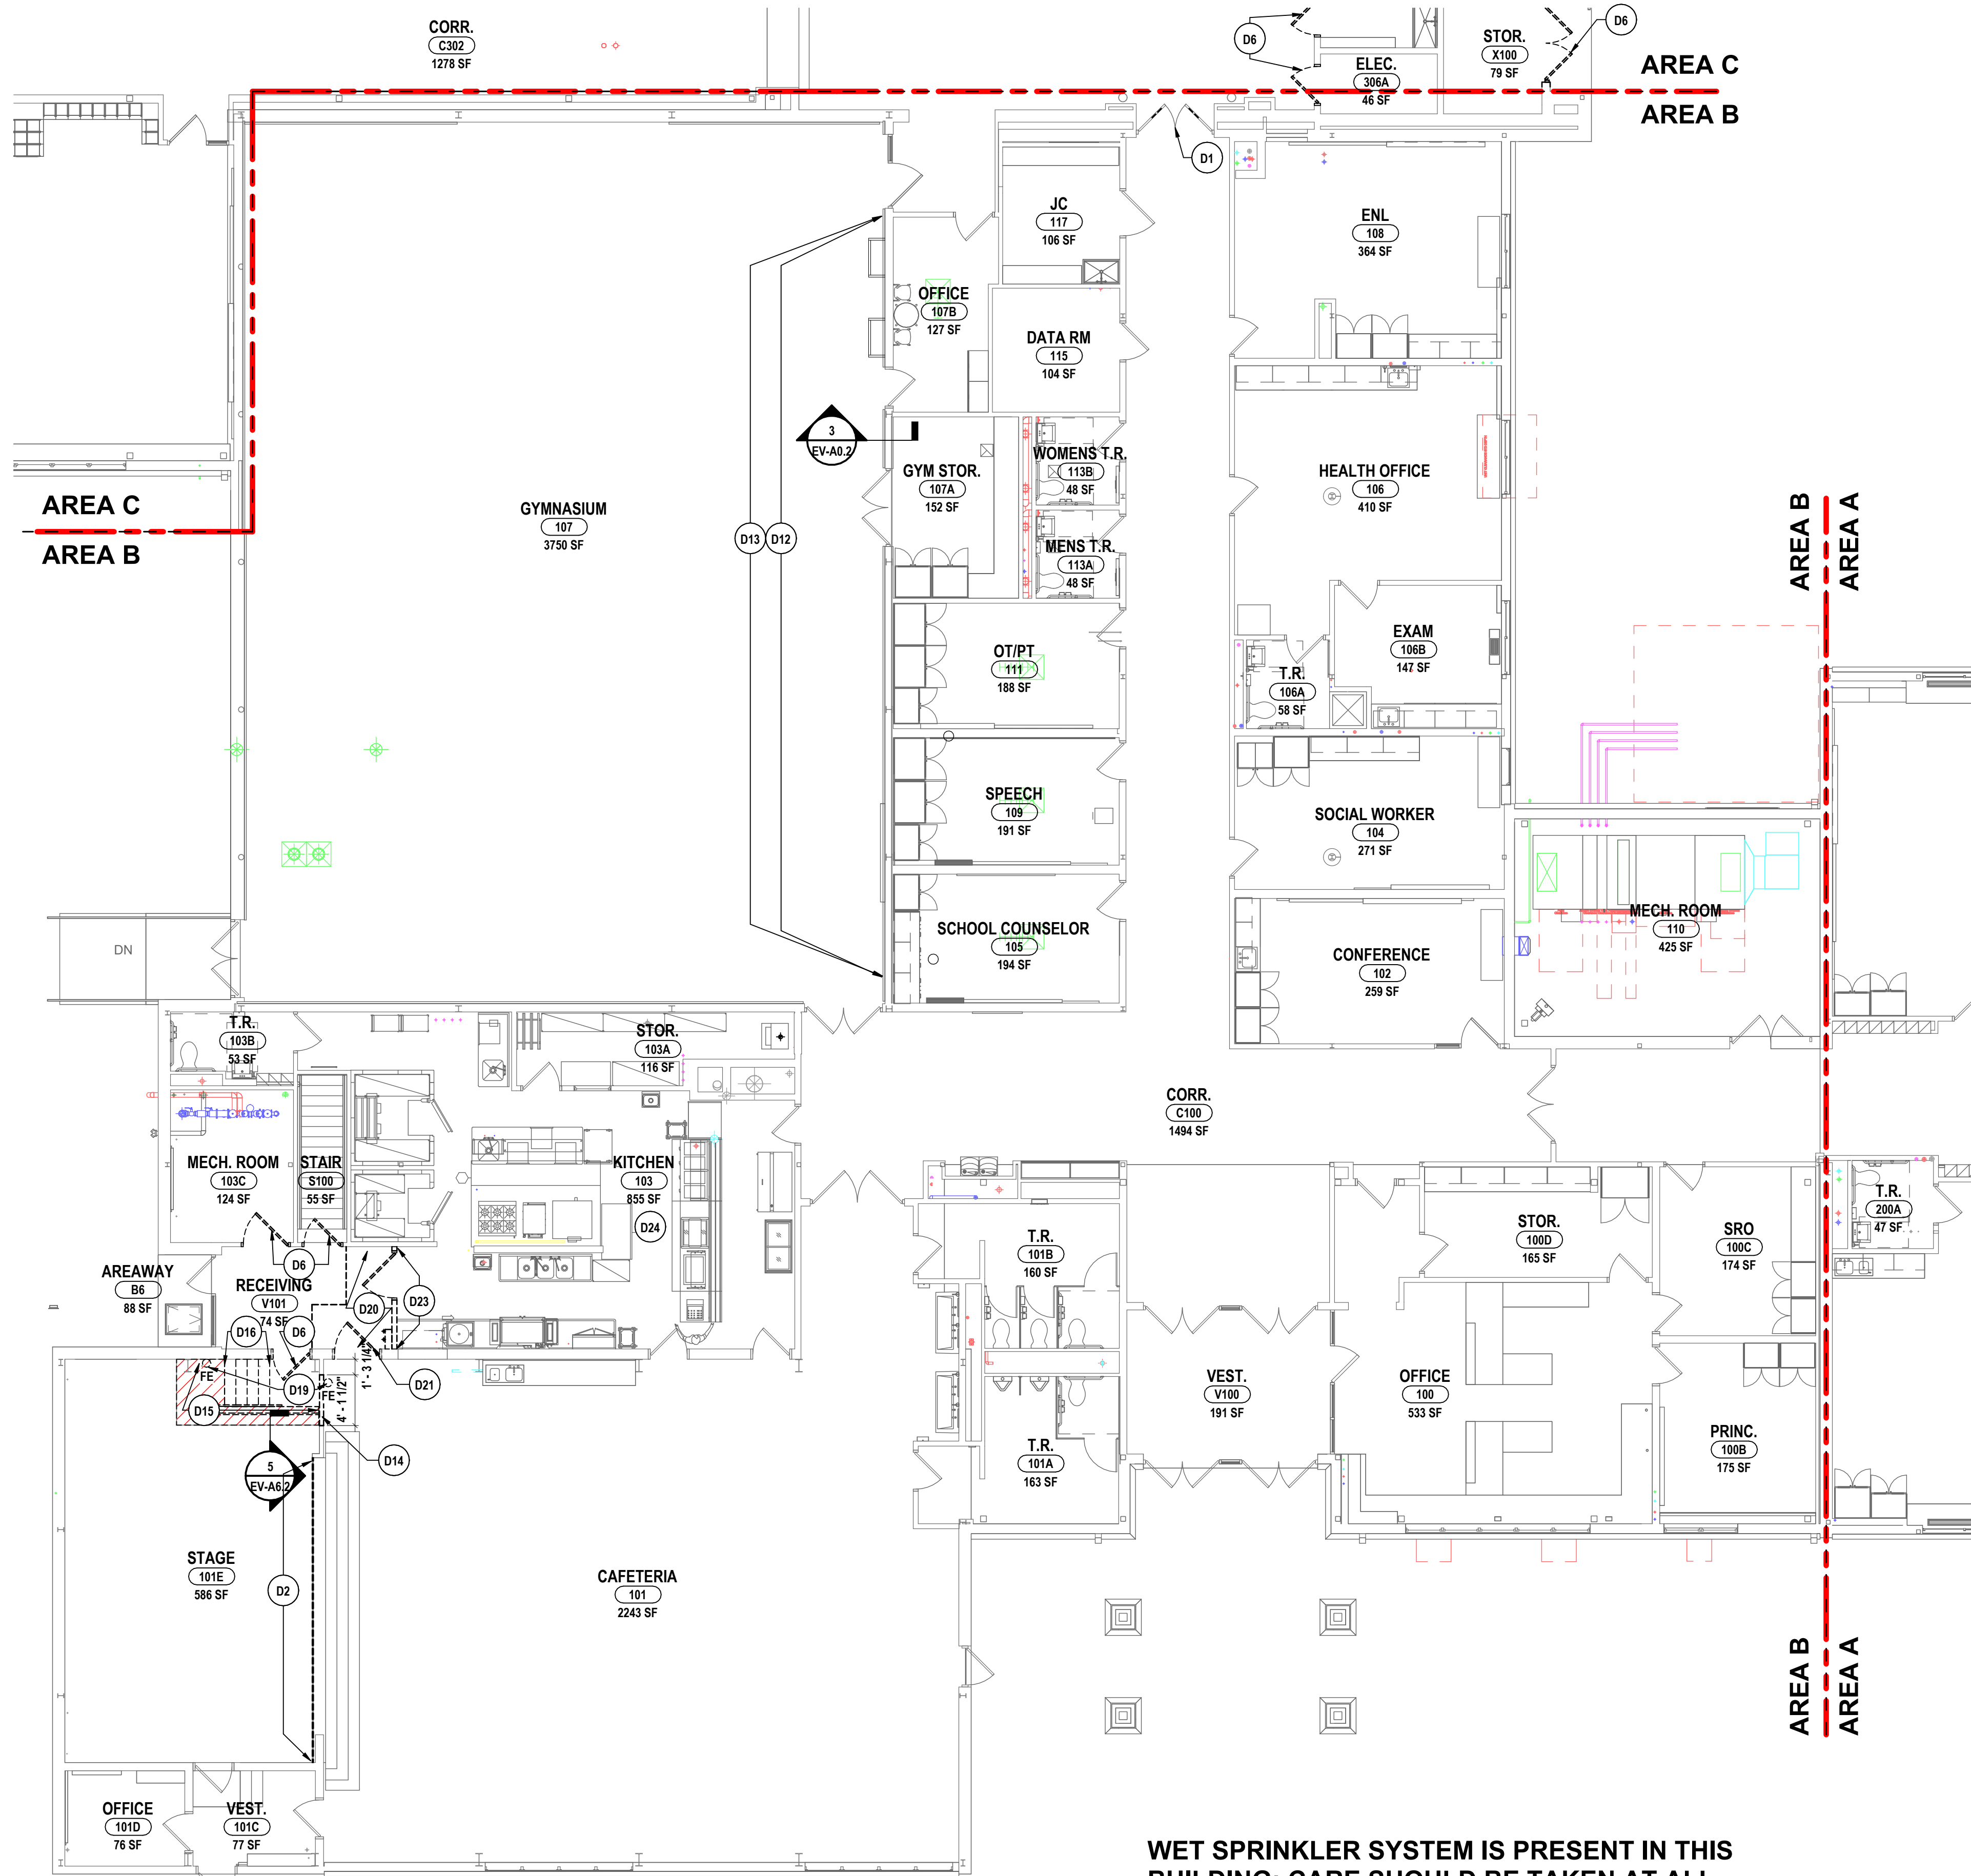

WET SPRINKLER SYSTEM IS PRESENT IN THIS BUILDING; CARE SHOULD BE TAKEN AT ALL TIMES TO NOT DISTURB THIS SYSTEM

2 FIRST FLOOR DEMOLITION PLAN - AREA B
1/8" = 1'-0"

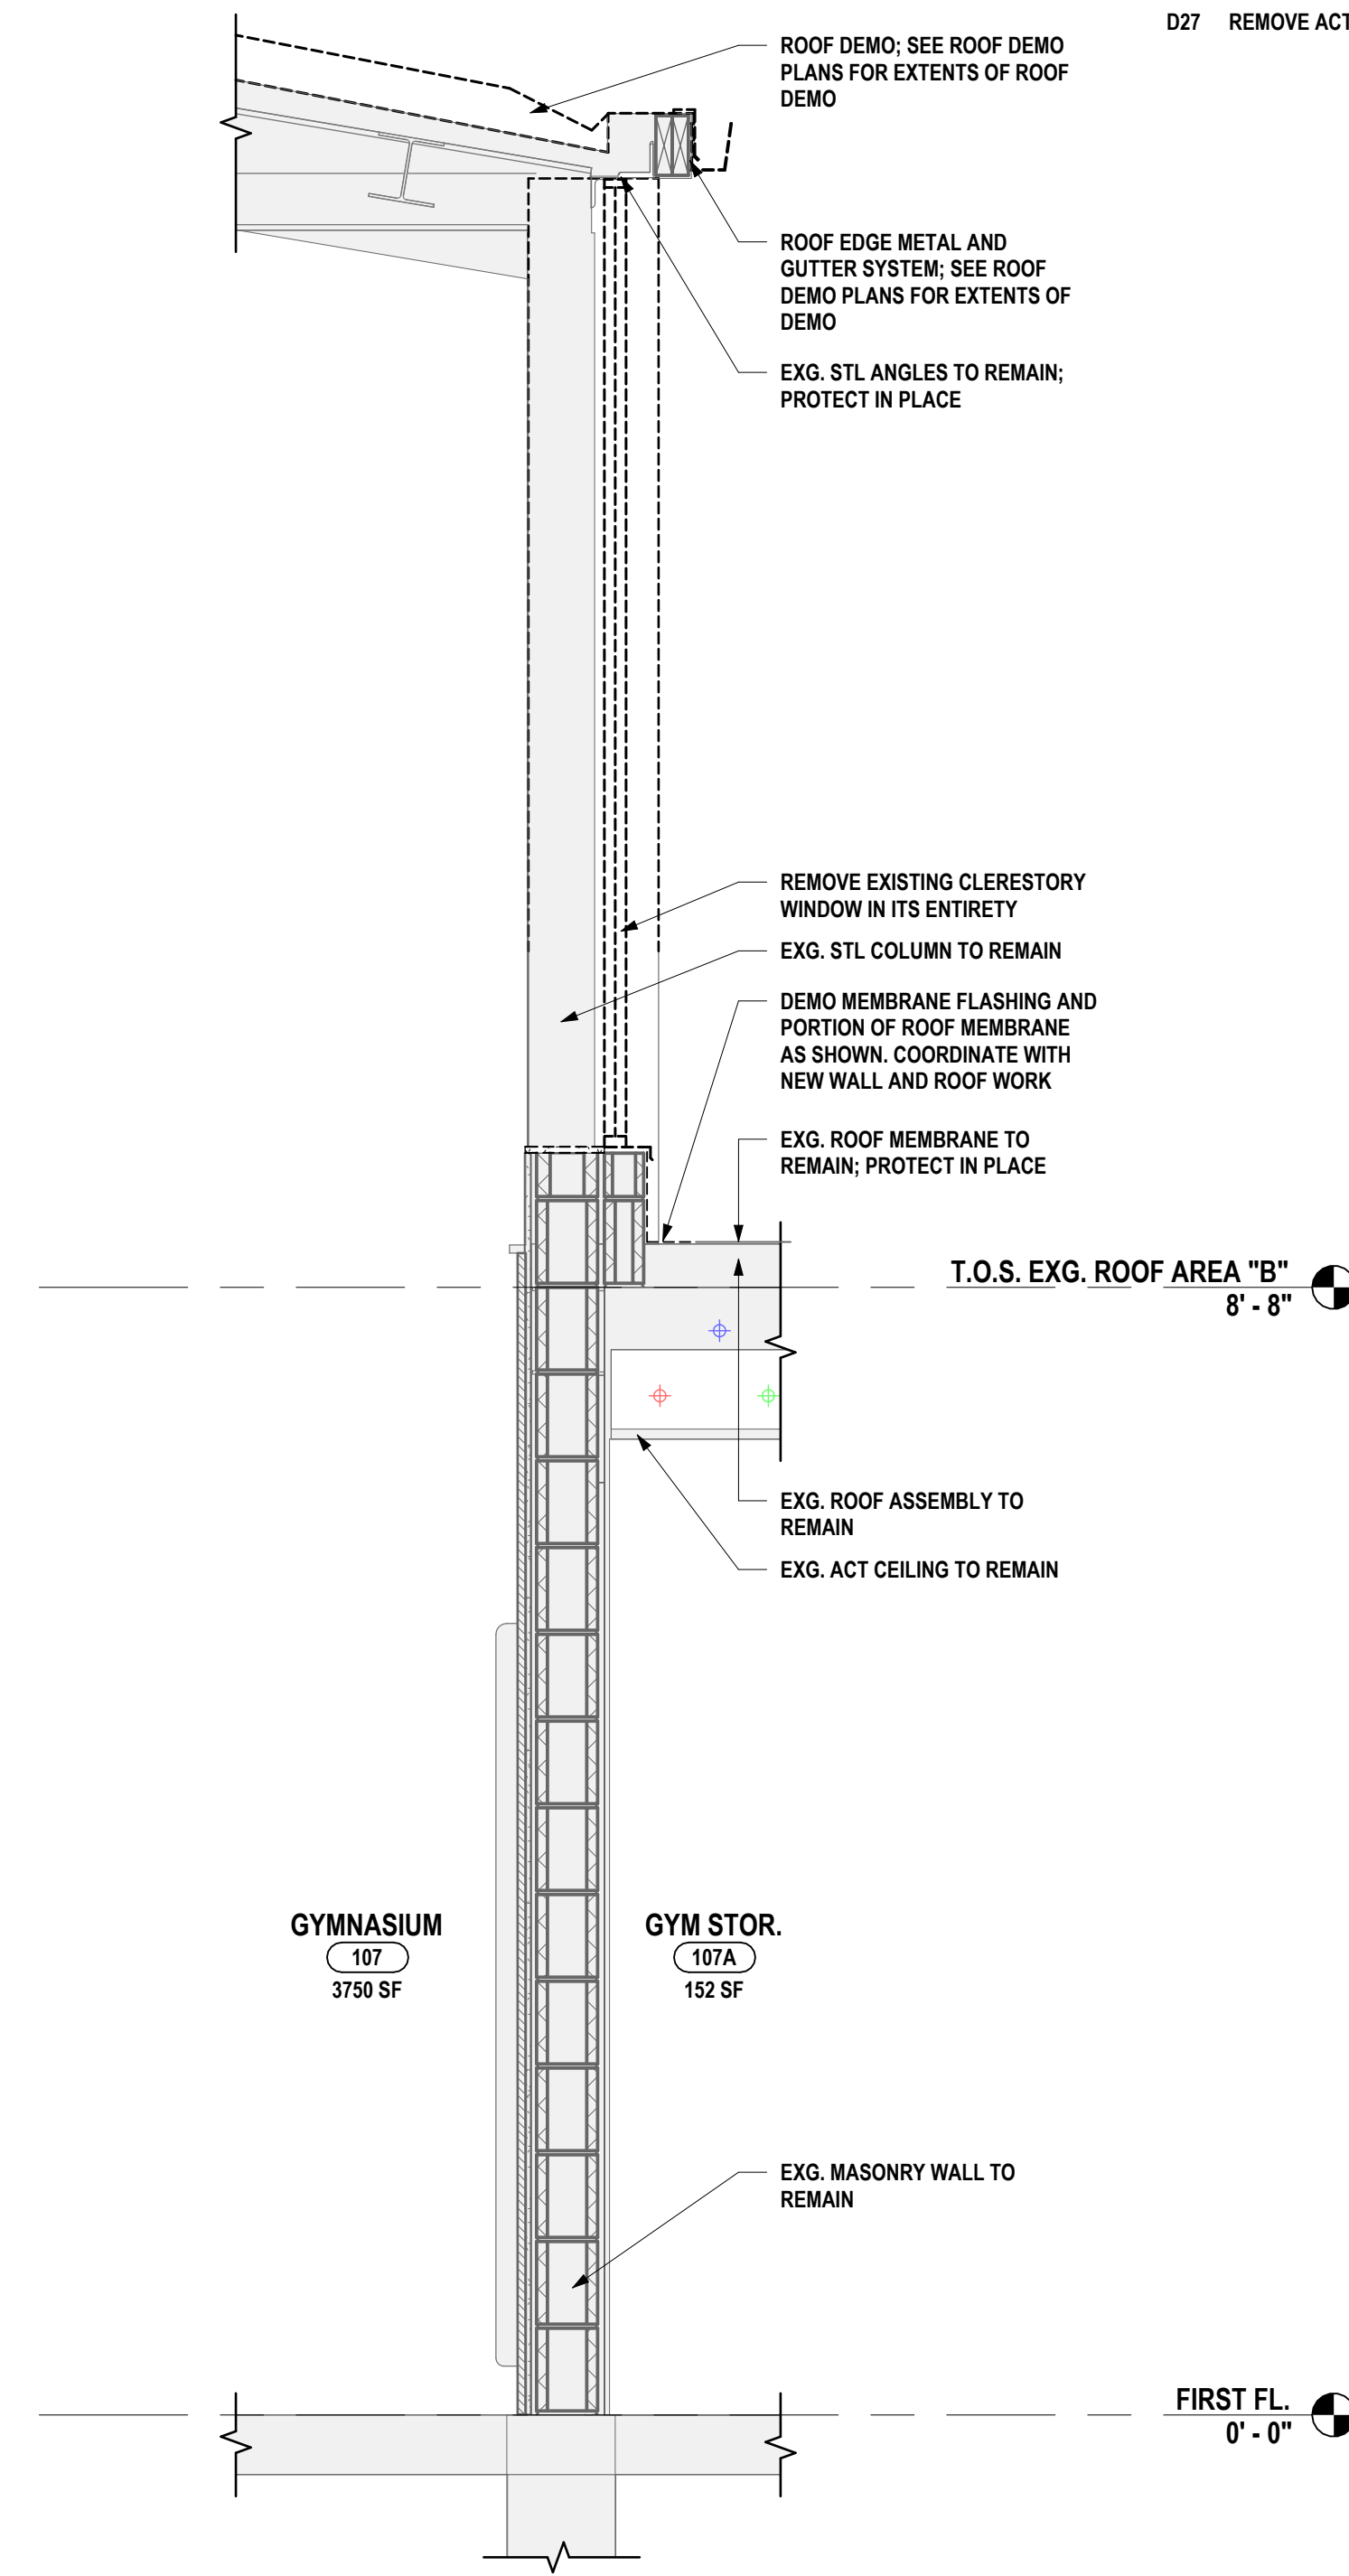


3 WALL DEMO SECTION @ GYM CLERESTORY WINDOW
3/4" = 1'-0"

GENERAL DEMO NOTES:

- ASBESTOS ABATEMENT IS BEING PERFORMED. ASBESTOS CONTAINING MATERIALS ARE PRESENT IN THE EXISTING BUILDING. REFER TO SPECIFICATIONS FOR LOCATIONS AND SCHEDULE. THE OWNER HAS REPORTS IDENTIFYING ACM MATERIALS AND WILL HAVE THESE AVAILABLE FOR CONTRACTORS REFERENCE. IF SUSPECT MATERIAL NOT SCHEDULED IS ENCOUNTERED, STOP WORK IMMEDIATELY. DO NOT DISTURB THE MATERIAL AND NOTIFY THE OWNER'S REPRESENTATIVES.
- MAINTAIN EXISTING STRUCTURAL SYSTEMS AT ALL TIMES. PROVIDE TEMPORARY SHORING AND BRACING AT LOCATIONS WHERE THE EXISTING STRUCTURE IS BEING MODIFIED. PROTECT THE EXISTING STRUCTURE SCHEDULED TO REMAIN, FROM DAMAGE DURING DEMOLITION. MAINTAIN SHORING AND BRACING UNTIL THE NEW STRUCTURE IS INSTALLED AND READY TO ACCEPT LOADS.
- CONTRACTOR TO PROVIDE PROTECTIVE BARRIER AT ALL AREAS OF DEMOLITION. KEEP ALL EXITS FREE AND CLEAR AT ALL TIMES DURING SCHOOL OPERATIONS.
- THE OWNER RESERVES THE RIGHT TO RETAIN ANY REMOVED ITEMS AFTER CONTRACTOR REMOVAL. THE CONTRACTOR SHALL REMOVE FROM THE SITE AND DISPOSE OF ALL REMOVED ITEMS THE OWNER DOES NOT WISH TO RETAIN.
- FLOOR CONC. AND GRINDING OF SUBSTRATES OF DIFFERENT HEIGHTS IN THE SAME AREA IS REQUIRED AT WALL REMOVALS AND NEW DOORS IN EXG. WALLS TO ALLOW THE NEW FINISHES TO ALIGN BETWEEN ADJACENT ROOMS AND ADJACENT ROOMS THAT BECOME ONE ROOM.
- PATCH, REPAIR, PAINT OR RE-FINISH EXG. CONSTRUCTION MATERIALS AND FINISHES DAMAGED DURING DEMOLITION OR NEW CONSTRUCTION.
- CONTRACTOR TO COORDINATE THE WORK OF THIS CONTRACT WITH THE WORK OF OTHER TRADES.
- DIMENSIONS SHOWN FOR ALL NEW OPENINGS IN EXISTING CONSTRUCTION SHOULD BE COORDINATED WITH THE NEW PLANS AND EXISTING CONDITIONS IN THE FIELD.
- ROOM NUMBERS INDICATED ARE EXISTING BUILDING NUMBERS. REFER TO NEW FLOOR PLANS (A-1 DRAWING SERIES FOR NEW ROOM NUMBERING).
- REMOVE EXISTING WOOD BLOCKING FOR EXISTING PENCIL SHARPENERS, BULLETIN BOARDS ETC. THAT INTERFERE WITH NEW LOCATIONS OR NEW ROOM FINISHES AND WALL TREATMENTS. TYPICAL FOR ALL AREAS.
- ALL EXISTING BRICK VENEER SCHEDULED FOR DEMOLITION IS TO BE REMOVED WITH CARE, SALVAGED, CLEANED AND STORED FOR RE-USE (TOOTH-N PATCHING IN DIFFERENT LOCATIONS OF THE EXISTING BUILDING).
- COORDINATE ANY WALL REPAIR/INFILL THAT IS CAUSED BY THE REMOVAL OF EQUIPMENT IN THE "H", "P", "E", AND "T" DWGS. AND PREPARE SURFACE TO RECEIVE NEW FINISHES.
- WET SPRINKLER SYSTEM IS PRESENT IN THIS BUILDING. CARE SHOULD BE TAKEN AT ALL TIMES TO NOT DISTURB THIS SYSTEM.
- ITEMS SHOWN ARE INTENDED TO GIVE APPROXIMATE QUANTITY, LOCATION AND TYPE. CONTRACTOR IS RESPONSIBLE FOR VERIFYING ACTUAL QUANTITIES AND EXISTING FIELD CONDITIONS, IN ORDER TO COMPLETE NEW WORK.

DEMOLITION NOTES:

- REMOVE WIRE GLASS FROM DOOR AND SIDELIGHT ASSEMBLIES AND PREPARE FOR IMPACT SAFETY GLASS TO BE INSTALLED.
- REMOVE EXISTING ACCORDIAN PATRITION ASSEMBLY, TRACK AND ASSOCIATED ACCESSORIES IN ITS ENTIRETY. PATCH AND REPAIR AS NEEDED. PREPARE FOR NEW FINISH.
- REMOVE COUNTERTOP AND SINK IN THE ENTIRETY.
- REMOVE DOOR KNOB ASSEMBLY FROM DOOR. DOOR TO BE PATCHED & REPAIRED AS NEEDED. PREPARE FOR NEW ACCESSIBLE DOOR HANDLE ASSEMBLY.
- REMOVE EXISTING CARPET FLOORING AND BASE IN ITS ENTIRETY. PREPARE EXISTING CONCRETE SLAB FOR NEW FLOORING.
- REMOVE DOOR, FRAME, AND HARDWARE IN ITS ENTIRETY TO EXTENTS SHOWN ON PLAN.
- REMOVE SUSPENDED CEILING SYSTEMS AND SOFFITS IN ITS ENTIRETY.
- REMOVE CASEWORK ONLY TO EXTENTS IMPACTED BY NEW TOILET ROOM PARTITION WALL. THIS INCLUDES TWO BAYS OF CASEWORK. ADJACENT CASEWORK SHALL REMAIN IN ITS EXISTING CONDITION. NEW TOILET ROOM PARTITION SHALL NOT IMPIDE OPERATION OF CASEWORK TO REMAIN.
- REMOVE STUD PARTITION COMPLETELY UP TO EXISTING DECK OR STRUCTURE ABOVE TO EXTENTS SHOWN ON PLAN. DEMOLITION TO INCLUDE BASE, DOORS, FRAMES GLAZING AND ALL WALL MOUNTED RECESSED ACCESSORIES, CASEWORK AND EQUIPMENT.
- REMOVE PAIR OF CLUBBIES AND STORAGE CASEWORK ABOVE WITH CARE. PROTECT AND STORE FOR REINSTALLATION. COORDINATE WITH PROPOSED FLOOR PLAN.
- REMOVE TALL CABINET WITH CARE. PROTECT AND STORE FOR REINSTALLATION IN A DIFFERENT LOCATION.
- REMOVE EXISTING CLERESTORY WINDOW IN ITS ENTIRETY. PREPARE ROOF EDGE AND EXISTING WALL FOR NEW CLERESTORY WINDOW.
- REMOVE EXTERIOR WALL SYSTEM UNDER CLERESTORY WINDOW TO EXTENTS SHOWN ON DEMO WALL SECTION (3-1/4-1/2).
- PROVIDE NEW OPENING IN MASONRY WALL FOR NEW PASSAGE. DOOR/WINDOW FRAME, BLOCKING, LINTEL OR STEEL COLUMN. REFER TO LINTEL SCHEDULE FOR SIZE AND TYPE. FINISH CUT EDGES OF WOOD PANELING. PTM AS NEEDED.
- PORTION OF STAGE FLOOR IS ABATED TO EXTENTS SHOWN. FINISH CUT EDGES OF WOOD FLOOR. PTM AS NEEDED. PREPARE FOR NEW CHAIR LIFT.
- REMOVE STAGE STAIR ASSEMBLY INCLUDING RAILINGS IN ITS ENTIRETY. PREPARE FLOOR AND EDGE OF STAGE FLOOR FOR NEW CHAIR LIFT.
- DISPOSE EXISTING FREE STANDING WOOD STAIR.
- REMOVE TOILET ROOM SIGNAGE WITH CARE AND STORE FOR REINSTALLATION.
- REMOVE FIRE EXTINGUISHER WITH CARE AND STORE FOR REINSTALLATION.
- REMOVE ACT SYSTEM TO EXTENTS IMPACTED BY NEW PARTITION WALLS. COORDINATE WITH PROPOSED RCP PLANS.
- DOOR AND FRAME ASSEMBLY TO BE REMOVED WITH CARE. PROTECT AND STORE IN A SAFE PLACE FOR REINSTALLATION IN A DIFFERENT LOCATION.
- REMOVE MARBLE THRESHOLD WITH CARE. PROTECT AND STORE TO BE REINSTALLED AT NEW TOILET ROOM DOOR.
- REMOVE MASONRY PARTITION COMPLETELY UP TO EXISTING DECK OR STRUCTURE ABOVE TO EXTENTS SHOWN ON PLAN. DEMOLITION TO INCLUDE BASE, DOORS, FRAMES, GLAZING AND WALL MOUNTED RECESSED ACCESSORIES, CASEWORK AND EQUIPMENT.
- REMOVE ACT SYSTEM FROM KITCHEN. REMOVE CEILING TILES WITH CARE AND STORE FOR REINSTALLATION IN NEW GRID. COORDINATE WITH PROPOSED RCP PLANS.
- REMOVE WALL TILE FROM PARTITION SCHEDULED TO REMAIN. PREPARE WALL TO RECEIVE NEW FINISHES.
- REMOVE FLOOR TILE IN ENTIRETY OF TOILET ROOM. PREPARE SLAB TO RECEIVE NEW FINISHES.
- REMOVE ACT SYSTEM ONLY TO EXTENTS NEEDED FOR NEW TOILET ROOM PARTITIONS. ASSUME 146SF BASE BID; ALT. #1 ADD 140SF.

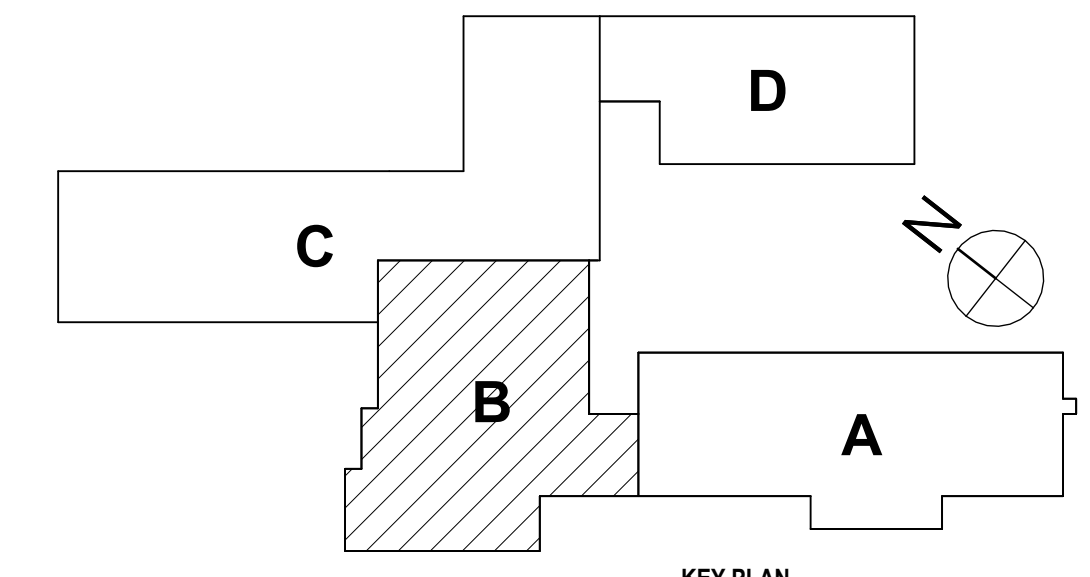

KEY PLAN

SED #ERWIN VALLEY ST 10-000-P-000-027; DOWN BUILDING ST 10-000-P-1-001-013

FIRST FLOOR DEMOLITION PLAN - AREA B

2025 ERWIN VALLEY ELEM & ADMIN BUILDING ALTERATIONS

CORNING-PAINTED POST ASD

16 BEARTOWN ROAD, PAINTED POST NY 14870

HUNT ENGINEERS | ARCHITECTS | SURVEYORS
ALBANY, NY - BINGHAMTON, NY - HORSESHOE FALLS, NY - ROCHESTER, NY
WWW.HUNT-EAS.COM 807-358-1000
NY CERTIFICATE NO. 0016320 PA CERTIFICATE NO. TSC220313464-1

EV-A0.2

PROJECT NO: 2649-160

DRAWN BY: CAM	
CHECKED BY: SZ	
DATE: 03/17/2026	
PHASE: CD	
#	REVISION:
1	ISSUE FOR BID
DATE:	10/22/2025
"IT IS A VIOLATION OF THE LAW FOR ANY PERSON TO MAKE UNAUTHORIZED ALTERATIONS OR ADDITIONS TO PLANS BEARING A LICENSED ENGINEER'S	

"IT IS A VIOLATION OF THE LAW FOR ANY PERSON TO MAKE UNAUTHORIZED ALTERATIONS OR ADJUSTMENTS TO PLANS BEARING A LICENSED ENGINEER'S ARCHITECT'S OR SURVEYOR'S SEAL."

A. ASBESTOS ABATEMENT IS BEING PERFORMED. ASBESTOS CONTAINING MATERIALS ARE PRESENT IN THE EXISTING BUILDING. REFER TO SPECIFICATIONS FOR LOCATIONS AND SCHEDULE. THE OWNER HAS REPORTS IDENTIFYING ACM MATERIALS AND WILL HAVE THESE AVAILABLE FOR CONTRACTORS REFERENCE. IF SUCH MATERIAL NOT SCHEDULED IS ENCOUNTERED, STOP WORK IMMEDIATELY, DO NOT DISTURB THE MATERIAL WITHIN THE EXISTING IDENTIFIERS.

B. MAINTAIN EXISTING STRUCTURAL SYSTEMS AT ALL TIMES. PROVIDE TEMPORARY SHORING AND BRACING AT LOCATIONS WHERE THE EXISTING STRUCTURE IS BEING MODIFIED. PROTECT THE EXISTING STRUCTURE SCHEDULED TO REMAIN, FROM DAMAGE DURING DEMOLITION. MAINTAIN SHORING AND BRACING UNTIL THE NEW STRUCTURE IS INSTALLED AND READY TO ACCEPT LOADS.

C. CONTRACTOR TO PROVIDE PROTECTIVE BARRIER AT ALL AREAS OF DEMOLITION. KEEP ALL EXITS FREE AND CLEAR AT ALL TIMES DURING SHORING OPERATIONS.

D. THE OWNER RESERVES THE RIGHT TO RETAIN ANY REMOVED ITEMS AFTER CONTRACTOR REMOVAL. THE CONTRACTOR SHALL REMOVE FROM THE SITE AND DISPOSE OF ALL REMOVED ITEMS THE OWNER DOES NOT WISH TO RETAIN.

E. FLOOR CONC. AND GRINDING OF SUBSTRATES OF DIFFERENT HEIGHTS IN THE SAME AREA IS REQUIRED AT WALL REMOVALS AND ROOMS IN EXG. WALLS TO ALLOW THE NEW FINISHES TO ALIGN BETWEEN ADJACENT ROOMS AND ADJACENT ROOMS THAT BECOME ONE ROOM.

F. CONTRACTOR SHALL NOT ALLOW ANY MATERIALS TO BE LEFT ON THE EXISTING STRUCTURE DURING DEMOLITION OR NEW CONSTRUCTION.

G. CONTRACTOR TO COORDINATE THE WORK OF THIS CONTRACT WITH THE WORK OF OTHER TRADES.

H. DIMENSIONS SHOWN FOR ALL NEW OPENINGS IN EXISTING STRUCTURE SHOULD BE COORDINATED WITH THE NEW PLANS AND EXISTING CONDITIONS IN THE FIELD.

I. REMOVALS AND INDICATORS ARE EXISTING BUILDING NUMBERS, REFERENCE TO FLOOR PLANS (A-D) DRAWING SERIES FOR NEW ROOM NUMBERS).

J. REMOVE EXISTING WALL BLOCKING FOR EXISTING PENCIL SHARPENERS, BULLETIN BOARDS ETC. THAT INTERFERE WITH NEW LOCATIONS OR NEW ROOM FINISHES AND WALL TREATMENTS. TYPICAL FOR ALL AREAS.

K. ALL EXISTING BRICK VENEER SCHEDULED FOR DEMOLITION IS TO BE REMOVED WITH CARE, SALVAGED, CLEANED AND STORED FOR RE-USE. (TOOTH-N-BITE MATCHING IN DIFFERENT LOCATIONS).

L. COORDINATE ANY WALL REPAIR/MATCH THAT IS CAUSED BY THE REMOVAL OF EQUIPMENT IN THE "H", "P", "E", AND "T" DWGS. AND PREPARE SURFACE TO RECEIVE NEW FINISHES.

M. NEW SPRINKLER SYSTEM IS PRESENT IN THIS BUILDING; CARE SHOULD BE TAKEN AT ALL TIMES TO NOT DISTURB THIS SYSTEM.

N. CONTRACTOR SHALL BE RESPONSIBLE FOR OBTAINING ALL NECESSARY LOCAL, STATE AND FEDERAL PERMITS. CONTRACTOR IS RESPONSIBLE FOR VERIFYING ALL QUANTITIES AND EXISTING FIELD CONDITIONS, IN ORDER TO COMPLETE NEW WORK.

- D1 REMOVE WIRE GLASS FROM DOOR AND Sidelights/ ASSEMBLIES AND PREPARE FOR IMPACT SAFETY GLASS TO BE INSTALLED.
- D2 REMOVE/EXISTING ACCORDIAN PARTITION ASSEMBLY, TRACK AND ASSOCIATED ACCESSORIES IN ITS ENTIRETY. PATCH AND REPAIR AS NEEDED. PREPARE FOR NEW FINISH.
- D3 REMOVE COUNTERTOP AND SINK IN THE ENTIRETY. COORDINATE WITH NEW ACCESSIBLE DOOR HANDLE ASSEMBLY.
- D4 REMOVE DOOR NOOK KINKBOM FROM DOOR. DOOR TO BE PATCHED & REPAIRED AS NEEDED. PREPARE FOR NEW ACCESSIBLE DOOR HANDLE ASSEMBLY.
- D5 REMOVE EXISTING CARPET FLOORING AND BASE IN ITS ENTIRETY. PREPARE EXISTING CONCRETE SLAB FOR NEW FLOORING.
- D6 REMOVE DOOR, FRAME, AND HINGES IN ITS ENTIRETY. COORDINATE WITH NEW DOOR HANDLE ASSEMBLY.
- D7 REMOVE SUSPENDED CEILING SYSTEMS AND SPOFFS IN ITS ENTIRETY.
- D8 REMOVE CASEWORK ONLY TO EXTENTS IMPACTED BY NEW TOILET ROOM PARTITION WALL. THIS INCLUDES TWO BAYS OF CASEWORK. ADJACENT CASEWORK SHALL REMAIN IN ITS EXISTING CONDITION. NEW TOILET ROOM PARTITION SHALL NOT IMPROVE OPERATION OF CASEWORK TO REMAIN.
- D9 REMOVE STUD PARTITION COMPLETELY UP TO EXISTING DECK OR STRUCTURE ABOVE TO EXTENTS SHOWN ON PLAN. DEMOLITION TO INCLUDE BASE, DOWEL FRAMES GLAZING AND ALL WALL MOUNTED/CEILING/ACCESSORIES, CASEWORK AND EQUIPMENT.
- D10 REMOVE PAIR OF CUBBIES AND STORAGE CASEWORK ABOVE WITH CARE. PROTECT AND STORE FOR REINSTALLATION. COORDINATE WITH PROPOSED FLOOR PLAN.
- D11 REMOVE TALL CABINETS WITH CARE. PROTECT AND STORE FOR REINSTALLATION IN A DIFFERENT LOCATION.
- D12 REMOVE EXISTING CLOSETTERY WINDOW IN ITS ENTIRETY. PREPARE ROOF EDGE AND EXISTING WALL FOR NEW CLOSETTERY WINDOW.
- D13 REMOVE EXTERIOR WALL SYSTEM UNDER CLOSETTERY WINDOW TO EXTENTS SHOWN ON DEMO WALL SECTION (9/14/E-A.02).
- D14 REMOVE NEW OPENING IN MASONRY WALL FOR NEW PASSAGE, DOOR/WINDOW FRAME, BLOCKING, LINTEL OR STEEL COLUMN. REFER TO LINTEL SCHEDULE FOR SIZE AND TYPE. FINISH CUT EDGES OF WOOD PANELING. PTM AS NEEDED.
- D15 REMOVE EXISTING DOOR AND FRAME ASSEMBLY INCLUDING RAILINGS IN ITS ENTIRETY. PREPARE FLOOR AND EDGE OF STAGE FLOOR FOR NEW CHAIR LIFT.
- D16 REMOVE STAGE STAR ASSEMBLY INCLUDING RAILINGS IN ITS ENTIRETY. PREPARE FLOOR AND EDGE OF STAGE FLOOR FOR NEW CHAIR LIFT.
- D17 DISPOSE EXISTING FREE STANDING WOOD STAR.
- D18 REMOVE TOILET ROOM SIGNAGE WITH CARE AND STORE FOR REINSTALLATION.
- D19 REMOVE FIRE EXTINGUISHER WITH CARE AND STORE FOR REINSTALLATION.
- D20 REMOVE AC SYSTEM TO EXTENTS SHOWN IMPACTED BY NEW TOILET ROOM PARTITION WALLS. COORDINATE WITH PROPOSED ROOF PLANS.
- D21 REMOVE DOOR FRAME ASSEMBLY TO BE REMOVED WITH CARE. PROTECT AND STORE IN A SAFE PLACE FOR REINSTALLATION IN A DIFFERENT LOCATION.
- D22 REMOVE MASONRY THRESHOLD WITH CARE. PROTECT AND STORE TO BE REINSTALLED AT NEW TOILET ROOM DOOR.
- D23 REMOVE MARBLE PARTITION COMPLETELY UP TO EXISTING DECK OR STRUCTURE ABOVE TO EXTENTS SHOWN ON PLAN. DEMOLITION TO INCLUDE BASE, DOWEL FRAMES, GLAZING AND ALL WALL MOUNTED/CEILING/ACCESSORIES, CASEWORK AND EQUIPMENT.
- D24 REMOVE AC SYSTEM FROM KITCHEN. REMOVE CEILING TILES WITH CARE AND STORE FOR REINSTALLATION IN NEW GRID. COORDINATE WITH PROPOSED ROOF PLANS.
- D25 REMOVE WALL, TILE FROM PARTITION SCHEDULED TO REMAIN. PREPARE WALL TO RECEIVE NEW FINISHES.
- D26 REMOVE WALL, TILE FROM LINTEL ENTRY TO TOILET ROOM. PREPARE SLAB TO RECEIVE NEW FINISHES.
- D27 REMOVE AC SYSTEM ONLY TO EXTENTS NEEDED FOR NEW TOILET ROOM PARTITIONS. ASSUME 140SF BASE BIL. #LT. #1 ADD 140SF.

AREA C

AREA B

1 FIRST FLOOR DEMOLITION PLAN - AREA C
1/8" = 1'-0"

A key plan of the site showing the layout of buildings A, B, C, and D. Building C is a large rectangular structure on the left, shaded with diagonal lines. Building B is a rectangular structure below building C. Building A is a rectangular structure to the right of building B. Building D is a rectangular structure above building A. A north arrow is located to the right of building D, pointing towards the top right. The plan is labeled 'KEY PLAN' at the bottom.


SED #:ERWIN VALLEY 57-10-00-01-0-009-027; ADMIN BUILDING 57-10-00-01-1-001-013

FIRST FLOOR DEMOLITION PLAN - AREA C
2025 ERWIN VALLEY ELEM & ADMIN BUILDING ALTERATIONS
CORNING-PAINTED POST ASD

HUNT
ENGINEERS | ARCHITECTS | SURVEYORS
ALBANY, NY • BINGHAMTON, NY • HORSEHEADS, NY • ROCHESTER, NY
TOWANDA, PA • WILLIAMSPORT, PA

EV-A0.3

PROJECT NO: 2649-160

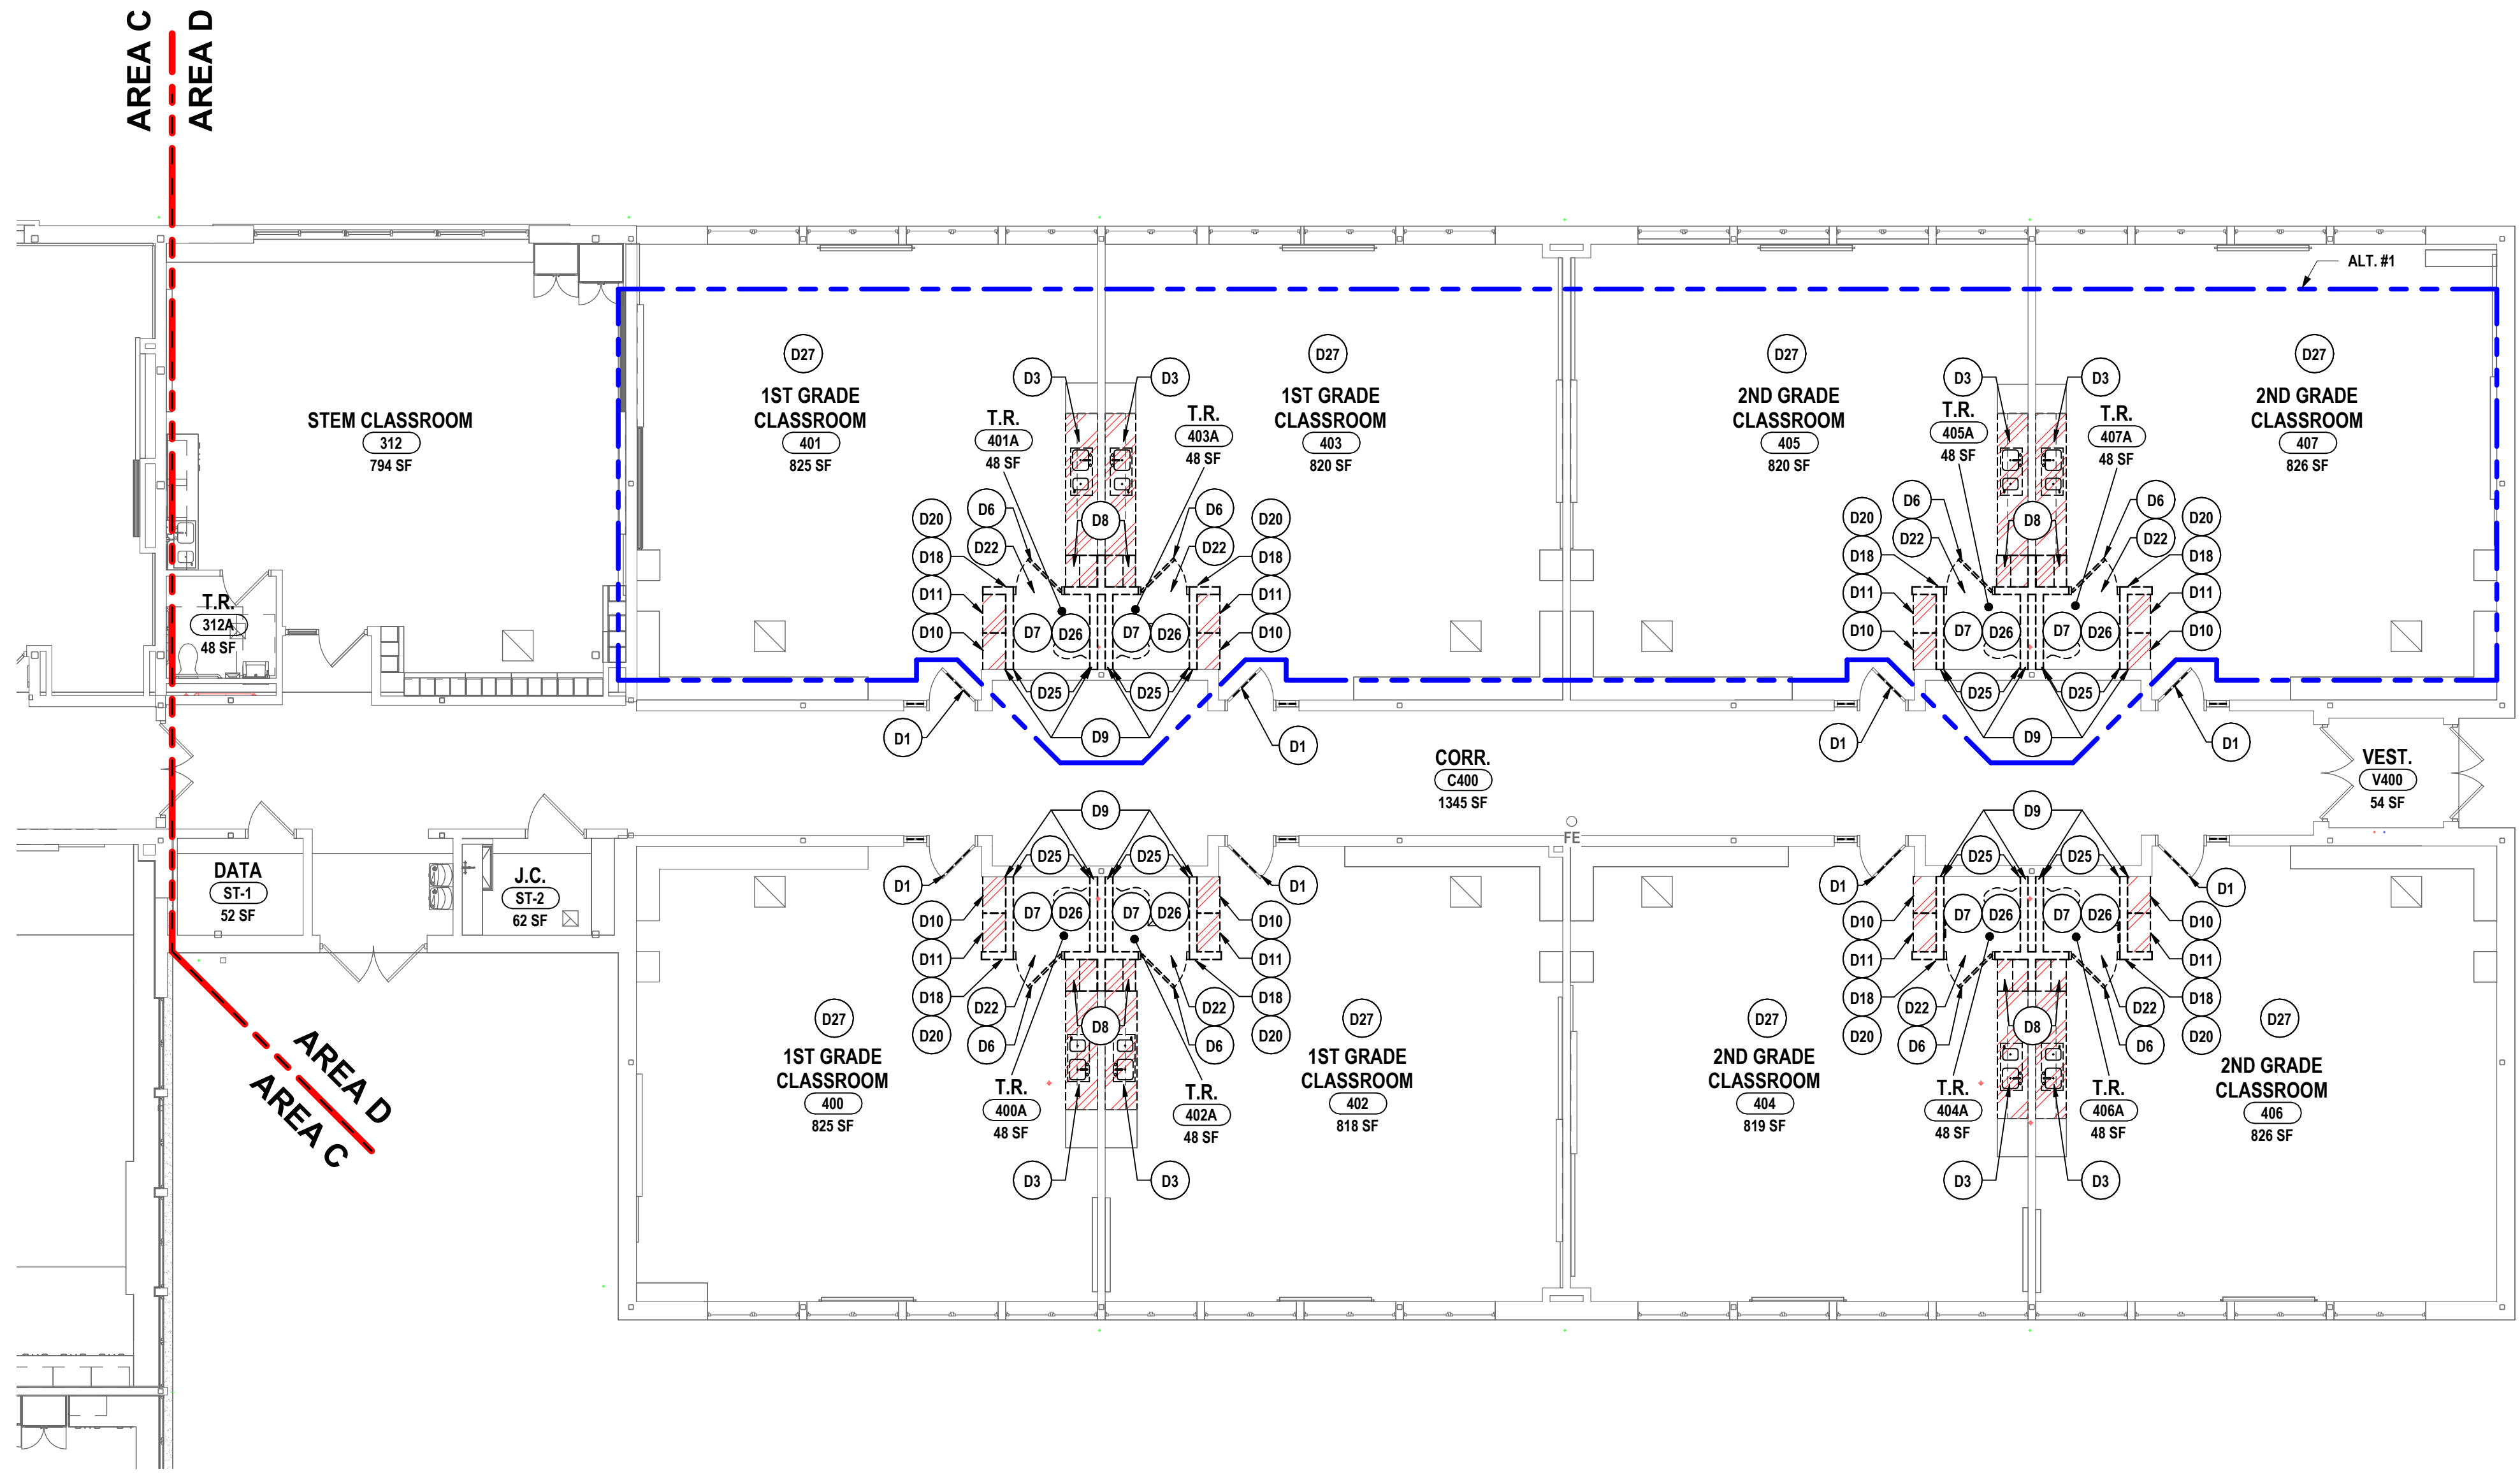


1 FIRST FLOOR DEMOLITION PLAN - AREA D
1/8" = 1'-0"

GENERAL DEMO NOTES:

- A ASBESTOS ABATEMENT IS BEING PERFORMED. ASBESTOS CONTAINING MATERIALS ARE PRESENT IN THE EXISTING BUILDING. REFER TO SPECIFICATIONS FOR LOCATIONS AND SCHEDULE. THE OWNER HAS REPORTS IDENTIFYING ACM MATERIALS AND WILL HAVE THESE AVAILABLE FOR CONTRACTORS REFERENCE. IF SUSPECT MATERIAL NOT SCHEDULED IS ENCOUNTERED, STOP WORK IMMEDIATELY. DO NOT DISTURB THE MATERIAL AND NOTIFY THE OWNER'S REPRESENTATIVES.
- B MAINTAIN EXISTING STRUCTURAL SYSTEMS AT ALL TIMES. PROVIDE TEMPORARY SHORING AND BRACING AT LOCATIONS WHERE THE EXISTING STRUCTURE IS BEING MODIFIED. PROTECT THE EXISTING STRUCTURE SCHEDULED TO REMAIN, FROM DAMAGE DURING DEMOLITION. MAINTAIN SHORING AND BRACING UNTIL THE NEW STRUCTURE IS INSTALLED AND READY TO ACCEPT LOADS.
- C CONTRACTOR TO PROVIDE PROTECTIVE BARRIER AT ALL AREAS OF DEMOLITION. KEEP ALL EXITS FREE AND CLEAR AT ALL TIMES DURING SCHOOL OPERATIONS.
- D THE OWNER RESERVES THE RIGHT TO RETAIN ANY REMOVED ITEMS AFTER CONTRACTOR REMOVAL. THE CONTRACTOR SHALL REMOVE FROM THE SITE AND DISPOSE OF ALL REMOVED ITEMS THE OWNER DOES NOT WISH TO RETAIN.
- E FLOOR CONC. AND GRINDING OF SUBSTRATES OF DIFFERENT HEIGHTS IN THE SAME AREA IS REQUIRED AT WALL REMOVALS AND NEW DOORS IN EXG. WALLS TO ALLOW THE NEW FINISHES TO ALIGN BETWEEN ADJACENT ROOMS AND ADJACENT ROOMS THAT BECOME ONE ROOM.
- F PATCH, REPAIR, PAINT OR RE-FINISH EXG. CONSTRUCTION MATERIALS AND FINISHES DAMAGED DURING DEMOLITION OR NEW CONSTRUCTION.
- G CONTRACTOR TO COORDINATE THE WORK OF THIS CONTRACT WITH THE WORK OF OTHER TRADES.
- H DIMENSIONS SHOWN FOR ALL NEW OPENINGS IN EXISTING CONSTRUCTION SHOULD BE COORDINATED WITH THE NEW PLANS AND EXISTING CONDITIONS IN THE FIELD.
- I ROOM NUMBERS INDICATED ARE EXISTING BUILDING NUMBERS. REFER TO NEW FLOOR PLANS (A-1 DRAWING SERIES FOR NEW ROOM NUMBERING).
- J REMOVE EXISTING WOOD BLOCKING FOR EXISTING PENCIL SHARPENERS, BULLETIN BOARDS ETC. THAT INTERFERE WITH NEW LOCATIONS OR NEW ROOM FINISHES AND WALL TREATMENTS. TYPICAL FOR ALL AREAS.
- K ALL EXISTING BRICK VENEER SCHEDULED FOR DEMOLITION IS TO BE REMOVED WITH CARE, SALVAGED, CLEANED AND STORED FOR RE-USE (TOOTH-IN PATCHING) IN DIFFERENT LOCATIONS OF THE EXISTING BUILDING.
- L COORDINATE ANY WALL REPAIR/FILL THAT IS CAUSED BY THE REMOVAL OF EQUIPMENT IN THE "H", "P", "E", "I" AND "T" DWGS. AND PREPARE SURFACE TO RECEIVE NEW FINISHES.
- M WET SPRINKLER SYSTEM IS PRESENT IN THIS BUILDING; CARE SHOULD BE TAKEN AT ALL TIMES TO NOT DISTURB THIS SYSTEM
- N ITEMS SHOWN ARE INTENDED TO GIVE APPROXIMATE QUANTITY, LOCATION AND TYPE. CONTRACTOR IS RESPONSIBLE FOR VERIFYING ACTUAL QUANTITIES AND EXISTING FIELD CONDITIONS, IN ORDER TO COMPLETE NEW WORK.

DEMOLITION NOTES:

- D1 REMOVE WIRE GLASS FROM DOOR AND SIDELIGHT ASSEMBLIES AND PREPARE FOR IMPACT SAFETY GLASS TO BE INSTALLED.
- D2 REMOVE EXISTING ACCORDIAN PATRITION ASSEMBLY, TRACK AND ASSOCIATED ACCESSORIES IN ITS ENTIRETY. PATCH AND REPAIR AS NEEDED.
- D3 PREPARE FOR NEW FINISH
- D4 REMOVE COUNTERTOP AND SINK IN THE ENTIRETY.
- D5 REMOVE DOOR KNOB ASSEMBLY FROM DOOR. DOOR TO BE PATCHED & REPAIRED AS NEEDED. PREPARE FOR NEW ACCESSIBLE DOOR HANDLE ASSEMBLY.
- D6 REMOVE EXISTING CARPET FLOORING AND BASE IN ITS ENTIRETY. PREPARE EXISTING CONCRETE SLAB FOR NEW FLOORING.
- D7 REMOVE DOOR, FRAME, AND HARDWARE IN ITS ENTIRETY TO EXTENTS SHOWN ON PLAN.
- D8 REMOVE SUSPENDED CEILING SYSTEMS AND SOFFITS IN ITS ENTIRETY.
- D9 REMOVE CASEWORK ONLY TO EXTENTS IMPACTED BY NEW TOILET ROOM PARTITION WALL. THIS INCLUDES TWO BAYS OF CASEWORK. ADJACENT CASEWORK SHALL REMAIN IN ITS EXISTING CONDITION. NEW TOILET ROOM PARTITION WALL NOT IMPEDE OPERATION OF CASEWORK TO REMAIN.
- D10 REMOVE STUD PARTITION COMPLETELY UP TO EXISTING DECK OR STRUCTURE ABOVE TO EXTENTS SHOWN ON PLAN. DEMOLITION TO INCLUDE BASE, DOORS, FRAMES GLAZING AND ALL WALL MOUNTED/RECESSED ACCESSORIES, CASEWORK AND EQUIPMENT.
- D11 REMOVE PAIR OF CUBBIES AND STORAGE CASEWORK ABOVE WITH CARE. PROTECT AND STORE FOR REINSTALLATION. COORDINATE WITH PROPOSED FLOOR PLAN.
- D12 REMOVE TALL CABINET WITH CARE. PROTECT AND STORE FOR REINSTALLATION IN A DIFFERENT LOCATION.
- D13 REMOVE EXISTING CLERESTORY WINDOW IN ITS ENTIRETY. PREPARE ROOF EDGE AND EXISTING WALL FOR NEW CLERESTORY WINDOW.
- D14 REMOVE EXTERIOR WALL SYSTEM UNDER CLERESTORY WINDOW TO EXTENTS SHOWN ON DEMO WALL SECTION (3EV-A.02).
- D15 PROVIDE NEW OPENING IN MASONRY WALL FOR NEW PASSAGE. DOOR/WINDOW FRAME, BLOCKING, LINTEL OR STEEL COLUMN. REFER TO LINTEL SCHEDULE FOR SIZE AND TYPE. FINISH CUT EDGES OF WOOD PANELING, PTM AS NEEDED. PREPARE FOR NEW CHAIR LIFT.
- D16 PORTION OF STAGE FLOOR IS ABATED TO EXTENTS SHOWN. FINISH CUT EDGES OF WOOD FLOOR, PTM AS NEEDED. PREPARE FOR NEW CHAIR LIFT.
- D17 REMOVE STAGE STAIR ASSEMBLY INCLUDING RAILINGS IN ITS ENTIRETY. PREPARE FLOOR AND EDGE OF STAGE FLOOR FOR NEW CHAIR LIFT.
- D18 DISPOSE EXISTING FREE STANDING WOOD STAIR.
- D19 REMOVE TOILET ROOM SIGNAGE WITH CARE AND STORE FOR REINSTALLATION.
- D20 REMOVE FIRE EXTINGUISHER WITH CARE AND STORE FOR REINSTALLATION.
- D21 REMOVE ACT SYSTEM TO EXTENTS SHOWN IMPACTED BY NEW PARTITION WALLS. COORDINATE WITH PROPOSED RCP PLANS.
- D22 DOOR AND FRAME ASSEMBLY TO BE REMOVED WITH CARE. PROTECT AND STORE IN A SAFE PLACE FOR REINSTALLATION IN A DIFFERENT LOCATION.
- D23 REMOVE MARBLE THRESHOLD WITH CARE. PROTECT AND STORE TO BE REINSTALLED AT NEW TOILET ROOM DOOR.
- D24 REMOVE MASONRY PARTITION COMPLETELY UP TO EXISTING DECK OR STRUCTURE ABOVE TO EXTENTS SHOWN ON PLAN. DEMOLITION TO INCLUDE BASE, DOORS, FRAMES, GLAZING AND WALL MOUNTED/RECESSED ACCESSORIES, CASEWORK AND EQUIPMENT.
- D25 REMOVE ACT SYSTEM FROM KITCHEN. REMOVE CEILING TILES WITH CARE AND STORE FOR REINSTALLATION IN NEW GRID. COORDINATE WITH PROPOSED RCP PLANS.
- D26 REMOVE WALL TILE FROM PARTITION SCHEDULED TO REMAIN. PREPARE WALL TO RECEIVE NEW FINISHES.
- D27 REMOVE FLOOR TILE IN ENTIRETY OF TOILET ROOM. PREPARE SLAB TO RECEIVE NEW FINISHES.
- D28 REMOVE ACT SYSTEM ONLY TO EXTENTS NEEDED FOR NEW TOILET ROOM PARTITIONS. ASSUME 140SF BASE BID; ALT. #1 ADD 140SF.

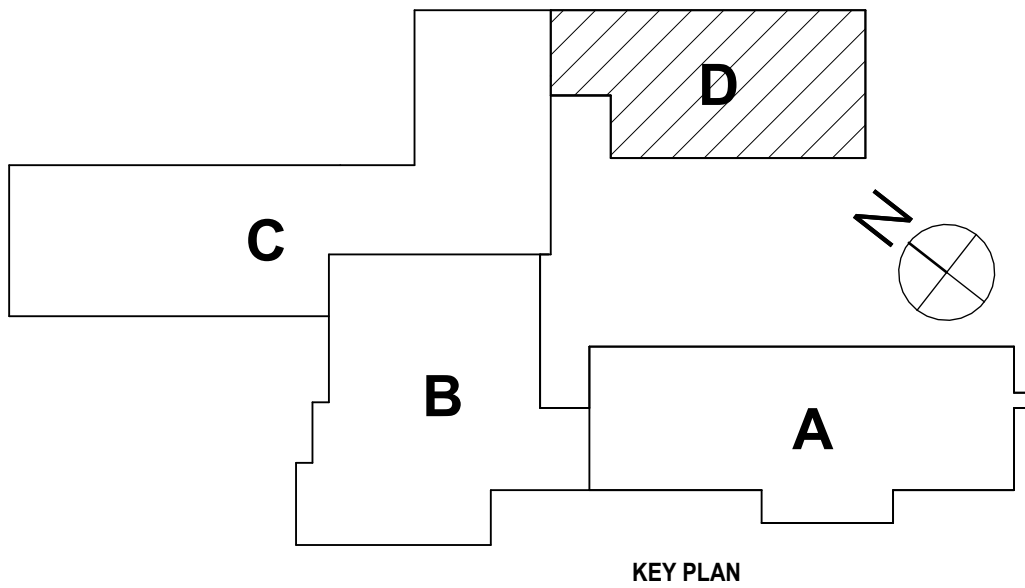

SED #ERWIN VALLEY 15-10-004-1-004-027; DOWN BUILDING 15-10-004-1-101-013

FIRST FLOOR DEMOLITION PLAN - AREA D

2025 ERWIN VALLEY ELEM & ADMIN BUILDING ALTERATIONS

CORNING-PAINTED POST ASD

16 BEARTOWN ROAD, PAINTED POST NY 14870

HUNT ENGINEERS | ARCHITECTS | SURVEYORS

ALBANY, NY - BINGHAMTON, NY - HORSESHOE FALLS, NY - ROCHESTER, NY

WWW.HUNT-EAS.COM 887-358-1000

NY CERTIFICATE NO. 0101620 PA CERTIFICATE NO. TSC220313464-1


EV-A0.4

PROJECT NO: 2649-160


DRAWN BY:		CAM
CHECKED BY:		SZ
DATE:		03/17/2026
PHASE:		CD
REVISION:		ISSUE FOR BID
#	DATE:	1 10/22/2026

"IT IS A VIOLATION OF THE LAW FOR ANY PERSON TO MAKE UNAUTHORIZED ALTERATIONS TO PLANS BEARING A LICENCED ENGINEER'S

IT IS A VIOLATION OF THE LAW FOR ANY PERSON TO MAKE UNAUTHORIZED ALTERATIONS OR ADDITIONS TO PLANS BEARING A LICENSED ENGINEER'S ARCHITECT'S OR SURVEYOR'S SEAL.

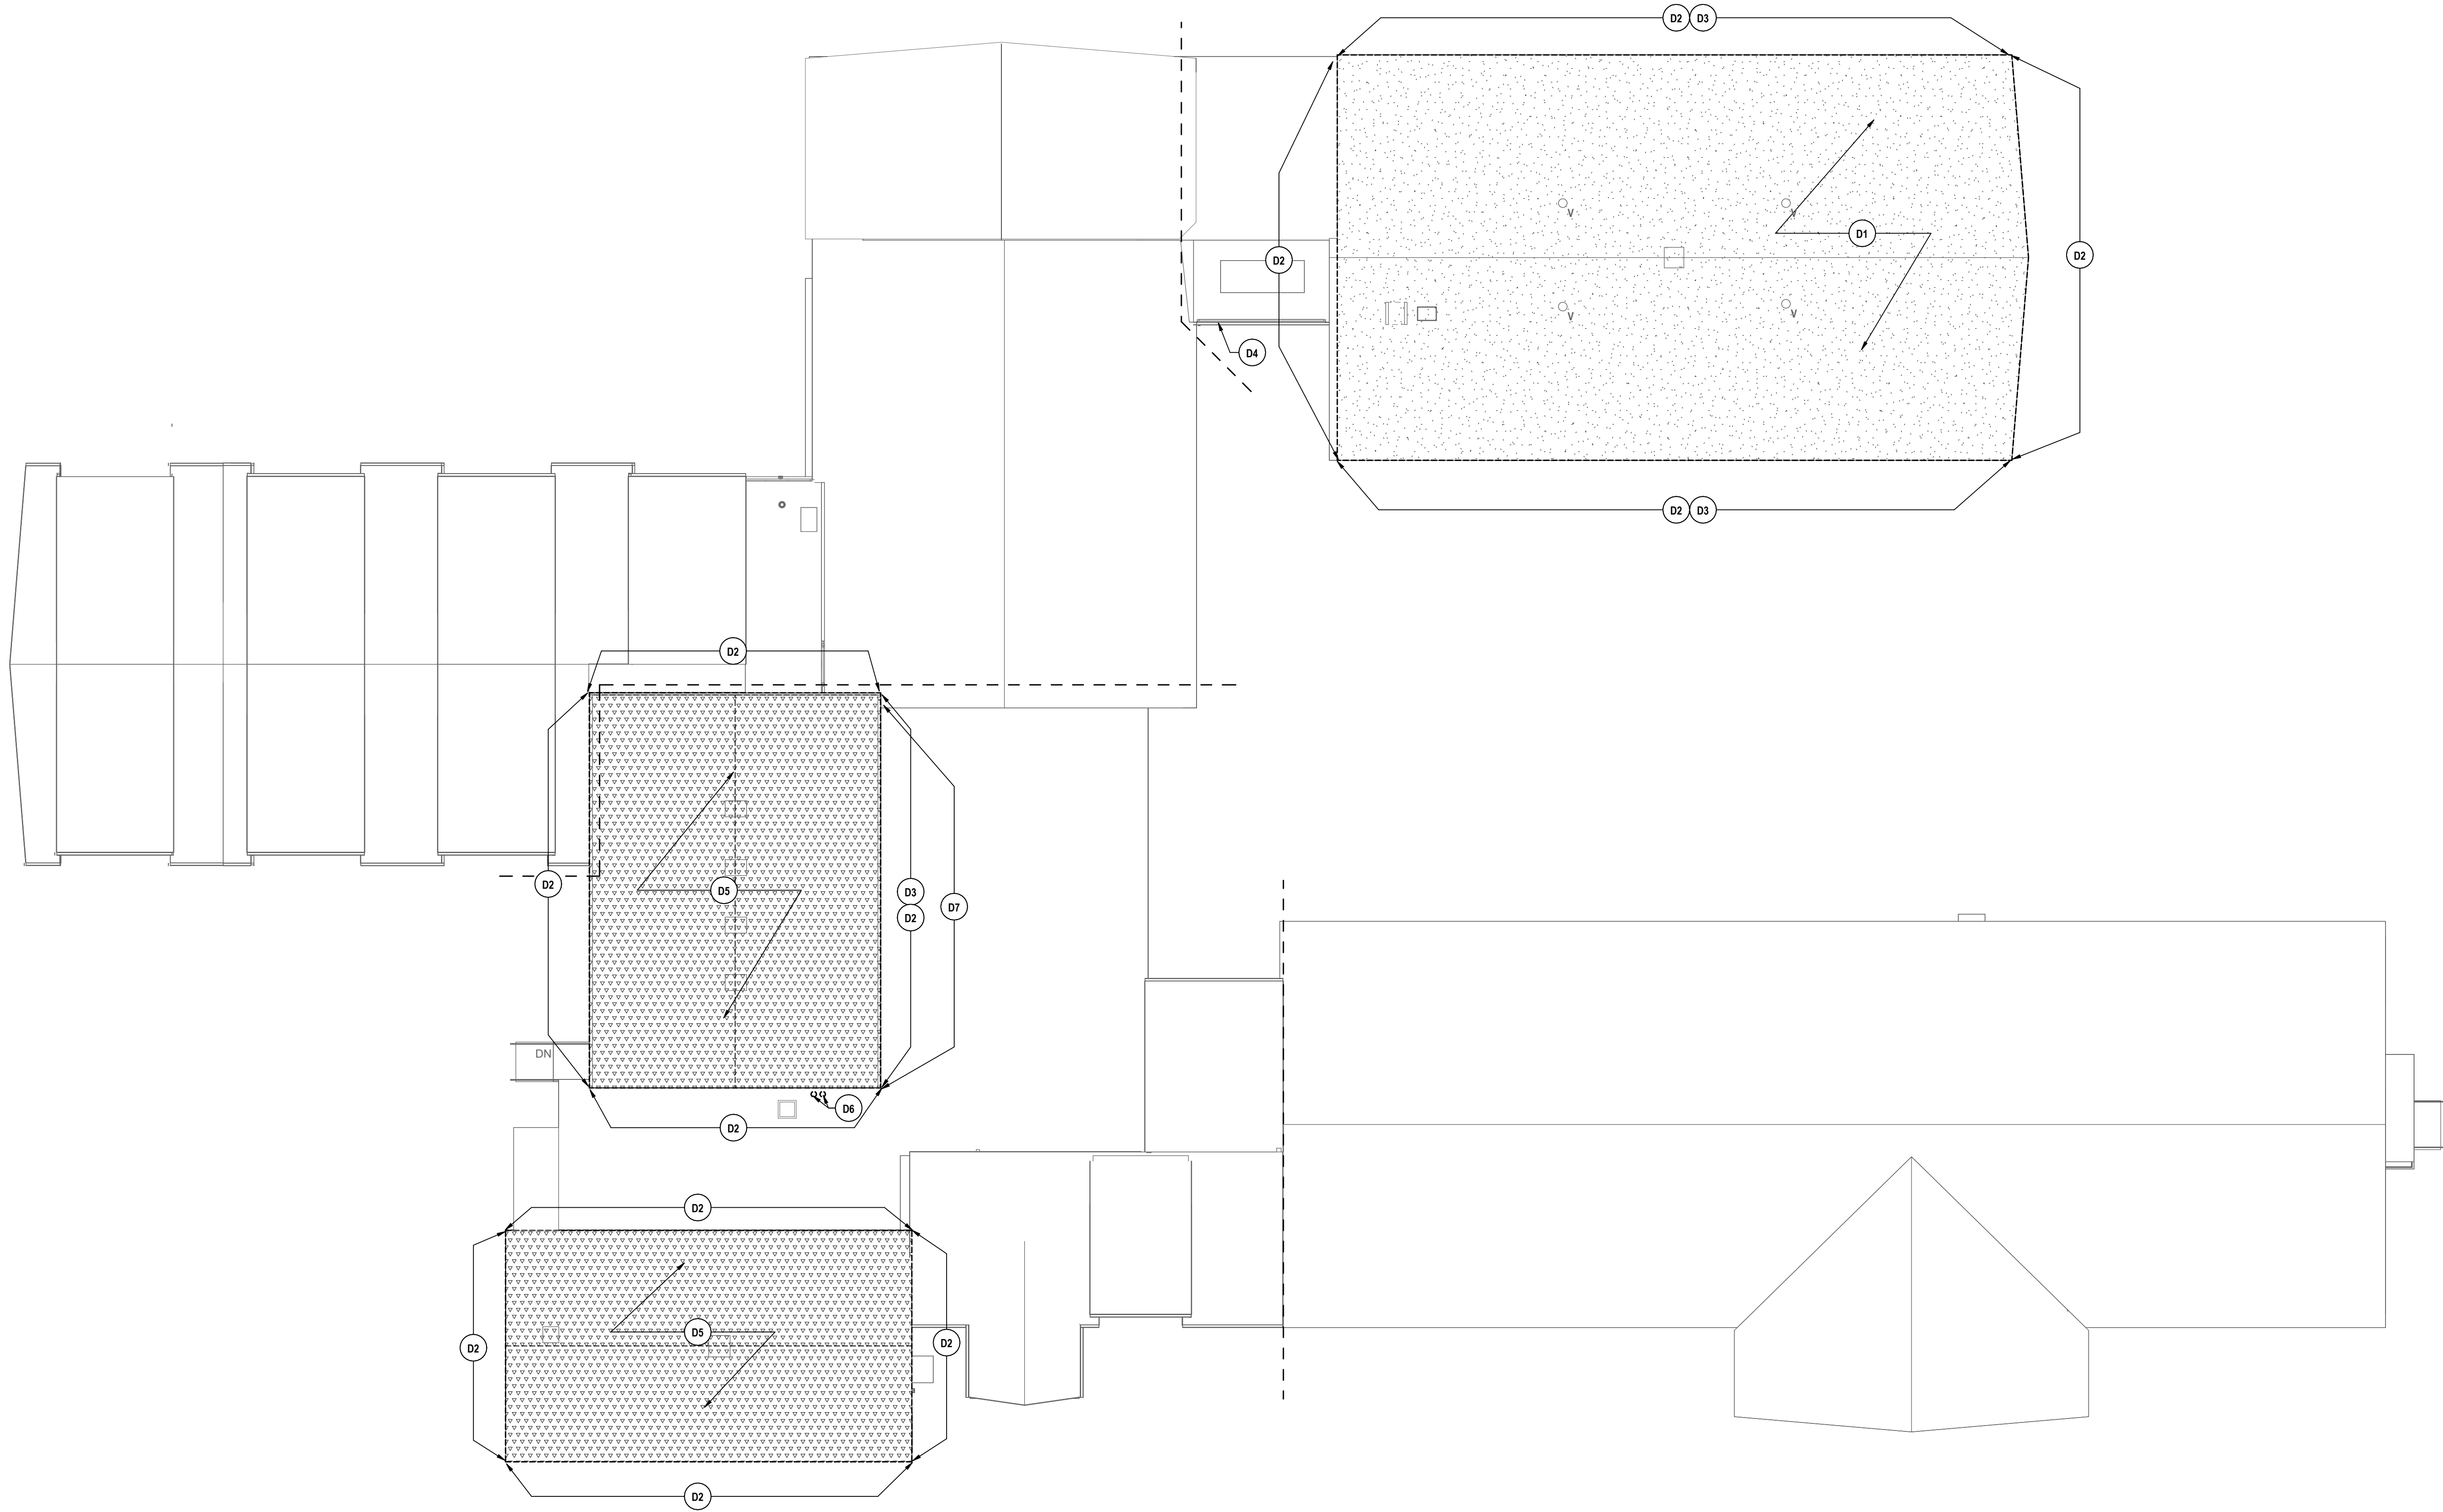

1 ROOF DEMOLITION PLAN
1/16" = 1'-0"

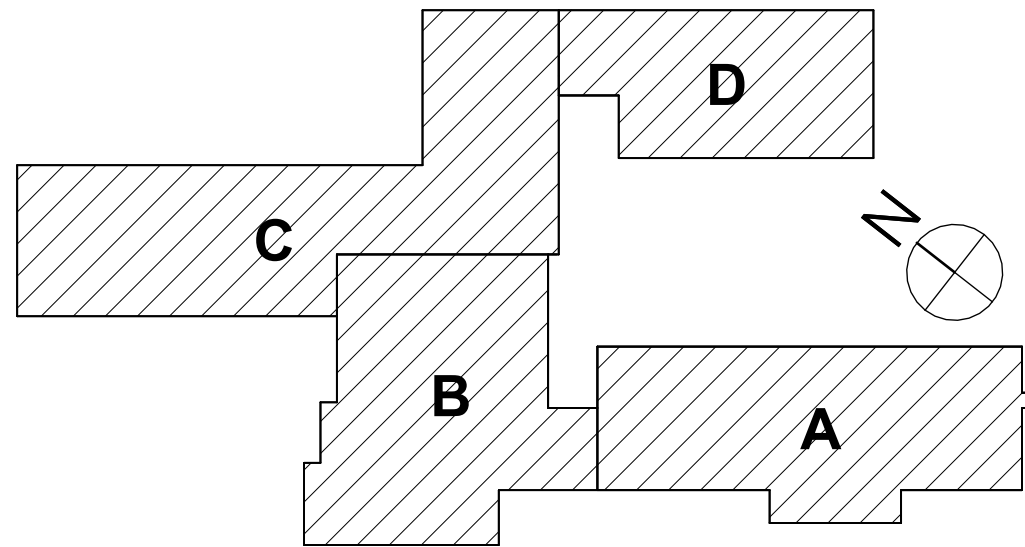

KEY PLAN

GENERAL ROOF NOTES:

- A REFER TO DRAWING EV-A0.1 FOR GENERAL DEMOLITION NOTES.
- B BY ALTERNATE #5. ALL MECHANICAL EQUIPMENT IS TO BE REMOVED BY THE HVAC CONTRACTOR. ALL ROOFTOP MECHANICAL EQUIPMENT SHALL BE TESTED PRIOR TO REMOVAL IN THE PRESENCE OF THE OWNER'S REPRESENTATIVE. FOLLOWING REINSTALLATION, EQUIPMENT WILL AGAIN BE TESTED IN THE PRESENCE OF THE OWNER'S REPRESENTATIVE.
- C ALL WORK, ON OR NEAR EXISTING ROOFING SCHEDULED TO REMAIN IN PLACE, SHALL BE REFORMED IN SUCH A MANNER TO MAINTAIN ALL EXISTING WARRANTIES.
- D THE CONTRACTOR SHALL INSTALL AND MAINTAIN TEMPORARY ROOFING TO ENSURE WEATHER TIGHT CONDITIONS UNTIL SUCH TIME THE PERMANENT ROOFING SYSTEM IS INSTALLED.
- E AN ACCEPTABLE INSULATION SHOP DRAWING SUBMISSION IS REQUIRED TO IDENTIFY INSULATION LAYOUT, DRAINAGE PATTERN, SLOPE AND "R" VALUE.
- F THE CONTRACTOR SHALL PROVIDE AND INSTALL ALL MATERIALS TO MAKE SMOOTH TRANSITIONS AT ROOF EDGES AND INTERSECTIONS.
- G REFER TO HIE-DRAWINGS FOR WORK BY HVAC AND ELECTRICAL CONTRACTORS ASSOCIATED WITH EXISTING EQUIPMENT REMOVALS AND RE-INSTALLATIONS.
- H IF EXISTING ROOF DECK OR STRUCTURAL SYSTEM DAMAGE IS SUSPECTED, NOTIFY THE OWNER'S REPRESENTATIVE IMMEDIATELY.

DEMOLITION NOTES:

- D1 BY ALTERNATE #4. SECTION OF EXISTING ADHERED PVC ROOF MEMBRANE & COVER BOARD TO BE REMOVED. PREP TO RECEIVE NEW ROOF ASSEMBLY. COORDINATE WITH NEW ROOF PLAN.
- D2 REMOVE EXISTING ROOF EDGE INCLUDING BUT NOT LIMITED TO GRAVEL STOP, FASCIA, SUB FACIA. REFER TO EXTENT OF NEW WORK; PREPARE FOR NEW ROOFING. TIE-IN AS REQUIRED.
- D3 REMOVE GUTTERS AND DOWNSPOUTS WITH CARE AND STORE FOR REINSTALLATION.
- D4 EXISTING EQUIPMENT SCREEN TO REMAIN. PROTECT IN PLACE.
- D5 BY ALTERNATE #4. EXG ROOFING SYSTEM TO BE REMOVED IN ITS ENTIRETY DOWN TO EXISTING GYPSUM DECK TO REMAIN. COORDINATE EXTENTS WITH NEW ROOFING.
- D6 PATCH ROOF WHERE EXISTING VENTS ARE REMOVED.
- D7 MEMBRANE FLASHING AND PORTION OF ROOF MEMBRANE BELOW TO BE DEMOED TO ALLOW FOR NEW EXTERIOR WALL CONSTRUCTION. TIE IN NEW MEMBRANE FLASHING UP THE NEW EXTERIOR WALL WITH EXISTING ROOF MEMBRANE.

SED #ERWIN VALLEY 15-10-00-01-0-00-027 ADMIN BUILDING 15-10-00-01-1-001-013

ROOF DEMOLITION PLAN

2025 ERWIN VALLEY ELEM & ADMIN BUILDING ALTERATIONS
CORNING-PAINTED POST ASD

16 BEARTOWN ROAD, PAINTED POST NY 14870

EV-A0.5

PROJECT NO: 2649-160

HUNT ENGINEERS | ARCHITECTS | SURVEYORS

ALBANY, NY - BINGHAMTON, NY - HORSESHOE FALLS, NY - ROCHESTER, NY
ALBANY, NY - BINGHAMTON, NY - HORSESHOE FALLS, NY - ROCHESTER, NY
WWW.HUNT-EAS.COM 807-358-1000


NY CERTIFICATE NO. 0016320 PA CERTIFICATE NO. TSC220313464-1

#	DATE:	1/10/2026	REVISION:	ISSUE FOR BID
1	DATE:	1/10/2026	REVISION:	ISSUE FOR BID


DRAWN BY:	CAM
CHECKED BY:	SZ
DATE:	03/17/2026
PHASE:	CD

Copyright 2025

"IT IS A VIOLATION OF THE LAW FOR ANY PERSON TO MAKE UNAUTHORIZED ALTERATIONS OR MODIFICATIONS TO PLANS BEARING A LICENSED ENGINEER'S ARCHITECT'S OR SURVEYOR'S SEAL."

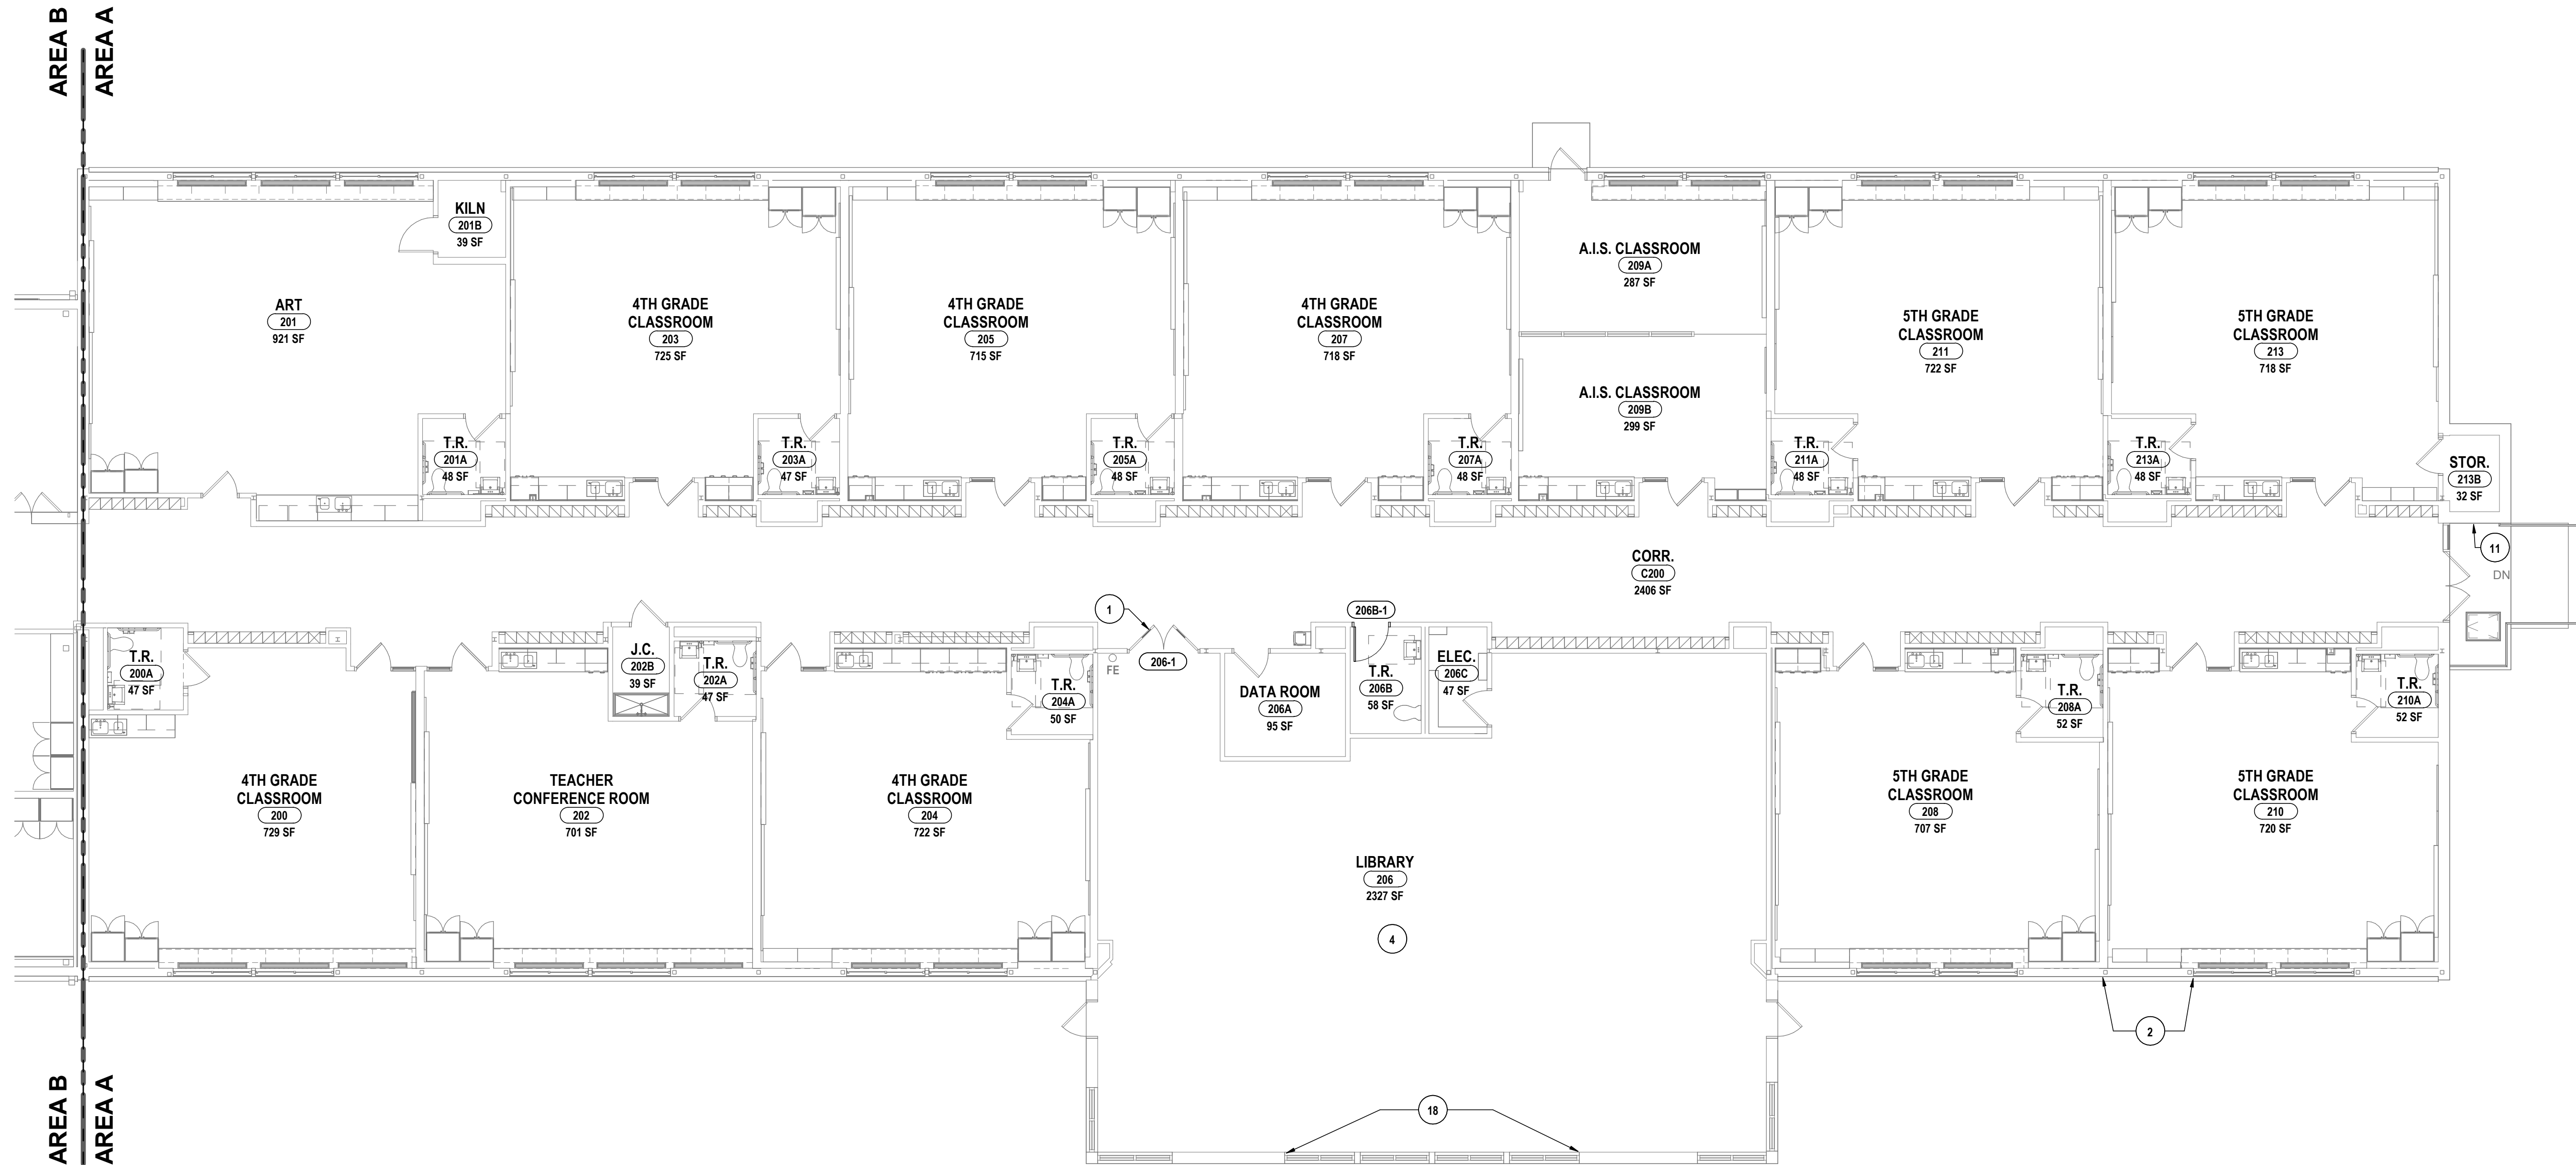

1 FIRST FLOOR PLAN - AREA A
1/8" = 1'-0"

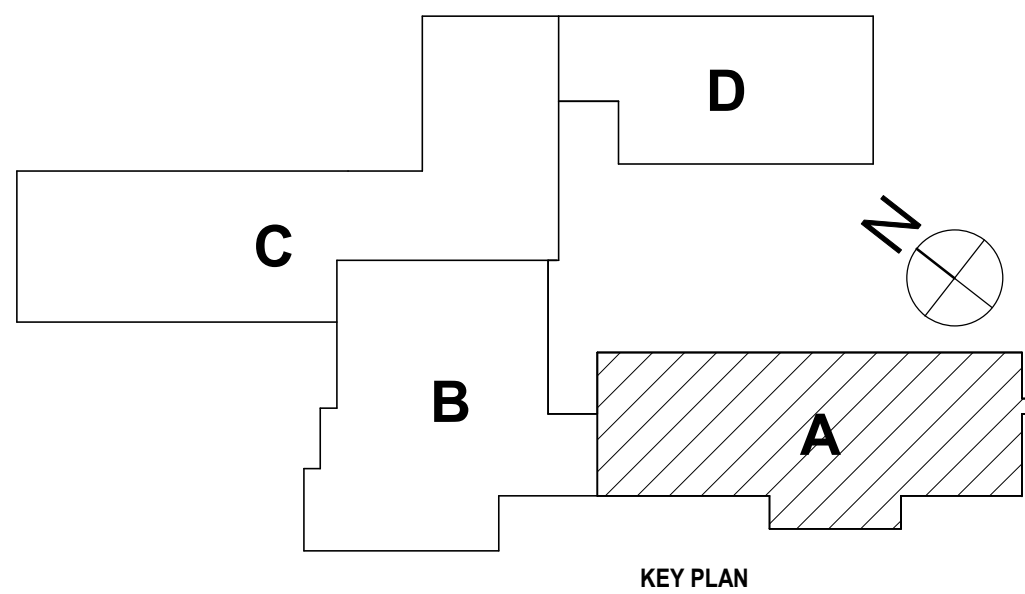

GENERAL NOTES:

- A EXTEND ALL NEW PARTITIONS TO DECK ABOVE UNLESS NOTED OTHERWISE. INSTALL FIRE STOPPING AT DECK FLUTES IN AREAS OF METAL DECKING WHERE FIRE SEPARATION IS REQUIRED.
- B ALL PENETRATIONS THROUGH FIRE RATED PARTITIONS TO BE SEALED W/ APPROVED U.L. FIRE RATED ASSEMBLIES.
- C FILL ALL VOIDS AND IMPERFECTIONS IN WALLS AND FLOORS CREATED BY DEMOLITION. PATCH TO MATCH EXISTING & PREPARE TO RECEIVE NEW FINISHES.
- D ALL NEW DOOR FRAMES INSTALLED IN METAL STUD OR MASONRY PARTITIONS SHALL BE MOUNTED 4" FROM ADJACENT WALLS (6" TO DOOR), UNLESS NOTED OTHERWISE.
- E INSTALL SOLID WOOD BLOCKING IN METAL STUD WALLS AT ALL AREAS OF CASEWORK, TACK/MARKER BOARDS, TOILET ACCESSORIES AND ALL WALL MOUNTED EQUIPMENT AND ACCESSORIES.
- F ALL NEW WALLS TO BE TYPE 1A UNLESS NOTED OTHERWISE.
- G ALL NEW DOORS TO BE WOOD WITH HOLLOW METAL FRAME UNLESS NOTED OTHERWISE.
- H ALL EXISTING BRICK VENEER SCHEDULED FOR DEMOLITION IS TO BE REMOVED WITH CARE, SALVAGED, CLEANED AND STORED FOR RE-USE (TOOTH-N-PATCHING) IN DIFFERENT LOCATIONS OF THE EXISTING BUILDING.
- I ITEMS SHOWN ARE INTENDED TO GIVE APPROXIMATE QUANTITY, LOCATION & TYPE. THE CONTRACTOR IS RESPONSIBLE FOR VERIFYING ACTUAL QUANTITY & EXISTING FIELD CONDITIONS.
- J VERIFY WITH OWNER EXACT SIZE OF ALL EQUIPMENT FURNISHED BY OWNER FOR PROPER FIT WITH CONTRACTOR SUPPLIED CASEWORK AND MILWORK.
- K ALL DIMENSIONS ARE TAKEN FROM FACE OF WALL TO FACE OF WALL, UNLESS NOTED OTHERWISE.
- L THERE SHALL BE A MINIMUM OF 1'-4" CLEAR FLOOR SPACE ON THE PULL SIDE OF ALL NEW DOORS; THERE SHALL BE A MINIMUM OF 1'-4" CLEAR FLOOR SPACE ON THE PUSH SIDE OF ALL NEW DOORS.
- M THE WHEELCHAIR SYMBOL INDICATES HANDICAP ACCESSIBLE MOUNTED FIXTURE ELEVATION AND SHALL CONFORM WITH CABO/ANSI A117.1 AND ADAAG.
- N WET SPRINKLER SYSTEM IS PRESENT IN THIS BUILDING; CARE SHOULD BE TAKEN AT ALL TIMES TO NOT DISTURB THIS SYSTEM.

PLAN DRAWING NOTES:

1. INSTALL FIRE RATED IMPACT SAFETY GLASS IN EXISTING DOOR ASSEMBLY.
2. REMOVE LOOSE CONCRETE AND OLD PATCHING MATERIAL. REPAIR WITH A CONCRETE PATCH SUCH AS SIKA REPAIR 223, PROVIDE PARGE COAT AND PAINT TO MATCH EXISTING ADJACENT.
3. REPLACE DOOR KNOBS IN EXISTING DOORS WITH ACCESSIBLE LEVER STYLE DOOR HANDLES.
4. PROVIDE NEW CARPET THROUGHOUT ENTIRE LIBRARY.
5. RAKE OUT DETRORATING WINDOW SILL/JOINT MATERIAL. REPOINT AND CAULK.
6. SAND AND REPAINT BASEMENT STAIR IN ITS ENTIRETY.
7. INFILL EXISTING DOOR, WINDOW, OR WALL OPENING AS SHOWN ON PLAN TO MATCH EXISTING WALL THICKNESS AND PREPARE FOR NEW FINISHES.
8. PROVIDE NEW COUNTERTOP AND SINK IN EXACT LOCATIONS, DIMENSIONS, AND QUANTITIES.
9. REINSTALL STORED PAIR OF CUBBIES IN LOCATIONS SHOWN ON PLANS.
10. REINSTALL STORED TALL CABINET IN LOCATIONS SHOWN ON PLANS.
11. PATCH EXISTING WALL OPENING WHERE CONDUITS WERE REMOVED.
12. PROVIDE PREFABRICATED METAL STAIR TO CRAWL SPACE DOOR IN PLACE OF EXISTING WOOD STAIR. REF. SPECS.
13. REFINISH WOOD STAGE FLOOR AND WOOD STAGE STAIR IN THEIR ENTIRETY.
14. REINSTALL STORED TOILET ROOM SIGNAGE.
15. REINSTALL STORED FIRE EXTINGUISHER.
16. PROVIDE TWO ROWS OF NEW TACK STRIPS, TKS-1 ON CORRIDOR WALL TO EXTENTS SHOWN @ 6'-0" A.F.F. AND @ 7'-6" A.F.F.
17. PROVIDE NEW CHAIR LIFT. B.O.D. GARAVENTA LIFT - GENESIS OPAL STANDARD. REF. SPECS.
18. PROVIDE WINDOW SHADES FOR THE STRAIGHT BOTTOM SASHES OF THE WINDOW. FAN SHAPED TOP SASHES DO NOT NEED WINDOW SHADES.
19. REINSTALL STORED DOOR AND FRAME ASSEMBLY IN NEW LOCATION AS SHOWN.
20. PROVIDE NEW GUARDRAIL MOUNTED TO THE NEW EDGE OF THE STAGE FLOOR TO EXTENTS SHOWN.
21. NEW END PANEL FOR MOVED CABINET. MATERIAL AND COLOR TO MATCH EXISTING.
22. MOVE END BAY OF CUBBIES WITH FINISHED END PANEL SO IT CAN REMAIN AT THE END. RELOCATED CUBBIES TO BE INSTALLED NEXT TO IT.

SED #ERWIN VALLEY 5710-0001-0-000-027; ADMIN BUILDING 5710-0001-001-001

FIRST FLOOR PLAN - AREA A
2025 ERWIN VALLEY ELEM & ADMIN BUILDING ALTERATIONS
CORNING-PAINTED POST ASD
16 BEARTOWN ROAD, PAINTED POST, NY 14870

EV-A1.1

PROJECT NO: 2649-160


HUNT ENGINEERS | ARCHITECTS | SURVEYORS
ALBANY, NY - BINGHAMTON, NY - HORSESHOE FALLS, NY - ROCHESTER, NY
WWW.HUNT-EAS.COM 807-358-1000
NY CERTIFICATE NO. 0016220 PA CERTIFICATE NO. TSC22020313464-1

DRAWN BY:	CAM
CHECKED BY:	SZ
DATE:	03/17/2026
PHASE:	CD
REVISION:	ISSUE FOR BID
#	DATE:
1	10/22/2025


"IT IS A VIOLATION OF THE LAW FOR ANY PERSON TO MAKE UNAUTHORIZED ALTERATIONS OR ADDITIONS TO PLANS BEARING A LICENSED ENGINEER, ARCHITECT'S OR SURVEYOR'S SEAL."

LOOSE LINTEL SCHEDULE		
WALL THICKNESS	MASONRY OPENING	
	UP TO 4'-0" 4" BEARING EACH END	4'-0" TO 8'-0" 8" BEARING EACH END
4"	L L3 1/2 x 3 1/2 x 5/16	L L5 x 3 1/2 x 5/16 (LLV)
6"	± WT 4 x 9	± WT 7 x 11
8"	± (2) L4 x 3 1/2 x 5/16 (LLV)	± (2) 5 x 3 1/2 x 5/16 (LLV)
10"	± (2) L4 x 3 1/2 x 5/16 (LLV) WITH 8" x 5/16" PLATE	± (2) 5 x 3 1/2 x 5/16 (LLV) 8" x 5/16" PLATE
12"	± (2) L5 x 3 1/2 x 5/16 (LLV) WITH 11" x 5/16" PLATE	± (2) 5 x 5 x 5/16 WITH 11" x 5/16" PLATE
14"	± (3) L4 x 3 1/2 x 5/16 (LLV) WITH 15" x 5/16" PLATE	± (3) L5 x 3 1/2 x 5/16 (LLV) WITH 15" x 5/16" PLATE
1'-0" (8" CMU)	± (3) L4 x 3 1/2 x 5/16 (LLV) WITH 16" x 5/16" PLATE	± (2) L5 x 3 1/2 x 5/16 (LLV) WITH 15" x 5/16" PLATE
1'-5" (8" CMU)	± (3) L4 x 3 1/2 x 5/16 (LLV) WITH 16" x 5/16" PLATE	± (2) L5 x 5 x 3/8 WITH 16" x 5/16" PLATE
1'-6" (10" CMU)	± (3) L4 x 3 1/2 x 5/16 (LLV) WITH 17" x 5/16" PLATE	± (2) L6 x 6 x 3/8 WITH 17" x 5/16" PLATE
NOTES: 1. ALL EXTERIOR LINTELS SHALL BE GALVANIZED. 2. BOTTOM PLATE TO BE CUT 1/2" SHORTER THAN THE MASONRY OPENING.		


- GENERAL NOTES:**
REFER TO DRAWING EV-A1.1 FOR GENERAL PLAN NOTES.
- PLAN DRAWING NOTES:**
- INSTALL FIRE RATED IMPACT SAFETY GLASS IN EXISTING DOOR ASSEMBLY.
 - REMOVE LOOSE CONCRETE AND OLD PATCHING MATERIAL. REPAIR WITH A CONCRETE PATCH SUCH AS SIKAPATCH 223. PROVIDE PARGE COAT AND PAINT TO MATCH EXISTING ADJACENT.
 - REPLACE DOOR KNOBS IN EXISTING DOORS WITH ACCESSIBLE LEVER STYLE DOOR HANDLES.
 - PROVIDE NEW CARPET THROUGHOUT ENTIRE LIBRARY.
 - RAKE OUT DETERIORATING WINDOW SILLJOINT MATERIAL. REPOINT AND CAULK.
 - SAND AND REPAINT BASEMENT STAIR IN ITS ENTIRETY.
 - INFILL EXISTING DOOR, WINDOW, OR WALL OPENING AS SHOWN ON PLAN TO MATCH EXISTING WALL THICKNESS AND PREPARE FOR NEW FINISHES.
 - PROVIDE NEW COUNTERTOP AND SINK IN EXACT LOCATIONS, DIMENSIONS, AND QUANTITIES.
 - REINSTALL STORED PAIR OF CURBIES IN LOCATIONS SHOWN ON PLANS.
 - REINSTALL STORED TALL CABINET IN LOCATIONS SHOWN ON PLANS.
 - PATCH EXISTING WALL OPENING WHERE CONDUITS WERE REMOVED.
 - PROVIDE PREFABRICATED METAL STAIR TO CRAWL SPACE DOOR IN PLACE OF EXISTING WOOD STAIR. REF. SPECS.
 - REFINISH WOOD STAGE FLOOR AND WOOD STAGE STAIR IN THEIR ENTIRETY.
 - REINSTALL STORED TOILET ROOM SIGNAGE.
 - REINSTALL STORED FIRE EXTINGUISHER.
 - PROVIDE TWO ROWS OF NEW TACK STRIPS, TKS-1 ON CORRIDOR WALL TO EXTENTS SHOWN @ 6'-0" A.F.F. AND @ 7'-6" A.F.F.
 - PROVIDE NEW CHAIR LIFT, B.O.D. GARAVENTA LIFT - GENESIS OPAL STANDARD. REF. SPECS
 - PROVIDE WINDOW SHADES FOR THE STRAIGHT BOTTOM SASHES OF THE WINDOW. FAN SHAPED TOP SASHES DO NOT NEED WINDOW SHADES
 - REINSTALL STORED DOOR AND FRAME ASSEMBLY IN NEW LOCATION AS SHOWN.
 - PROVIDE NEW GUARDRAIL MOUNTED TO THE NEW EDGE OF THE STAGE FLOOR TO EXTENTS SHOWN.
 - NEW END PANEL FOR MOVED CABINET. MATERIAL AND COLOR TO MATCH EXISTING.
 - MOVE END RAY OF CURBIES WITH FINISHED END PANEL SO IT CAN REMAIN AT THE END. RELOCATED CURBIES TO BE INSTALLED NEXT TO IT

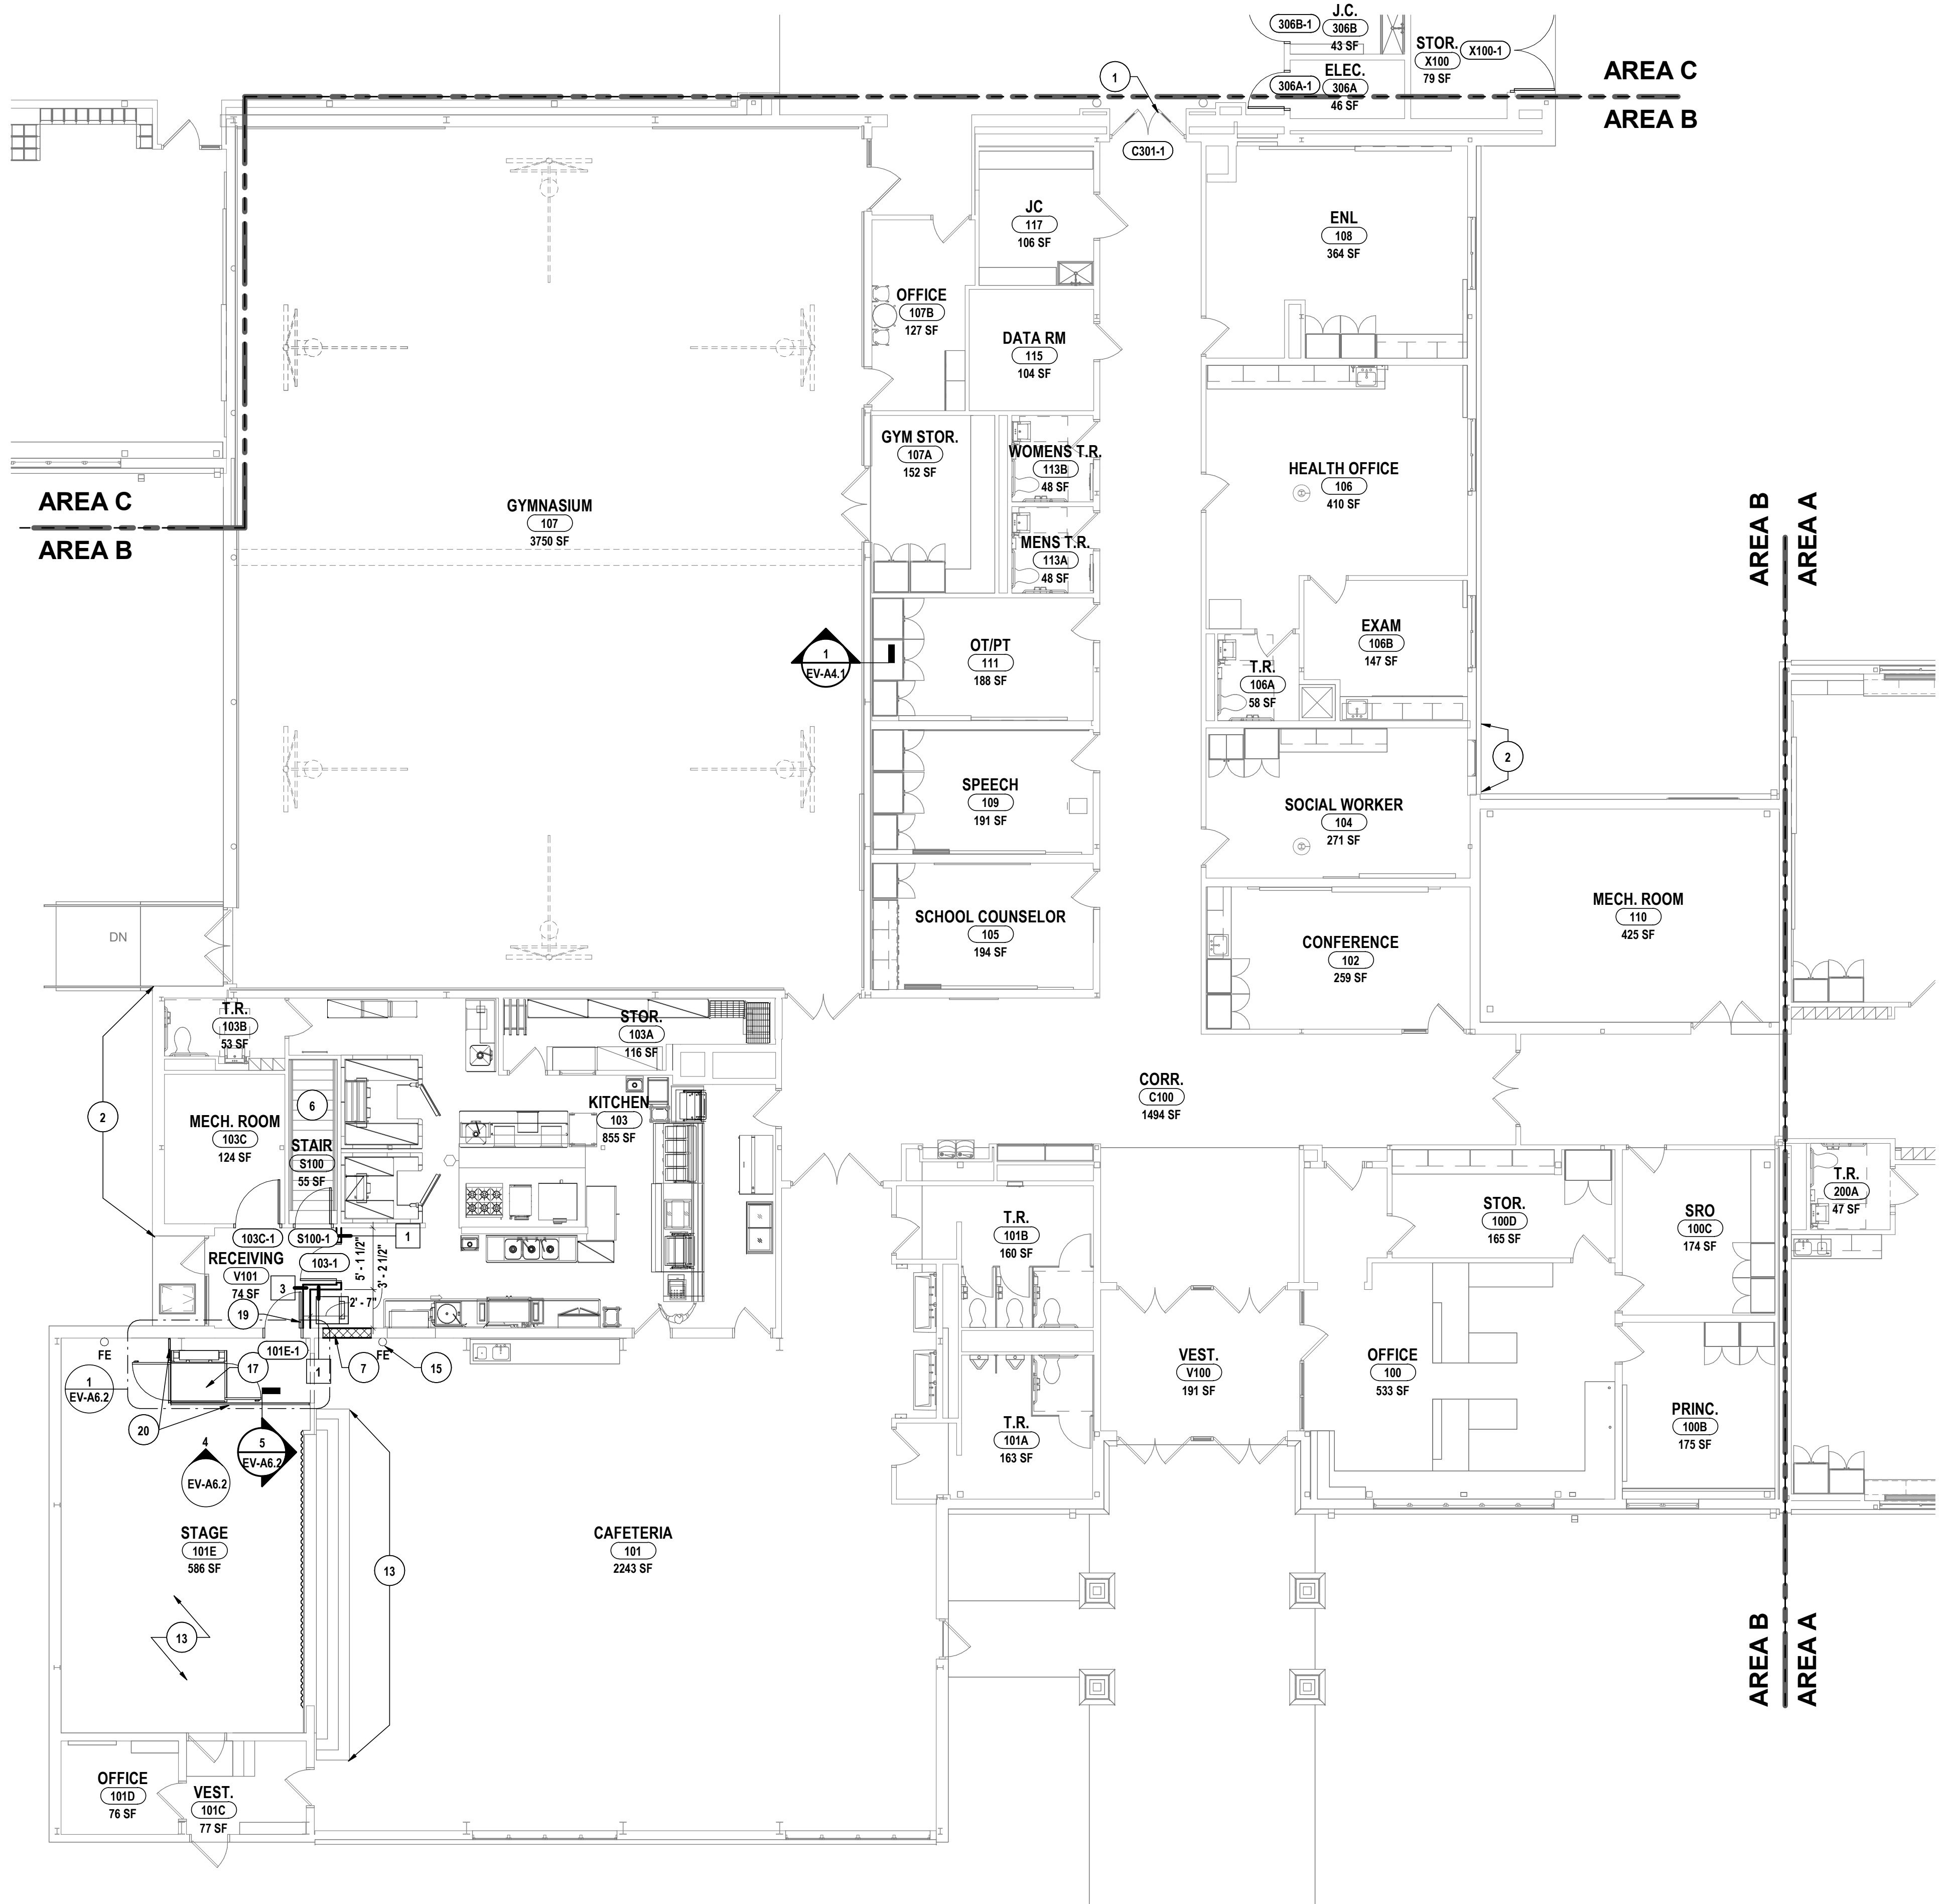


2 FIRST FLOOR PLAN - AREA B
1/8" = 1'-0"

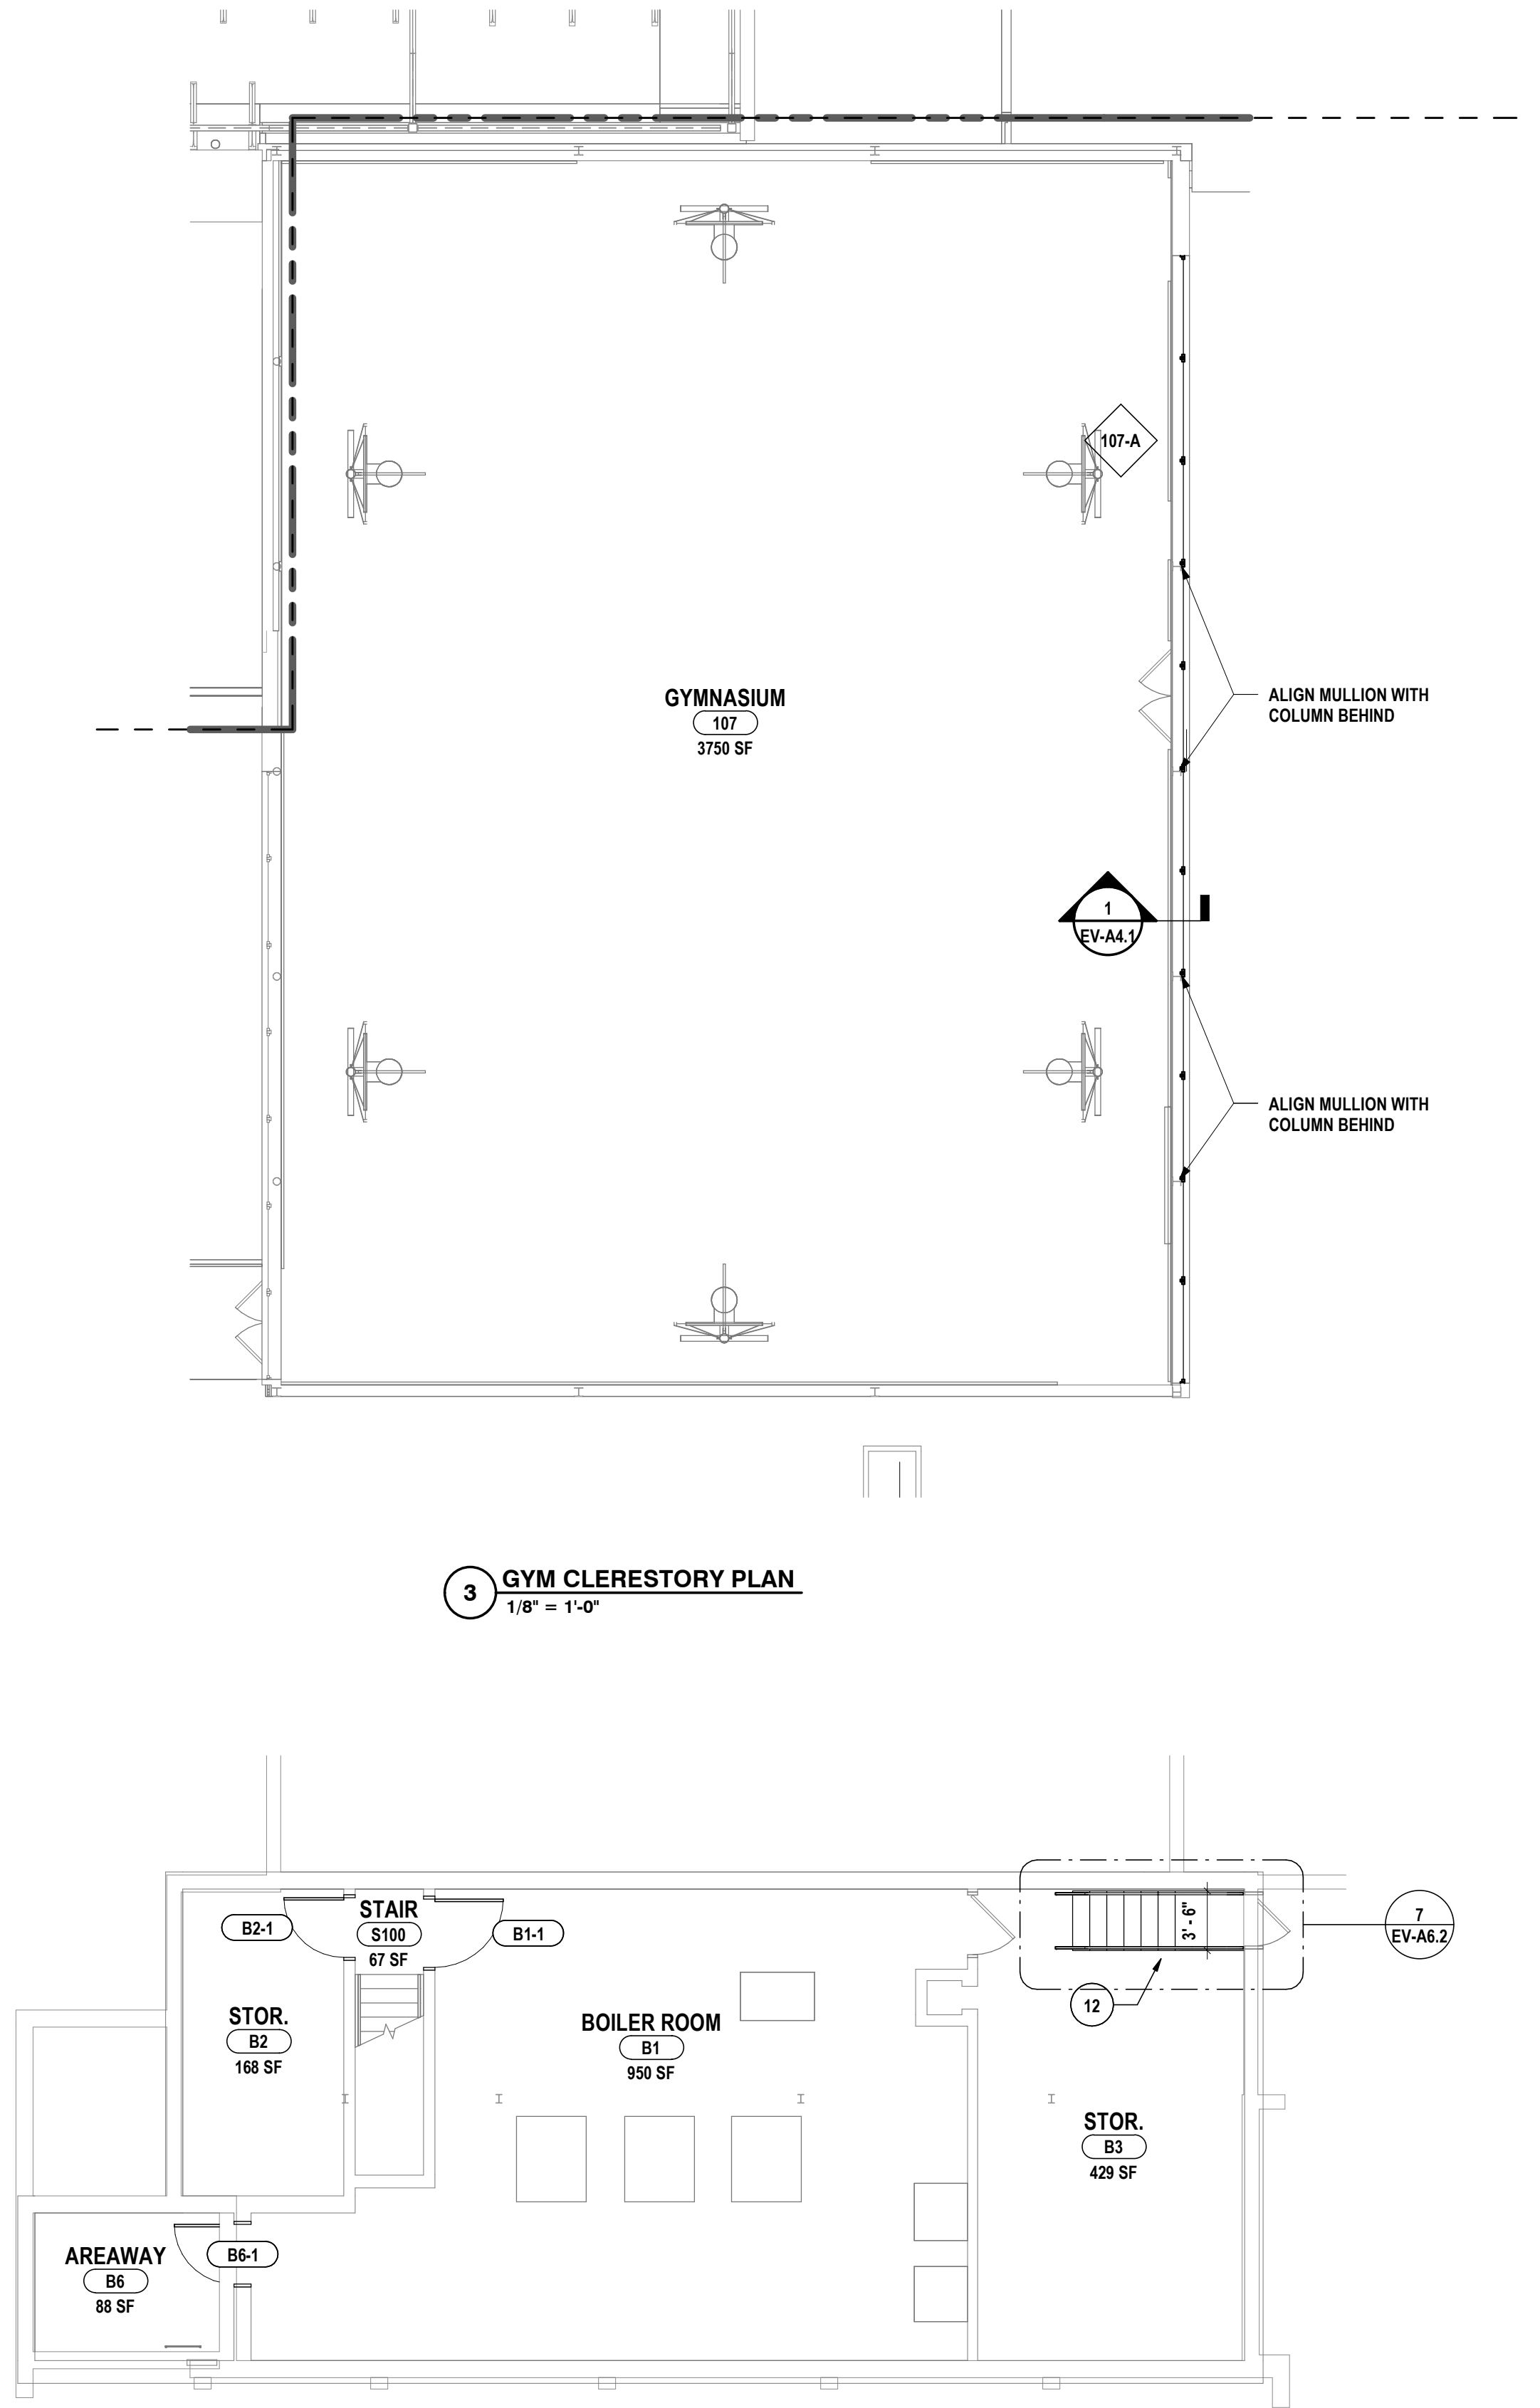

3 GYM CLERESTORY PLAN
1/8" = 1'-0"

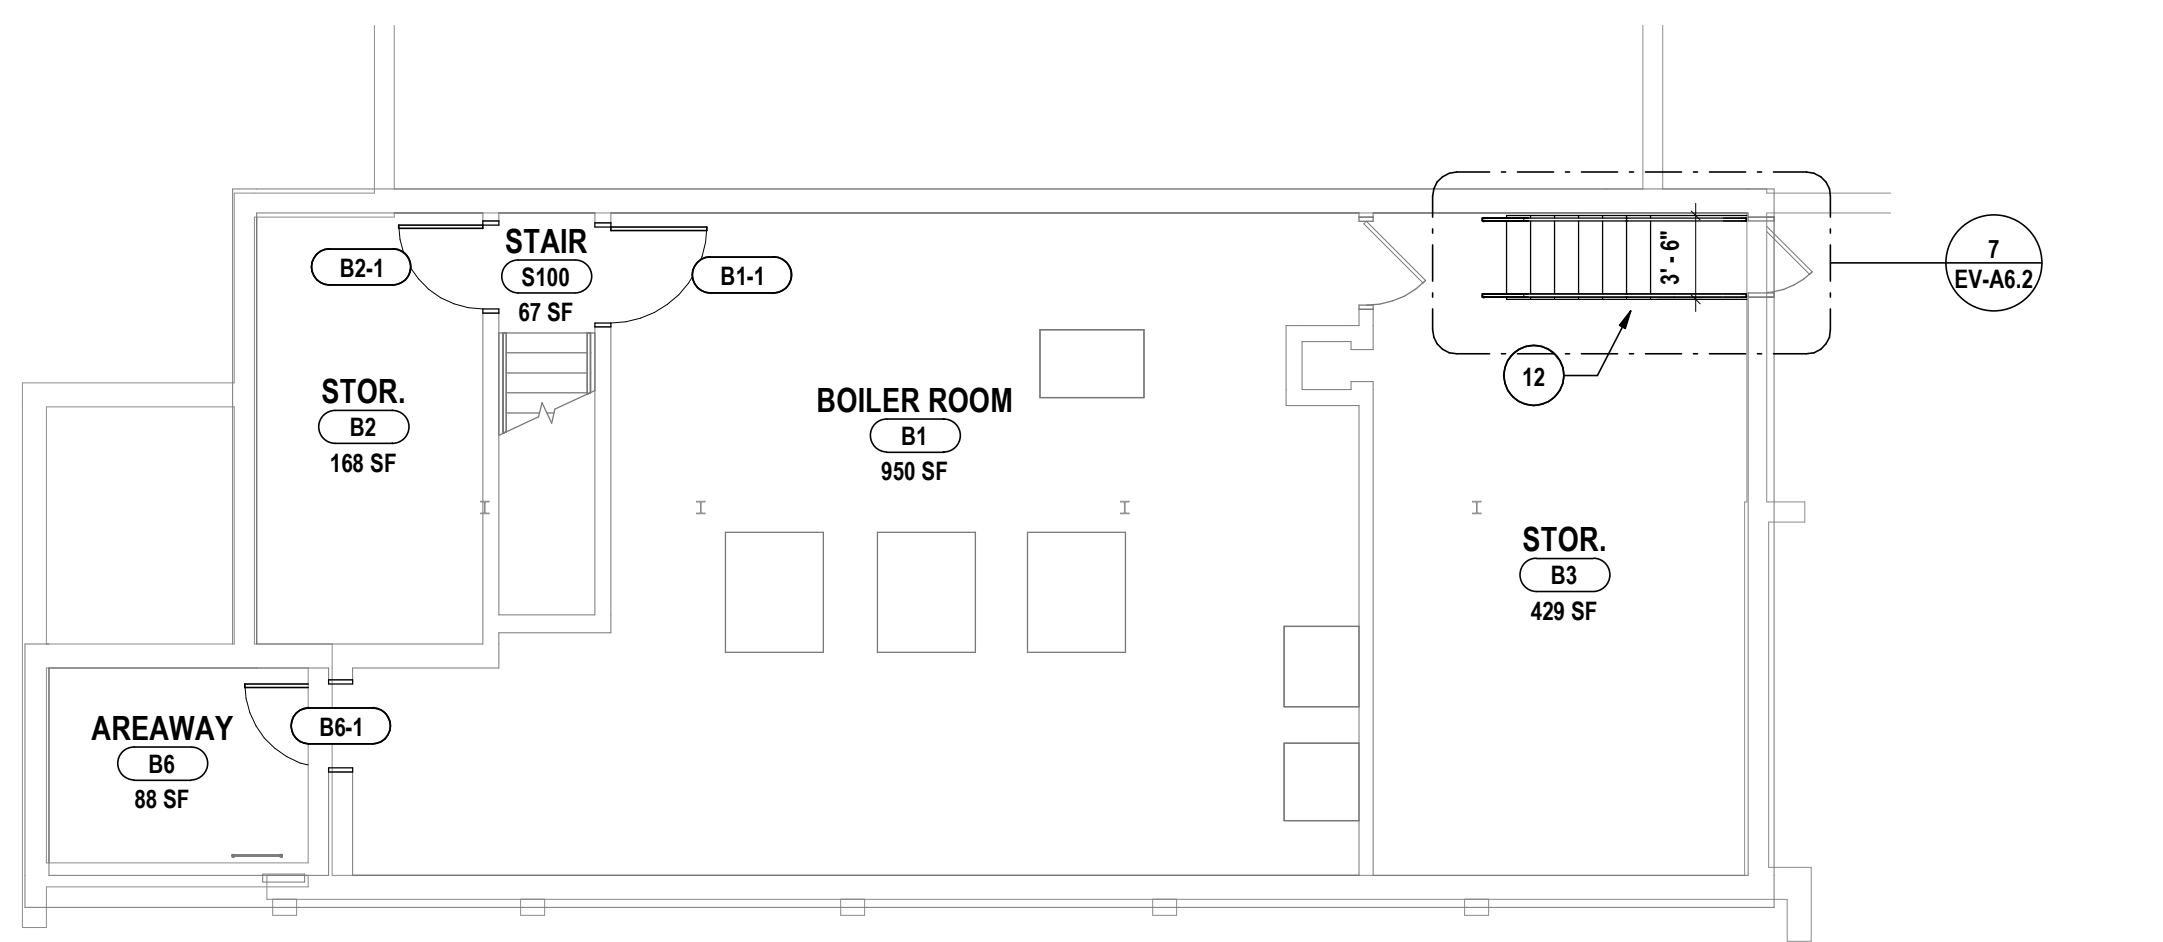

1 BASEMENT FLOOR PLAN
1/8" = 1'-0"

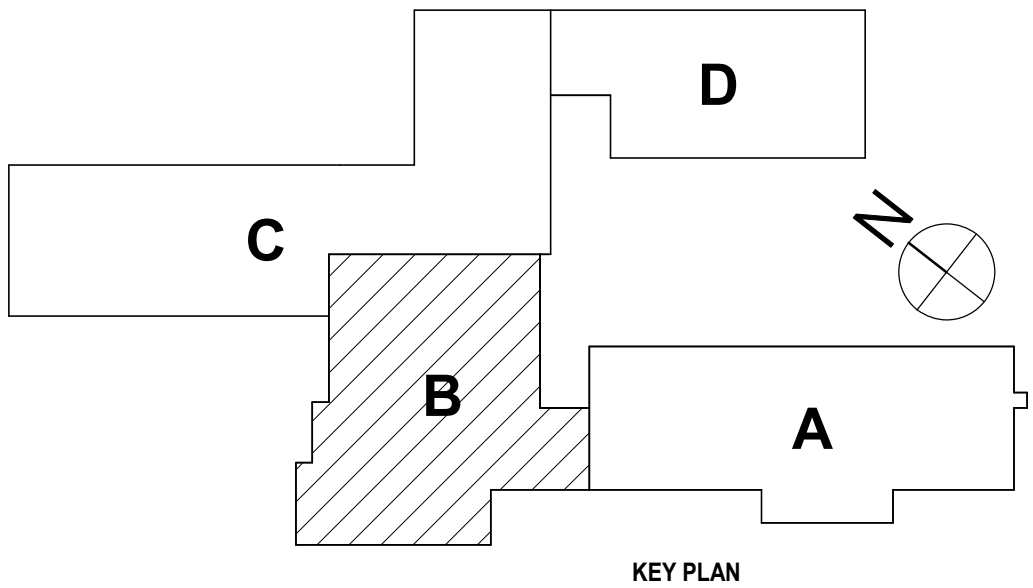


SED #ERWIN VALLEY ST 10-0001-0-000-027; ADMIN BUILDING 57-10-00-01-1-001-013

FIRST FLOOR PLAN - AREA B
2025 ERWIN VALLEY ELEM & ADMIN BUILDING ALTERATIONS
CORNING-PAINTED POST ASD
16 BEARTOWN ROAD PAINTED POST NY 14870


EV-A1.2
PROJECT NO: 2649-160

HUNT ENGINEERS | ARCHITECTS | SURVEYORS
ALBANY, NY - BINGHAMTON, NY - HORSENEADS, NY - ROCHESTER, NY
WWW.HUNT-EAS.COM 807-358-1000
NY CERTIFICATE NO. 0016220 PA CERTIFICATE NO. TSC220313464-1

REVISION:
1 10/22/2025
DATE:
1 10/22/2025
CHECKED BY:
DATE:
03/17/2026
PHASE:
CIP
DRAWN BY:
CAM
ST
SIGNED BY:
DATE:
03/17/2026
IT IS A VIOLATION OF THE LAW FOR ANY PERSON TO MAKE UNAUTHORIZED ALTERATIONS OR ADDITIONS TO PLANS BEARING A LICENSED ENGINEER, ARCHITECT'S OR SURVEYOR'S SEAL.

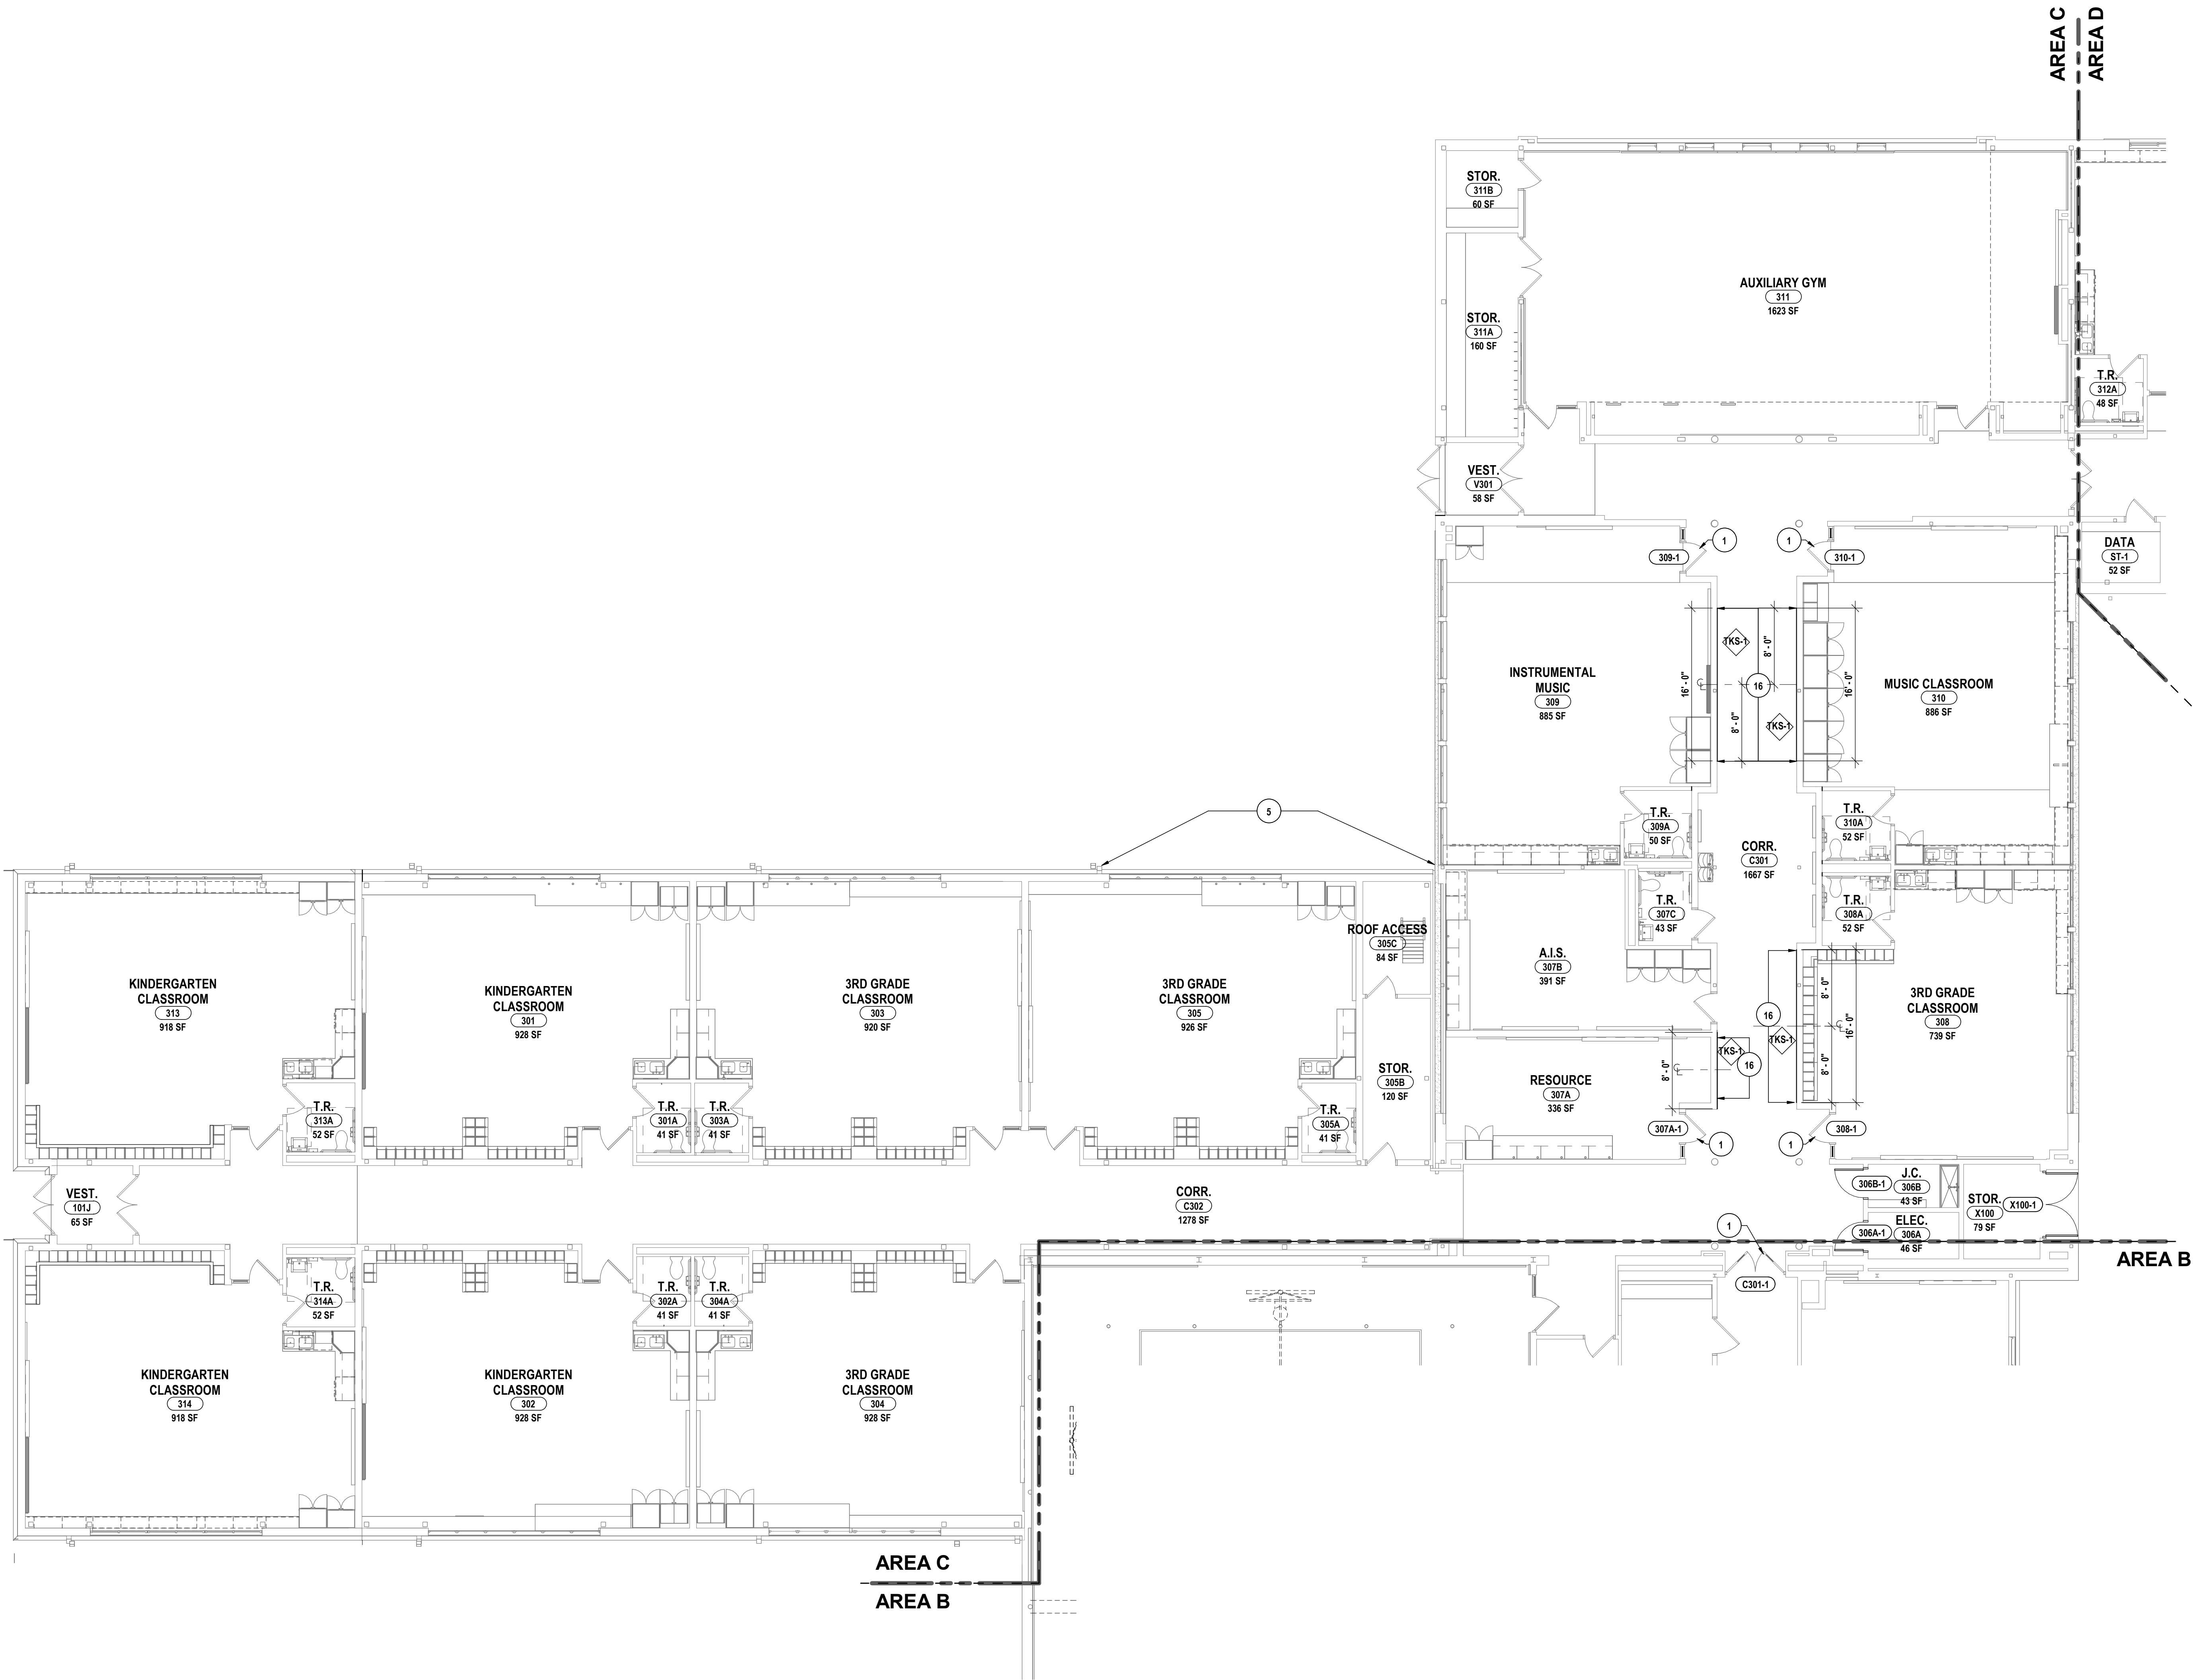

1 FIRST FLOOR PLAN - AREA C
1/8" = 1'-0"

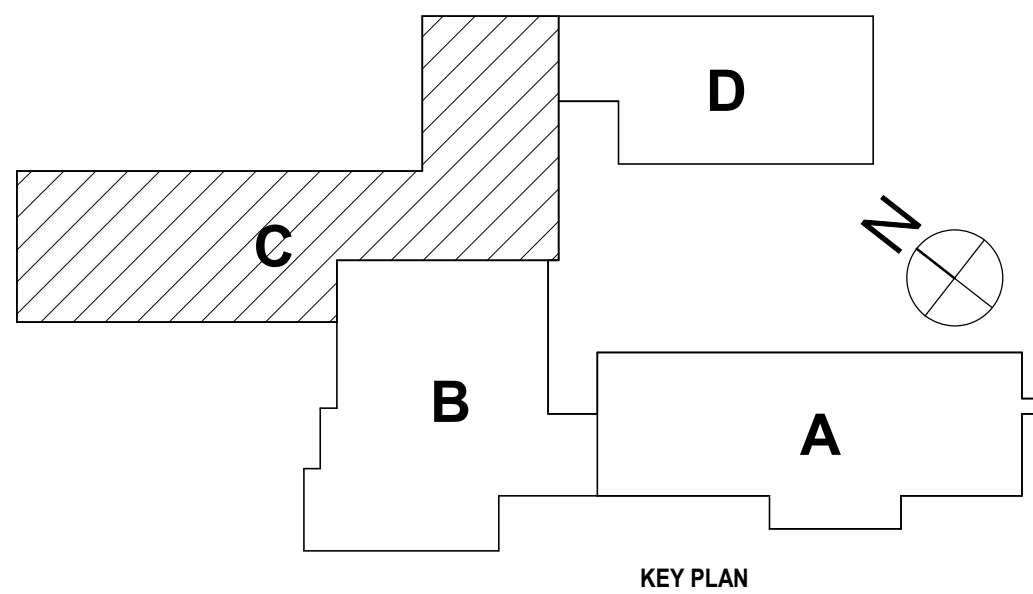

GENERAL NOTES:
REFER TO DRAWING EV-A1.1 FOR GENERAL PLAN NOTES.

PLAN DRAWING NOTES:

1. INSTALL FIRE RATED IMPACT SAFETY GLASS IN EXISTING DOOR ASSEMBLY.
2. REMOVE LOOSE CONCRETE AND OLD PATCHING MATERIAL. REPAIR WITH A CONCRETE PATCH SUCH AS Sika REPAIR 223. PROVIDE PARGE COAT AND PAINT TO MATCH EXISTING ADJACENT.
3. REPLACE DOOR KNOBS IN EXISTING DOORS WITH ACCESSIBLE LEVER STYLE DOOR HANDLES.
4. PROVIDE NEW CARPET THROUGHOUT ENTIRE LIBRARY.
5. RAKE OUT DETERIORATING WINDOW SILLJOINT MATERIAL. REPOINT AND CAULK.
6. SAND AND REPAINT BASEMENT STAIR IN ITS ENTIRETY.
7. INFILL EXISTING DOOR, WINDOW, OR WALL OPENING AS SHOWN ON PLAN TO MATCH EXISTING WALL THICKNESS AND PREPARE FOR NEW FINISHES.
8. PROVIDE NEW COUNTERTOP AND SINK IN EXACT LOCATIONS, DIMENSIONS, AND QUANTITIES.
9. REINSTALL STORED PAIR OF CUBBIES IN LOCATIONS SHOWN ON PLANS.
10. REINSTALL STORED TALL CABINET IN LOCATIONS SHOWN ON PLANS.
11. PATCH EXISTING WALL OPENING WHERE CONDUITS WERE REMOVED.
12. PROVIDE PREFABRICATED METAL STAIR TO CRAWL SPACE DOOR IN PLACE OF EXISTING WOOD STAIR. REF. SPECS
13. REFINISH WOOD STAGE FLOOR AND WOOD STAGE STAIR IN THEIR ENTIRETY.
14. REINSTALL STORED TOILET ROOM SIGNAGE.
15. REINSTALL STORED FIRE EXTINGUISHER.
16. PROVIDE TWO ROWS OF NEW TACK STRIPS, TKS-1 ON CORRIDOR WALL TO EXTENTS SHOWN @ 6'-0" A.F.F. AND @ 7'-6" A.F.F.
17. PROVIDE NEW CHAIR LIFT, B.O.D. GARAVENTA LIFT - GENESIS OPAL STANDARD. REF. SPECS
18. PROVIDE WINDOW SHADES FOR THE STRAIGHT BOTTOM SASHES OF THE WINDOW. FAN SHAPED TOP SASHES DO NOT NEED WINDOW SHADES
19. REINSTALL STORED DOOR AND FRAME ASSEMBLY IN NEW LOCATION AS SHOWN.
20. PROVIDE NEW GUARDRAIL MOUNTED TO THE NEW EDGE OF THE STAGE FLOOR TO EXTENTS SHOWN.
21. NEW END PANEL FOR MOVED CABINET. MATERIAL AND COLOR TO MATCH EXISTING.
22. MOVE END BAY OF CUBBIES WITH FINISHED END PANEL SO IT CAN REMAIN AT THE END. RELOCATED CUBBIES TO BE INSTALLED NEXT TO IT

SED #ERWIN VALLEY ST 10-00-01-0-000-027 ADMIN BUILDING 57-10-00-01-001-013

FIRST FLOOR PLAN - AREA C
2025 ERWIN VALLEY ELEM & ADMIN BUILDING ALTERATIONS
CORNING-PAINTED POST ASD
16 BEARTOWN ROAD PAINTED POST NY 14870

EV-A1.3

PROJECT NO: 2649-160

HUNT ENGINEERS | ARCHITECTS | SURVEYORS
ALBANY, NY - BINGHAMTON, NY - HORSESHOE FALLS, NY - ROCHESTER, NY
WWW.HUNT-EAS.COM 807-358-1000
NY CERTIFICATE NO. 0016220 PA CERTIFICATE NO. TSC220313464-1

DRAWN BY:	CAM
CHECKED BY:	SE
DATE:	03/17/2026
PHASE:	CD
REVISION:	ISSUE FOR BID
# DATE:	1 10/22/2025



"IT IS A VIOLATION OF THE LAW FOR ANY PERSON TO MAKE UNAUTHORIZED ALTERATIONS OR ADDITIONS TO PLANS BEARING A LICENSED ENGINEER, ARCHITECT'S OR SURVEYOR'S SEAL."

GENERAL NOTES:
REFER TO DRAWING EV-A1.1 FOR GENERAL PLAN NOTES.

PLAN DRAWING NOTES:

1. INSTALL FIRE RATED IMPACT SAFETY GLASS IN EXISTING DOOR ASSEMBLY.
2. REMOVE LOOSE CONCRETE AND OLD PATCHING MATERIAL. REPAIR WITH A CONCRETE PATCH SUCH AS Sika REPAIR 223. PROVIDE PARGE COAT AND PAINT TO MATCH EXISTING ADJACENT.
3. REPLACE DOOR KNOBS IN EXISTING DOORS WITH ACCESSIBLE LEVER STYLE DOOR HANDLES.
4. PROVIDE NEW CARPET THROUGHOUT ENTIRE LIBRARY.
5. RAKE OUT DETERIORATING WINDOW SILL JOINT MATERIAL. REPOINT AND CAULK.
6. SAND AND REPAINT BASEMENT STAIR IN ITS ENTIRETY.
7. INFILL EXISTING DOOR, WINDOW, OR WALL OPENING AS SHOWN ON PLAN TO MATCH EXISTING WALL THICKNESS AND PREPARE FOR NEW FINISHES.
8. PROVIDE NEW COUNTERTOP AND SINK IN EXACT LOCATIONS, DIMENSIONS, AND QUANTITIES.
9. REINSTALL STORED PAIR OF CUBBIES IN LOCATIONS SHOWN ON PLANS.
10. REINSTALL STORED TALL CABINET IN LOCATIONS SHOWN ON PLANS.
11. PATCH EXISTING WALL OPENING WHERE CONDUITS WERE REMOVED.
12. PROVIDE PREFABRICATED METAL STAIR TO CRAWL SPACE DOOR IN PLACE OF EXISTING WOOD STAIR. REF. SPECS.
13. REFINISH WOOD STAGE FLOOR AND WOOD STAGE STAIR IN THEIR ENTIRETY.
14. REINSTALL STORED TOILET ROOM SIGNAGE.
15. REINSTALL STORED FIRE EXTINGUISHER.
16. PROVIDE TWO ROWS OF NEW TACK STRIPS, TKS-1 ON CORRIDOR WALL TO EXTENTS SHOWN @ 6'-0" A.F.F. AND @ 7'-6" A.F.F.
17. PROVIDE NEW CHAIR LIFT, B.O.D. GARAVENTA LIFT - GENESIS OPAL STANDARD. REF. SPECS
18. PROVIDE WINDOW SHADES FOR THE STRAIGHT BOTTOM SASHES OF THE WINDOW. FAN SHAPED TOP SASHES DO NOT NEED WINDOW SHADES
19. REINSTALL STORED DOOR AND FRAME ASSEMBLY IN NEW LOCATION AS SHOWN.
20. PROVIDE NEW GUARDRAIL MOUNTED TO THE NEW EDGE OF THE STAGE FLOOR TO EXTENTS SHOWN.
21. NEW END PANEL FOR MOVED CABINET. MATERIAL AND COLOR TO MATCH EXISTING.
22. MOVE END BAY OF CUBBIES WITH FINISHED END PANEL SO IT CAN REMAIN AT THE END. RELOCATED CUBBIES TO BE INSTALLED NEXT TO IT

DRAWN BY:	CAM
CHECKED BY:	ST
DATE:	03/17/2026
PHASE:	CP
#	1
DATE:	1/10/2026
REVISION:	ISSUE FOR BID
"IT IS A VIOLATION OF THE LAW FOR ANY PERSON TO MAKE UNAUTHORIZED ALTERATIONS OR ADDITIONS TO PLANS BEARING A LICENSED ENGINEER, ARCHITECT'S OR SURVEYOR'S SEAL."	

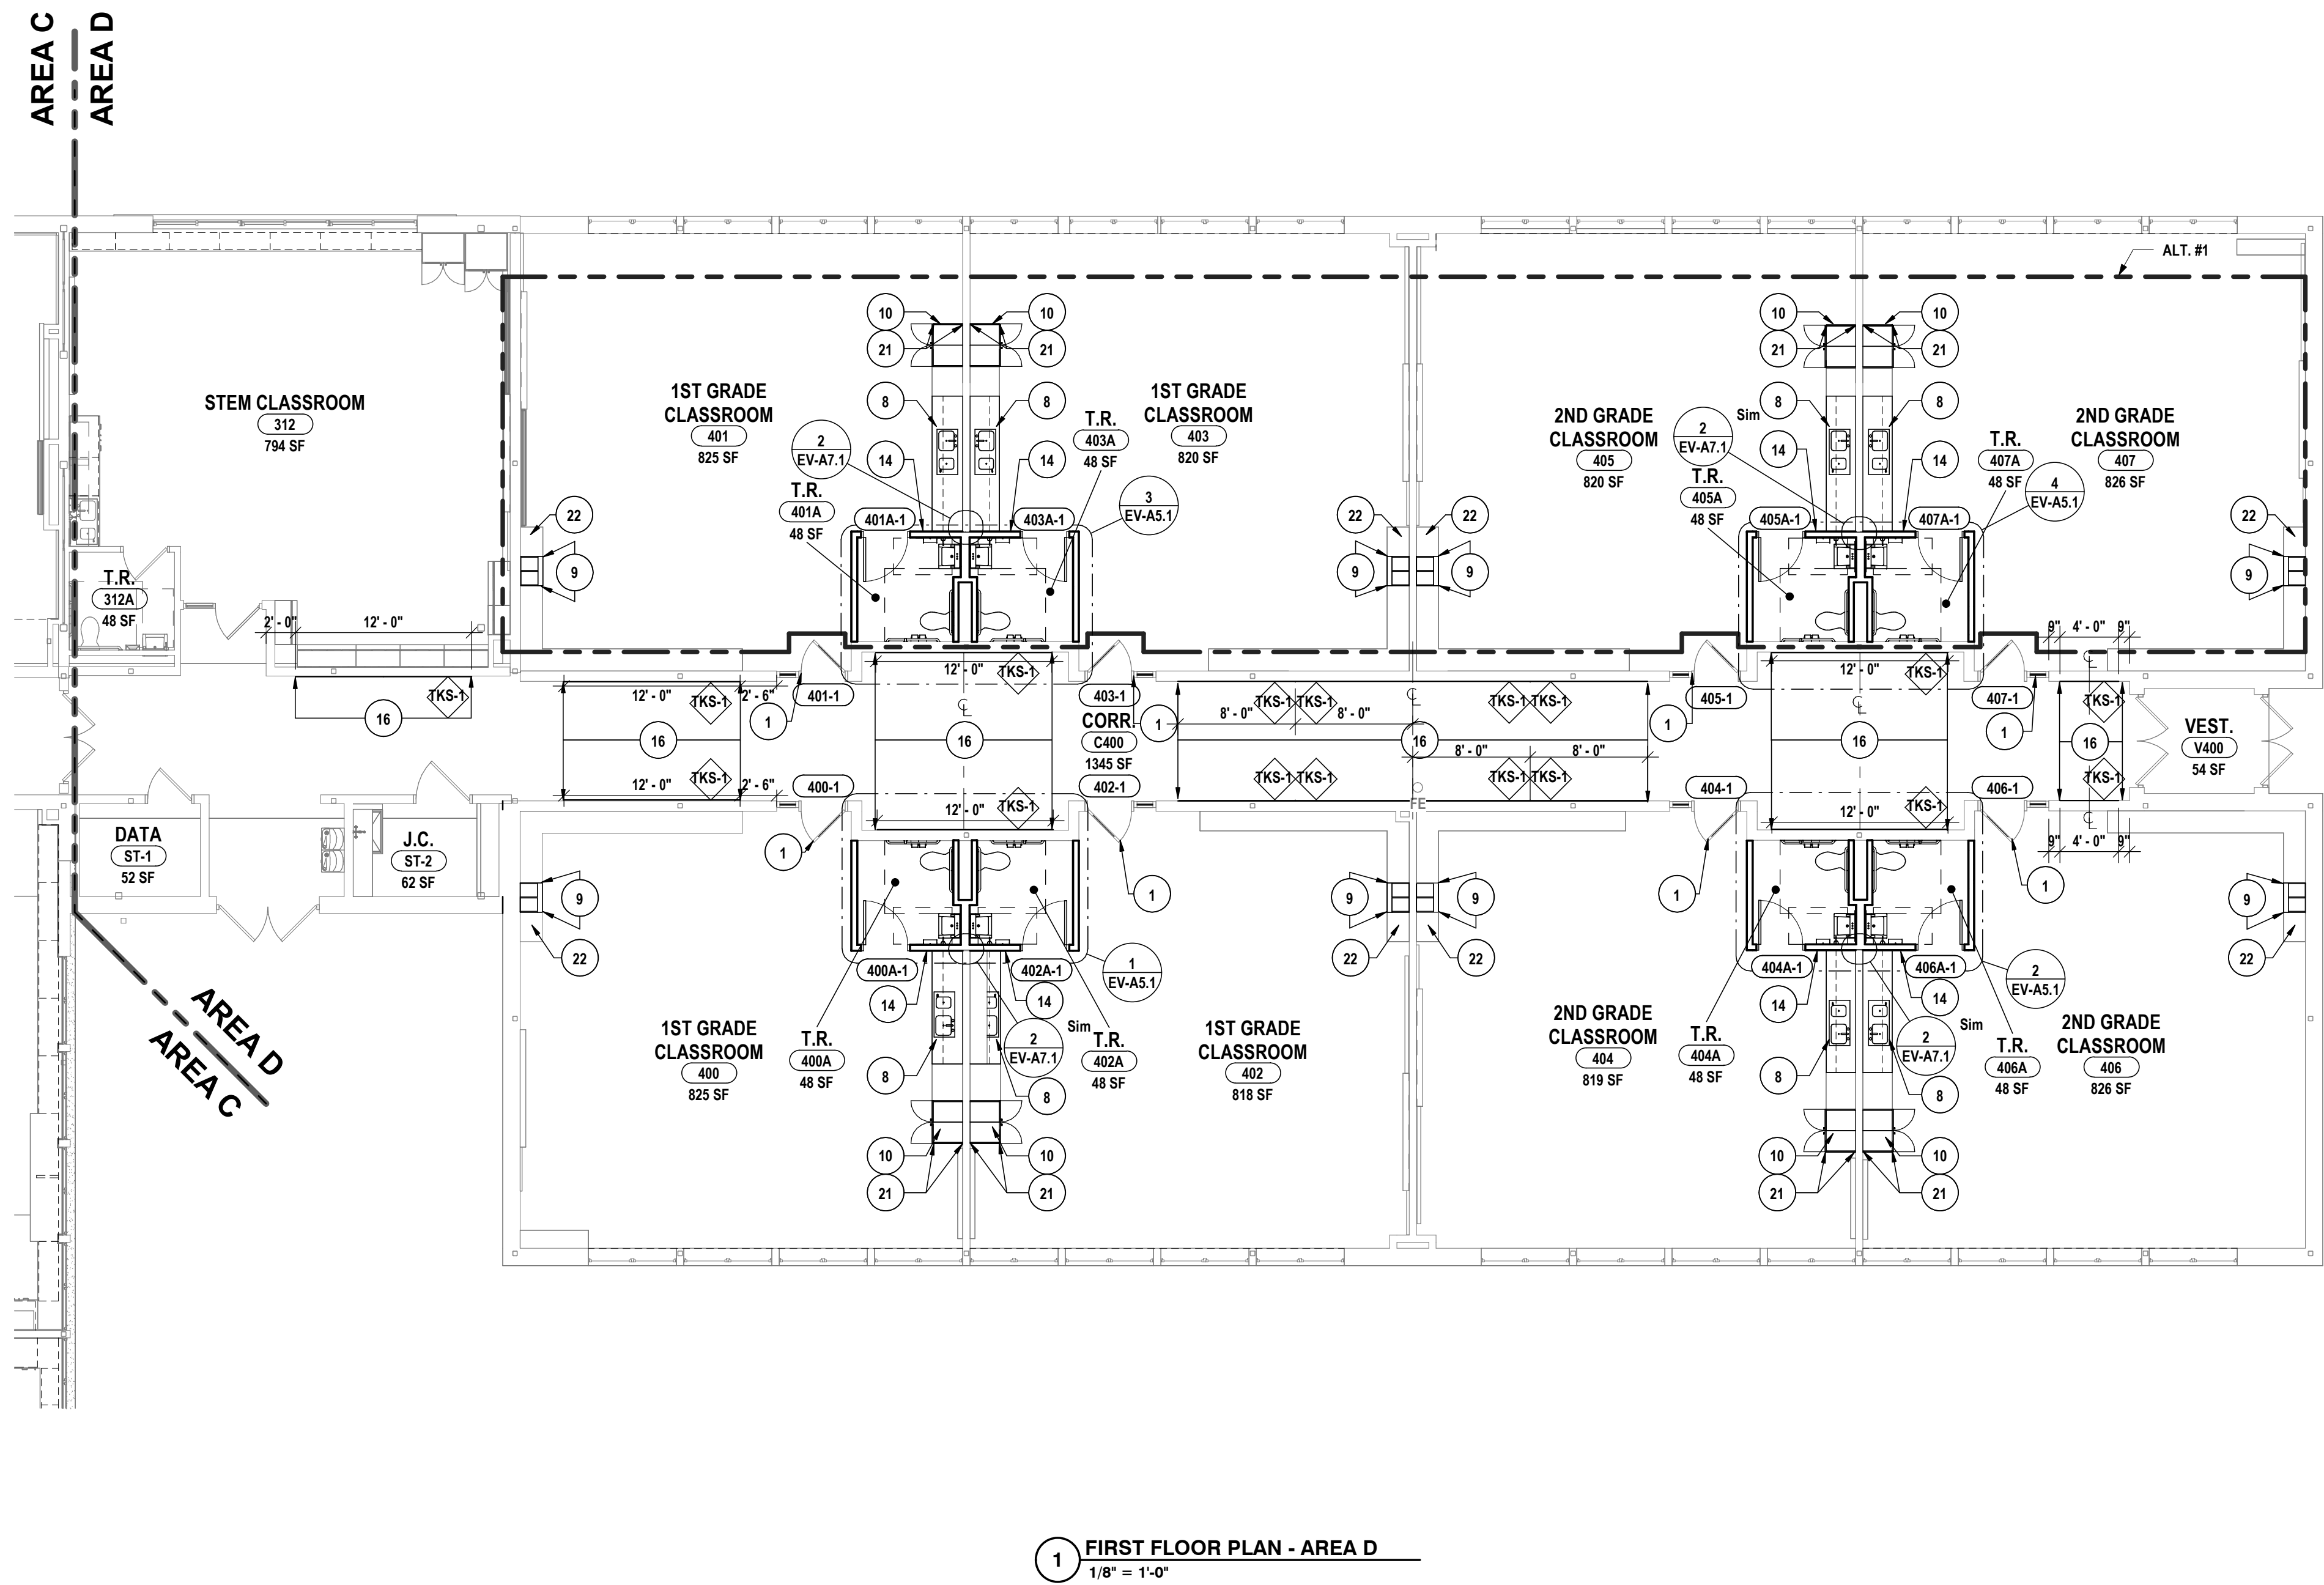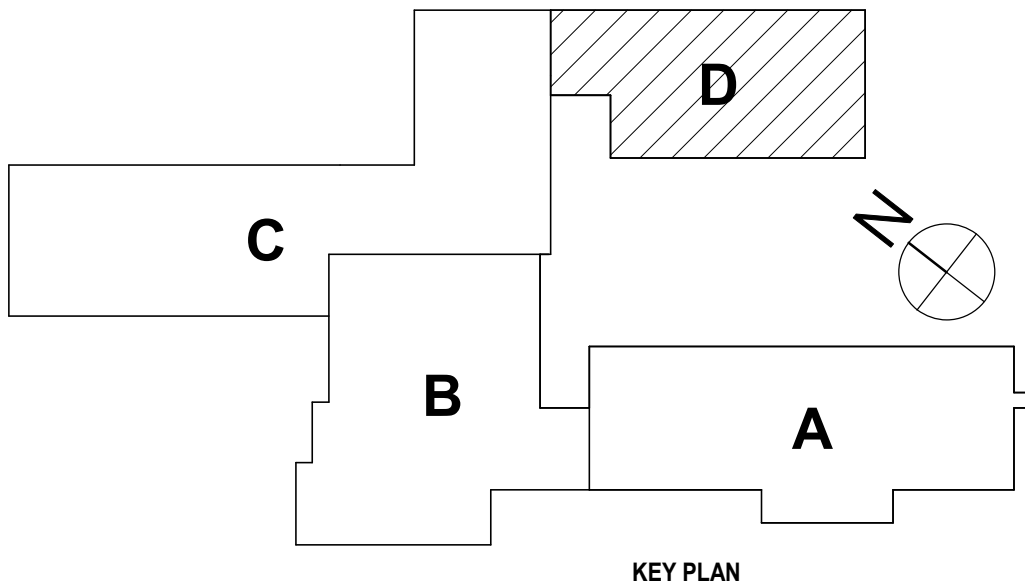

SED #ERWIN VALLEY ST 10-000-1-0-000-027; ADMIN BUILDING 57-10-000-011-000-013

FIRST FLOOR PLAN - AREA D
2025 ERWIN VALLEY ELEM & ADMIN BUILDING ALTERATIONS
CORNING-PAINTED POST ASD
16 BEARTOWN ROAD, PAINTED POST, NY 14870

EV-A1.4
PROJECT NO: 2649-160

HUNT ENGINEERS | ARCHITECTS | SURVEYORS
ALBANY, NY - BINGHAMTON, NY - HORSESHOE, NY - ROCHESTER, NY
WWW.HUNT-EAS.COM 807-358-1000
NY CERTIFICATE NO. 0016220 PA CERTIFICATE NO. TSC22031464-1

GENERAL ROOF NOTES:

- A ALL WORK SHALL CONFORM TO THE NEW YORK STATE BUILDING CODE AND ADOPTED REFERENCE STANDARDS.
B ALL WORK, ON OR NEAR EXISTING ROOFING SCHEDULED TO REMAIN IN PLACE, SHALL BE REMOVED IN SUCH A MANNER TO MAINTAIN ALL EXISTING WARRANTIES.
C THE CONTRACTOR SHALL PROTECT EXISTING CONSTRUCTION TO REMAIN AS REQUIRED DURING DEMOLITION. ALL EXISTING CONSTRUCTION TO REMAIN SHALL BE RESTORED TO ITS ORIGINAL CONDITION, UNLESS NOTED OTHERWISE.
D THE CONTRACTOR SHALL INSTALL AND MAINTAIN TEMPORARY ROOFING TO ENSURE WEATHER TIGHT CONDITIONS UNTIL SUCH TIME THE PERMANENT ROOFING SYSTEM IS INSTALLED.
E THE CONTRACTOR SHALL PROVIDE ALL MATERIALS TO MAKE SMOOTH TRANSITIONS AT ROOF EDGES AND INTERSECTIONS. TAPERED EDGE STRIPS ARE REQUIRED AT PERIMETER.
F THE CONTRACTOR SHALL PROVIDE FLASHING AT ALL PENETRATIONS.
G CONTRACTOR TO PROVIDE ANY ADDITIONAL BLOCKING AND ANY ASSOCIATED ACCESSORIES REQUIRED BASED ON FINAL GUTTER AND DOWNSPOUT LOCATIONS.
H PREVENT DIRT AND ROOFING DEBRIS FROM ENTERING THE ROOF DRAINS AND DRAIN LINES (LEADERS) DURING CONSTRUCTION. THE CONTRACTOR SHALL SNAKE DRAIN LINES AT COMPLETION OF WORK.
I IF EXISTING ROOF DECK OR STRUCTURAL SYSTEM DAMAGE IS SUSPECTED, NOTIFY THE OWNER'S REPRESENTATIVE IMMEDIATELY.

ROOF DRAWING NOTES:

- 1 CLEAN CHIMNEY MASONRY AND REPOINT MORTAR JOINTS.
2 REINSTALL STORED GUTTERS AND DOWNSPOUTS IN ORIGINAL LOCATIONS.
3 PROVIDE NEW RAIL SNOW GUARDS IN LOCATIONS SHOWN ON PLANS.
4 PROVIDE MEMBRANE WRAPPED 2X6 AS A WATER DIVERTER. MATCH EXG.
5 MECHANICAL INTAKE HOOD, SEE "H" DWGS. PROVIDE NEW CURB FLASH PER TYPICAL CURB DETAIL ON EV-A1.6. PATCH ROOF SYSTEM AND INSTALL NEW MEMBRANE FLASHING. TIE-IN SHALL NOT VOID WARRANTY.
6 PLUMBING VENT; SEE "P" DWGS. PROVIDE NEW VENT HOOD PER TYPICAL VENT PIPE DETAIL.
7 PROVIDE VENT FOR RELOCATED WASHER AND DRYER. SEE "H" DWGS.
8 PATCH AND INFILL REMOVED VENT HOLE. SEE EXISTING OPENING INFILL DETAIL.

ROOF LEGEND (ALTERNATE #4):

- INSTALL SYSTEM AS DETAILED BELOW.
MAINTAIN A MIN. R-VALUE OF R-33
- NEW TPO MEMBRANE
NEW 3/8" COVERBOARD
NEW 2" RIGID INSULATION MECHANICALLY FASTENED
EXG RIGID INSULATION TO REMAIN
EXG VAPOR BARRIER TO REMAIN
EXG ROOF SHEATHING TO REMAIN
SLOPED METAL DECK
- TPO MEMBRANE
3/8" COVERBOARD
RIGID INSULATION
VAPOR BARRIER
EXG SLOPED POURED GYPSUM DECK TO REMAIN
- TPO MEMBRANE TO BE PATCHED IN TO PROVIDE TRANSITION FROM EXISTING TO NEW
- EXISTING ROOF TO REMAIN
- VENT PIPE
- ARROW INDICATES DIRECTION OF SLOPE FOR THE ROOF STRUCTURE OR TAPERED INSULATION (SEE STRUCTURAL DRAWINGS)
- INSULATION THK @ HIGH POINT
- INSULATION THK @ LOW POINT
- DOWNSPOUT



ROOF LEGEND (BASE BID):

- TPO FLEECEBACK OVER EXISTING ADHERED SINGLE-PLY PVC ROOFING
- TPO FLEECEBACK OVER EXISTING ADHERED SINGLE-PLY TPO ROOFING
- TPO MEMBRANE TO BE PATCHED IN TO PROVIDE TRANSITION FROM EXISTING TO NEW
- EXISTING ROOF TO REMAIN
- VENT PIPE
- ARROW INDICATES DIRECTION OF SLOPE FOR THE ROOF STRUCTURE OR TAPERED INSULATION (SEE STRUCTURAL DRAWINGS)
- INSULATION THK @ HIGH POINT
- INSULATION THK @ LOW POINT
- DOWNSPOUT

WIND UPLIFT INFORMATION				
ROOF ZONE	WINDWARD	LEEWARD	WINDWARD	LEEWARD
CORNER	10 SF	10 SF	10 SF	10 SF
EDGE	17.1	12.1	-89.9	-42.4
INTERIOR	17.1	12.1	-63.2	-34.5

WIND LOAD DESIGN PARAMETERS

BASIC WIND SPEED: 120 MPH
OCCUPANCY RISK CATEGORY: III
WIND EXPOSURE CATEGORY: B
Kz = 0.7, Kzt = 0.85, Ke = 1.0
ENCLOSED BUILDING GCpf = ±0.18

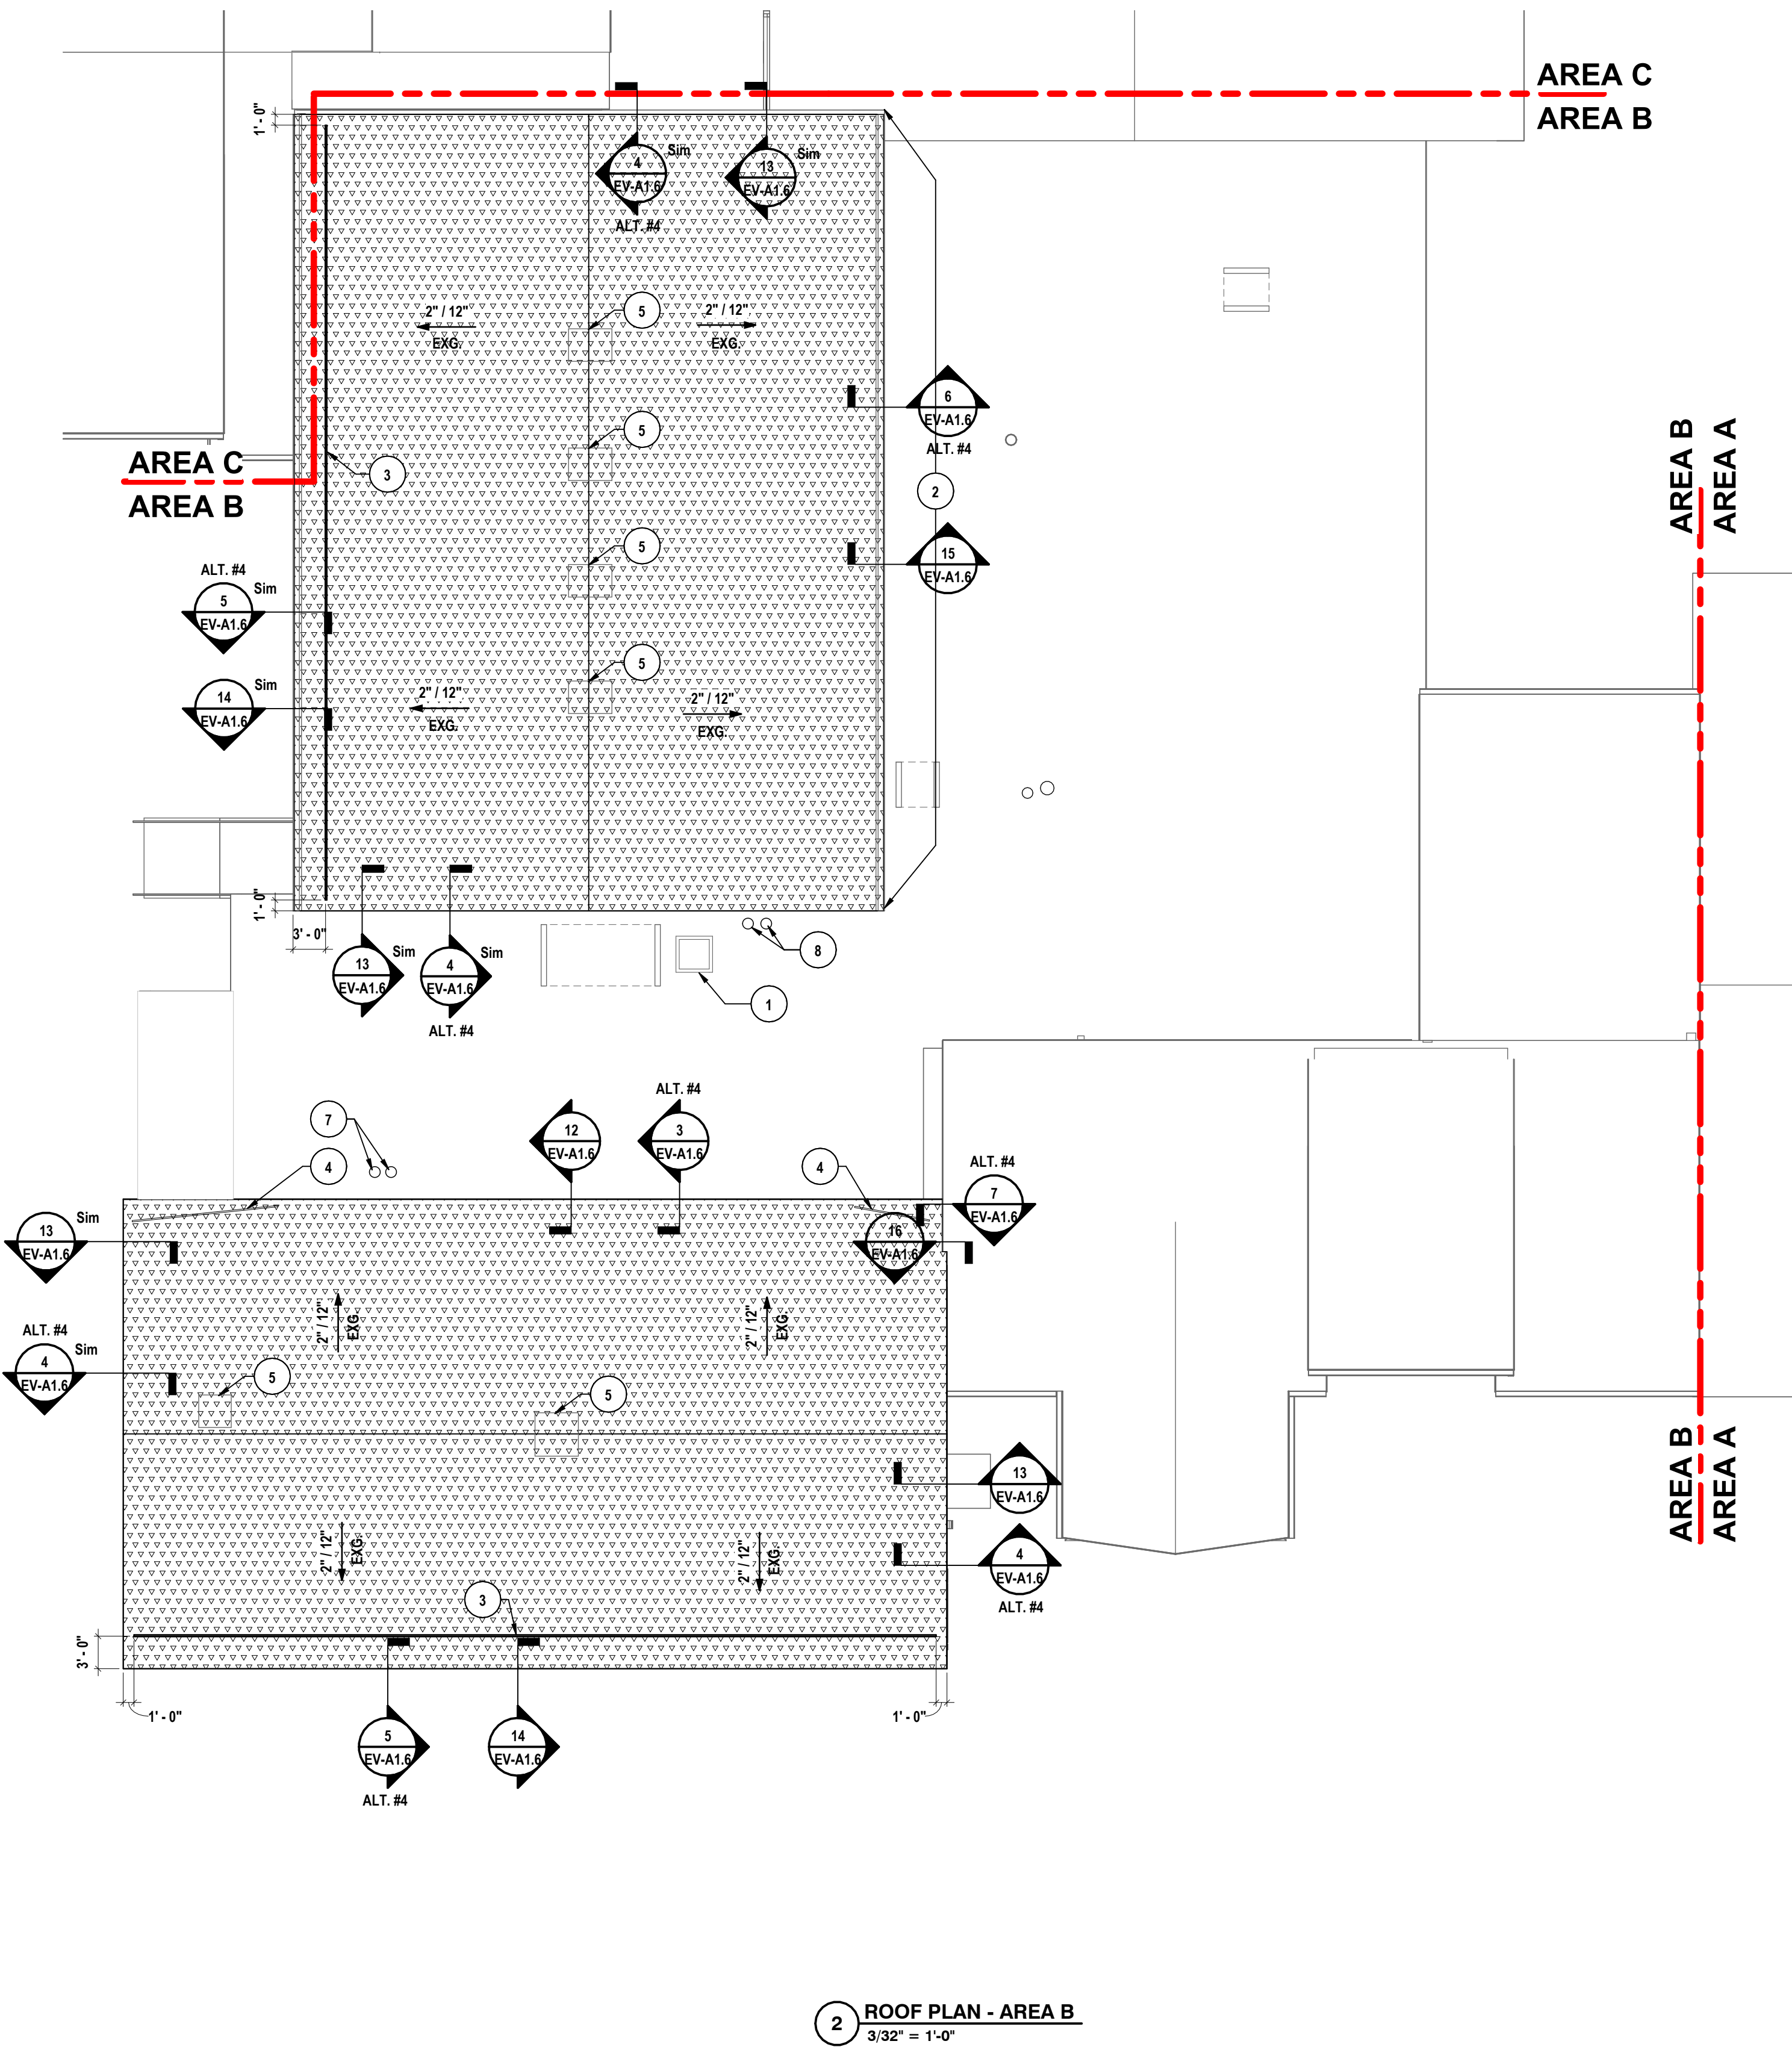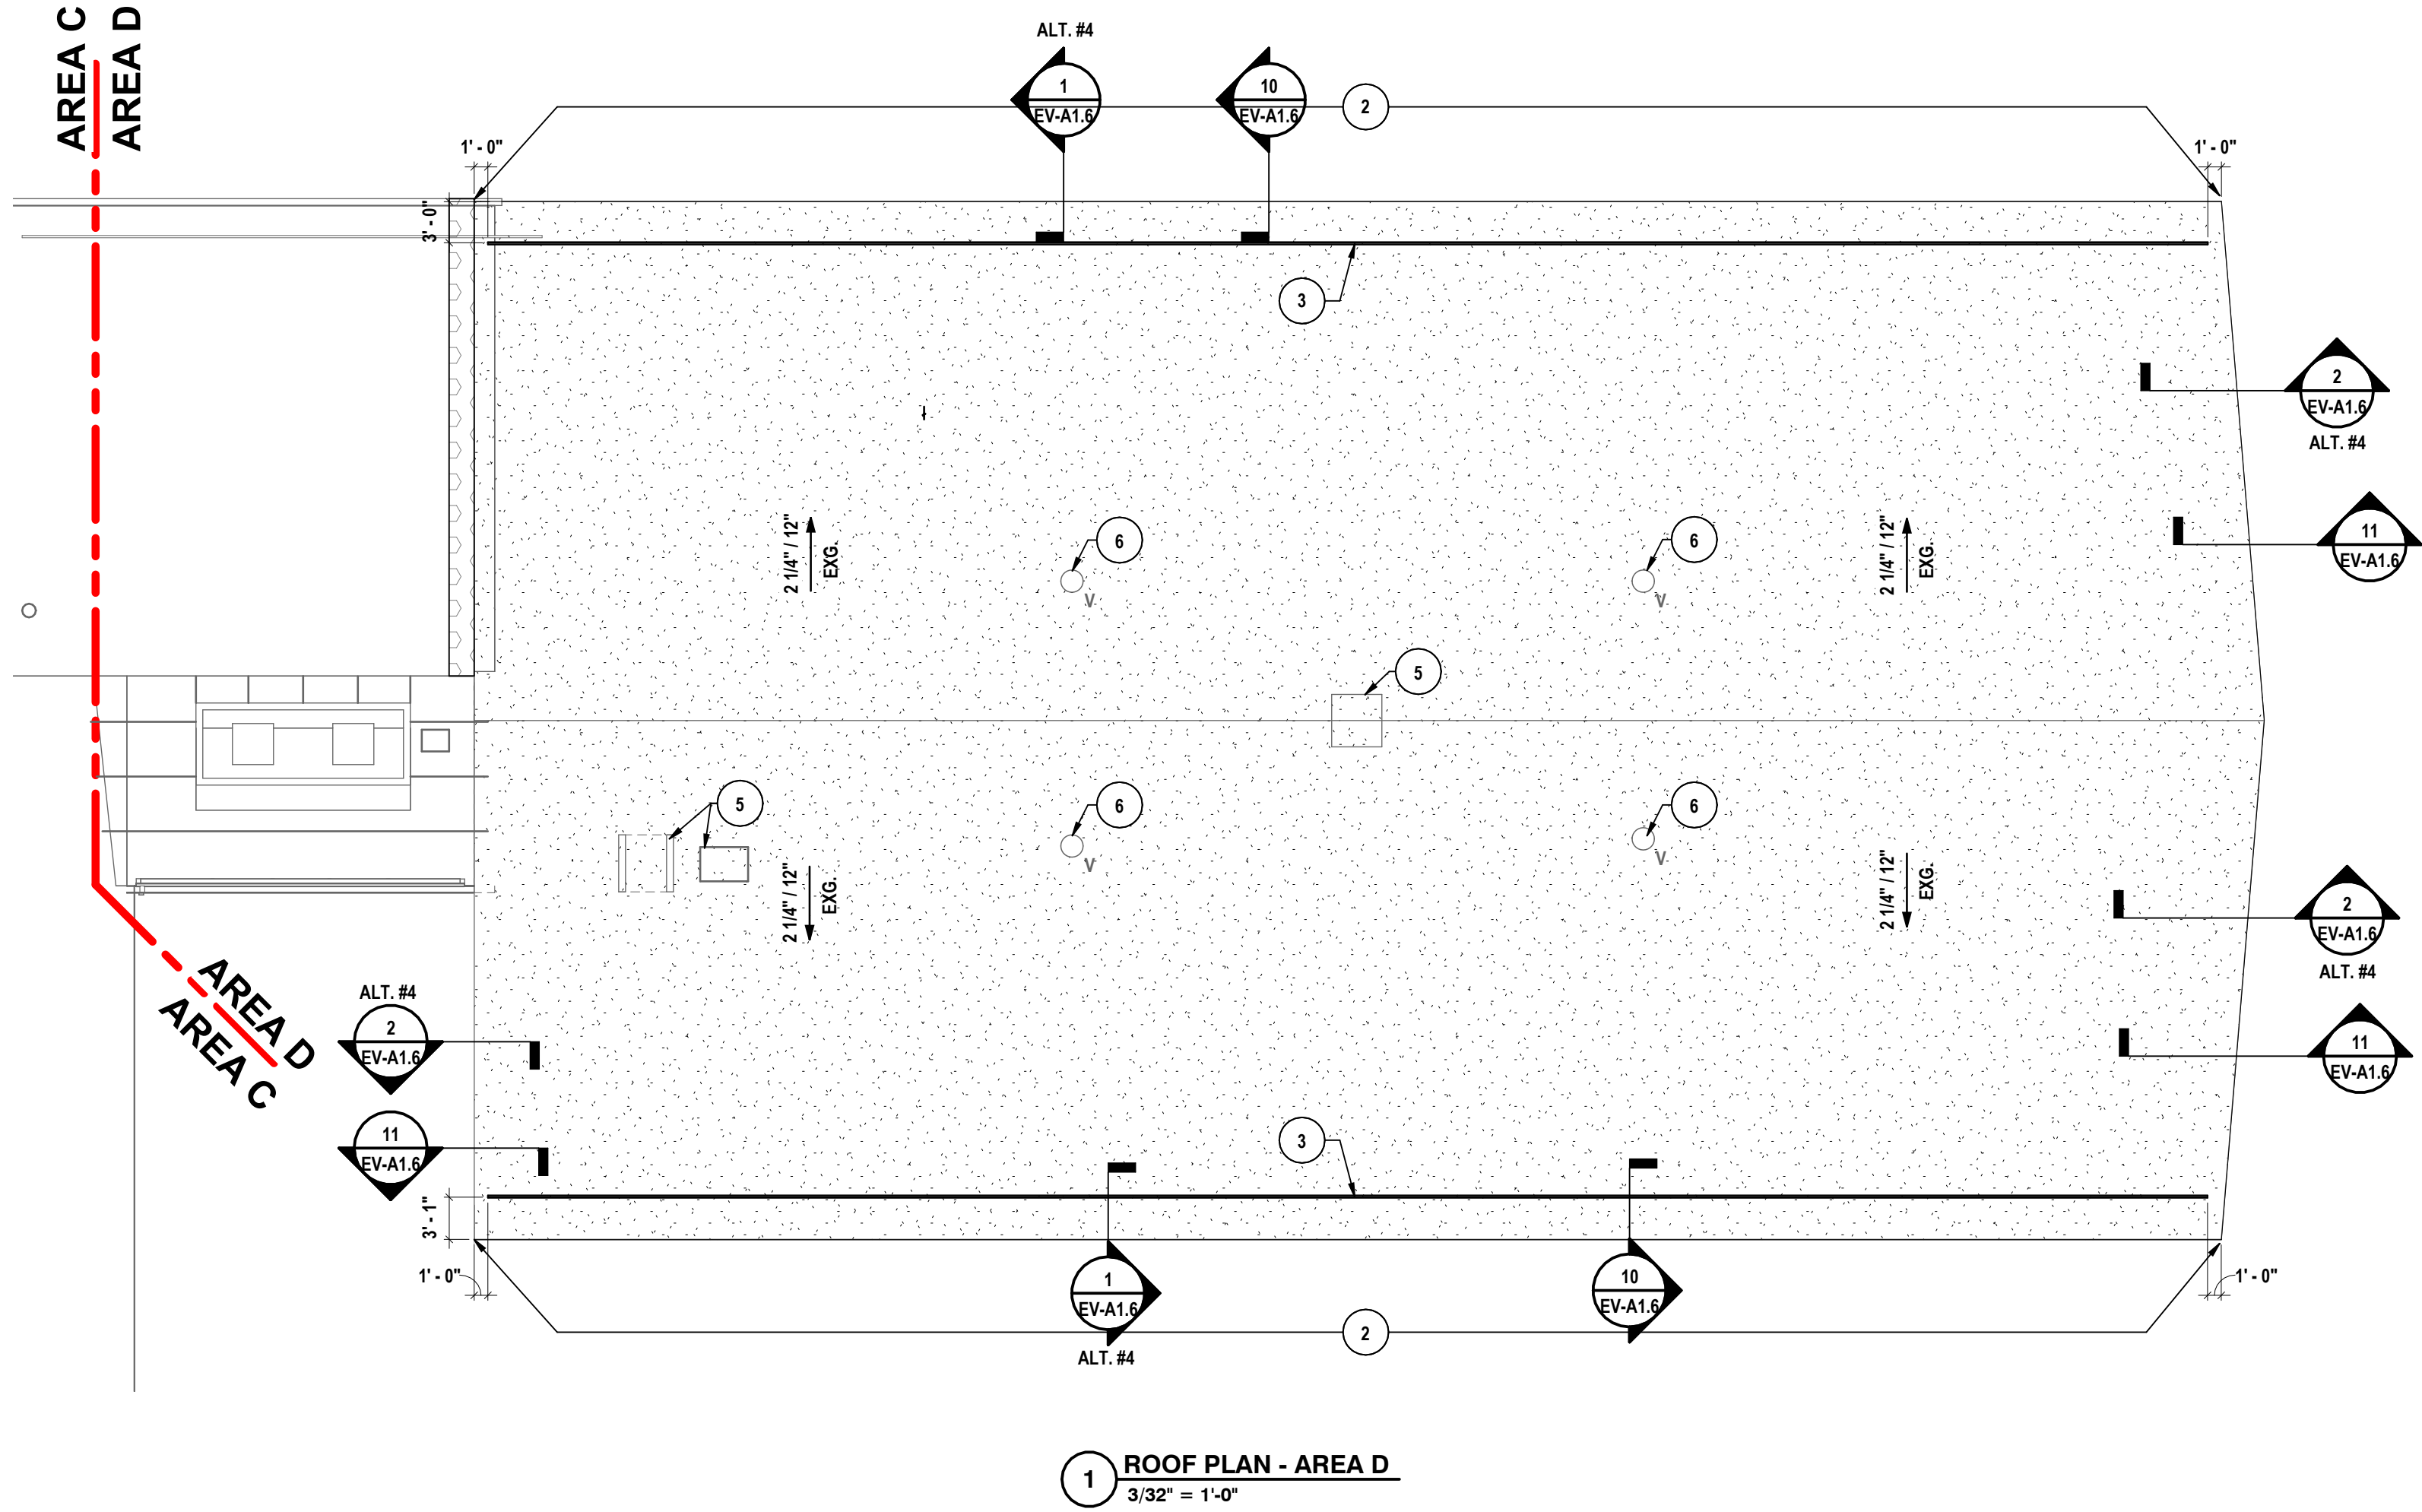

DRAWN BY: CAM		CHECKED BY: SZ	
DATE: 03/17/2026		PHASE: CP	
REVISION: 1		DATE: 10/22/2025	
ISSUE FOR BID		DATE: 10/22/2025	

IT IS A VIOLATION OF THE LAW FOR ANY PERSON TO MAKE UNAUTHORIZED ALTERATIONS OR ADDITIONS TO PLANS BEARING A LICENSED ENGINEER'S ARCHITECT'S OR SURVEYOR'S SEAL.

HUNT ENGINEERS | ARCHITECTS | SURVEYORS

ALBANY, NY • BINGHAMTON, NY • HORSEHEADS, NY • ROCHESTER, NY
AUGUSTA, NY • ELIZABETH, NY • ITHACA, NY • NEW YORK, NY
WWW.HUNT-EAS.COM 887-358-1000
NY CERTIFICATE NO. 0016320 PA CERTIFICATE NO. TSC220313464-1

ROOF PLAN - AREA B & AREA D

2025 ERWIN VALLEY ELEM & ADMIN BUILDING ALTERATIONS


CORNING-PAINTED POST ASD

16 BEARTOWN ROAD, PAINTED POST, NY 14870


EV-A1.5

PROJECT NO: 2649-160


BASE BID ROOF DETAILS

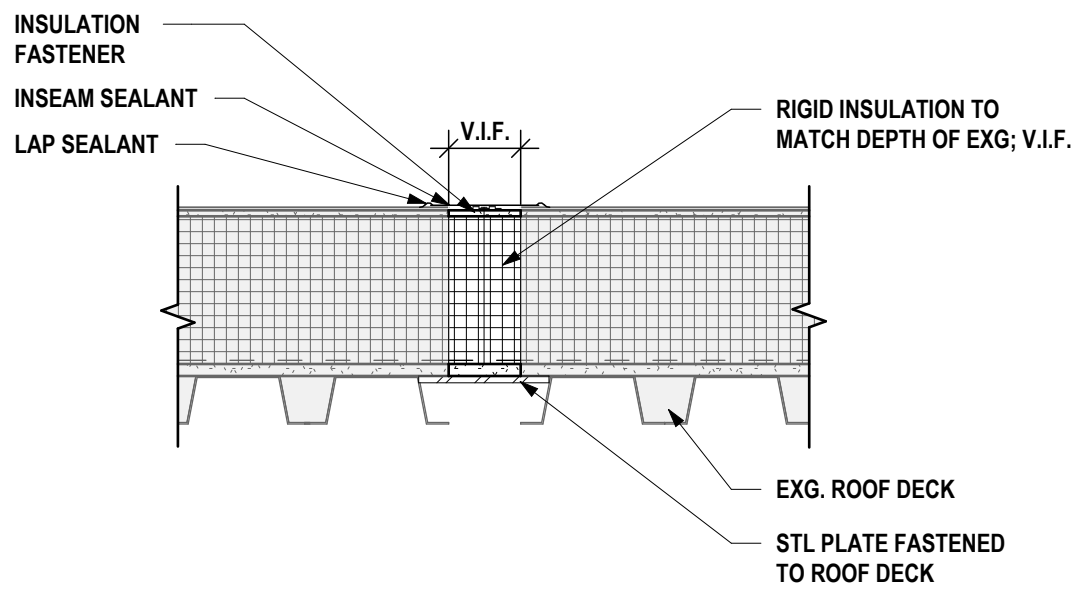


19 EXISTING OPENING INFILL
1 1/2" = 1'-0"

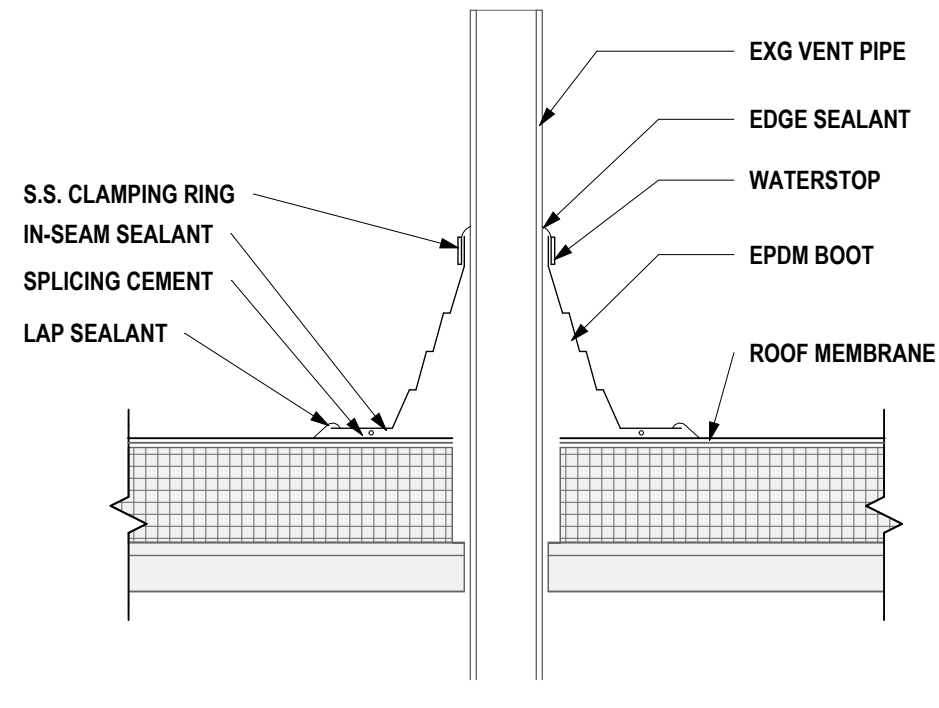


18 VENT PIPE DETAIL
1 1/2" = 1'-0"

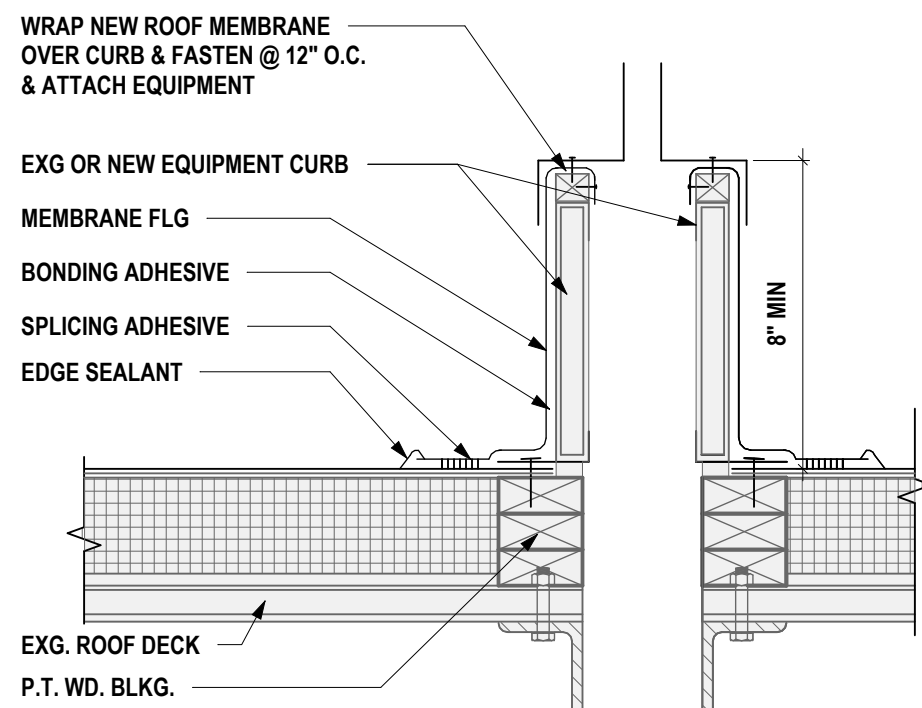


17 TYPICAL CURB DETAIL
1 1/2" = 1'-0"

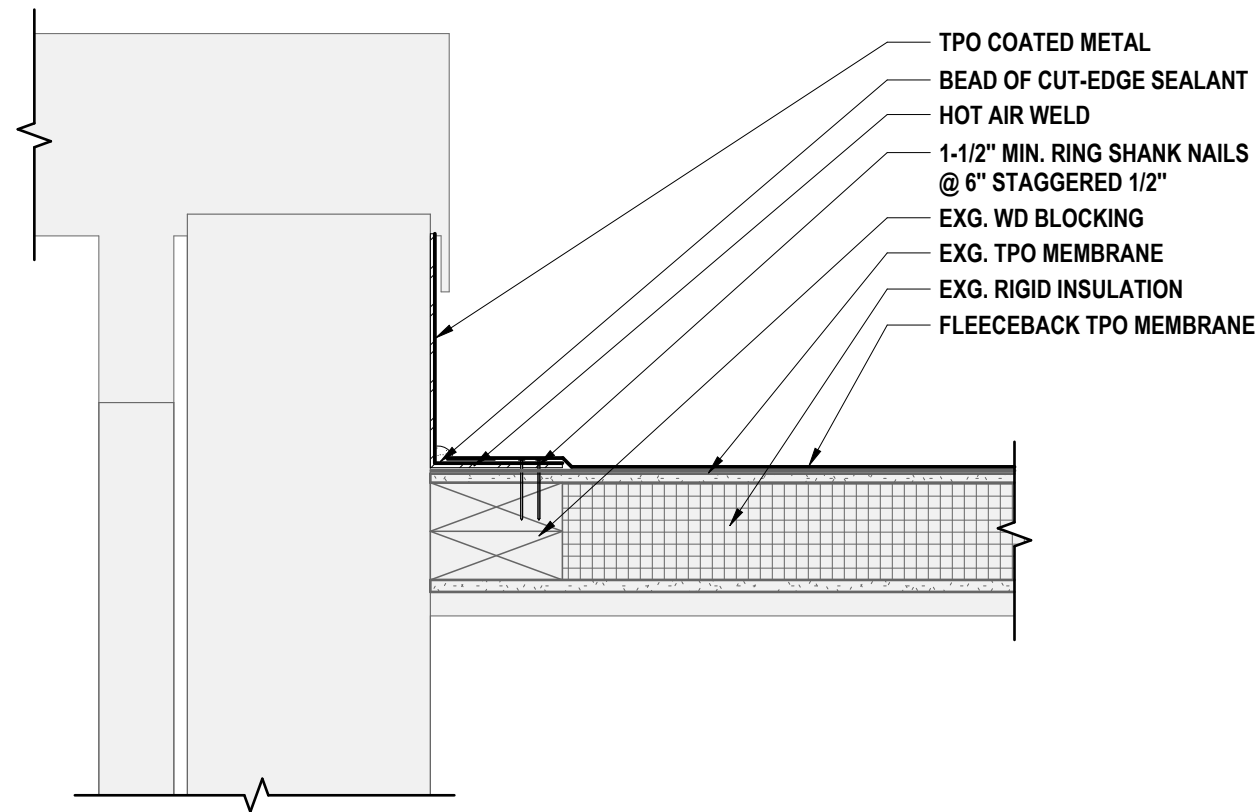


16 ROOF EDGE @ EXG. ENTRY ROOF
1 1/2" = 1'-0"

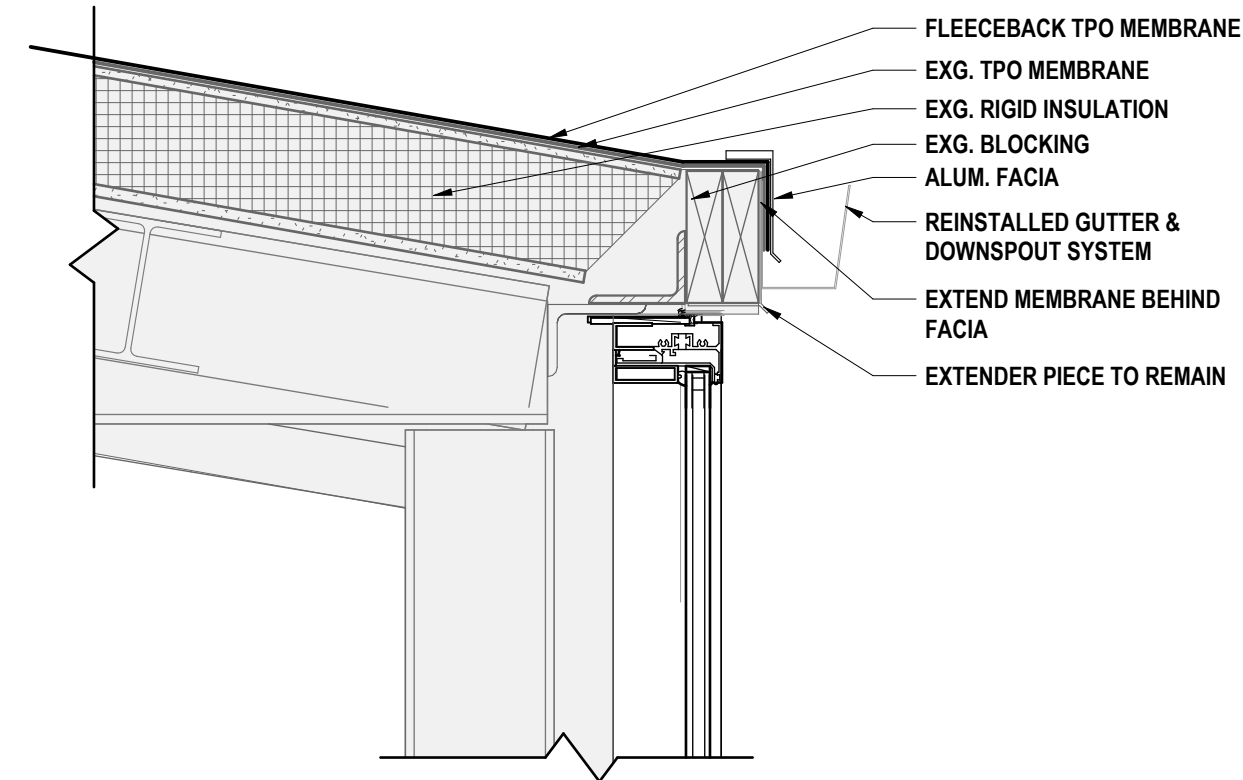


15 ROOF EDGE @ GYMNASIUM - B
1 1/2" = 1'-0"

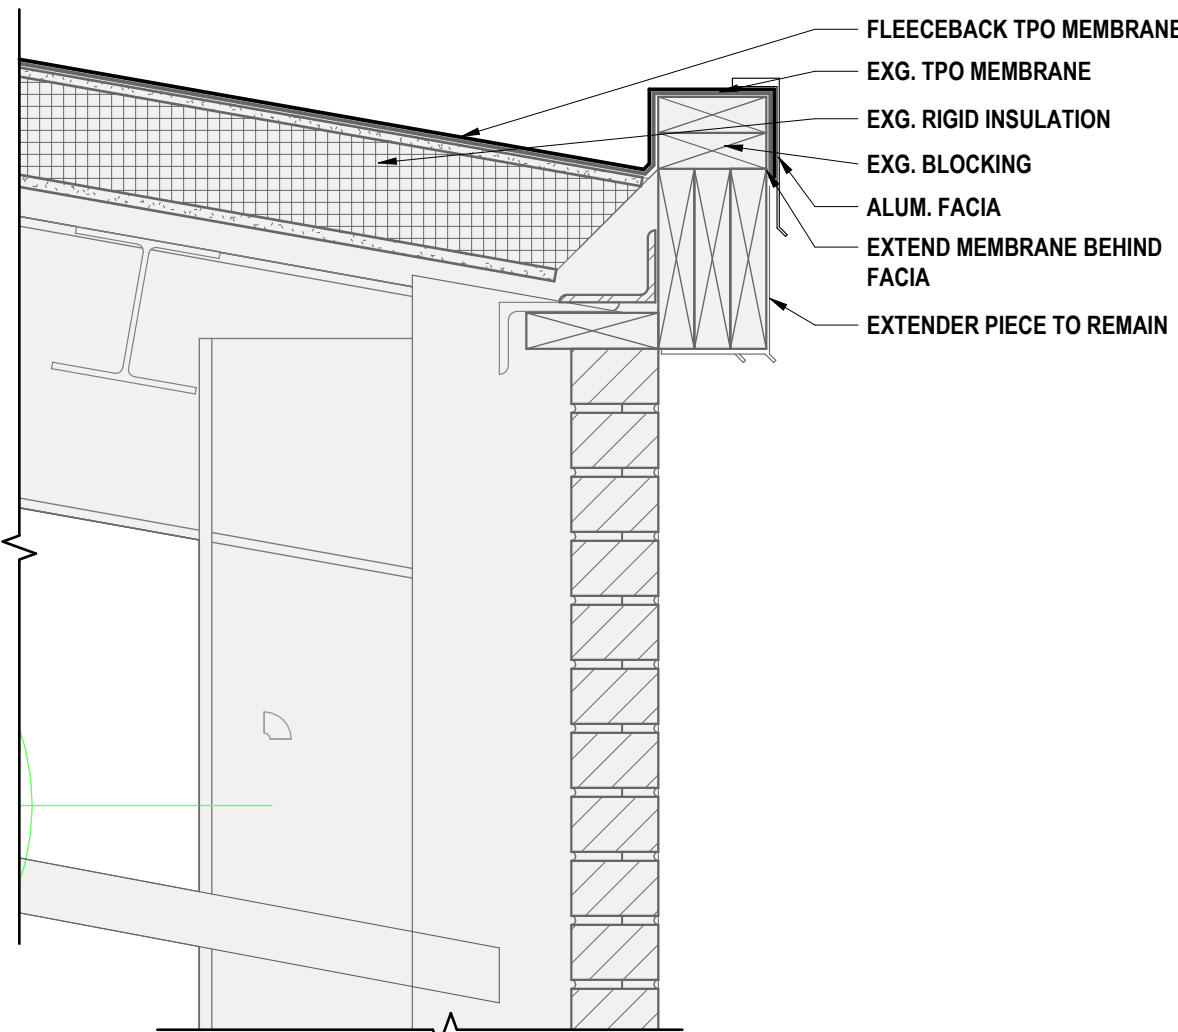


14 ROOF EDGE @ CAFETERIA - C
1 1/2" = 1'-0"

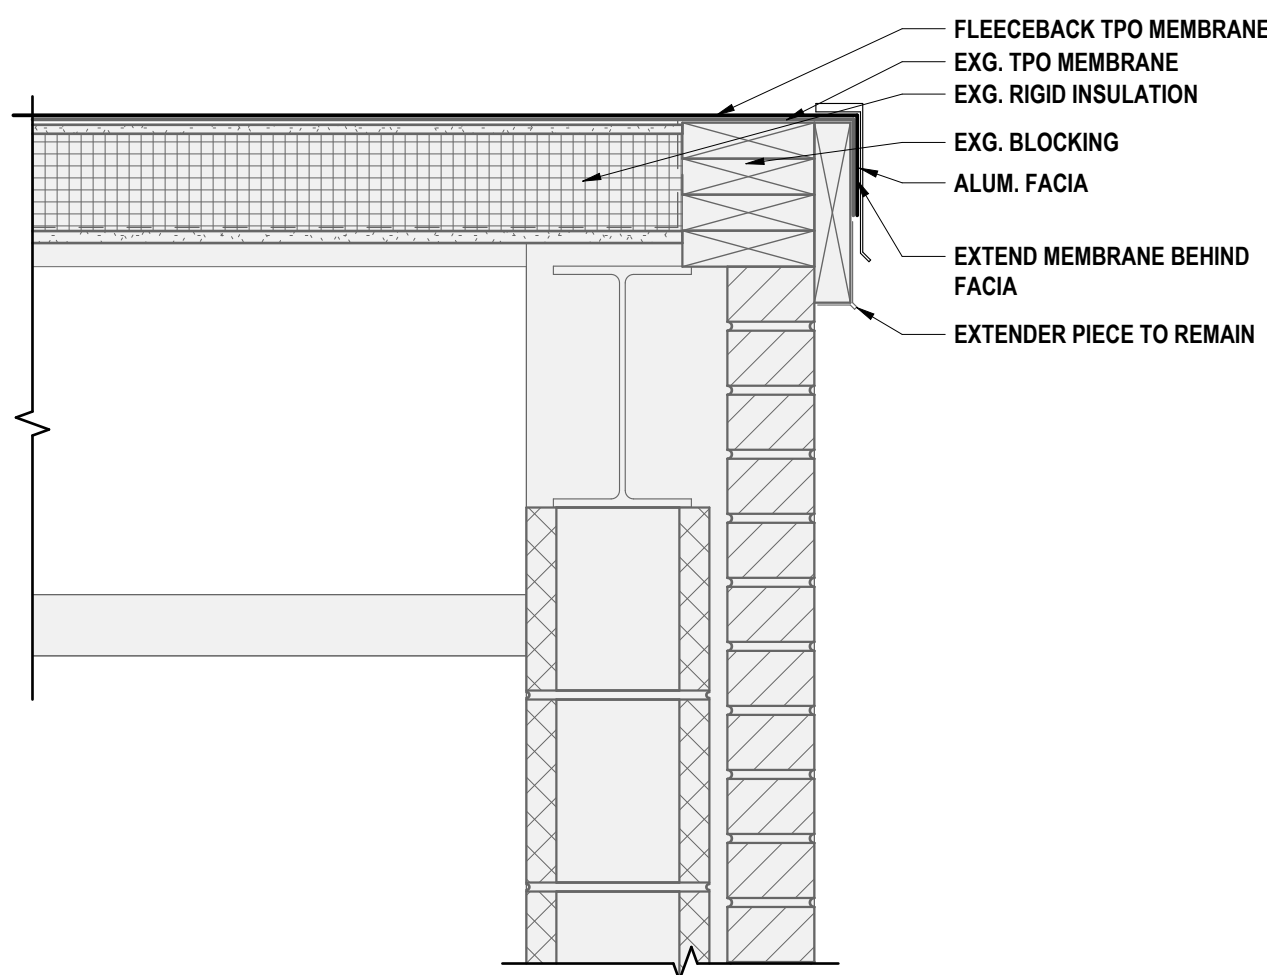


13 ROOF EDGE @ CAFETERIA - B
1 1/2" = 1'-0"

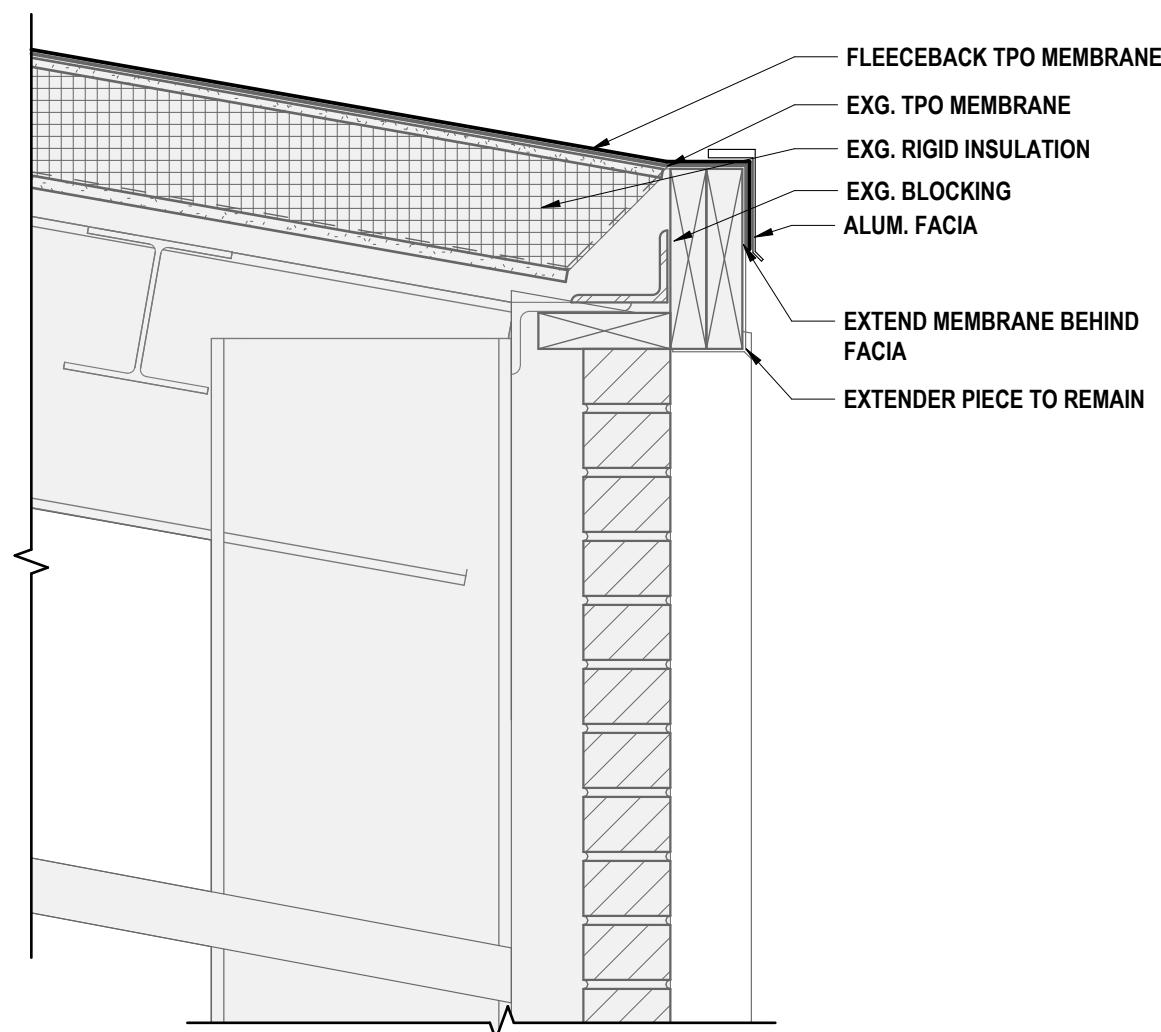

12 ROOF EDGE @ CAFETERIA - A
1 1/2" = 1'-0"

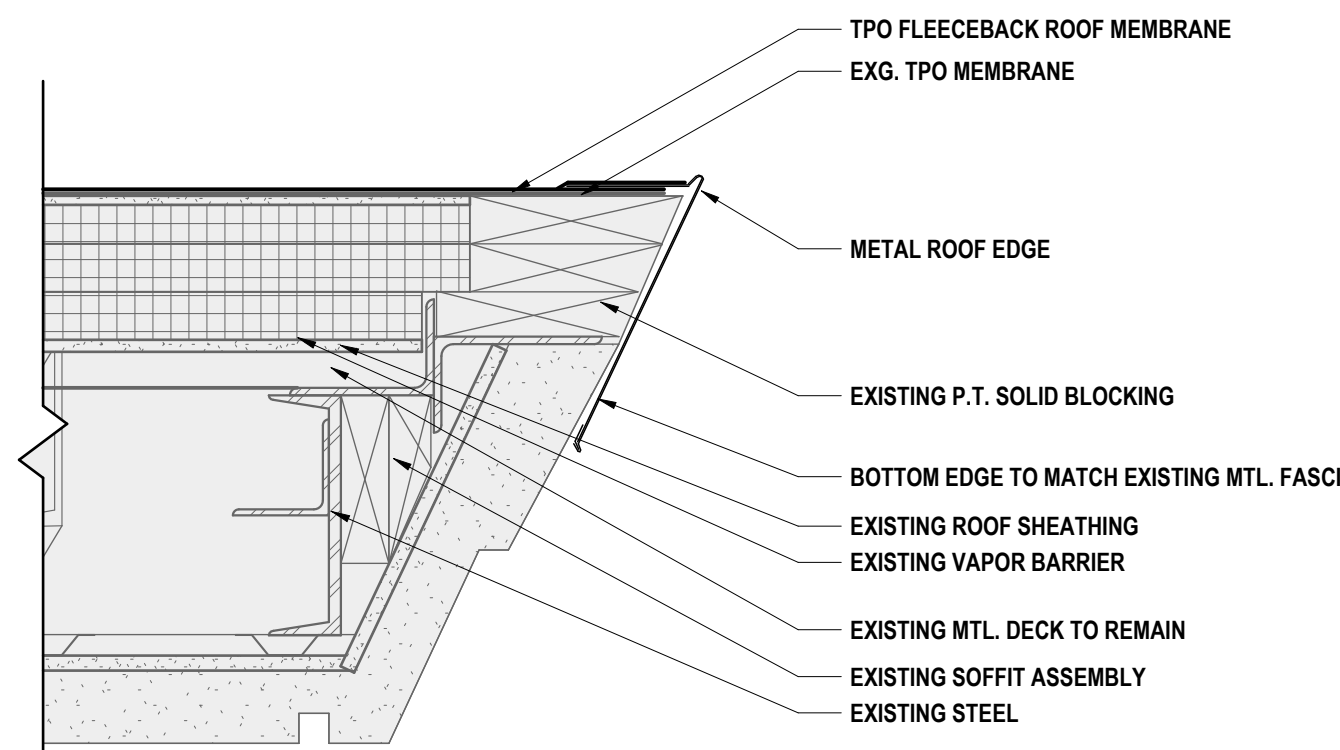


11 ROOF EDGE @ EXISTING ROOF RAKE
1 1/2" = 1'-0"

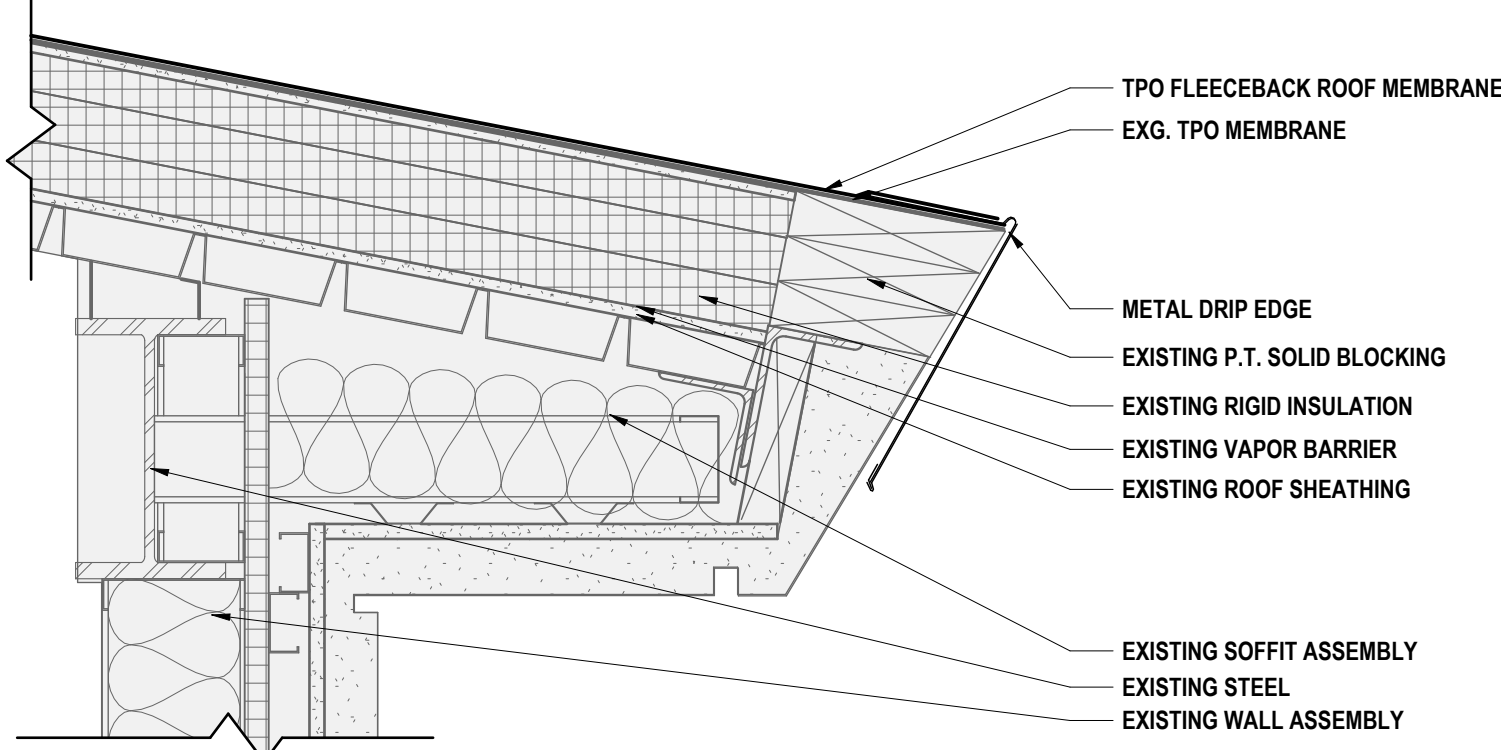


10 ROOF EDGE @ EXISTING ROOF FACIA
1 1/2" = 1'-0"


ALTERNATE #4 ROOF DETAILS

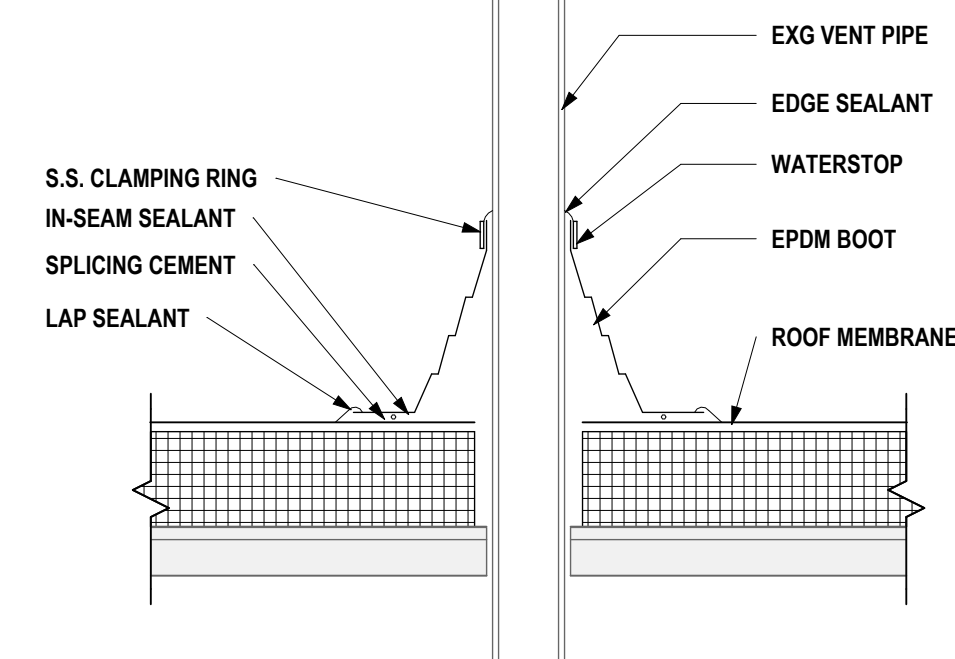


9 VENT PIPE DETAIL (ALT. #4)
1 1/2" = 1'-0"

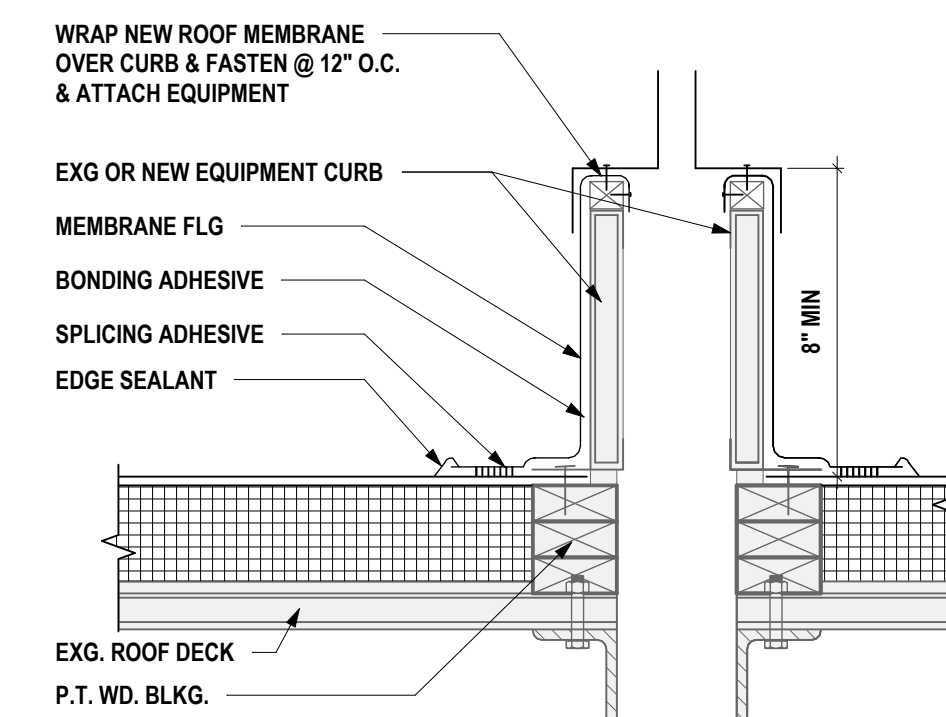


8 TYPICAL CURB DETAIL (ALT. #4)
1 1/2" = 1'-0"

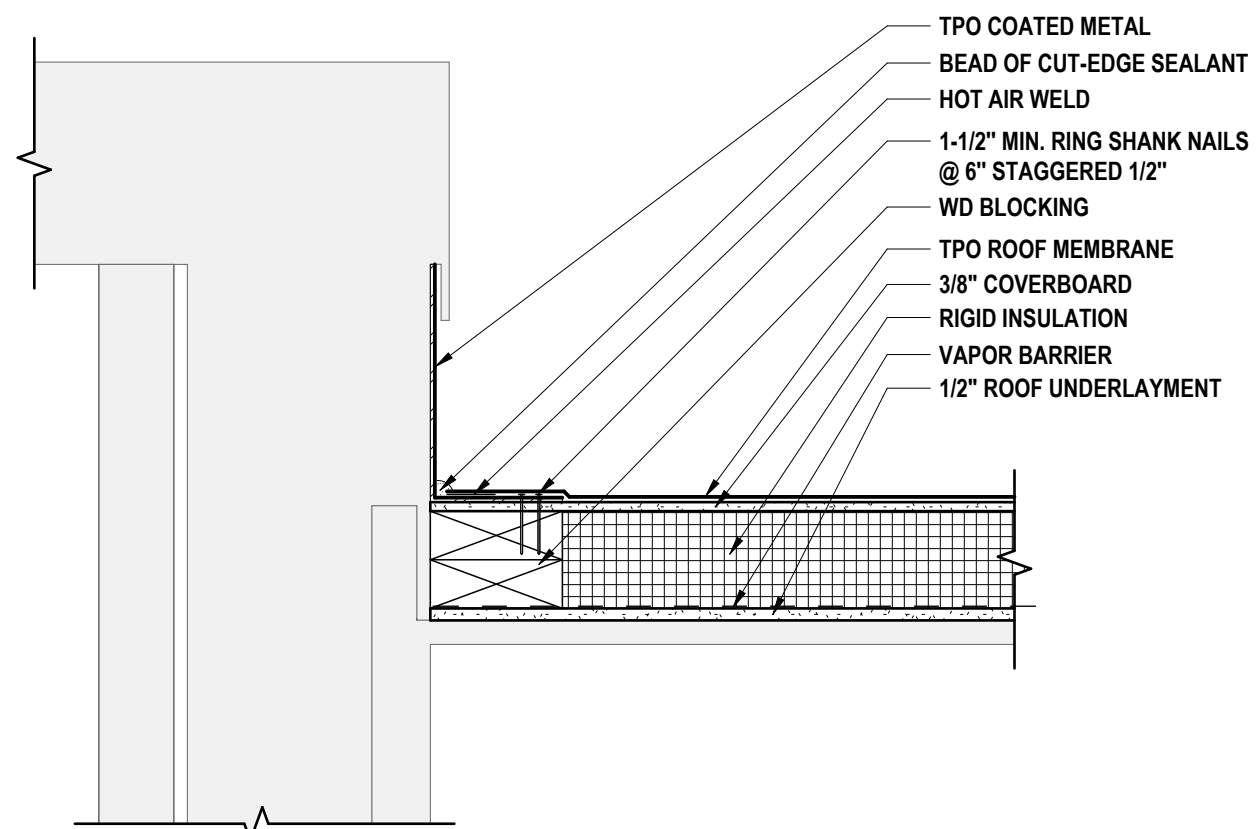


7 ROOF EDGE @ EXG. ENTRY ROOF (ALT. #4)
1 1/2" = 1'-0"

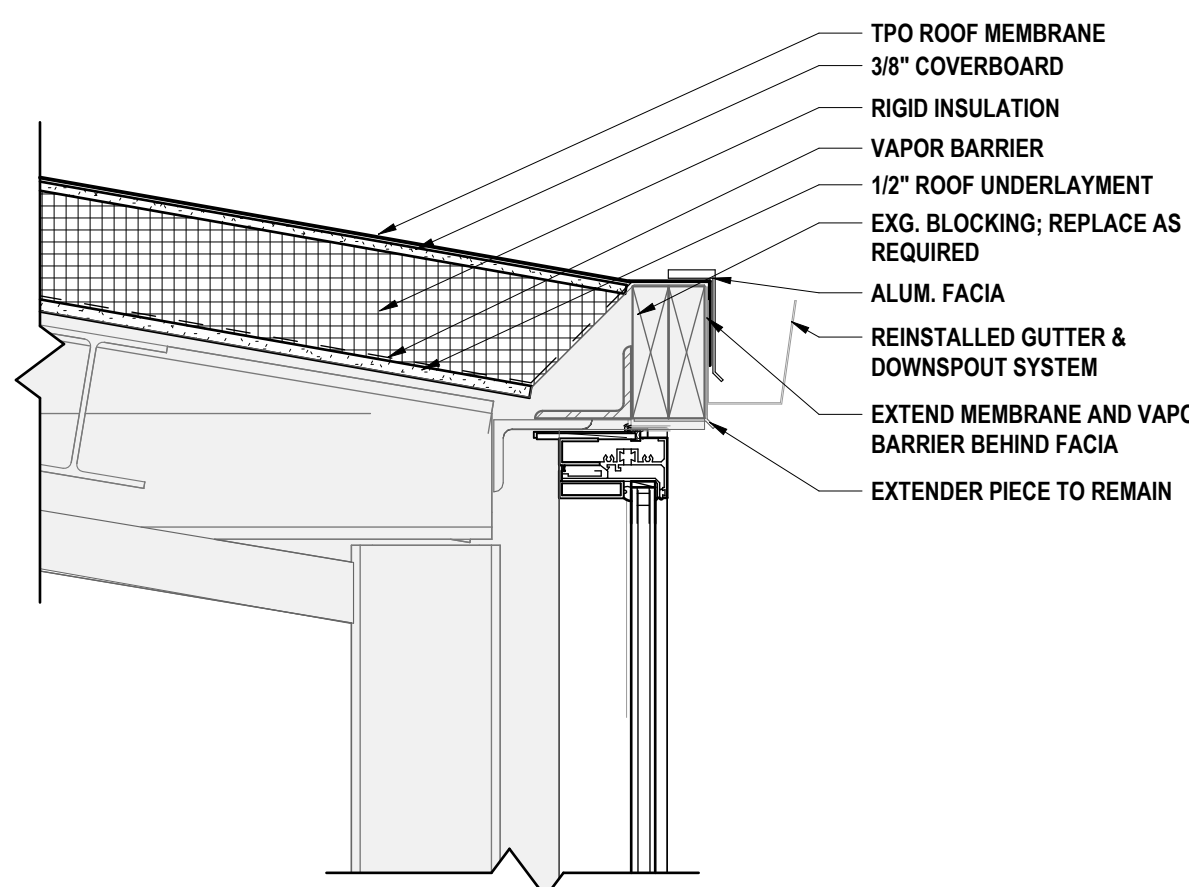


6 ROOF EDGE @ GYMNASIUM - B (ALT. #4)
1 1/2" = 1'-0"

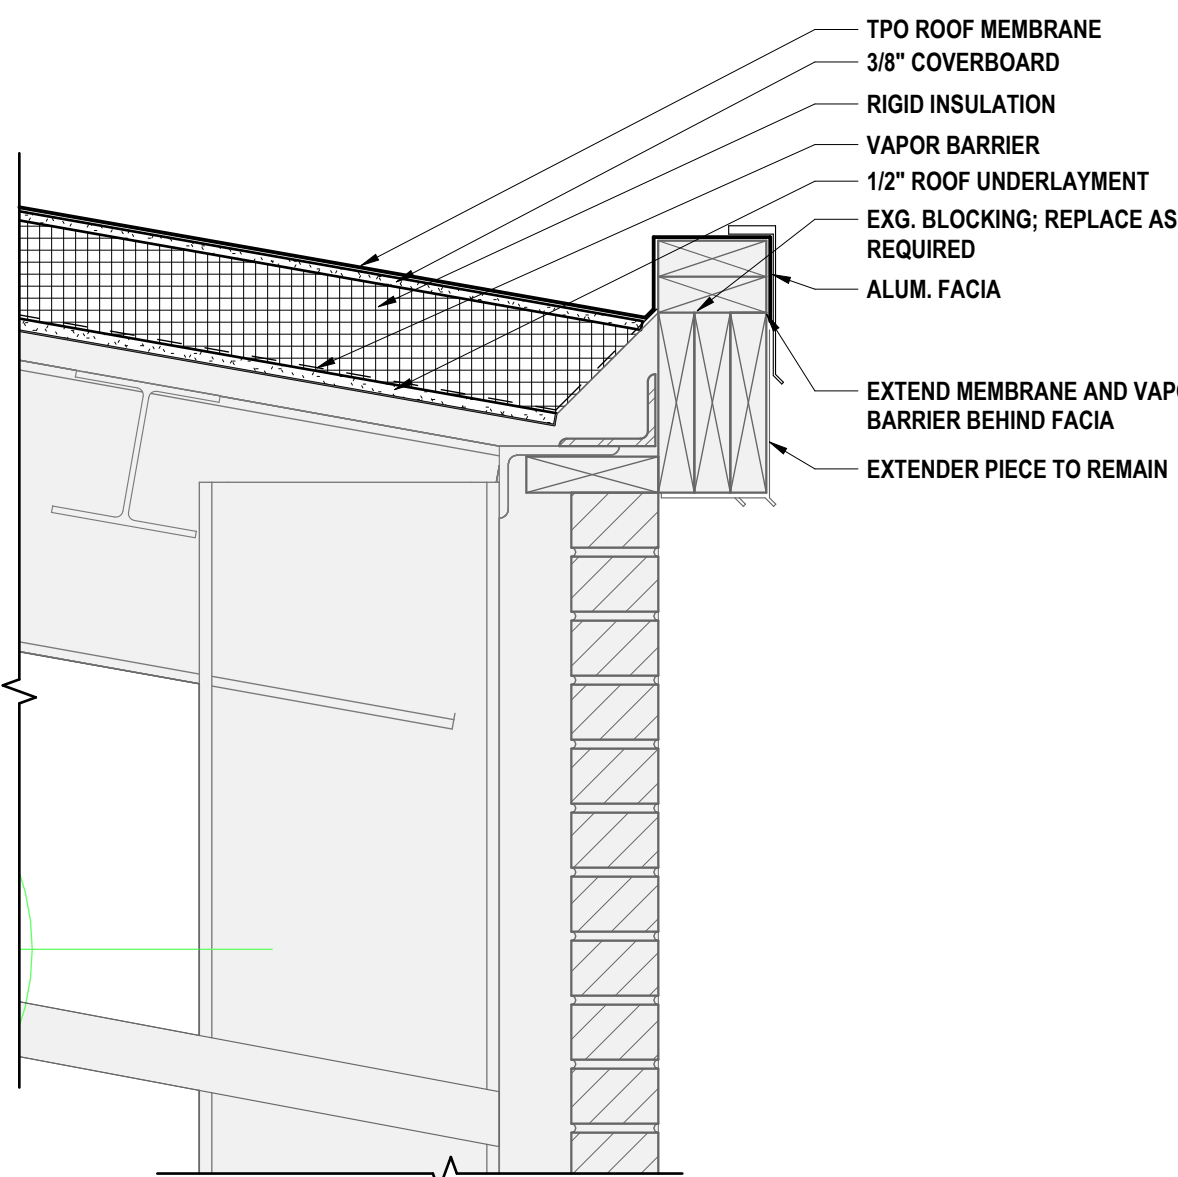


5 ROOF EDGE @ CAFETERIA - C (ALT. #4)
1 1/2" = 1'-0"

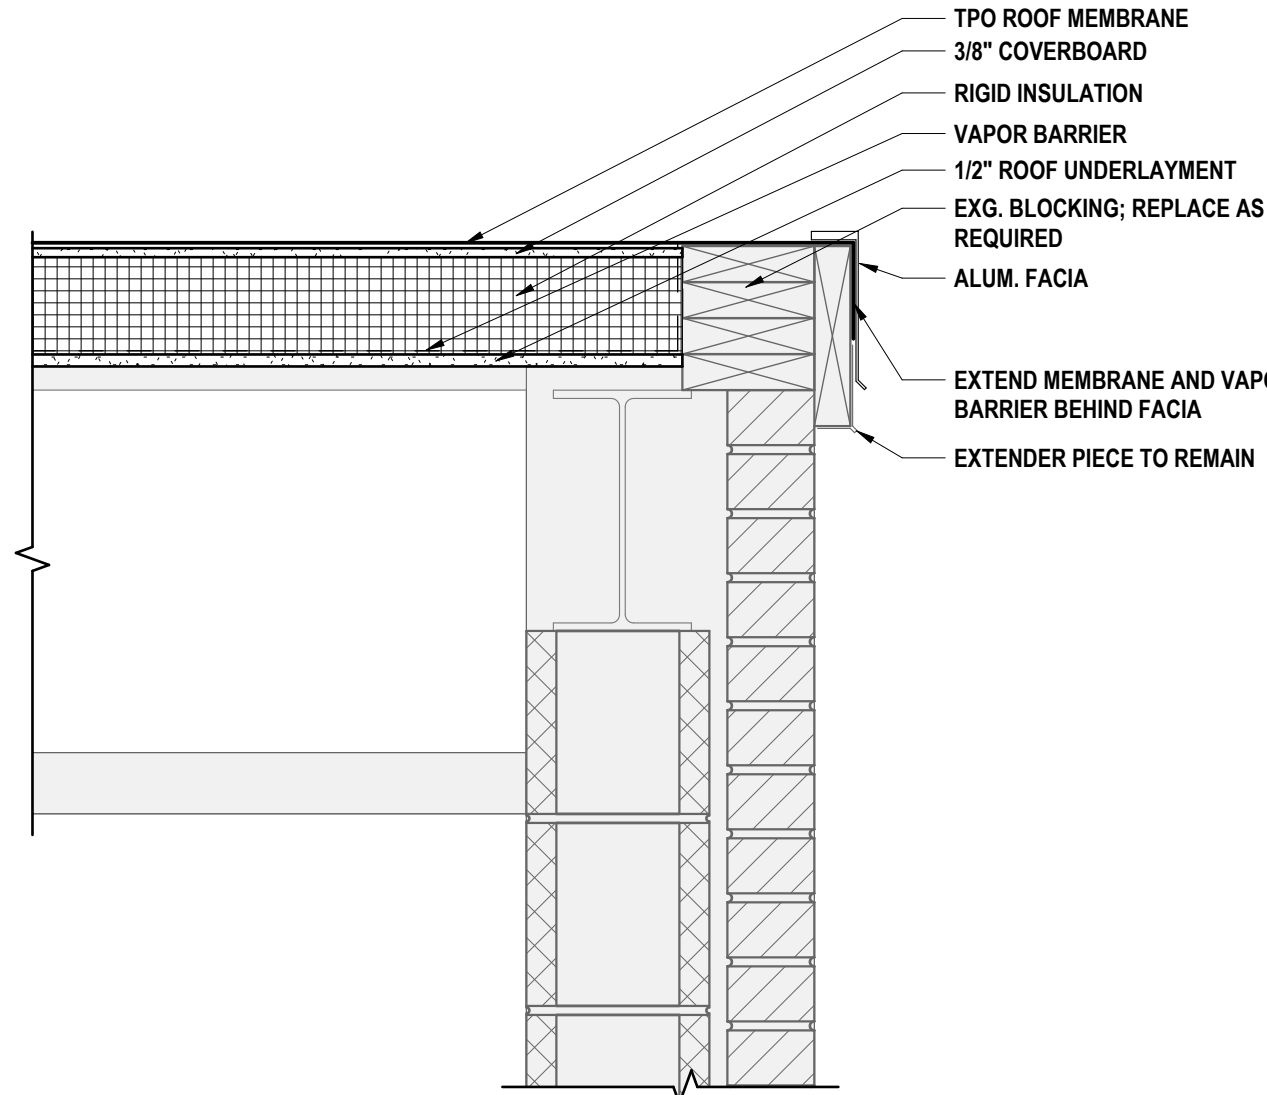


4 ROOF EDGE @ CAFETERIA - B (ALT. #4)
1 1/2" = 1'-0"

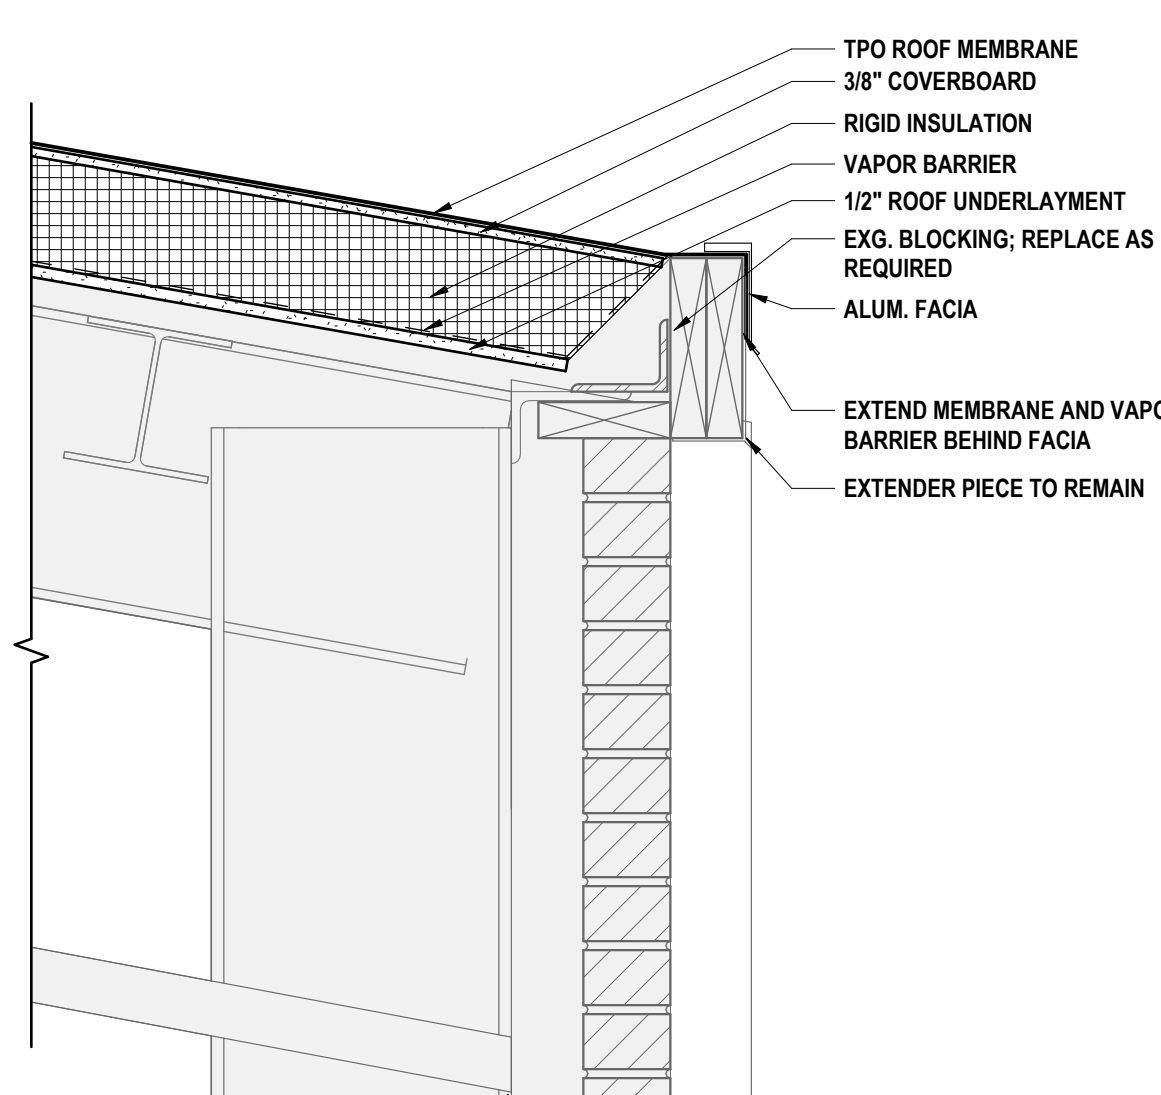

3 ROOF EDGE @ CAFETERIA - A (ALT. #4)
1 1/2" = 1'-0"

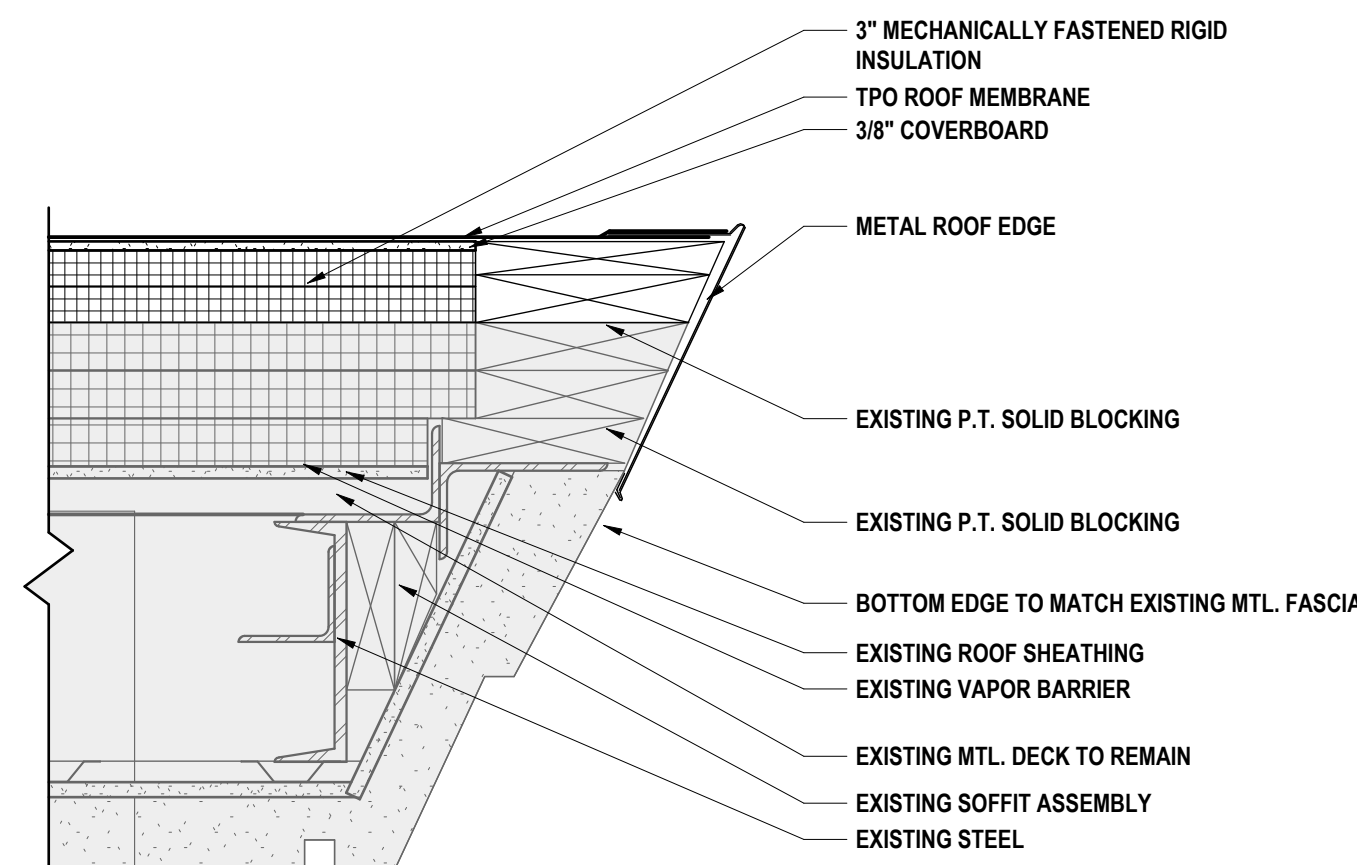

2 ROOF EDGE @ EXISTING ROOF RAKE (ALT. #4)
1 1/2" = 1'-0"

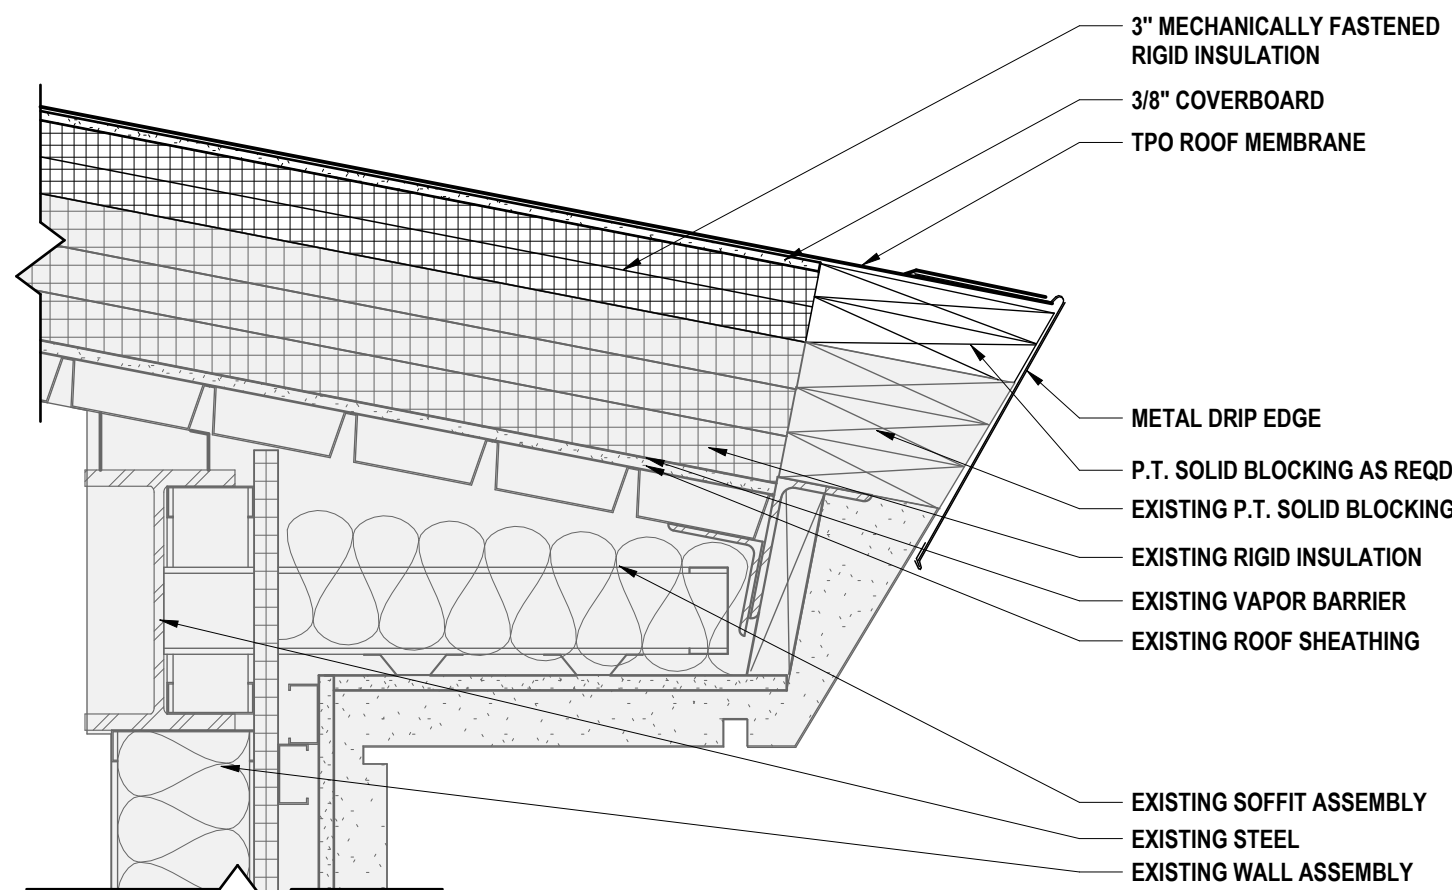

1 ROOF EDGE @ EXISTING ROOF FACIA (ALT. #4)
1 1/2" = 1'-0"

SED #ERWIN VALLEY 15-10-00-01-000-007; ADMIN BUILDING 15-10-00-01-001-013

ROOF DETAILS

2025 ERWIN VALLEY ELEM & ADMIN BUILDING ALTERATIONS
CORNING-PAINTED POST ASD

16 BEARTOWN ROAD, PAINTED POST NY 14870


HUNT

ENGINEERS | ARCHITECTS | SURVEYORS

ALBANY, NY • BINGHAMTON, NY • HORSENEADS, NY • ROCHESTER, NY
ROSENTHAL, NY • SENECA FALLS, NY • SYRACUSE, NY
WWW.HUNT-EAS.COM 807-358-1000

NY CERTIFICATE NO. 0016320 PA CERTIFICATE NO. TSC22031464-1

DATE:	1 10/2/2026	REVISION:	ISSUE FOR BID
PHASE:		CHECKED BY:	SZ
		DATE:	03/17/2026
		PHASE:	CD
		DRAWN BY:	CAM
		CHECKED BY:	SZ
		DATE:	03/17/2026
		PHASE:	CD
			Copyright 2025
			"IT IS A VIOLATION OF THE LAW FOR ANY PERSON TO MAKE UNAUTHORIZED ALTERATIONS OR ADDITIONS TO PLANS BEARING A LICENSED ENGINEER'S ARCHITECT'S OR SURVEYOR'S SEAL."

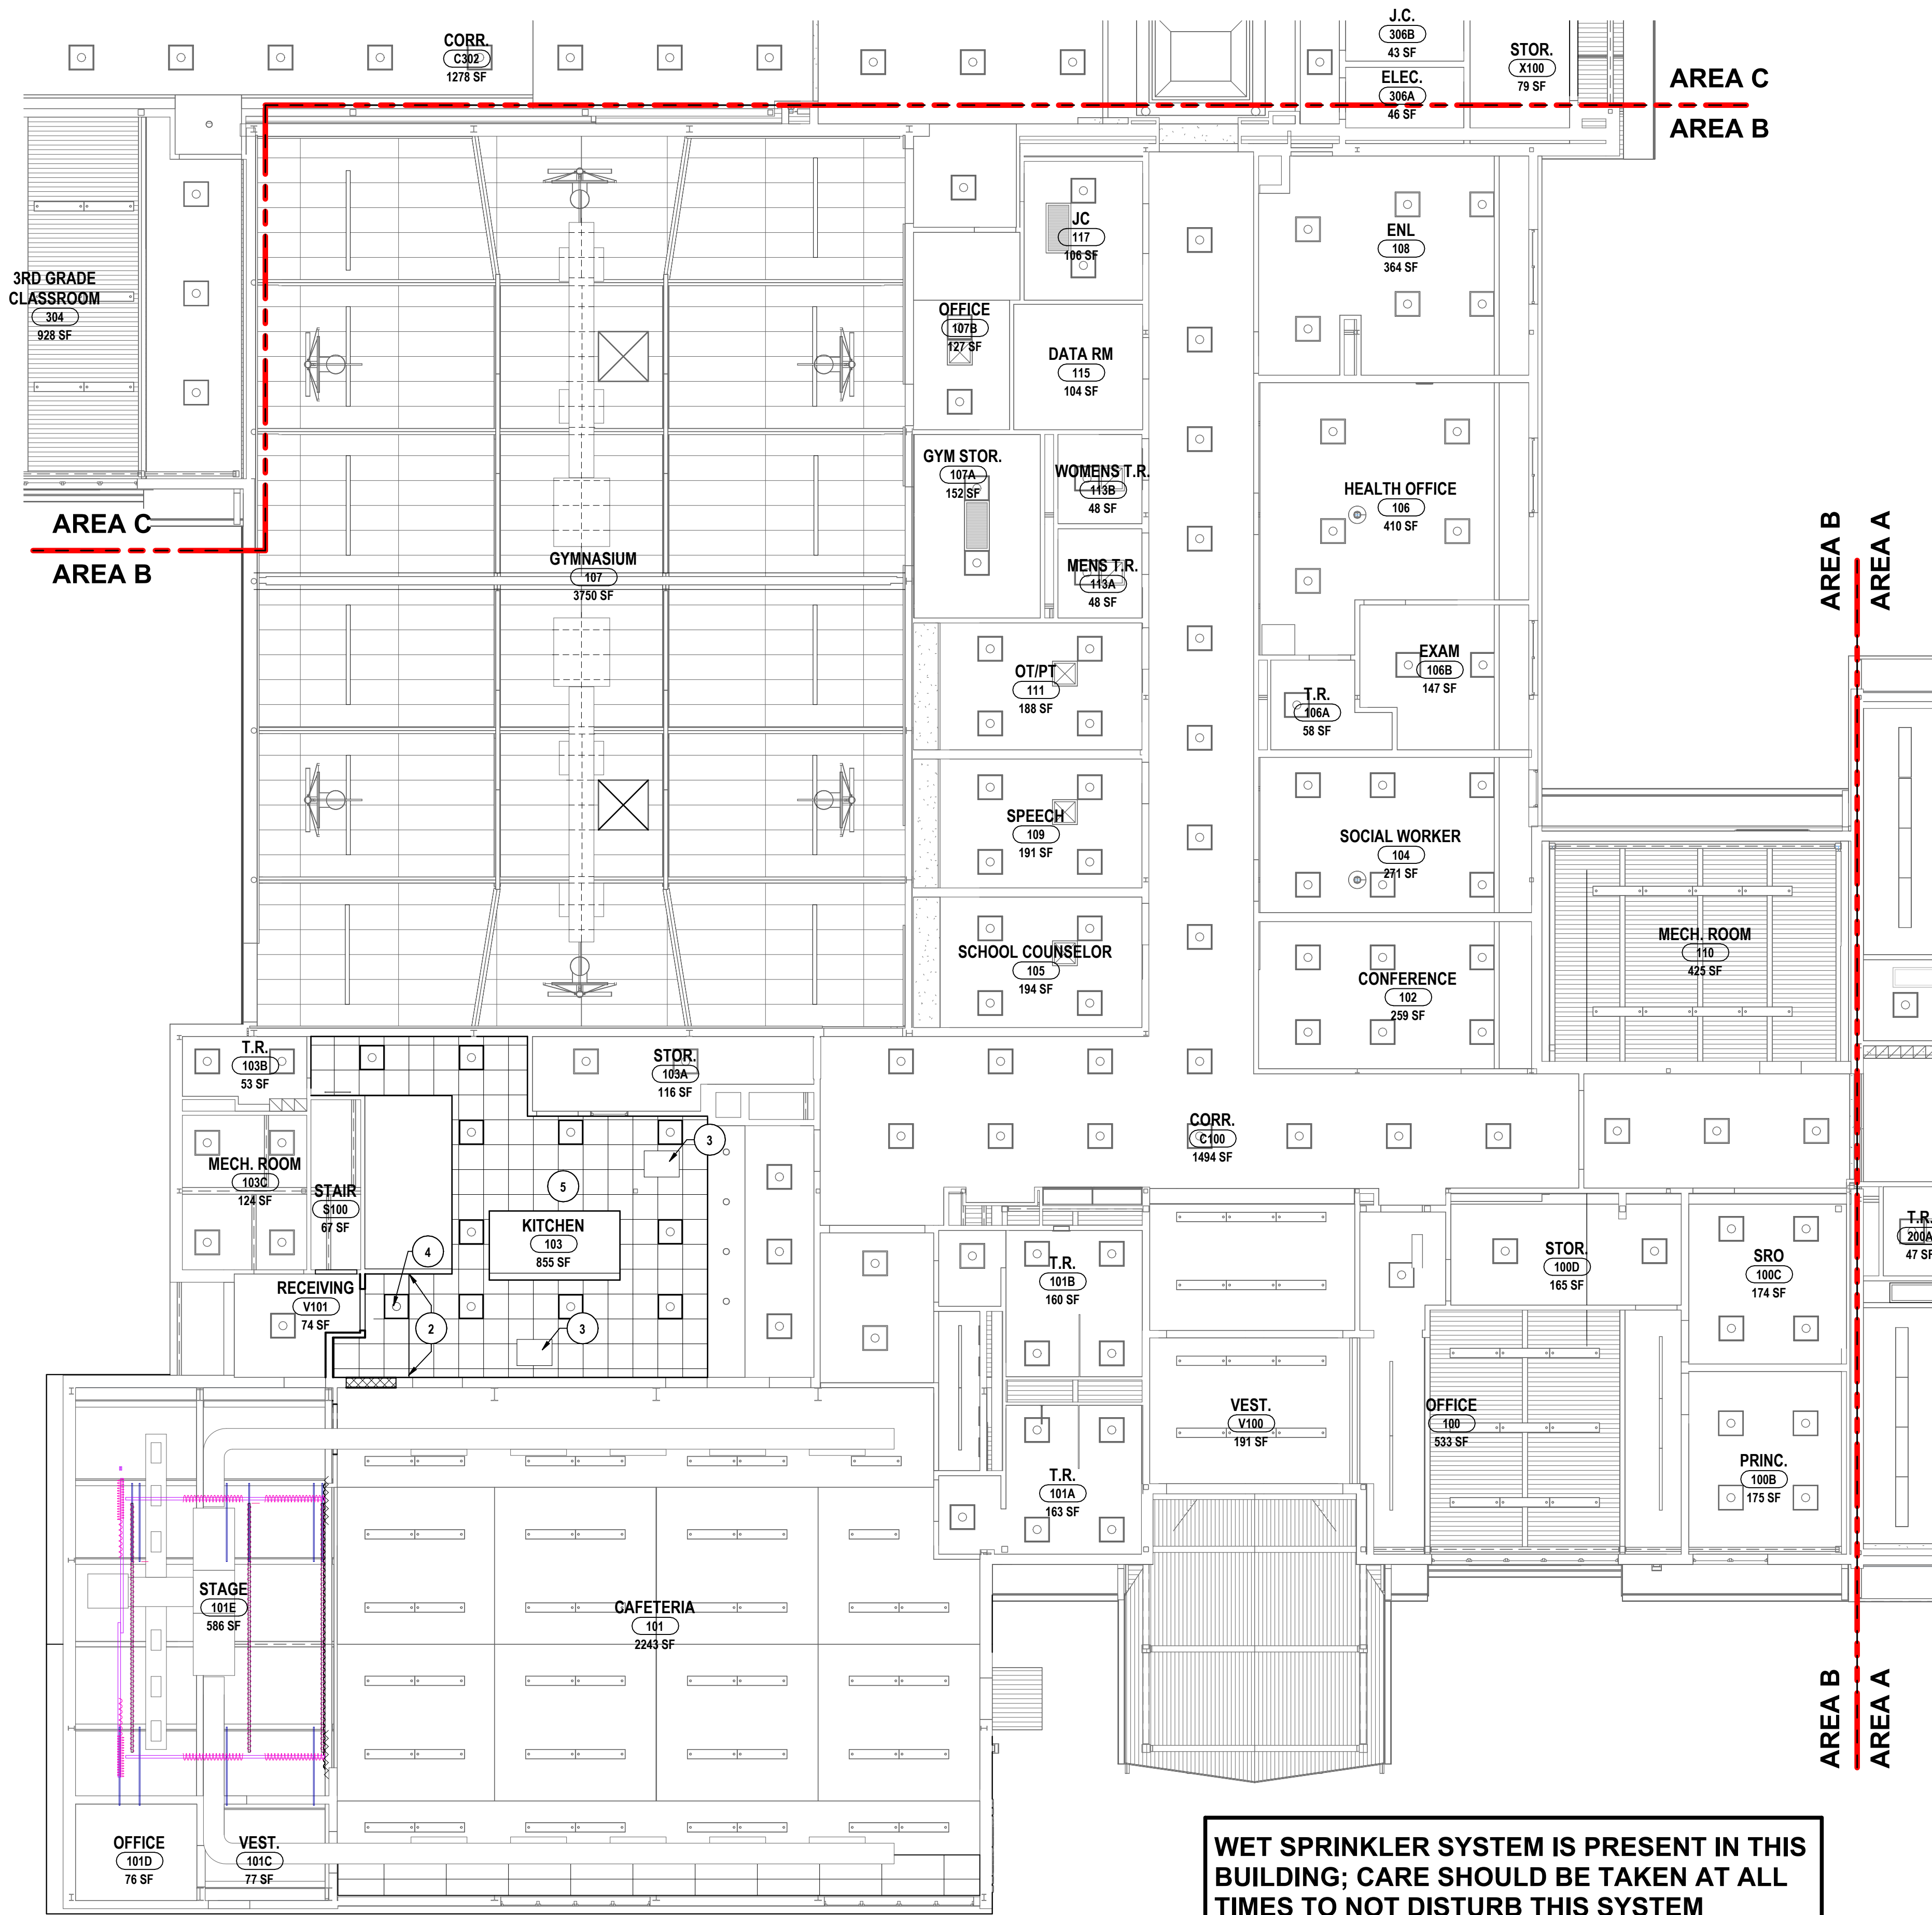

1 FIRST FLOOR REFLECTED CEILING PLAN - AREA B
1/8" = 1'-0"

GENERAL CEILING NOTES:

- A ALL CEILINGS TO BE 9'-0" A.F.F. UNLESS NOTED OTHERWISE.
B ALL SOFFITS TO BE 2" LOWER THAN CEILING HEIGHT UNLESS NOTED OTHERWISE.
C CENTER ALL MECHANICAL PENETRATIONS & ELECTRICAL DEVICES WITHIN 2X2 CEILING TILE.
D REFER TO FINISH SCHEDULE FOR INDIVIDUAL CEILING TYPES.
E VERIFY IN FIELD THE AMOUNT OF EXISTING LIGHTS TO BE REMOVED AND REINSTALLED.
F ALL NEW CEILING SYSTEMS TO BE INSTALLED DIRECTLY TO STRUCTURE.
G CENTER ALL MECHANICAL PENETRATIONS AND ELECTRICAL DEVICES WITHIN CEILING TILES. UNLESS NOTED OTHERWISE.
H COORDINATE ALL MECHANICAL DUCTWORK, PIPING, SPRINKLER LINES & CABLE TRAY TO AVOID CONFLICTS WITH LIGHTS AND STRUCTURE.
I ARCHITECTURAL DRAWINGS TAKE PRECEDENCE OVER ENGINEERING DRAWINGS FOR LOCATION OF LIGHT FIXTURES. SEE ELECTRICAL DRAWINGS FOR ALL FIXTURES.
J ARCHITECTURAL DRAWINGS TAKE PRECEDENCE OVER ENGINEERING DRAWINGS FOR LOCATION OF MECHANICAL LOUVERS. SEE MECHANICAL DRAWINGS FOR EQUIPMENT INFORMATION.
K WET SPRINKLER SYSTEM IS PRESENT IN THIS BUILDING; CARE SHOULD BE TAKEN AT ALL TIMES TO NOT DISTURB THIS SYSTEM.

RCP DRAWING NOTE:

- 1 ACT-2 TO BE 8'-0" A.F.F.
2 NEW CEILING TILES IN NEW CEILING GRID. INSTALL NEW CEILING, ACT-1, AT THE SAME HEIGHT AS THE EXG CEILING.
3 MECHANICAL UNIT MOUNTED FLUSH WITH CEILING. SEE "H" DWGS.
4 REINSTALL EXISTING LIGHT FIXTURE IN NEW LOCATION.
5 NEW CEILING GRID IN KITCHEN. INSTALL STORED EXISTING CEILING TILES IN NEW GRID. NEW ACT SYSTEM TO BE INSTALLED AT SAME HEIGHT AS EXISTING CEILING. REINSTALL ALL EXISTING FIXTURES IN ORIGINAL LOCATIONS IN NEW ACT SYSTEM.

RCP LEGEND

- INDICATES GYP BD OR PLASTER CEILING/SOFFIT
2'X2' TROFFERS LIGHT FIXTURE
DOWN LIGHT
LINEAR PENDANT MOUNTED DIRECT/INDIRECT LIGHT FIXTURE
HVAC RETURN
HVAC SUPPLY
HVAC EXHAUST
INDICATES ACT CEILING SYSTEM

		DRAWN BY: CAM	
		CHECKED BY: SZ	
		DATE: 03/17/2026	
		PHASE: CD	
#	DATE:	REVISION:	THIS IS ONE OF THE PLACES ANY PERSON TO HAVE UNAUTHORIZED ALTERATIONS OR ADDITIONS TO PLANS SIGNING A LICENSED PROFESSIONAL ARCHITECT'S OR SURVEYOR'S SEAL.
1	10/02/2026	ISSUE FOR BID	


"IT IS A VIOLATION OF THE LAW FOR ANY PERSON TO MAKE UNAUTHORIZED ALTERATIONS OR ADDITIONS TO PLANS BEARING A LICENSED ENGINEER'S ARCHITECT'S OR SURVEYOR'S SEAL."

HUNT ENGINEERS | ARCHITECTS | SURVEYORS
ALBANY, NY • BINGHAMTON, NY • HORSENEAR, NY • ROCHESTER, NY
WWW.HUNT-EAS.COM 807-358-1000
NY CERTIFICATE NO. 0016220 PA CERTIFICATE NO. TSC220313464-1


REFLECTED CEILING PLAN - AREA B
2025 ERWIN VALLEY ELEM & ADMIN BUILDING ALTERATIONS
CORNING-PAINTED POST ASD
16 BEARTOWN ROAD, PAINTED POST NY 14870

EV-A2.1

PROJECT NO: 2649-160

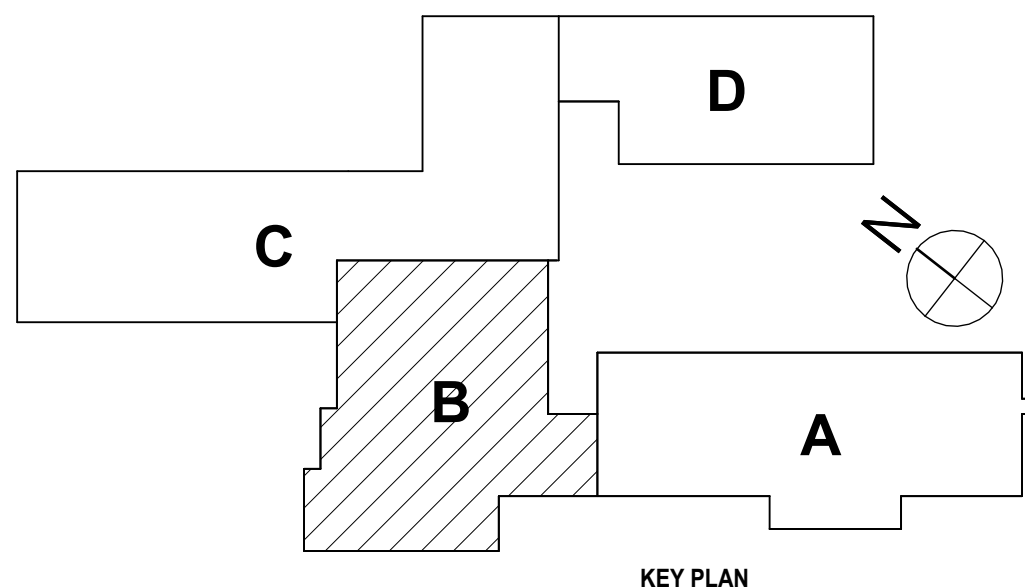

SED #ERWIN VALLEY 15-10-0001-0-000427; DOWN BUILDING 15-10-0001-1-001-013

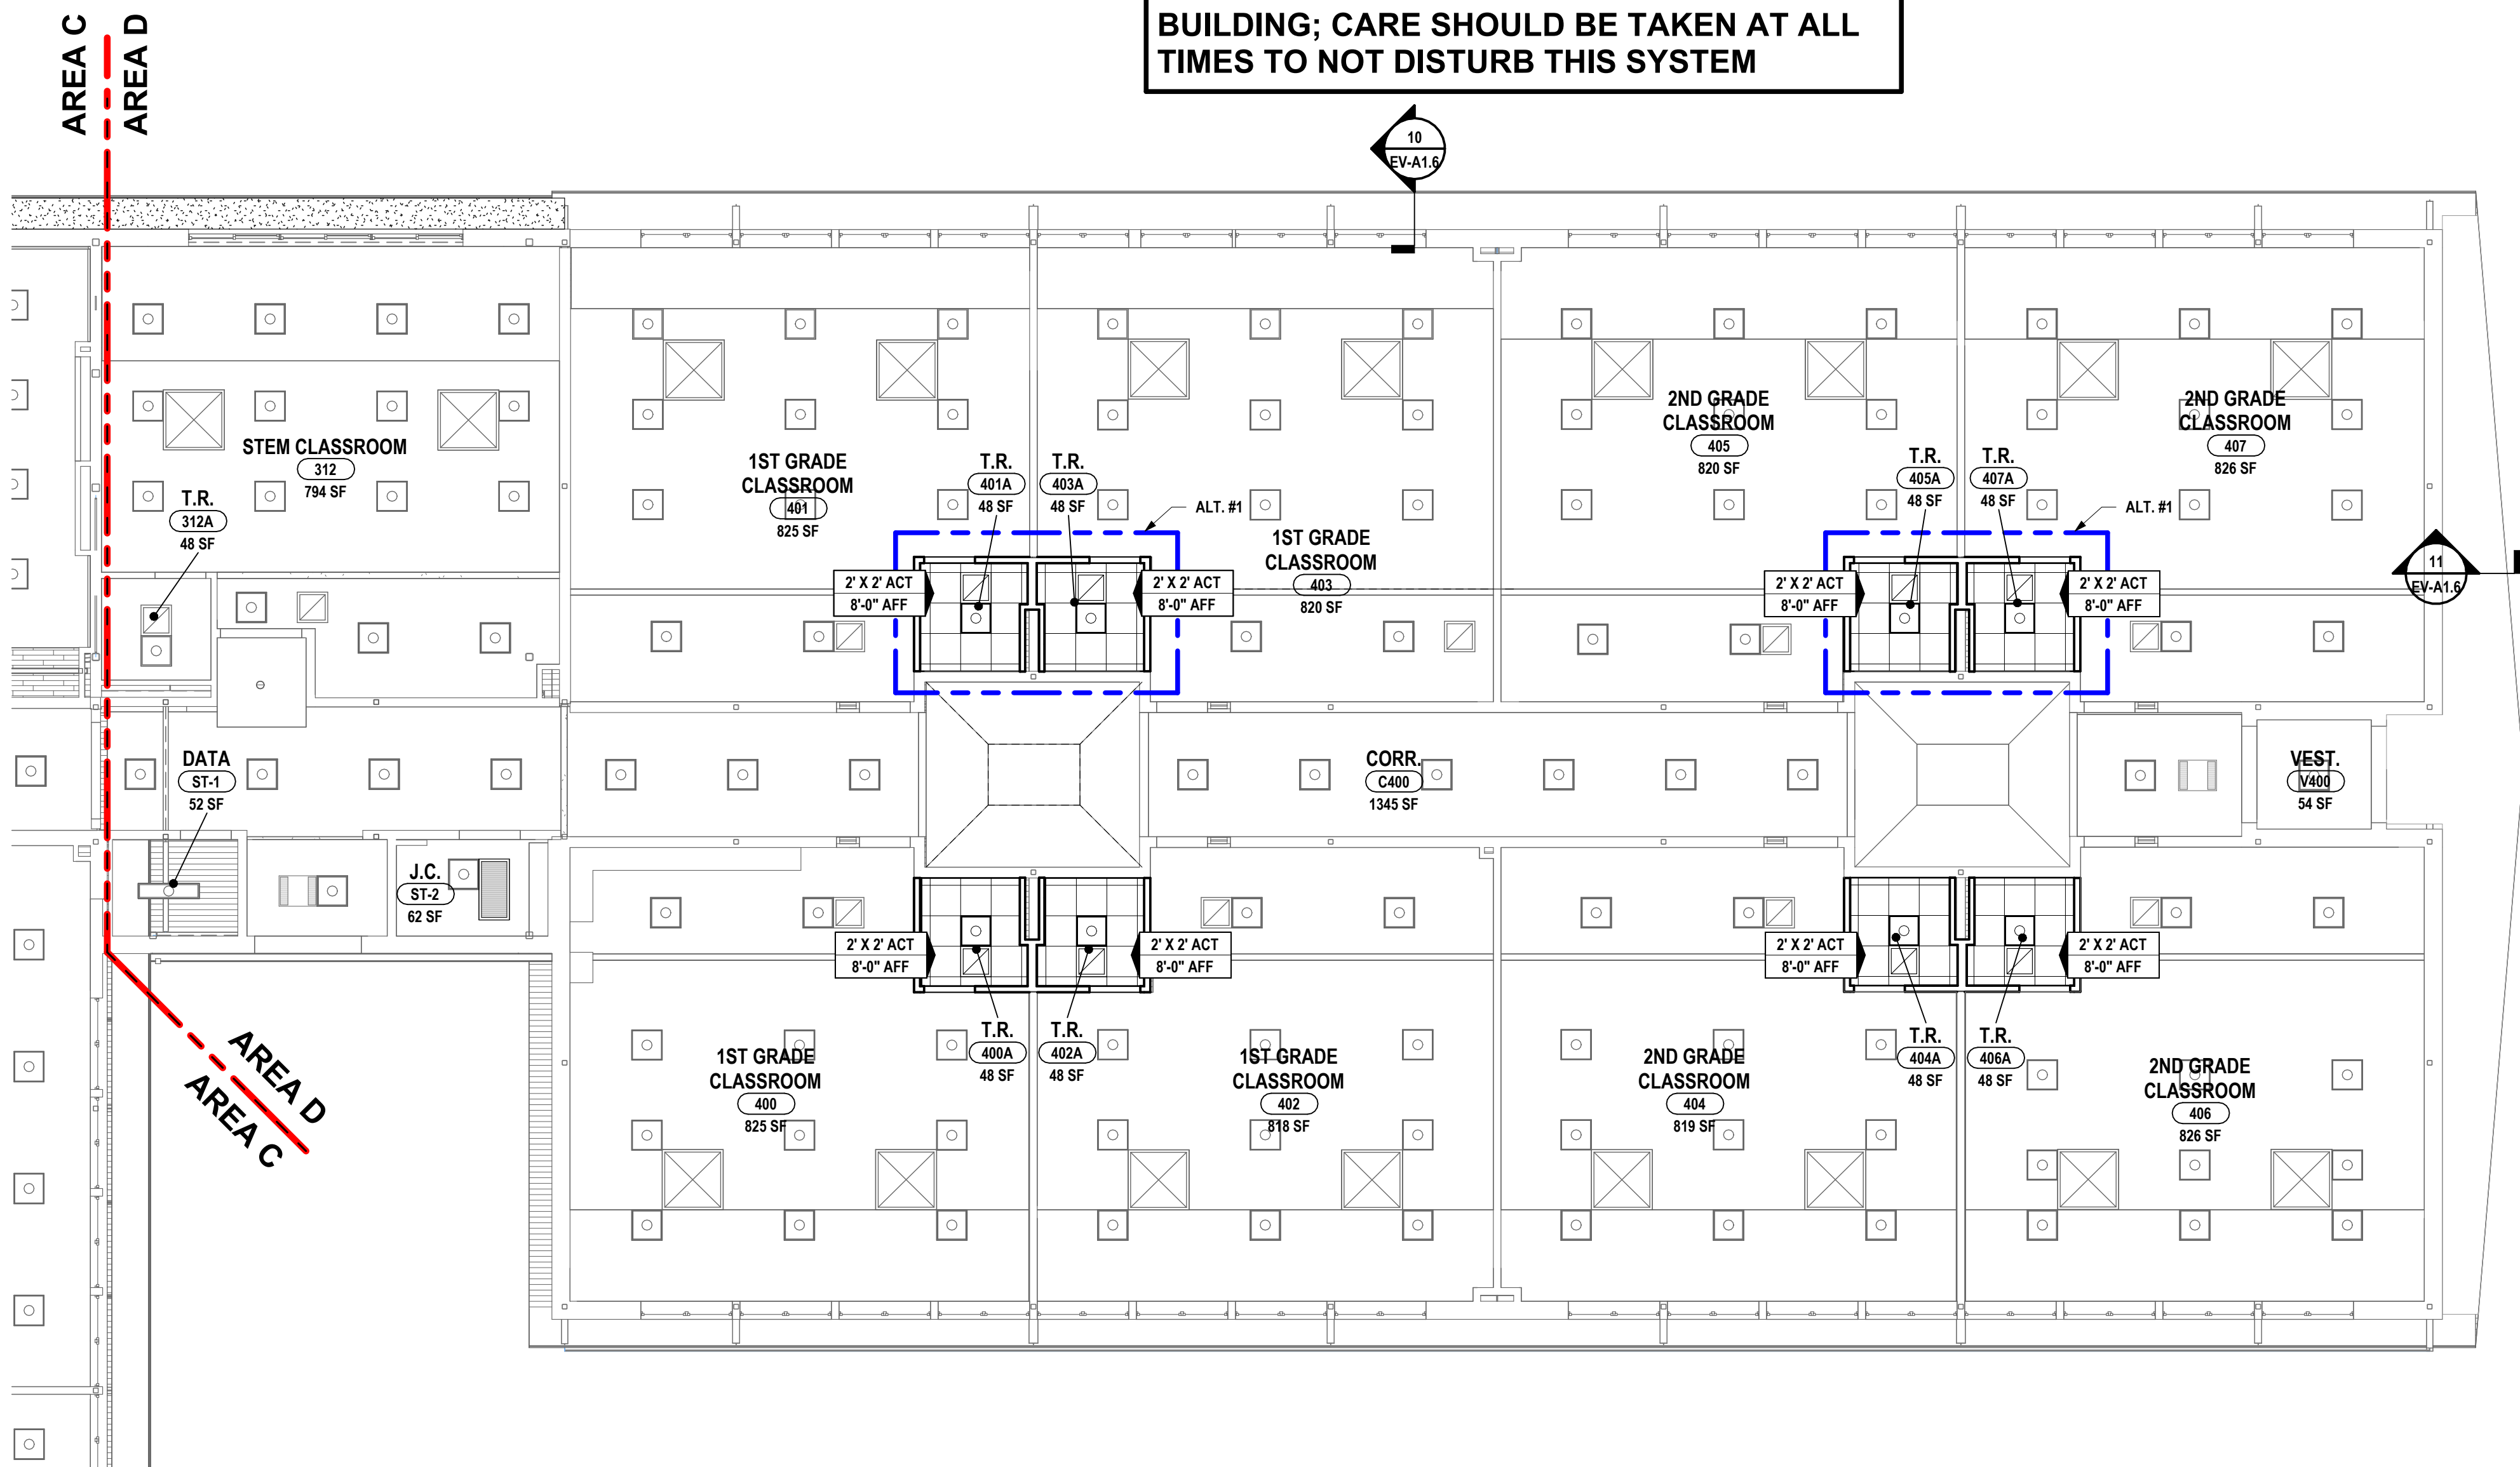

1 FIRST FLOOR REFLECTED CEILING PLAN - AREA D
1/8" = 1'-0"

GENERAL CEILING NOTES:


- A ALL CEILINGS TO BE 9'-0" A.F.F. UNLESS NOTED OTHERWISE.
B ALL SOFFITS TO BE 2" LOWER THAN CEILING HEIGHT UNLESS NOTED OTHERWISE.
C CENTER ALL MECHANICAL PENETRATIONS & ELECTRICAL DEVICES WITHIN 2X2 CEILING TILE.
D REFER TO FINISH SCHEDULE FOR INDIVIDUAL CEILING TYPES.
E VERIFY IN FIELD THE AMOUNT OF EXISTING LIGHTS TO BE REMOVED AND REINSTALLED.
F ALL NEW CEILING SYSTEMS TO BE INSTALLED DIRECTLY TO STRUCTURE.
G CENTER ALL MECHANICAL PENETRATIONS AND ELECTRICAL DEVICES WITHIN CEILING TILES. UNLESS NOTED OTHERWISE.
H COORDINATE ALL MECHANICAL DUCTWORK, PIPING, SPRINKLER LINES & CABLE TRAY TO AVOID CONFLICTS WITH LIGHTS AND STRUCTURE.
I ARCHITECTURAL DRAWINGS TAKE PRECEDENCE OVER ENGINEERING DRAWINGS FOR LOCATION OF LIGHT FIXTURES. SEE ELECTRICAL DRAWINGS FOR ALL FIXTURES.
J ARCHITECTURAL DRAWINGS TAKE PRECEDENCE OVER ENGINEERING DRAWINGS FOR LOCATION OF MECHANICAL LOUVERS. SEE MECHANICAL DRAWINGS FOR EQUIPMENT INFORMATION.
K WET SPRINKLER SYSTEM IS PRESENT IN THIS BUILDING; CARE SHOULD BE TAKEN AT ALL TIMES TO NOT DISTURB THIS SYSTEM.

RCP DRAWING NOTE:

- 1 ACT-2 TO BE 8'-0" A.F.F.
2 NEW CEILING TILES IN NEW CEILING GRID. INSTALL NEW CEILING, ACT-1, AT THE SAME HEIGHT AS THE EXG CEILING.
3 MECHANICAL UNIT MOUNTED FLUSH WITH CEILING. SEE "H" DWGS.
4 REINSTALL EXISTING LIGHT FIXTURE IN NEW LOCATION.
5 NEW CEILING GRID IN KITCHEN. INSTALL STORED EXISTING CEILING TILES IN NEW GRID. NEW ACT SYSTEM TO BE INSTALLED AT SAME HEIGHT AS EXISTING CEILING. REINSTALL ALL EXISTING FIXTURES IN ORIGINAL LOCATIONS IN NEW ACT SYSTEM.

RCP LEGEND

- INDICATES GYP BD OR PLASTER CEILING/SOFFIT
2'X2' TROFFERS LIGHT FIXTURE
DOWN LIGHT
LINEAR PENDANT MOUNTED DIRECT/INDIRECT LIGHT FIXTURE
HVAC RETURN
HVAC SUPPLY
HVAC EXHAUST
INDICATES ACT CEILING SYSTEM

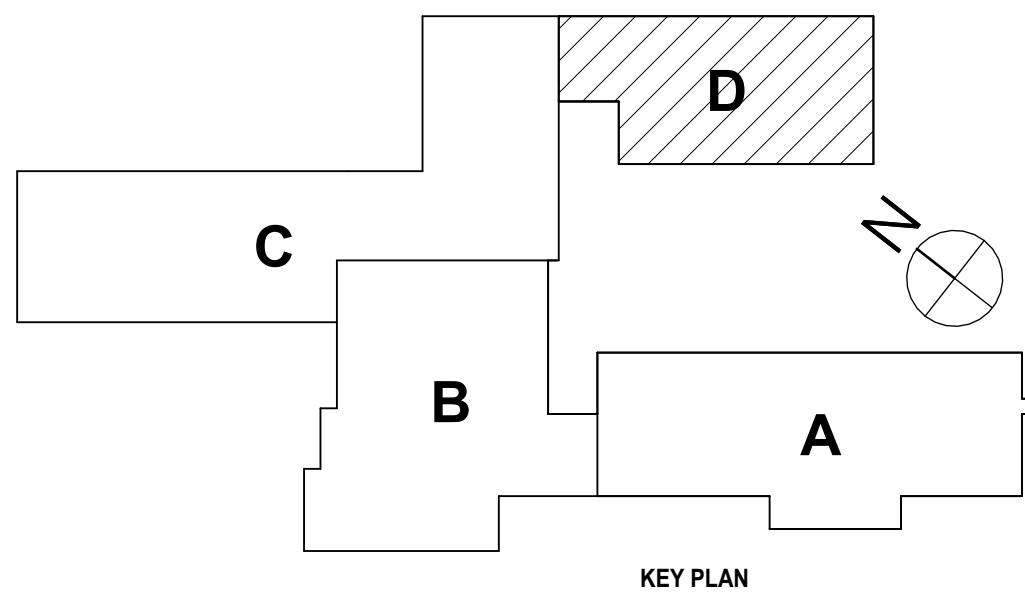

SED #ERWIN VALLEY 15-10-00-01-0-00-027; DOWN BUILDING 15-10-00-01-1-001-013

REFLECTED CEILING PLAN - AREA D

2025 ERWIN VALLEY ELEM & ADMIN BUILDING ALTERATIONS

CORNING-PAINTED POST ASD

16 BEARTOWN ROAD, PAINTED POST NY 14870


EV-A2.2

PROJECT NO: 2649-160


HUNT ENGINEERS | ARCHITECTS | SURVEYORS
ALBANY, NY - BINGHAMTON, NY - HORSESHOE FALLS, NY - ROCHESTER, NY
WWW.HUNT-EAS.COM 607-358-1000
NY CERTIFICATE NO. 0016320 PA CERTIFICATE NO. TSC220313464-1

#	DATE:	1	10/2/2025
REVISION:	ISSUE FOR BID		
DRAWN BY:	CAM	CHECKED BY:	SZ
DATE:	03/17/2026	PHASE:	CP

"IT IS A VIOLATION OF THE LAW FOR ANY PERSON TO MAKE UNAUTHORIZED ALTERATIONS OR ADDITIONS TO PLANS BEARING A LICENSED ENGINEER'S ARCHITECT'S OR SURVEYOR'S SEAL."

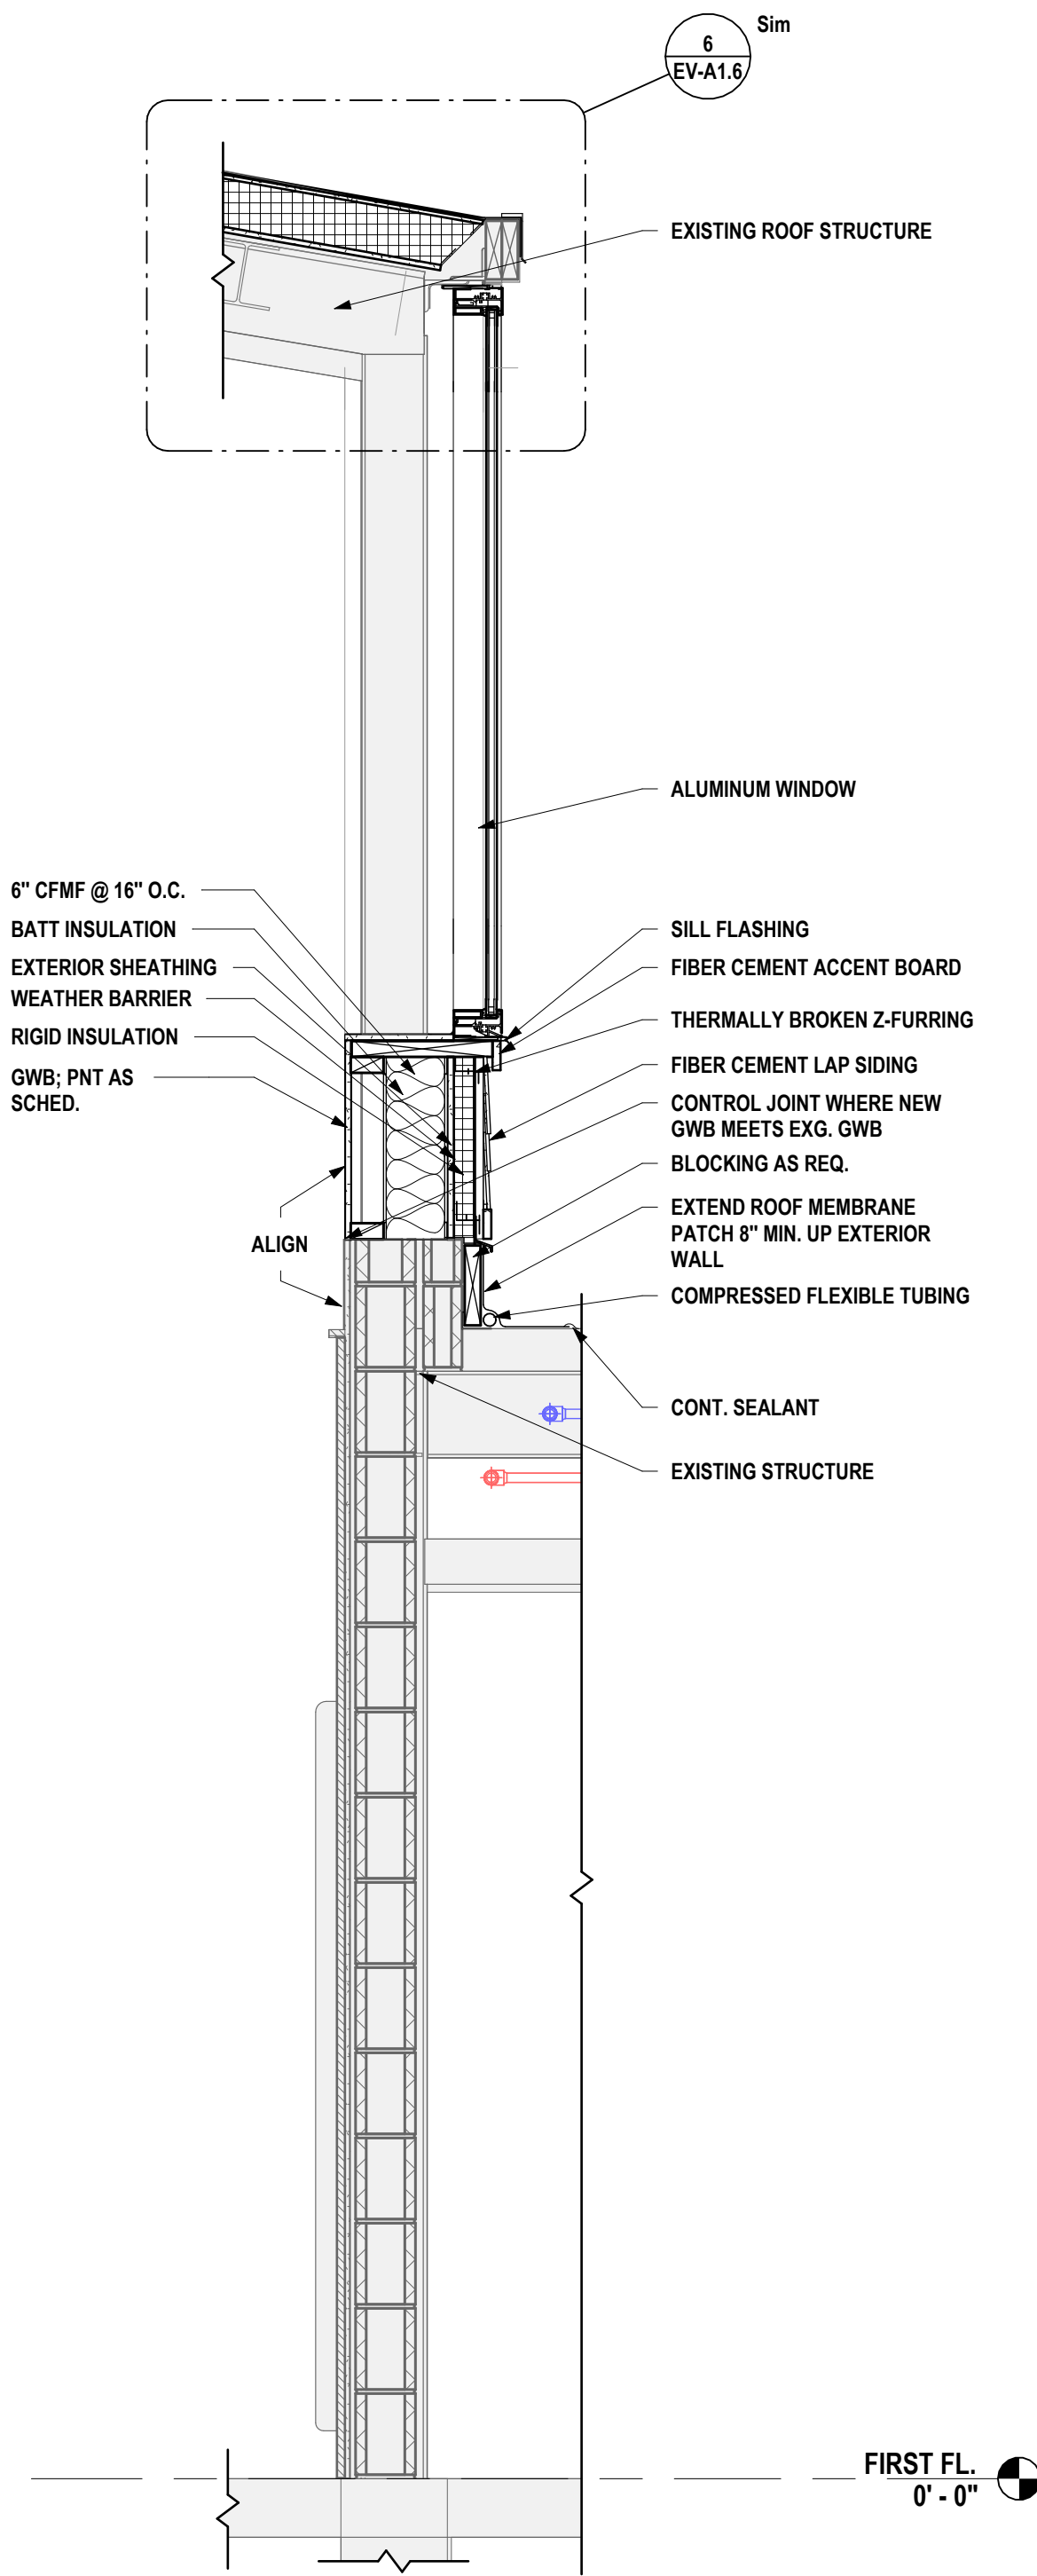

1 GYM WALL SECTION @ CLERESTORY WINDOW
3/4" = 1'-0"

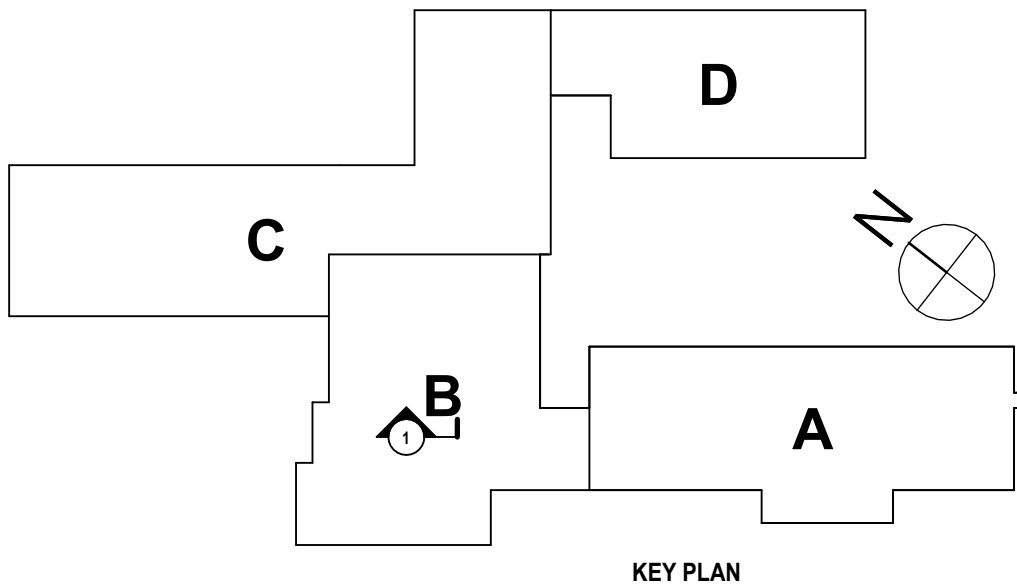

SED #ERWIN VALLEY 15-10-00-01-0-00-027 ADMIN BUILDING 15-10-00-01-1-001-013

WALL SECTIONS

2025 ERWIN VALLEY ELEM & ADMIN BUILDING ALTERATIONS

CORNING-PAINTED POST ASD

16 BEARTOWN ROAD, PAINTED POST NY 14870

EV-A4.1

PROJECT NO: 2649-160

HUNT


ENGINEERS | ARCHITECTS | SURVEYORS

ALBANY, NY • BINGHAMTON, NY • HORSEHEADS, NY • ROCHESTER, NY
ONE HUNTSMEAD DRIVE, SUITE 200, BINGHAMTON, NY 13902
WWW.HUNT-EAS.COM 607-758-1000
NY CERTIFICATE NO. 0016320 PA CERTIFICATE NO. TSC220313464-1

#	DATE:	1	10/2/2026	REVISION:	ISSUE FOR BID
"IT IS A VIOLATION OF THE LAW FOR ANY PERSON TO MAKE UNAUTHORIZED ALTERATIONS OR ADDITIONS TO PLANS BEARING A LICENSED ENGINEER'S ARCHITECT'S OR SURVEYOR'S SEAL."					


DRAWN BY:	CAM
CHECKED BY:	SZ
DATE:	03/17/2026
PHASE:	CD

Copyright 2026




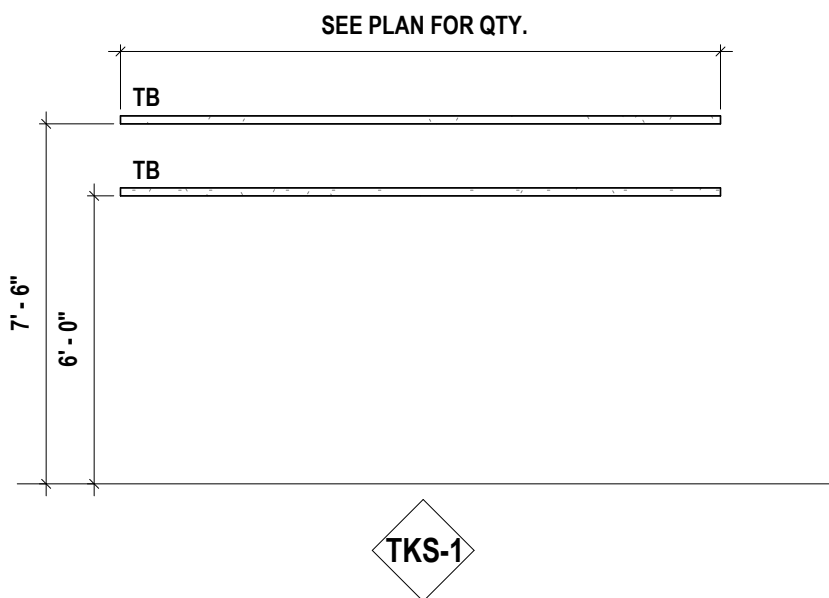


TACKBOARD ELEVATIONS

- NOTES:
1. REFER TO FLOOR PLANS FOR QUANTITIES
 2. CUT ALL REQUIRED OPENINGS IN MASONRY TO ACCOMMODATE RECESSED ACCESSORIES
 3. REFER TO SECTION 10170 OF PROJECT MANUAL FOR TOILET COMPARTMENTS AND URINAL SCREENS
 4. ALL DIMENSIONS FROM FACE OF FINISHED FLOOR OR WALL

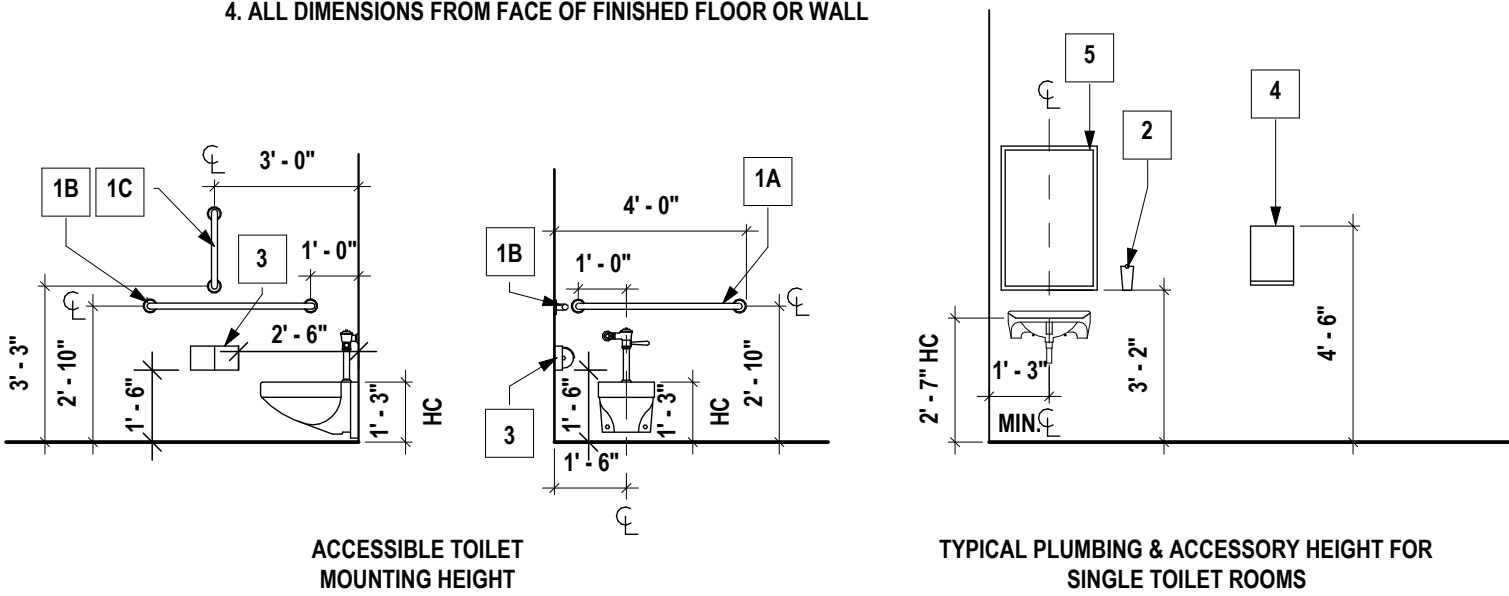

TOILET ROOM ACCESSORY SCHEDULE					
SYMBOL	DESCRIPTION	MANUFACT.	MODEL	SIZE	REMARKS
1A	GRAB BAR	AMERICAN SPECIALTIES INC.	3800	36"	HORIZONTAL
1B	GRAB BAR	AMERICAN SPECIALTIES INC.	3800	42"	HORIZONTAL
1C	GRAB BAR	AMERICAN SPECIALTIES INC.	3800	18"	VERTICAL
2	SOAP DISPENSER	FURNISHED BY OWNER	--	--	INSTALLED BY G.C.
3	TOILET TISSUE DISPENSER	FURNISHED BY OWNER	--	--	INSTALLED BY G.C.
4	PAPER TOWEL DISPENSER	FURNISHED BY OWNER	--	--	INSTALLED BY G.C.
5	MIRROR	AMERICAN SPECIALTIES INC.	#600 SERIES	24" x 36"	SURFACE MOUNTED

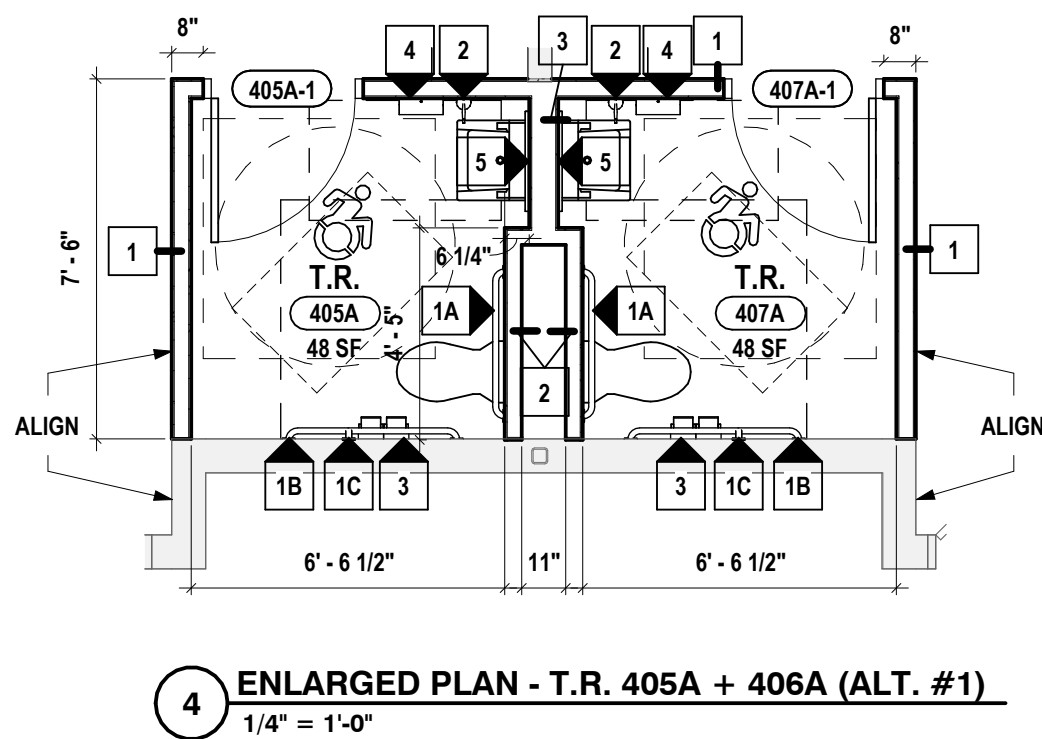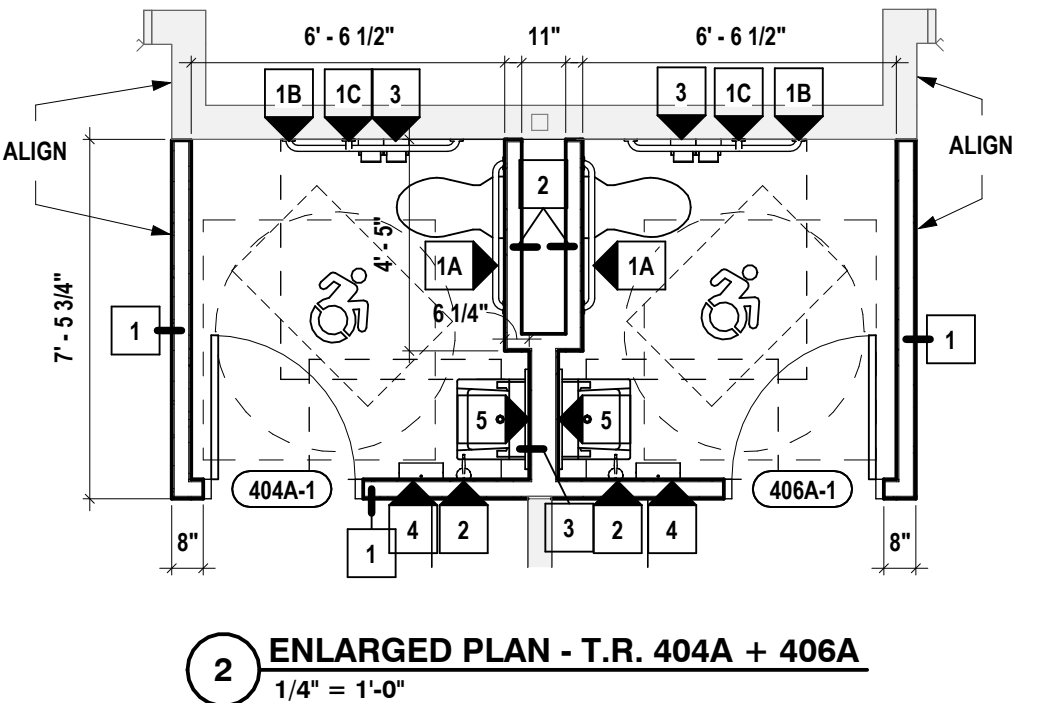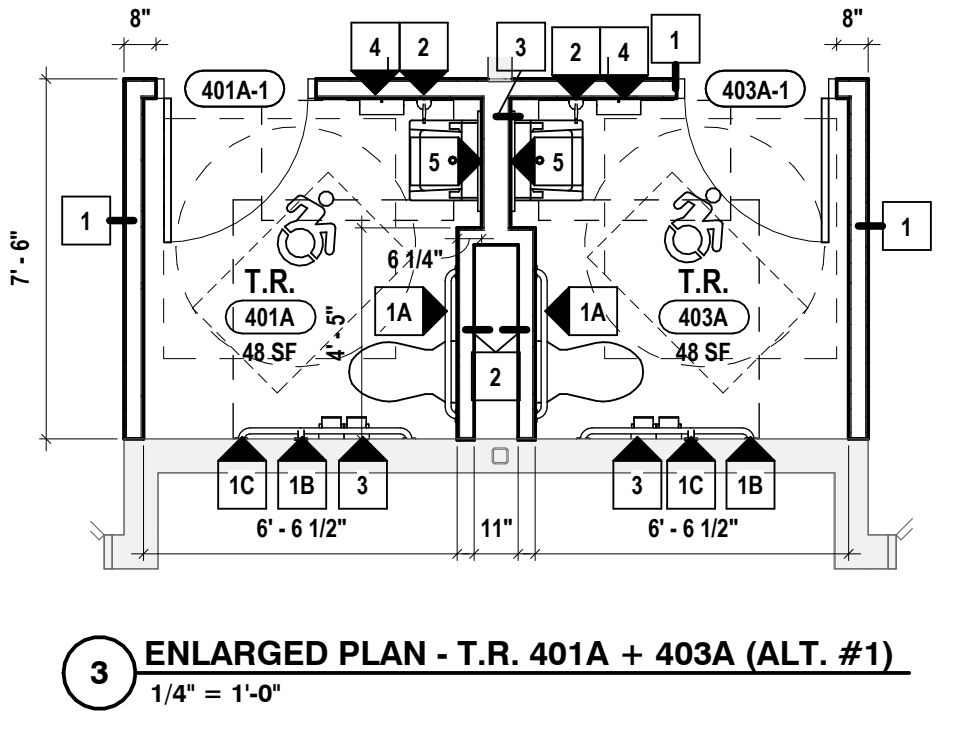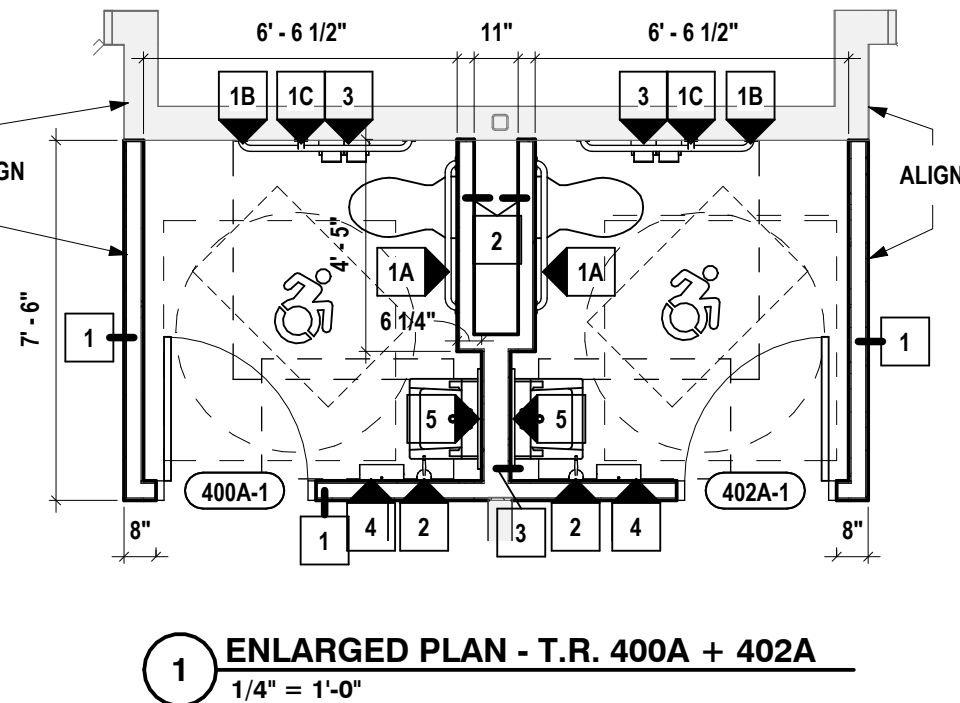

SED #ERWIN VALLEY 1510-0001-0-000-027; JOWIN BUILDING 07-10-00-01-1-001-013

ENLARGED T.R. PLANS + DETAILS
2025 ERWIN VALLEY ELEM & ADMIN BUILDING ALTERATIONS
CORNING-PAINTED POST ASD
16 BEARTOWN ROAD, PAINTED POST NY 14870


EV-A5.1
PROJECT NO: 2649-160

HUNT ENGINEERS | ARCHITECTS | SURVEYORS
ALBANY, NY • BINGHAMTON, NY • HORSESHOE FALLS, NY • ROCHESTER, NY
ONE HUNT EAS.COM • 807-358-1000
WWW.HUNT-EAS.COM • 807-358-1000
NY CERTIFICATE NO. 0016320 PA CERTIFICATE NO. TSC22031464-1


#	DATE:	REVISION:	DRAWN BY:
1	10/2/2026	ISSUE FOR BID	CAM
			CHECKED BY:
			ST
			DATE:
			03/17/2026
			PHASE:
			CP
			Copyright 2026
			"IT IS A VIOLATION OF THE LAW FOR ANY PERSON TO MAKE UNAUTHORIZED ALTERATIONS OR ADDITIONS TO PLANS BEARING A LICENSED ENGINEER'S ARCHITECT'S OR SURVEYOR'S SEAL."

DOOR SCHEDULE																	
NUMBER	DOOR		SIZE	DOOR		ASSEMBLY LABEL	GLAZING		HDWR SET	FRAME TYPE	DOOR FRAME		DETAIL			NOTES	
	DOOR TYPE	THICK.		MATL.	FINISH		MATL.	MARKING			MATL.	FINISH	HEAD	JAMB	SILL		
101E-1	EXG	1 3/4"	3'-0" x 7'-0"	WD	STN		EXG		EXG		1	HM	PNT	6/EV-A6.1	5/EV-A6.1	4/EV-A6.1	EXG DOOR AND FRAME ASSEMBLY TO BE SALVAGED AND INSTALLED IN A NEW LOCATION. SEE PLANS FOR NOTES.
103-1	A	1 3/4"	3'-0" x 7'-0"	FRP	FRP	45 MIN	--	--	--	08	1	HM	PNT	11/EV-A6.1	12/EV-A6.1	4/EV-A6.1	
103C-1	A	1 3/4"	3'-0" x 7'-0"	WD	STN	45 MIN	--	--	--	07	1	HM	PNT	1/EV-A6.1	2/EV-A6.1	4/EV-A6.1	
206-1	F	1 3/4"	PR @ 3'-0" x 7'-0"	EXG	EXG		--	SG		01	2	EXG	EXG	--	--	--	REPLACE WIRE GLASS IN DOOR WITH IMPACT SAFETY GLASS.
206B-1	A	1 3/4"	3'-0" x 7'-2"	WD	STN		--	--	--	04	2	HM	PNT	1/EV-A6.1	2/EV-A6.1	4/EV-A6.1	
306A-1	A	1 3/4"	3'-0" x 7'-2"	WD	STN	45 MIN	--	--	--	03	1	HM	PNT	1/EV-A6.1	2/EV-A6.1	4/EV-A6.1	
306B-1	A	1 3/4"	3'-0" x 7'-2"	WD	STN		--	--	--	03	1	HM	PNT	1/EV-A6.1	2/EV-A6.1	4/EV-A6.1	
307A-1	A	1 3/4"	3'-0" x 7'-0"	EXG	EXG		--	SG		01	3	EXG	EXG	--	--	--	REPLACE WIRE GLASS IN SIDELIGHT WITH IMPACT SAFETY GLASS.
308-1	A	1 3/4"	3'-0" x 7'-0"	EXG	EXG		--	SG		01	3	EXG	EXG	--	--	--	REPLACE WIRE GLASS IN SIDELIGHT WITH IMPACT SAFETY GLASS.
309-1	A	1 3/4"	3'-0" x 7'-0"	EXG	EXG		--	SG		01	3	EXG	EXG	--	--	--	REPLACE WIRE GLASS IN SIDELIGHT WITH IMPACT SAFETY GLASS.
310-1	A	1 3/4"	3'-0" x 7'-0"	EXG	EXG		--	SG		01	3	EXG	EXG	--	--	--	REPLACE WIRE GLASS IN SIDELIGHT WITH IMPACT SAFETY GLASS.
400-1	C	1 3/4"	3'-0" x 7'-0"	EXG	EXG		--	SG		01	3	EXG	EXG	--	--	--	REPLACE WIRE GLASS IN SIDELIGHT WITH IMPACT SAFETY GLASS.
400A-1	A	1 3/4"	3'-0" x 7'-0"	WD	STN		--	--	--	05	1	HM	PNT	1/EV-A6.1	2/EV-A6.1	4/EV-A6.1	
401-1	C	1 3/4"	3'-0" x 7'-0"	EXG	EXG		--	SG		01	3	EXG	EXG	--	--	--	REPLACE WIRE GLASS IN DOOR AND SIDELIGHT WITH IMPACT SAFETY GLASS.
401A-1	A	1 3/4"	3'-0" x 7'-0"	WD	STN		--	--	--	05	1	HM	PNT	1/EV-A6.1	2/EV-A6.1	4/EV-A6.1	ALT. #1
402-1	C	1 3/4"	3'-0" x 7'-0"	EXG	EXG		--	SG		01	3	EXG	EXG	--	--	--	REPLACE WIRE GLASS IN DOOR AND SIDELIGHT WITH IMPACT SAFETY GLASS.
402A-1	A	1 3/4"	3'-0" x 7'-0"	WD	STN		--	--	--	05	1	HM	PNT	1/EV-A6.1	2/EV-A6.1	4/EV-A6.1	
403-1	C	1 3/4"	3'-0" x 7'-0"	EXG	EXG		--	SG		01	3	EXG	EXG	--	--	--	REPLACE WIRE GLASS IN DOOR AND SIDELIGHT WITH IMPACT SAFETY GLASS.
403A-1	A	1 3/4"	3'-0" x 7'-0"	WD	STN		--	--	--	05	1	HM	PNT	1/EV-A6.1	2/EV-A6.1	4/EV-A6.1	ALT. #1
404-1	C	1 3/4"	3'-0" x 7'-0"	EXG	EXG		--	SG		01	3	EXG	EXG	--	--	--	REPLACE WIRE GLASS IN DOOR AND SIDELIGHT WITH IMPACT SAFETY GLASS.
404A-1	A	1 3/4"	3'-0" x 7'-0"	WD	STN		--	--	--	05	1	HM	PNT	1/EV-A6.1	2/EV-A6.1	4/EV-A6.1	
405-1	C	1 3/4"	3'-0" x 7'-0"	EXG	EXG		--	SG		01	3	EXG	EXG	--	--	--	REPLACE WIRE GLASS IN DOOR AND SIDELIGHT WITH IMPACT SAFETY GLASS.
405A-1	A	1 3/4"	3'-0" x 7'-0"	WD	STN		--	--	--	05	1	HM	PNT	1/EV-A6.1	2/EV-A6.1	4/EV-A6.1	ALT. #1
406-1	C	1 3/4"	3'-0" x 7'-0"	EXG	EXG		--	SG		01	3	EXG	EXG	--	--	--	REPLACE WIRE GLASS IN DOOR AND SIDELIGHT WITH IMPACT SAFETY GLASS.
406A-1	A	1 3/4"	3'-0" x 7'-0"	WD	STN		--	--	--	05	1	HM	PNT	1/EV-A6.1	2/EV-A6.1	4/EV-A6.1	
407-1	C	1 3/4"	3'-0" x 7'-0"	EXG	EXG		--	SG		01	3	EXG	EXG	--	--	--	REPLACE WIRE GLASS IN DOOR AND SIDELIGHT WITH IMPACT SAFETY GLASS.
407A-1	A	1 3/4"	3'-0" x 7'-0"	WD	STN		--	--	--	05	1	HM	PNT	1/EV-A6.1	2/EV-A6.1	4/EV-A6.1	ALT. #1
B1-1	A	1 3/4"	4'-0" x 7'-0"	FRP	FRP	90 MIN	--	--	--	07	1	FRP	FRP	6/EV-A6.1	5/EV-A6.1	4/EV-A6.1	
B2-1	A	1 3/4"	3'-6" x 7'-0"	FRP	FRP		--	--	--	07	1	FRP	FRP	6/EV-A6.1	5/EV-A6.1	4/EV-A6.1	
B6-1	A	1 3/4"	3'-6" x 7'-0"	FRP	FRP	90 MIN	--	--	--	09	1	FRP	FRP	7/EV-A6.1	8/EV-A6.1	3/EV-A6.1	
C301-1	E	1 3/4"	PR @ 3'-0" x 7'-0"	EXG	EXG		--	SG		01	1	EXG	EXG	--	--	--	REPLACE WIRE GLASS IN DOOR WITH IMPACT SAFETY GLASS.
CY-1	GATE	1 1/2"	3'-0" x 4'-0"	STL	FACTORY FINISH		--	--	--	10	--	--	--	--	--	--	EXTERIOR SWING GATE IN FENCE. SEE 'L' DWGS FOR MORE INFORMATION.
CY-2	GATE	1 1/2"	3'-0" x 4'-0"	STL	FACTORY FINISH		--	--	--	10	--	--	--	--	--	--	EXTERIOR SWING GATE IN FENCE. SEE 'L' DWGS FOR MORE INFORMATION.
S100-1	B	1 3/4"	3'-0" x 7'-0"	WD	STN	45 MIN	FRG-1		45 MIN	07	1	HM	PNT	1/EV-A6.1	2/EV-A6.1	4/EV-A6.1	
X100-1	D	1 3/4"	PR @ 3'-4" x 7'-0"	FRP	FRP		--	--	--	06	1	FRP	FRP	10/EV-A6.1	9/EV-A6.1	3/EV-A6.1	


WINDOW SCHEDULE								
NUMBER	FRAME			GLAZING	DETAIL			NOTES
	WINDOW TYPE	MATERIAL	FINISH		HEAD	JAMB	SILL	
107-A	A	ALUM	FACTORY FINISH	IG-B	13/EV-A6.1	14/EV-A6.1	15/EV-A6.1	

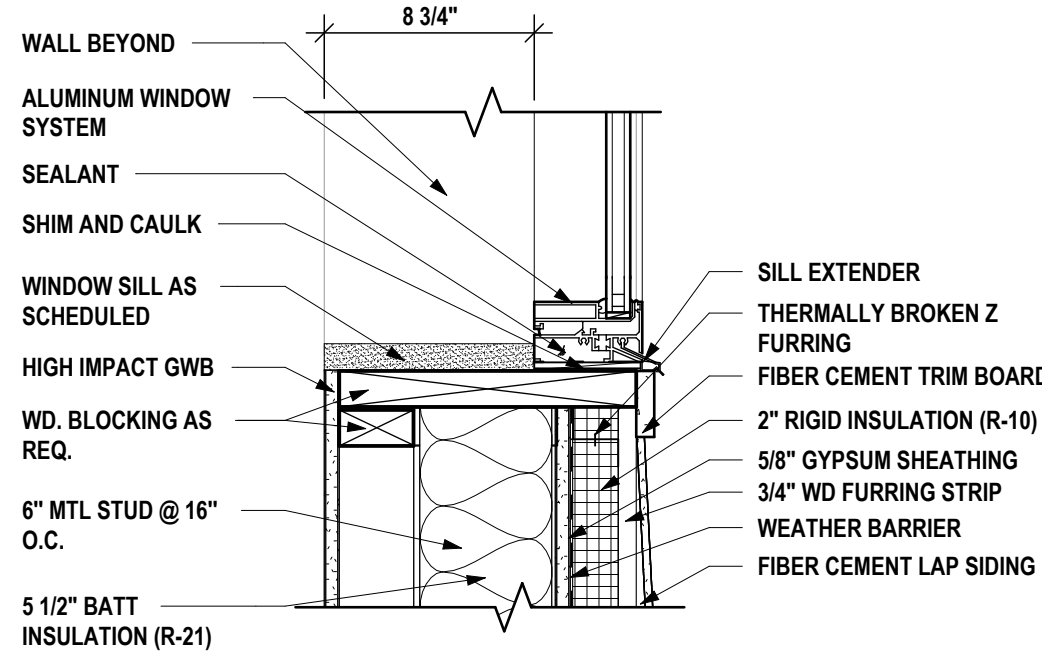


15 WINDOW SILL - GYM WINDOW
1 1/2" = 1'-0"

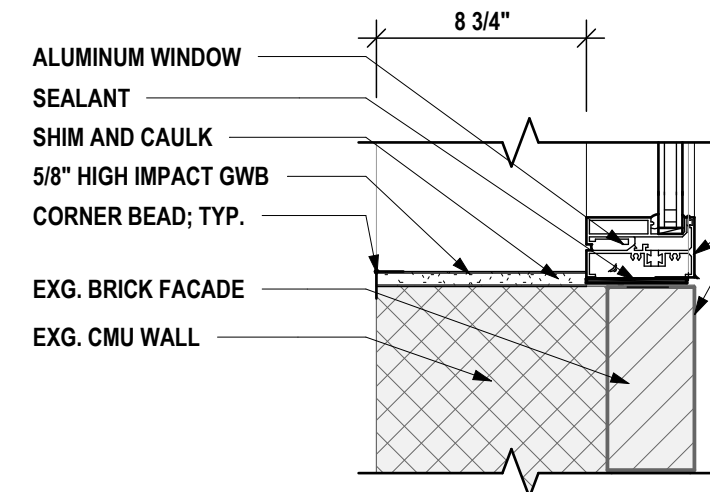

14 WINDOW JAMB - GYM WINDOW
1 1/2" = 1'-0"

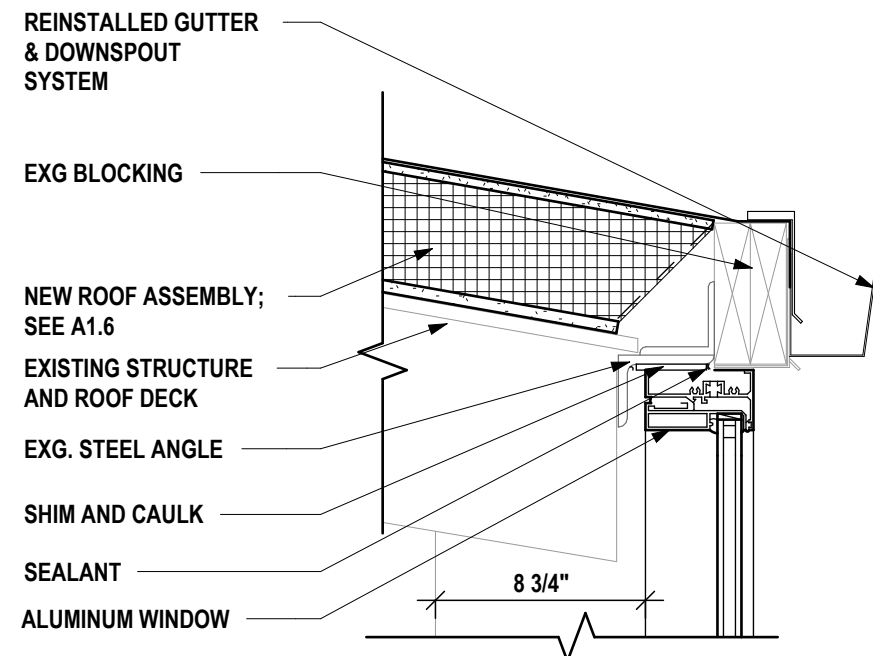


13 WINDOW HEAD - GYM WALL
1 1/2" = 1'-0"

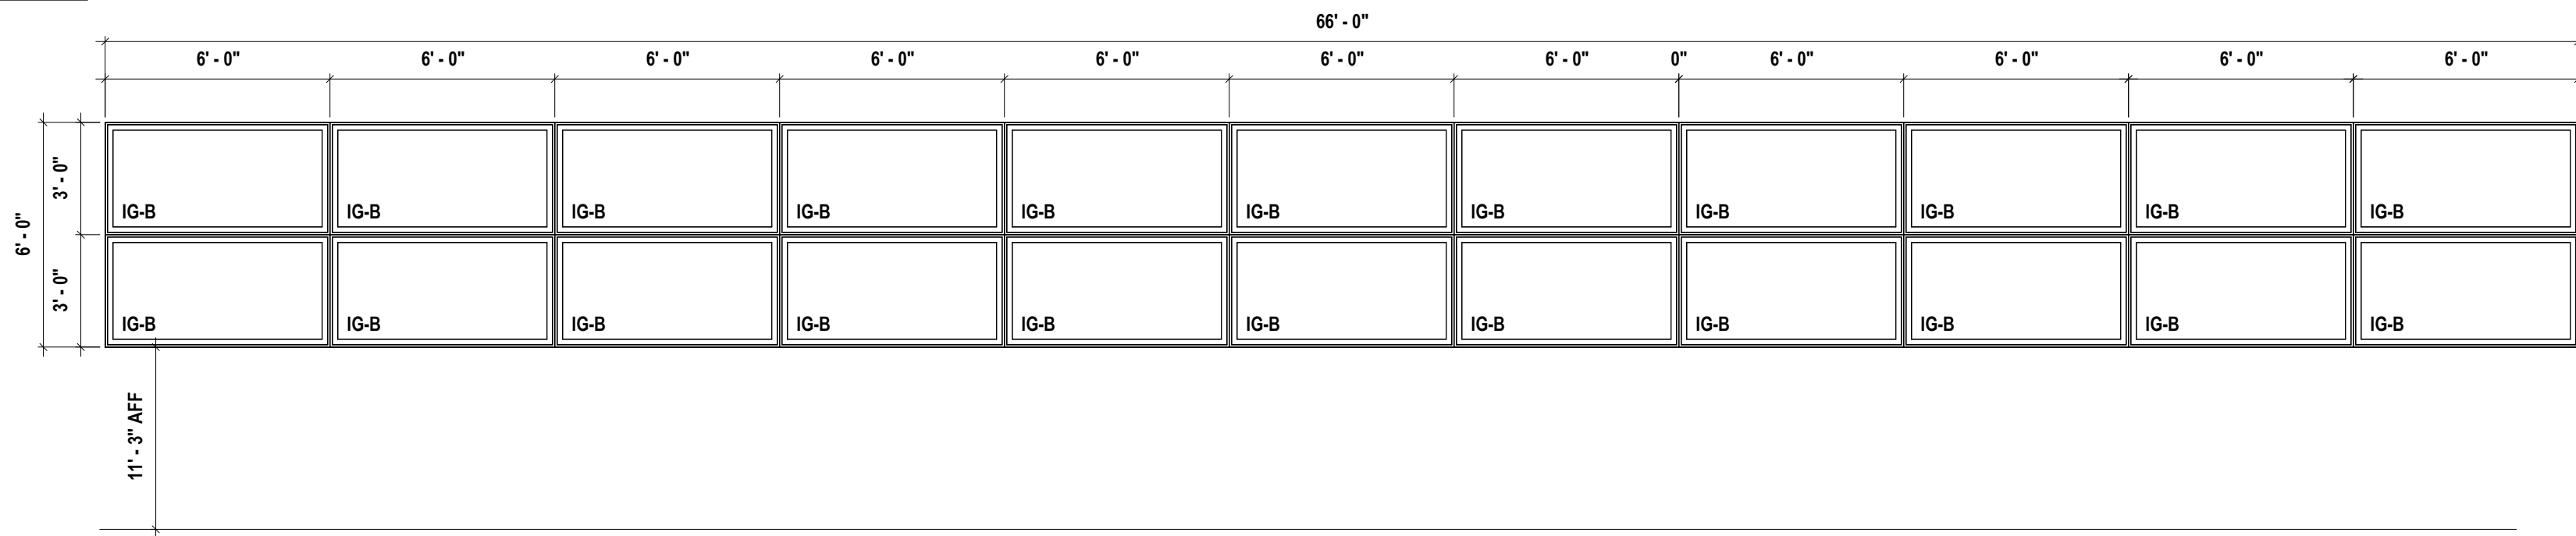


A


WINDOW TYPES

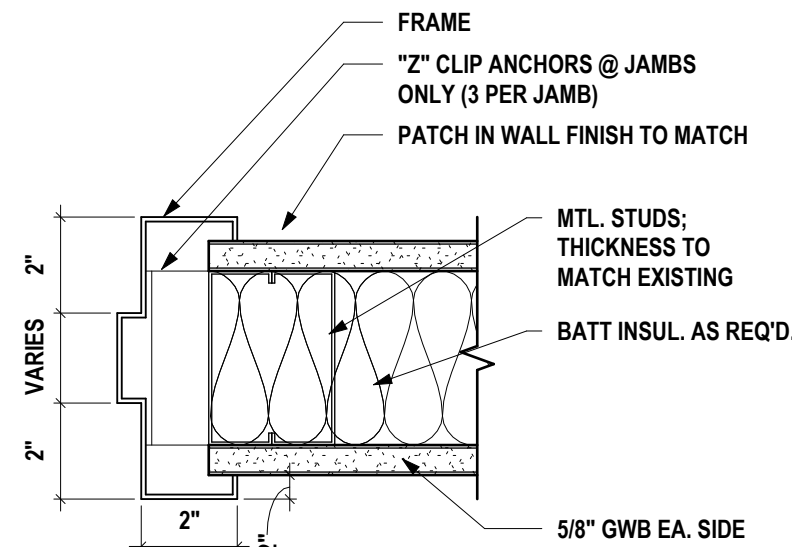


12 METAL STUD WALL JAMB DETAIL - B
3\"/>

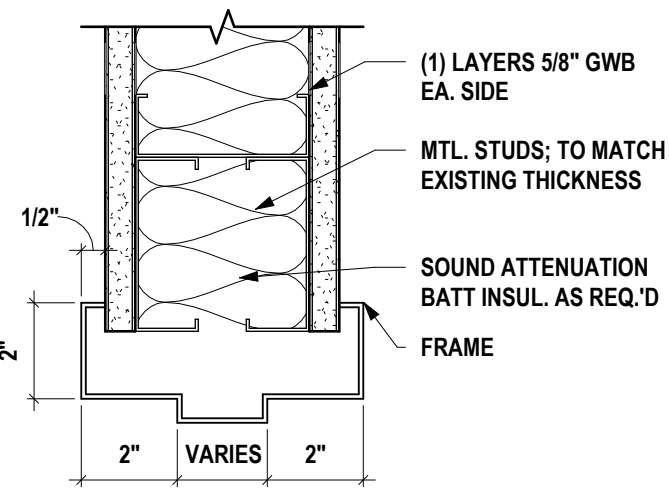


11 METAL STUD WALL HEAD DETAIL - B
3\"/>

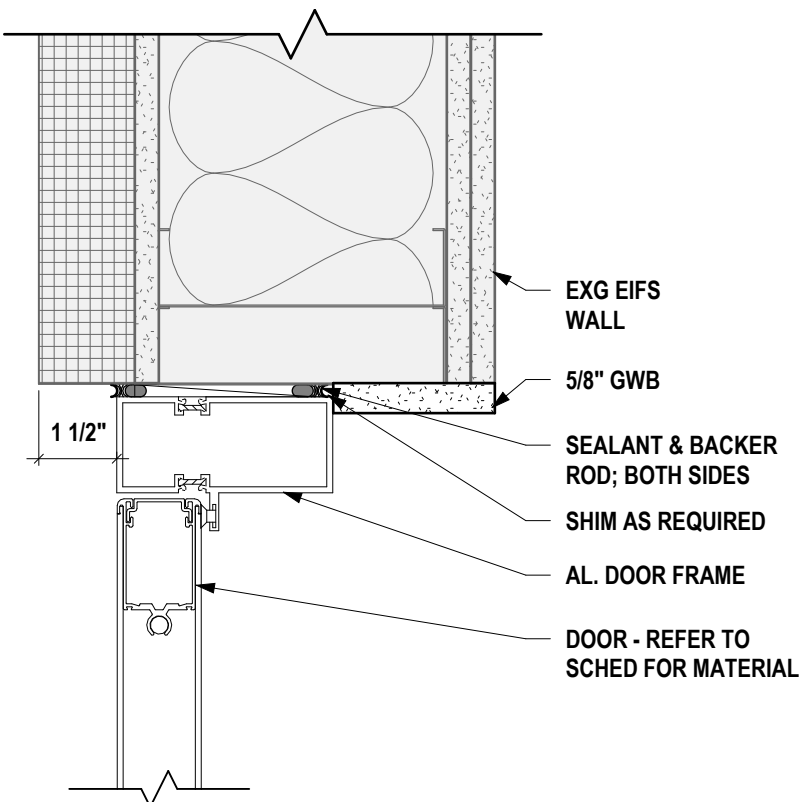


10 EXISTING MASONRY WALL HEAD DETAIL - C
3\"/>

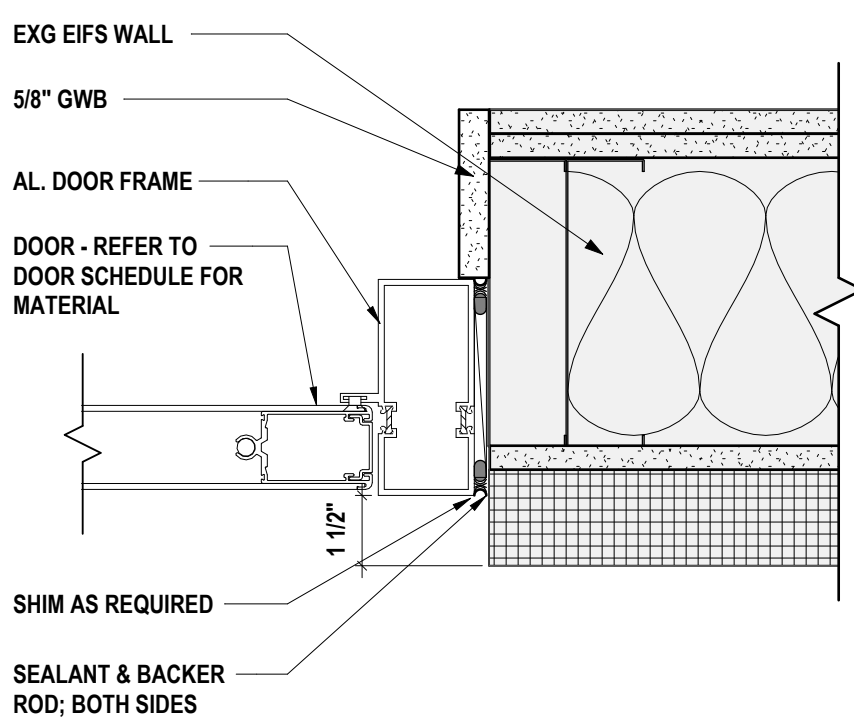


9 EXISTING MASONRY WALL JAMB DETAIL - C
3\"/>

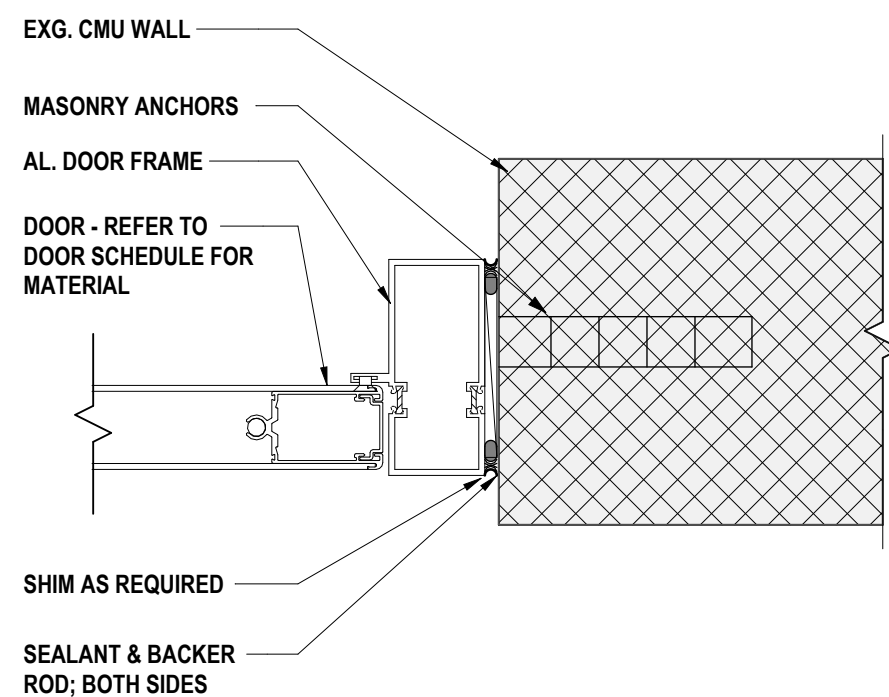


8 EXISTING MASONRY WALL JAMB DETAIL - B
3\"/>

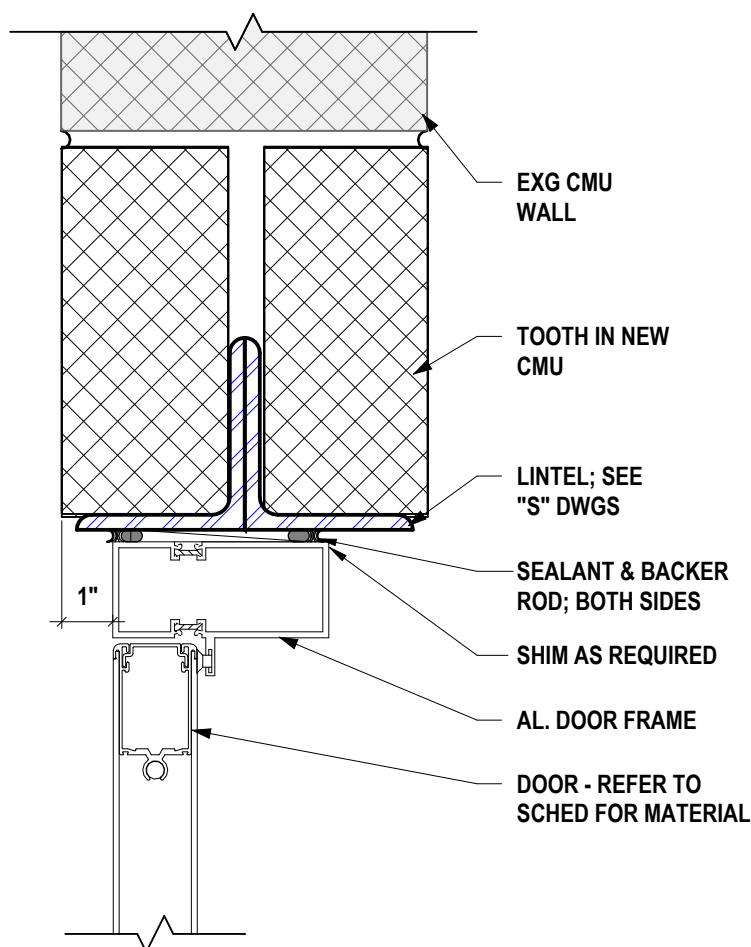


7 EXISTING MASONRY WALL HEAD DETAIL - B
3\"/>

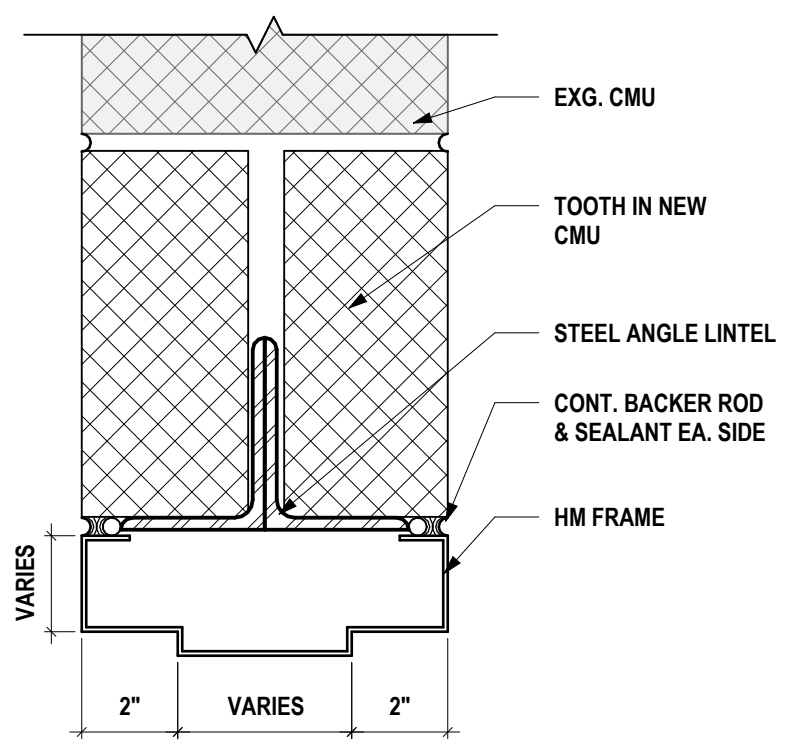


6 EXISTING MASONRY WALL HEAD DETAIL - A
3\"/>

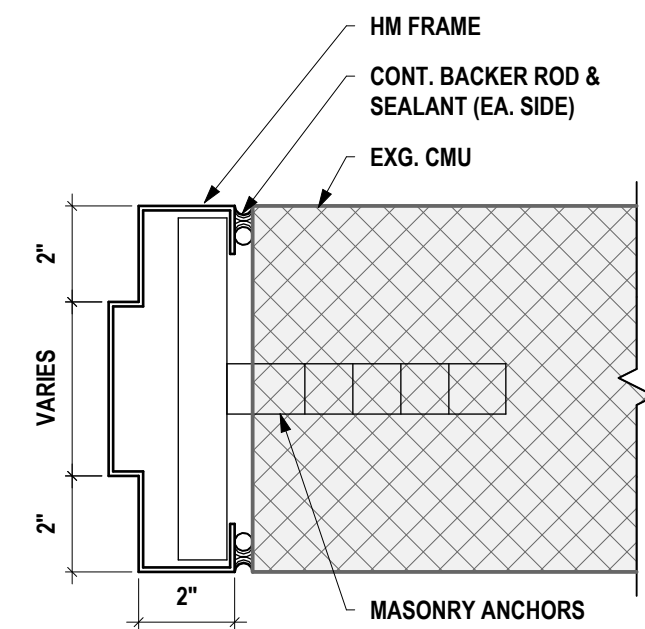


5 EXISTING MASONRY WALL JAMB DETAIL - A
3\"/>

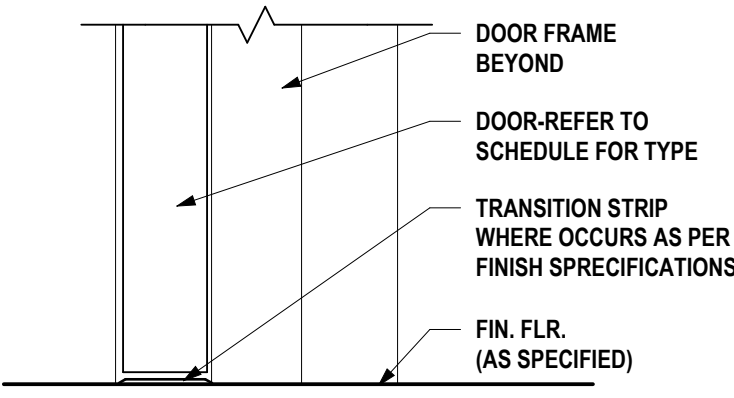


4 THRESHOLD DETAIL - B
3\"/>

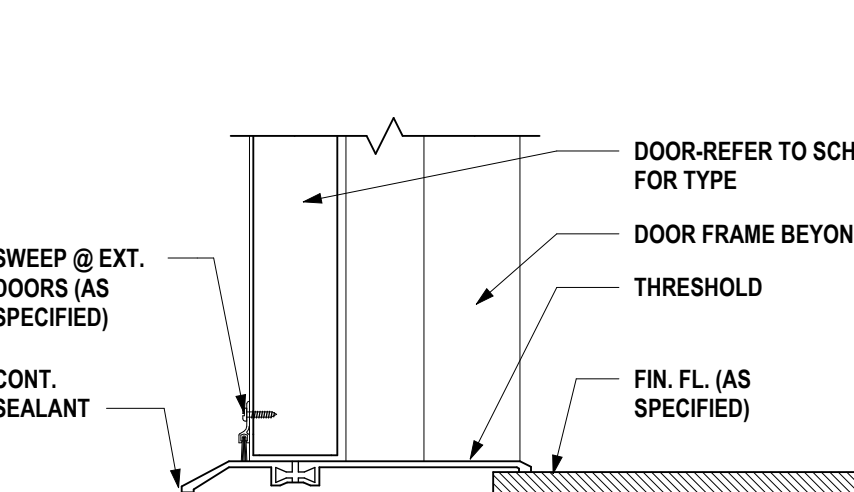


3 THRESHOLD DETAIL - A
3\"/>

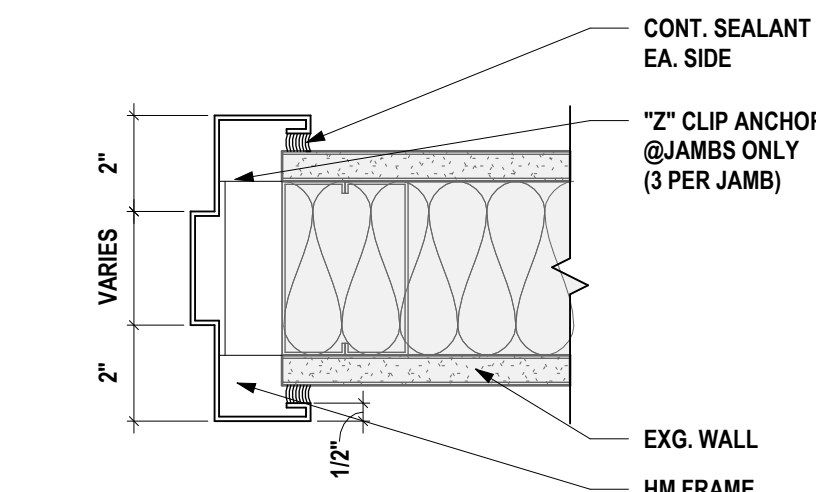


2 METAL STUD WALL JAMB DETAIL - A
3\"/>

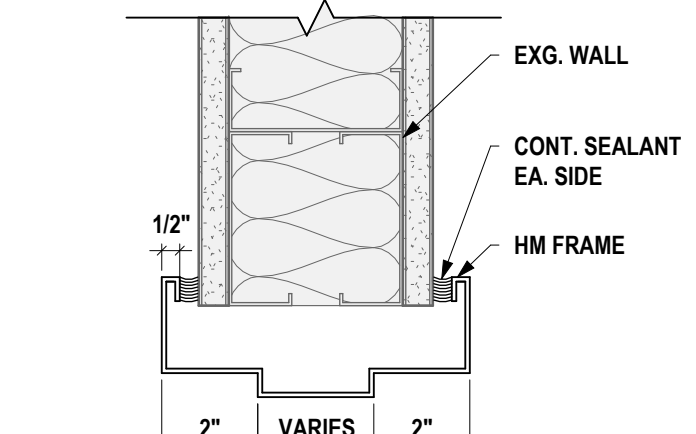

1 METAL STUD WALL HEAD DETAIL - A
3\"/>

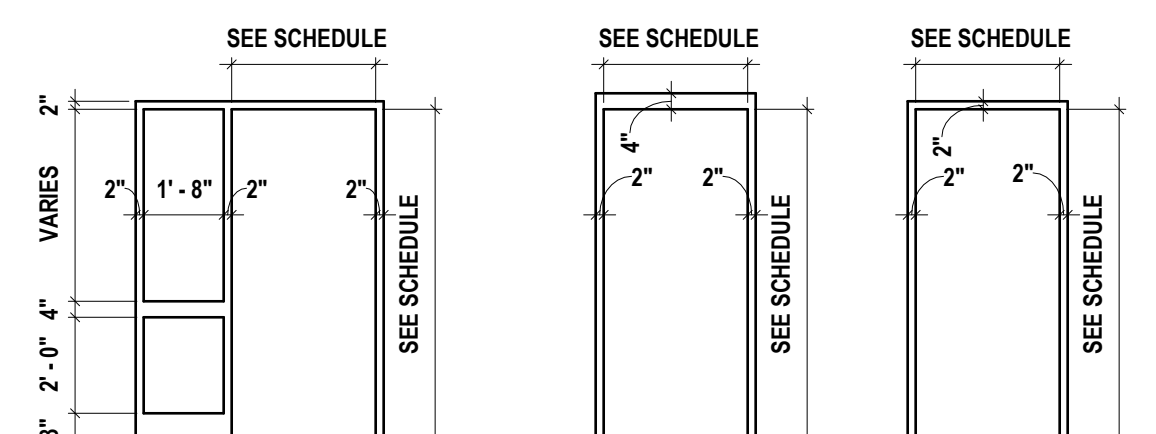

FRAME TYPES

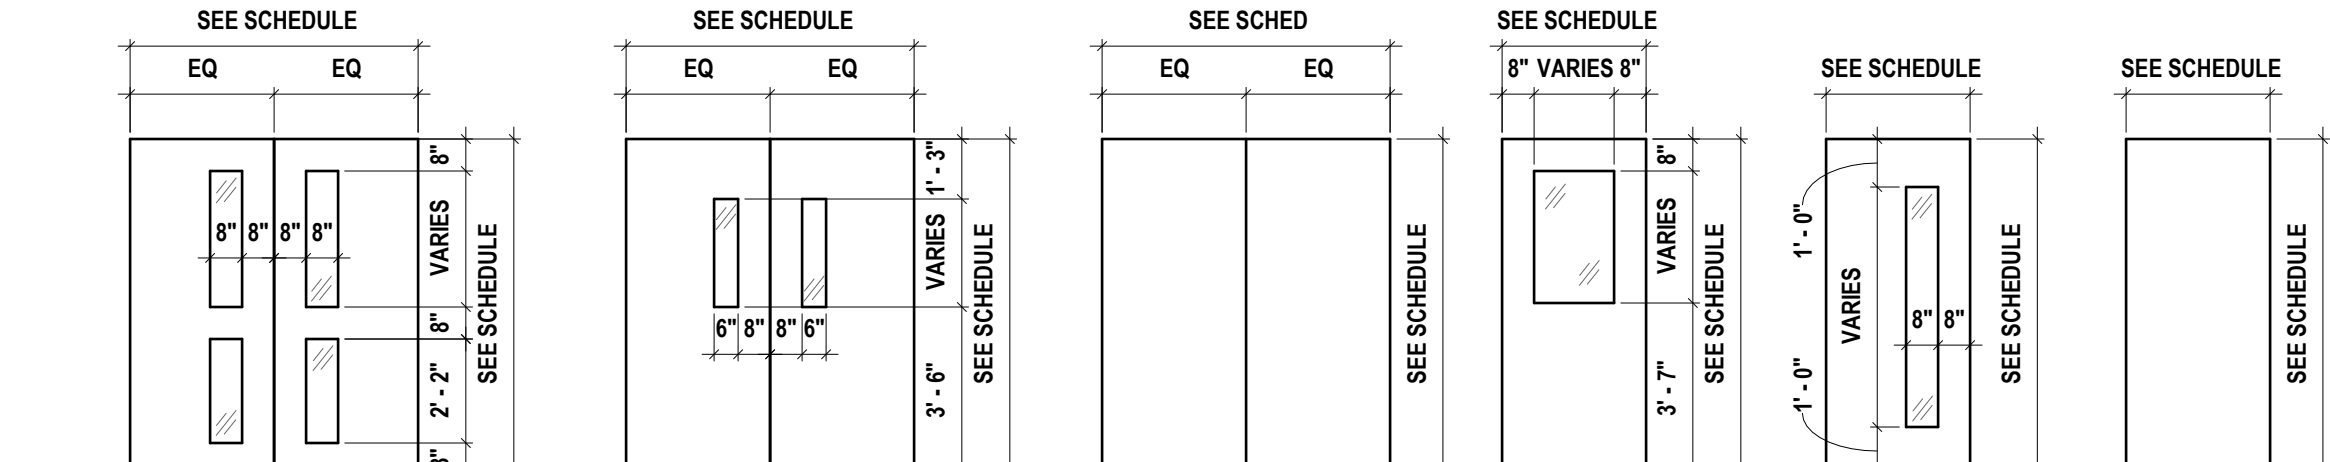

DOOR TYPES

SED #ERWIN VALLEY 15-10-00-01-000-027; DOWN BUILDING 15-10-00-01-1-001-013

DOOR & GLAZING SCHEDULE AND DETAILS

2025 ERWIN VALLEY ELEM & ADMIN BUILDING ALTERATIONS

CORNING-PAINTED POST ASD

16 BEARTOWN ROAD, PAINTED POST NY 14870

HUNT

ENGINEERS | ARCHITECTS | SURVEYORS

ALBANY, NY - BINGHAMTON, NY - HORSESHOE FALLS, NY - ROCHESTER, NY

WWW.HUNT-EAS.COM 807-358-1000

NY CERTIFICATE NO. 0016320 PA CERTIFICATE NO. TSC220313464-1

DRAWN BY: CAM

CHECKED BY: ST

DATE: 03/17/2026

PHASE: CP

DATE: 1 10/22/08


REVISION: ISSUE FOR BID

IT IS A VIOLATION OF THE LAW FOR ANY PERSON TO MAKE UNAUTHORIZED ALTERATIONS OR ADDITIONS TO PLANS BEARING A LICENSED ENGINEER'S ARCHITECT'S OR SURVEYOR'S SEAL.


Copyright 2025

EV-A6.1


PROJECT NO: 2649-160

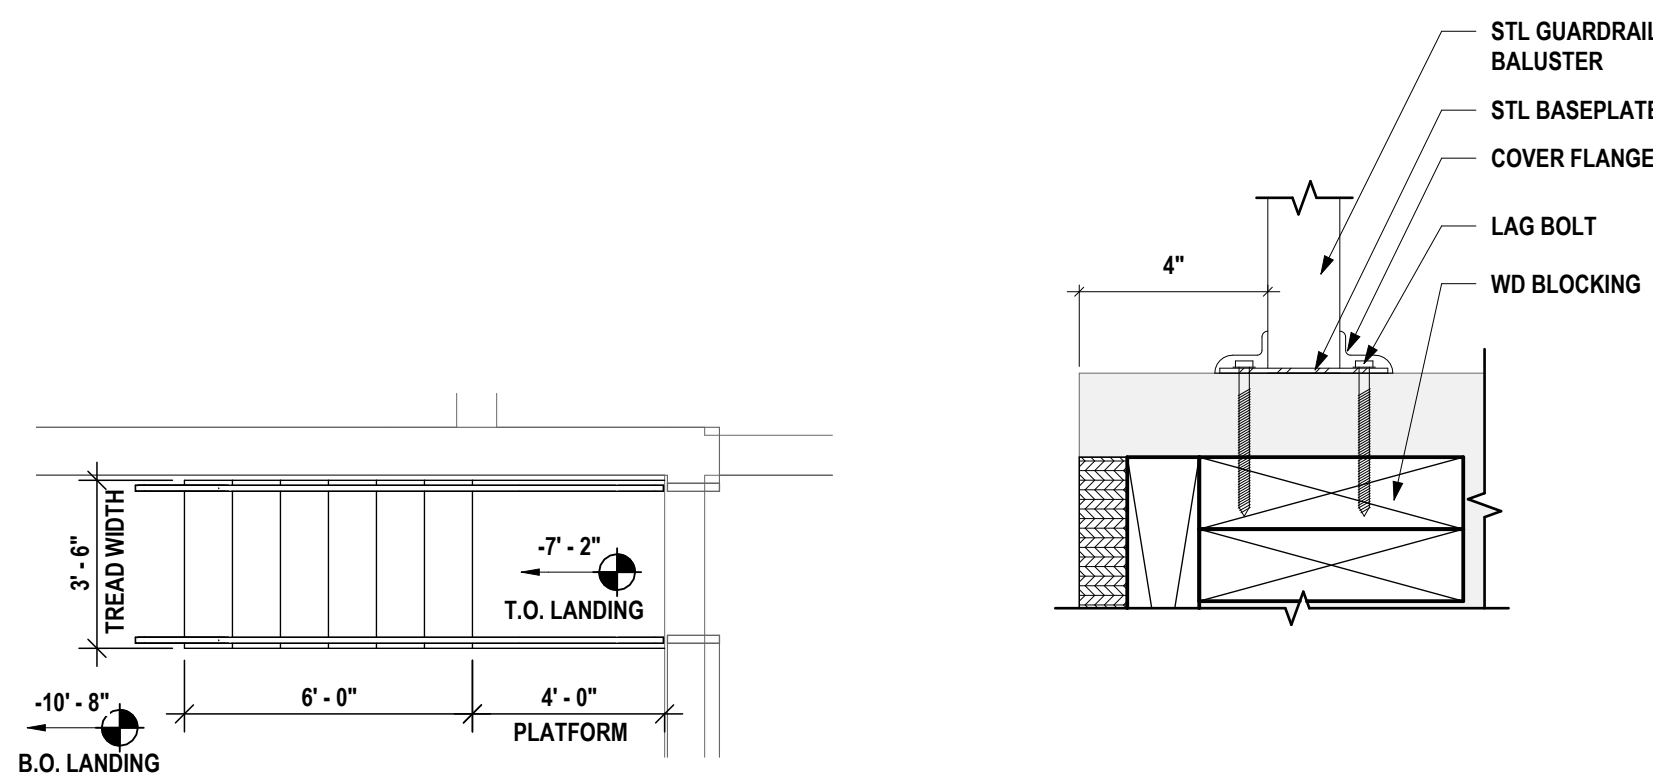


7 BASEMENT PREFABRICATED STAIR PLAN
1/4\" = 1'-0"

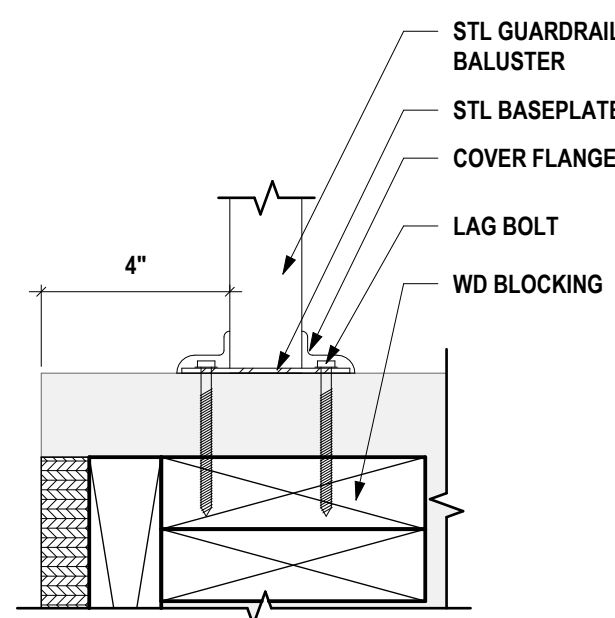


6 GUARDRAIL MOUNTING DETAIL
3\" = 1'-0"

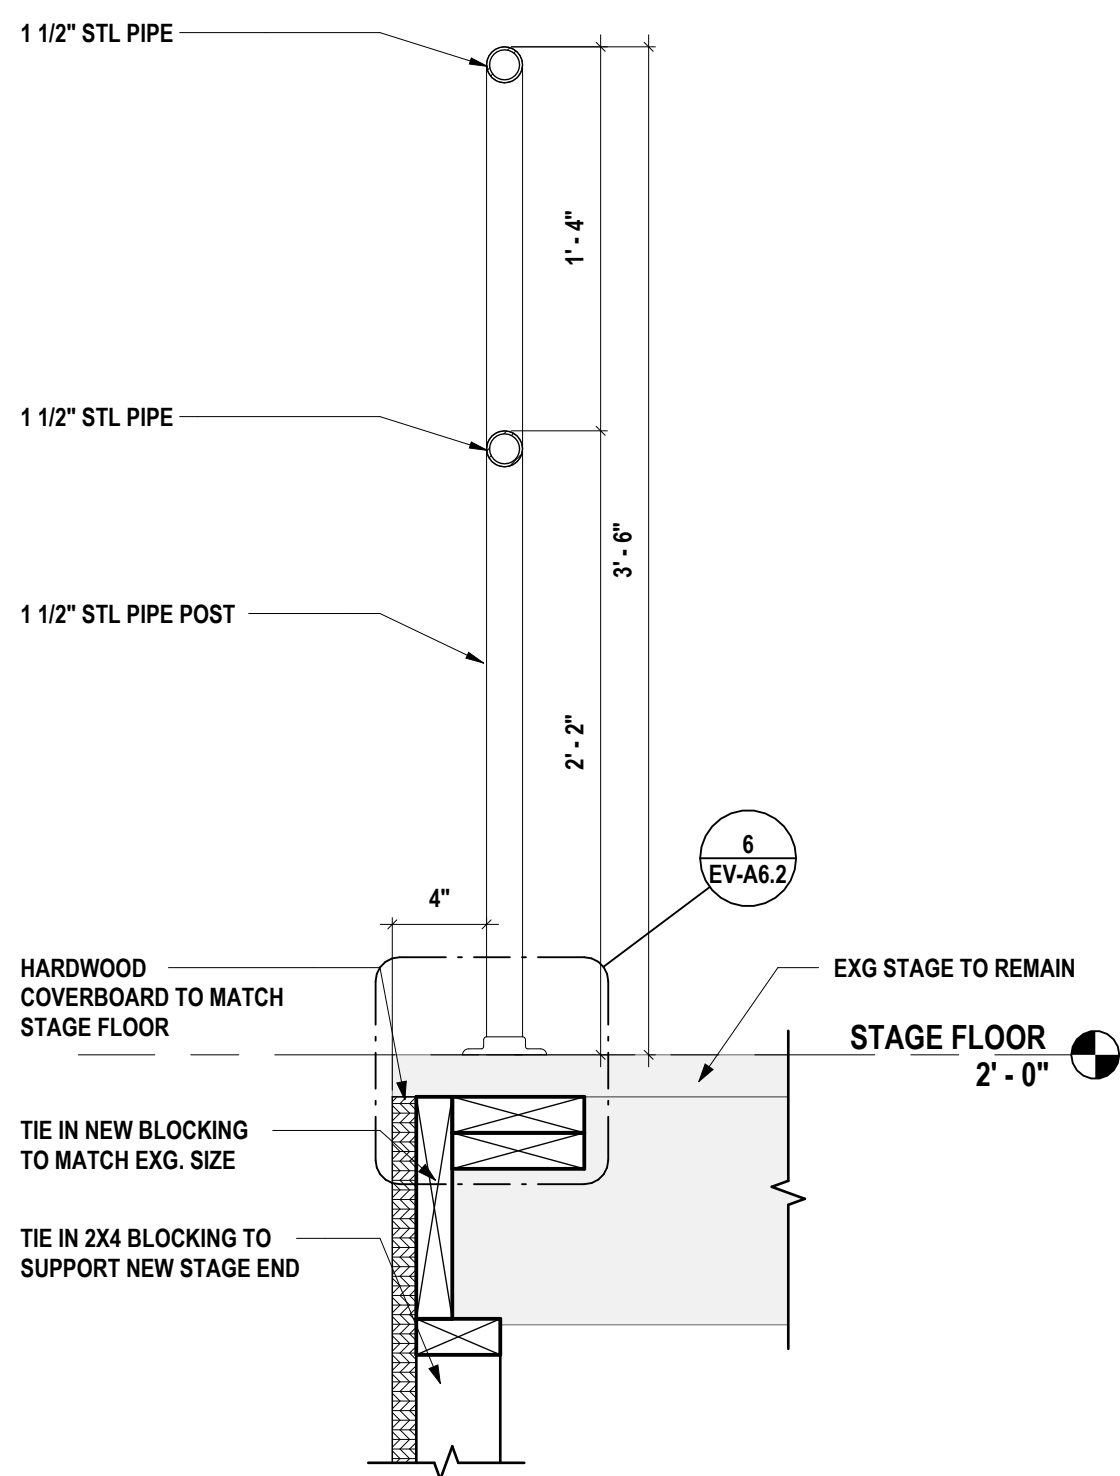


5 STAGE GUARDRAIL SECTION
1 1/2\" = 1'-0"

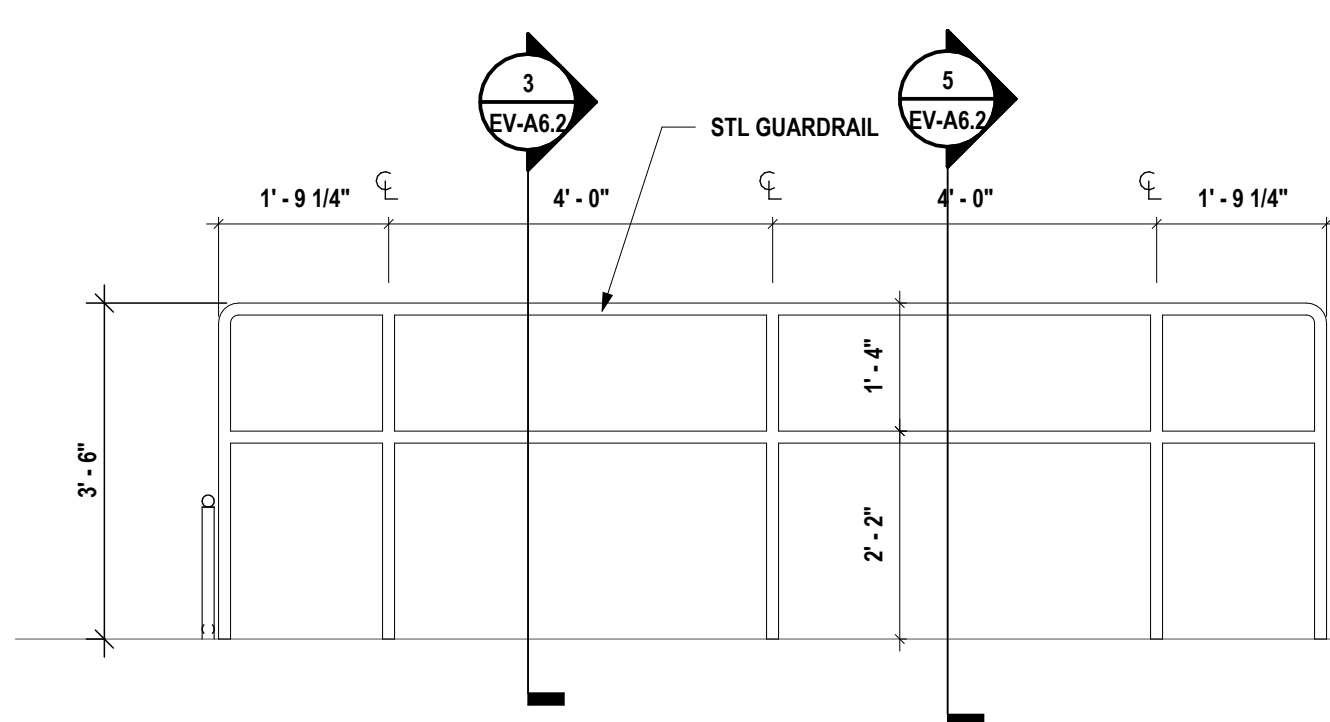


4 STAGE GUARDRAIL ELEVATION
1/2\" = 1'-0"

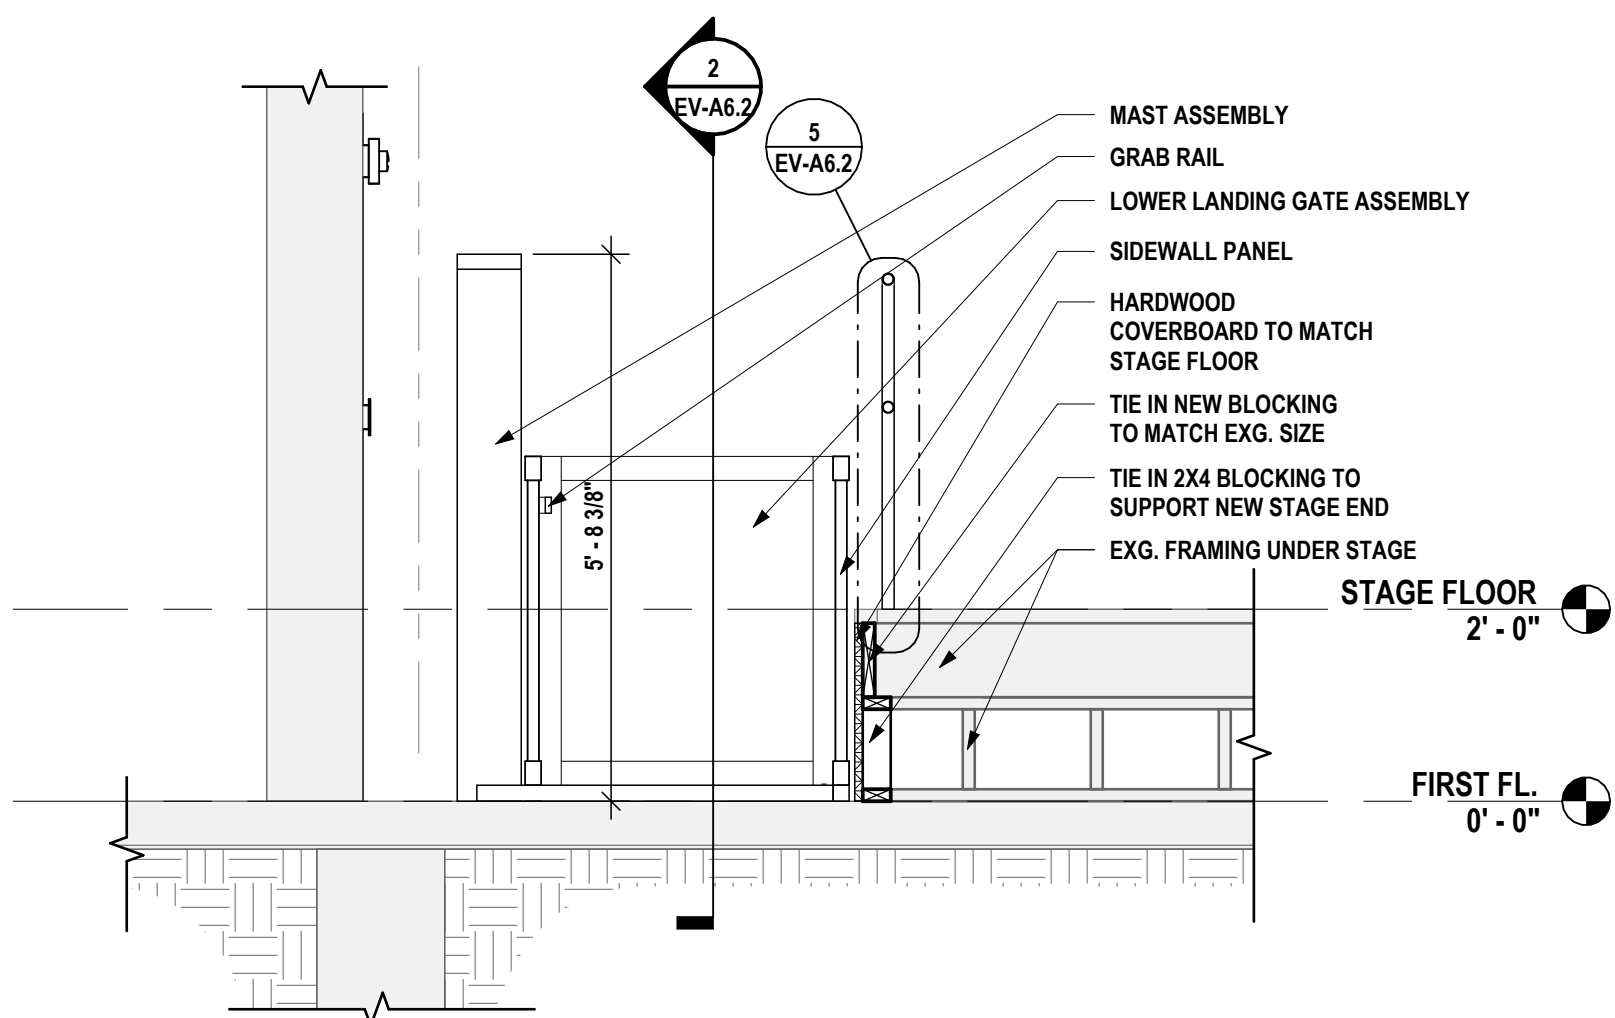

3 CHAIR LIFT SECTION - B
1/2\" = 1'-0"

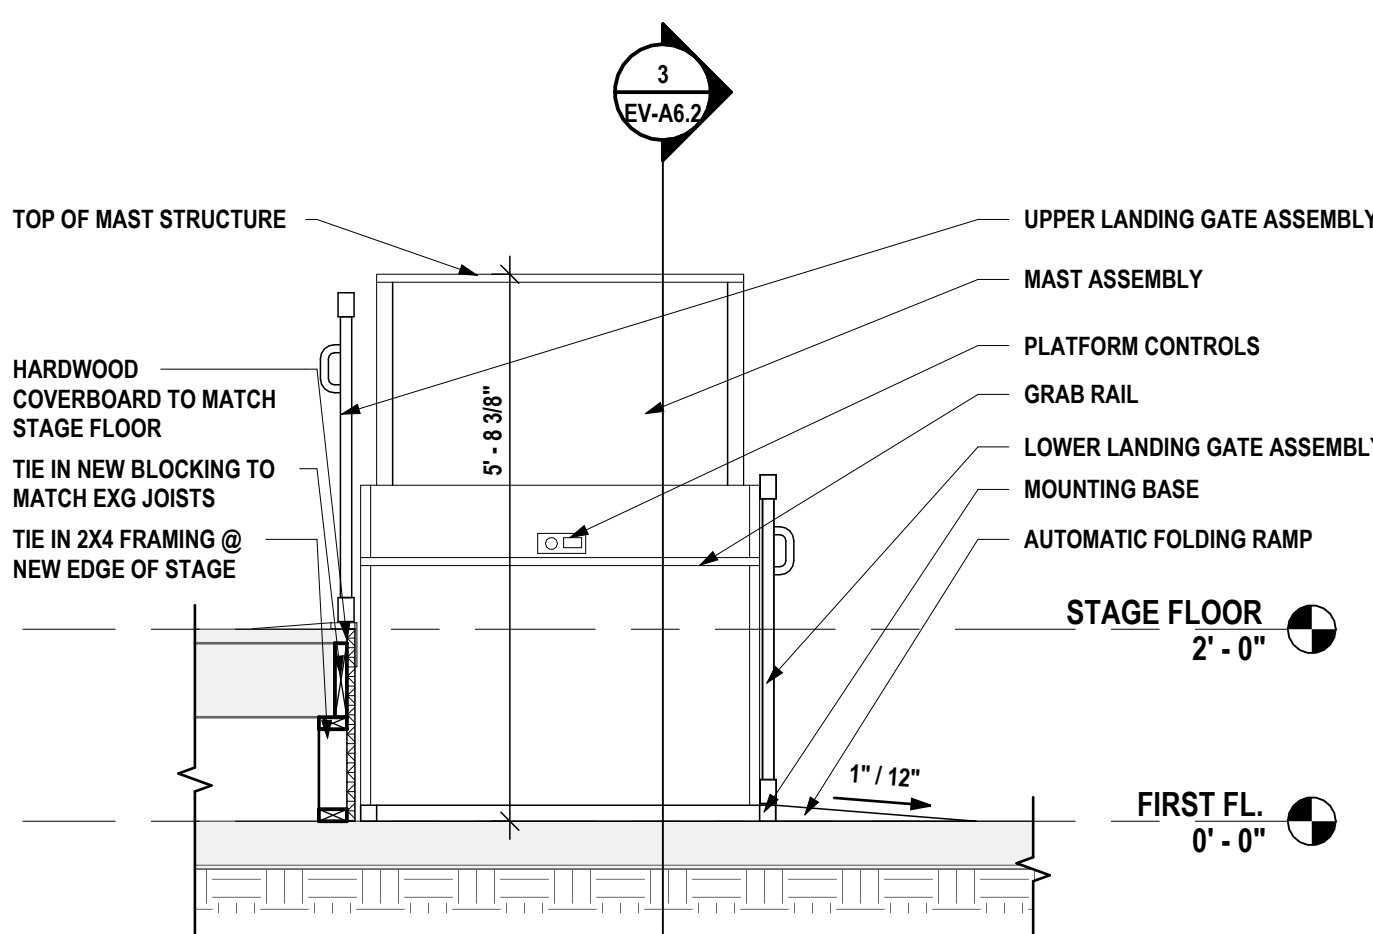

2 CHAIR LIFT SECTION - A
1/2\" = 1'-0"

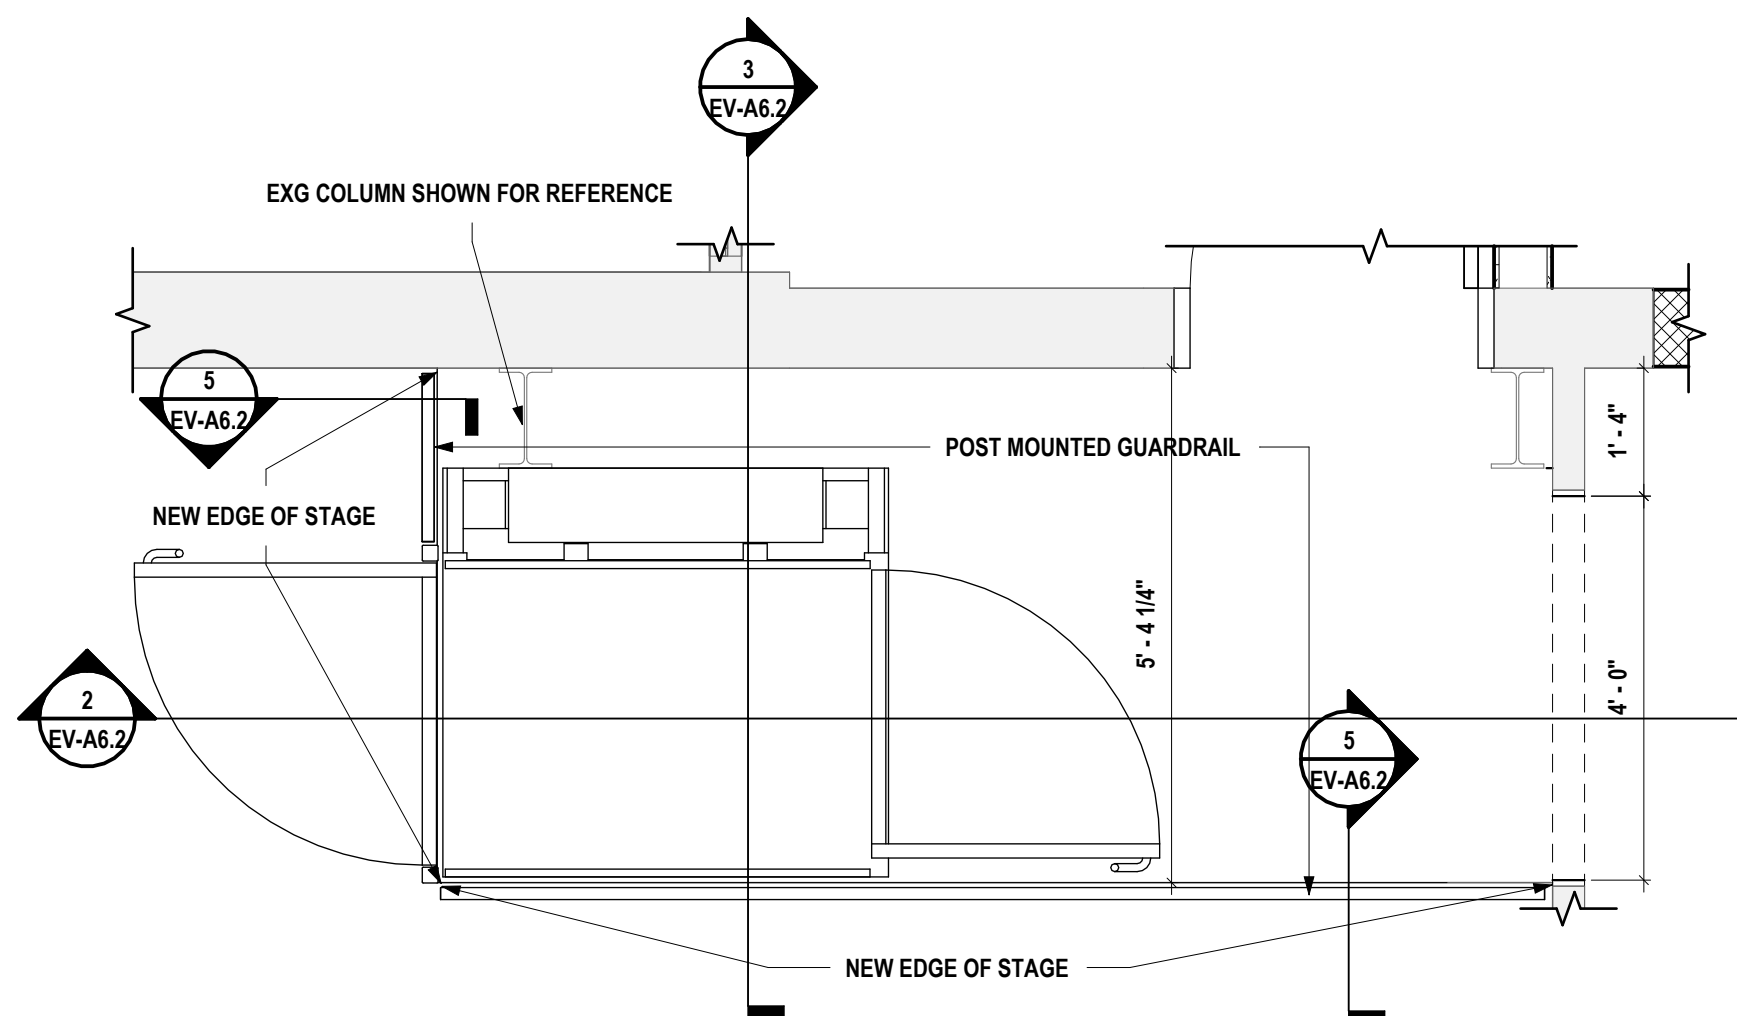

1 ENLARGED CHAIR LIFT PLAN
1/2\" = 1'-0"

SED #ERWIN VALLEY 15-10-00-01-0-00-027 ADMIN BUILDING 15-10-00-01-1-001-013

STAIR PLANS & DETAILS

2025 ERWIN VALLEY ELEM & ADMIN BUILDING ALTERATIONS

CORNING-PAINTED POST ASD

16 BEARTOWN ROAD, PAINTED POST NY 14870

HUNT ENGINEERS | ARCHITECTS | SURVEYORS

ALBANY, NY • BINGHAMTON, NY • HORSENEADS, NY • ROCHESTER, NY

CHARTERS, NY • CANTON, NY • CATTARAUGUS, NY • CATTARAUGUS, NY

WWW.HUNT-EAS.COM 807-358-1000

NY CERTIFICATE NO. 0016320 PA CERTIFICATE NO. TSC22031464-1

EV-A6.2

PROJECT NO: 2649-160

DRAWN BY: CAM

CHECKED BY: SZ

DATE: 03/17/2026


PHASE: CD

DATE: 1 10/22/2026


REVISION: ISSUE FOR BID

"IT IS A VIOLATION OF THE LAW FOR ANY PERSON TO MAKE UNAUTHORIZED ALTERATIONS OR ADDITIONS TO PLANS BEARING A LICENSED ENGINEER'S ARCHITECT'S OR SURVEYOR'S SEAL."


Copyright 2026

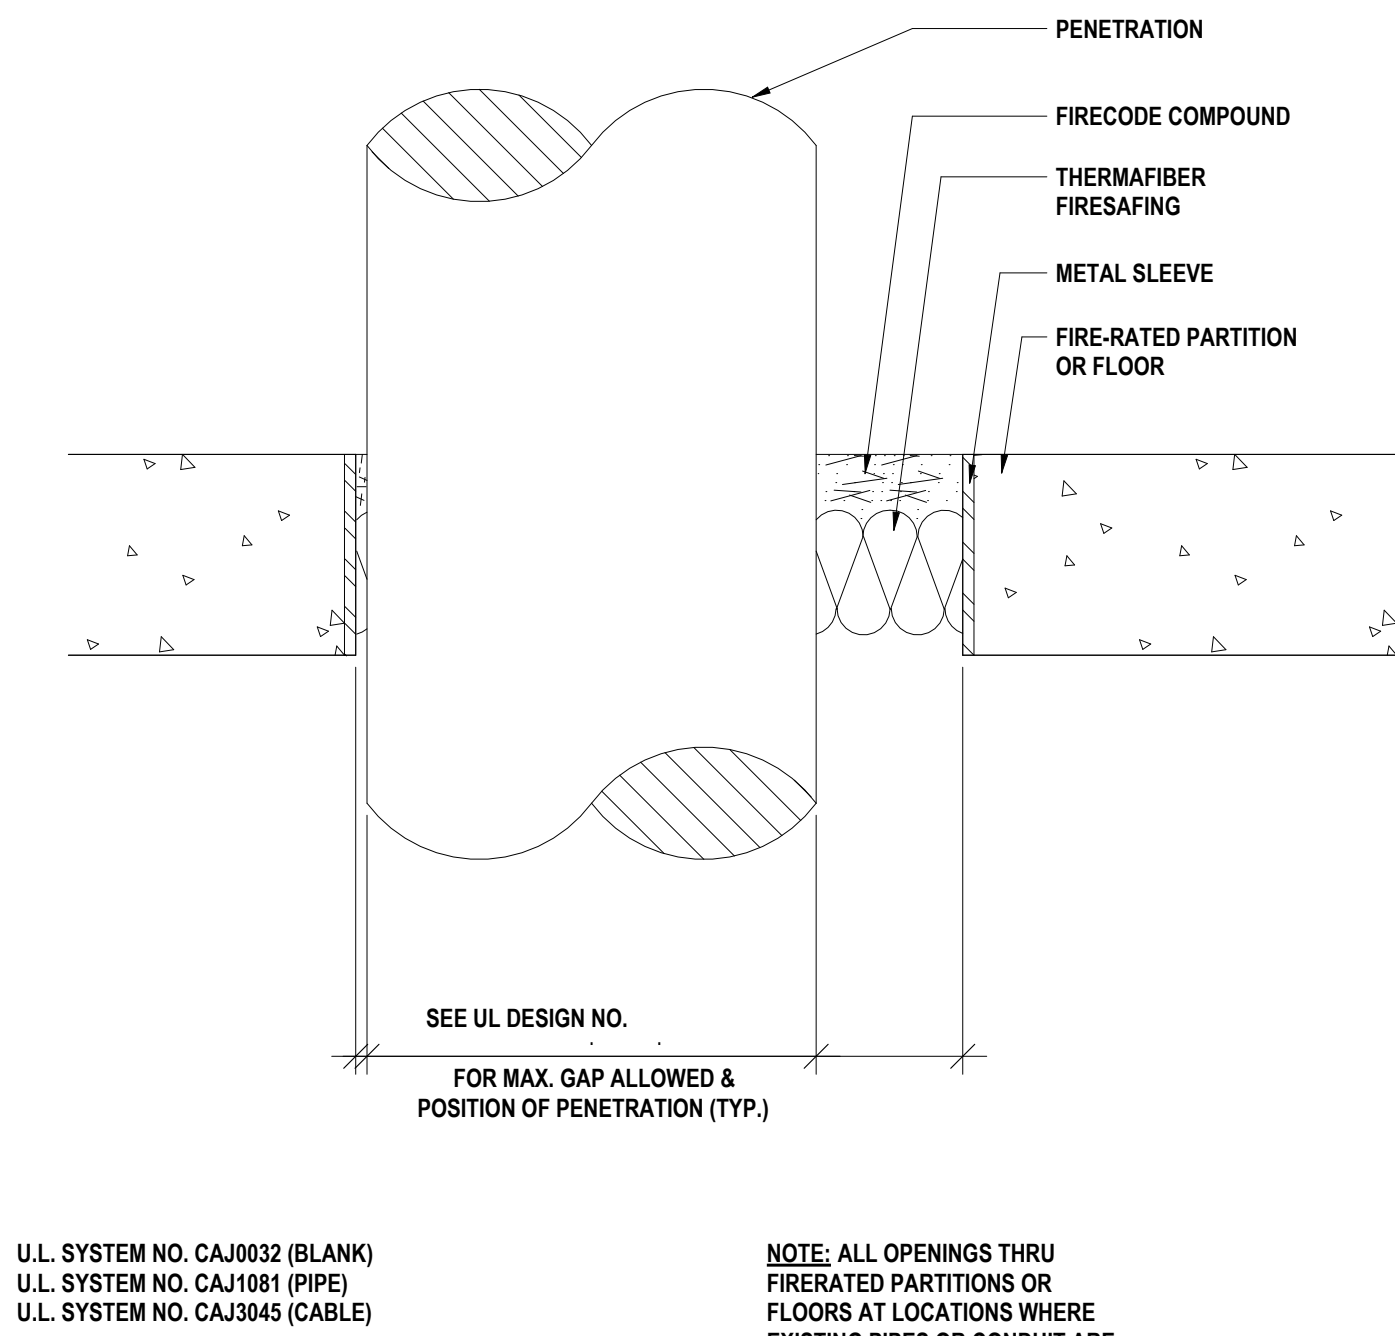


4 HORIZONTAL PENETRATION FIRESTOPPING DETAIL
1" = 1'-0"

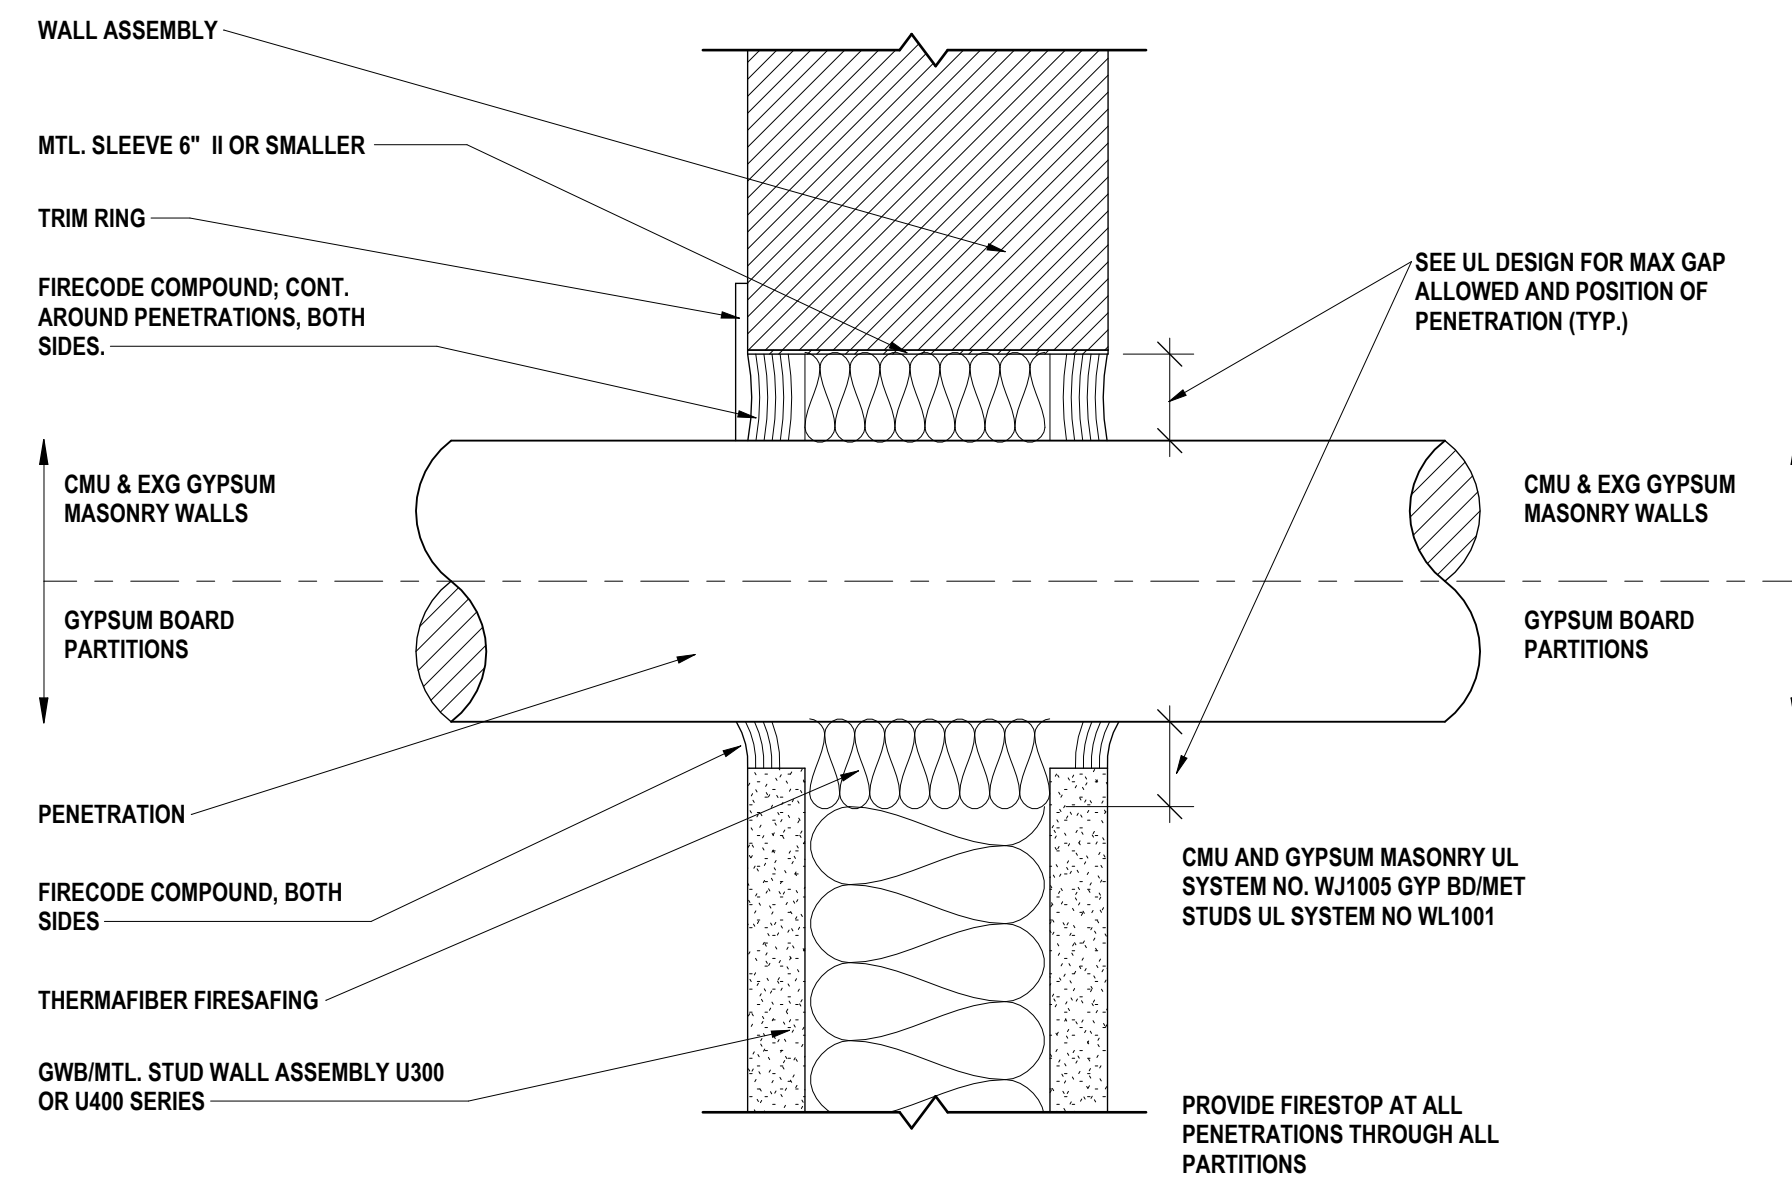

3 PENETRATION FIRESTOPPING DETAIL @ WALL
1" = 1'-0"

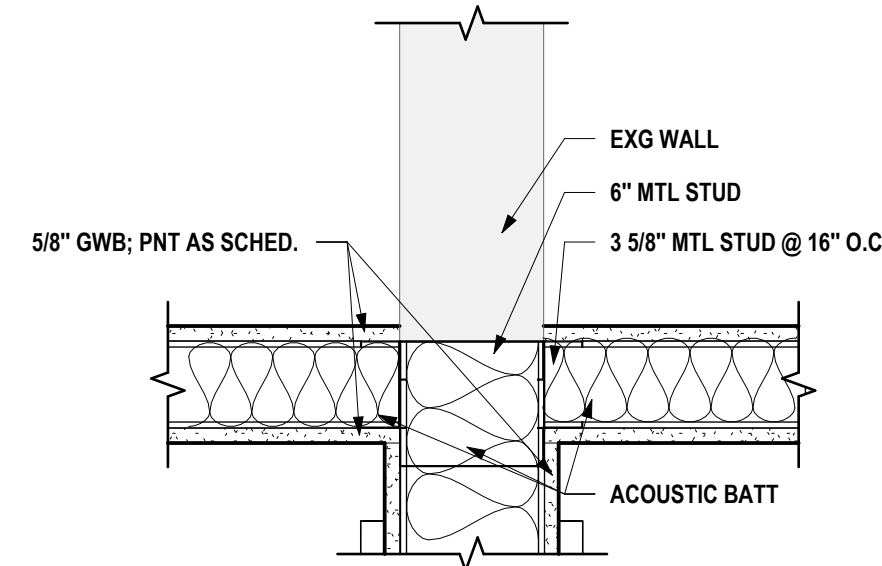


2 PLAN DETAIL @ NEW TOILET ROOMS
1 1/2" = 1'-0"

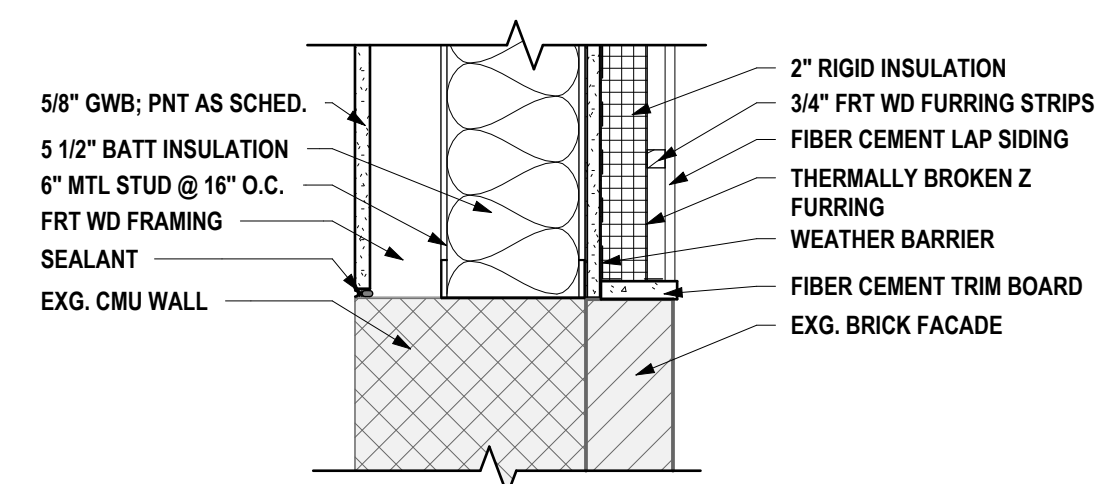


1 PLAN DETAIL @ BUILT UP SILL AND EXG. MASONRY
1 1/2" = 1'-0"

EXTERIOR PARTITION TYPES

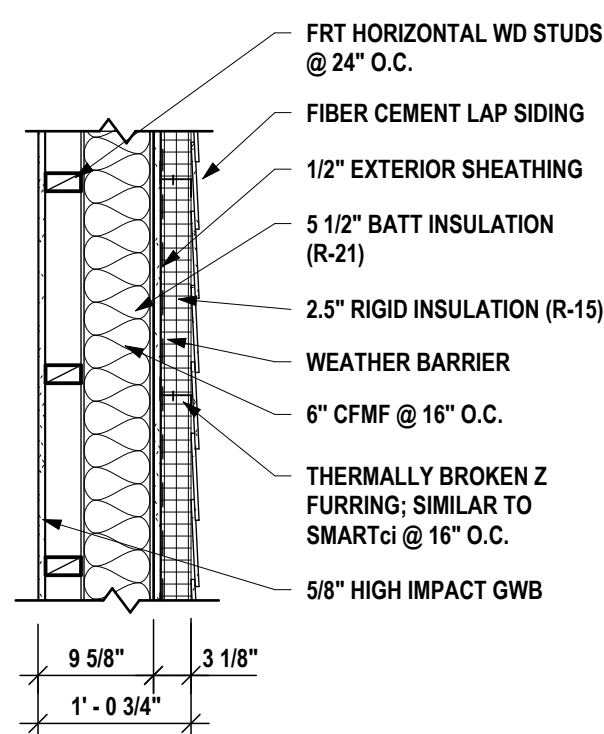


E1


INTERIOR PARTITION TYPES

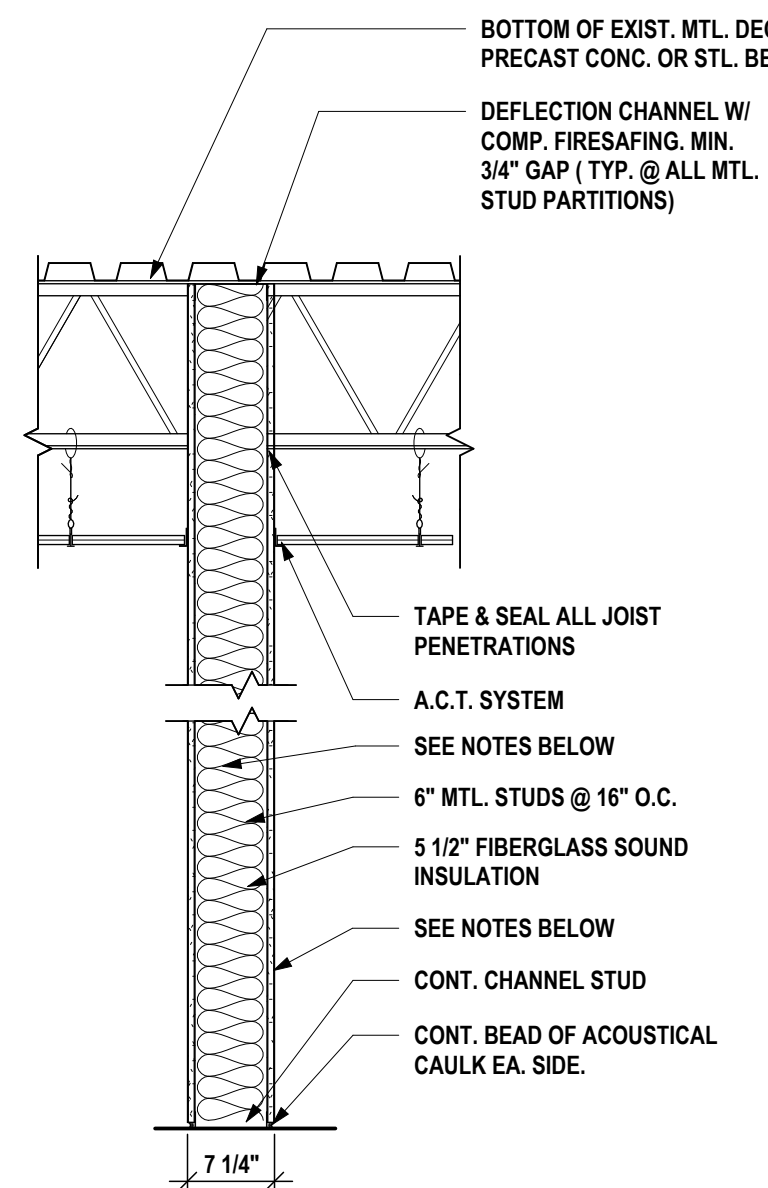


3 PARTITION TYPE
(1) LAYER 5/8" GWB EA. SIDE; MOISTURE RESISTANT GWB

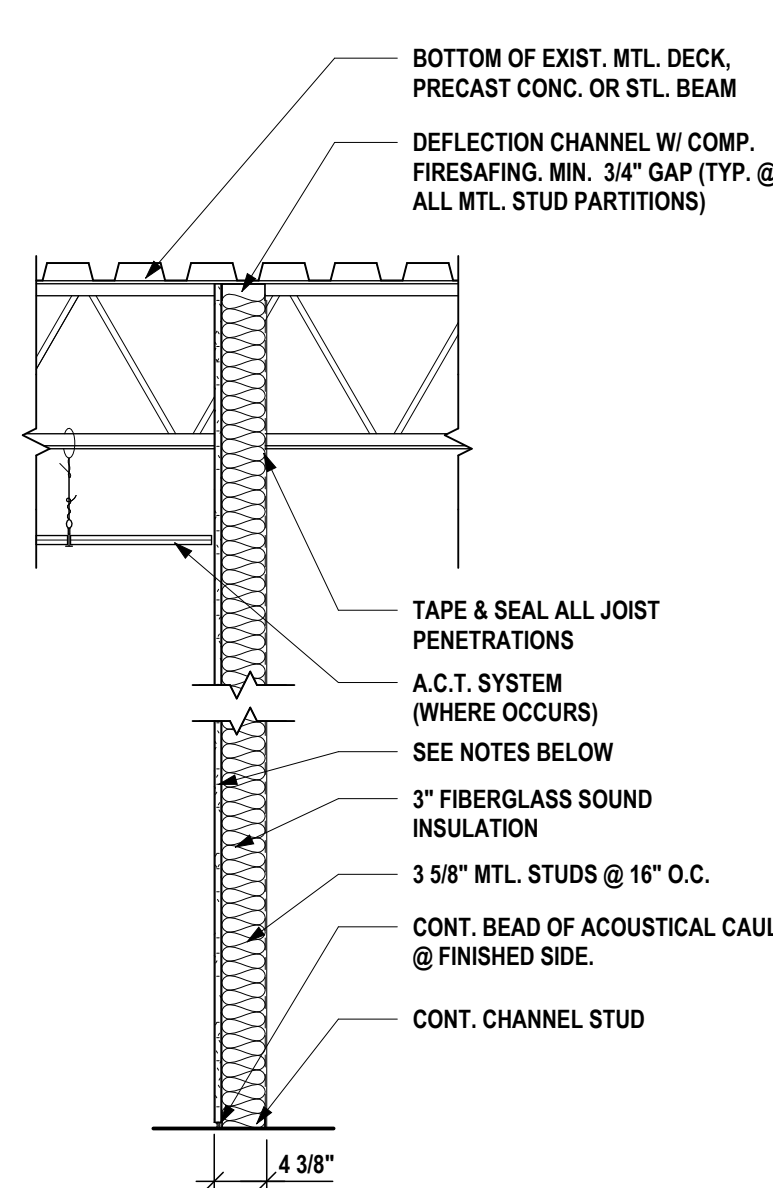

2 PARTITION TYPE
(1) LAYER 5/8" GWB ONE SIDE; MOISTURE RESISTANT GWB

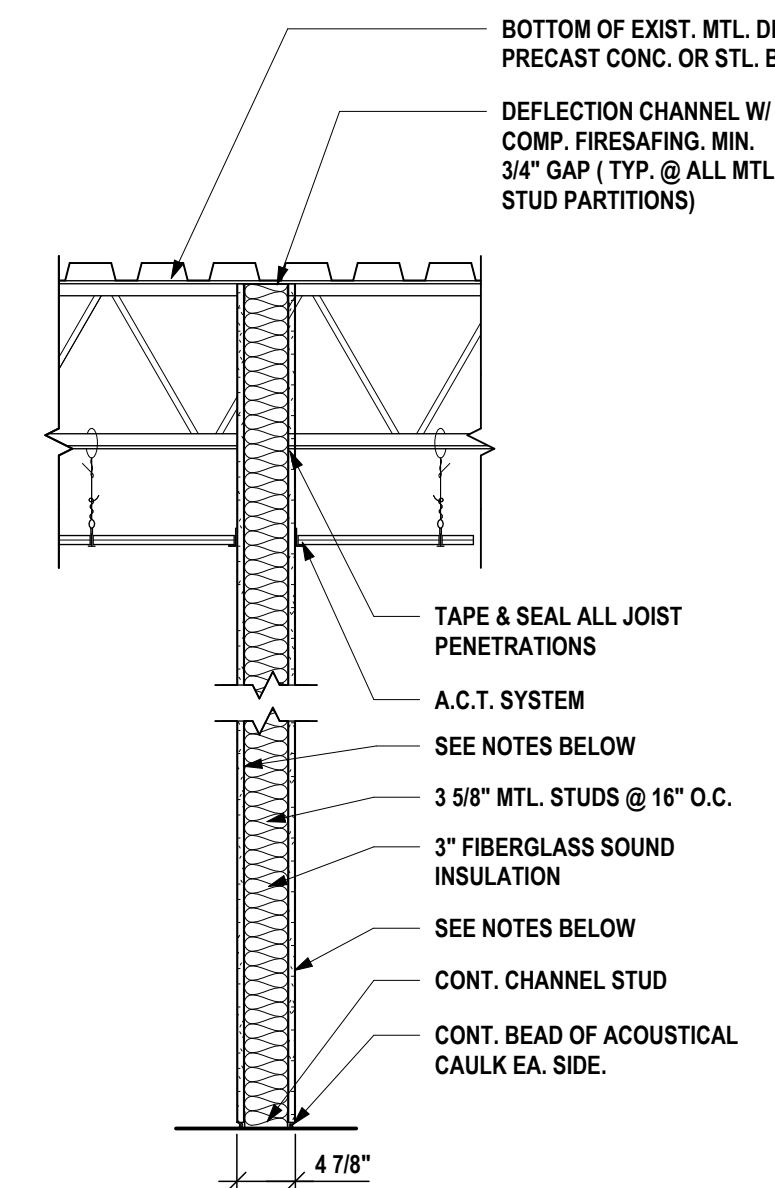

1 PARTITION TYPE
(1) LAYER 5/8" GWB EA. SIDE; MOISTURE RESISTANT GWB

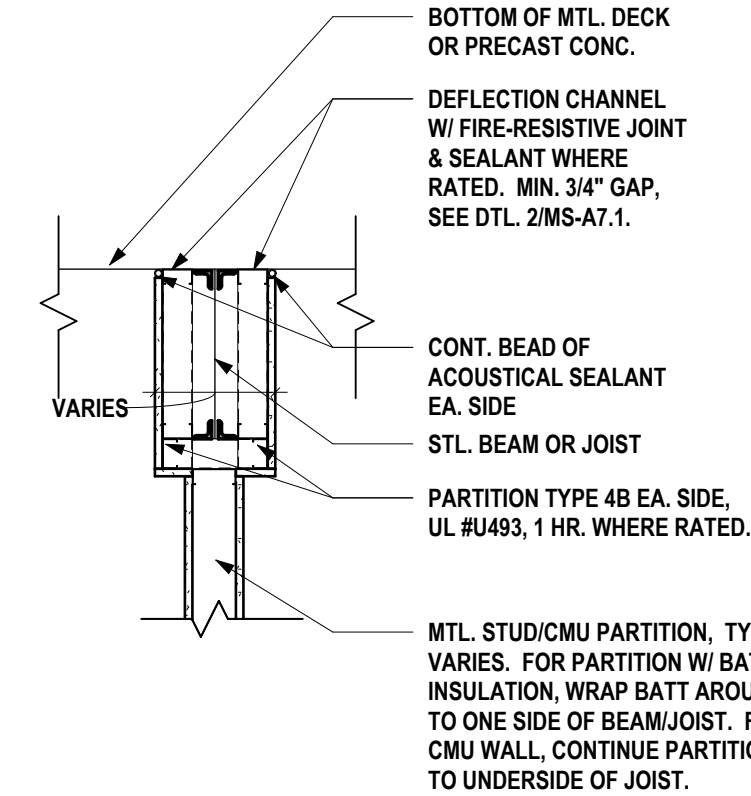

- NOTE: TOP OF WALL CONDITION AT LOCATIONS WHERE WALL INTERSECTS PARALLEL TO STEEL. TYPICAL FOR ALL PARTITIONS.
- NOTE: SEAL AND FIRESTOP ALL PENETRATIONS THROUGH ALL PARTITIONS SEE DETAILS 1-3 THIS SHEET TYPICAL ALL WALL TYPES.
- NOTE: LOCATION OF UL DESIGNATED PARTITIONS AND THE LENGTH OF THEIR FIRE RATINGS ARE INDICATED ON CODE COMPLIANCE PLANS
- NOTE: ALL WALLS TO HAVE MOISTURE RESISTANT GWB AT WITHIN 4'-0" OF WET AREAS

SED #ERWIN VALLEY 15-10-0047-0-00427; ADMIN BUILDING 15-10-0047-1-001-013

PARTITION TYPES & DETAILS

2025 ERWIN VALLEY ELEM & ADMIN BUILDING ALTERATIONS
CORNING-PAINTED POST ASD

16 BEARTOWN ROAD, PAINTED POST NY 14870

EV-A7.1


PROJECT NO: 2649-160

#	DATE:	1	10/22/2025	REVISION:	ISSUE FOR BID
DRAWN BY:	CAM	CHECKED BY:	SZ	DATE:	03/17/2026
PHASE:	CD	DATE:	03/17/2026	REVISION:	ISSUE FOR BID
"IT IS A VIOLATION OF THE LAW FOR ANY PERSON TO MAKE UNAUTHORIZED ALTERATIONS OR ADDITIONS TO PLANS BEARING A LICENSED ENGINEER'S ARCHITECT'S OR SURVEYOR'S SEAL."					

HUNT ENGINEERS | ARCHITECTS | SURVEYORS


ALBANY, NY - BINGHAMTON, NY - HORSESHOE FALLS, NY - ROCHESTER, NY
100 HUNTERS LANE, SUITE 200, ALBANY, NY 12205
WWW.HUNT-EAS.COM 518.358.1000

NY CERTIFICATE NO. 0016320 PA CERTIFICATE NO. TSC22031464-1

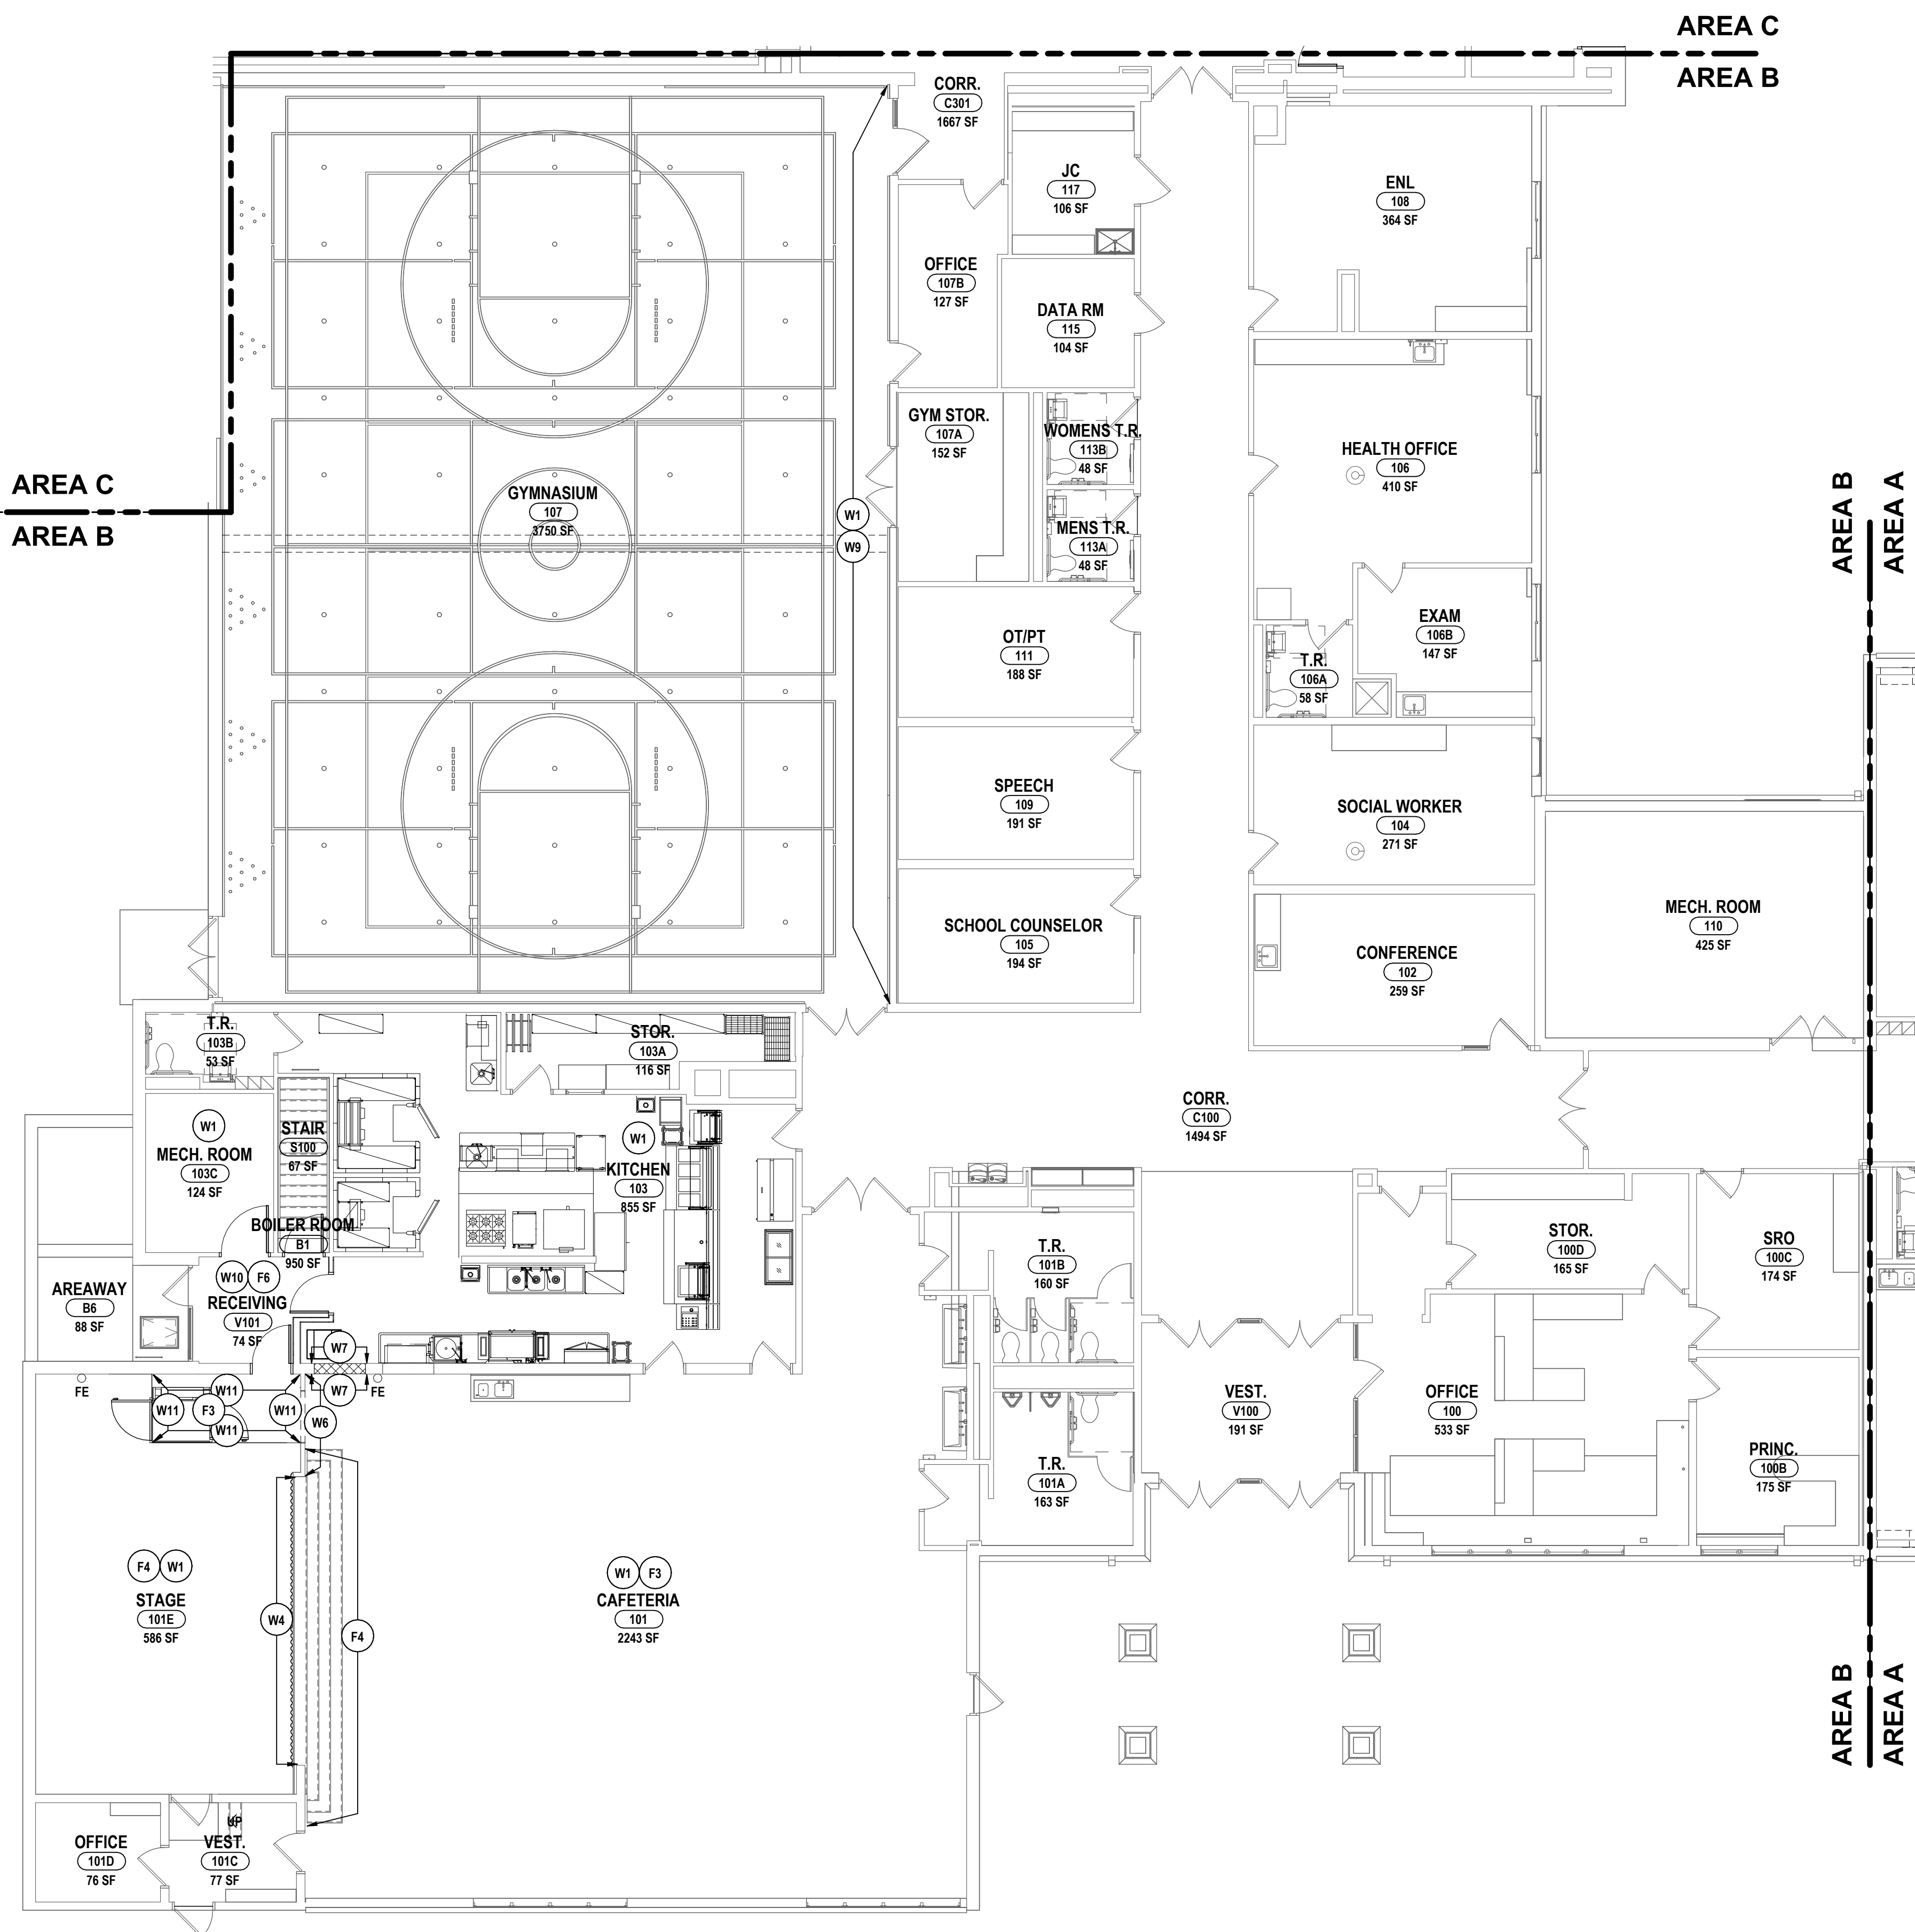


1 FIRST FLOOR AND WALL FINISH PLAN - AREA B
1/8" = 1'-0"

FLOOR FINISH LEGEND:

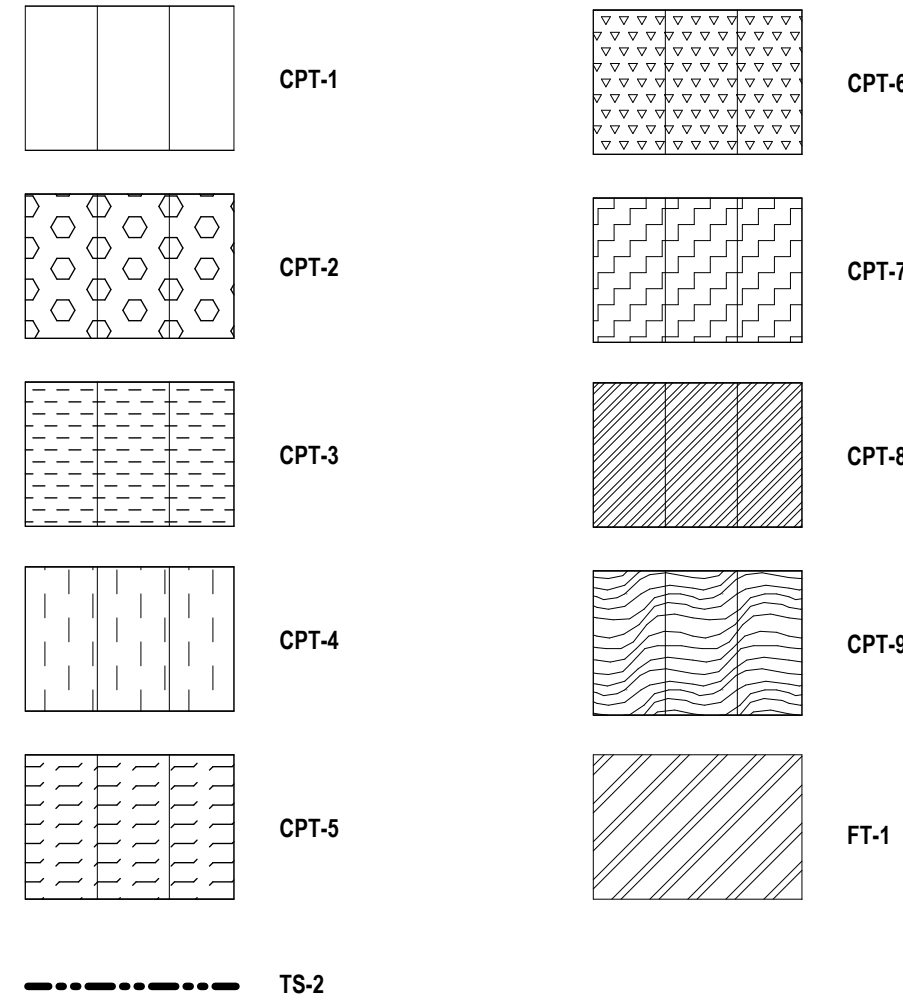

WALL FINISH LEGEND

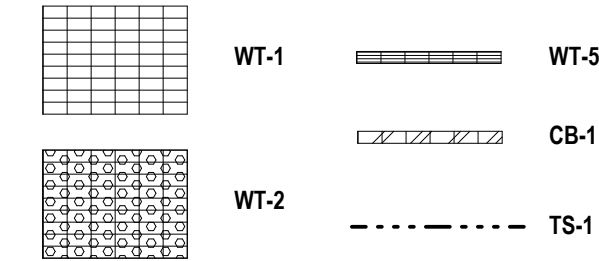

GENERAL NOTES - INTERIOR FLOOR FINISH:

- A FLOOR FINISH PATTERNS ARE INDICATED WHERE FLOOR FINISHES WILL BE EXPOSED. ALL FLOOR FINISHES, WITH THE EXCEPTION OF CARPET, SHALL BE INSTALLED EXTENDING COMPLETELY UNDER NEW BUILT-IN CASEWORK, EVEN WHEN NOT SHOWN ON PLANS.
- B SCARIFY CONCRETE SLAB AS REQUIRED IN ORDER TO PROVIDE SMOOTH TRANSITION BETWEEN ADJACENT DISSIMILAR MATERIALS.
- C ALL FLOOR FINISHES TO TRANSITION @ CENTERLINE OF DOOR UNLESS NOTED OTHERWISE.
- D CARPETING TO EXTEND UNDER COUNTERTOPS WHERE THERE ARE NO BASE CABINETS.
- E PATCH EXISTING FLOORING TO PROVIDE SMOOTH TRANSITION @ FLOOR SETTLEMENT ALONG EXISTING CORRIDOR LINES.
- F WHERE NO PATTERN IS INDICATED REFER TO FINISH SCHEDULE FOR FLOOR FINISHES. REFER TO FINISH KEY FOR ACTUAL COLORS AND FINISHES.
- G INSTALL NEW WOOD STRIP FLOORING ADJACENT TO EXISTING WOOD STRIP FLOORING DIRECTION.

CONSTRUCTION NOTES - INTERIOR FLOOR FINISH


- F1 FLOOR TO RECEIVE CARPET, CPT-1,2,3,4,5,6,7,8,9 IN INDICATED INSTALLATION PATTERN. PROVIDE RB-1 AS BASE.
- F2 FLOOR TO RECEIVE TILE, FT-1 AS INDICATED, PROVIDE CB-1,2 AS BASE AS INDICATED ON ELEVATIONS.
- F3 EXISTING FLOOR TO REMAIN, PATCH TO MATCH EXISTING FLOORING WHERE NEW FINISH WORK EFFECTS EXISTING FINISHES.
- F4 SAND AND REFINISH EXISTING WOOD FLOOR AND STAIRS USING STN-1.
- F5 RE-INSTALL EXISTING MARBLE THRESHOLD WHERE NEW FLOOR TILE MEETS EXISTING FLOORING AT DOOR THRESHOLD.
- F6 PATCH TO MATCH FLOOR TILE, FT-2 WHERE NEW WORK IMPACTS EXISTING FINISHES. PROVIDE CB-2 AS BASE.
- F7 PATCH TO MATCH RESILIENT BASE USING RB-2.

GENERAL NOTES - INTERIOR WALL FINISH:

- A DRAWING REPRESENTS LOCATIONS RECEIVING NEW WALL FINISHES AND INDICATES WALL ACCENTS AND/OR PATTERNS ONLY. FOR COMPLETE LIST OF FINISHES, REFER TO FINISH KEY AND SCHEDULE LOCATED ON EV-A8.1.
- B REFER TO RCPS TO VERIFY CEILING HEIGHTS AND VERIFY IN FIELD PRIOR TO START OF WORK.
- C PAINT ALL AIR DIFFUSERS AND RETURNS AT CEILING PLANE TO MATCH ADJACENT FINISH. ARCHITECT TO SELECT COLOR.
- D ALL WALLS TO BE PNT-1 AND ALL WINDOW/DOOR TRIMS TO BE PNT-2 UNLESS NOTED OTHERWISE.
- E WHERE NO ACCENT WALL IS INDICATED REFER TO FINISH SCHEDULE FOR PAINT LOCATION.

CONSTRUCTION NOTES - INTERIOR WALL FINISH:

- W1 EXISTING WALL FINISHES TO REMAIN IN THEIR ENTIRETY. PATCH TO MATCH EXISTING WALL FINISHES WHERE NEW WORK EFFECTS EXISTING FINISHES.
- W2 TOILET ROOM ACCENT WALL TO RECEIVE TILE, WT-1,2 AT FULL HEIGHT. REFER TO 7/EV-A8.3 FOR TILE PATTERN AND TRIM LOCATIONS.
- W3 TOILET ROOM TYPICAL WALLS TO RECEIVE TILE, WT-1,5 AT WAINSCOT HEIGHT OF 4'-0". REFER TO 6/EV-A8.3 FOR TILE PATTERN AND TRIM LOCATIONS.
- W4 PROVIDE STAGE CURTAIN, CR-1,2.
- W5 WINDOW TO RECEIVE ROLLER SHADE, WS-1.
- W6 SAND AND REFINISH EXISTING WOOD WALL PANELS, STN-2.
- W7 PATCH TO MATCH EXISTING WALL TILE USING WT-3 AND CB-3.
- W8 PROVIDE SOLID SURFACE COUNTERTOP, SSM-1.
- W9 PROVIDE SOLID SURFACE WINDOW SILL, SSM-2.
- W10 PATCH TO MATCH WALL TILE, WT-4 WHERE NEW FINISH WORK IMPACTS EXISTING FINISHES.
- W11 CONTINUE WALL TILE AND BASE INTO NEW OPENING, WT-3 AND CB-3 AT SAME HEIGHT AS EXISTING TILE, PROVIDE PNT-1 ABOVE.

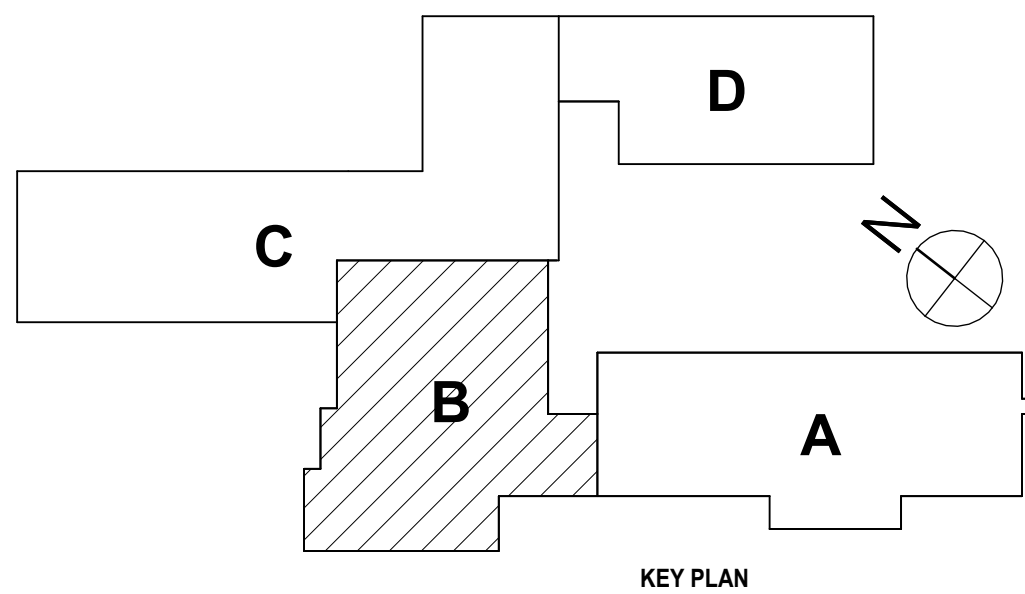

SED #ERWIN VALLEY ST-10-0001-0-000427; DOWN BUILDING ST-10-0001-1-001-013

FIRST FLOOR AND WALL FINISH PLAN - AREA B

2025 ERWIN VALLEY ELEM & ADMIN BUILDING ALTERATIONS

CORNING-PAINTED POST ASD

16 BEARTOWN ROAD, PAINTED POST NY 14870


HUNT ENGINEERS | ARCHITECTS | SURVEYORS
ALBANY, NY - BINGHAMTON, NY - HORSESHOE FALLS, NY - ROCHESTER, NY
CHAMPAIGN, IL - CHICAGO, IL - CINCINNATI, OH - CLEVELAND, OH
WWW.HUNT-EAS.COM 807-358-1000
NY CERTIFICATE NO. 0016320 PA CERTIFICATE NO. TSC220313464-1

EV-A8.2


PROJECT NO: 2649-160

DRAWN BY:		PMP
CHECKED BY:		SZ
DATE:		03/17/2026
PHASE:		CD
	REVISION:	
	ISSUE FOR BID	
#	DATE:	
1	10/22/2026	


"IT IS A VIOLATION OF THE LAW FOR ANY PERSON TO MAKE UNAUTHORIZED ALTERATIONS OR ADDITIONS TO PLANS BEARING A LICENSED ENGINEER'S ARCHITECT'S OR SURVEYOR'S SEAL."

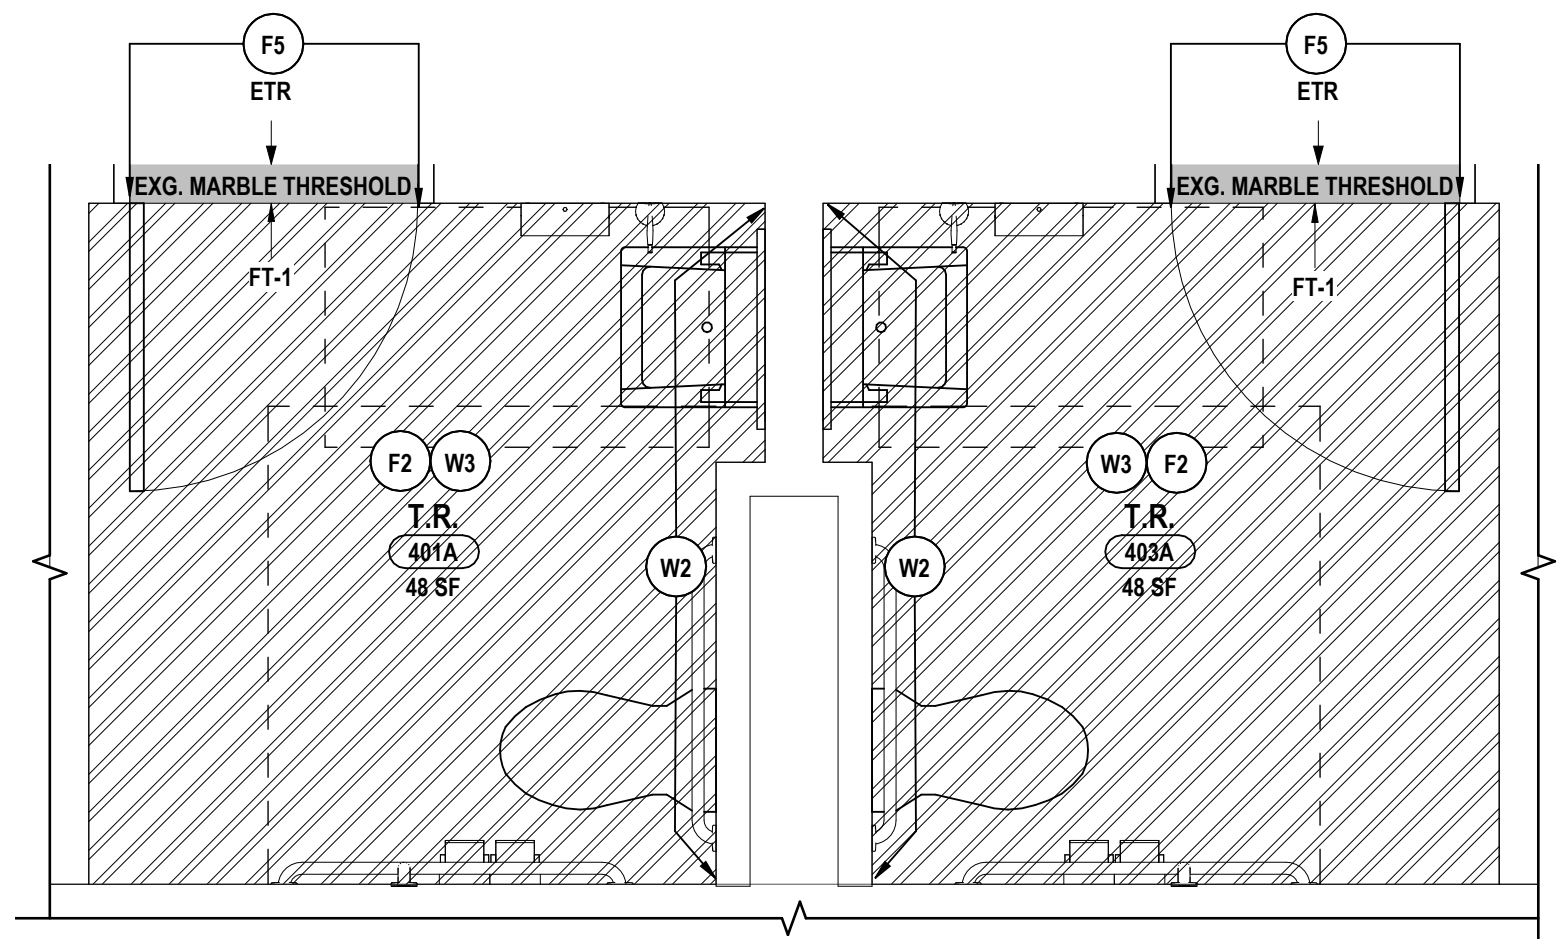


5 ALT# 1 - TOILET ROOMS 401A AND 403A
1/2" = 1'-0"

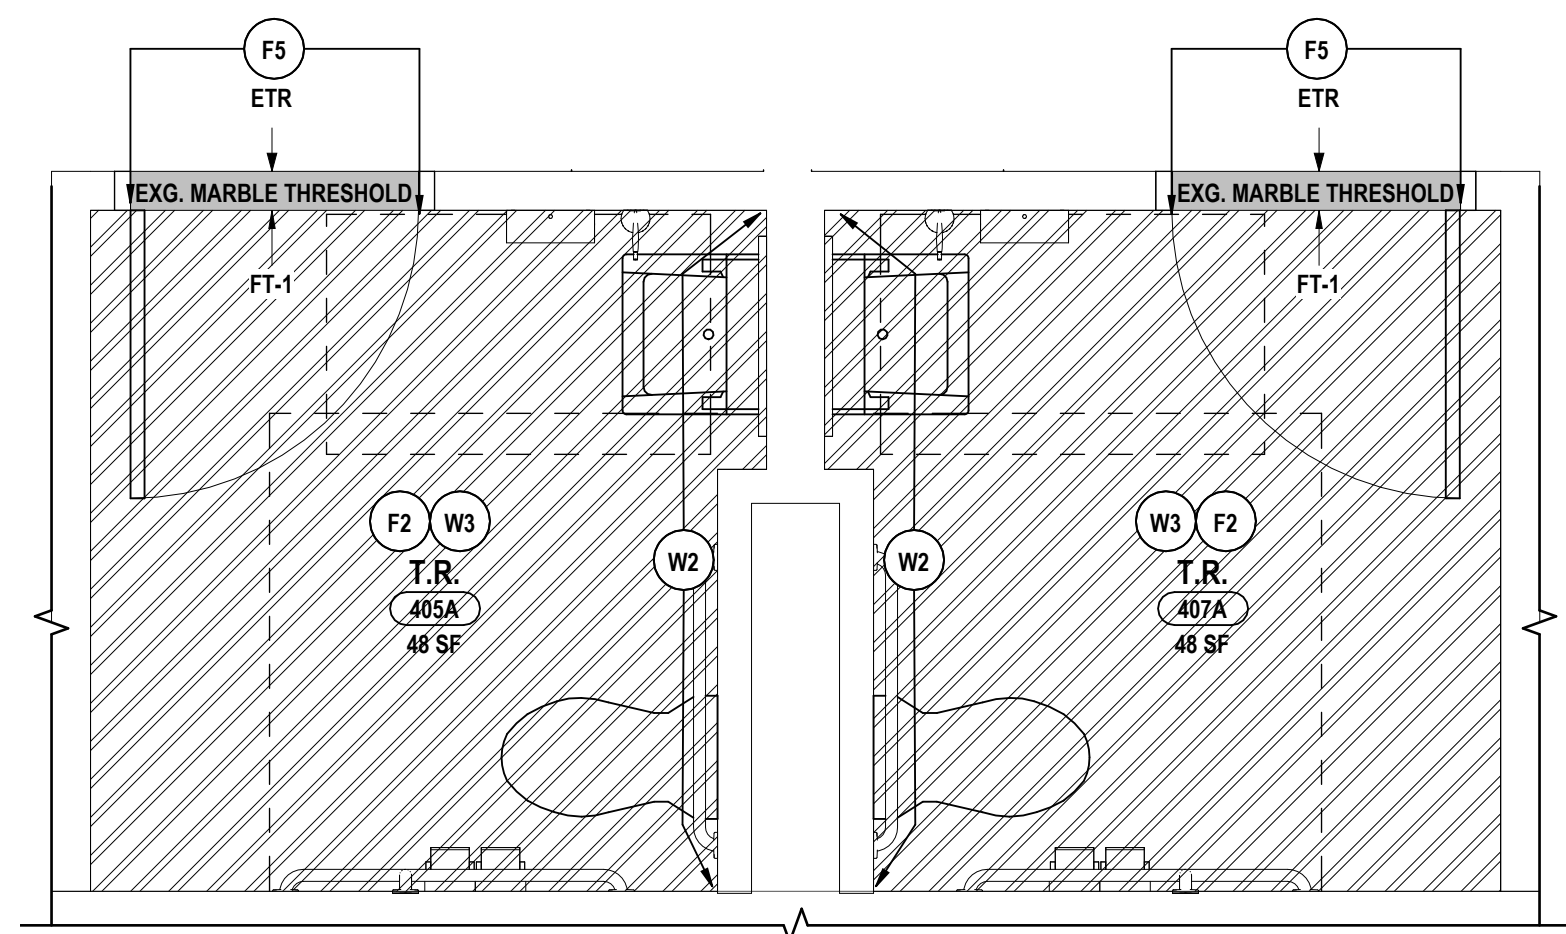


4 ALT# 1 - TOILET ROOMS 405A AND 407A
1/2" = 1'-0"

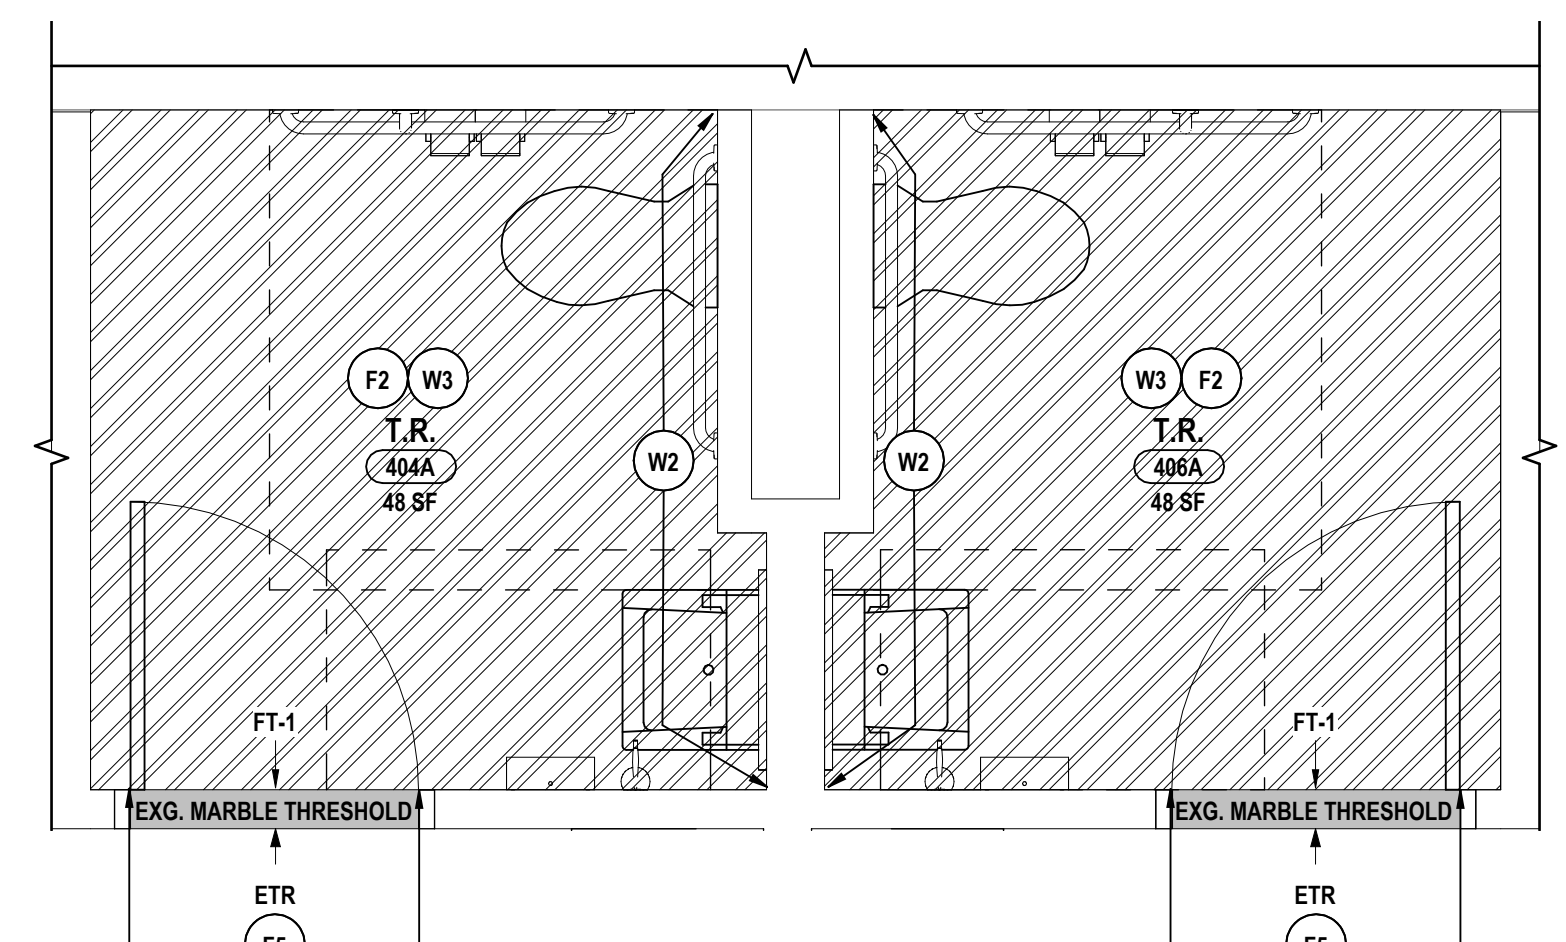


3 BASE BID - TOILET ROOMS 404A AND 406A
1/2" = 1'-0"

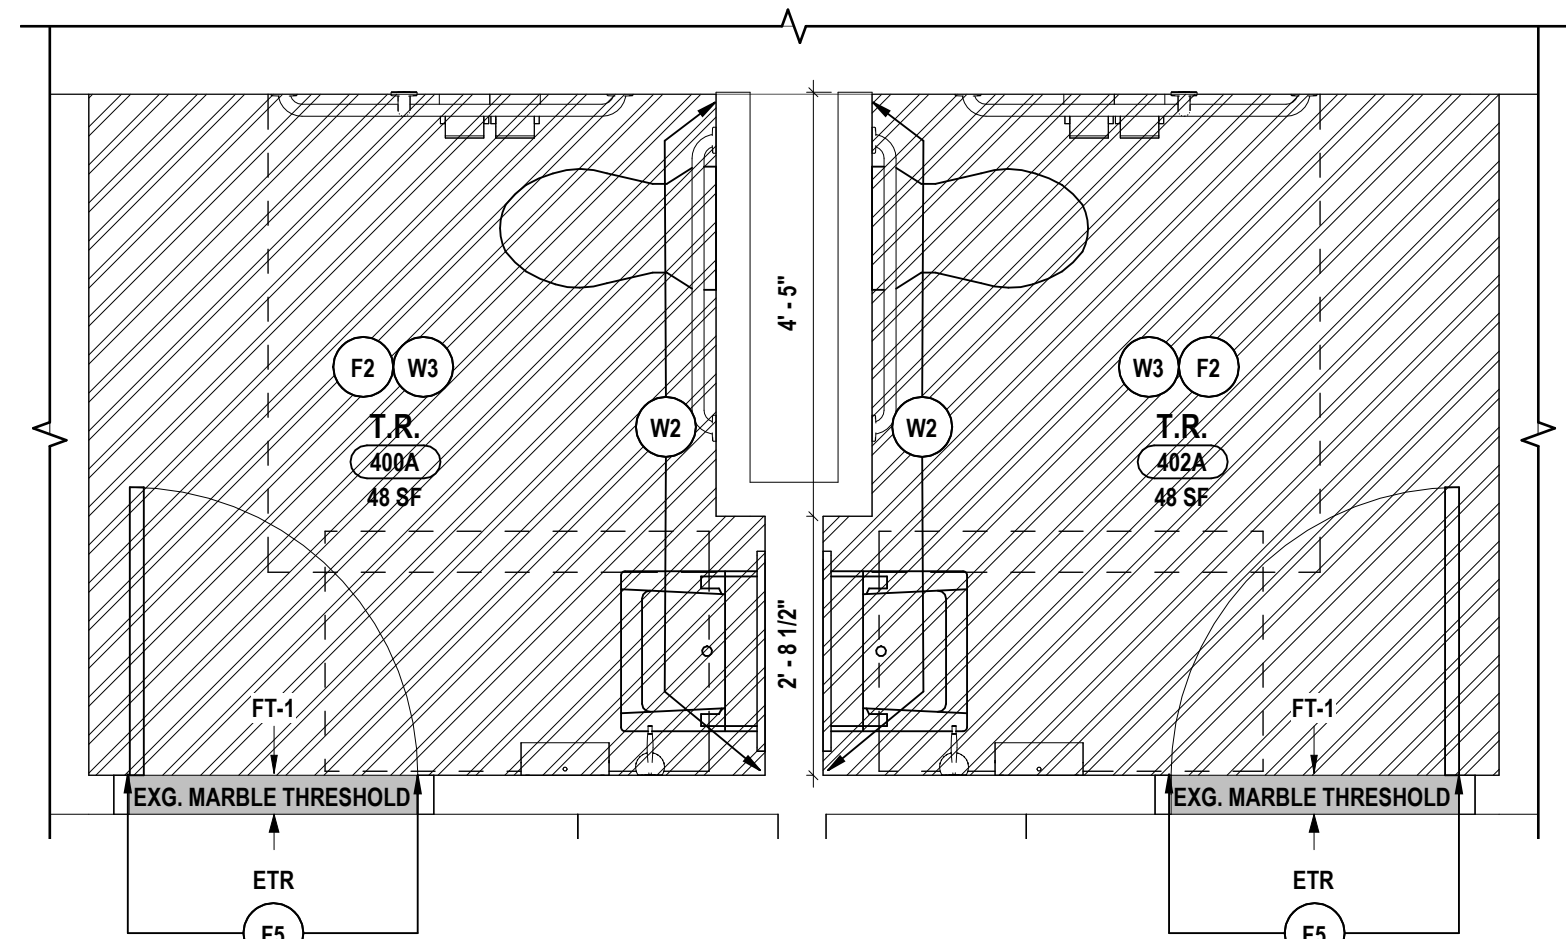

2 BASE BID - TOILET ROOMS 400A AND 402A
1/2" = 1'-0"

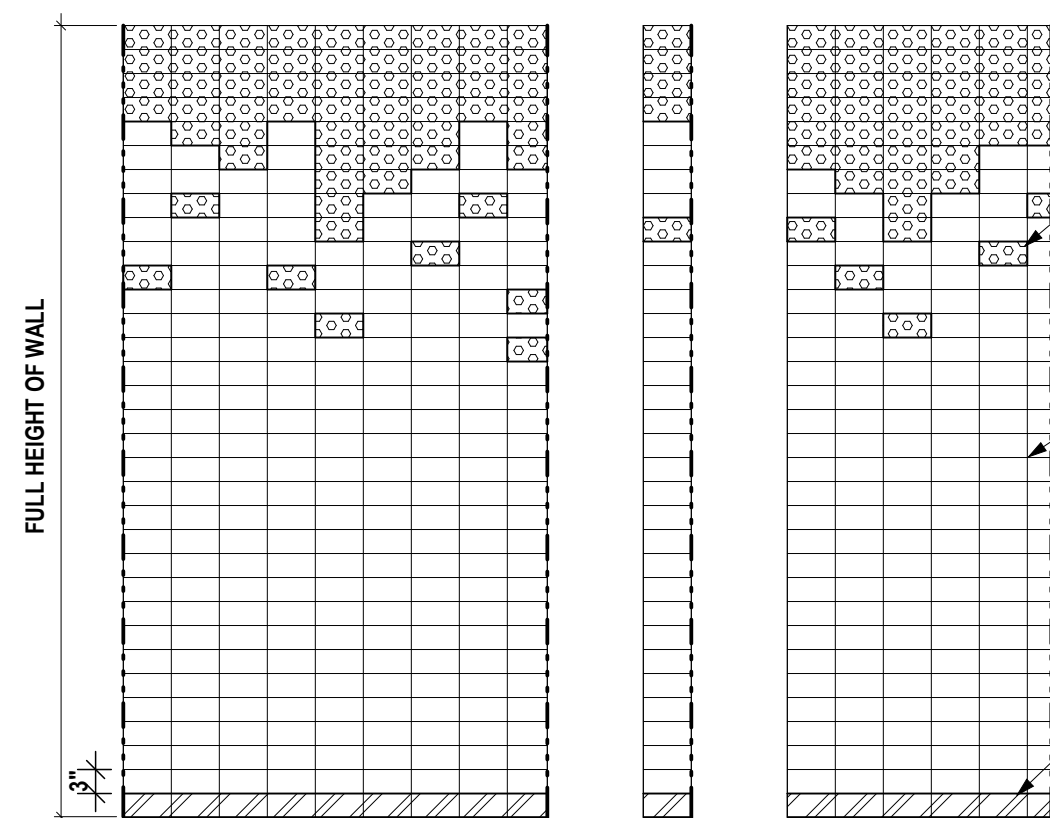


7 TYP. TOILET ROOM ACCENT WALL TILE PATTERN
1/2" = 1'-0"

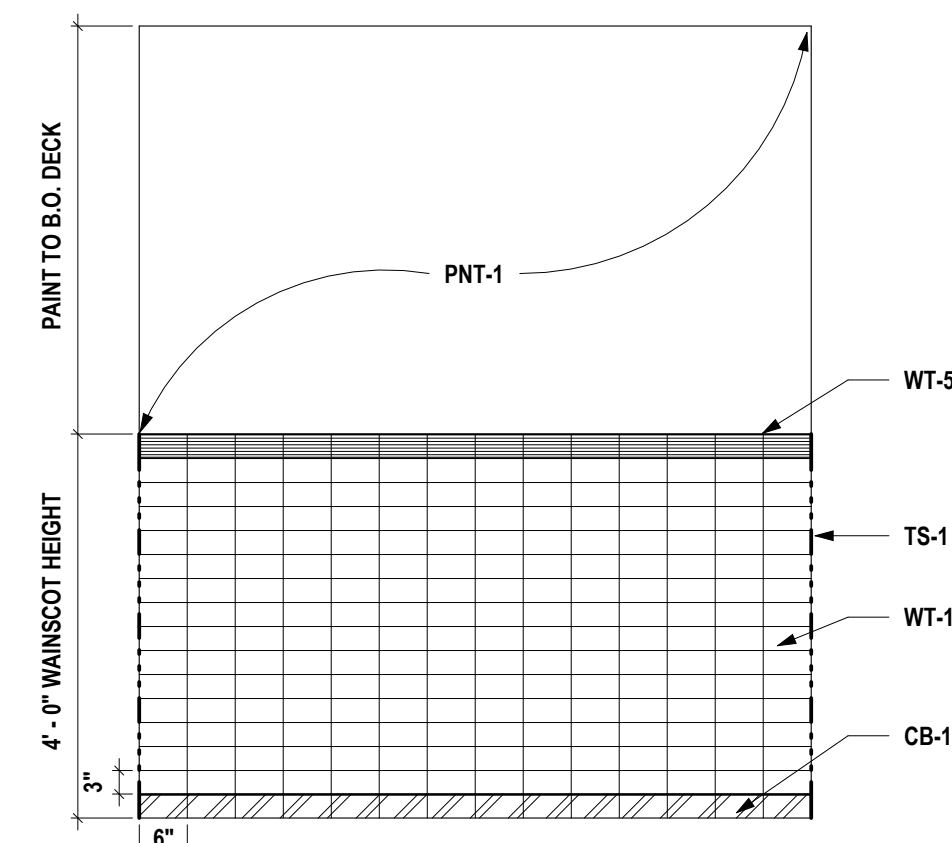


6 TYP. TOILET ROOM TYPICAL WALL TILE PATTERN
1/2" = 1'-0"

FLOOR FINISH LEGEND:

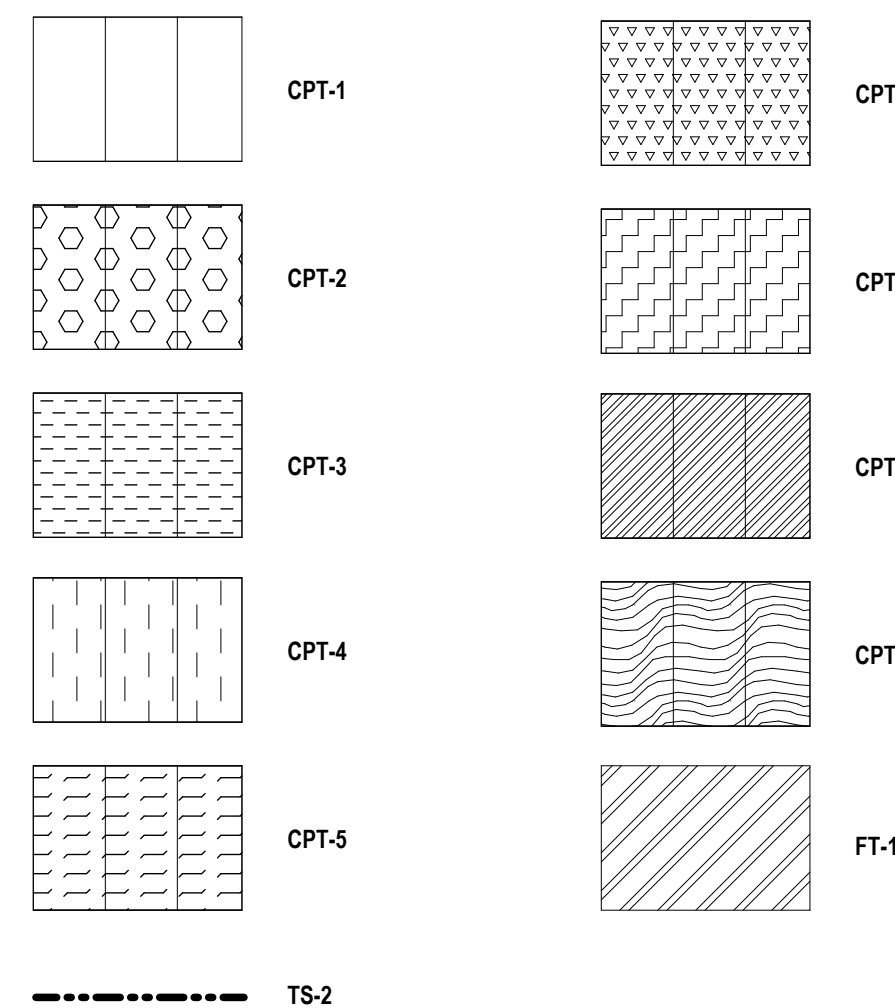

WALL FINISH LEGEND

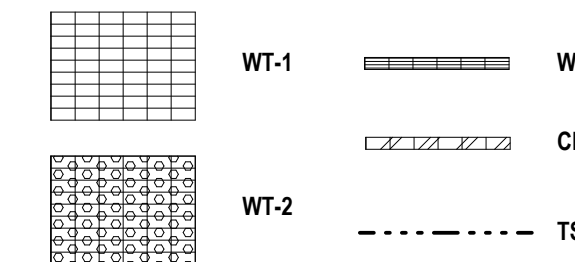

GENERAL NOTES - INTERIOR FLOOR FINISH:

- A FLOOR FINISH PATTERNS ARE INDICATED WHERE FLOOR FINISHES WILL BE EXPOSED. ALL FLOOR FINISHES, WITH THE EXCEPTION OF CARPET, SHALL BE INSTALLED EXTENDING COMPLETELY UNDER NEW BUILT-IN CASEWORK, EVEN WHEN NOT SHOWN ON PLANS.
- B SCARIFY CONCRETE SLAB AS REQUIRED IN ORDER TO PROVIDE SMOOTH TRANSITION BETWEEN ADJACENT DISSIMILAR MATERIALS.
- C ALL FLOOR FINISHES TO TRANSITION @ CENTERLINE OF DOOR UNLESS NOTED OTHERWISE.
- D CARPETING TO EXTEND UNDER COUNTERTOPS WHERE THERE ARE NO BASE CABINETS.
- E PATCH EXISTING FLOORING TO PROVIDE SMOOTH TRANSITION @ FLOOR SETTLEMENT ALONG EXISTING CORRIDOR LINES.
- F WHERE NO PATTERN IS INDICATED REFER TO FINISH SCHEDULE FOR FLOOR FINISHES. REFER TO FINISH KEY FOR ACTUAL COLORS AND FINISHES.
- G INSTALL NEW WOOD STRIP FLOORING ADJACENT TO EXISTING WOOD STRIP FLOORING DIRECTION.

CONSTRUCTION NOTES - INTERIOR FLOOR FINISH


- F1 FLOOR TO RECEIVE CARPET, CPT-1,2,3,4,5,6,7,8,9 IN INDICATED INSTALLATION PATTERN. PROVIDE RB-1 AS BASE.
- F2 FLOOR TO RECEIVE TILE, FT-1 AS INDICATED, PROVIDE CB-1,2 AS BASE AS INDICATED ON ELEVATIONS.
- F3 EXISTING FLOOR TO REMAIN, PATCH TO MATCH EXISTING FLOORING WHERE NEW FINISH WORK EFFECTS EXISTING FINISHES.
- F4 SAND AND REFINISH EXISTING WOOD FLOOR AND STAIRS USING STN-1.
- F5 RE-INSTALL EXISTING MARBLE THRESHOLD WHERE NEW FLOOR TILE MEETS EXISTING FLOORING AT DOOR THRESHOLD.
- F6 PATCH TO MATCH FLOOR TILE, FT-2 WHERE NEW WORK IMPACTS EXISTING FINISHES. PROVIDE CB-2 AS BASE.
- F7 PATCH TO MATCH RESILIENT BASE USING RB-2.

GENERAL NOTES - INTERIOR WALL FINISH:


- A DRAWING REPRESENTS LOCATIONS RECEIVING NEW WALL FINISHES AND INDICATES WALL ACCENTS AND/OR PATTERNS ONLY. FOR COMPLETE LIST OF FINISHES, REFER TO FINISH KEY AND SCHEDULE LOCATED ON EV-A8.1.
- B REFER TO RCPS TO VERIFY CEILING HEIGHTS AND VERIFY IN FIELD PRIOR TO START OF WORK.
- C PAINT ALL AIR DIFFUSERS AND RETURNS AT CEILING PLANE TO MATCH ADJACENT FINISH. ARCHITECT TO SELECT COLOR.
- D ALL WALLS TO BE PNT-1 AND ALL WINDOW/DOOR TRIMS TO BE PNT-2 UNLESS NOTED OTHERWISE.
- E WHERE NO ACCENT WALL IS INDICATED REFER TO FINISH SCHEDULE FOR PAINT LOCATION.

CONSTRUCTION NOTES - INTERIOR WALL FINISH:

- W1 EXISTING WALL FINISHES TO REMAIN IN THEIR ENTIRETY. PATCH TO MATCH EXISTING WALL FINISHES WHERE NEW WORK EFFECTS EXISTING FINISHES.
- W2 TOILET ROOM ACCENT WALL TO RECEIVE TILE, WT-1,2 AT FULL HEIGHT. REFER TO 7/EV-A8.3 FOR TILE PATTERN AND TRIM LOCATIONS.
- W3 TOILET ROOM TYPICAL WALLS TO RECEIVE TILE, WT-1,5 AT WAINSCOT HEIGHT OF 4'-0". REFER TO 6/EV-A8.3 FOR TILE PATTERN AND TRIM LOCATIONS.
- W4 PROVIDE STAGE CURTAIN, CR-1,2.
- W5 WINDOW TO RECEIVE ROLLER SHADE, WS-1.
- W6 SAND AND REFINISH EXISTING WOOD WALL PANELS, STN-2.
- W7 PATCH TO MATCH EXISTING WALL TILE USING WT-3 AND CB-3.
- W8 PROVIDE SOLID SURFACE COUNTERTOP, SSN-1.
- W9 PROVIDE SOLID SURFACE WINDOW SILL, SSN-2.
- W10 PATCH TO MATCH WALL TILE, WT-4 WHERE NEW FINISH WORK IMPACTS EXISTING FINISHES.
- W11 CONTINUE WALL TILE AND BASE INTO NEW OPENING, WT-3 AND CB-3 AT SAME HEIGHT AS EXISTING TILE, PROVIDE PNT-1 ABOVE.

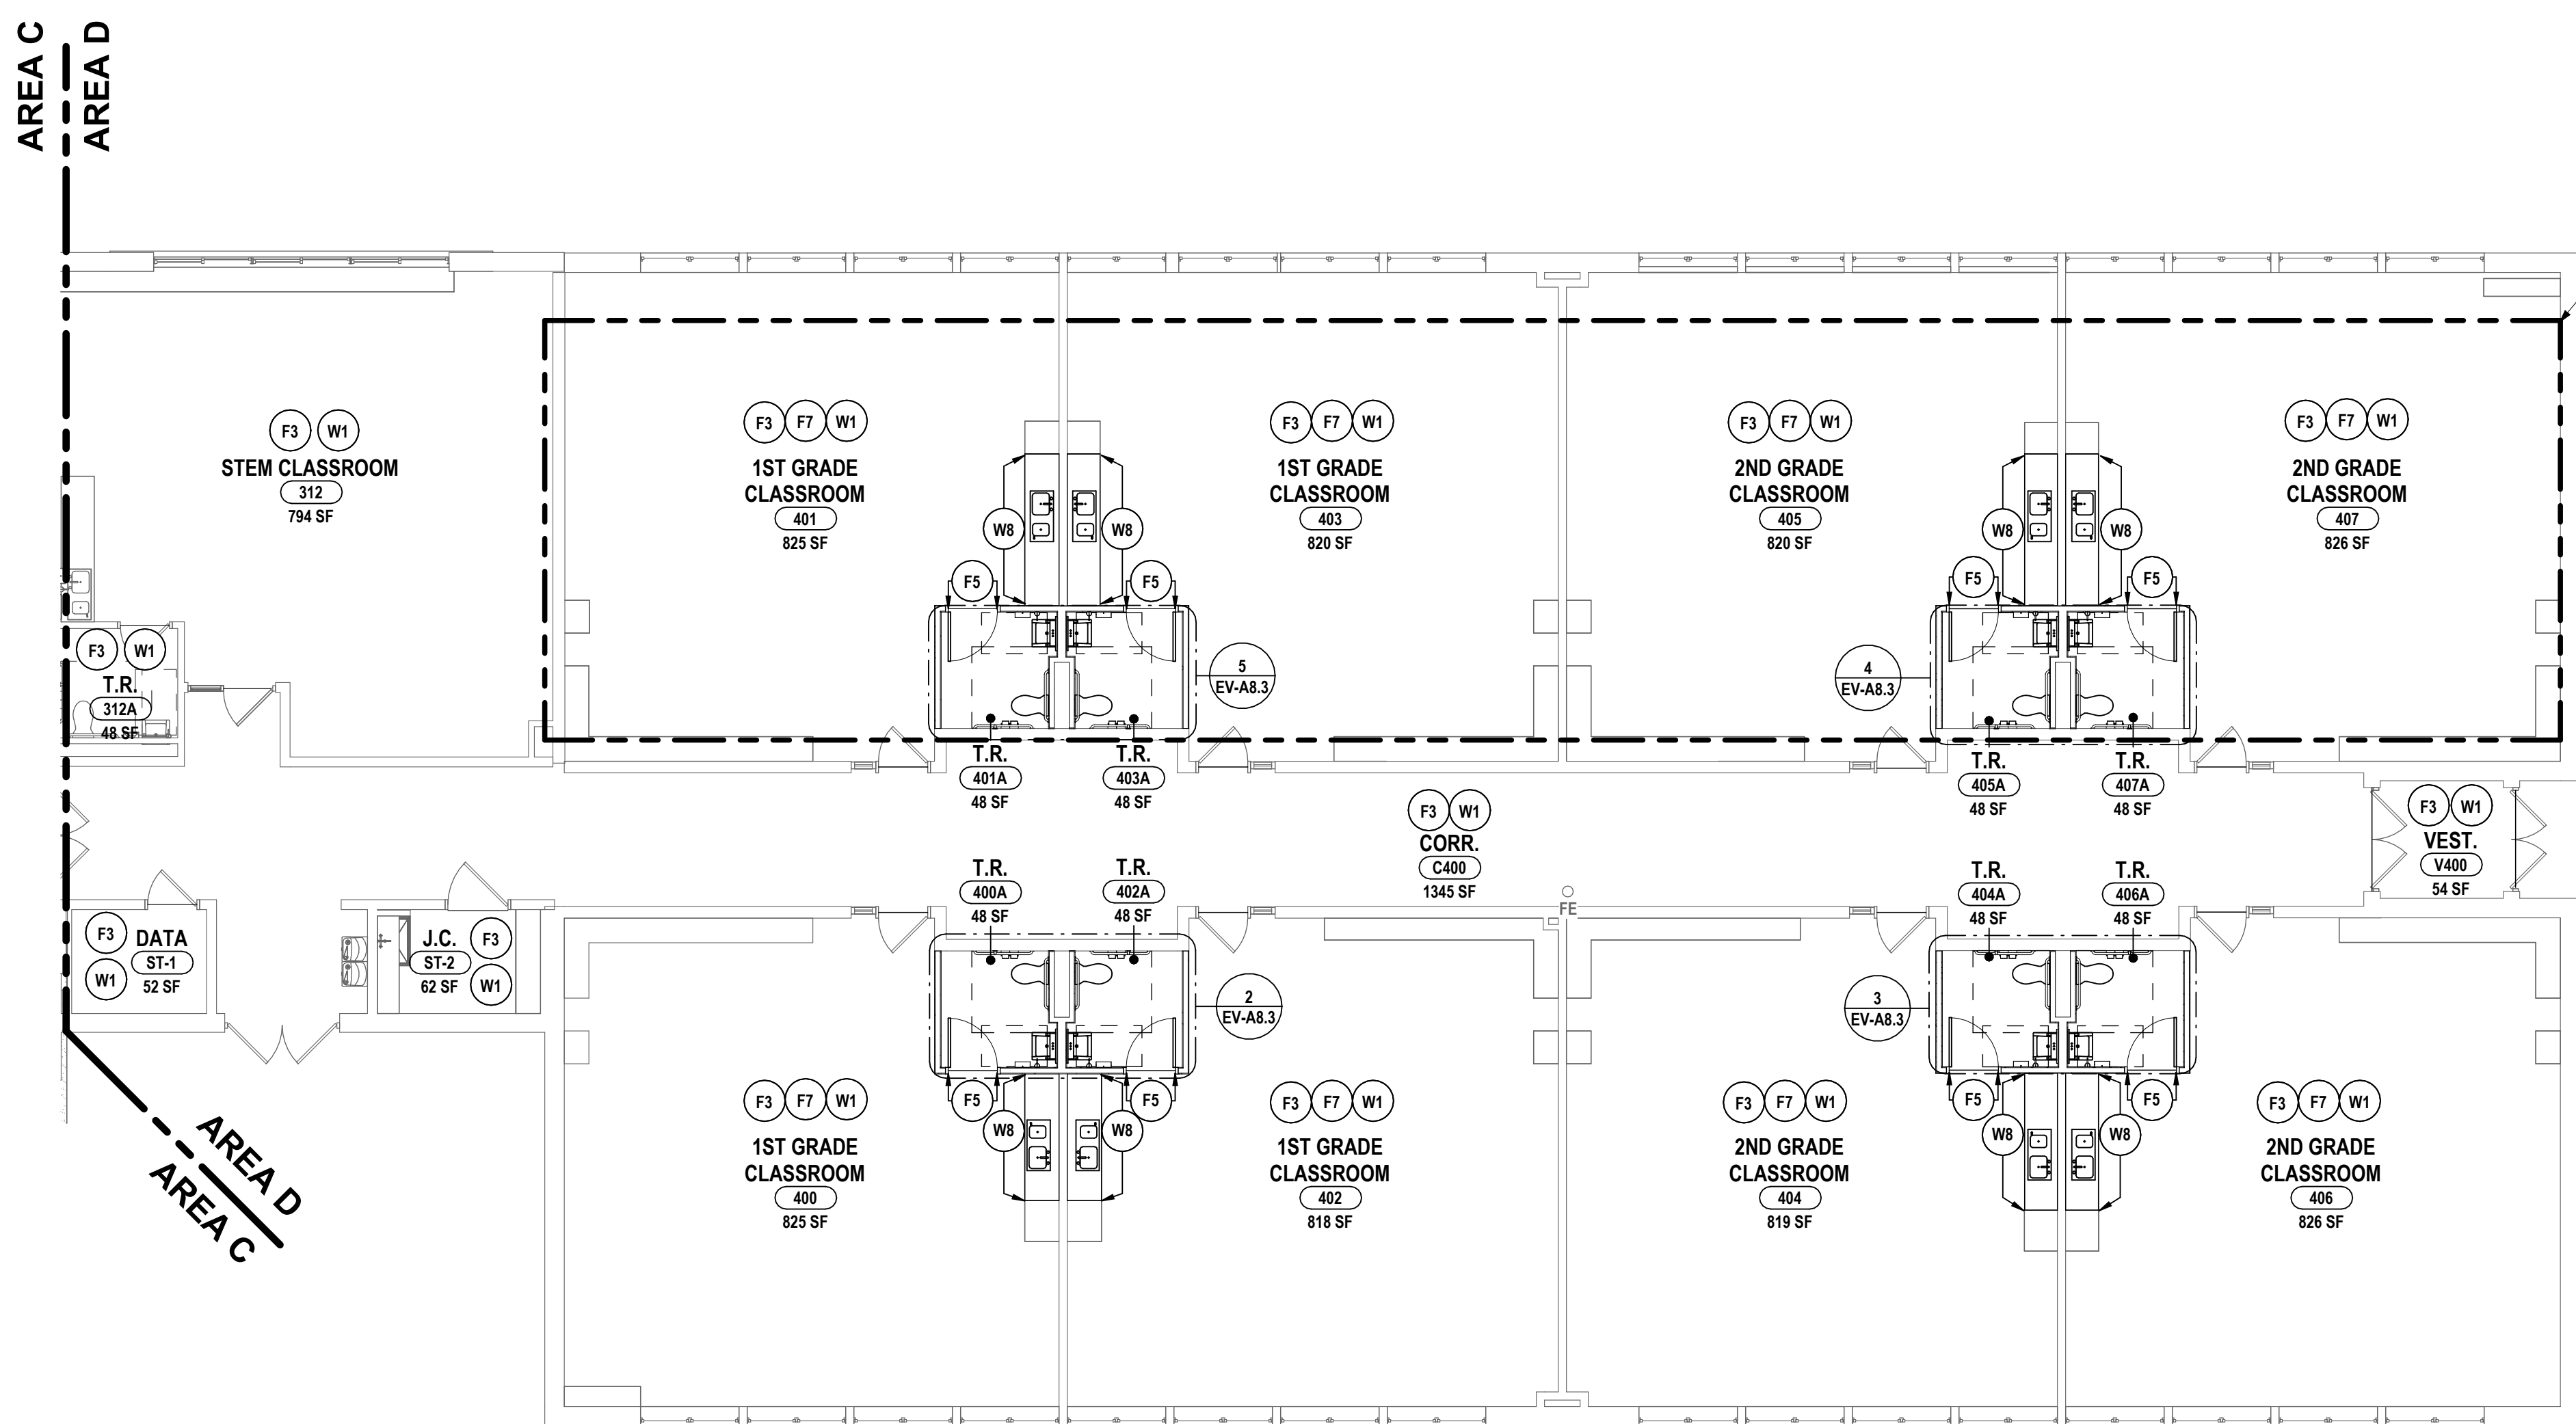

1 FIRST FLOOR AND WALL FINISH PLAN - AREA D
1/8" = 1'-0"

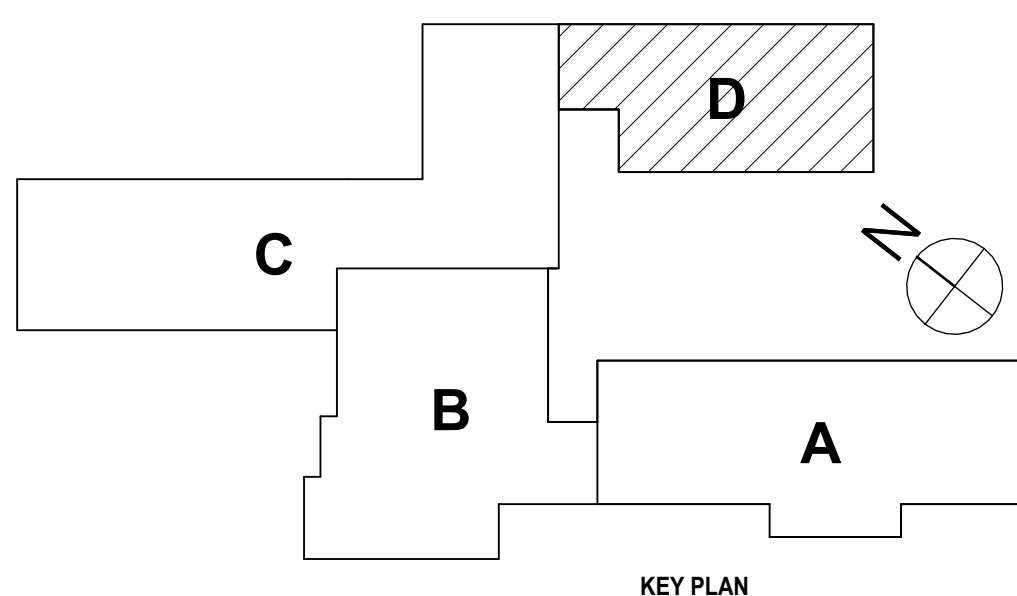

KEY PLAN

SED #ERWIN VALLEY 15-10-0001-0-000407; DOWN BUILDING 15-10-0001-1-001-013

FIRST FLOOR AND WALL FINISH PLAN - AREA D

2025 ERWIN VALLEY ELEM & ADMIN BUILDING ALTERATIONS

CORNING-PAINTED POST ASD

16 BEARTOWN ROAD, PAINTED POST NY 14870

HUNT ENGINEERS | ARCHITECTS | SURVEYORS
ALBANY, NY - BINGHAMTON, NY - HORSESHOE FALLS, NY - ROCHESTER, NY
NEW YORK, NY - WESTCHESTER, NY
WWW.HUNT-EAS.COM 807-558-1000
NY CERTIFICATE NO. 0016320 PA CERTIFICATE NO. TSC220313464-1


EV-A8.3

PROJECT NO: 2649-160


DRAWN BY: PMP
CHECKED BY: SZ
DATE: 03/17/2026
PHASE: CD
REVISION: ISSUE FOR BID
DATE: 1 10/22/26
"IT IS A VIOLATION OF THE LAW FOR ANY PERSON TO MAKE UNAUTHORIZED ALTERATIONS OR ADJUSTMENTS TO ANY ARCHITECT'S OR SURVEYOR'S SEAL."

EV - ROOM FINISH SCHEDULE											
ROOM #	ROOM NAME	FLOOR	BASE	WALL	DOOR	CEILING	COUNTERTOP	CASEWORK	WINDOW	REMARKS	
		FINISH	FINISH	FINISH	FRAME	FINISH	FINISH		SHADE		
FIRST FLOOR AREA - A											
213	5TH GRADE CLASSROOM	ETR	ETR	ETR	ETR	ETR	ETR	ETR	ETR	-	
213B	STOR.	ETR	ETR	ETR	ETR	ETR	-	-	-	-	
C200	CORR.	ETR	ETR	ETR	ETR PTM PNT-2	ETR	-	-	-	-	
208	5TH GRADE CLASSROOM	ETR	ETR	ETR	ETR	ETR	ETR	ETR	ETR	-	
210	5TH GRADE CLASSROOM	ETR	ETR	ETR	ETR	ETR	ETR	ETR	ETR	-	
210A	T.R.	ETR	ETR	ETR	ETR	ETR	-	-	-	-	
208A	T.R.	ETR	ETR	ETR	ETR	ETR	-	-	-	-	
213A	T.R.	ETR	ETR	ETR	ETR	ETR	-	-	-	-	
211	5TH GRADE CLASSROOM	ETR	ETR	ETR	ETR	ETR	ETR	ETR	ETR	-	
209B	A.I.S. CLASSROOM	ETR	ETR	ETR	ETR	ETR	ETR	ETR	ETR	-	
209A	A.I.S. CLASSROOM	ETR	ETR	ETR	ETR	ETR	ETR	ETR	ETR	-	
211A	T.R.	ETR	ETR	ETR	ETR	ETR	-	-	-	-	
206B	T.R.	ETR	ETR	ETR	PNT-2	ETR	ETR	ETR	ETR	DOOR FRAME TO RECEIVE PAINT, PNT-2.	
206C	ELEC.	ETR	ETR	ETR	ETR	ETR	ETR	ETR	ETR	-	
206A	DATA ROOM	ETR	ETR	ETR	ETR	ETR	ETR	ETR	ETR	-	
206	LIBRARY	CPT-1,2,3,4,5,6,7,8,9 TS-3	RB-1	ETR PTM	ETR	ETR	ETR	ETR	WS-1	CARPET TILE PATTERN INDICATED ON 2/EV-A8.1. PROVIDE WINDOW SHADES AT INDICATED WINDOW.	
207A	T.R.	ETR	ETR	ETR	ETR	ETR	-	-	-	-	
207	4TH GRADE CLASSROOM	ETR	ETR	ETR	ETR	ETR	ETR	ETR	ETR	-	
205	4TH GRADE CLASSROOM	ETR	ETR	ETR	ETR	ETR	ETR	ETR	ETR	-	
203	4TH GRADE CLASSROOM	ETR	ETR	ETR	ETR	ETR	ETR	ETR	ETR	-	
205A	T.R.	ETR	ETR	ETR	ETR	ETR	-	-	-	-	
203A	T.R.	ETR	ETR	ETR	ETR	ETR	-	-	-	-	
202B	J.C.	ETR	ETR	ETR	ETR	ETR	-	-	-	-	
202A	T.R.	ETR	ETR	ETR	ETR	ETR	-	-	-	-	
204A	T.R.	ETR	ETR	ETR	ETR	ETR	-	-	-	-	
204	4TH GRADE CLASSROOM	ETR	ETR	ETR	ETR	ETR	ETR	ETR	ETR	-	
202	TEACHER CONFERENCE ROOM	ETR	ETR	ETR	ETR	ETR	ETR	ETR	ETR	-	
200	4TH GRADE CLASSROOM	ETR	ETR	ETR	ETR	ETR	ETR	ETR	ETR	-	
200A	T.R.	ETR	ETR	ETR	ETR	ETR	ETR	ETR	ETR	-	
201	ART	ETR	ETR	ETR	ETR	ETR	ETR	ETR	ETR	-	
201A	T.R.	ETR	-	ETR	ETR	ETR	-	-	-	-	
201B	KILN	ETR	ETR	ETR	ETR	ETR	-	-	-	-	
FIRST FLOOR AREA - B											
101A	T.R.	ETR	ETR	ETR	ETR	ETR	ETR	ETR	ETR	-	
101B	T.R.	ETR	ETR	ETR	ETR	ETR	ETR	ETR	ETR	-	
107	GYMNASIUM	ETR	ETR	ETR	ETR	ETR	ETR	ETR	ETR	-	
103	KITCHEN	ETR	CB-3 PTM ETR	WT-3 PTM	PNT-2	ETR PTM ACT-2	ETR	ETR	ETR	PROVIDE ACT-1 WHERE INDICATED ON CEILING PLAN, NEW CEILING GRID, SPN+1 TO BE INSTALLED AT SAME HEIGHT AS EXISTING CEILING. PROVIDE EXISTING CEILING TILE IN NEW GRID.	
103B	T.R.	ETR	ETR	ETR	ETR	ETR	ETR	-	-	-	
103C	MECH. ROOM	ETR	ETR	ETR	PNT-2	ETR	ETR	ETR	ETR	-	
V101	RECEIVING	FT-2 PTM	CB-2 PTM	WT-4 PTM	PNT-2	ETR PTM	ETR	ETR	ETR	PATCH TO MATCH EXISTING FINISHES WHERE NEW WORK IMPACTS EXISTING FINISH CONDITIONS.	
101	CAFETERIA	ETR PTM	CB-3 PTM ETR	WT-3 PTM ETR	PTM PNT-2	ETR	ETR	ETR	ETR	REFINISH EXISTING WOOD PANELING USING STN-1. SAND AND REFINISH STAIRS WITH STN-1, PTM EXISTING.	
101E	STAGE	STN-1, PTM	RB-1 PTM	CR-1,2	ETR	ETR	ETR	ETR	ETR	REMOVE EXISTING ACCORDION DOOR AND MECHANISMS IN ITS ENTIRETY. STAGE TO RECEIVE NEW CURTAIN SYSTEM, CR-1,2.	
101D	OFFICE	ETR	ETR	ETR	ETR	ETR	ETR	ETR	ETR	-	
101C	VEST.	ETR	ETR	ETR	ETR	ETR	ETR	ETR	ETR	-	
B6	AREAWAY	ETR	ETR	ETR PTM	ETR	ETR	ETR	ETR	ETR	-	
FIRST FLOOR AREA - C											
C301	CORR.	ETR	ETR	ETR TKS-1	ETR	ETR	ETR	ETR	ETR	ALL EXISTING WALL FINISHES TO REMAIN, PROVIDE NEW TACK STRIPS AT EXTENTS SHOWN ON EV-A1.3.	
306A	ELEC.	ETR	ETR	ETR	PNT-2	ETR	ETR	ETR	ETR	PAINT NEW DOOR FRAMES PNT-2.	
306B	J.C.	ETR	ETR	ETR	PNT-2	ETR	ETR	ETR	ETR	PAINT NEW DOOR FRAMES PNT-2.	
X100	STOR.	ETR	ETR	ETR	PNT-2	ETR	ETR	ETR	ETR	PAINT NEW DOOR FRAMES PNT-2.	
FIRST FLOOR AREA - D											
406	2ND GRADE CLASSROOM	ETR	RB-2 PTM	ETR	ETR	ETR	SSM-1	ETR	ETR	PROVIDE NEW SOLID SURFACE COUNTERTOP, SSM-1.	
404	2ND GRADE CLASSROOM	ETR	RB-2 PTM	ETR	ETR	ETR	SSM-1	ETR	ETR	PROVIDE NEW SOLID SURFACE COUNTERTOP, SSM-1.	
C400	CORR.	ETR	ETR	ETR TKS-1	ETR	ETR	ETR	ETR	ETR	ALL EXISTING WALL FINISHES TO REMAIN, PROVIDE NEW TACK STRIPS AT EXTENTS SHOWN ON EV-A1.3.	
402	1ST GRADE CLASSROOM	ETR	RB-2 PTM	ETR	ETR	ETR	SSM-1	ETR	ETR	PROVIDE NEW SOLID SURFACE COUNTERTOP, SSM-1.	
400	1ST GRADE CLASSROOM	ETR	RB-2 PTM	ETR	ETR	ETR	SSM-1	ETR	ETR	PROVIDE NEW SOLID SURFACE COUNTERTOP, SSM-1.	
401	1ST GRADE CLASSROOM	ETR	RB-2 PTM	ETR	ETR	ETR	ALT #1: SSM-1	ETR	ETR	ALT #1: PROVIDE NEW SOLID SURFACE COUNTERTOP, SSM-1.	
403	1ST GRADE CLASSROOM	ETR	RB-2 PTM	ETR	ETR	ETR	ALT #1: SSM-1	ETR	ETR	ALT #1: PROVIDE NEW SOLID SURFACE COUNTERTOP, SSM-1.	
407	2ND GRADE CLASSROOM	ETR	RB-2 PTM	ETR	ETR	ETR	ALT #1: SSM-1	ETR	ETR	ALT #1: PROVIDE NEW SOLID SURFACE COUNTERTOP, SSM-1.	
405	2ND GRADE CLASSROOM	ETR	RB-2 PTM	ETR	ETR	ETR	ALT #1: SSM-1	ETR	ETR	ALT #1: PROVIDE NEW SOLID SURFACE COUNTERTOP, SSM-1.	
312	STEM CLASSROOM	ETR	ETR	ETR	ETR	ETR	ETR	ETR	ETR	-	
401A	T.R.	ALT #1: FT-1	ALT #1: CB-1	ALT #1: WT-1,2,5 TS-1 PNT-1	ATL #1: PNT-2	ALT #1: ACT-1	-	-	-	ALT #1: REINSTALL EXISTING THRESHOLDS FROM EXISTING FLOOR INTO NEW TILE FLOOR.	
403A	T.R.	ALT #1: FT-1	ALT #1: CB-1	ALT #1: WT-1,2,5 TS-1 PNT-1	ATL #1: PNT-2	ALT #1: ACT-1	-	-	-	ALT #1: REINSTALL EXISTING THRESHOLDS FROM EXISTING FLOOR INTO NEW TILE FLOOR.	
ST-2	J.C.	ETR	ETR	ETR	ETR	ETR	ETR	ETR	ETR	-	
ST-1	DATA	ETR	ETR	ETR	ETR	ETR	-	-	-	-	
312A	T.R.	ETR	ETR	ETR	ETR	ETR	-	-	-	-	
405A	T.R.	ALT #1: FT-1	ALT #1: CB-1	ALT #1: WT-1,2,5 TS-1 PNT-1	ATL #1: PNT-2	ALT #1: ACT-1	-	-	-	ALT #1: REINSTALL EXISTING THRESHOLDS FROM EXISTING FLOOR INTO NEW TILE FLOOR.	
407A	T.R.	ALT #1: FT-1	ALT #1: CB-1	ALT #1: WT-1,2,5 TS-1 PNT-1	ATL #1: PNT-2	ALT #1: ACT-1	-	-	-	ALT #1: REINSTALL EXISTING THRESHOLDS FROM EXISTING FLOOR INTO NEW TILE FLOOR.	
400A	T.R.	FT-1	CB-1,2	WT-1,2,5 TS-1 PNT-1	PNT-2	ACT-1	-	-	-	REINSTALL EXISTING THRESHOLDS FROM EXISTING FLOOR INTO NEW TILE FLOOR.	
402A	T.R.	FT-1	CB-1,2	WT-1,2,5 TS-1 PNT-1	PNT-2	ACT-1	-	-	-	REINSTALL EXISTING THRESHOLDS FROM EXISTING FLOOR INTO NEW TILE FLOOR.	
404A	T.R.	FT-1	CB-1,2	WT-1,2,5 TS-1 PNT-1	PNT-2	ACT-1	-	-	-	REINSTALL EXISTING THRESHOLDS FROM EXISTING FLOOR INTO NEW TILE FLOOR.	
406A	T.R.	FT-1	CB-1,2	WT-1,2,5 TS-1 PNT-1	PNT-2	ACT-1	-	-	-	REINSTALL EXISTING THRESHOLDS FROM EXISTING FLOOR INTO NEW TILE FLOOR.	

EV - FINISH KEY									
ABBR.	MATERIAL TYPE	MANUFACTURER	SERIES	SIZE	NUMBER	COLOR	SECTION #	REMARKS	
ACOUSTIC CEILING TILE									
ACT-1	ACOUSTICAL CEILING TILE	ARMSTRONG WORLD INDUSTRIES	FINE FISSURED HIGH NRC SQUARE LAY-IN	24" X 24"	1713	WHITE (WH)	09 51 00	KITCHEN CEILING TILE REPLACEMENT	
ACT-2	ACOUSTICAL CEILING TILE	ARMSTRONG WORLD INDUSTRIES	PEBBLE SQUARE LAY-IN	24" X 24"	2988	WHITE (WH)	09 51 00	TOILET ROOM CEILINGS	
CARPET									
CPT-1	MODULAR CARPET TILE	J + J FLOORING	ANALYTIC	18" X 36"	3590	COOL	09 68 13	LIBRARY CARPET REPLACEMENT - GENERAL	
CPT-2	MODULAR CARPET TILE	J + J FLOORING	ANALYTIC DIFFUSE	18" X 36"	3600	COOL GREEN	09 68 13	LIBRARY CARPET REPLACEMENT - GENERAL (LIGHT)	
CPT-3	MODULAR CARPET TILE	J + J FLOORING	ANALYTIC DIFFUSE	18" X 36"	3599	COOL BLUE	09 68 13	LIBRARY CARPET REPLACEMENT - GENERAL (LIGHT)	
CPT-4	MODULAR CARPET TILE	J + J FLOORING	ANALYTIC DIFFUSE	18" X 36"	3597	COOL RED	09 68 13	LIBRARY CARPET REPLACEMENT - GENERAL (LIGHT)	
CPT-5	MODULAR CARPET TILE	J + J FLOORING	ANALYTIC DIFFUSE	18" X 36"	3602	COOL ORANGE	09 68 13	LIBRARY CARPET REPLACEMENT - GENERAL (LIGHT)	
CPT-6	MODULAR CARPET TILE	J + J FLOORING	ANALYTIC FORM	18" X 36"	3600	COOL GREEN	09 68 13	LIBRARY CARPET REPLACEMENT - GENERAL (DARK)	
CPT-7	MODULAR CARPET TILE	J + J FLOORING	ANALYTIC FORM	18" X 36"	3599	COOL BLUE	09 68 13	LIBRARY CARPET REPLACEMENT - GENERAL (DARK)	
CPT-8	MODULAR CARPET TILE	J + J FLOORING	ANALYTIC FORM	18" X 36"	3597	COOL RED	09 68 13	LIBRARY CARPET REPLACEMENT - GENERAL (DARK)	
CPT-9	MODULAR CARPET TILE	J + J FLOORING	ANALYTIC FORM	18" X 36"	3602	COOL ORANGE	09 68 13	LIBRARY CARPET REPLACEMENT - GENERAL (DARK)	
CERAMIC BASE									
CB-1	CERAMIC COVE BASE	DAL-TILE	COLOR WHEEL - CLASSIC	3" X 6" COVE BASE	A3361MOD	ALMOND	09 30 00	TOILET ROOMS, GENERAL	
CB-2	CERAMIC COVE BASE	DAL-TILE	PATCH TO MATCH EXISTING	PTM	PTM	PTM	09 30 00	RECEIVING (V101) COVE BASE	
CB-3	PORCELAIN COVE BASE	CROSSVILLE - TILE WHOLESALERS	CROSSVILLE - NEST	PTM	AV365	PEACEFUL OLIVE	09 30 00	KITCHEN WALL TILE REPLACEMENT, CAFETERIA PATCH TO MATCH TILE	
FLOOR TILE									
FT-1	PORCELAIN MOSAIC	DAL-TILE	KEYSTONES	1/2" HEX SHAMROCK	DK04	BEACH BLEND	09 30 00	GENERAL TOILET ROOM FLOOR TILE	
FT-2	PATCH TO MATCH EXISTING	PATCH TO MATCH EXISTING	PATCH TO MATCH EXISTING	PTM	PTM	PTM	09 30 00	RECEIVING (V101) FLOOR TILE	
GROUT									
G-1	EPOXY GROUT	LATICRETE	SPECTRALOCK PRO	-	56	DESERT KHAKI	09 30 00	FLOOR TILE GROUT	
G-2	PREMIUM GROUT WITH EPOXY PERFORMANCE	LATICRETE	SPECTRALOCK ONE	-	23	ANTIQUE WHITE	09 30 00	WALL TILE GROUT	
PAINT									
PNT-1	PAINT	SHERWIN WILLIAMS	-	-	SW 7006	EXTRA WHITE	09 91 23	GENERAL/FIELD, GWB SOFFITS	
PNT-2	PAINT	SHERWIN WILLIAMS	-	-	SW 7018	DOVETAIL	09 91 23	NEW HM DOOR FRAMES, PTM DOOR FRAMES	
RESILIENT BASE									
RB-1	VINYL BASE	JOHNSONITE	STANDARD COVE BASE	4" H	32	PEBBLE WG	09 68 13	GENERAL WALL BASE	
RB-2	RESILIENT WALL BASE	PATCH TO MATCH EXISTING	MATCH EXISTING	PTM	PTM	PTM	09 68 13	AREA D CLASSROOMS, PTM BASE	
SOLID SURFACE									
SSM-1	SOLID SURFACE MATERIAL	CORIAN	COLORS BY DUPONT	V.I.F.	-	CLAM SHELL	12 36 00	GENERAL COUNTERTOPS (INCLUDING ALT #1)	
SSM-2	SOLID SURFACE MATERIAL	CORIAN	COLORS BY DUPONT	V.I.F.	-	WHITE JASMINE	12 36 00	WINDOW SILLS	
STAGE CURTAIN									
CR-1	IFR POLYESTER STAGE CURTAIN - BACKSIDE CURTAIN	KM FABRICS	CRESCENT - CLASS A FIRE RATED	-	1064	PLATEAU BLACK	19 30 00	CAFETERIA - STAGE BACK/SIDE CURTAIN FABRIC	
CR-2	IFR POLYESTER STAGE CURTAIN - MAIN VALANCE CURTAIN	KM FABRICS	CRESCENT - CLASS A FIRE RATED	-	1036	GREEN	19 30 00	CAFETERIA - STAGE MAIN CURTAIN FABRIC	
STAIN									
STN-1	STAIN	MINWAX	COLOR MATCH ALGOMA HARDWOODS, INC.	-	-	RA-4368	09 64 30	STAGE 101E FLOOR AND STAIR REFINISHING	
STN-2	STAIN	MINWAX	PATCH TO MATCH EXISTING WOOD FLOOR	-	-	PTM	09 91 23	WOOD WALL PANELS	
TACK STRIPS									
TKS-1	TACKABLE DISPLAY STRIPS	CLARIDGE	EDR EXHIBIT RAIL	3" WIDE, LENGTH VARIES BASED ON LOCATION, REFER TO A1 SERIES	EDR	TRIM: JET BLACK CORK: BLACK	10 11 00	AREA C AND AREA D CORRIDORS	
TRANSITION STRIP									
TS-1	STAINLESS STEEL	SCHLUTER SYSTEMS INC.	RONDEC - INSIDE AND OUTSIDE CORNERS	V.I.F. AS REQUIRED BY TILE THICKNESS	-	BRUSHED STAINLESS STEEL	09 30 00	EDGE OFF OUTSIDE AND INSIDE CORNERS OF WALL TILE	
TS-2	STAINLESS STEEL	SCHLUTER SYSTEMS INC.	SCHIENE	V.I.F. AS REQUIRED BY FLOORING THICKNESS	-	BRUSHED STAINLESS STEEL	09 68 13	FLOORING TRANSITION/EDGE PROTECTION	
WALL TILE									
WT-1	CERAMIC WALL TILE	DAL-TILE	COLOR WHEEL - CLASSIC	3" X 6"	0135	ALMOND	09 30 00	TOILET ROOMS, GENERAL	
WT-2	CERAMIC WALL TILE	DAL-TILE	COLOR MATCH - SPECIAL ORDER CERAMIC TILE	3" X 6"	CU71	MATTE MANGO	09 30 00	TOILET ROOMS, ACCENT	
WT-3	PORCELAIN WALL TILE	CROSSVILLE - TILE WHOLESALERS	CROSSVILLE - NEST	3" X 6" PTM	AV361	LEVITY OLIVE	09 30 00	KITCHEN WALL TILE REPLACEMENT, CAFETERIA PATCH TO MATCH TILE	
WT-4	CERAMIC WALL TILE - BULLNOSE	DAL-TILE	PATCH TO MATCH EXISTING	3" X 6"	PTM	PTM	09 30 00	RECEIVING (V101) WALL TILE	
WT-5	CERAMIC WALL TILE - BULLNOSE	DAL-TILE	COLOR WHEEL - CLASSIC	3" X 6" - BULLNOSE 6" SIDE	\$4369MOD	ALMOND	09 30 00	TOILET ROOMS, WALL TRIM WAINSCOT HEIGHT.	
WINDOW TREATMENT									
WS-1	25% FIBERGLASS, 75% PVC COATING	DRAPER INC.	SUN BLOC SB9000 - FLEXSHADE	V.I.F.	SB9102	IVORY	12 24 00	LIBRARY SPRING ROLLER SHADE	

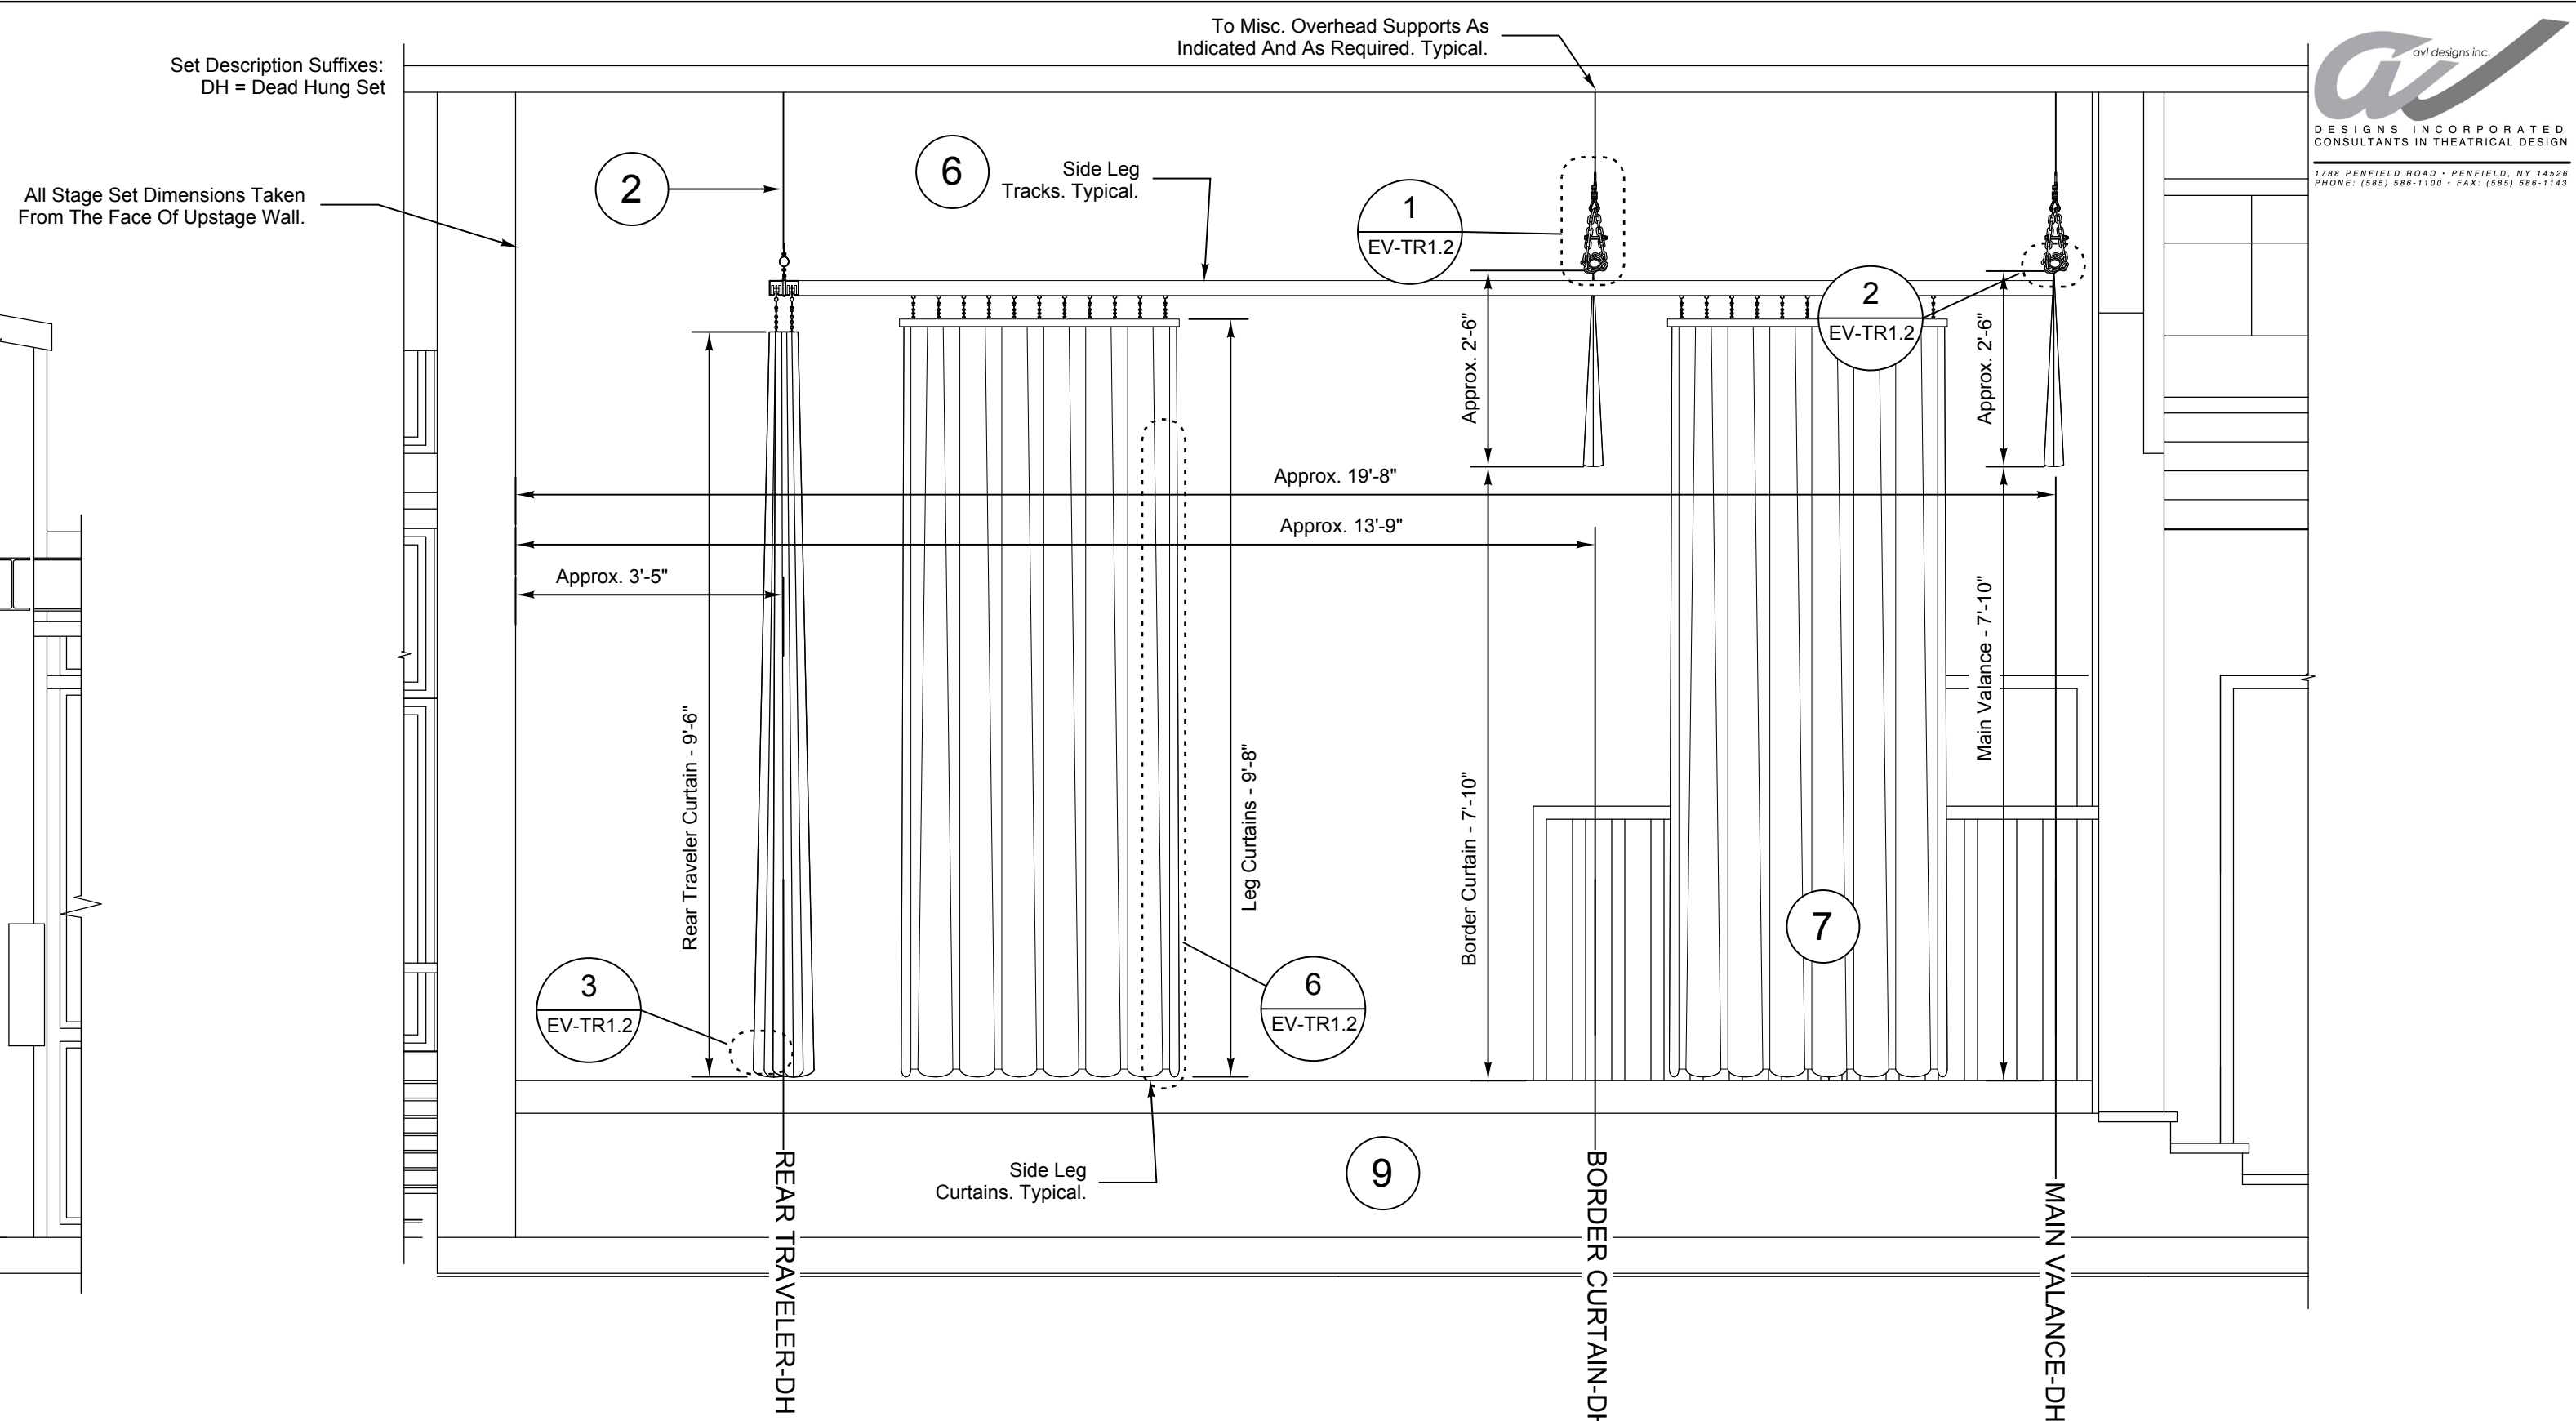

1 STAGE RIGGING SYSTEM PARTIAL SECTION
SCALE: 1/2" = 1'

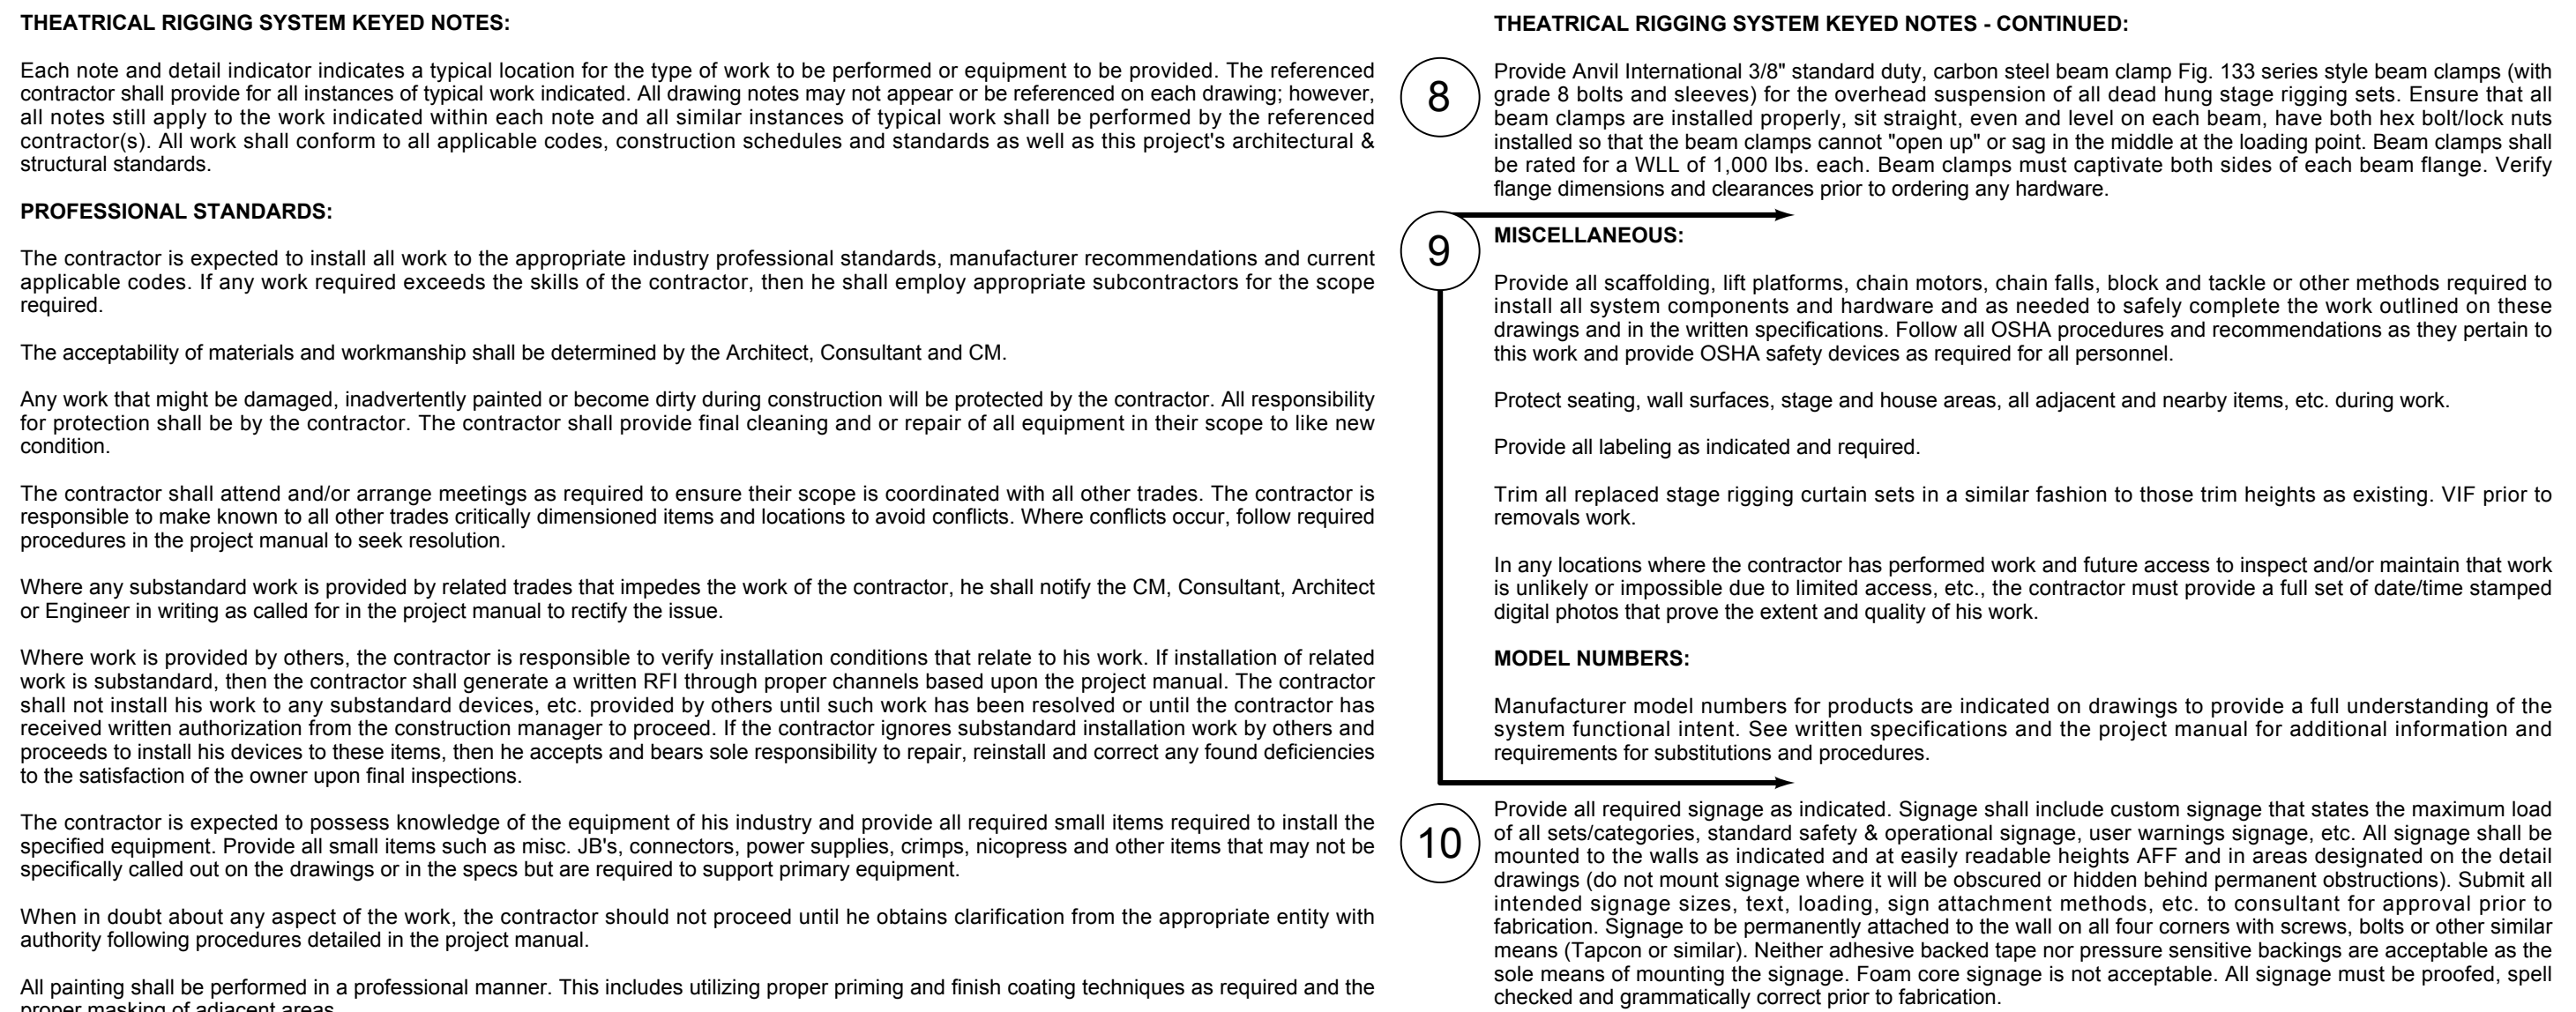

This plan shall be spray applied where possible before suspension and shall be multi-coat and meat, no drips, runs, mottled finishes, etc. shall be allowed.

THEATRICAL SCOPE NOTES FOR THE THEATRICAL RIGGING SYSTEM:

GENERAL:

All dead hung rigging systems equipment to be H&M Specialties, ADC or equal. All system miscellaneous hardware such as shackles, bolts and other hardware to be of domestic manufacture and stamped with the working load limit. The working load limit shall incorporate a safety factor of four times the rated breaking strength and detailed drawings for additional rigging standards and requirements. Minimum size of misc. hardware to be 1/4" (this includes wire rope assemblies). Provide larger sizes as required in order to maintain indicated ratings and safety margins.

All rigging system equipment and all misc. hardware shall be brand new (never been used before) and specifically configured for use on this project.

All rigging system equipment and all misc. hardware indicated on these drawings shall be mounted to the beams and overhead steel as is visually depicted. The intent is for all headblocks, loftblocks, beam clamps, suspension assemblies, etc. to be mounted to overhead beams/busses. Attachment points are indicated through visual representations on these drawings and the building's structural beams are the responsibility of the rigging company. Visual representation of attachment methods have been designed and clearly labeled on the contract documents). The contractor shall not be allowed to field select other rigging attachment points, misc. spanning equipment locations, and/or attachments which would compromise the integrity of the building's structural members. Unless prior written authorization has been specifically granted, verified by the project structural engineer and clearly communicated to all design team members and related construction trades.

All suspension hardware, lifelines, supports, lines, etc. shall be installed plumb (understood to be perpendicular in the vertical plane relative to earth level) from their overhead attachment points to their batten (or other) terminations points, unless they are bridles or otherwise specifically shown on the contract documents as being installed at angles.

All misc. hardware used on this project shall feature load rating markings (if applicable). All hardware shall be Grade 5 minimum (higher if specifically called out).

All wire rope shall be of a tested load rated variety, either domestic or imported. Load test information must be provided for all wire rope utilized in this system.

At any locations where nicressop oval sleeves have been provided and crimped but are in inaccessible locations where field inspections are not possible from the floor, platform or other area, the contractor shall provide written authentication and digital photos of these properly crimped swages (to the manufacturer's recommended tolerances in order to realize full load capacity) and shall provide copies of these verifications to the consultant, architect and owner.

RIGGING SYSTEM EQUIPMENT:

Provide miscellaneous metal, plate steel adapters and/or Unitruss adapter members complete with Unitruss channel assemblies, wall flanges, clevises & bracing, misc. beam clamps and rated anchorages and all necessary and miscellaneous hardware as indicated on drawings. If needed in order to provide appropriate pickup points for all rigging equipment where beams do not exist and/or to mount devices where indicated. Mount at elevations) as indicated on TR series drawings. Entire Unitruss assemblies and all suspension hardware are to be painted black. Paint any remaining surfaces of the equipment and hardware with a black paint. All equipment and hardware shall be maintained and Unitruss assemblies must be rigidly attached to existing overhead structural steel and be rated for a 10:1 safety factor for the loads imposed.

Provide 14"x19 galvanized lift links. All closures shall be copper nicressop. Thimbles shall be up to all terminations. All nicressop oval sleeves shall be crimped with the proper dies properly inserted into an appropriate and properly calibrated swaging tool and shall be crimped to the manufacturer's recommended tolerances in order to realize full load capacity.

BATTENS:

1.5" (1.9" OD) Schedule 40 black iron pipe battens (painted to match existing) with industry standard 18" batten splices & grade 5

Miscellaneous:

All Installed Curtains Must Be Hung Low Enough For All Wrinkles, Folds & Creases From Stages & Shipments To Have Been Removed (Use Bottom Pipe Weight, Stretchers, Etc. As Assist As Needed). Final Curtain Presentation, Upon Acceptance Testing & Turnover To The Owner, Shall Be Smooth, Flat Curtains. No Curtains Displaying Wrinkles, Folds or Creases Or Other Such Anomalies Shall Be Allowed Or Accepted.

Wrinkling: The Overall Width Of B-Burping Stylet Shall Conform To The Drawings. If A Single Panel In A Bi-Panel Pattern In A Width That Is 1/2 Of Total Width Of Stage Plus 1/2" Standard Allowance, Then The Remaining Panels Shall Show A Bypass At Each Stage. No Bi-Burping Curtains Shall Be Allowed That Do Not Display This Overlap. Overlap Cannot Be Obtained By Tracking Curtains In From Track Ends, Overly Stretching Curtains, Deducting From Ideal Fullness Or Other Abuse Means.

Alignment: All Curtains & Related Tracks Shall Be Mounted So That They Are Centered With The Proscenium Opening. Unless Specific, Detailed Instructions are Shown Requiring Alternate Mountings or Matching Existing Conditions Precludes That Mounting Relative To The Proscenium Opening. This Does Not Apply To Leg Track Curtain Ends. These Should Be Mounted So That Track Is Flush With The End Of The Related Detail.

The Bottom Edge Of All Installed Curtains Must Be Level & Flat Relative To The Stage Floor. No Curtains Shall Be Allowed That Feature A Hump, Angle, Wave Or Other Non-flat And Non-level Installations.

WARNING! - Notify The Owner In Writing and During Equalization (To The Highest Level Possible) That Any Future Chemical Treatments Of IFR Curtains (Such As The Application Of Isocyanate-shield Fire Retardant or Equal) Will Negate Those Very IFR Properties In The Fabric, Thus Potentially Rendering Them Able To Burn And In Some Cases Ignite! Therefore, It Is Such A Critical Factor In Such A Situation That The Owner's Choice To Retain The Manufacturer's Original Finish On IFR Curtains Is Paramount.

NOTE: Refer To Rigging Specifications For More Information Regarding Specific Curtain Types, Colors, Fabrication & Other Requirements.


General:











"As Existing" Intents Are That All New Curtains Be Similar In Size To Existing, Unless There Are Physical Constraints With The New System Which Preclude This Intended Sizing. Existing Curtains Intents Are Approximately Only And Not Accurately Or Exactly Reflect The Actual Finished Size Of Existing Stage Curtains. Field Measure, Verify, Document & Provide New Curtains & Tracks In Similar Sizes To Existing (Including Required Overlaps, Etc. Noted On Drawings).


IFR Indicates That Curtain Material Is Inherently & Permanently Flame Retardant & Never Needs Flame Treatment For The Life Of The Fabric. Flame Retardant Will Not Wash Out Or Weights Given With Additional Flame Retardant Chemicals.

Oz Weights Given Are Per Yard And Are Approximate. See Manufacturer's Specs For Exact Weight Per Yard.

Oz Weights Given Are Per Yard And Are Approximate. See Manufacturer's Specs For Exact Weight Per Yard

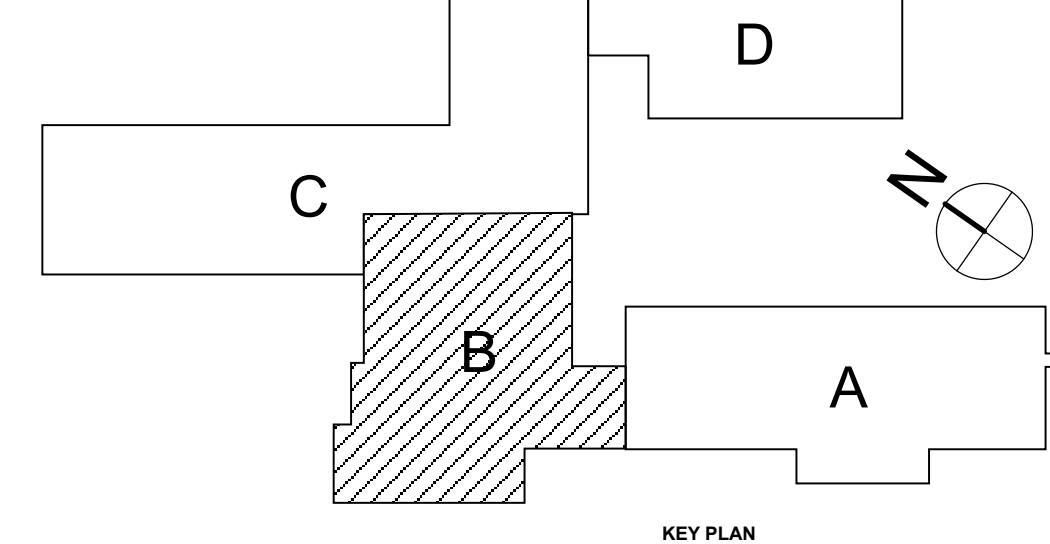


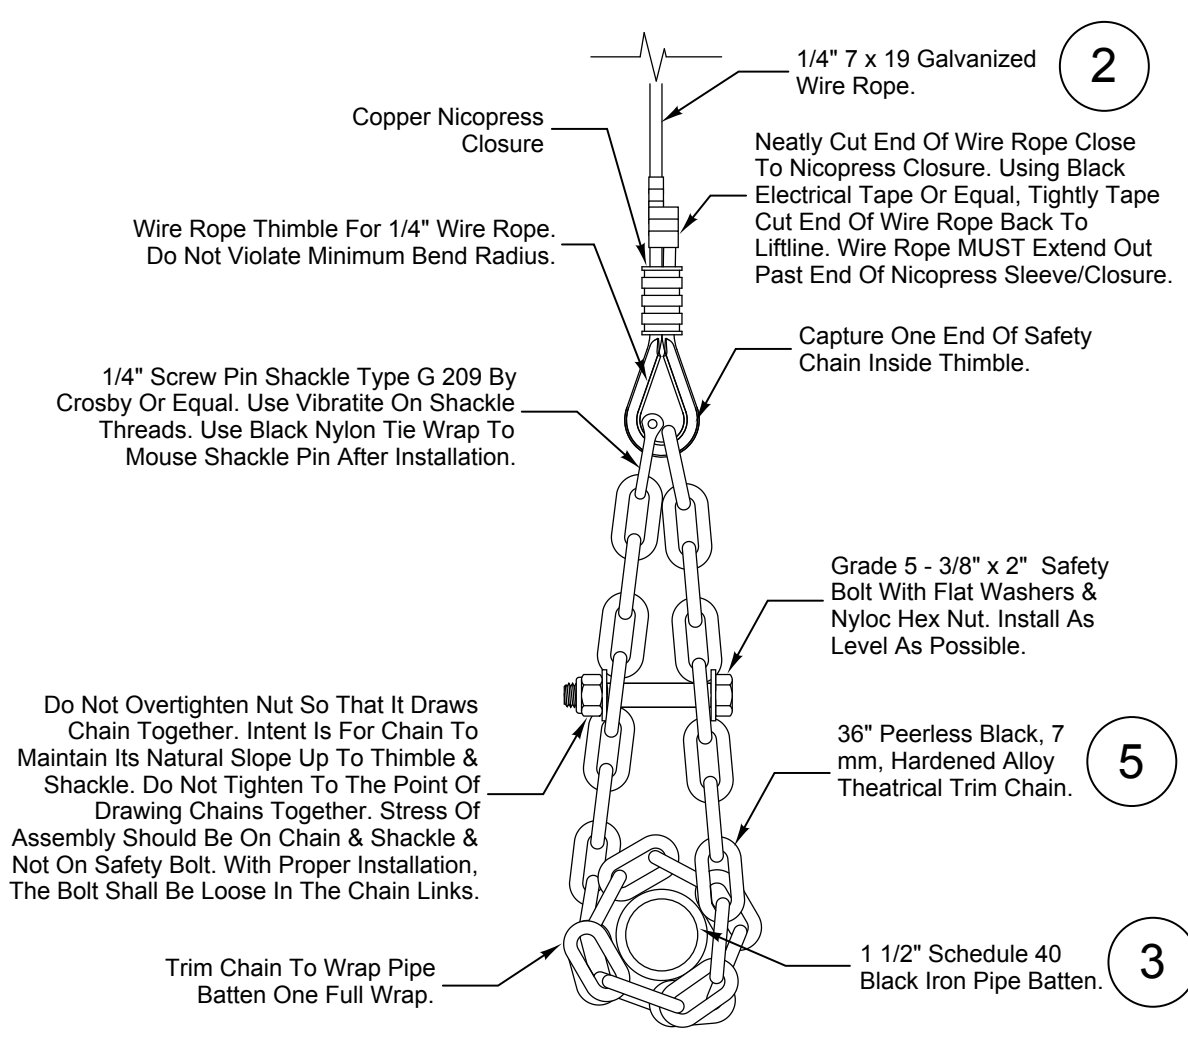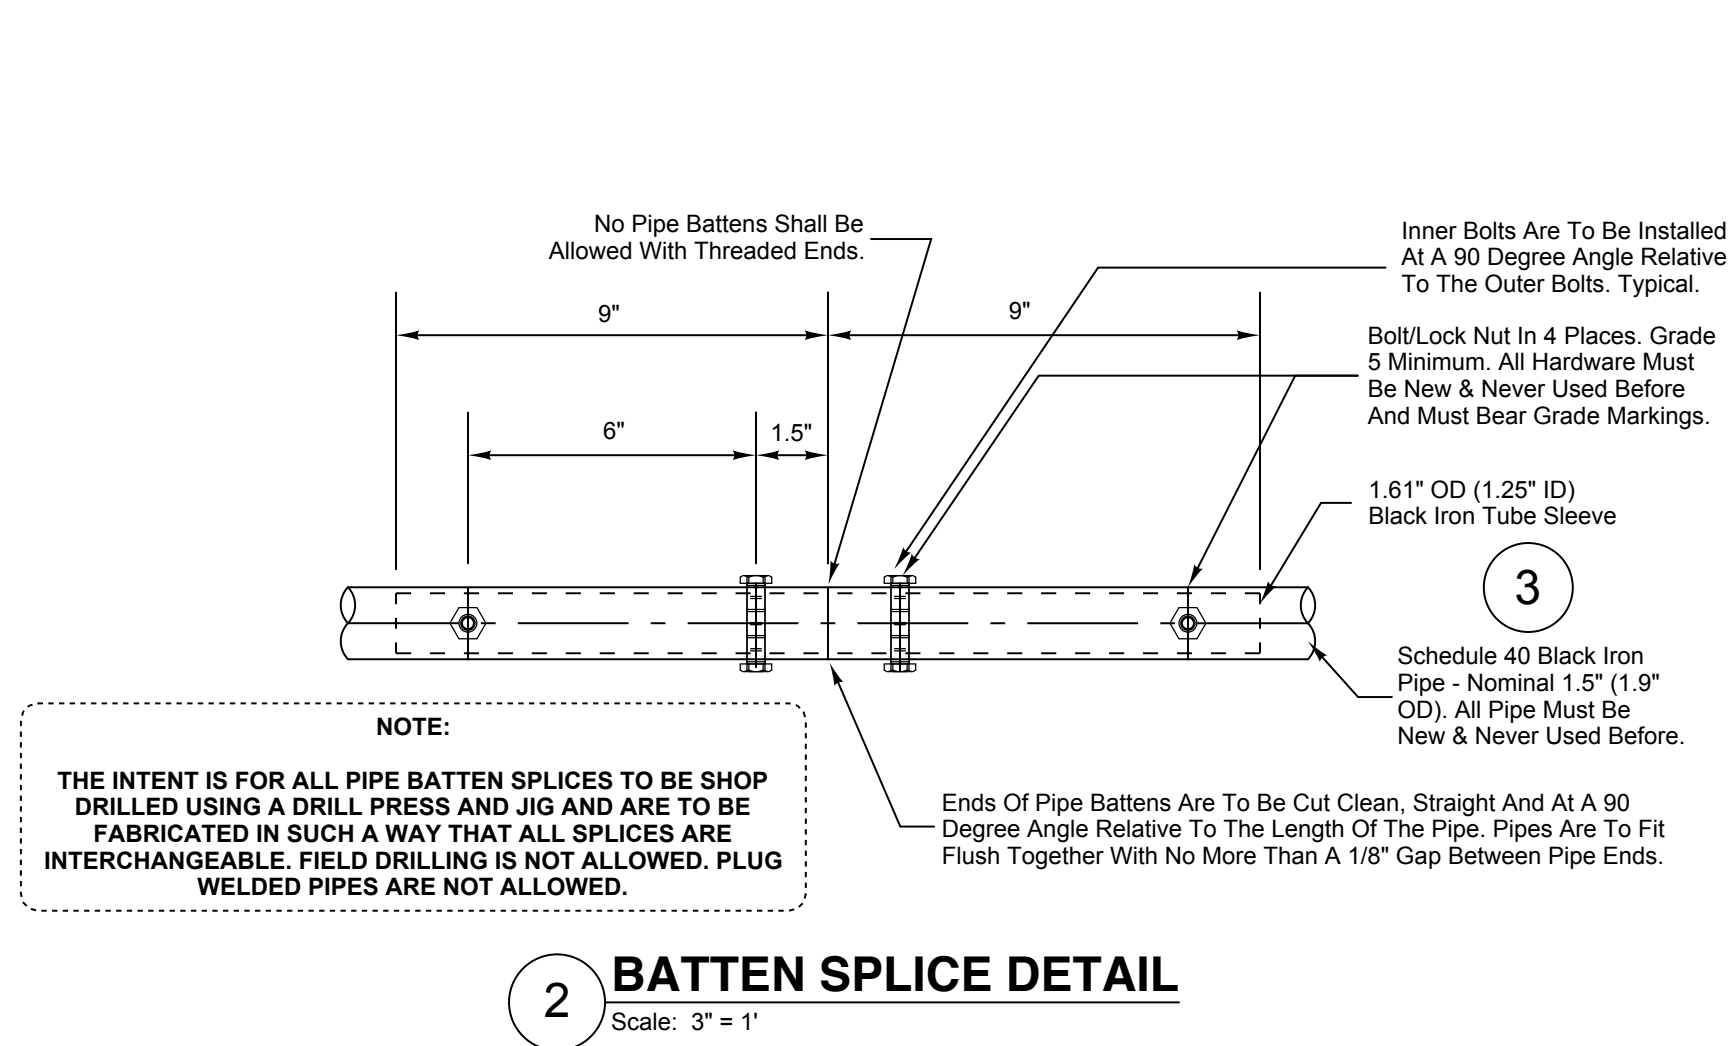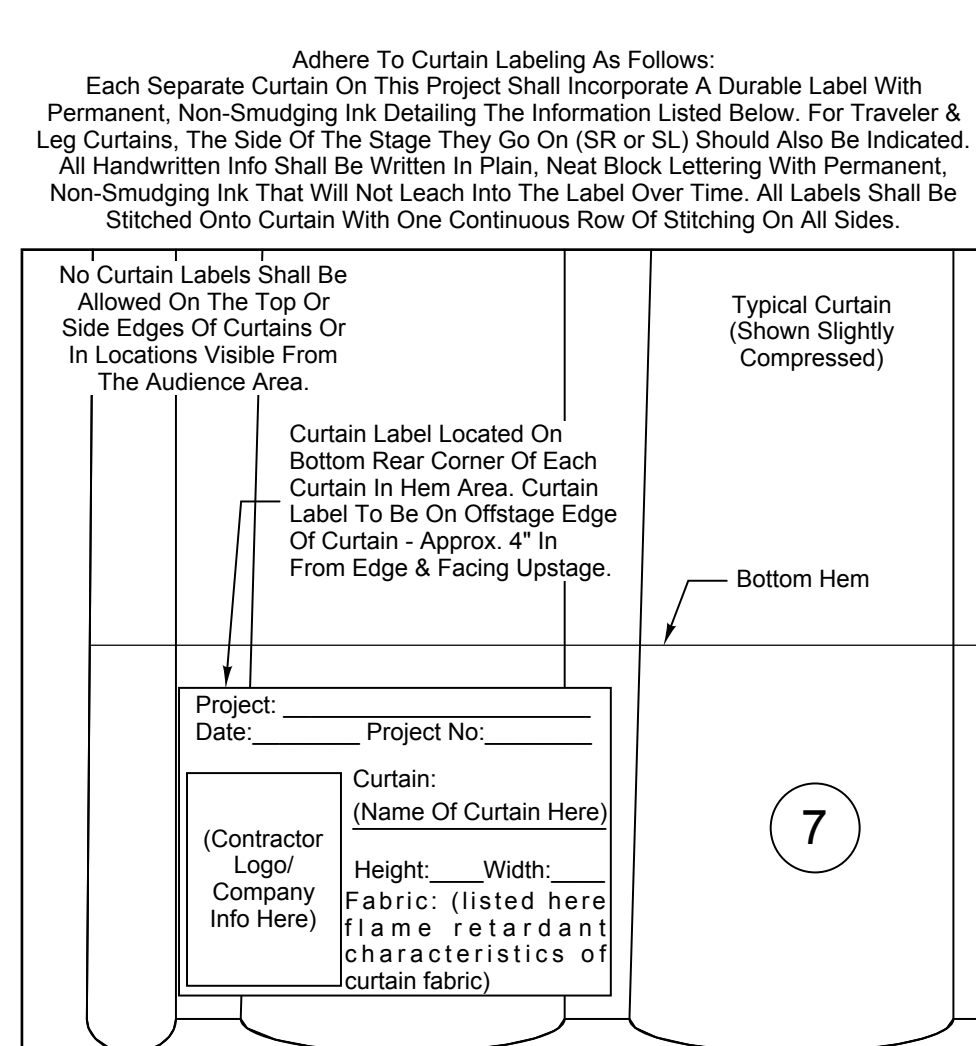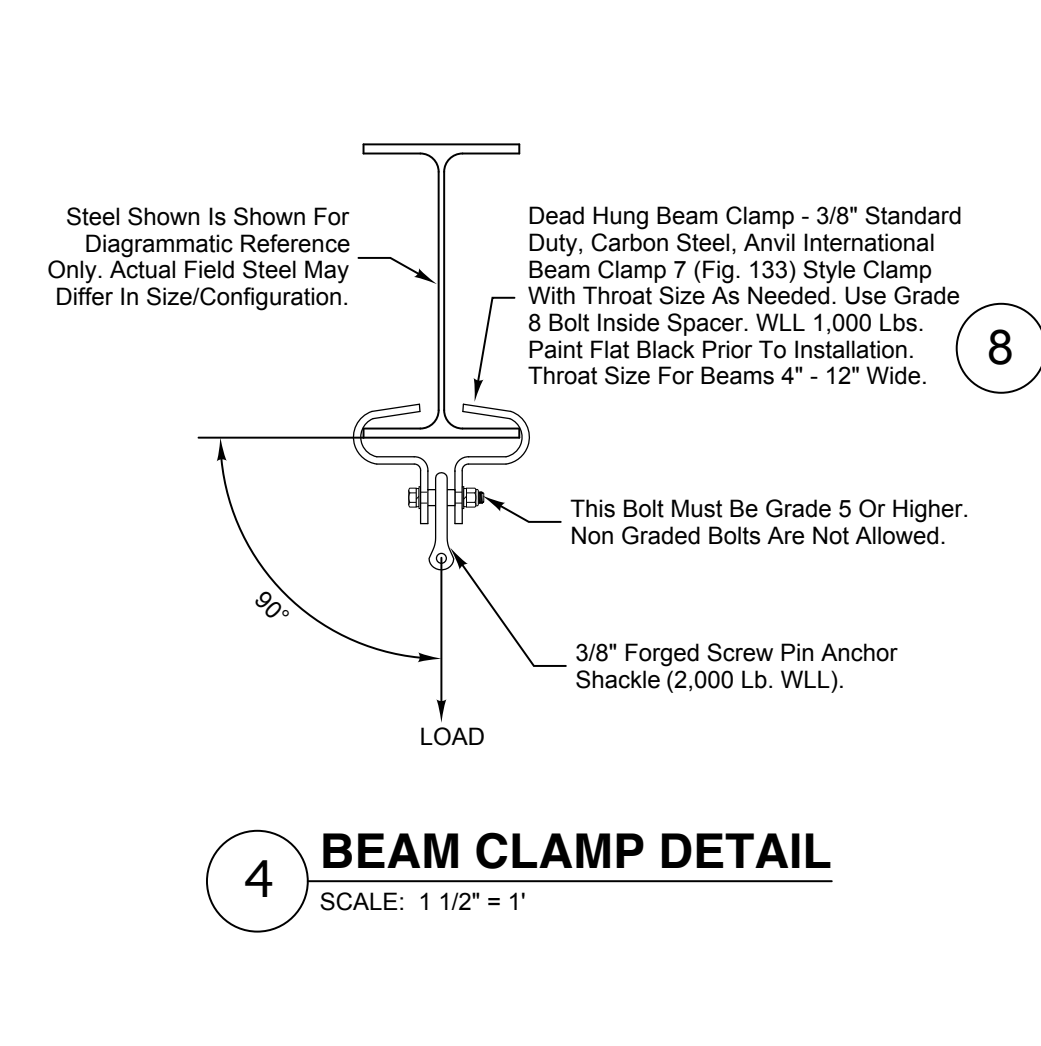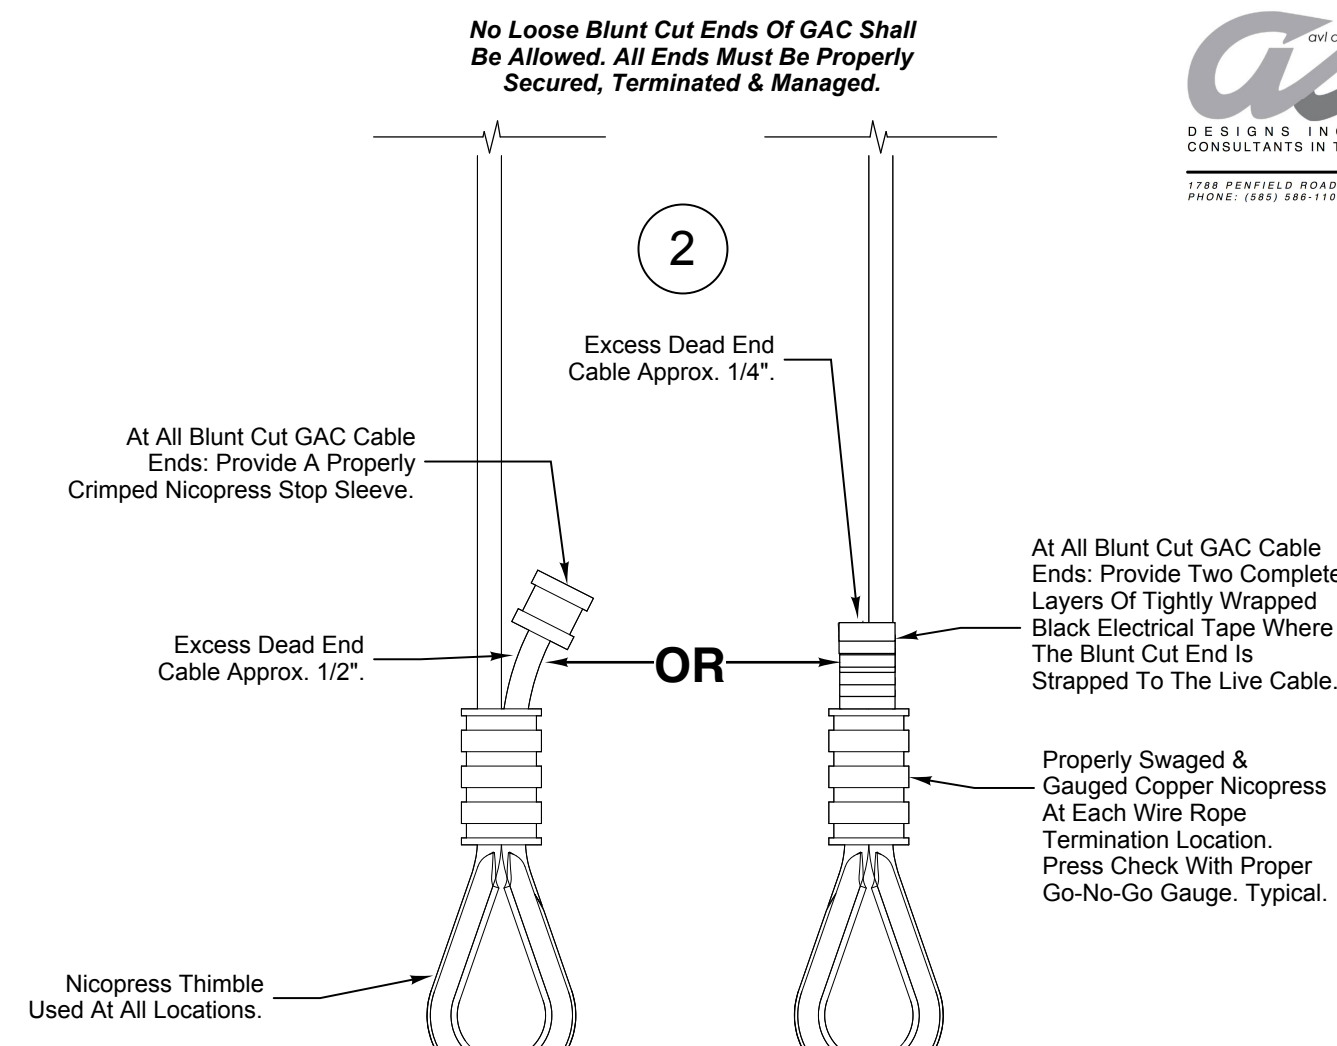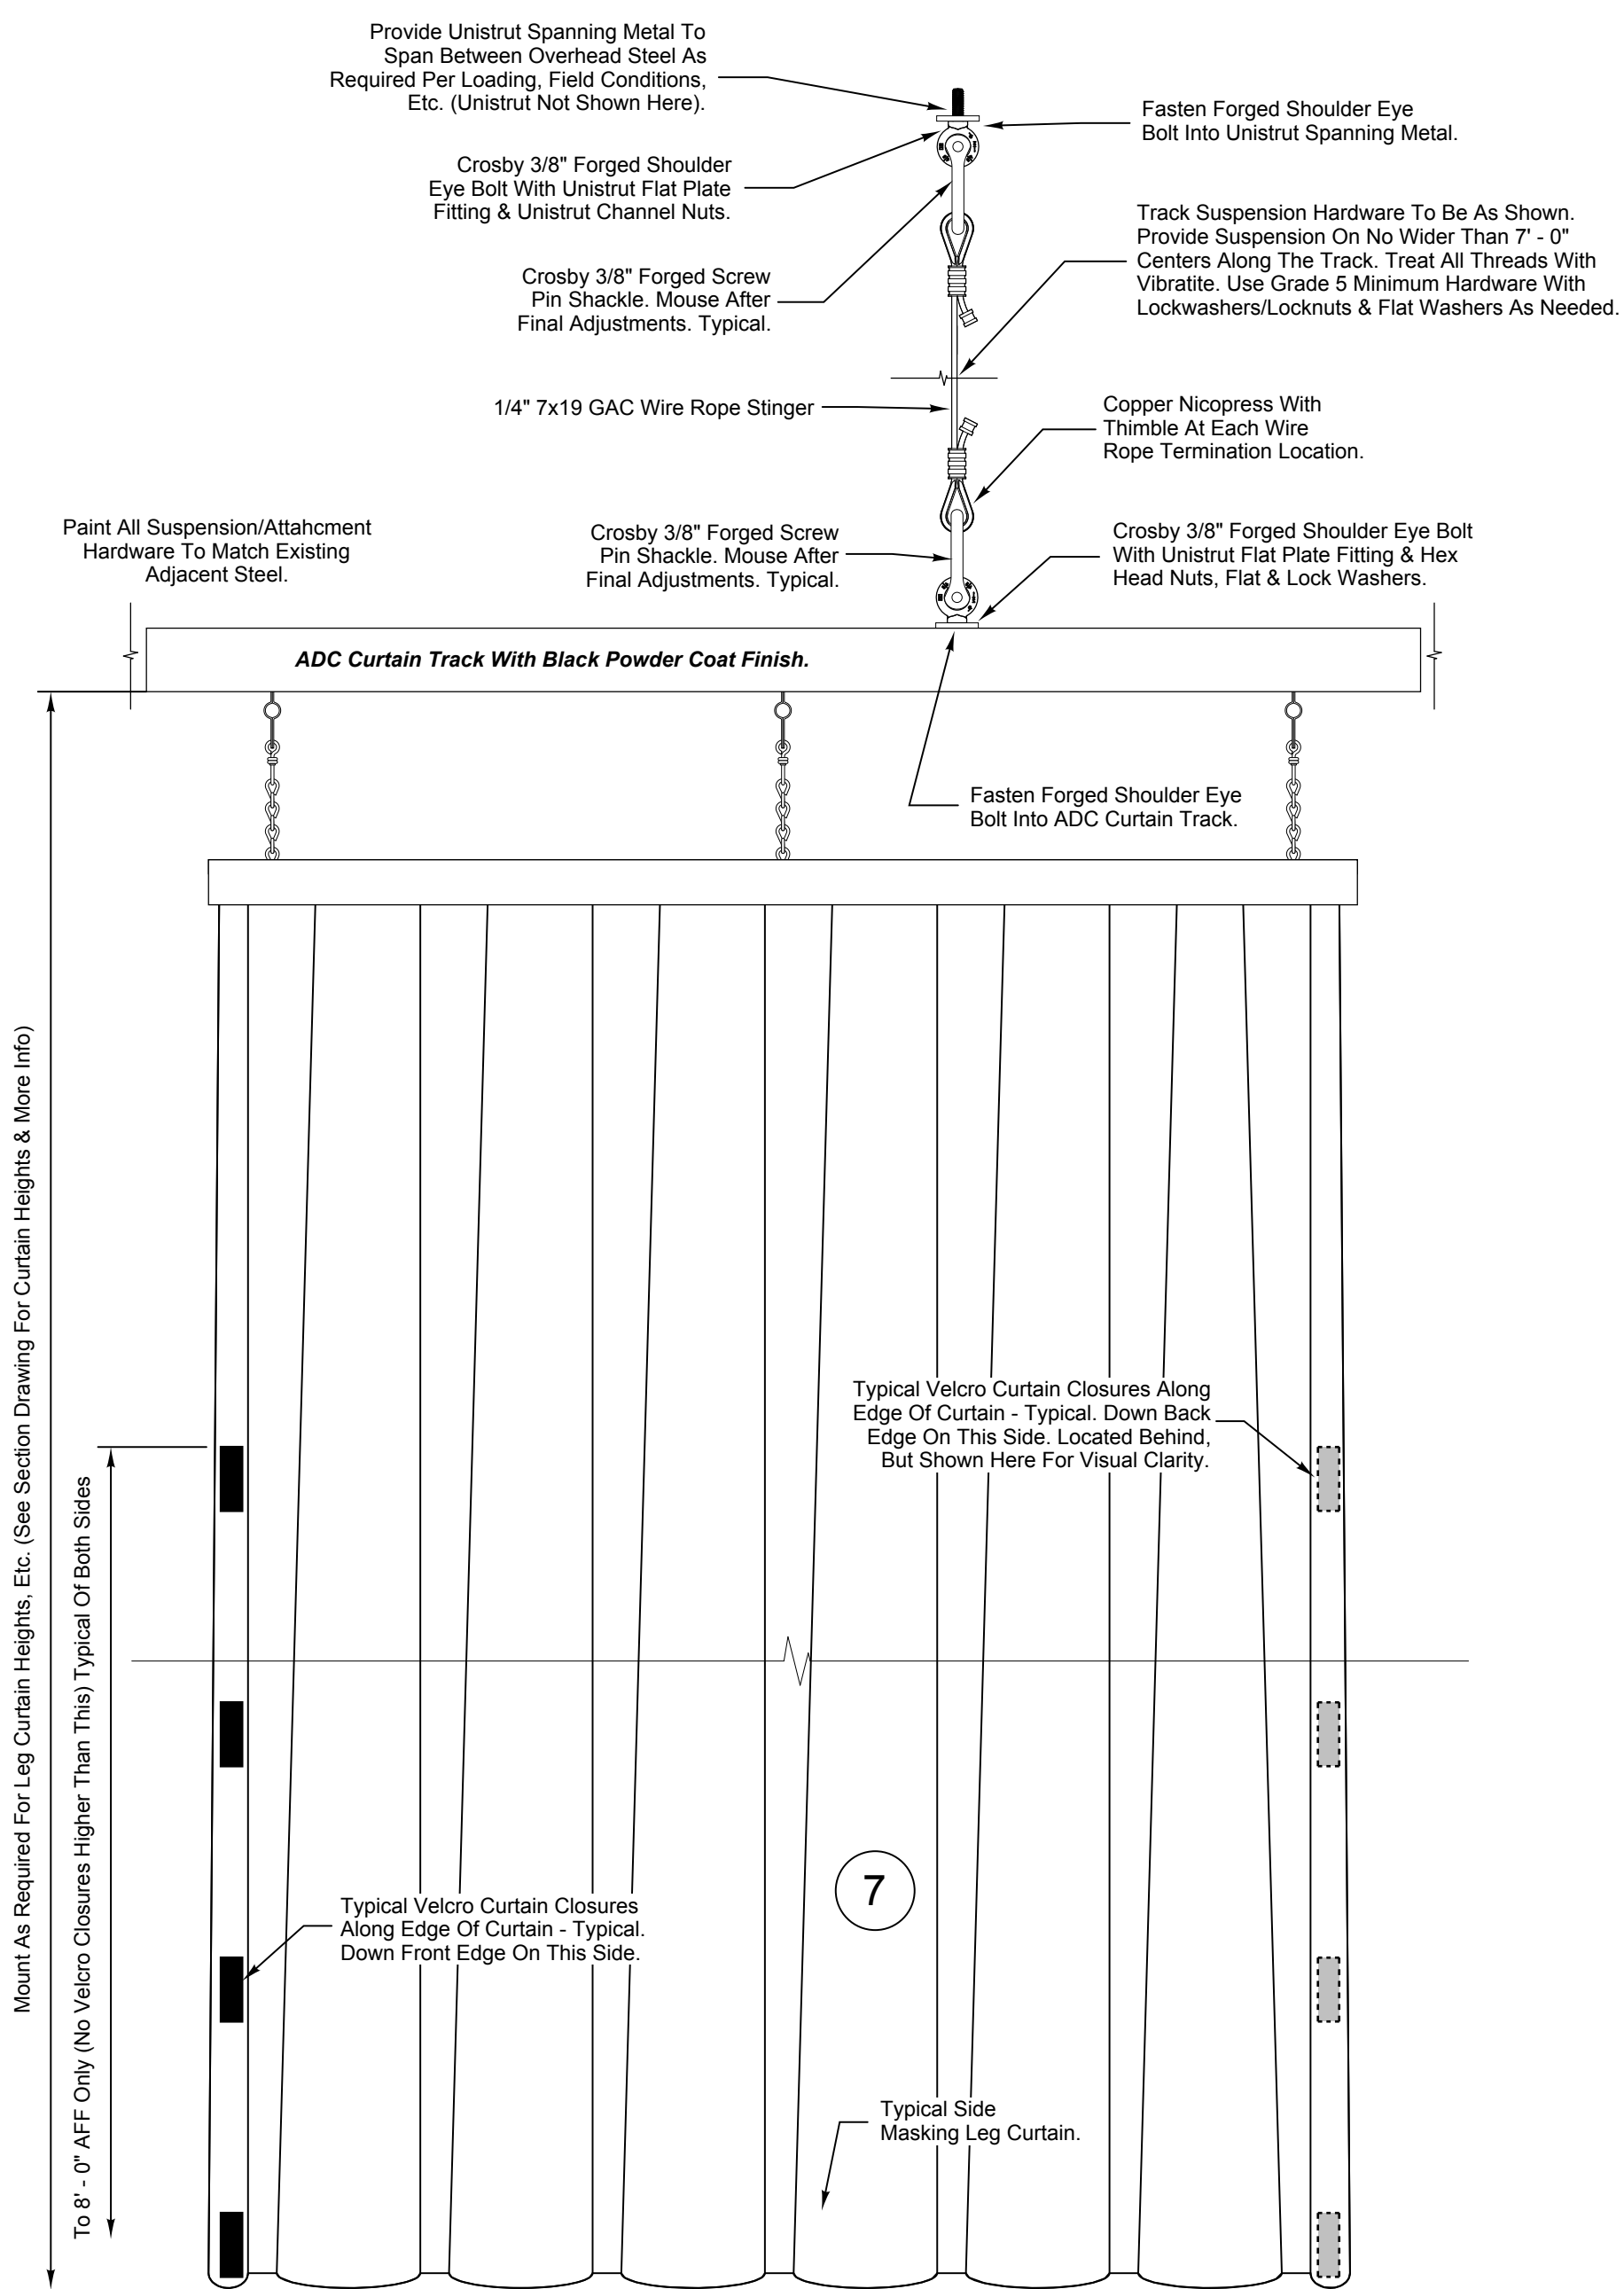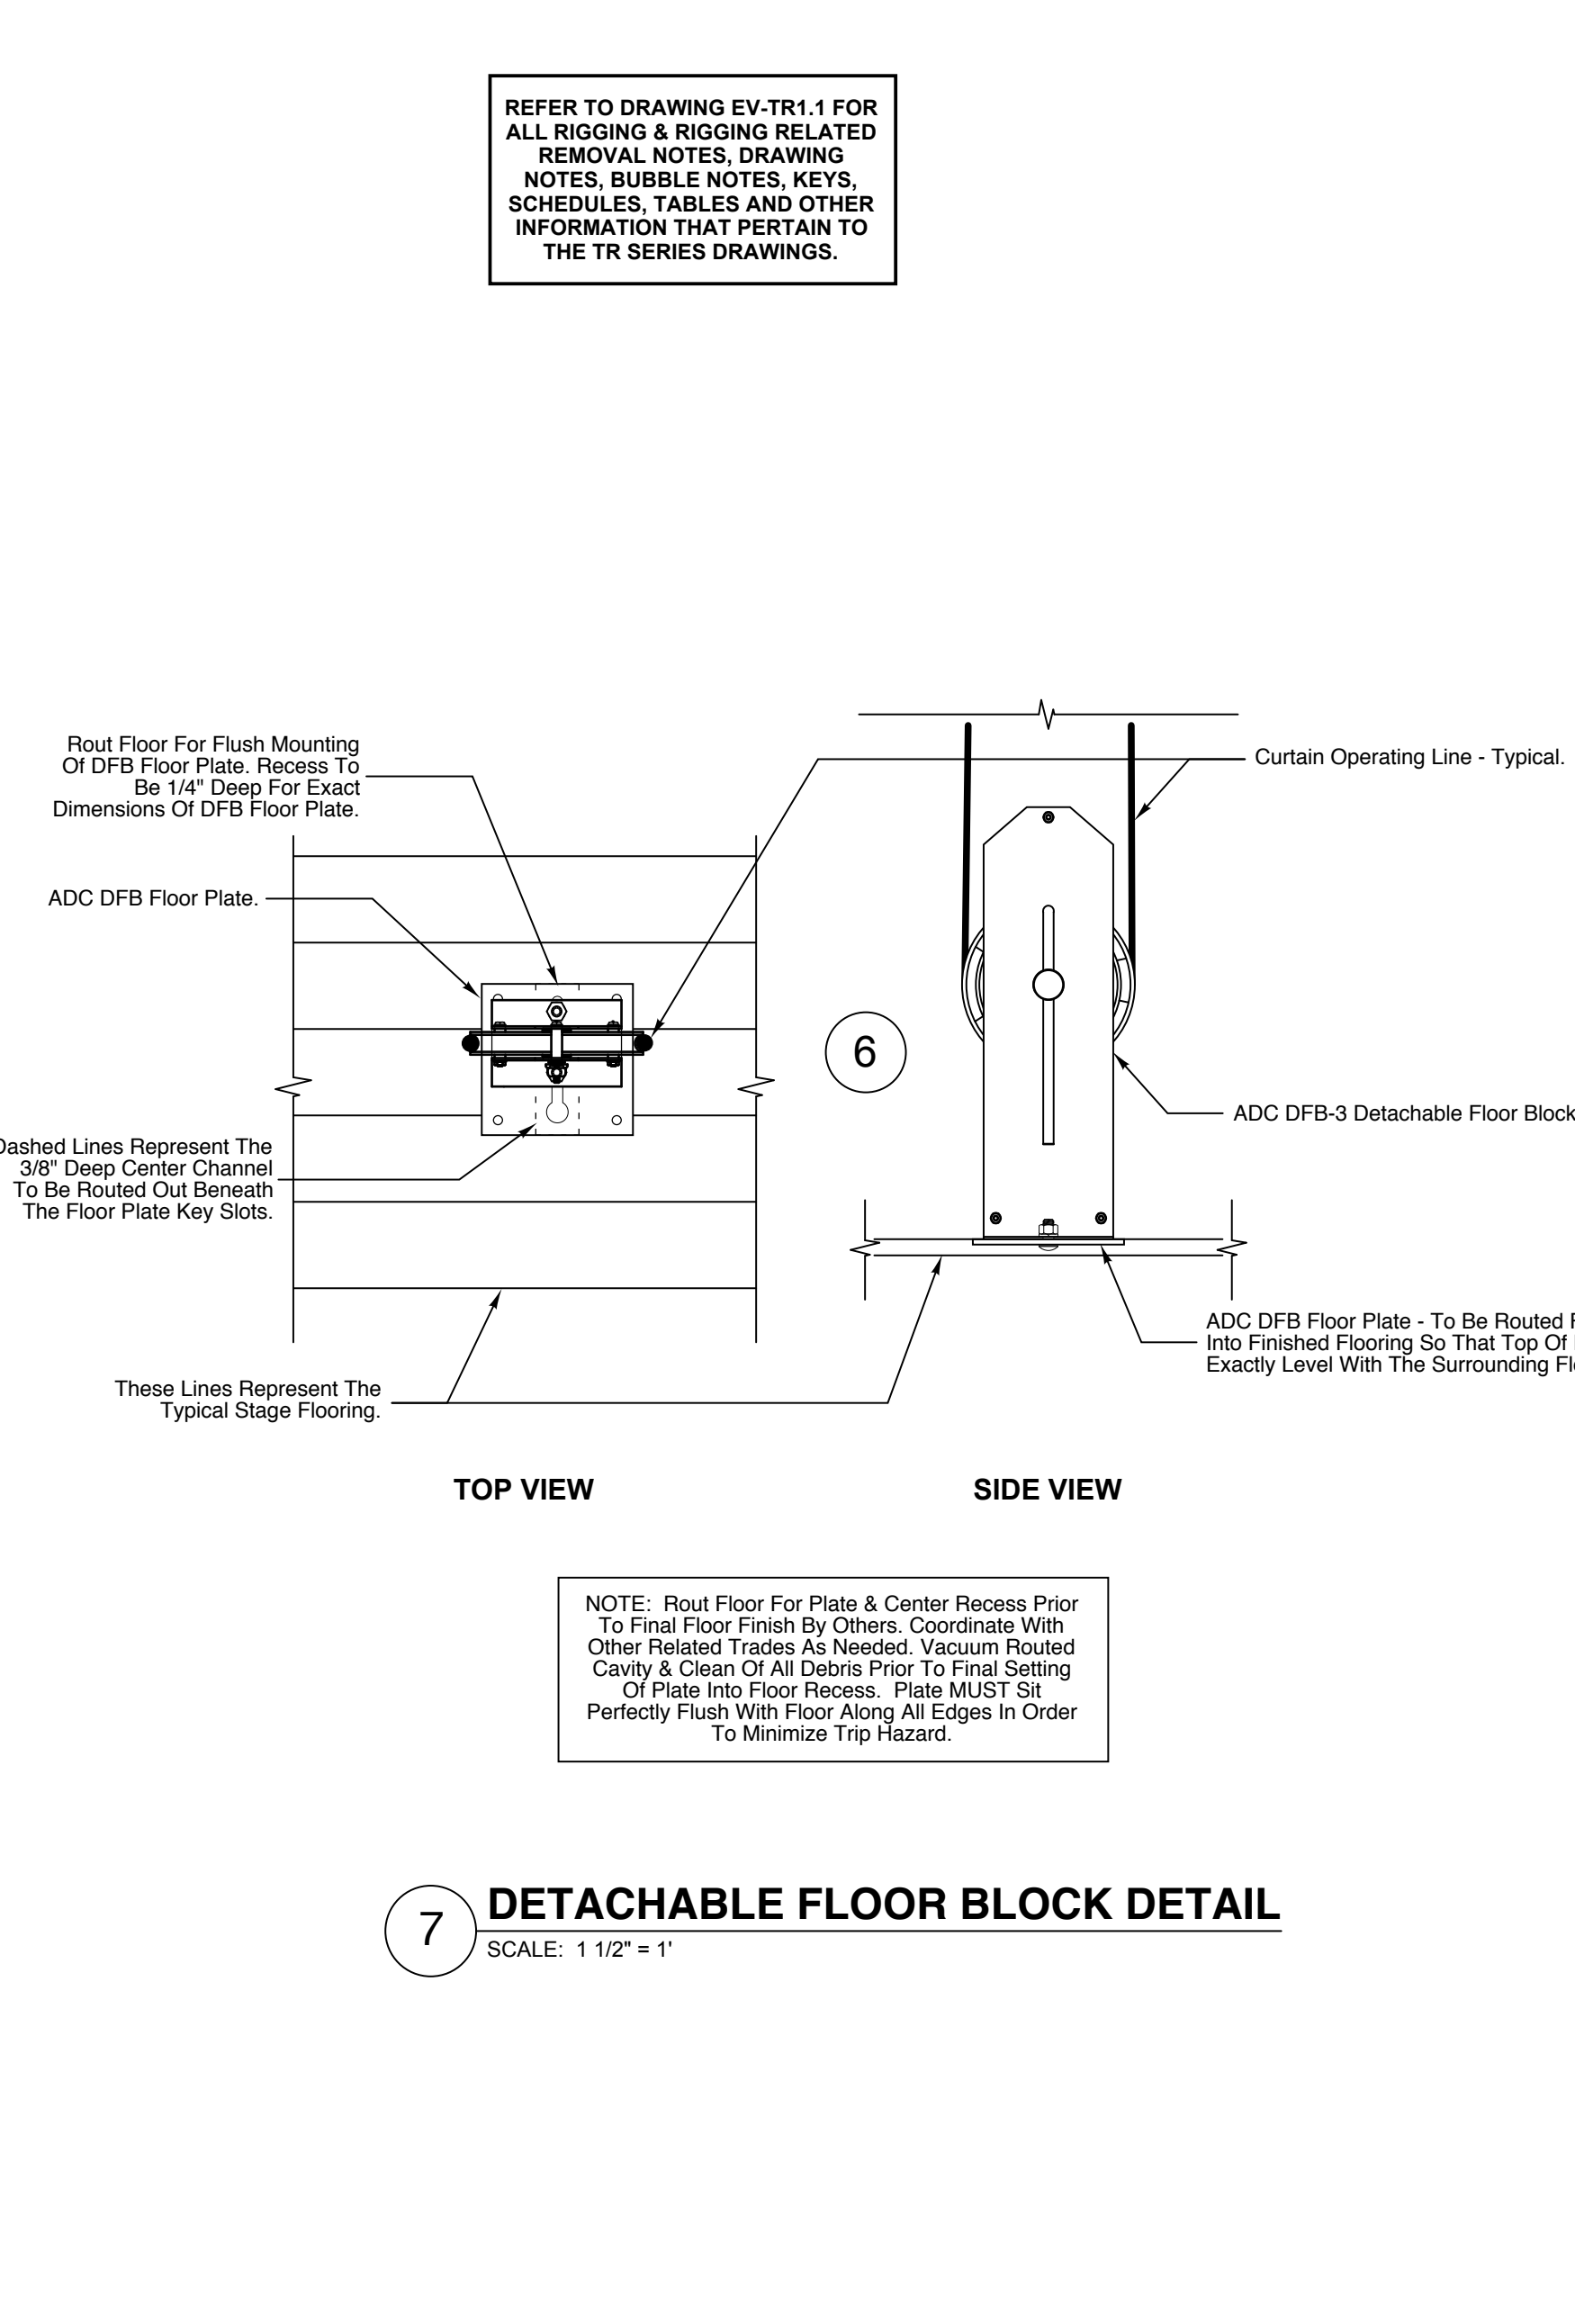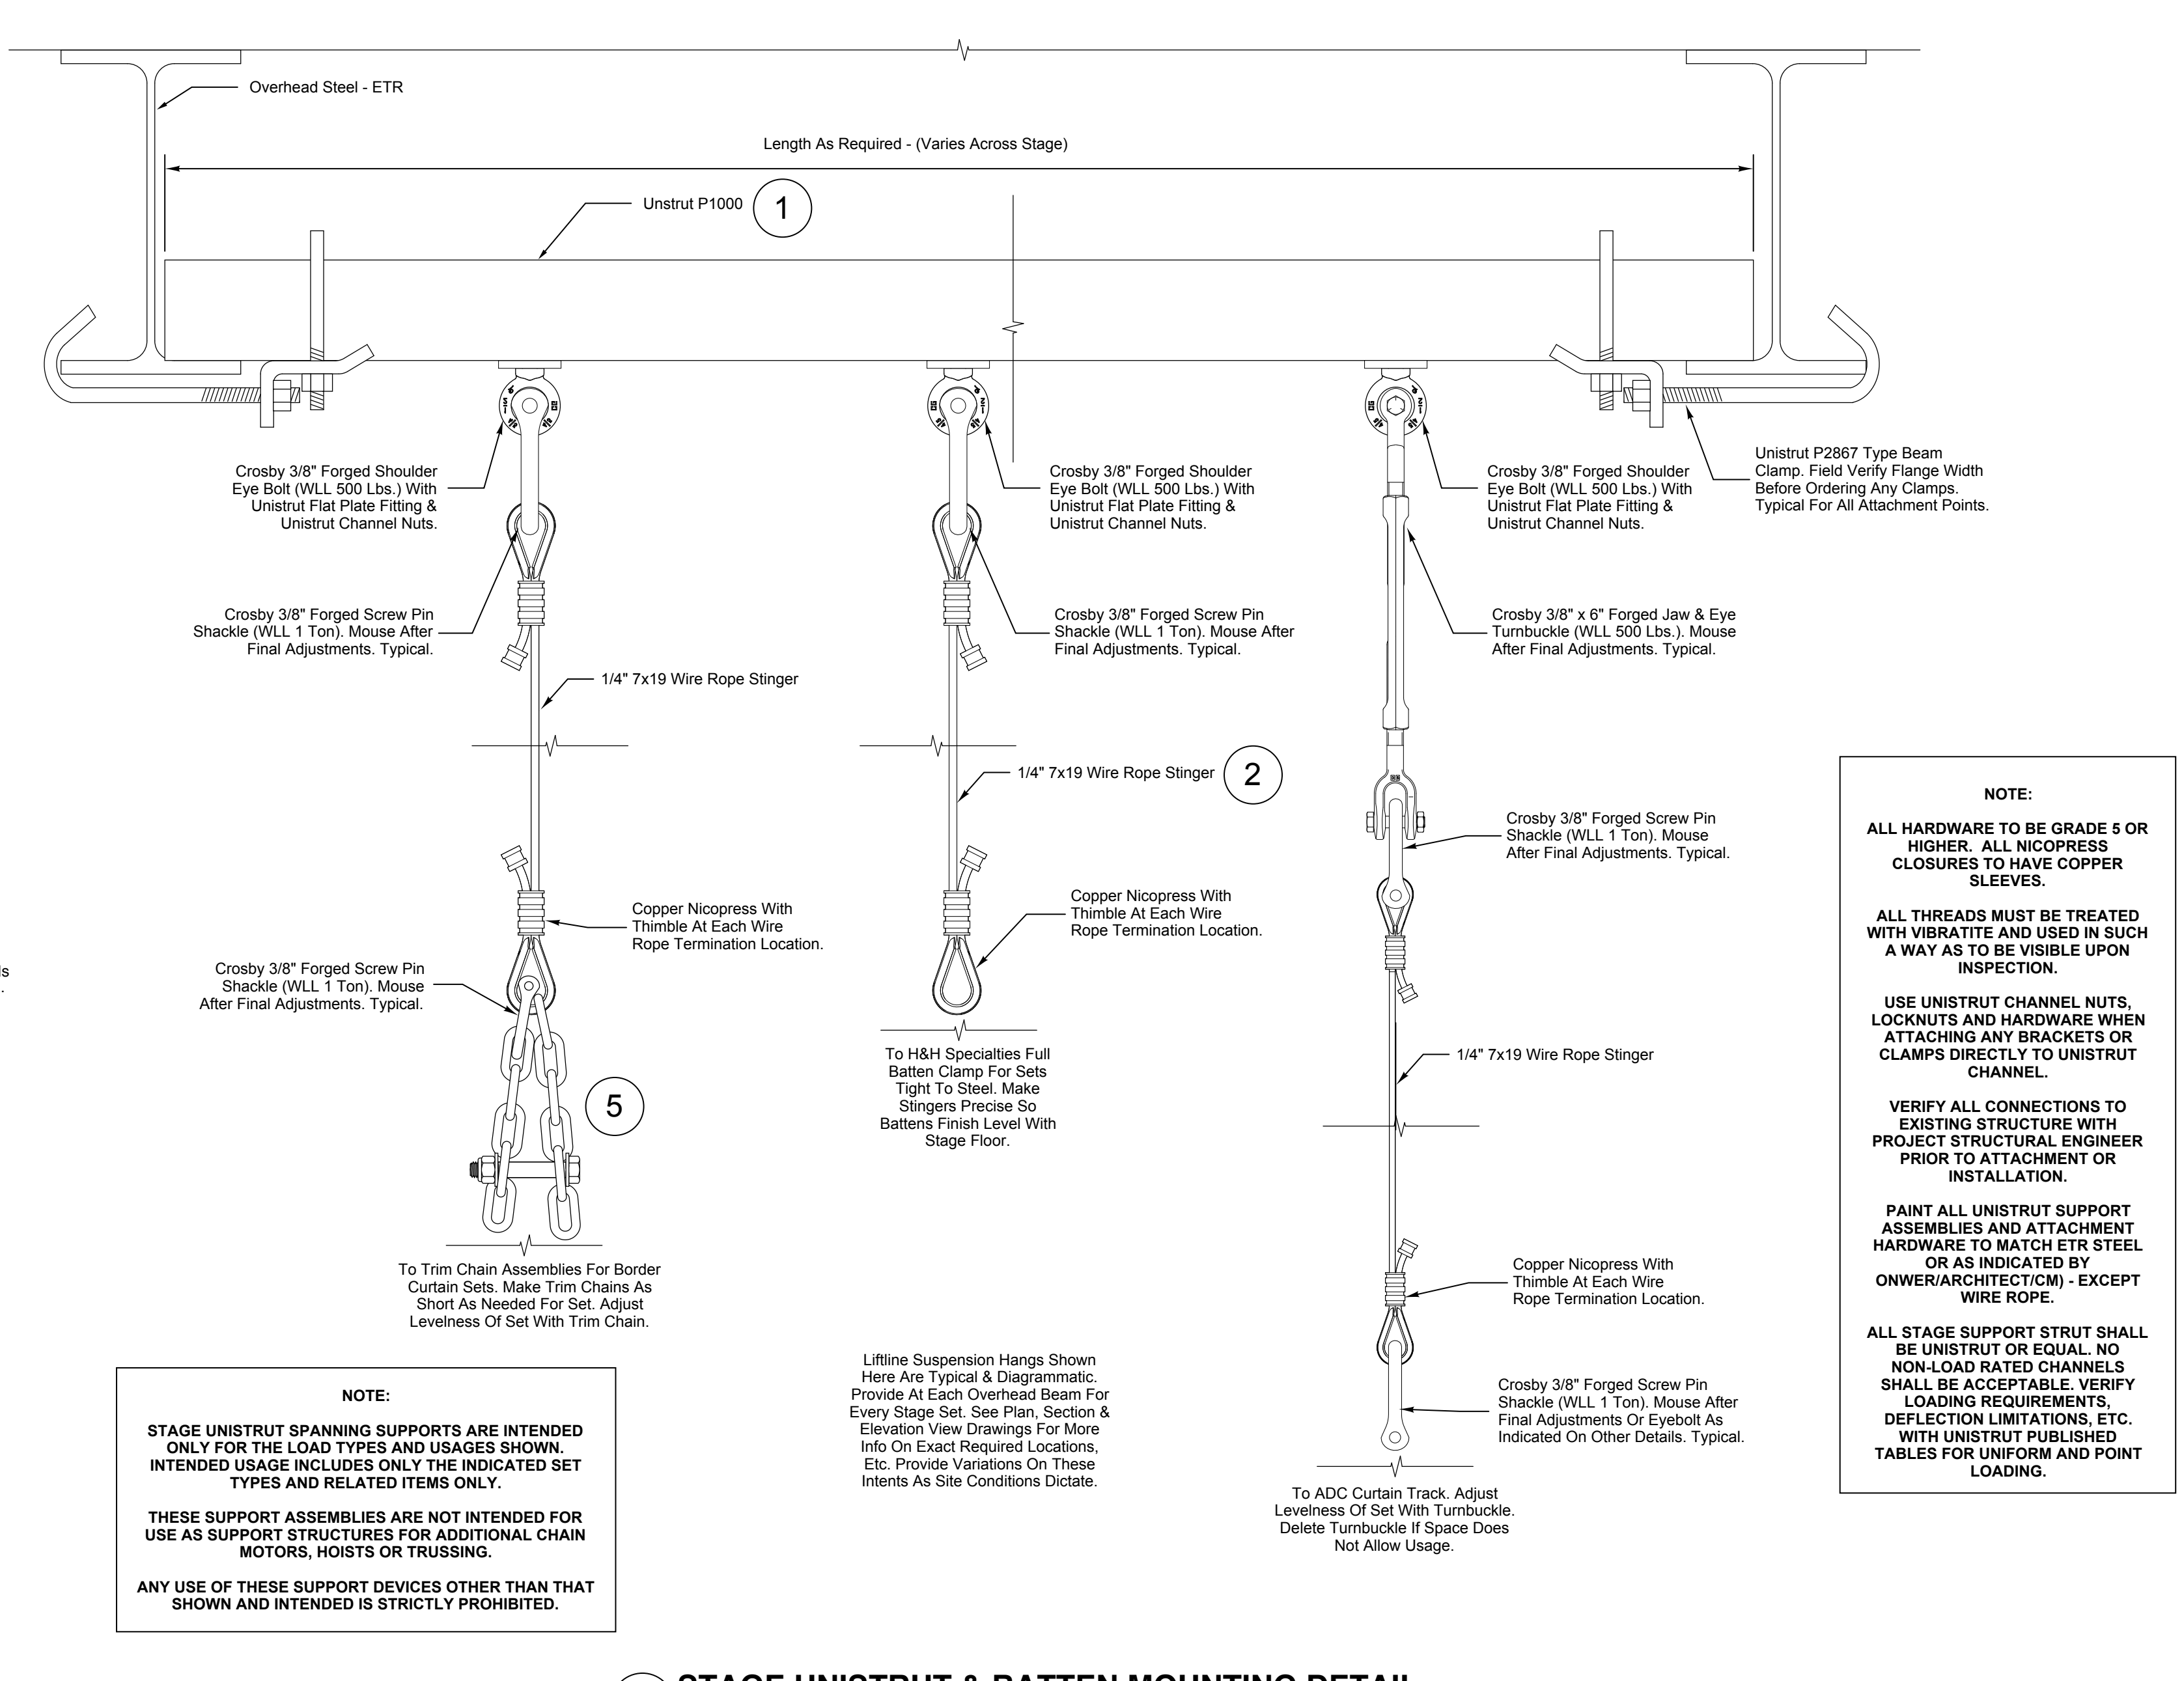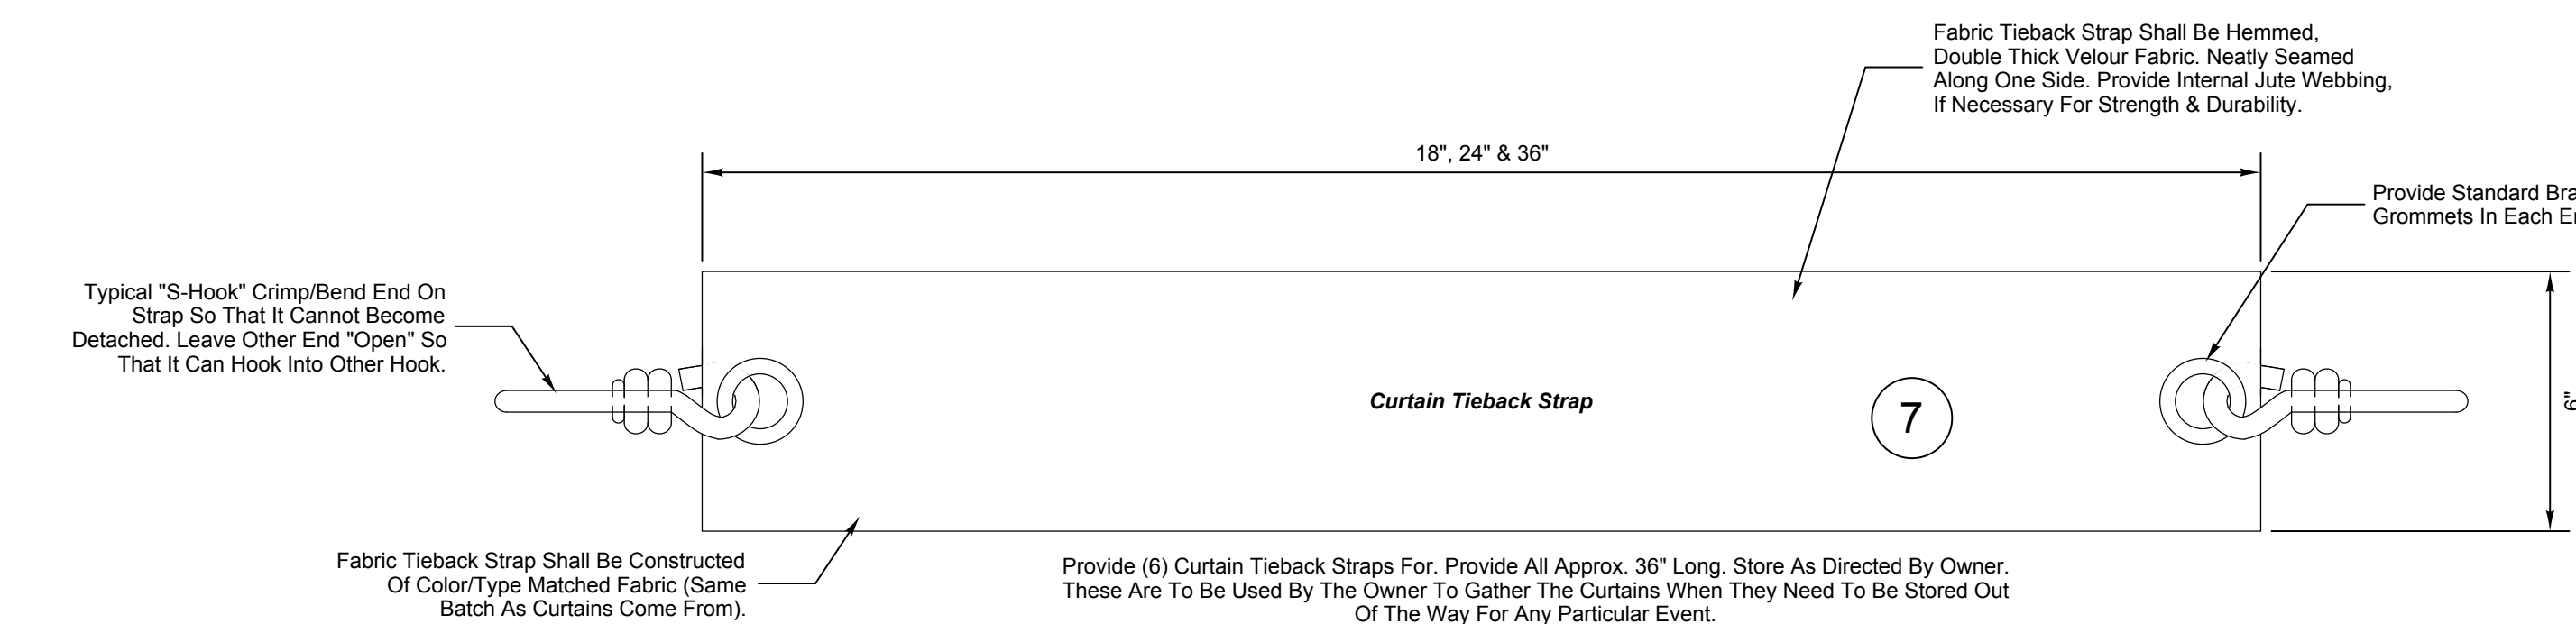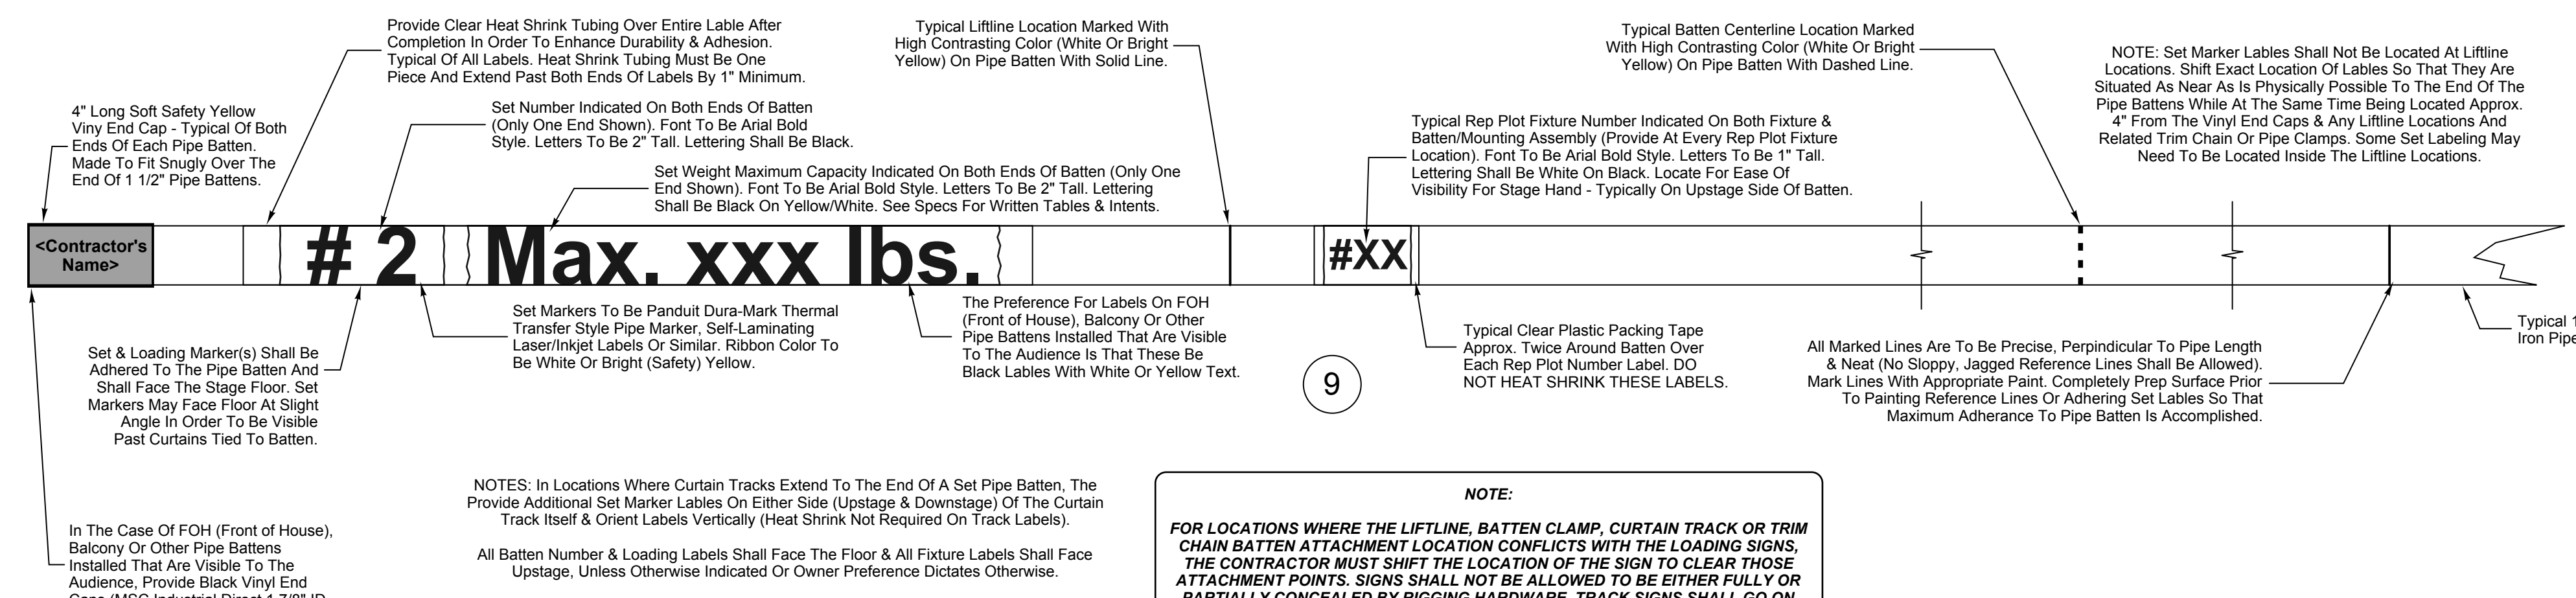

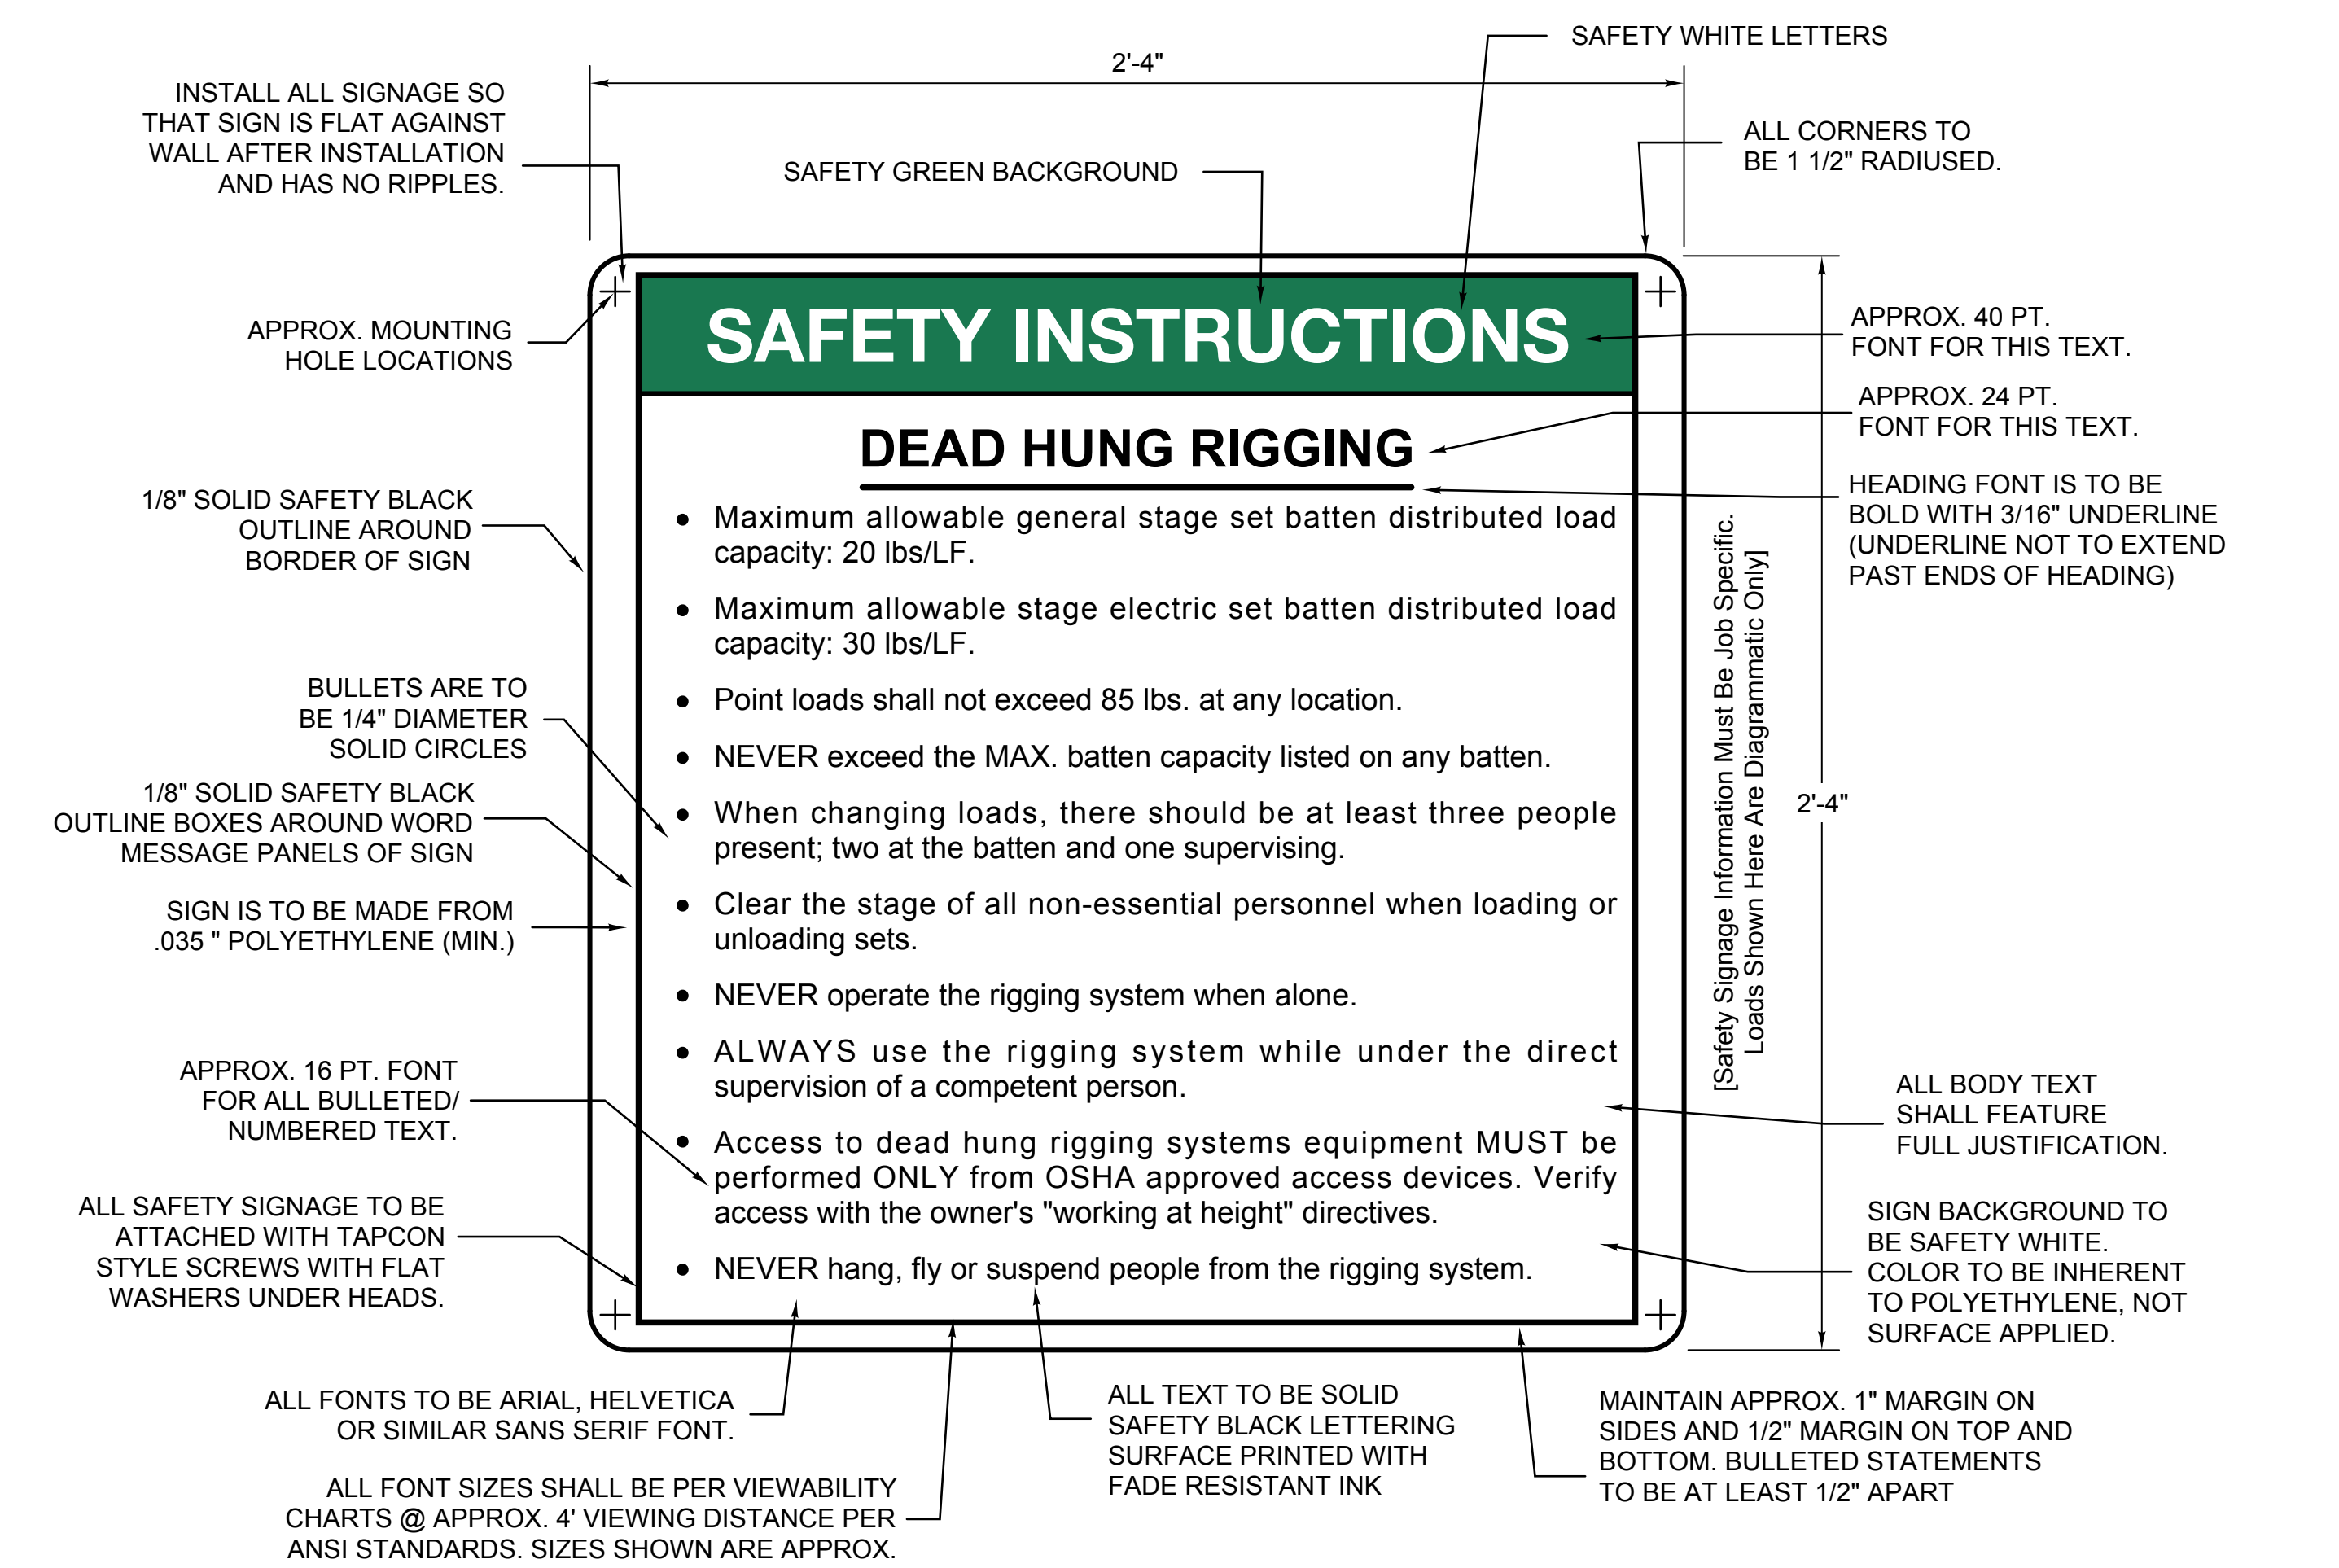

1 SAMPLE DEAD HUNG RIGGING SAFETY SIGNAGE
SCALE: NONE

REFER TO DRAWING EV-TR1.1 FOR ALL RIGGING & RIGGING RELATED REMOVAL NOTES, DRAWING NOTES, BUBBLE NOTES, KEYS, SCHEDULES, TABLES AND OTHER INFORMATION THAT PERTAIN TO THE TR SERIES DRAWINGS.

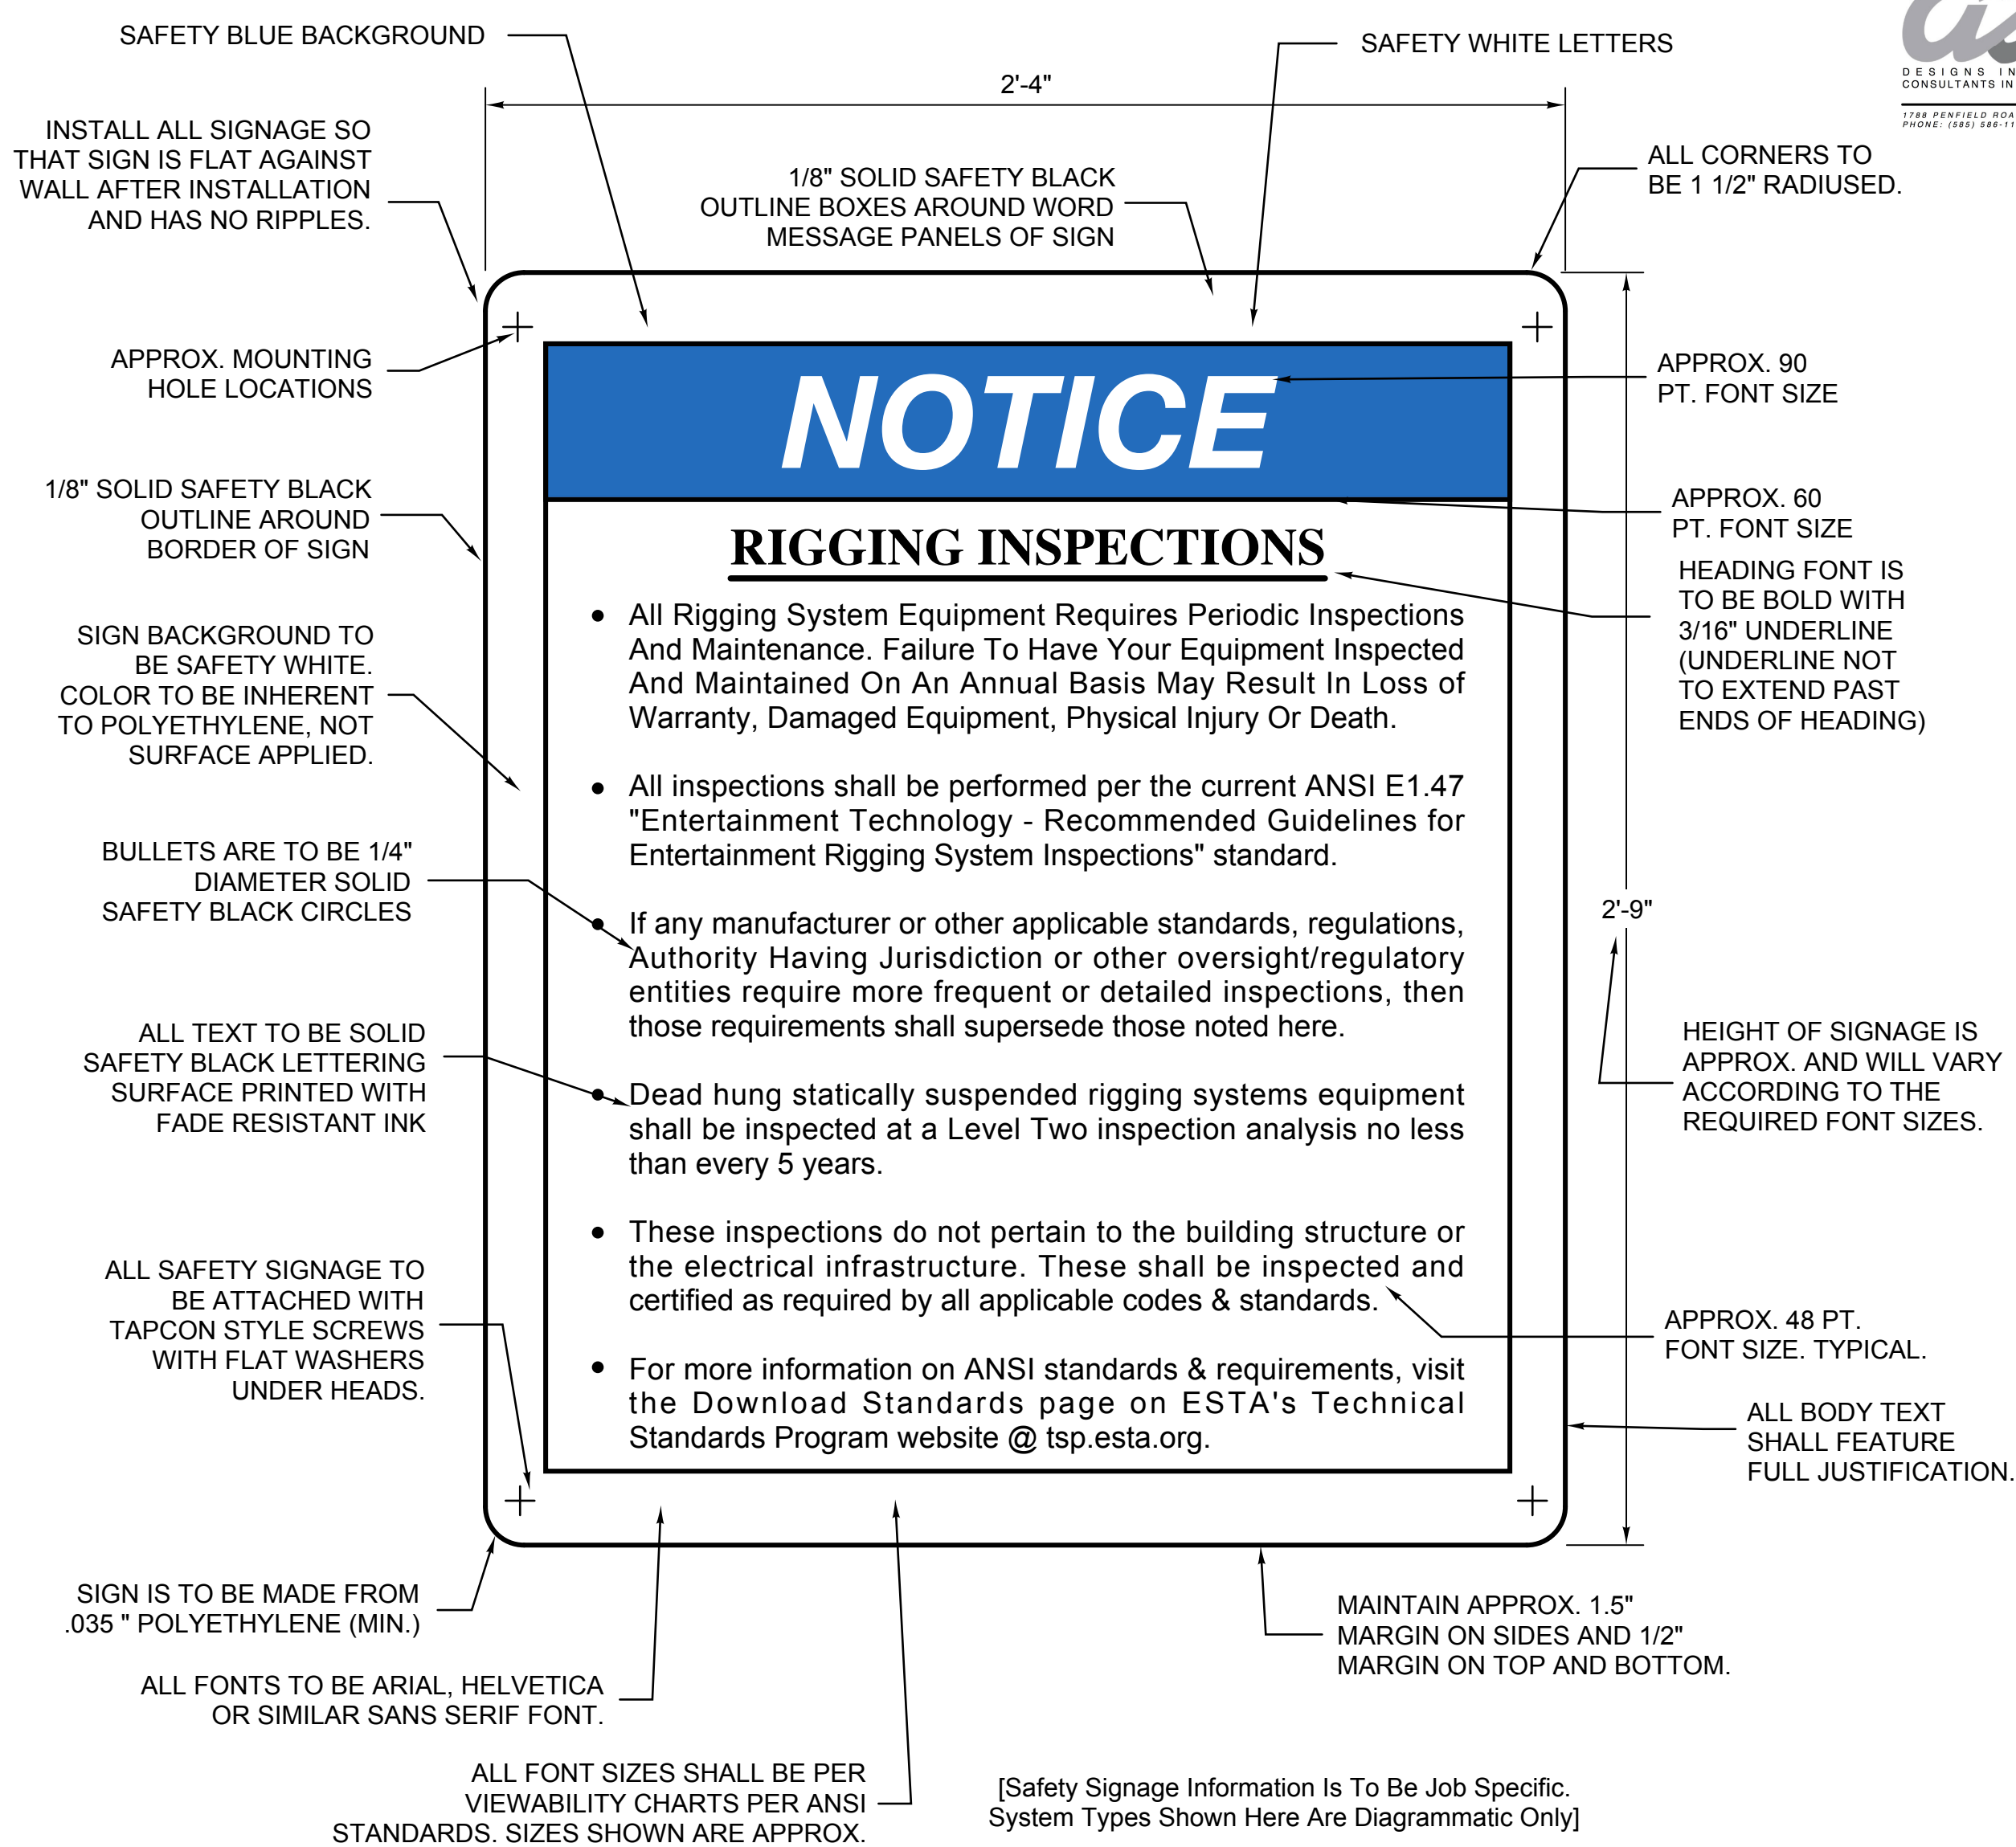

2 SAMPLE RIGGING INSPECTIONS SIGNAGE
SCALE: NONE

- NOTES:
- Provide The Following Custom Safety Signs (See Written Specifications For More Information)
- (1) General Notice Informational Sign (Mount On One Side Of The Stage)
- (1) General Caution Safety Sign (Mount On One Side Of The Stage)
- (1) Set Capacity Sign - Dead Hung System (Mount On One Side Of The Stage)
- (1) Standard Dead Hung Rigging Operational Guidance Sign (Mount On One Side Of The Stage)
- (1) Dead Hung Rigging Sign (Mount On One Side Of The Stage)
- (1) Rigging Inspections Sign (Mount On One Side Of The Stage)
- Unistrut Signage (Provide & Mount As Indicated)
- Field Verify All Exact Mounting Locations With The Owner & Mount Where Existing Obstructions Permit. DO NOT Mount Any Safety Signage Where It Is Hidden Behind Curtains, Doors, Etc. Or Where It Cannot Be Easily Seen & Read.

NOTES:

All Safety Signage Shown Is Diagrammatic In Nature. Specific Safety Signage Text & Statements Must Accurately Reflect The Rigging At The Intended Facility. Verify All Pertinent Signage Text With The Designed & Intended System(s). Do Not Include Any Signage Text That Does Not Apply To This Particular Installation. Signage Sizes May Need To Be Larger Than What Is Shown Due To Increased Text Demands. Do Not Reduce Signage Text Font Size In Order To Fit Intended Verbiage Onto Specific Signage Size Shown (Except For Critical Signage Sizes Such As Unistrut, Etc. Signs).

All Safety Signage Shown Is Diagrammatic In Nature. Specific Safety Signage Text & Statements Must Accurately Reflect The Rigging At The Intended Facility. Verify All Pertinent Signage Text With The Designed & Intended System(s). Do Not Include Any Signage Text That Does Not Apply To This Particular Installation. Signage Sizes May Need To Be Larger Than What Is Shown Due To Increased Text Demands. Do Not Reduce Signage Text Font Size In Order To Fit Intended Verbiage Onto Specific Signage Size Shown (Except For Critical Signage Sizes Such As Unistrut, Etc. Signs).

All Signage Is To Be Installed In Locations That Make Sense, Unless Otherwise Instructed In Writing By Owner. I.E. Place Signage Near, Beside Or Above Equipment It Is Referring To, Except For Any Visible FOH Locations.

GENERAL SIGNAGE NOTES:

All Signage Shall Meet The ANSI Z35.2-2011 (R2017) Or Most Recent Version.

All Safety Signage Shown Is Diagrammatic In Nature. Specific Safety Signage Text & Statements Must Accurately Reflect The Rigging At The Intended Facility. Verify All Pertinent Signage Text With The Designed & Intended System(s). Do Not Include Any Signage Text That Does Not Apply To This Particular Installation. Signage Sizes & Related Text May Need To Be Larger Than What Is Shown Due To Increased Text Demands And ANSI Requirements For Readability At Distance. Typical Readable Distance Is Generally Understood To Be Approx. 10' - 0" To 15' - 0".

Do Not Reduce Signage Text Font Size In Order To Fit Intended Verbiage Onto Specific Signage Size Shown (Except For Critical Signage Sizes Such As Unistrut, Etc. Signs).

Do Not Cherry Pick Desired Text From Examples Shown Or Rename Signage Titles To Suit Personal Tastes. Include All Pertinent & Relevant Text Shown As It Pertains To This Project As Well As Any Additional Text That May Be Relevant. Reinterpretations Of Text Are Not Allowed Without Prior Written Approval.

For All Set Naming Nomenclatures As Shown On The "Set Capacity Chart" Use Those Names As Shown On The Contract Documents Unless Specifically Instructed By The Owner In Writing To Use Alternate Naming Conventions. If The Owner Is Used To Calling Certain Set Types By Specific Names (I.E. Stage Electrics May Be Colloquially Referred To As "LX", "LX2" Or Border Curtains May Be Variouslly Referred To As "Teaser, Olo Valance, Top Masking, Header, Etc.). In Those Cases It Would Be Best To Maintain Owner Familiarity In Naming Conventions To Avoid Confusion. Verify With Owner In Writing Prior To Signage Fabrication.

All Signage Is To Be Installed In Locations That Make Sense & That Meet The Current ANSI Standards, Unless Otherwise Instructed In Writing By Owner To Mount Elsewhere. (I.E. Place Signage Near, Beside Or Above Equipment It Is Referring To & Within Easy View Of Operators, Except For Any Visible FOH Locations.).


All Signage Colors Referenced Shall Meet The ANSI Z35.1-2017 Or Most Recent Version Color Technical Specifications. Specific Pantone Colors Or Color Mix Makeup Percentages Have Not Been Noted Here. Refer To The Most Recent Version Of The Referenced Standard For Exact Color Requirements.

Do Not Include QR Codes Or Other Links/URL's To Specific Standards On Any Signage. As These May Change And/Or Be Superseded Over Time. Instead Reference Higher Level Locations On A Relevant Website (I.E. "Visit The "Download Standards" Page On ESTA's Technical Standards Program Website @ TSP. ESTA.ORG For More Information" Or Something Similar).


All Signage Must Be Spall-Checked By The Contractor. No Signage With Spelling And/Or Major Grammatical Mistakes Shall Be Allowed. Verify That All Final Signage Text Matches Approved Shop Drawings Prior To Installation. Any Deficient Signage Will Be Replaced By The Contractor At His Own Expense.

Fully Instruct The Owner On Periodic Maintenance Required Of Signage To Keep Clean & To Maintain Good Legibility Over Time. Inform Not To Use Harsh Cleaning Chemicals On Signage.

Do Not Place Any Safety Signage Where It May Get Damaged Or Dislodged Due To Set, Arbor, Motor Or Other Stage Device Movement Or Areas Where Portions Of The Signage Will Be Blocked By Doors, Racks, Gates, Rigging System Components, Etc.

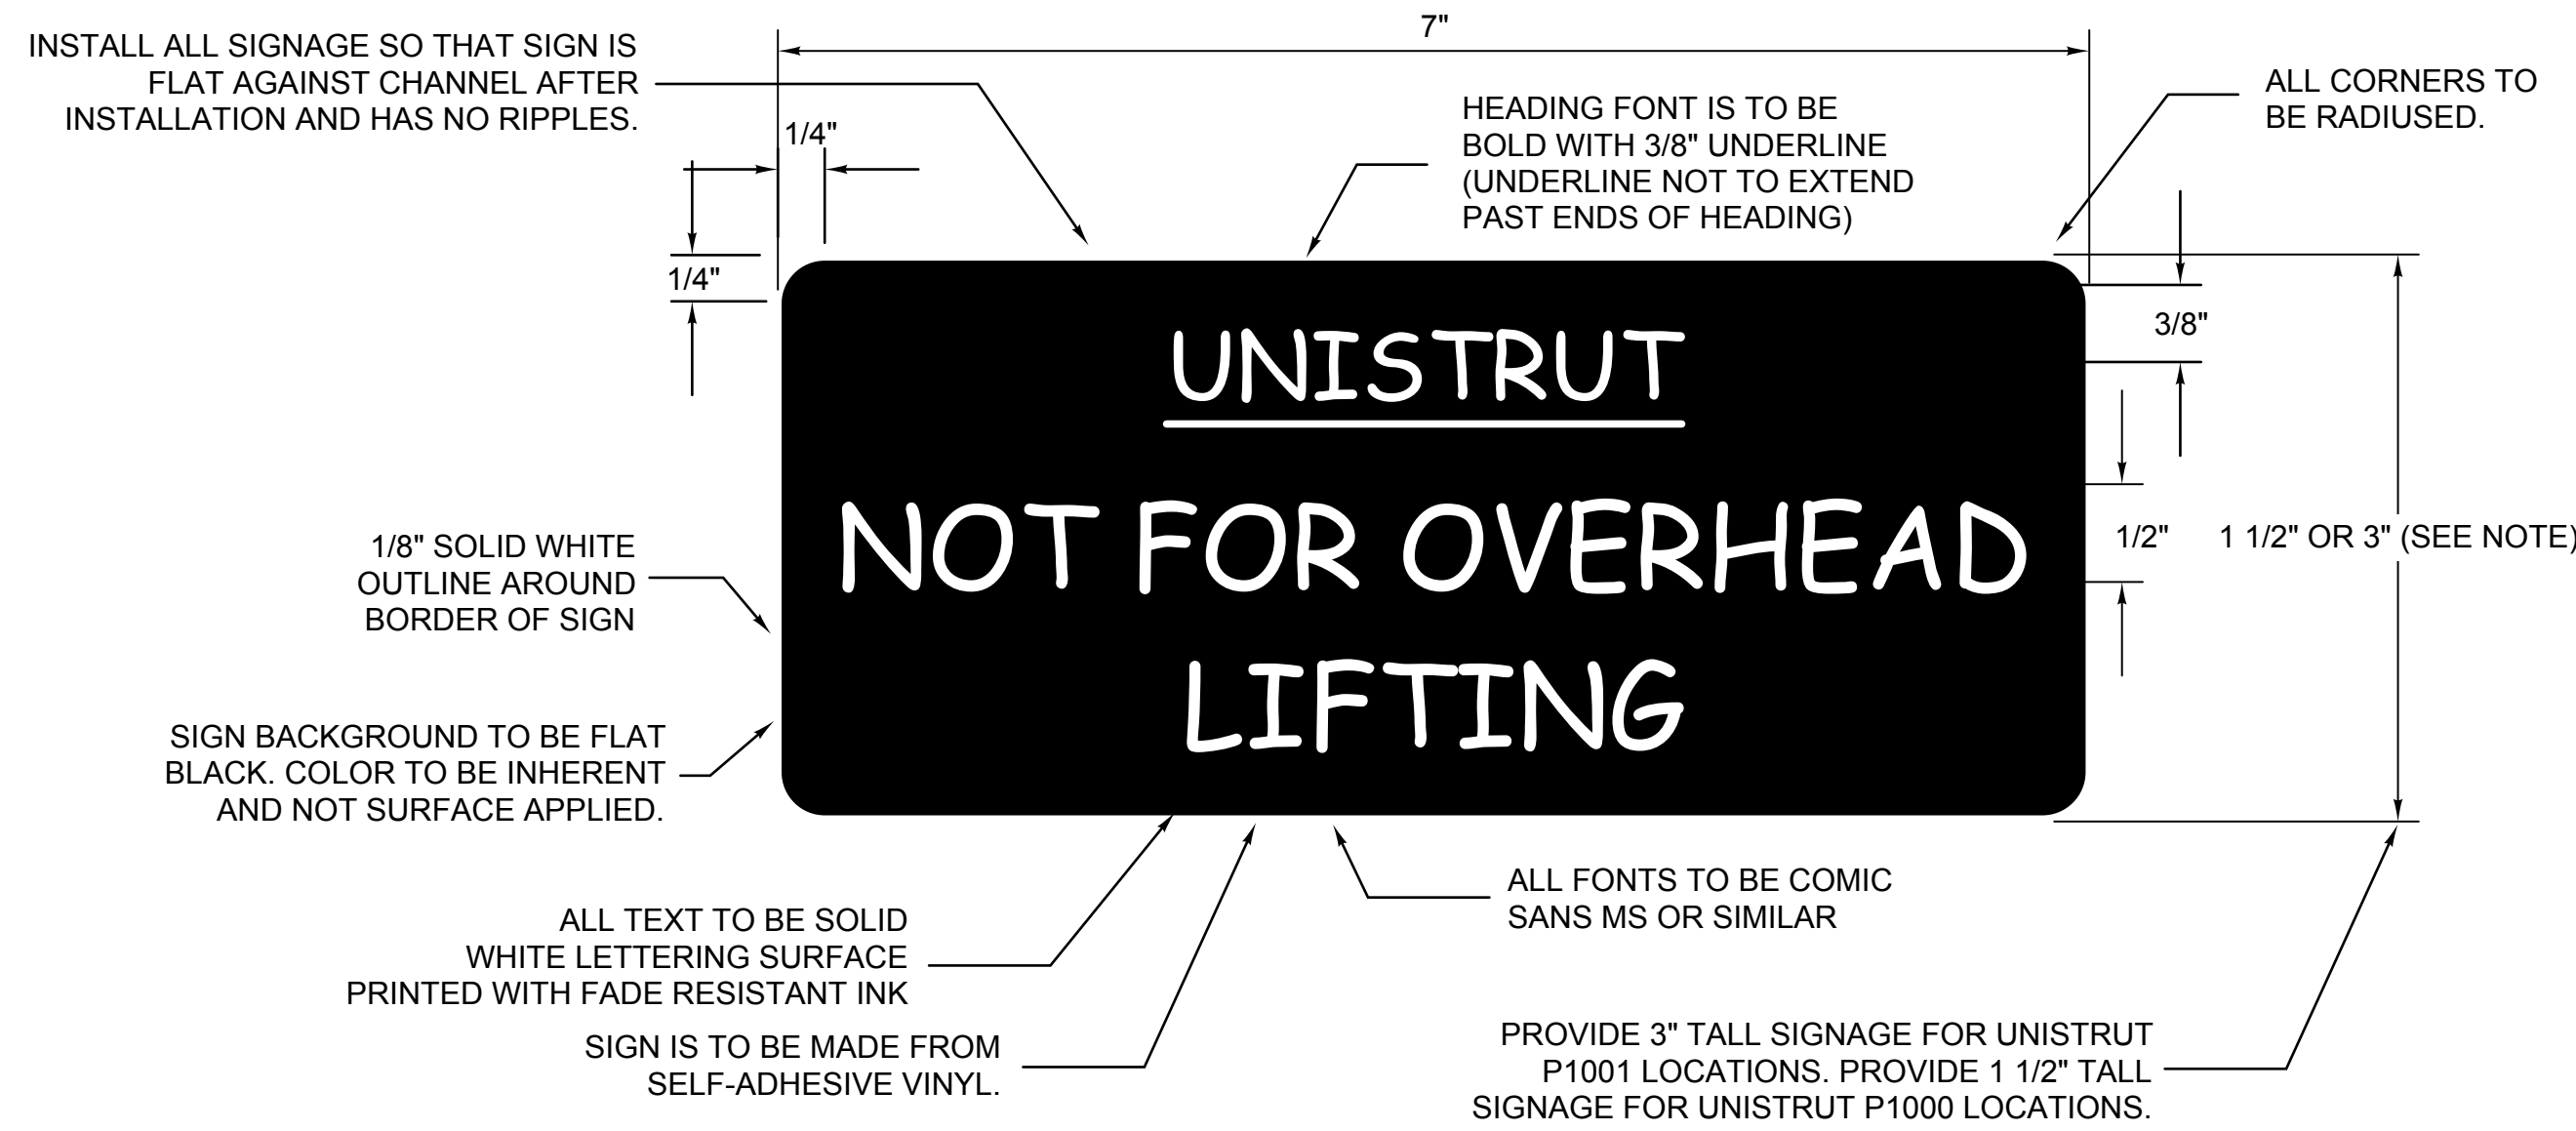

3 SAMPLE UNISTRUT SAFETY SIGNAGE
SCALE: NONE

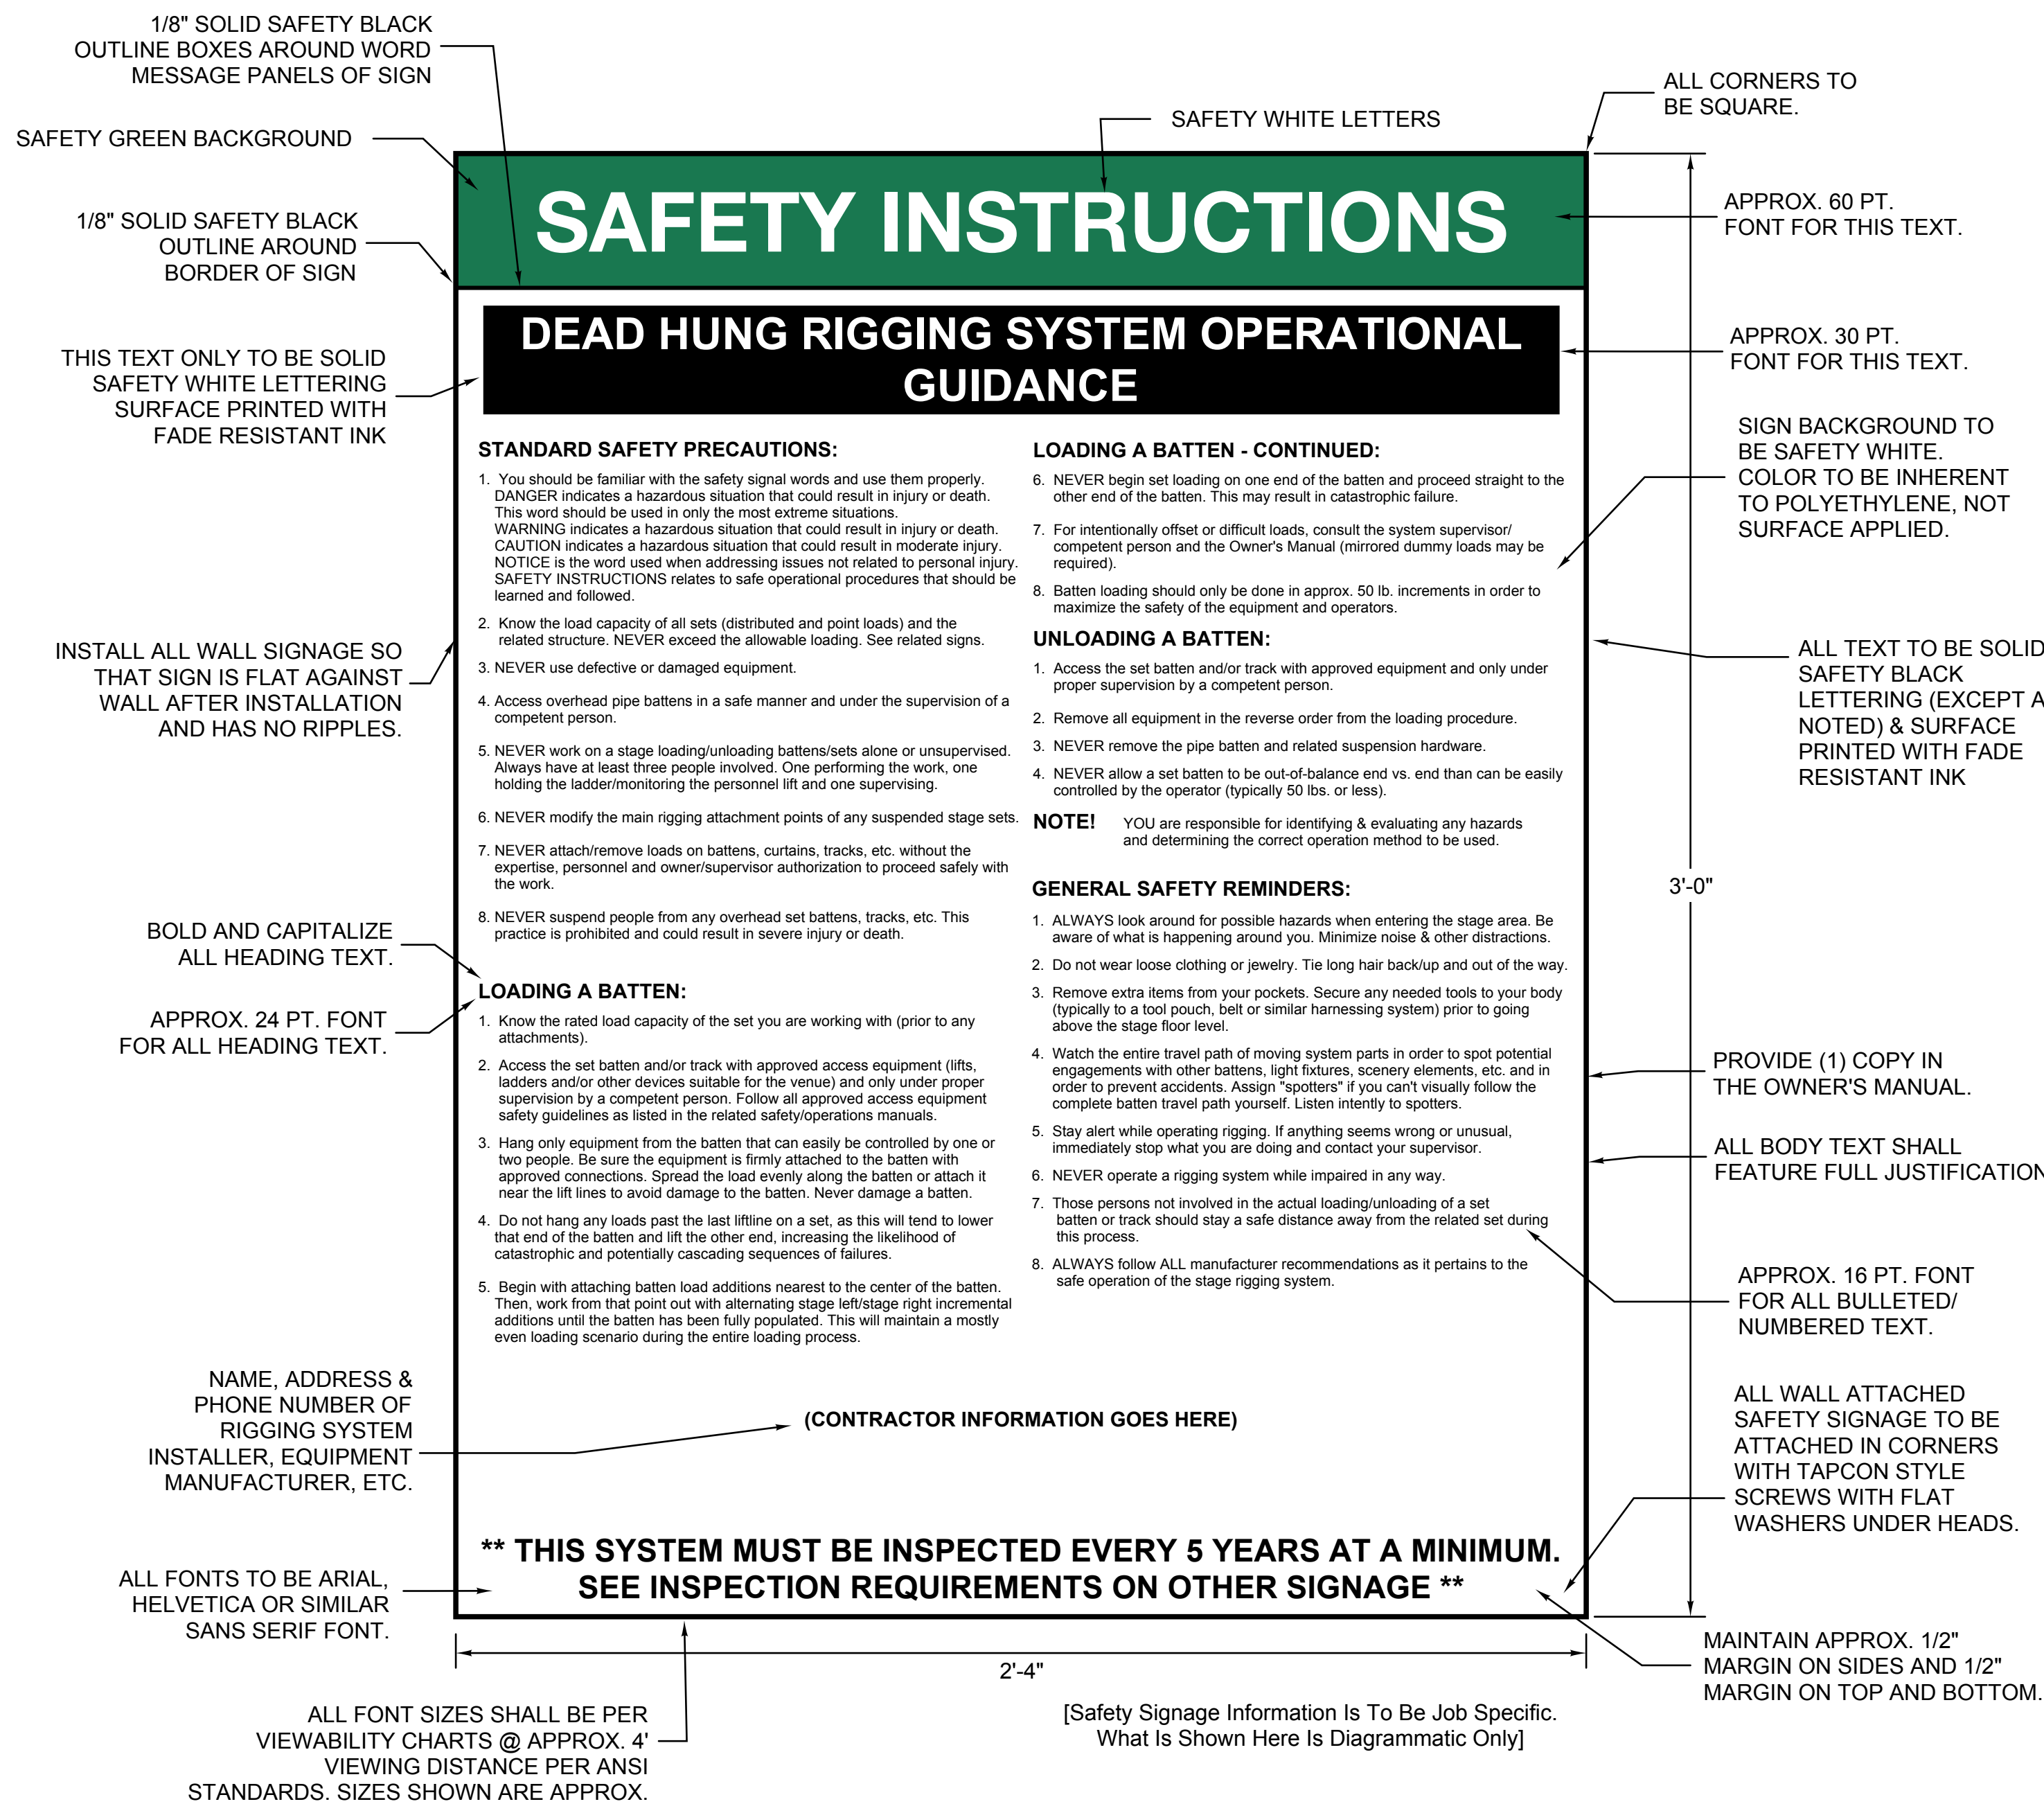

4 SAMPLE STANDARD OPERATIONAL SIGNAGE
SCALE: NONE



DRAWN BY: SPJ
CHECKED BY: SPJ
DATE: 03/17/2026
PHASE: CD

DESCRIPTION OF REVISION:
ISSUE FOR BID


DATE:
1 10/12/2026

IT IS A VIOLATION OF THE LAW FOR ANY PERSON TO MAKE UNAUTHORIZED ALTERATIONS OR ADDITIONS TO PLANS
UNLESS A LICENSED ENGINEER'S INITIALS & SIGNATURE ARE OBTAINED

HUNT ENGINEERS | ARCHITECTS | SURVEYORS
HORSEHEADS, NY 807-558-0038 BROOKLYN, NY 800-558-7508
BANGHARTON, NY 807-798-8081 ALBANY, NY 807-798-8081
WWW.HUNT-EAS.COM
NY CERTIFICATE NO. 0010220 PA CERTIFICATE NO. TSC2020191464-1

THEATRICAL RIGGING DETAILS - AREA B
2025 ERWIN VALLEY ELEM & ADMIN BUILDING ALTERATIONS
CORNING-PAINTED POST AREA SCHOOL DISTRICT
16 BEARTOWN ROAD, PAINTED POST, NY 14870


EV-TR1.3
PROJECT NO: 2649-160

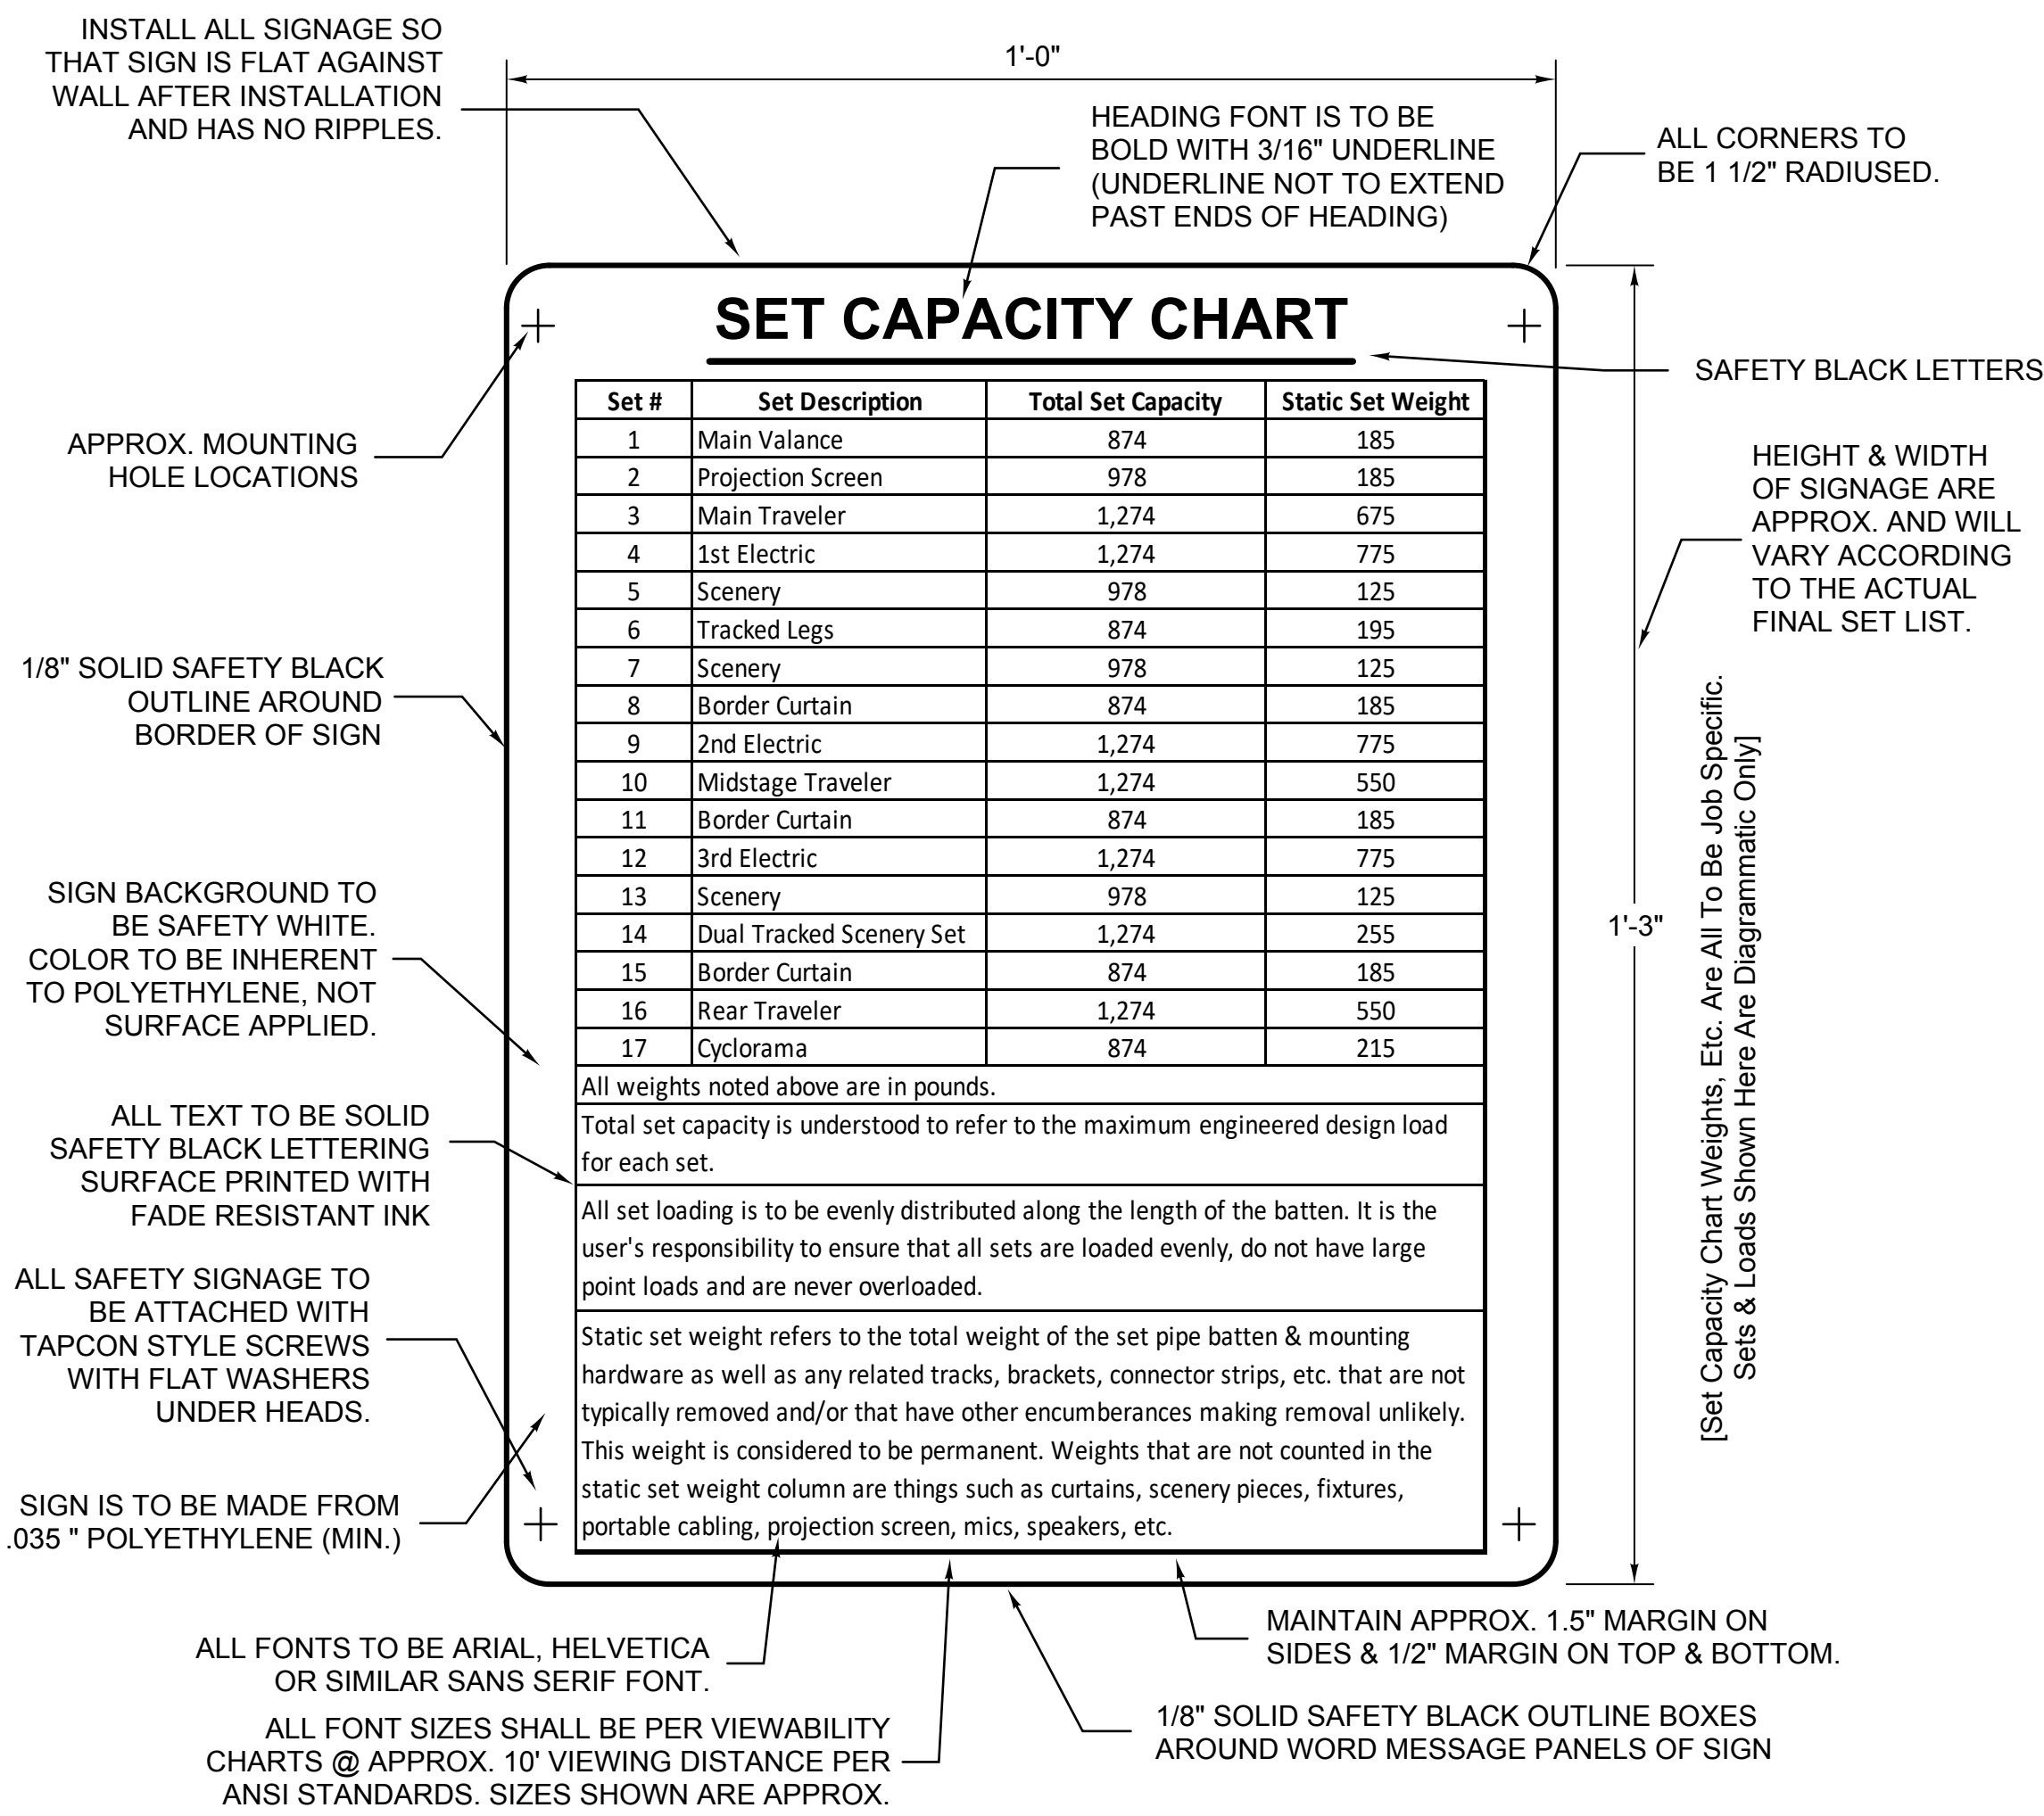

1 SAMPLE SET CAPACITY CHART SIGNAGE

SCALE: NONE

REFER TO DRAWING EV-TR1.1 FOR ALL RIGGING & RIGGING RELATED REMOVAL NOTES, DRAWING NOTES, BUBBLE NOTES, KEYS, SCHEDULES, TABLES AND OTHER INFORMATION THAT PERTAIN TO THE TR SERIES DRAWINGS.

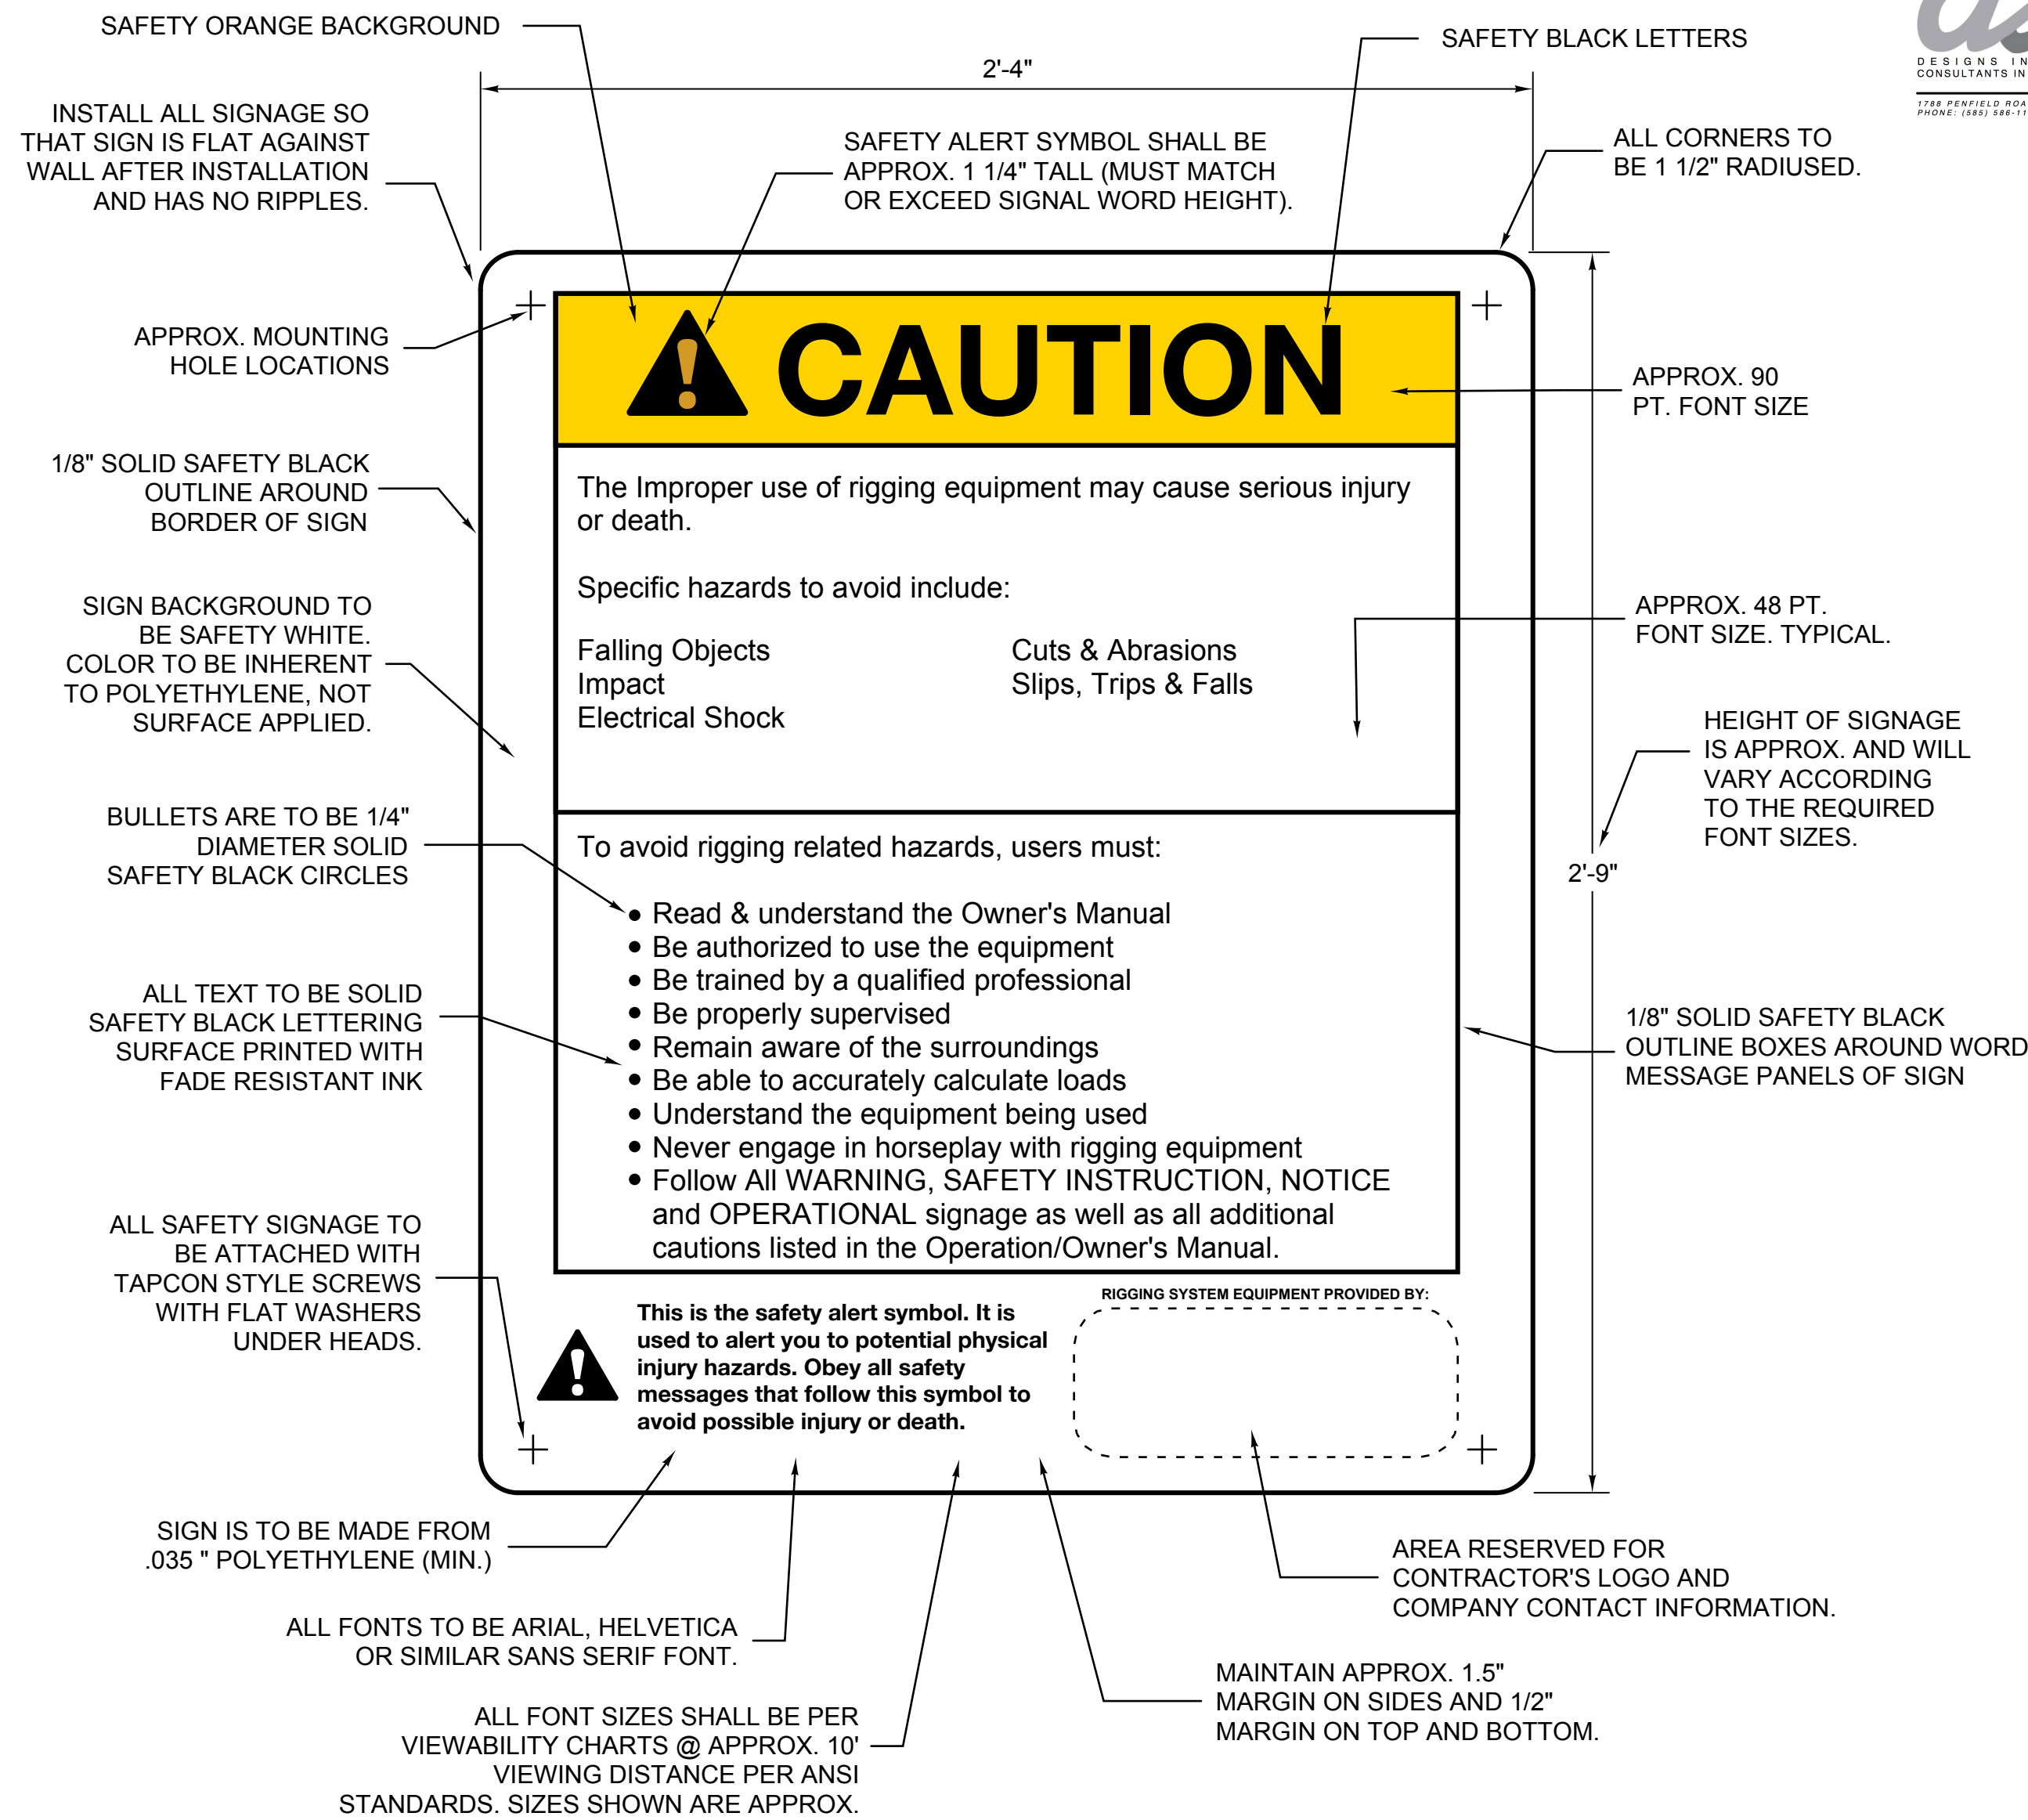

2 SAMPLE GENERAL CAUTION SAFETY SIGNAGE

SCALE: NONE

GENERAL SIGNAGE NOTES:

All Signage Shall Meet The ANSI Z535.2-2011 (R2017) Or Most Recent Version.

NOTES:

Provide The Following Custom Safety Signs (See Written Specifications For More Information)

(1) General Notice Informational Sign (Mount On One Side Of The Stage)

(1) General Caution Safety Sign (Mount On One Side Of The Stage)

(1) Set Capacity Sign - Dead Hung System (Mount On One Side Of The Stage)

(1) Standard Dead Hung Rigging Operational Guidance Sign (Mount On One Side Of The Stage)

(1) Dead Hung Rigging Sign (Mount On One Side Of The Stage)

(1) Rigging Inspections Sign (Mount On One Side Of The Stage)

Unistrut Signage (Provide & Mount As Indicated)

Field Verify All Exact Mounting Locations With The Owner & Mount Where Existing Obstructions Permit. DO NOT Mount Any Safety Signage Where It Is Hidden Behind Curtains, Doors, Etc. Or Where It Cannot Be Easily Seen & Read.

10

NOTES:

All Safety Signage Shown Is Diagrammatic In Nature. Specific Safety Signage Text & Statements Must Accurately Reflect The Rigging At The Intended Facility. Verify All Pertinent Signage Text With The Designed & Intended System(s). Do Not Include Any Signage Text That Does Not Apply To This Particular Installation. Signage Sizes May Need To Be Larger Than What Is Shown Due To Increased Text Demands. Do Not Reduce Signage Text Font Size In Order To Fit Intended Verbiage Onto Specific Signage Size Shown (Except For Critical Signage Sizes Such As Unistrut, Etc. Signs).

All Signage Is To Be Installed In Locations That Make Sense, Unless Otherwise Instructed In Writing By Owner. I.E. Place Signage Near, Beside Or Above Equipment It Is Referring To, Except For Any Visible FOH Locations.

For All Set Naming Nomenclatures As Shown On The "Set Capacity Chart" Use Those Names As Shown On The Contract Documents Unless Specifically Instructed By The Owner In Writing To Use Alternate Naming Conventions. If The Owner Is Used To Calling Certain Set Types By Specific Names (I.E. Stage Electrics May Be Colloquially Referred To As "LX1", "LX2" Or Border Curtains May Be Variouslly Referred To As Teaser, Olio Valance, Top Masking, Header, Etc.). In Those Cases It Would Be Best To Maintain Owner Familiarity In Naming Conventions To Avoid Confusion. Verify With Owner In Writing Prior To Signage Fabrication.

All Signage Is To Be Installed In Locations That Make Sense & That Meet The Current ANSI Standards, Unless Otherwise Instructed In Writing By Owner To Mount Elsewhere. (I.E. Place Signage Near, Beside Or Above Equipment It Is Referring To & Within Easy View Of Operators, Except For Any Visible FOH Locations.).


All Signage Colors Referenced Shall Meet The ANSI Z535.1-2017 Or Most Recent Version Color Technical Specifications. Specific Pantone Colors Or Color Mix Makeup Percentages Have Not Been Noted Here. Refer To The Most Recent Version Of The Referenced Standard For Exact Color Requirements.

Do Not Include QR Codes Or Other Links/URL's To Specific Standards On Any Signage. As These May Change And/Or Be Superseded Over Time. Instead Reference Higher Level Locations On A Relevant Website (I.E. "Visit The 'Download Standards' Page On ESTA's Technical Standards Program Website @ TSP.ESTA.ORG For More Information" Or Something Similar).

All Signage Must Be Spell-Checked By The Contractor. No Signage With Spelling And/Or Major Grammatical Mistakes Shall Be Allowed. Verify That All Final Signage Text Matches Approved Shop Drawings Prior To Installation. Any Deficient Signage Will Be Replaced By The Contractor At His Own Expense.

Fully Instruct The Owner On Periodic Maintenance Required Of Signage To Keep Clean & To Maintain Good Legibility Over Time. Inform Not To Use Harsh Cleaning Chemicals On Signage.

Do Not Place Any Safety Signage Where It May Get Damaged Or Dislodged Due To Set, Arbor, Motor Or Other Stage Device Movement Or In Areas Where Portions Of The Signage Will Be Blocked By Doors, Racks, Gates, Rigging System Components, Etc.

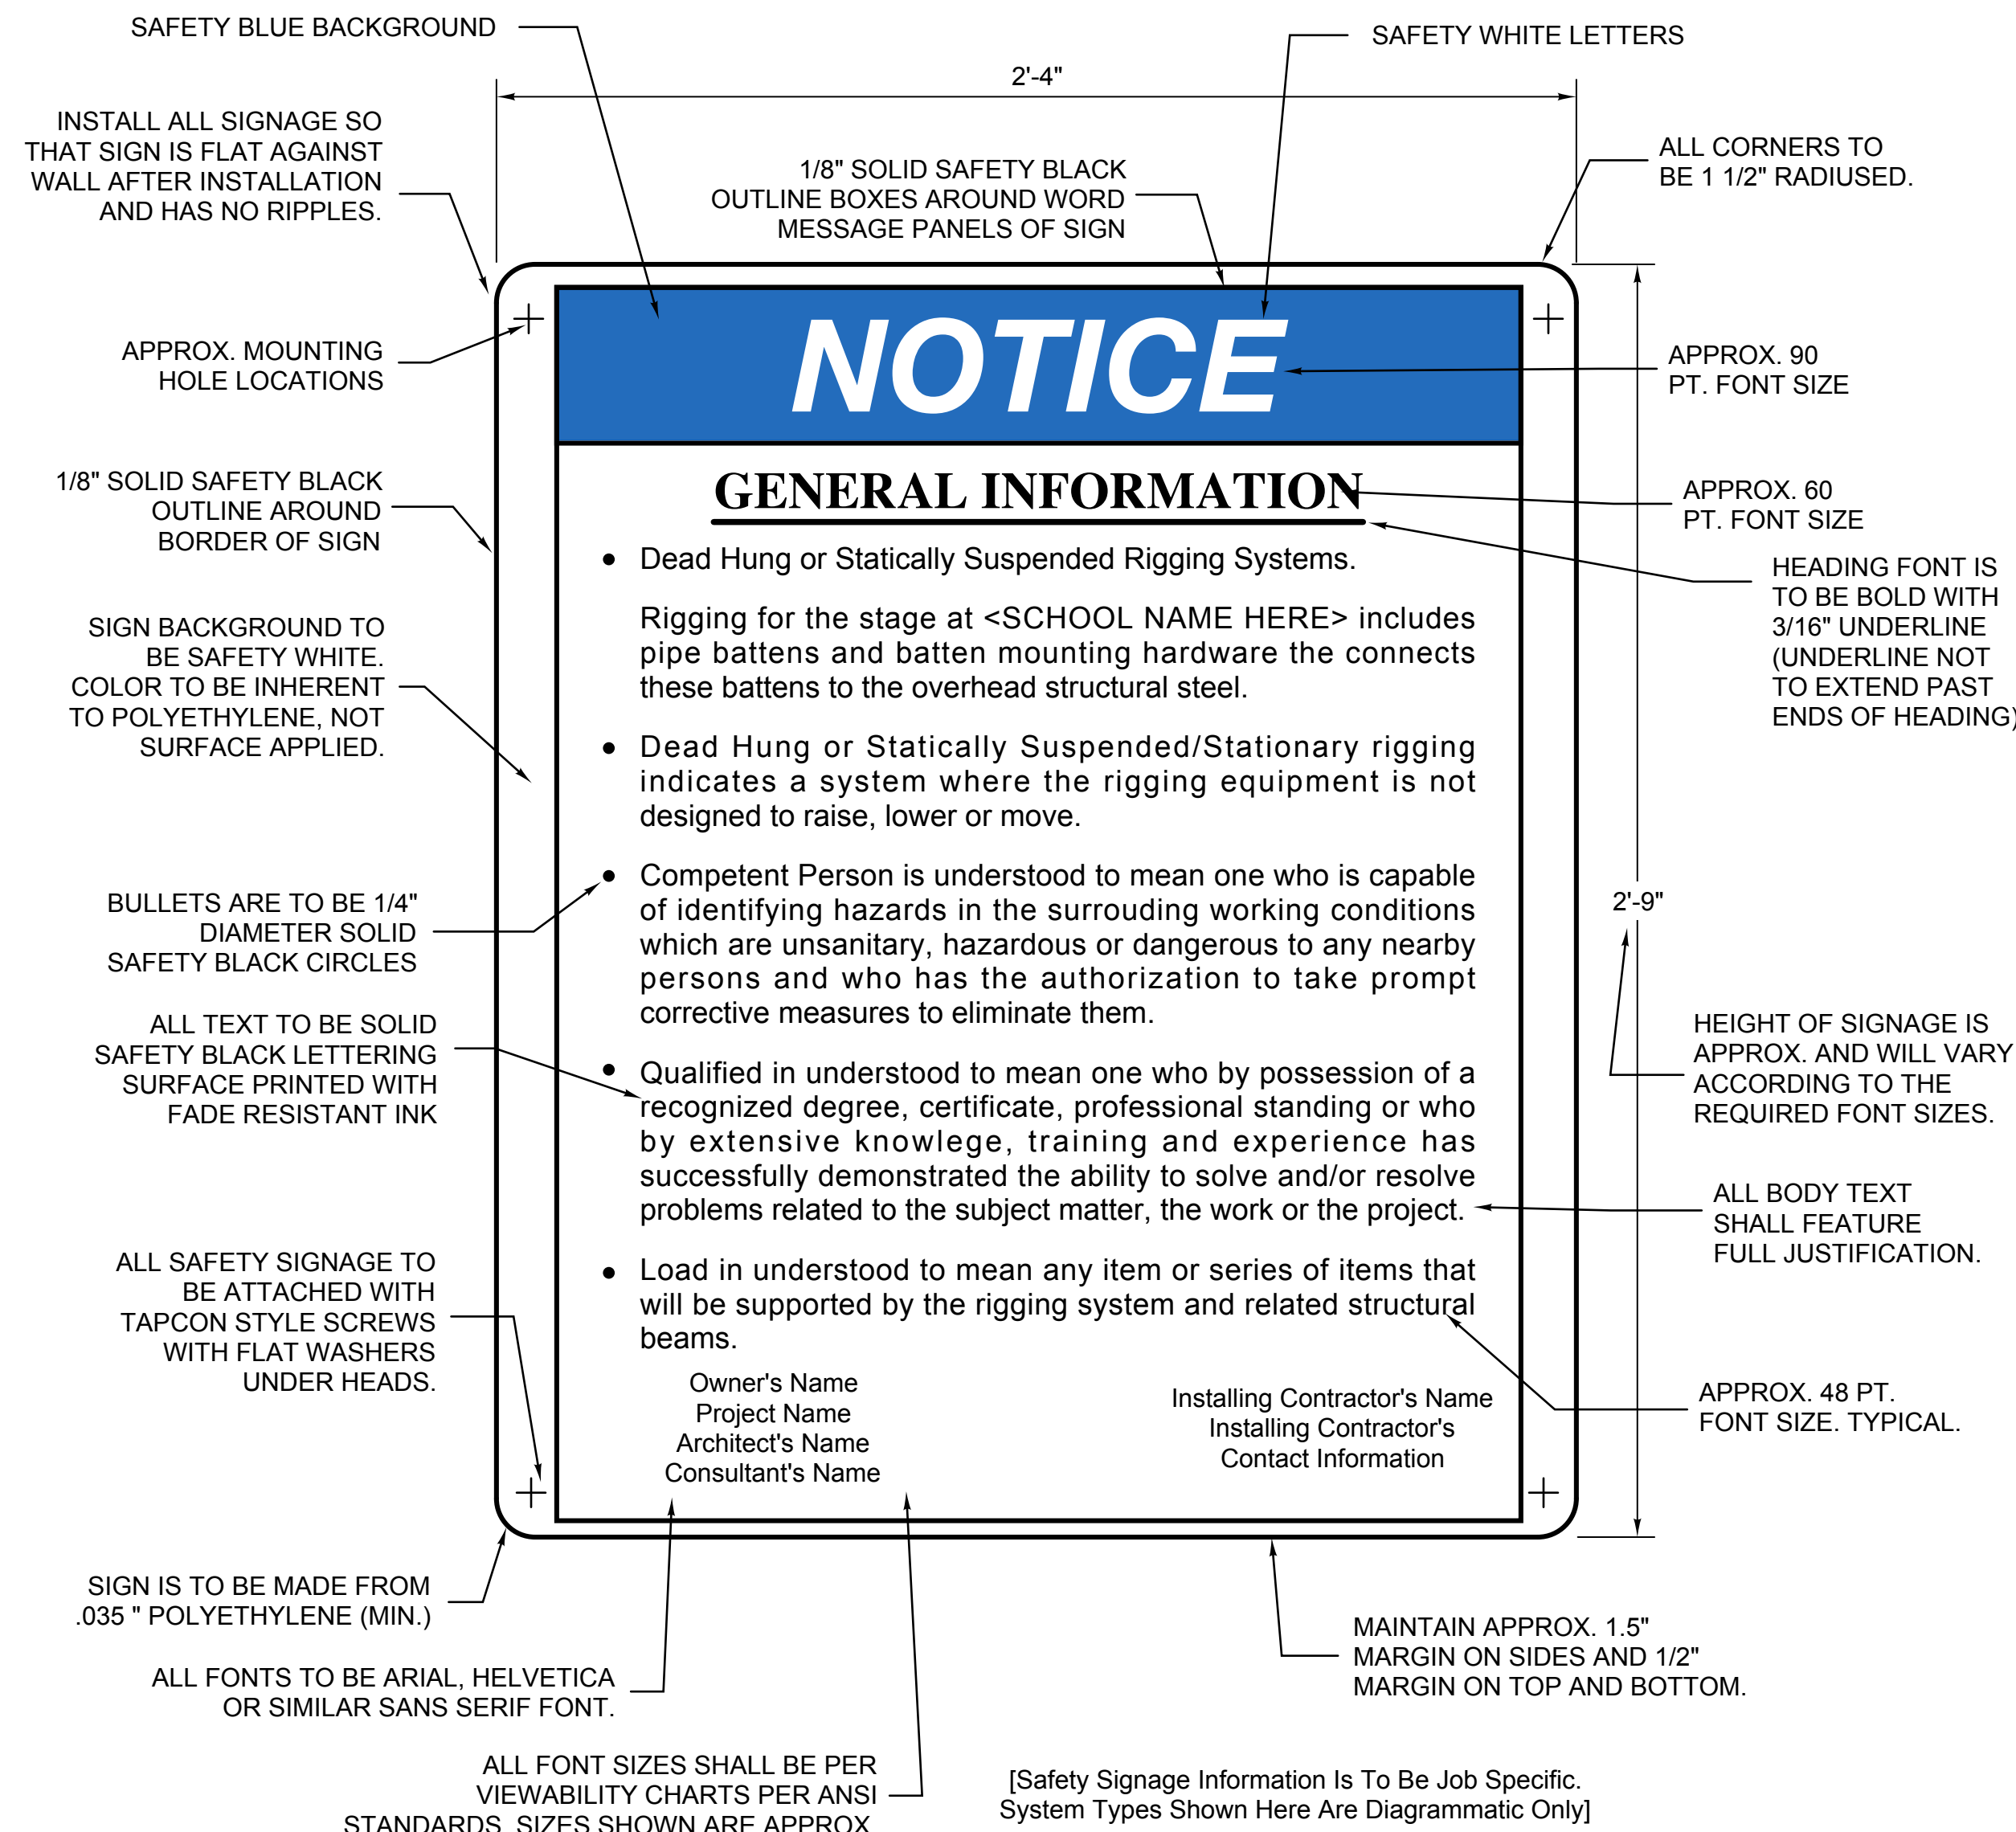

3 SAMPLE GENERAL INFORMATION SIGNAGE

SCALE: NONE

HUNT ENGINEERS | ARCHITECTS | SURVEYORS

HORSEHEADS, NY 807-468-1038 PROQUESTED, NY 585-837-7808 TOWNHOLM, PA 570-285-4668
BINGHAMTON, NY 807-798-5081 ALBANY, NY 807-798-5081
WWW.HUNT-EAS.COM

NY CERTIFICATE NO. 0010220 PA CERTIFICATE NO. TSC2208191464-1

THEATRICAL RIGGING DETAILS - AREA B

2025 ERWIN VALLEY ELEM & ADMIN BUILDING ALTERATIONS

CORNING-PAINTED POST AREA SCHOOL DISTRICT

16 BEARTOWN ROAD, PAINTED POST, NY 14870

EV-TR1.4

PROJECT NO: 2649-160

AD

DESIGN

CONSULTANTS

1000 WEST 10TH AVENUE, SUITE 1000
DENVER, CO 80202

DRAWN BY: SP

CHECKED BY: SP

DATE: 03/17/2026

PHASE: CD

DESCRIPTION OF REVISION:

DATE: 1 10/12/2026

ISSUE FOR BID

17 IS A VIOLATION OF THE LAW FOR ANY PERSON TO MAKE UNAUTHORIZED ALTERATIONS OR ADDITIONS TO PLANS
UNLESS A LICENSED ENGINEER, ARCHITECT OR SURVEYOR SHALL

Copyright 2025

CONTRACTOR SCOPE OF WORK (RELATED TO THE AV SYSTEM):

The Shall Perform All Work As Described Below And On Each TS Series Drawing. All Work Shall Conform To The Standards Of Division 26 Specifications And Spec Section 19 1000.

BOXES, CONDUIT & WIRE:

The contractor shall provide (provide means to furnish and install) all conduit, duplex or quad outlets and related faceplates, multiple device boxes, miscellaneous hardware and all installation labor to provide complete conduit layouts and control, line and load circuits/runs as indicated. All devices shown on the drawings are indicated in appropriate locations. The contractor coordinate the exact locations of all devices shown with the owner, existing obstructions and any other A/V related items that they may need to be located near or in conjunction with. The contractor shall determine all final locations prior to routing or installing any conduit or backboxes.

The contractor shall provide all wiring run in conduit. No conduit shall be allowed to be loaded beyond 50% fill.

The contractor shall terminate all conduits into racks, junction boxes, pull-boxes or other appropriate devices as indicated. No cut off conduits with end bushings and wiring dangling out the end shall be allowed.

The contractor shall refer to all AV related notes, drawing arrow notes and written specifications for work clarification and additional scope of work as it regards assembly, installation labor, labeling requirements and/or coordination with theatrical trades. Labeling requirements outlined in the written specifications are extensive and detailed.

Labeling (By Contractor): All conduits shall be clearly labeled on each end as to their origin and destination in a simple, logical manner. All junction boxes, switch boxes and backboxes indicated on drawings shall be labeled with the nomenclature indicated on the drawings. All outlet boxes shall be labeled with the corresponding panel and circuit designations they are fed from. Permanent black marker on conduit or junction box face is acceptable on conduits, junction boxes, etc. that will not be painted. If any related devices are to be painted, then the contractor shall provide the following: Conduits shall be labeled with 3M Durable ID Labels with permanent adhesive (applied after painting). Junction boxes, etc. shall be labeled with 3M Durable ID Labels with permanent adhesive (except stage devices, which shall be labeled with Lamscoil style engraved labels permanently adhered to the device). All junction boxes, outlets, etc. shall also be labeled by the contractor on the back of each cover plate and also with a durable tag inside each box stating the same information. All labeling shall be done with neat, simple, easily readable, block style lettering/numbering (labeling may be done by hand, if the labeler's handwriting is neat and legible. If not, then all labeling must be done by laser printing onto indicated labels). All labeling shall reference the device's designation, conduit originations/destinations, etc. & not be a coded, indexed or legend style referencing system. The contractor shall provide printed documentation to all related contractors as to the source, destination, elbows/sweeps, pull box locations, approx. run distances and routing of related conduits throughout building as part of normal coordination on the project. Labeling shall be done in neat, easily readable, block style letters/numbers. Locate internal labels to prevent damage/smudging, etc.

The contractor shall provide blank cover plates for any switch box or junction box that does not have a specific device plate indicated on the drawings symbols keys. All cover plates shall be provided in a color and style that matches other cover plates in the immediate vicinity of the indicated device or as determined by the owner. Cover plates shall be "form fitting" and shall not have sharp edges that protrude out past edges of backboxes.

All conduits are to be concealed unless specifically called out on drawings as exposed. Any visible conduits and boxes are to conform to general contract requirements and Division 26 for finish and installation requirements.

Back-to-back outlets in common walls shall not be permitted. All outlet boxes shall be separated by at least one stud bay/cavity.

Note - All circuits are required to have separate hot and neutral conductors. Provide ground wiring as required by applicable code. All circuits shall be calculated for full rated loads, constant duty non diversity unless otherwise specified. Size wire gauges and conduit sizing to allow for full load operation after taking into account all derating for distance, voltage drop and other conditions required by the most recent national electric code (NEC), the New York State building codes and local codes.

Where wire is indicated on the drawings, either in conduit or in walls, ceilings or chases, the contractor shall leave at least 3' excess wire at each end unless otherwise indicated on the drawing. Secure ends of all pulled wire to prevent accidental removal or damage during construction. Label all low voltage cables as to their origin and destination and tuck into back boxes to protect from damage. The contractor shall provide continuous pull strings (for future use) in all conduits even after all indicated wire is pulled in.

Where conduit is indicated with no wire called out on the plan drawings, the contractor shall provide the conduit empty. The contractor shall provide continuous pull strings in all empty conduits, tied off at both ends. Wire must be able to be pulled through the conduits without exceeding the pull spec of the wire to be pulled. Typical pulling tension for cables of this type is between 35 and 50 lbs. tension.

Wiring Standards - Plenum Rated Cable: Unless specifically noted on the drawings, all low voltage wiring is to be CL2/CL3 wiring. Where specific plenum conduits exist its has been noted to use a plenum rated cable. Where wiring runs occur in concealed spaces - walls, ceilings, etc. - and are not enclosed in conduit the contractor must verify the space is not being used as a plenum path. Any areas encountered that are plenums must have plenum cable or the wiring must be contained in conduit rated for the plenum application. Field verify conditions prior to ordering or installing cableing.

In some areas wiring may be called out as CL3 not in conduit. In these areas the EC must provide adequate attachment and support to protect the cable from potential damage using the best routing. Wiring may not be left lying loose in any area unless fully protected (i.e. inside a wall).

The contractor shall radius all conduits where possible. Conduit runs are not to exceed 270 degrees of radius bend. Where elbows and pull boxes are unavoidable, locate these in easily accessible locations not requiring special equipment to reach. Any elbows used must be sweeps and must be accessible without the use of special equipment. If more than 270 degrees of bend is required, the contractor shall provide accessible pull boxes.

The contractor shall provide all power circuits indicated on TL, TR, and TS drawings and associated conduit, backboxes, wire, termination and duplex outlets. Termination of these outlets will be to panel boards as indicated on E-series drawings. These outlets may also be indicated on E series drawings. Check TS and E drawings and verify there is no duplication of devices. Some outlets are to be installed in racks - coordinate with the contractor for exact locations within each rack.

The contractor is responsible for fire stopping all penetrations in new and existing fire rated assemblies resulting from the work of his contract.

CONTROLS/PLATES:

The contractor shall provide all cover plates for back boxes or switch boxes as indicated on the drawings.

CONTRACTOR POWER SYSTEM DRAWING NOTES:

Each note indicates a typical location for the type of work to be performed or equipment to be provided. The contractor shall provide for all instances of typical work indicated. All drawing notes may not appear or be referenced on each drawing; however, all notes still apply to the work indicated within each note and shall be performed by the referenced contractor(s).

Failure by the contractor to adhere to any of the specific notes on these drawings shall result in the contractor repairing, replacing or reinstalling extensive system components, conduit, wire or related items at his own expense and at no additional cost to the owner in order to bring the installation up to the standards and intents set forth in these contract documents.

Branch circuits indicated are for the dedicated use of the specified system: Audio, video, theatrical lighting or rigging. No other connections may be made or branches added to these circuits. Each circuit must have a separate hot, neutral, and ground conductor. Conduit grounds are not acceptable for these circuits. All wire to be THHN Stranded with Gauge, as required by NEC. All grounds to be #12 minimum THHN Stranded copper. Where ISO ground panels are provided the THHN ground wire will be utilized for ISO ground. Building ground to switch boxes on ISO ground circuits as required by NEC.

Neutrals and grounds may not be shared with any other circuits.

The branch circuits indicated are to be installed as indicated. The EC shall coordinate with the appropriate contractor where connections are to be made within racks and equipment furnished by others to provide well timed construction progress.

See E series drawings for panel designations and origination. Do not duplicate circuits.

All indicated circuits shall be individual, independent, home-run circuits to a panel/breaker box as indicated on the E series drawings (unless otherwise noted or indicated as being paralleled with another). Provide circuits in voltage, wattage, phase and amperage and land/terminate each circuit into a backbox or other device as indicated.

If a circuit designated does not appear on the E series panel schedules, the EC shall still be responsible for providing the circuit to a panel designated by the electrical engineer for the project. Typically this panel will be within 150 feet of the branch circuit location.

The contractor shall provide all backboxes in sizes as indicated. No multi-gang backboxes with raised, tile ring, extension ring or mud ring style reducers to obtain the specified faceplate gang size shall be acceptable in lieu of the indicated device backbox. Any multi-gang devices with these extension rings used shall be replaced and the specified backbox sizes provided by the contractor at no additional cost to the owner. The contractor shall install all backboxes flush, plumb and level.

The contractor shall provide all surface mounted outlet boxes as full-sized backboxes so that the cover/face plates do not protrude beyond the box edges. All outlet boxes to be Thomas & Betts AFS style boxes or equivalent size. Any boxes that are smaller than the cover/face plate will not be accepted. The intent is for faceplate to be the same size as the backbox in order to prevent sharp or protruding edges that could catch or snag clothing, etc. or cause injury.

AUDITORIUM SYMBOLS KEY

Device	Description	Box Size	Mounting
XX*	Indicates conduit size and/or wire runs		
XX	Home-run to device		
TS501	Audio Racks 19" EIA - for Specific Rack Information See TS501		
Ø	Power - Duplex Outlet- 20A-120VAC	1 Gang	Mount At Standard Electrical Outlet Height, In Racks Or As Indicated
IO	Plate with (4) Neutrik XLR-F and (2) Neutrik XLR-M Connectors	3 Gang	Flush Mount At Standard Electrical Outlet Height, Or As Indicated
WF-X	Whirlwind Wallframe WF-12x12x2.5 With Custom Insert Plate. See TS401 For Details.	12x12x4	Flush Mount In Face Of The Stage As Indicated
TP	Creston TSW-1070-B With TSW-UMB-70	Creston TSW-UMB-70-BB	Flush Mounted At Standard Switch Height Or As Indicated
IC	Telex Audiocon WP-2	1 Gang	Flush Mounted At Standard Switch Height Or As Indicated
NR	Plate with (6) Neutrik Ethercon Connectors	3 Gang	Flush Mount At Standard Electrical Outlet Height
S	Plate with Grommet For Speaker Cable Exit	1 Gang	Flush Mount In Ceiling Or As Indicated
JM	Hanging Mic Box - (4) Channel Whirlwind BBNLS Series		Mount To Pipe Battens As Indicated. See TS501 For More Information
JB	6x6x4 Screw Cover Style Box		Surface Mount To Structural Steel, Or As Indicated
AJB	Audio Junction Box - 12x12x4		Flush Mount At Standard Electrical Outlet Height, Or As Indicated
LVC	Da-Lite External Low Voltage Controller	By Factory	Surface Mount To Structural Steel, Or As Indicated
DMR	Creston MP-WP181-C-B With Decora Plate	1 Gang	Flush Mount As Indicated

Note: All References To "Standard Electrical Outlet Height" And "Standard Switch Height" Are Intended For The Installing Contractor To Mount These Devices To Match These Mounting Heights With Any Existing Or Adjacent Devices On Site In The Auditorium.

All Device Backboxes Shall Be Flush Mounted Unless Otherwise Noted On The Drawings. If Building Construction Makes Flush Mounting Impossible Or Impractical, Then The EC Shall Obtain Written Permission & Instructions From The Architect (Including Specific Device Types, Conduit/Wirement Types, Required Painting, Sizes, Profiles, Etc.) Prior To Installing Any Surface Mounted Devices (This Is Excepting Devices Such As GJB's, JB's, Pull Boxes, Etc. Mounted To Stage Or Other Overhead Steel).

Where Boxes Are Indicated As Surface Mounted, Wiremold Style Boxes Shall Be Utilized, Painted To Match Mounting Surface Or As Directed By Architect.

All Catwalk Mounted Backboxes Below 7' - 0" AFF Shall Be Thomas & Betts AFS Style Boxes Or Equal. The Intent Is For All Catwalk/Gallery Backboxes To Physically Match The Faceplate Dimensions.

All Backboxes Shall Be 3.5" Deep With Internal Square Edges. No Backboxes With Rounded Or Radiused Corners Shall Be Acceptable. Where Mounting Brackets Are Required, The EC Shall Provide Appropriate Brackets As Needed To Mount To Studs, Wall, Etc. No Contractor Fabricated Mounting Systems Shall Be Acceptable. The EC Shall Read All Drawing Notes For More Information On Backbox Styles, Types, Etc. Required.

The TC Shall Provide The Owner With Actual Sized Paper Template Copies Of Station Faceplates That Are Part Of This Project, Which The Owner Shall Then Tape On The Walls In The Final Desired Locations For All Architectural Control Stations. The EC Shall Not Install Any Related Conduit Or Backboxes Until Final Locations Have Been Determined By The Owner. No Stations Shall Be Allowed To Exist In Areas Or Locations Where They Conflict With Other Devices, Are Buried Behind Other Devices, Block Access To Life-Safety Devices, Are Tucked Into Inaccessible Corners Or Are Otherwise In Impractical, Out-Of-The-Way Locations.

Standard Outlet Height Typically Is 48" To The Top Of Box.

Standard Outlet Height Is Typically 20" To Top Of Box.

Where Existing Switches Or Outlets Are Located In The Vicinity Of New And Are Mounted At Different Heights, Verify Design Height With The Owner/Owner's Representative Prior To Rough In.

Where An Existing Back Box And Conduit Patch Can Be Reused, Verify With The Owner/Owner's Representative Before Reusing The Location.

NOTE:

It is each contractor's responsibility to receive all device shipments, equipment, deliveries, etc. for their own equipment on/at the job site personally. This will require each contractor to carefully coordinate drop-ship delivery dates with the manufacturers and trucking companies in order to have adequate personnel on site to inspect, unload and store all shipments. Each contractor shall be responsible to arrange for storage of all received materials on site until the appropriate time when he shall either turn them over to installing contractor or install them himself.

If the contractor chooses to allow a third party to receive shipments on his behalf, then that contractor bears sole responsibility for any missing and/or damaged parts and devices that may need to be reordered or rush freight required to maintain schedule, all at no additional cost to the owner.

Any equipment that is furnished by the receiving contractor but installed by others shall be turned over to the installing contractor at such time as it fits into their production schedule and the project's overall construction schedule.

Any large items such as racks, emergency transfer equipment, etc. shall be transported by the receiving contractor from its storage area and relocated to the general vicinity (i.e. in the room and general area) where it will be installed. At this point in time it shall be turned over to the installing contractor for installation.

All Work Indicated In Written Specifications Section 19 10 00 "Theatrical AV Systems" As Well As All Work Indicated On The TS Series Drawings Is Critical In Nature And Cannot Move To Accommodate Adjacent Trades And Related Equipment. This Includes, But Is Not Limited To, HVAC, Plumbing, Architectural, Structural, Electrical, Life Safety And Interiors Equipment And Related Wiring And Conduits And Other Appearances. Design Tolerances For The Rigging System Are Too Precise To Allow Deviation From Ideal Locations. Therefore, It Is The Sole Responsibility Of All Other Trades To Be Familiar With The Work In Section 19 10 00 And On The TS Series Drawings And To Locate All Other Devices Clear Of It. Coordinate With The Theatrical Contractor In Instances Of Potential Conflict. Where Conflicts Do Occur, The Work Of All Other Trades Shall Move To Accommodate The Theatrical Contractor In The TR Series Drawings At No Additional Cost To The Owner.

GENERAL NOTES:

Do not scale plans.

Field verify all dimensions before ordering material or performing any work. Location of all devices must be coordinated with existing and/or new architectural, mechanical, electrical and structural elements. Where conflicts occur contact the architect, construction manager and consultant in writing for clarification before performing any work. If the contractor chooses to proceed without clarification they do so at their own risk. Any work done by the contractor without clarification will be redone at no cost to the owner at the request of the architect, owner, construction manager or consultant.

Where work is provided by others (i.e. conduit, backboxes, rack installations, etc.), the specialties contractor (audio, A/V, lighting or rigging) is responsible to verify installation conditions that relate to his work. If installation of related work is substandard, deficient or missing items (this includes crooked backboxes in architecturally sensitive areas, missing pull boxes, incorrect conduit sizes, items that deviate from contract documents, etc.) then the specialties contractor shall stop his work and generate a written RFI through proper channels based upon construction documents. The specialties contractor shall not install his work to any substandard devices, etc. provided by others until such work has been repaired/returned to a satisfactory condition and until he has received written authorization from the construction manager to proceed. If the specialties contractor ignores substandard installation work by others and proceeds to install his devices to these items, then he accepts and bears sole responsibility to repair, reinstall and correct any found deficiencies to the satisfaction of the owner upon final inspections.

Where work is critically dimensioned to work provided by others it is the sole responsibility of the contractor to verify the intended location of other elements with other contractors by reviewing their shop drawings.




Coordinate all work for symmetrical installation with relation to height and level with architectural elements, switches, outlets, and other controls.

This drawing represents the configuration of a system. It does not in any way constitute instructions for installation except with regards to configuration. The sole responsibility for field verification of dimensions, installation/fabrication methods, code conformance, safety issues, and the quality and performance of their work shall be that of the installing contractor.


This drawing is to be interpreted in conjunction with other drawings in the construction set as well as written specifications for this project. The contents of the drawing do not in any way negate the written specifications, nor do the written specifications in any way negate the contents of the drawings.

If there are inconsistencies between written specifications and drawings or between any drawing and other drawings in the construction document set it is the responsibility of the contractor to obtain clarification before bidding this project. If no clarification has been obtained prior to bid the contractor will abide by the decision of the architect and consultant at no additional cost to the owner even if work has to be redone.


Obtain shop drawings from related trades to verify the intended configurations and scheduling of their work. The contractor is responsible for coordinating their work with other related trades in a manner that avoids conflicts of work and scheduling.

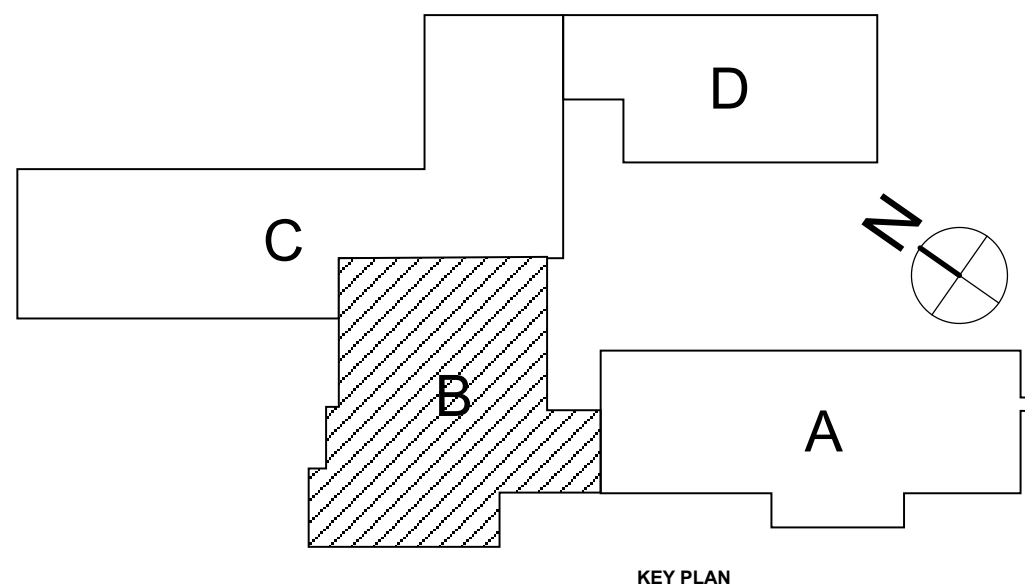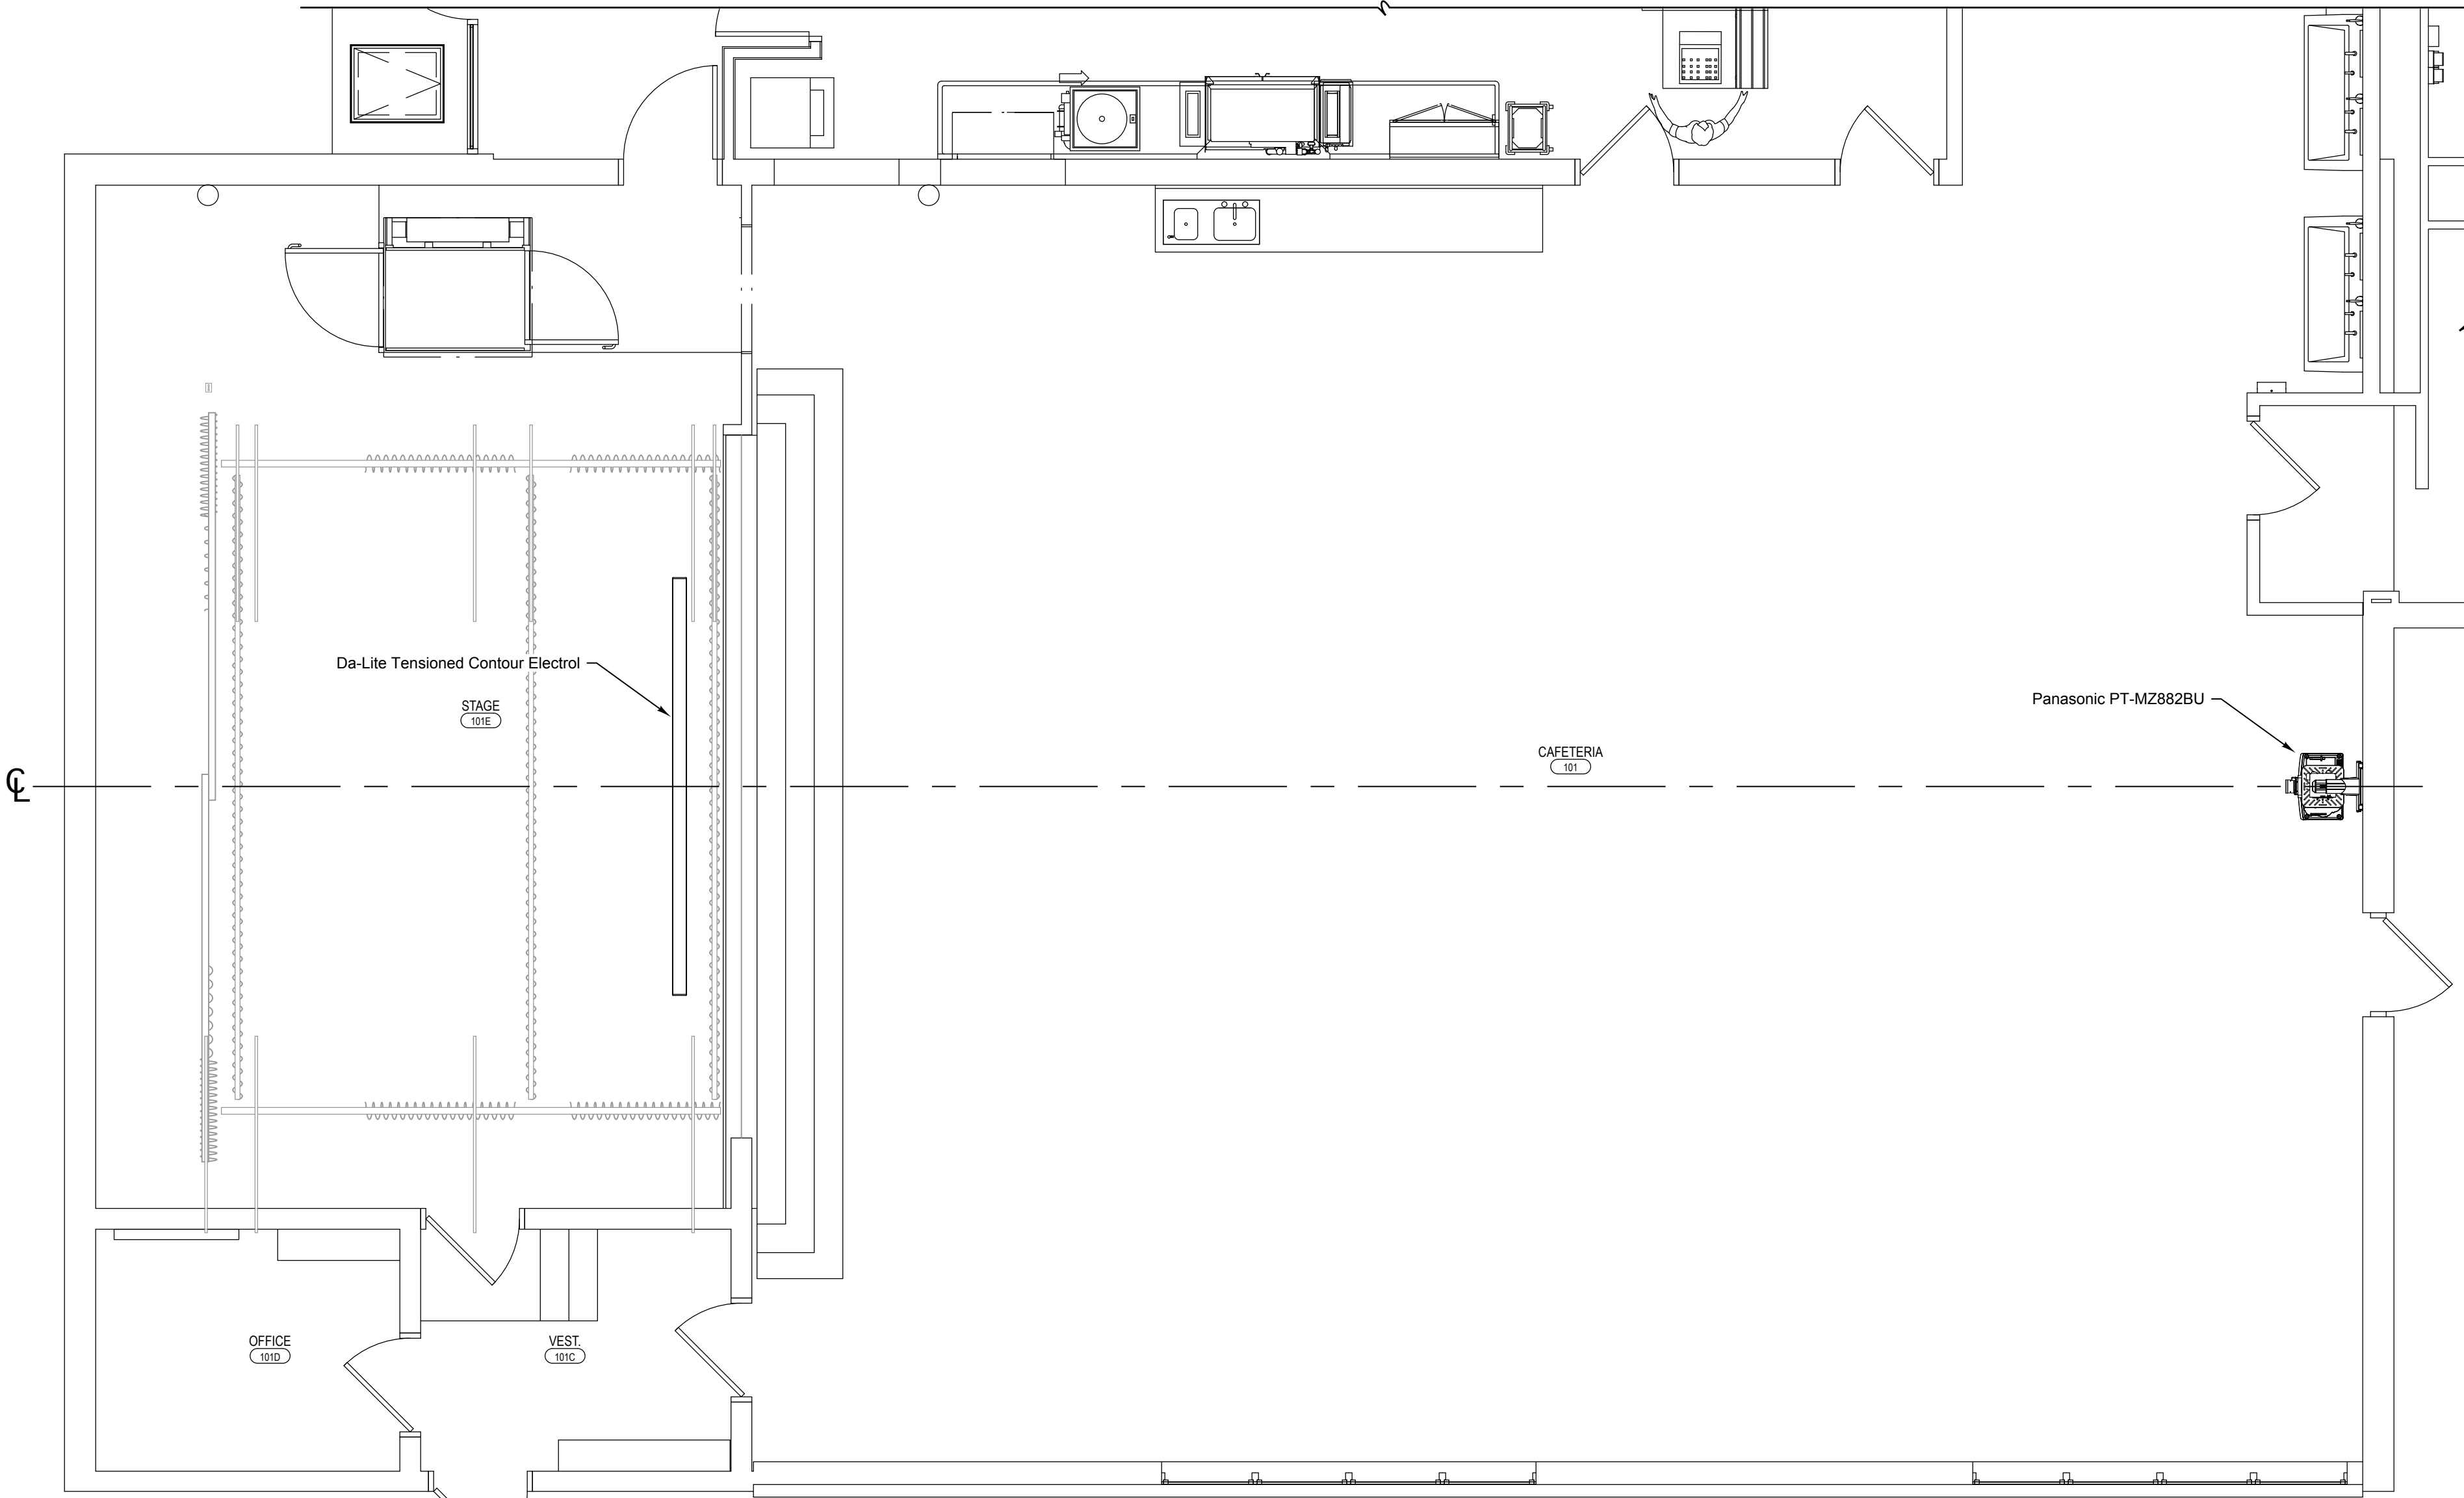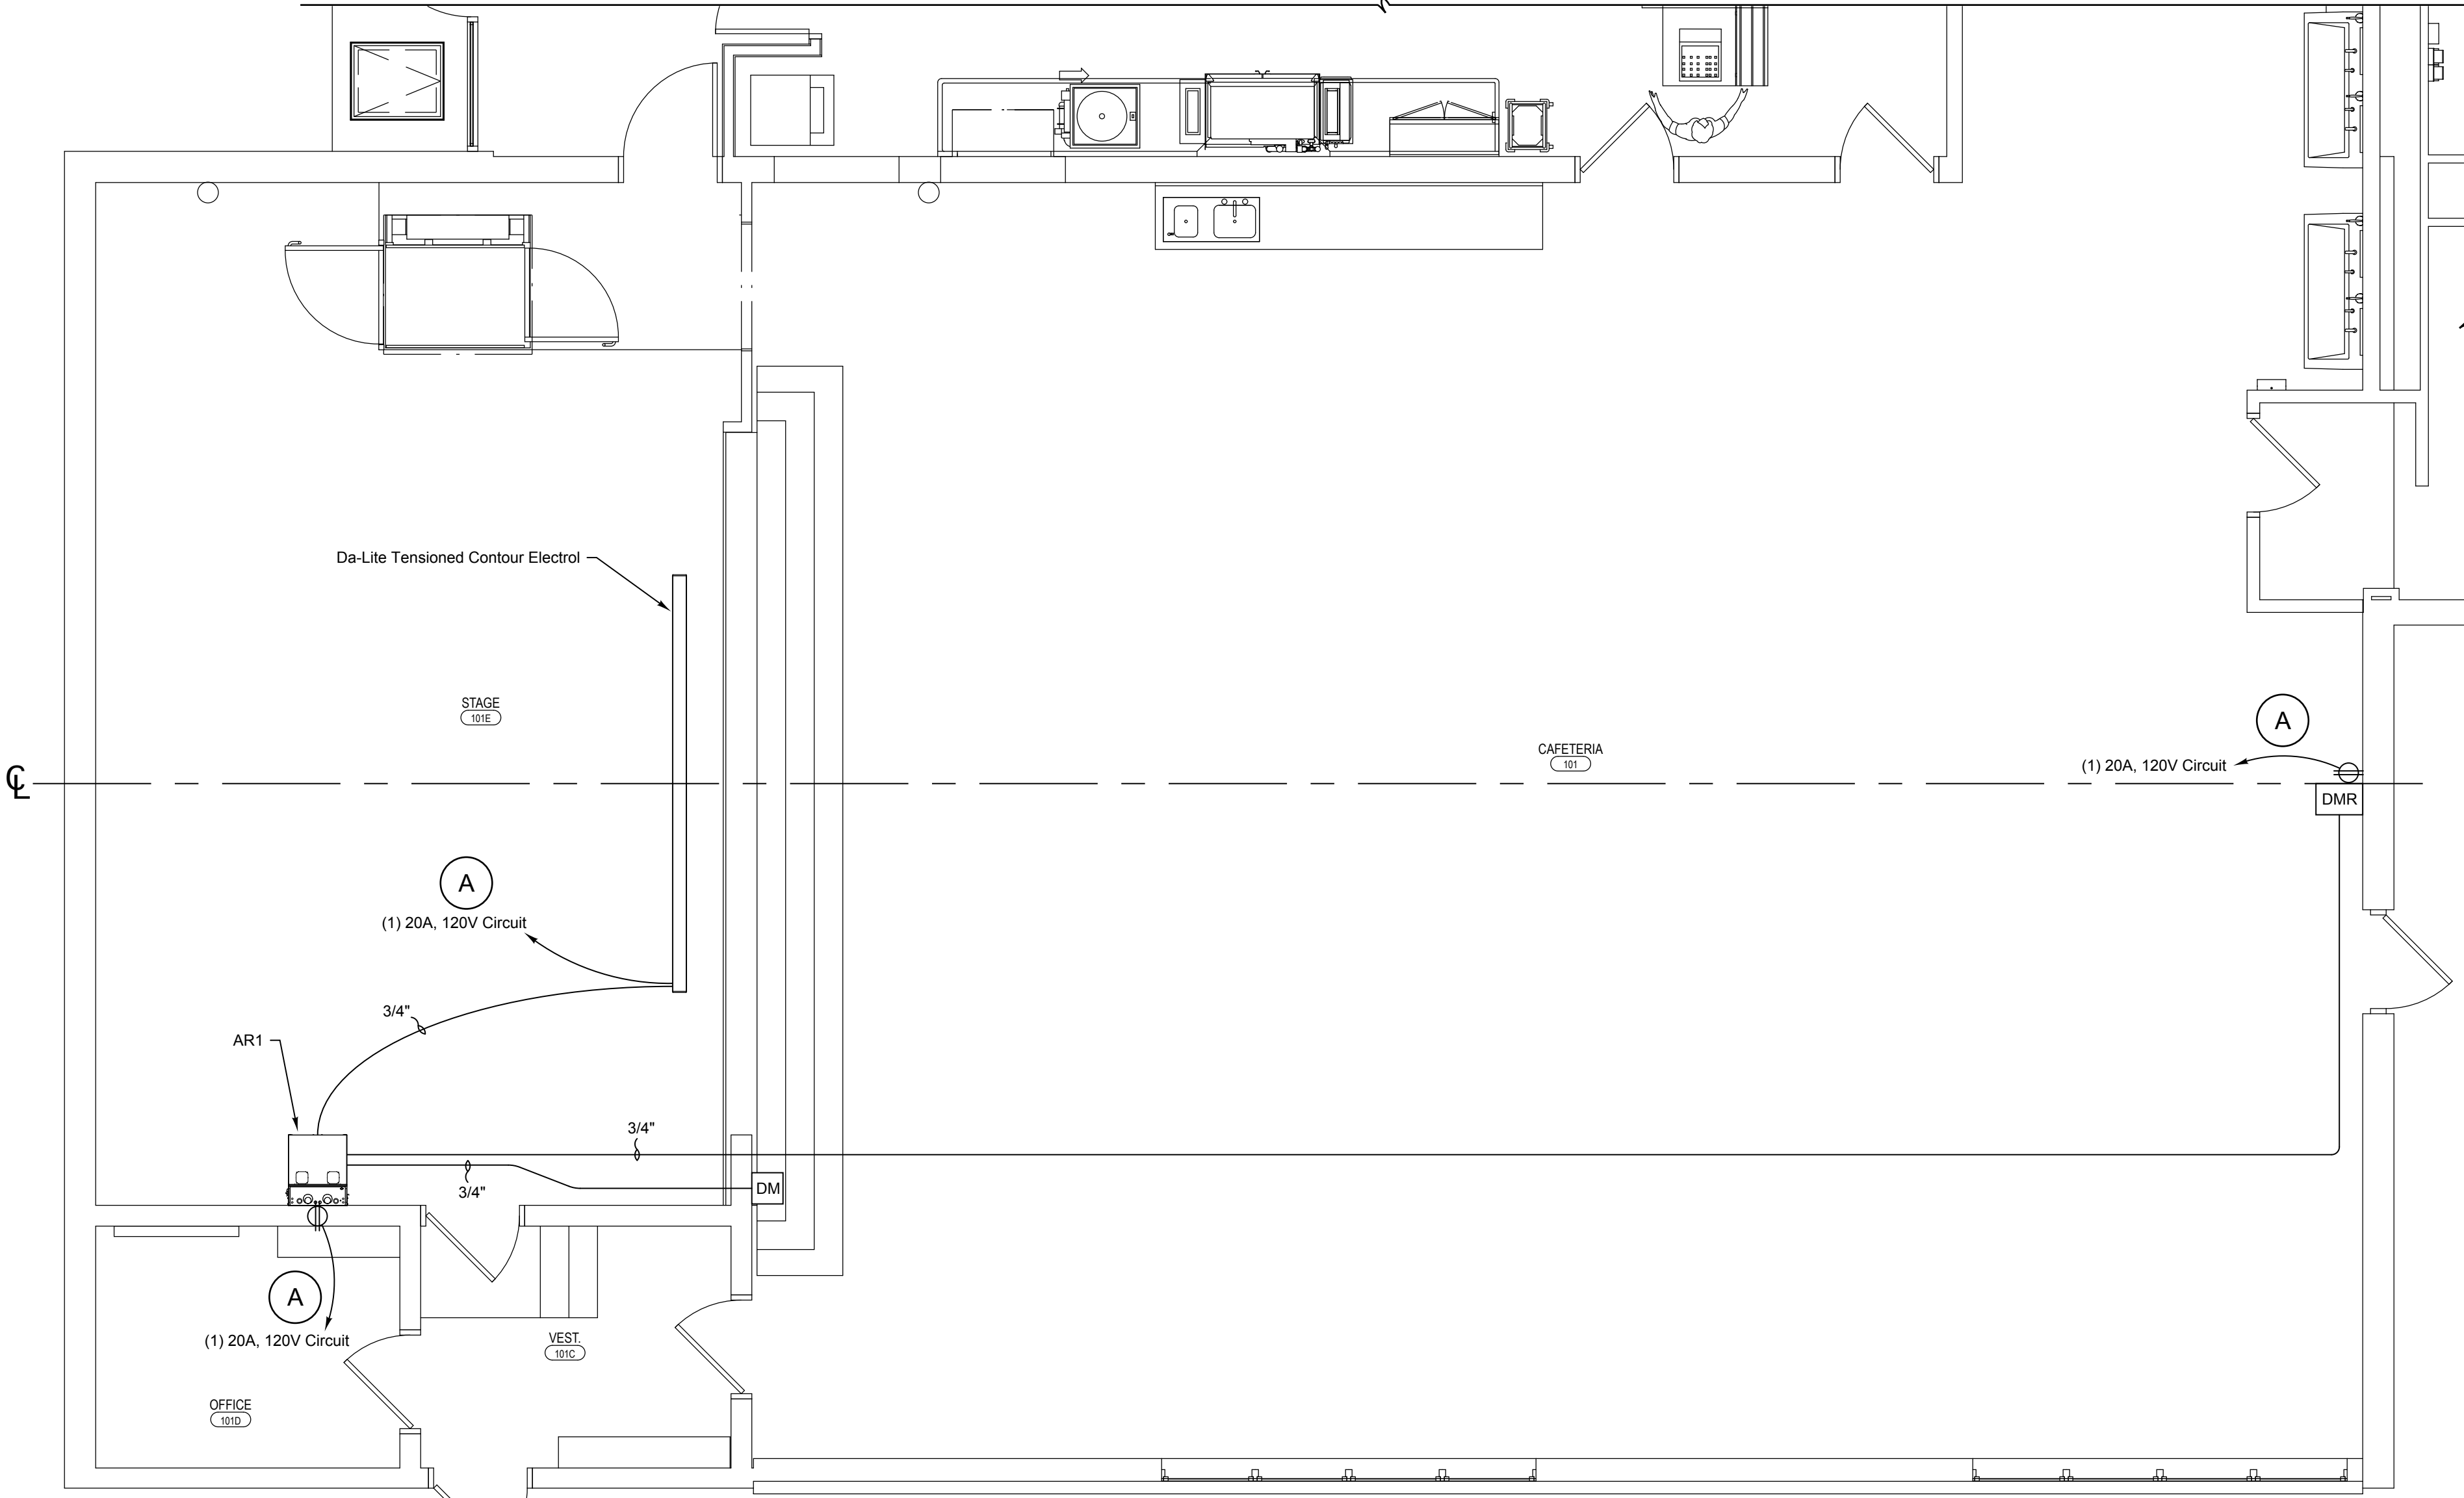


2 AV SYSTEM PLAN
SCALE: 1/4" = 1'-0"

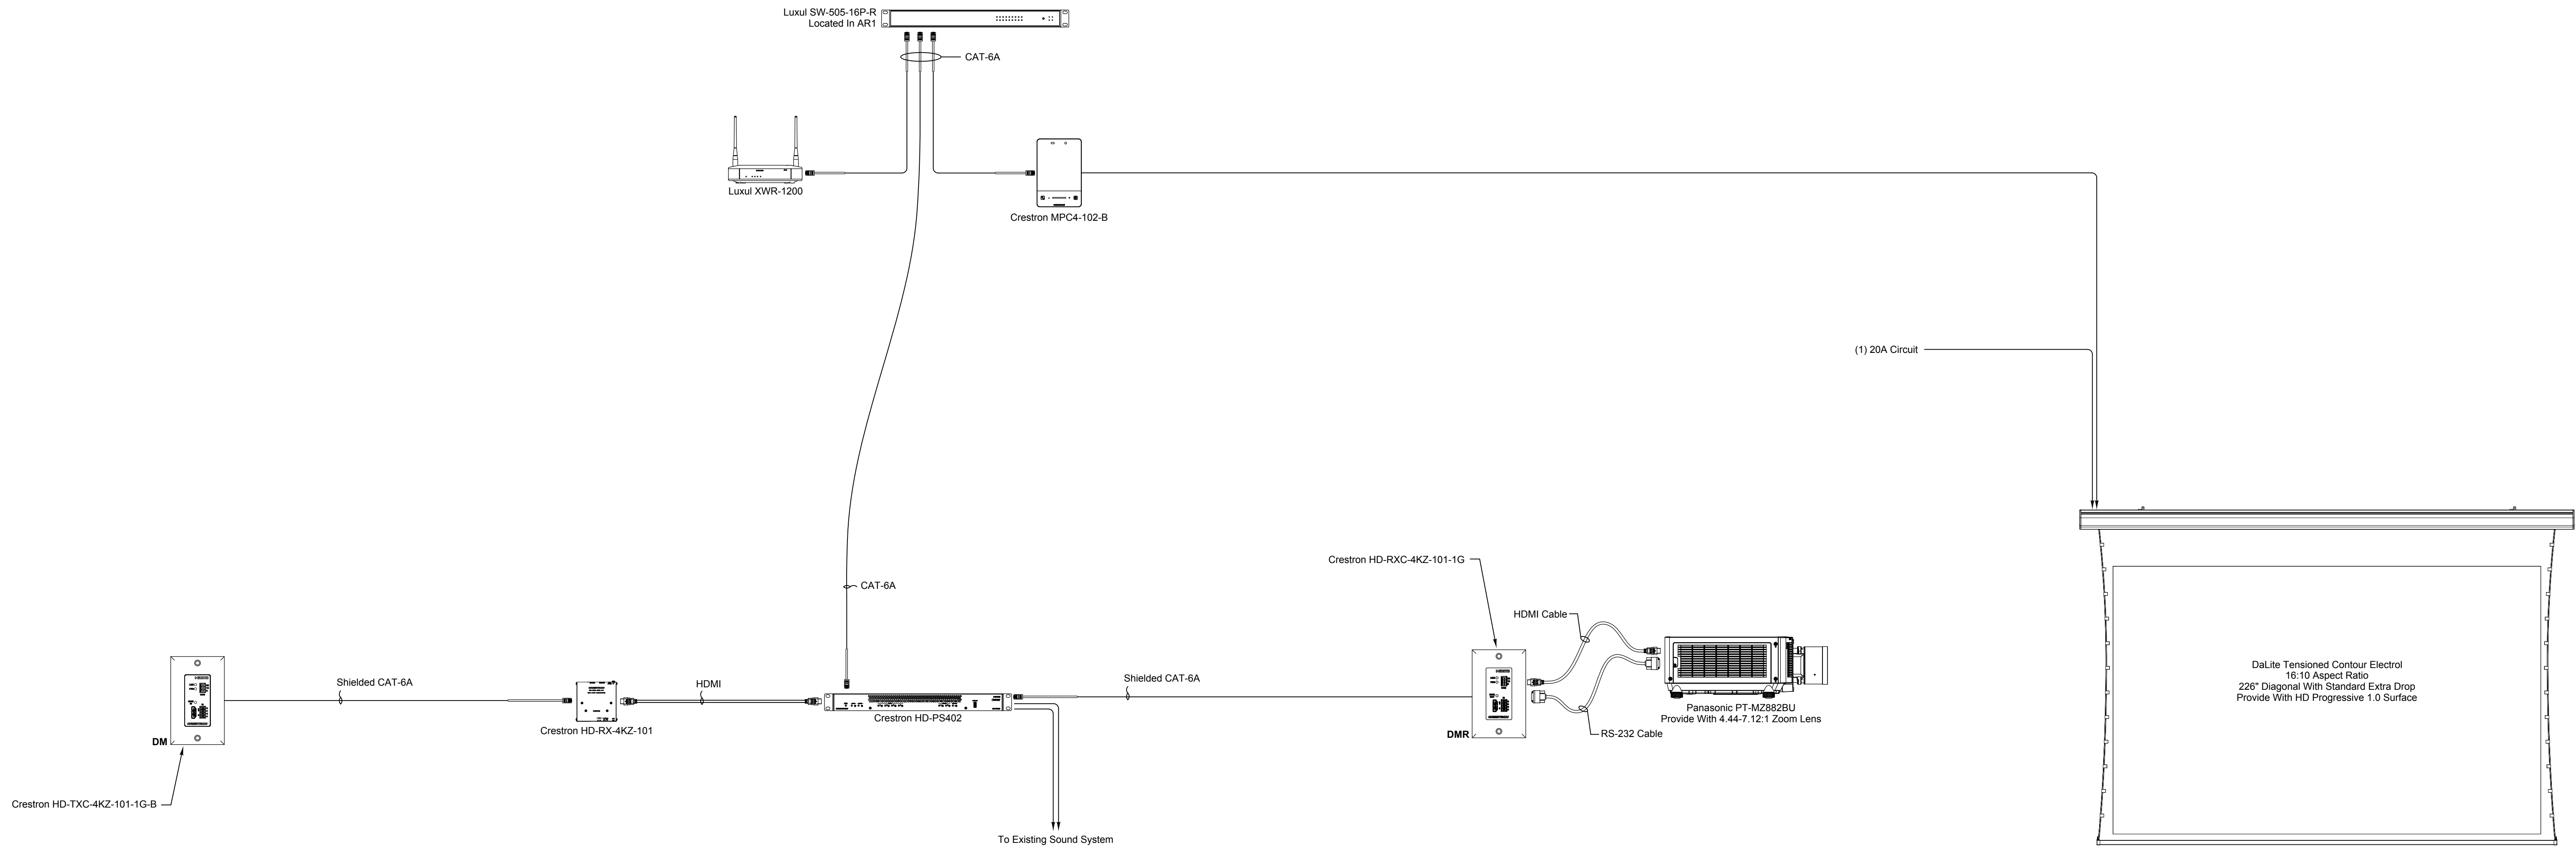

1 AV SYSTEM SINGLE LINE FLOW DIAGRAM
SCALE: NONE

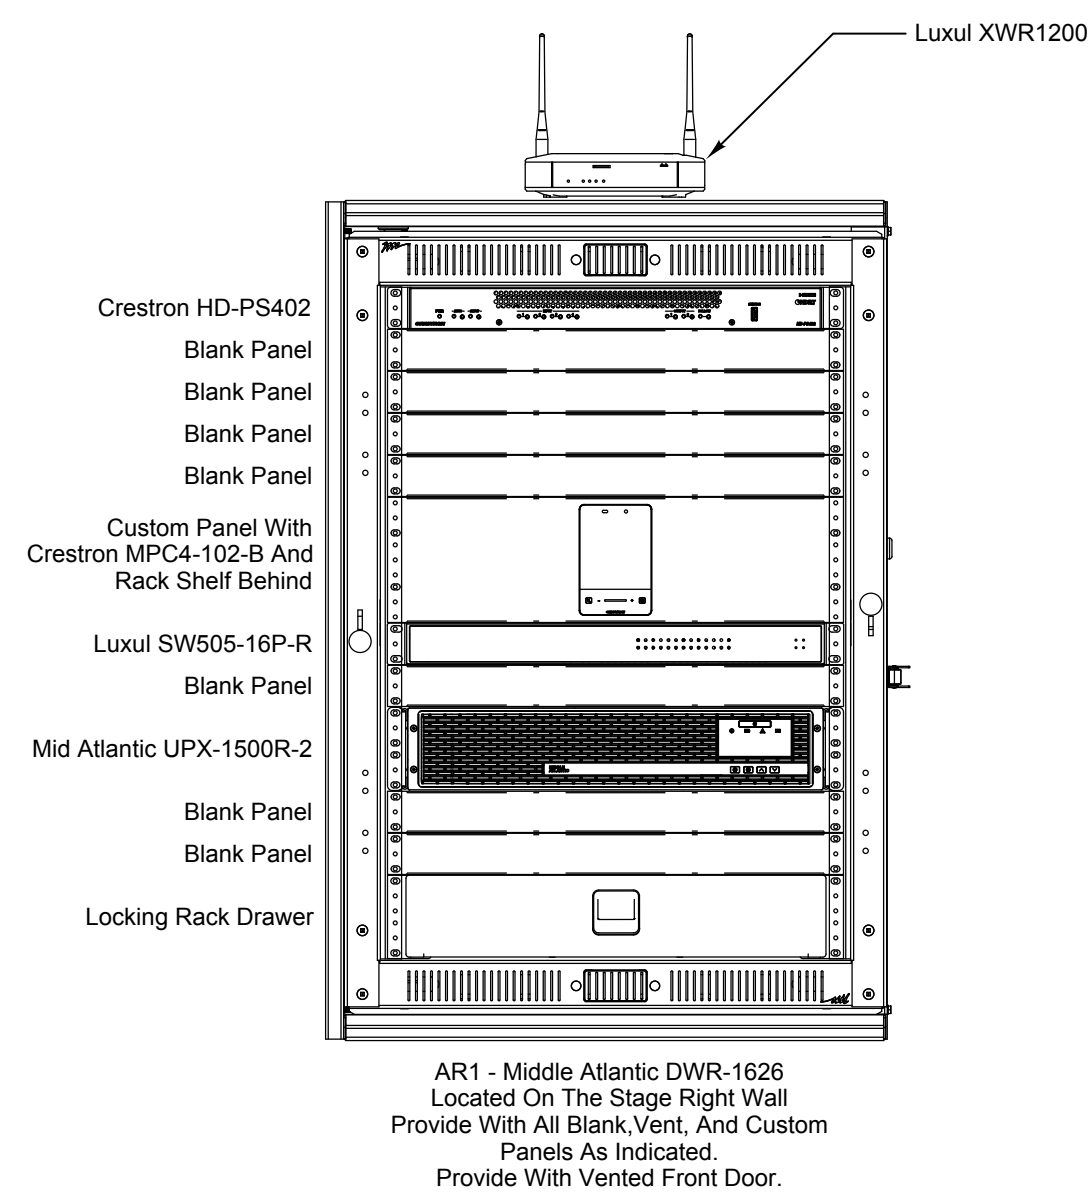

2 AV SYSTEM SINGLE LINE FLOW DIAGRAM
SCALE: 3/16" = 1'-0"

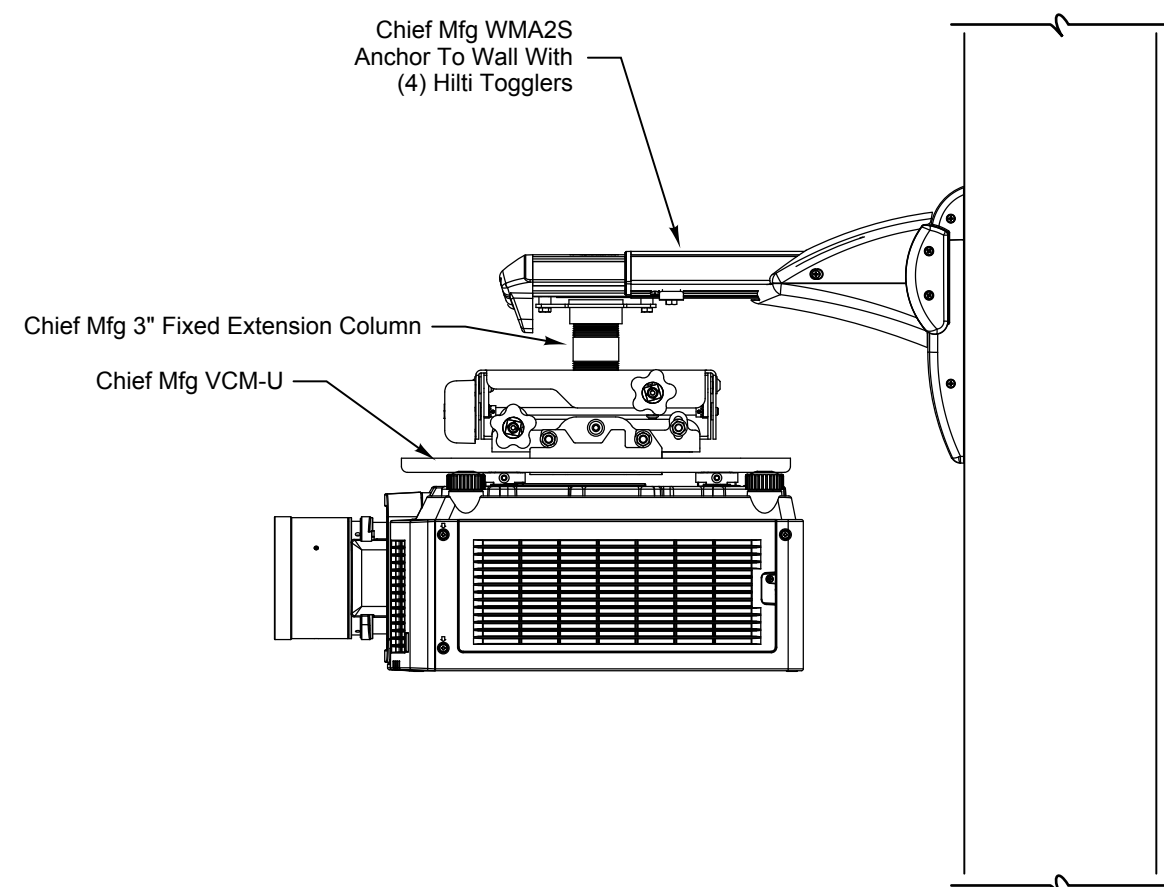

3 VIDEO PROJECTOR MOUNTING DETAIL
SCALE: 1-1/2" = 1'



DRAWN BY:		GWN
CHECKED BY:		GWN
DATE:		03/17/2026
PHASE:		CD
DESCRIPTION OF REVISION:		
#	DATE:	
1	10/12/2026	ISSUE FOR BID
IT IS A VIOLATION OF THE LAW FOR ANY PERSON TO MAKE UNAUTHORIZED ALTERATIONS OR ADDITIONS TO PLANS BEARING A LICENSED ENGINEER, ARCHITECT'S OR SURVEYOR'S SEAL.*		


HUNT ENGINEERS | ARCHITECTS | SURVEYORS
HORSEHEADS, NY 607-568-1038
ROCHESTER, NY 585-637-7806
BINGHAMTON, NY 607-798-8081
ALBANY, NY 607-798-8081
TOWNHALL, PA 570-285-4668
WWW.HUNTEAS.COM
NY CERTIFICATE NO. 001620 PA CERTIFICATE NO. TSC2208191464-1

CAFETORIUM AV SYSTEM SINGLE LINE DIAGRAM & DETAILS - AREA B
2025 ERWIN VALLEY ELEM & ADMIN BUILDING ALTERATIONS
CORNING-PAINTED POST AREA SCHOOL DISTRICT
16 BEARTOWN ROAD, PAINTED POST, NY 14870


EV-TS2.1
PROJECT NO: 2649-160

FOODSERVICE EQUIPMENT SCHEDULE

ITEM	QUANT.	DESCRIPTION
1	1	COLD FOOD COUNTER
2	1	DISPLAY CASE
3	1	HOT FOOD COUNTER - EXISTING/MODIFY
4	1	SERVE/SELF-SERVE PROTECTOR GUARD
5	1	COLD FOOD COUNTER - EXISTING/MODIFY
6	1	DISPLY CASE
7	1	CASHIER COUNTER - EXISTING/TO REMAIN
8	1	SERVING EQUIPMENT - EXISTING/TO REMAIN
9	1	EXISTING EQUIPMENT/TO REMAIN PLACE
10	1	SOILED DISHTABLE - EXISTING/MODIFY
11	1	PRE-RINSE FAUCET
12	1	POT/PAN SINK
13	3	STORAGE SHELVING
14	1	PREP SINK WORKTABLE - EXISTING/MODIFY
15	1	TWO TIER SHELVING - MOUNTED TO PREP SINK WORKTABLE
16	1	WASHER/DRYER STACKED UNIT - EXISTING/RELOCATE

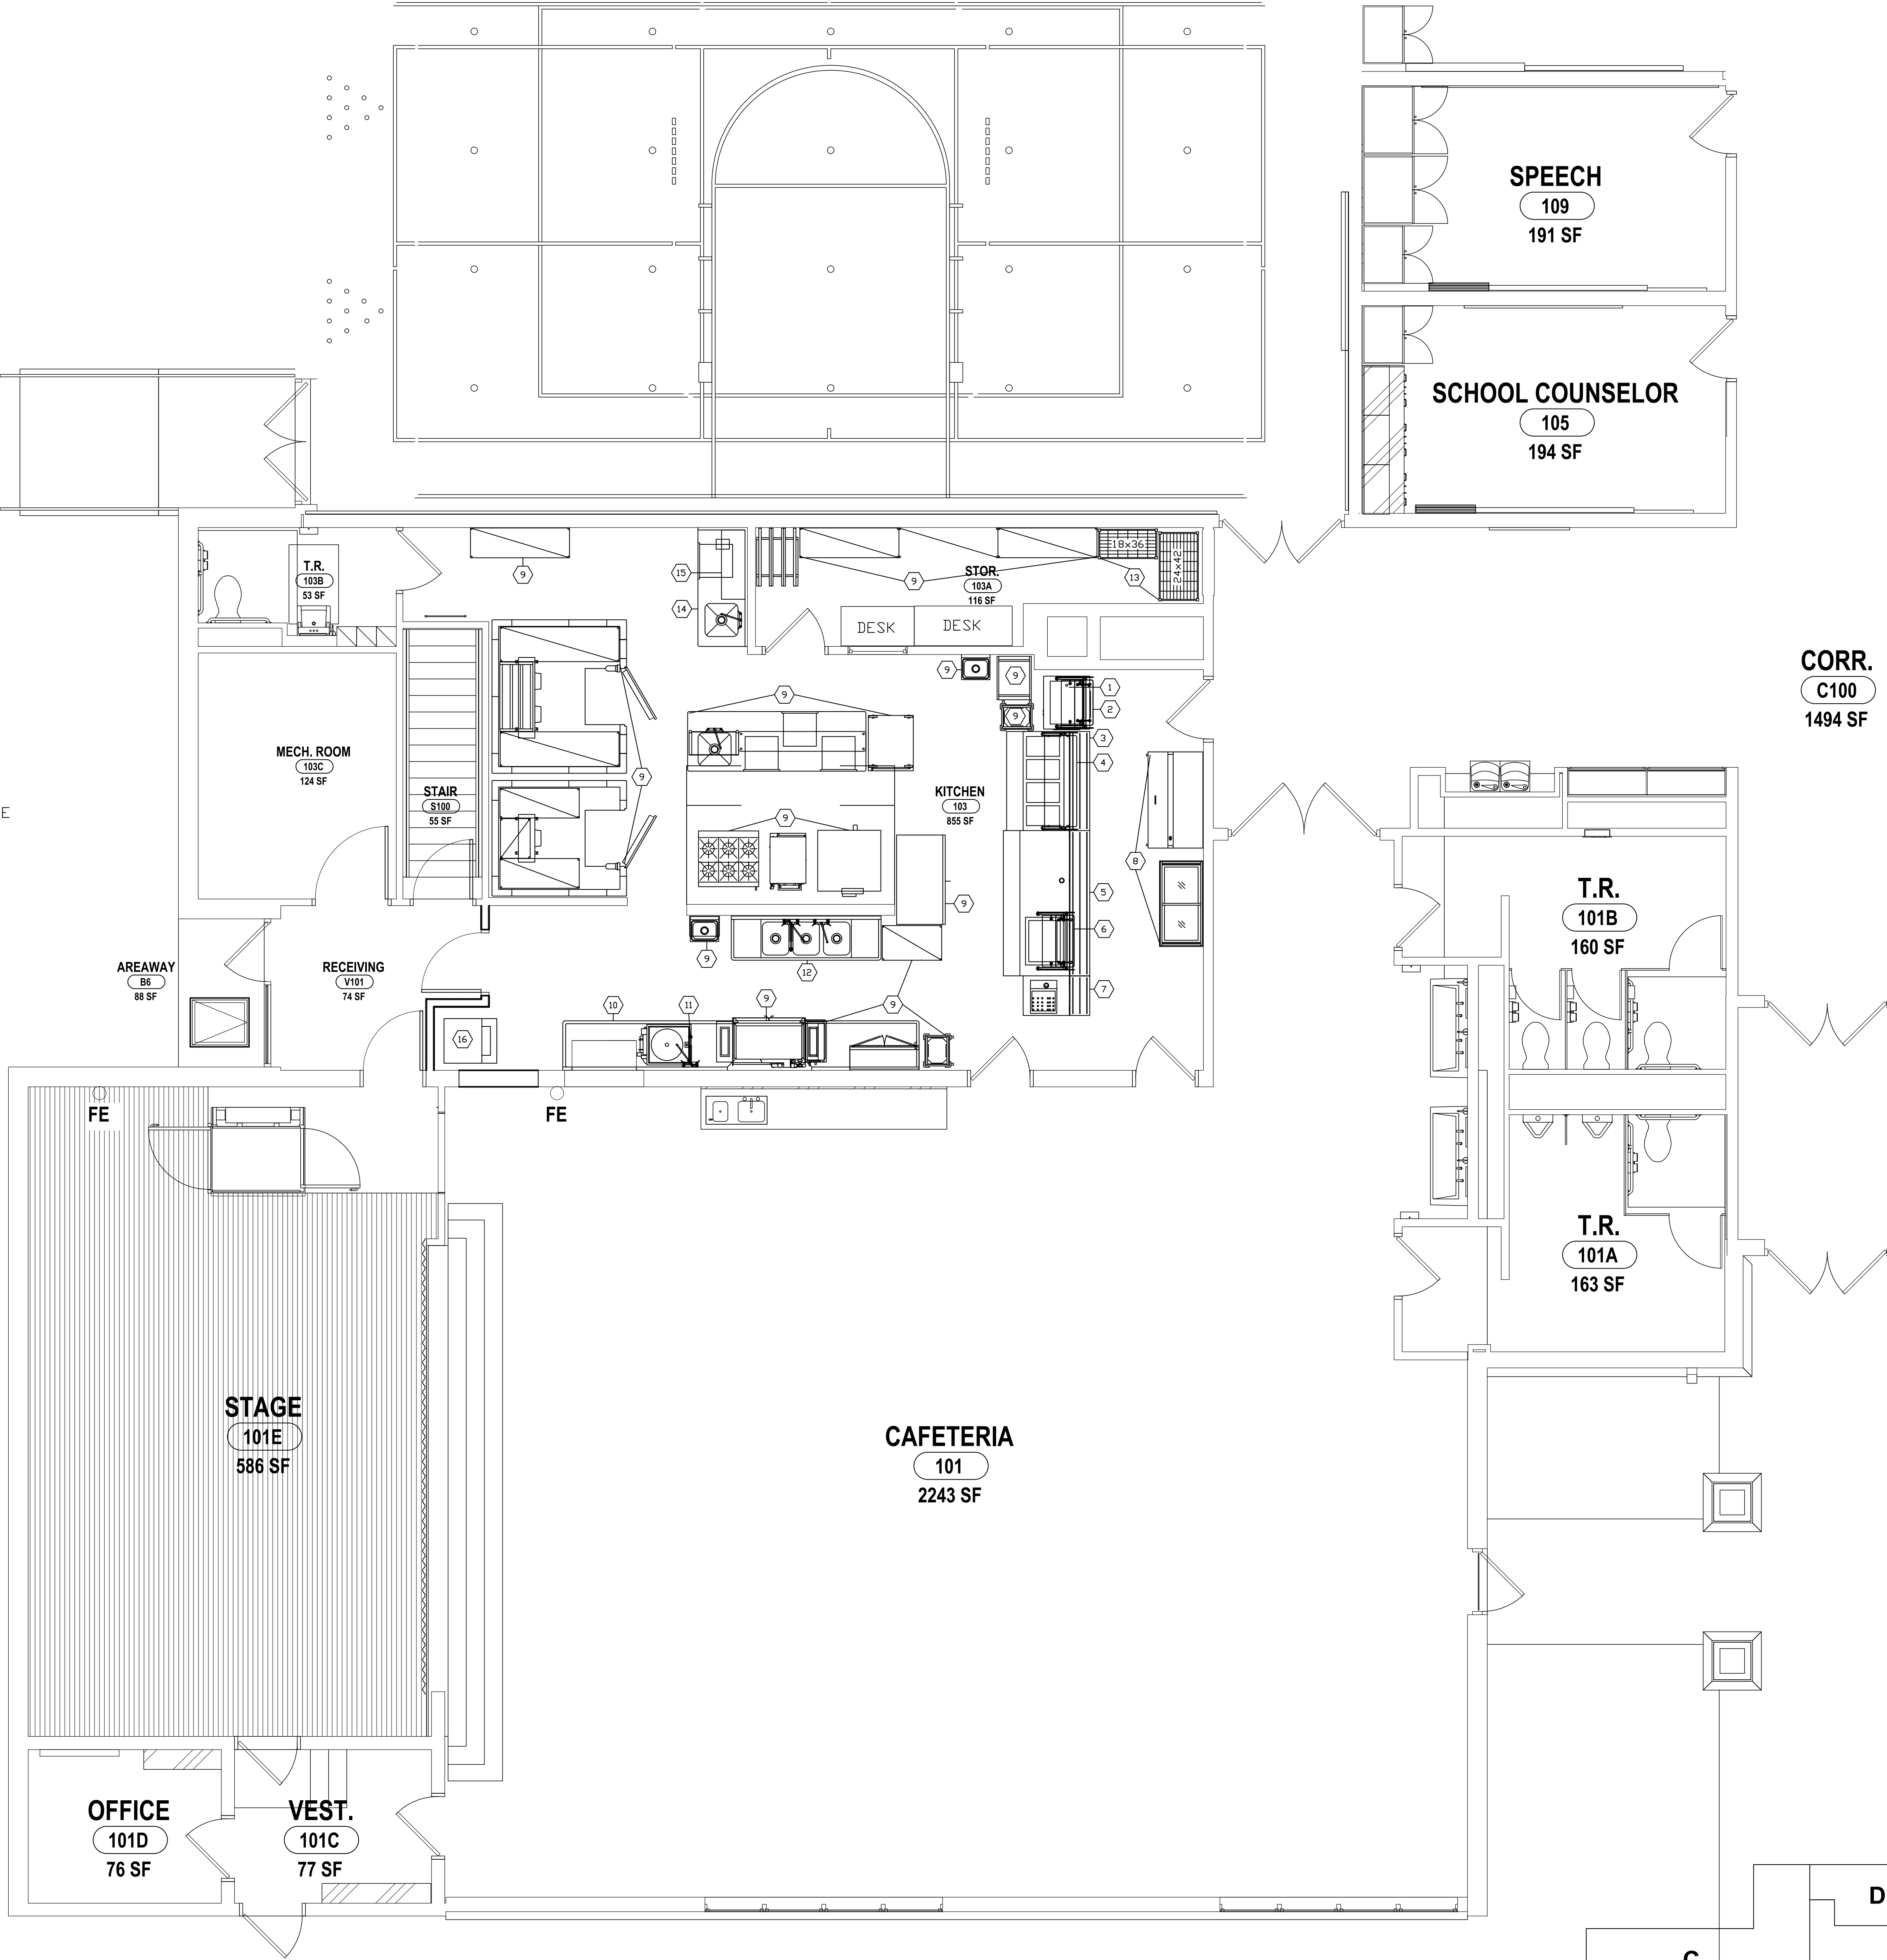

SCALE: 1/4"=1'-0"

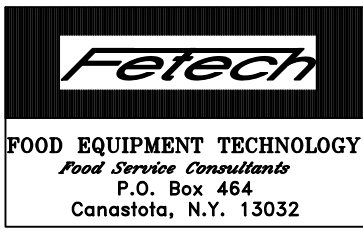

KEY PLAN

2025 ERWIN VALLEY 57-10-00-1-4-00-027, ADMIN BUILDING 57-10-00-01-1-001-013

KITCHEN EQUIPMENT PLAN

2025 ERWIN VALLEY ELEM & ADMIN BUILDING ALTERATIONS
CORNING-PAINTED POST ASD

16 BEARTOWN ROAD, PAINTED POST, NY 14870

EV-FS1.1

PROJECT NO: 2649-160

HUNT ENGINEERS | ARCHITECTS | SURVEYORS

HORSEHEADS, NY 607-359-1000 ROCHESTER, NY 585-527-7549 TOWANDA, PA 570-265-6665
BINGHAMTON, NY 607-788-8081 ALBANY, NY 607-758-8081
WWW.HUNT-EAS.COM

NY CERTIFICATE NO. 001620 PA CERTIFICATE NO. 15C220213 464-1

DESCRIPTION OF REVISION:

#	DATE:	ISSUE FOR BID
1	1/01/2026	

DRAWN BY:	Fetech
CHECKED BY:	Fetech
DATE:	03/17/2026
PHASE:	CD

THIS IS A VOLUNTARY OF THE LAW FOR ANY PERSON TO MAKE UNAUTHORIZED ALTERATIONS OR ADDITIONS TO PLANS
DRAWN UNDER SUPERVISION OF LICENSED PROFESSIONAL ARCHITECT OR SURVEYOR

Copyright: 2025

SYMBOL/ ABBREVIATION SCHEDULE			
PLUMBING - HEATING		ELECTRICAL	
C.W.	● COLD WATER	E.C.	■ ELECTRIC CONNECTION
H.W.	● HOT WATER	J.B.	□ JUNCTION BOX
G.	● GAS	S.R.	□ SINGLE RECEPTACLE
S.	● STEAM SUPPLY	D.R.	□ DUPLEX RECEPTACLE
R.	● STEAM RETURN	C.O.	□ CONVENIENCE OUTLET
PC	⊕ PIPE CONNECTION	R.C.	△ REMOTE CONNECTION
W.	● WASTE DR I. W.	SV	□ SWITCH
F.D.	● FLOOR DRAIN	RMF	□ REMOTE MANUAL FIRE PULL
F.S.	● FLOOR SINK	EL	□ ELECTRIC LIGHT
FFD.	● FUNNEL FLOOR DRAIN	KW	□ KILOWATT
BTU	□ BRITISH THERMAL UNIT	HP	□ MOTOR HORSEPOWER
		AMP	□ AMPERE
MISCELLANEOUS			
DFA	DOWN FROM ABOVE	AFF	ABOVE FINISHED FLOOR
S.P.	STATIC PRESSURE	NIC	NOT IN KITCHEN CONTRACT
CFM	CUBIC FEET PER MINUTE		
NOTES			
This plan is an instrument of service prepared for the convenience of the architect, engineers, and bidders. It is as accurate as can be determined at this date. We will not be responsible for any discrepancies which may develop between locations of connections shown and actual locations of connections of fixtures furnished. The Kitchen Equipment Contractor will furnish dimensioned plans. Connections shown are approximate locations and are for reference ONLY!			


FOODSERVICE EQUIPMENT SCHEDULE

ITEM	QUANT.	DESCRIPTION
1	1	COLD FOOD COUNTER
2	1	DISPLAY CASE
3	1	HOT FOOD COUNTER - EXISTING/MODIFY
4	1	SERVE/SELF-SERVE PROTECTOR GUARD
5	1	COLD FOOD COUNTER - EXISTING/MODIFY
6	1	DISPLY CASE
7	1	CASHIER COUNTER - EXISTING/TO REMAIN
8	1	SERVING EQUIPMENT - EXISTING/TO REMAIN
9	1 LOT	EXISTING EQUIPMENT/TO REMAIN PLACE
10	1	SOILED DISHTABLE - EXISTING/MODIFY
11	1	PRE-RINSE FAUCET
12	1	POT/PAN SINK
13	3	STORAGE SHELVEING
14	1	PREP SINK WORKTABLE - EXISTING/MODIFY
15	1	TWO TIER SHELVEING - MOUNTED TO PREP SINK WORKTABLE
16	1	WASHER/DRYER STACKED UNIT - EXISTING/RELOCATE

NOTES TO ENGINEERS

- *A* PLUMBING CONTRACTOR TO INTERPIPE HAND SINK FOOT PEDAL VALVES TO FAUCET.
- *B* THIS DRAWING DOES NOT SHOW MECHANICAL REQUIREMENTS FOR EXISTING EQUIPMENT. THESE ITEMS MUST BE FIELD VERIFIED FOR REQUIRED SERVICES.
- *C* SCULLERY SINK WASTES SHOULD BE CONNECTED TO A GREASE SEPERATOR.
- *GENERAL NOTE*
VERIFY ALL INFORMATION SHOWN ON THIS DRAWING WITH CATALOG CUTS. THIS DRAWING IS FOR INFORMATIONAL USE ONLY BY THE ENGINEERS AND IS NOT TO BE INCLUDED IN THE BID DOCUMENTS.
- *GENERAL NOTE*
PLUMBING ENGINEERS ARE TO DECIDE WHERE FLOOR DRAINS & FLOOR SINKS ARE TO BE USED.
- *GENERAL NOTE*
THIS DWG. SHOWS ELECTRICAL REQUIREMENTS FOR EQUIPMENT ONLY. EXTRA RECEPTACLES SHOULD BE LOCATED NEAR ALL WORKSTATIONS.

SCALE: 1/4"=1'-0"

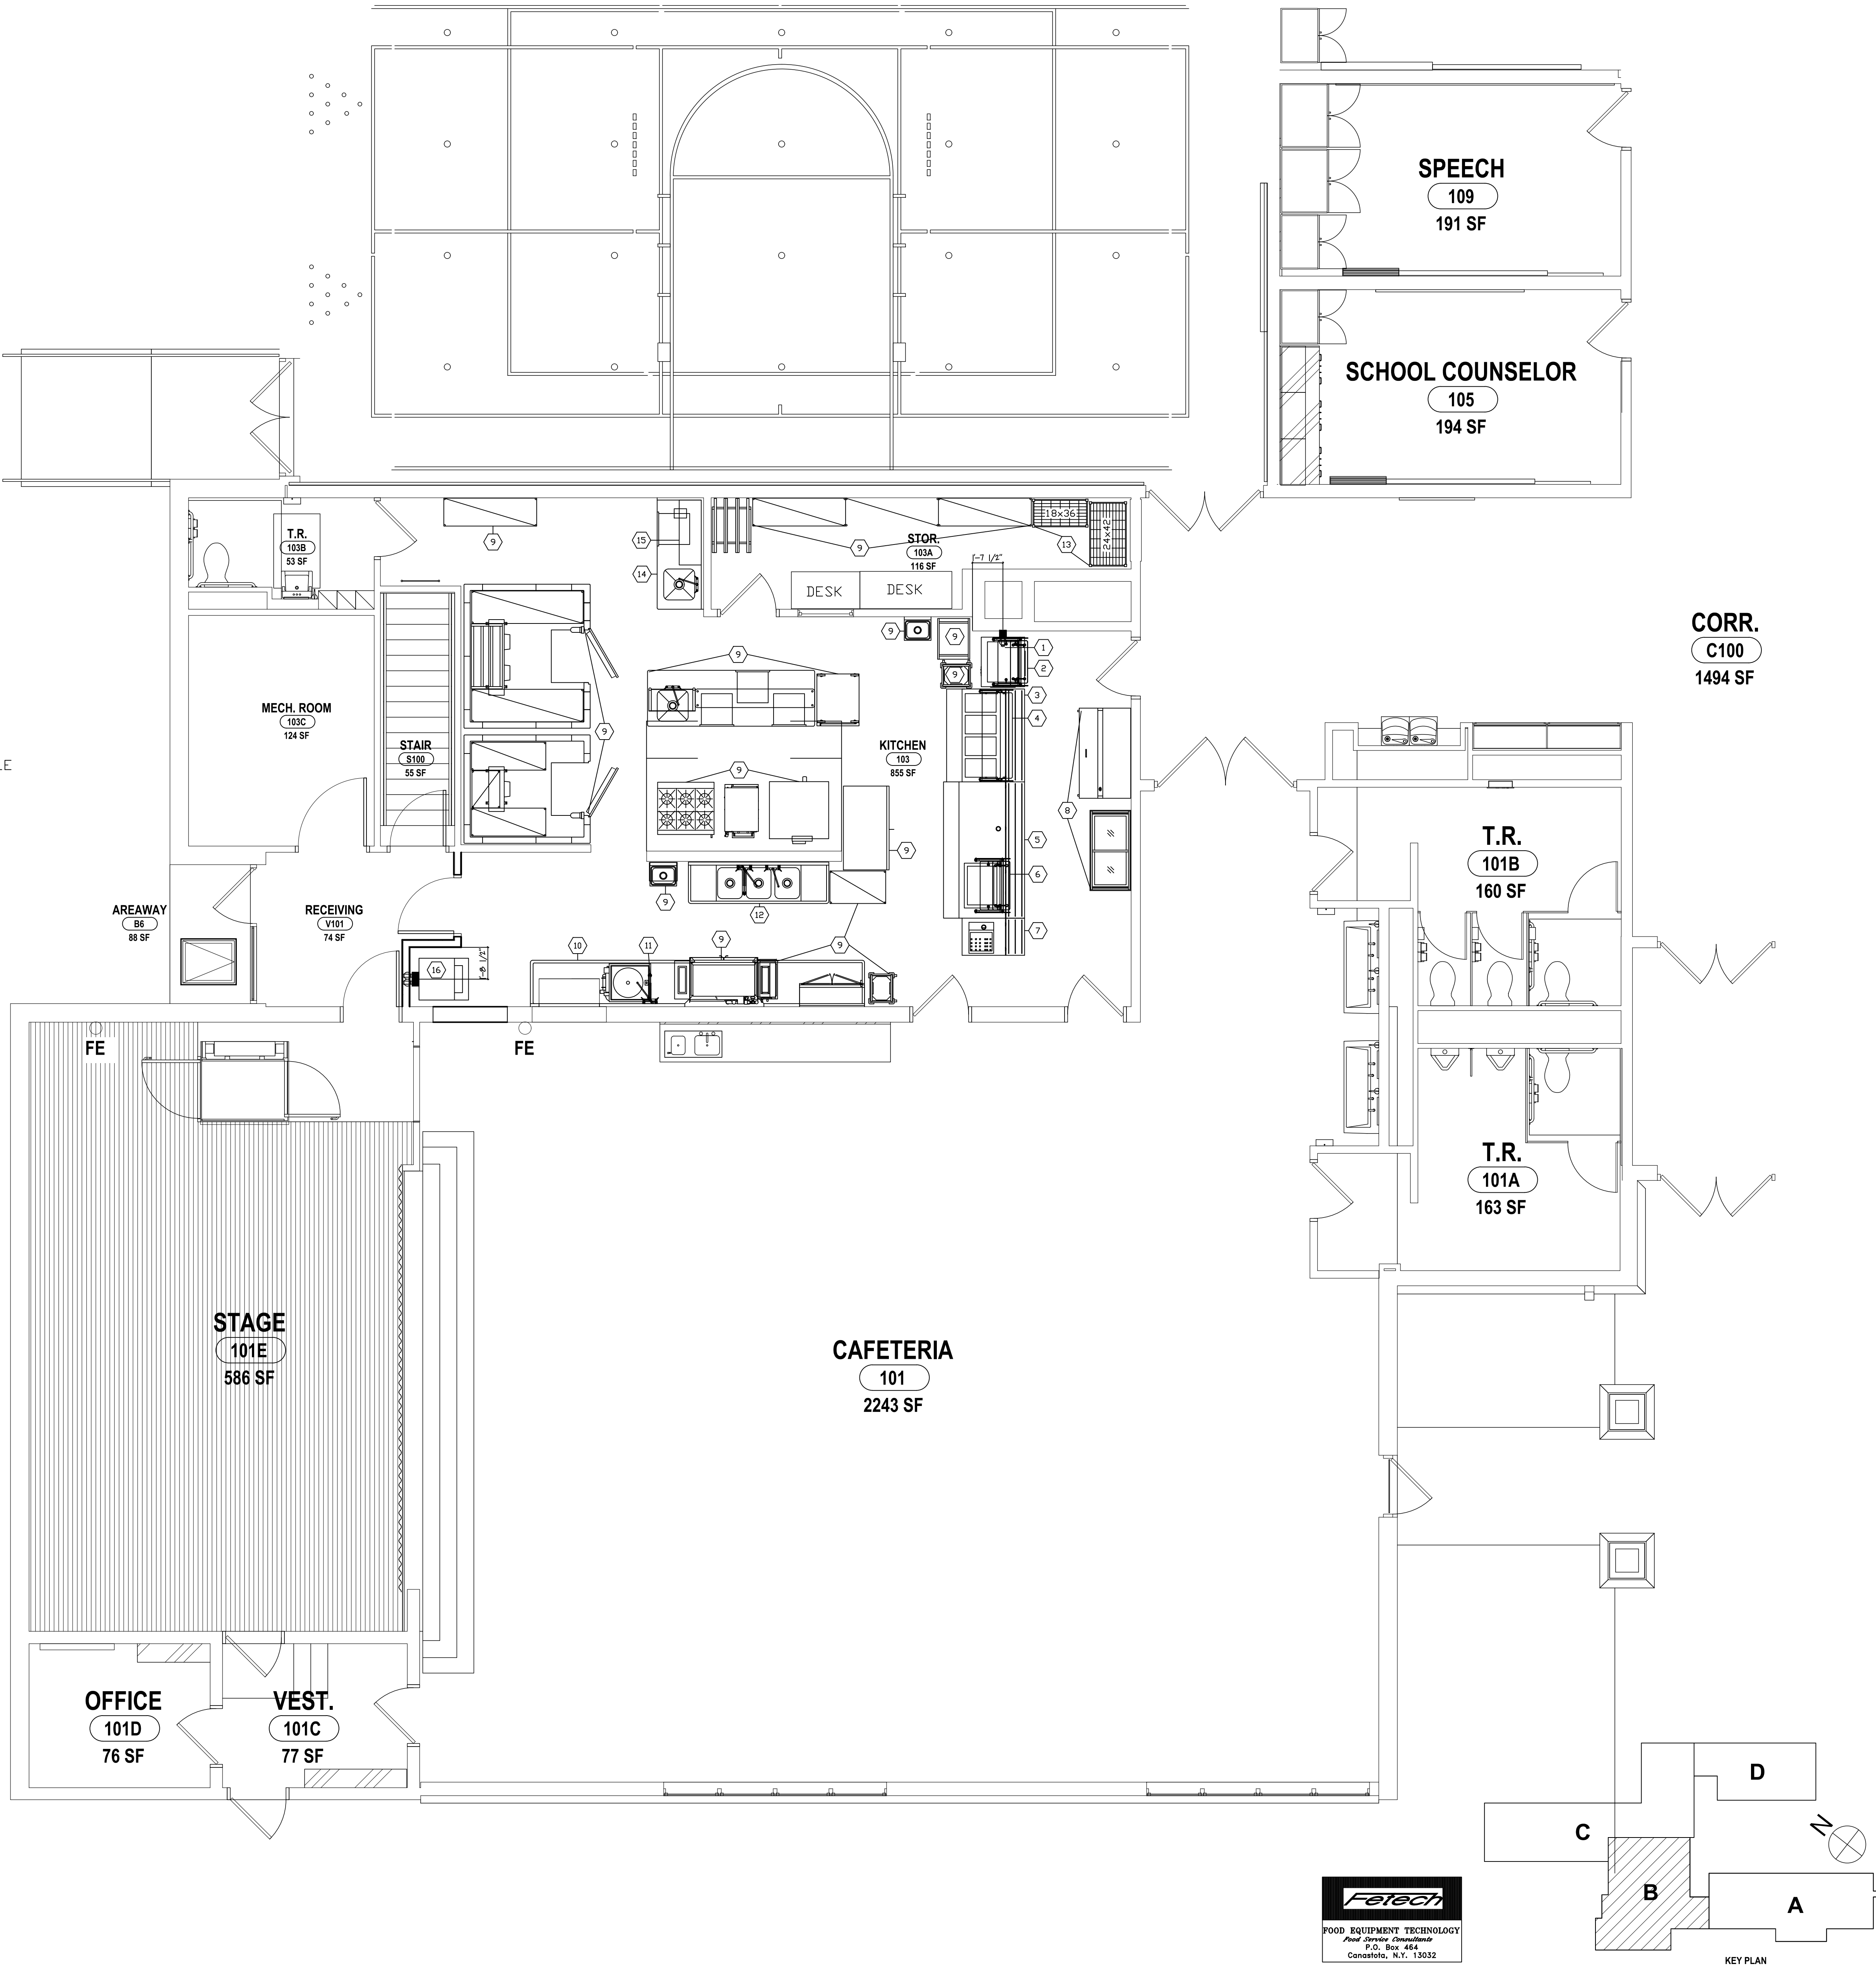

DRAWN BY: Fetech	
CHECKED BY: Fetech	
DATE: 03/17/2026	
PHASE: CD	
#	DATE
1	10/12/2026
DESCRIPTION OF REVISION:	
ISSUE FOR BID	
THIS IS A VOLUTION OF THE DRAWING AND PERSON TO MAKE UNINTENDED ALTERATIONS OR ADDITIONS TO PLANS. CHANGES MUST BE SUBMITTED IN WRITING TO THE ARCHITECT FOR APPROVAL.	
Copyright: 2026	

HUNT
ENGINEERS | ARCHITECTS | SURVEYORS
HORSEHEADS, NY 607-359-1000
ROCHESTER, NY 585-337-7549
TOWANDA, PA 570-265-4666
BINGHAMTON, NY 607-738-8081
ALBANY, NY 607-738-8091
WWW.HUNT-EAS.COM
NY CERTIFICATE NO. 001620 PA CERTIFICATE NO. TSC2202013 464-1

2025 ERWIN VALLEY ELEM & ADMIN BUILDING ALTERATIONS
CORNING-PAINTED POST ASD
16 BEARTOWN ROAD, PAINTED POST, NY 14870

SED # ERWIN VALLEY 57-10-00-01-000-027 ADMIN BUILDING 57-10-00-01-100-103

EV-FS1.2
PROJECT NO: 2649-160

SYMBOL/ ABBREVIATION SCHEDULE			
PLUMBING - HEATING		ELECTRICAL	
C.W. ● COLD WATER	E.C. ■ ELECTRIC CONNECTION	J.B. □ JUNCTION BOX	
H.W. ● HOT WATER	S.R. □ SINGLE RECEPTACLE	D.R. □ DUPLEX RECEPTACLE	
G. ● GAS	C.O. □ CONVENIENCE OUTLET	R.C. □ REMOTE CONNECTION	
S. ● STEAM SUPPLY	SW. □ SWITCH		
R. ● STEAM RETURN	RE. □ REMOTE MANUAL FIRE PULL		
PC. ● PIPE CONNECTION	E.L. □ ELECTRIC LIGHT		
V. ● WASTE OR L.W.	KV. KILOWATT		
F.D. □ FLOOR DRAIN	HP. MOTOR HORSEPOWER		
F.S. □ FLOOR SINK	AMP. AMPERE		
FFD. □ FUNNEL FLOOR DRAIN			
BTU. □ BRITISH THERMAL UNIT			
MISCELLANEOUS			
DFA. DOWN FROM ABOVE	AFF. ABOVE FINISHED FLOOR		
S.P. STATIC PRESSURE	NIC. NOT IN KITCHEN CONTRACT		
CFM. CUBIC FEET PER MINUTE			
NOTES			
This plan is an instrument of service prepared for the convenience of the architect, engineers, and bidders. It is as accurate as can be determined at this date. We will not be responsible for any discrepancies which may develop between locations of connections shown and actual locations of connections of fixtures furnished. The Kitchen Equipment Contractor will furnish dimensioned plans. Connections shown are approximate locations and are for reference ONLY!			


FOODSERVICE EQUIPMENT SCHEDULE

ITEM	QUANT.	DESCRIPTION
1	1	COLD FOOD COUNTER
2	1	DISPLAY CASE
3	1	HOT FOOD COUNTER - EXISTING/MODIFY
4	1	SERVE/SELF-SERVE PROTECTOR GUARD
5	1	COLD FOOD COUNTER - EXISTING/MODIFY
6	1	DISPLY CASE
7	1	CASHIER COUNTER - EXISTING/TO REMAIN
8	1	SERVING EQUIPMENT - EXISTING/TO REMAIN
9	1 LOT	EXISTING EQUIPMENT/TO REMAIN PLACE
10	1	SOILED DISHTABLE - EXISTING/MODIFY
11	1	PRE-RINSE FAUCET
12	1	POT/PAN SINK
13	3	STORAGE SHELIVING
14	1	PREP SINK WORKTABLE - EXISTING/MODIFY
15	1	TWO TIER SHELIVING - MOUNTED TO PREP SINK WORKTABLE
16	1	WASHER/DRYER STACKED UNIT - EXISTING/RELOCATE

NOTES TO ENGINEERS

- *A* PLUMBING CONTRACTOR TO INTERPIPE HAND SINK FOOT PEDAL VALVES TO FAUCET.
- *B* THIS DRAWING DOES NOT SHOW MECHANICAL REQUIREMENTS FOR EXISTING EQUIPMENT. THESE ITEMS MUST BE FIELD VERIFIED FOR REQUIRED SERVICES.
- *C* SCULLERY SINK WASTES SHOULD BE CONNECTED TO A GREASE SEPERATOR.
- *GENERAL NOTE*
VERIFY ALL INFORMATION SHOWN ON THIS DRAWING WITH CATALOG CUTS. THIS DRAWING IS FOR INFORMATIONAL USE ONLY BY THE ENGINEERS AND IS NOT TO BE INCLUDED IN THE BID DOCUMENTS.
- *GENERAL NOTE*
PLUMBING ENGINEERS ARE TO DECIDE WHERE FLOOR DRAINS & FLOOR SINKS ARE TO BE USED.
- *GENERAL NOTE*
THIS DWG. SHOWS ELECTRICAL REQUIREMENTS FOR EQUIPMENT ONLY. EXTRA RECEPTACLES SHOULD BE LOCATED NEAR ALL WORKSTATIONS.

SCALE: 1/4"=1'-0"

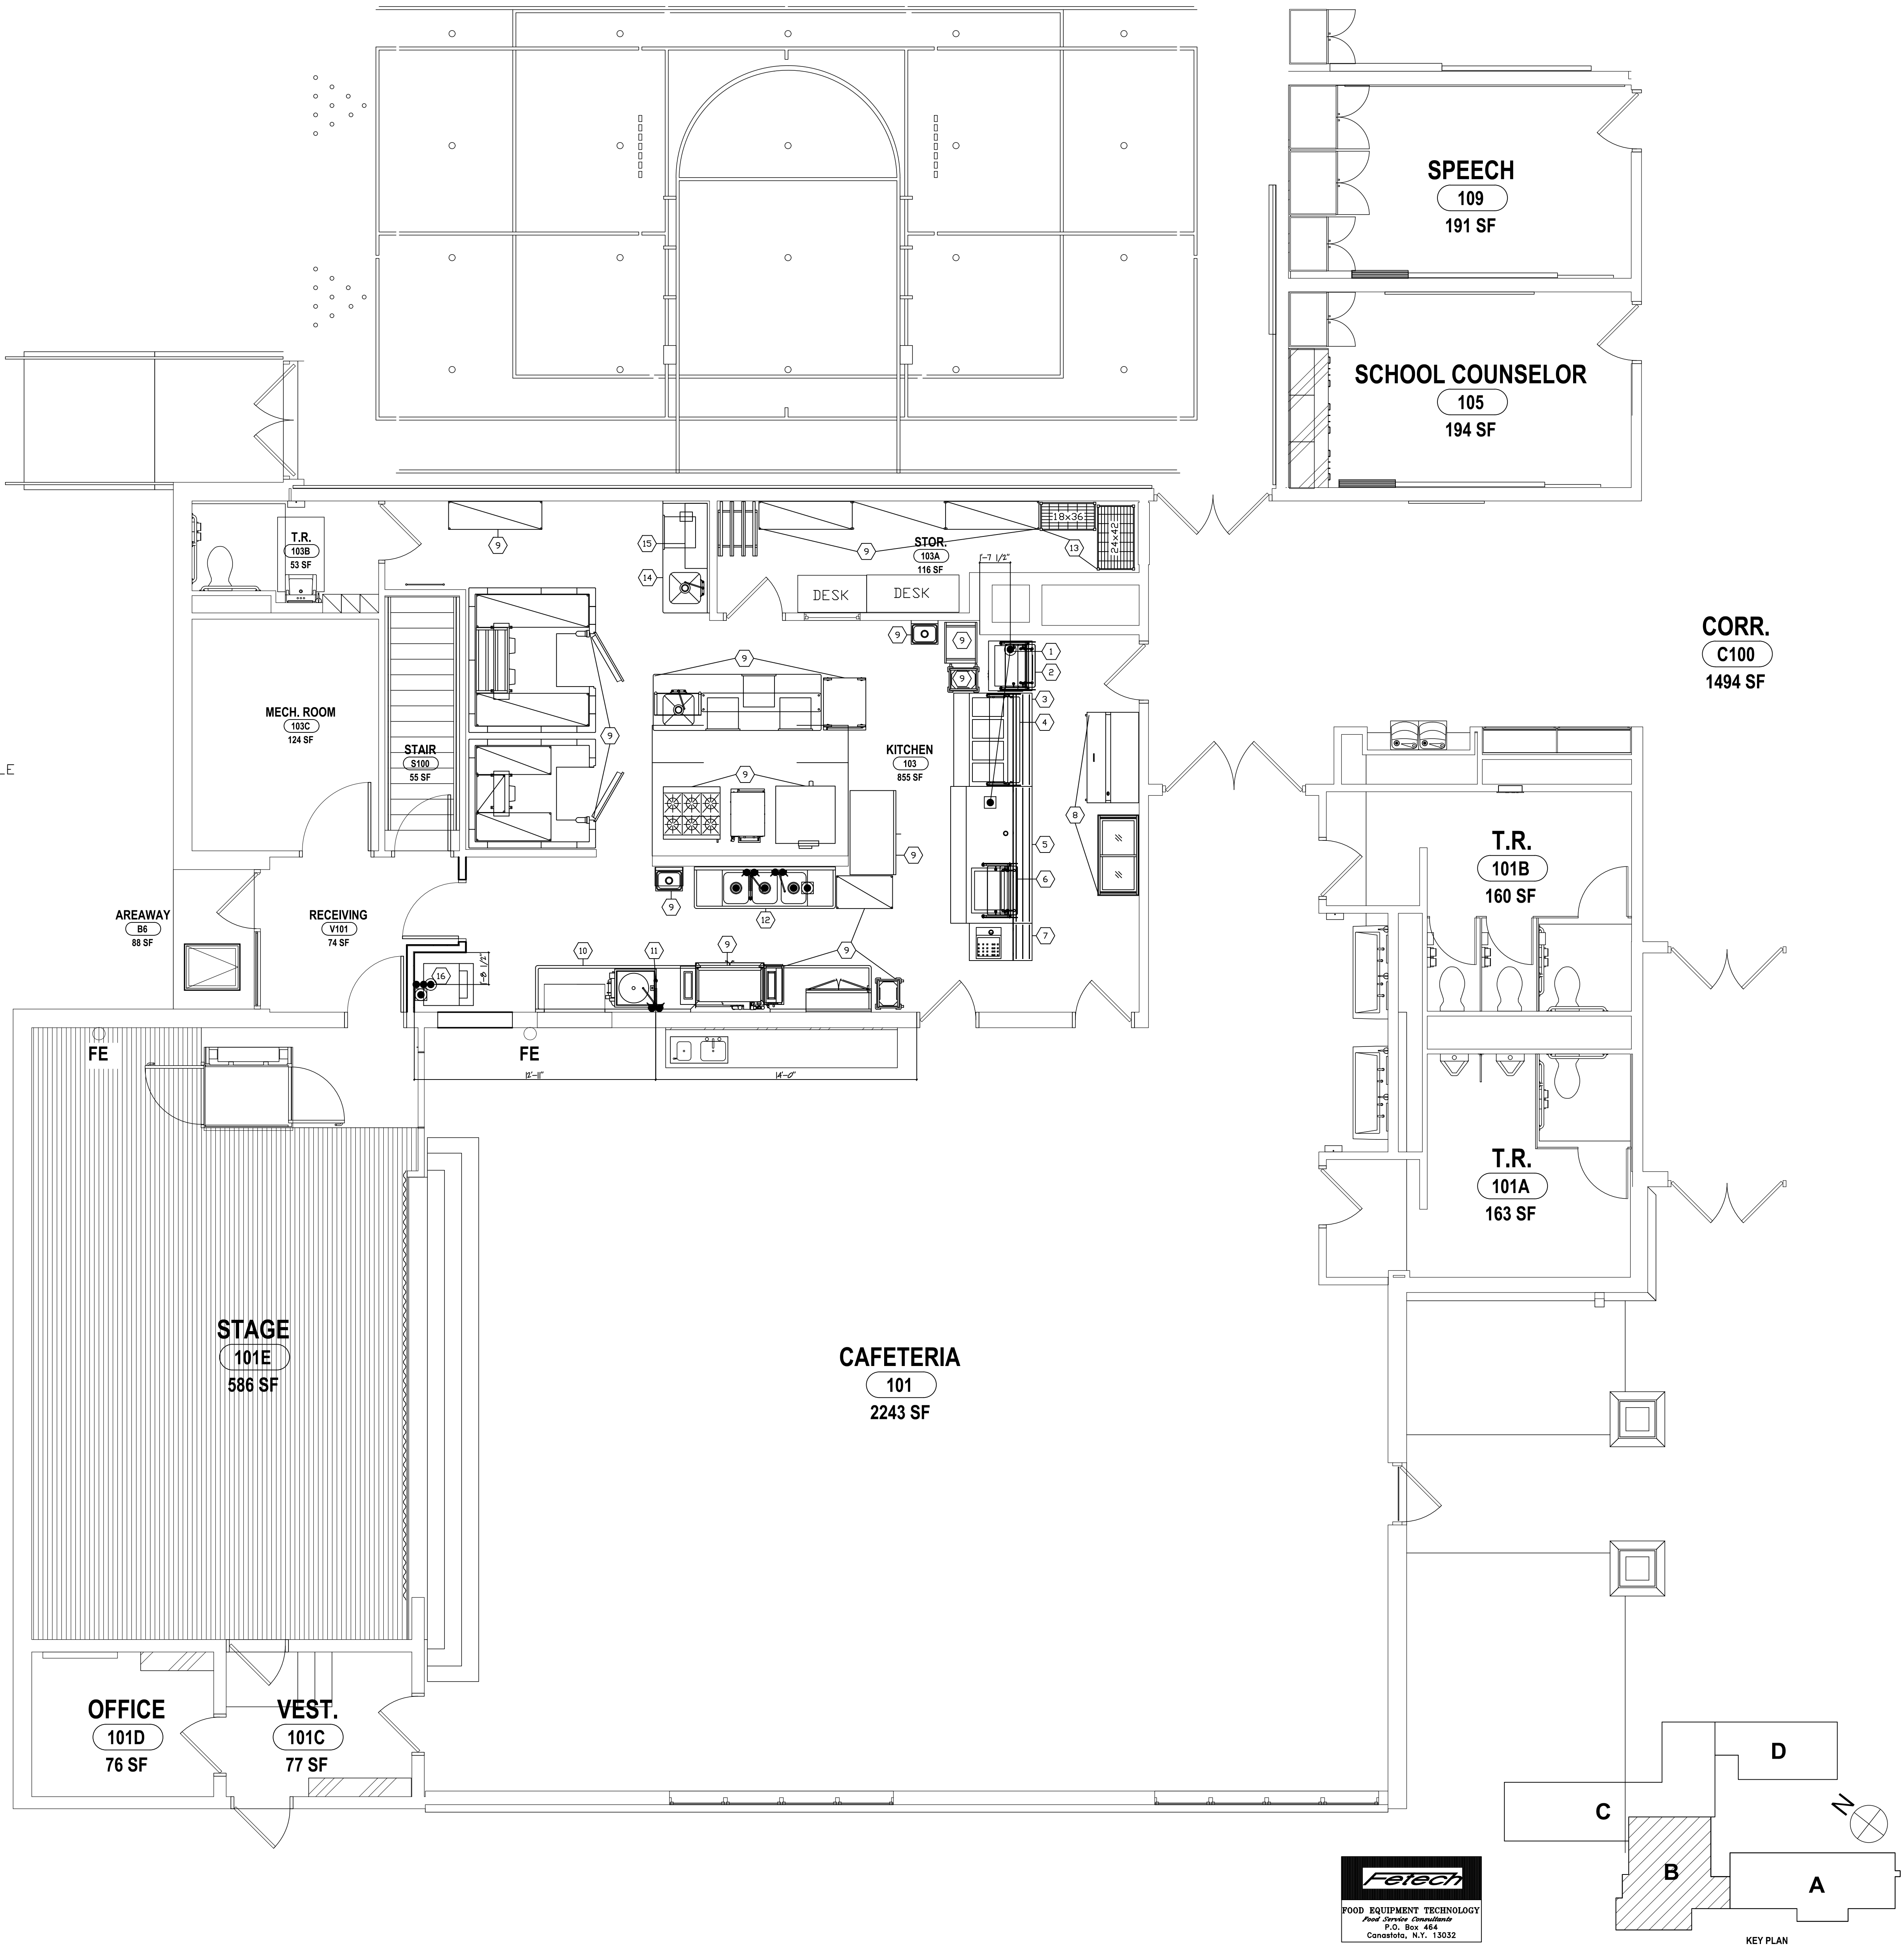

			DRAWN BY: Feteck	
			CHECKED BY: Feteck	
			DATE: 03/17/2026	
			PHASE: CD	
			Copyright: 2026	
#	DATE:	DESCRIPTION OF REVISION:		
1	10/12/2026	ISSUE FOR BID		

HUNT ENGINEERS | ARCHITECTS | SURVEYORS

ROCHESTER, NY 585-227-7249
BINGHAMTON, NY 607-738-8081
ALBANY, NY 607-738-8081
TOWANDA, PA 570-265-4666
WWW.HUNT-EAS.COM

NY CERTIFICATE NO. 001620 PA CERTIFICATE NO. 15C220313 464-1

KITCHEN EQUIPMENT PLUMBING CONNECTION PLAN

2025 ERWIN VALLEY ELEM & ADMIN BUILDING ALTERATIONS

CORNING-PAINTED POST ASD



16 BEARTOWN ROAD, PAINTED POST, NY 14870

EV-FS1.3

PROJECT NO: 2649-160

ITEM #	DESCRIPTION	QTY.	VOLT/PH	AMP	NEMA/DC	ELEC AFF	CW	CW AFF	HW	HW AFF	IW	IW AFF	NOTES
1	COLD FOOD COUNTER	1	120/1	10.00	5-15P	4.00					1.00	4.00	GARDEN HOSE DRAIN TO EXIST. F.D.
2	DISPLAY CASE	1	120/1	1.00	DIRECT	---							INTERWIRED TO ITEM #1
3	HOT FOOD COUNTER - EXISTING/MODIF	1	208/1	19.23	6-30P	4.00					1.00	4.00	GARDEN HOSE TO EXIST F.D.
4	PROTECTOR GUARD	1	120/1	1.00	DIRECT	---							INTERWIRED TO ITEM #3
5	COLD FOOD COUNTER-EXISTING/MODIF	1	120/1	12.00	5-15P	4.00					1.00	4.00	GARDEN HOSE TO EXIST F.D.
6	DISPLAY CASE	1	120/1	1.00	DIRECT	---							INTERWIRED TO TO ITEM #5
7	CASHIER COUNTER - EXISTING	1	120/1	15.00	5-15P	4.00							VERIFY SERVICES
8	SERVING EQUIPMENT - EXISTING	1LOT	120/1	10.00	5-15P	4.00							VERIFY SERVICES
9	EXSITING EQUIPMENT - TO REMAIN	1LOT											VERIFY SERVICES
10	SOILED DISHTABLE-EXISTING/MODIFY	1											INSTALL ITEM #11
11	PRE-RINSE FAUCET	1					0.50	30.00	0.50	30.00			
12	POT/PAN SINK	1					(2)0.50	30.00	(2)0.50	30.00	(3)2.00	18.00	DRAIN TO EXIST F.S. TO GREASE TRAI
13	STORAGE SHELIVING	2											NO MECHANICAL REQUIREMENTS
14	PREP WORKTABLE-EXISTING/MODIFY	1											
15	TWO TIER SHELIVING	1											INSTALLED ON ITEM #14
16	WASHER/DRYER-EXISTING/RELOCATE	1	120/240/1	VERIFY	VERIFY	VERIFY	0.50	30.00	0.50	30.00	1.50	VERFIY	VERIFY SVCS - NEED F.S.

SCALE: NONE

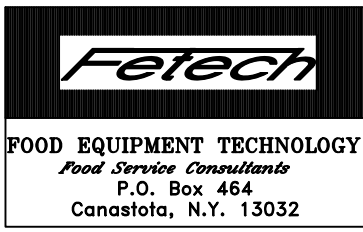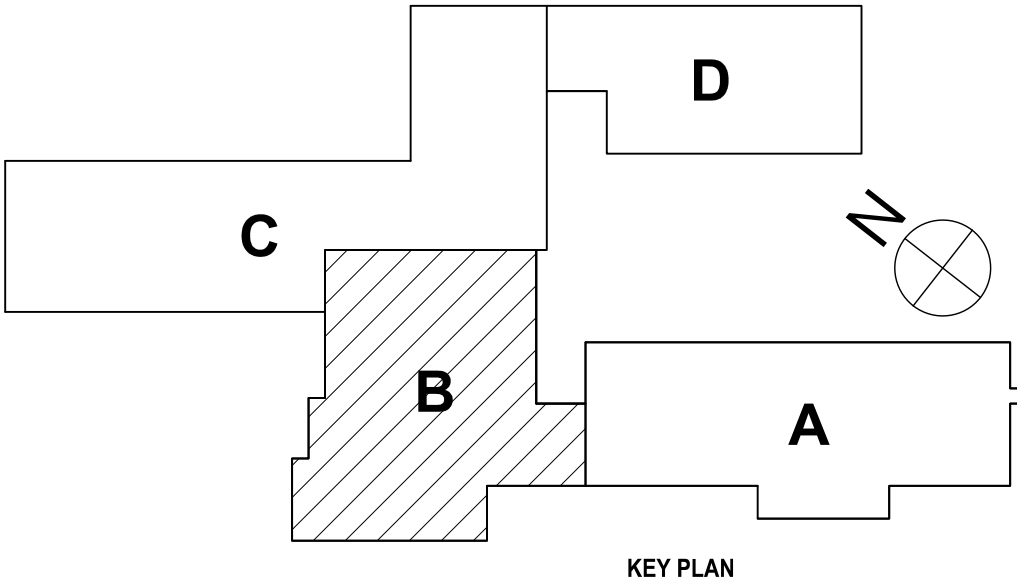

SED # ERWIN VALLEY ST-10-00-01-0-00-027; ADMIN BUILDING ST-10-00-01-1-00-133

KITCHEN EQUIPMENT MECHANICAL SCHEDULE

2025 ERWIN VALLEY ELEM & ADMIN BUILDING ALTERATIONS

CORNING-PAINTED POST ASD

16 BEARTOWN ROAD, PAINTED POST, NY 14870

EV-FS1.4

PROJECT NO: 2649-160

HUNT

ENGINEERS | ARCHITECTS | SURVEYORS

HORSEHEADS, NY 607-359-1000 ROCHESTER, NY 585-227-7549 TOWNANDA, PA 470-265-4665 BINGHAMTON, NY 607-738-8081 ALBANY, NY 607-738-8081

WWW.HUNT-EAS.COM

NY CERTIFICATE NO. 001620 PA CERTIFICATE NO. 15C2202013 464-1

#

DATE:

1

10/12/2026

DESCRIPTION OF REVISION:

ISSUE FOR BID

DRAWN BY:

Felechi

CHECKED BY:

Felechi

DATE:

03/17/2026

PHASE:

CD

IT IS A VIOLATION OF THE LAW FOR ANY PERSON TO MAKE UNAUTHORIZED ALTERATIONS OR ADDITIONS TO PLANS DRAWN OR ENGINEERED BY A LICENSED PROFESSIONAL ENGINEER OR ARCHITECT.


Copyright: 2026

GENERAL NOTES


- A ALL WORK ON THIS DRAWING IS THE RESPONSIBILITY OF THE CONTRACTOR UNLESS CLEARLY INDICATED TO BE PART OF ANOTHER CONTRACT.
- B THESE DRAWINGS ARE INTENDED TO SHOW THE GENERAL SCOPE OF ITEMS TO BE REMOVED. IT IS NOT INTENDED TO BE ALL INCLUSIVE. THE CONTRACTOR SHALL FIELD VERIFY ALL ITEMS TO BE REMOVED. ANY ITEM IN QUESTION SHOULD BE VERIFIED WITH ENGINEER PRIOR TO REMOVAL.
- C ALL ITEMS SCHEDULED FOR DEMOLITION ARE THE PROPERTY OF THE OWNER. THE CONTRACTOR SHALL PLACE WANTED EQUIPMENT IN AREA DESIGNATED ON SITE BY OWNER. ANY ITEM THE OWNER WISHES NOT TO KEEP SHALL BE DISPOSED OF BY THE CONTRACTOR.
- D THE CONTRACTOR SHALL REMOVE, PROTECT, REPLACE AND/OR REINSTALL ANY CEILING OR GRID DAMAGED OR REMOVED AS A RESULT OF WORK IN AREAS WHERE CEILINGS ARE NOT SCHEDULED TO BE REPLACED.
- E THE CONTRACTOR SHALL FIELD VERIFY ALL EXISTING CONDITIONS (FRAMING, ELECTRICAL, PLUMBING, HVAC, ETC) PRIOR TO CONSTRUCTION AND INSTALLATION OF NEW WORK. NOTIFY ARCHITECT/ENGINEER OF ANY CONFLICTS THAT REQUIRE MODIFICATION TO NEW PLUMBING SYSTEM INSTALLATION.
- F THE CONTRACTOR TO REINSULATE ALL PORTIONS OF EXISTING PLUMBING SYSTEM DISTURBED DURING INSTALLATION OF NEW PIPING.
- G THE CONTRACTOR WILL BE RESPONSIBLE FOR ALL NEW FLOOR OPENINGS, EXCAVATIONS OF EXISTING SUBSTRATES AND WALL PENETRATIONS TO INSTALL NEW PIPING. UNLESS OTHERWISE NOTED, ALL PIPE PENETRATIONS THROUGH WALLS AND FLOORS WILL BE SEALED WITH FIRE-STOPPING.
- H THE CONTRACTOR IS RESPONSIBLE FOR INSTALLATION AND CONNECTION OF ALL PIPING WITHIN 5 FEET FROM BUILDING. COORDINATE CONNECTIONS.
- I THE CONTRACTOR WILL BE RESPONSIBLE FOR PATCHING AND SEALING OF ALL DISTURBED SUBSTRATE, WALLS AND CEILING TO EXISTING FINISHES UNLESS OTHERWISE NOTED.
- J THE CONTRACTOR TO COORDINATE ALL NEW ROOF PENETRATIONS.
- K INVERT DIMENSION IS TO BOTTOM OF PIPE.
- L THE CONTRACTOR TO PROVIDE WATER HAMMER ARRESTORS ON ALL NEW PLUMBING FIXTURES. REFER TO SPECIFICATION SECTION 22.10.05.
- M PROVIDE 3M METAL COLLAR ASSEMBLY MODEL ULTRA RC OR SIMILAR WHERE NON-METALLIC PIPE PENETRATES FIRE RATED WALLS.
- N THE CONTRACTOR WILL BE RESPONSIBLE FOR FINAL CONNECTION OF PLUMBING EQUIPMENT TO KITCHEN EQUIPMENT AFTER PLACEMENT. COORDINATE LOCATIONS.
- O THE CONTRACTOR TO PROVIDE ADA COMPLIANT VINYL PIPE COVER ON EXPOSED COLD WATER, HOT WATER AND SANITARY PIPING BELOW ADA LAVATORY/SINK. SANITARY PIPE COVER SHALL BE INSTALLED UP TO BOTTOM OF FIXTURE.
- P THE CONTRACTOR TO PROVIDE IDENTIFICATION TO PLUMBING PIPING AND TAGS TO PLUMBING VALVES. REFER TO SPECIFICATION SECTION 22.05.03.
- Q ALL PLUMBING FIXTURES SHALL BE PROVIDED WITH P-TRAP.
- R ALL BURIED SANITARY PIPING SHALL BE A MINIMUM OF 2 INCH. ALL BURIED VENT PIPING FOR FLOOR DRAIN OR FLOOR SINK SHALL BE 2 INCH. ALL ABOVE GRADE VENT PIPING FOR FLOOR DRAIN OR FLOOR SINK SHALL BE 1-1/2 INCH.
- S ALL COLD WATER, HOT WATER AND GAS PIPING SHALL BE PROVIDED WITH SHUTOFF BALL VALVES ON BRANCH PIPING.
- T NEW GAS PIPING SYSTEM SHALL MEET REQUIREMENTS OF SEISMIC DESIGN CATEGORY C. REFER TO 'S' DRAWINGS FOR DESIGN LOADS.
- U ALL PIPING TO BE ROUTED AS HIGH AND AS TIGHT TO STEEL STRUCTURE AS POSSIBLE.
- V PROVIDE INSULATION TO STORM PIPING IN ITS ENTIRETY FROM ROOF DRAIN, ENTIRE LENGTH OF FIRST HORIZONTAL STORM PIPING RUN TO FIRST VERTICAL DROP.
- W THESE DRAWINGS ARE INTENDED TO SHOW THE GENERAL SCOPE OF NEW WORK. IT IS NOT INTENDED TO BE ALL INCLUSIVE. ANY ITEM IN QUESTION SHOULD BE REVIEWED WITH ENGINEER.
- X PRIOR TO CORE DRILLING, LOCATION OF FLOOR PENETRATIONS SHALL BE COORDINATED AND ADJUSTED, AS NEEDED, TO AVOID CONTACT WITH STRUCTURAL MEMBERS.
- Y PVC PIPING IS NOT ALLOWED TO BE INSTALLED IN PLACES OF ASSEMBLY, PLENUM SPACES, EXIT DISCHARGE CORRIDOR OR STAIRS. USE CAST IRON OR COPPER PIPING IN THESE LOCATIONS.

DEMOLITION NOTES - PLUMBING

- D1 DISCONNECT AND REMOVE WATER CLOSET AND ALL ASSOCIATED ACCESSORIES IN ITS ENTIRETY. DISCONNECT AND REMOVE COLD WATER PIPING AND ALL ASSOCIATED ACCESSORIES BACK TO MAIN AND PREPARE FOR RECONNECTION IN NEW WORK. DISCONNECT AND REMOVE SANITARY PIPING AND ALL ASSOCIATED ACCESSORIES BACK TO FLOOR AND PREPARE FOR RECONNECTION IN NEW WORK. DISCONNECT AND REMOVE VENT PIPING AND ALL ASSOCIATED ACCESSORIES BACK TO CEILING AND PREPARE FOR RECONNECTION IN NEW WORK.
- D2 DISCONNECT AND REMOVE SINK AND ALL ASSOCIATED ACCESSORIES. DISCONNECT BOTTLE FILLER AND TURN OVER TO OWNER FOR INSTALLATION IN NEW WORK. DISCONNECT COLD WATER, HOT WATER AND SANITARY PIPING. PREPARE FOR RECONNECTION IN NEW WORK.

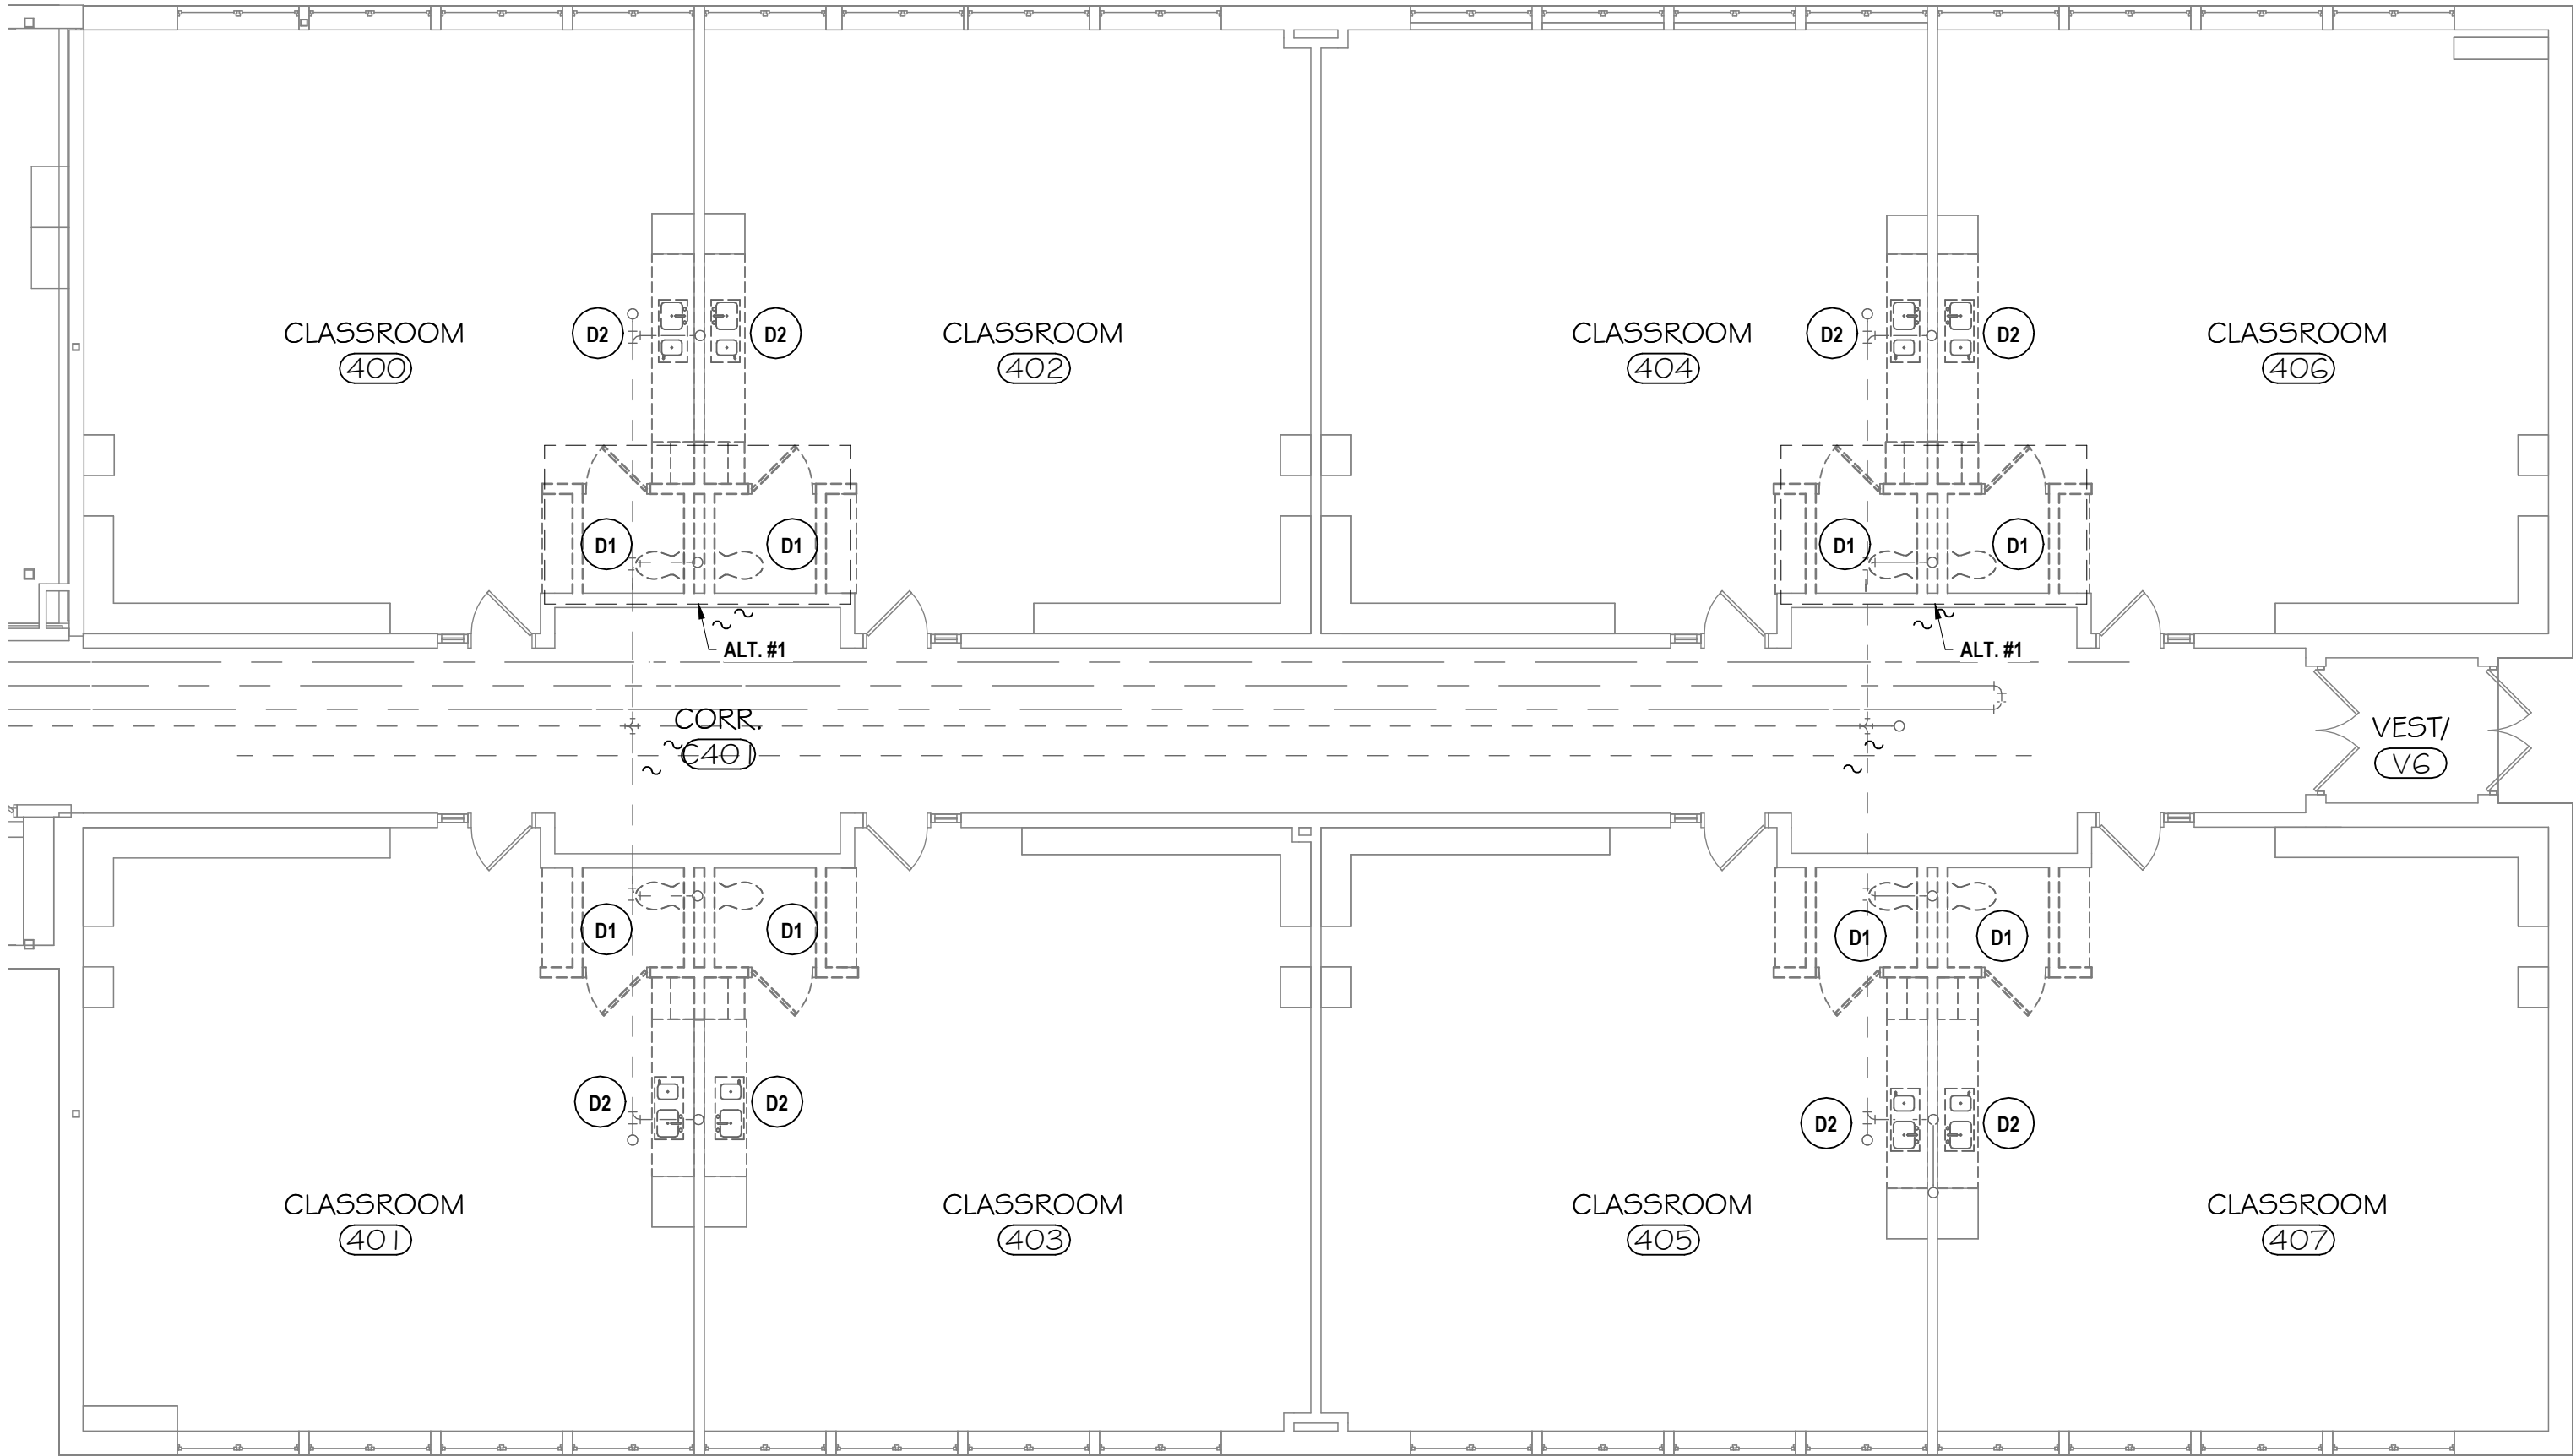

1 FIRST FLOOR DEMOLITION PLAN - AREA D
1/8" = 1'-0"

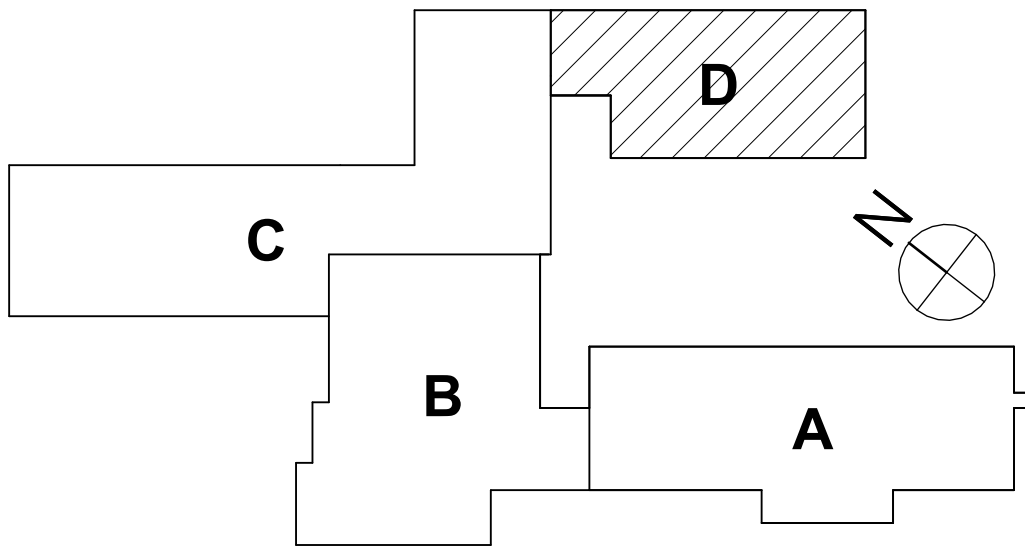

SED NUMBERS EV-21-00-001-0-000-007, AD-21-00-001-1-001-013

FIRST FLOOR DEMOLITION PLANS - AREA D
2025 ERWIN VALLEY ELEM & ADMIN BUILDING ALTERATIONS
CORNING-PAINTED POST AREA SCHOOL DISTRICT
16 BEARTOWN ROAD, PAINTED POST NY 14870

EV-P0.1

PROJECT NO: 2649-160

HUNT ENGINEERS | ARCHITECTS | SURVEYORS
HORSEHEADS, NY 807-265-1000 ROCHESTER, NY 585-537-7868 TOWNAND, PA 570-265-4608
BINGHAMTON, NY 807-798-8081 ALBANY, NY 807-798-8081
WWW.HUNTEAS.COM

NY CERTIFICATE NO. 001620 PA CERTIFICATE NO. TSC2202131464-1

DRAWN BY: CJH			
CHECKED BY: JDA			
DATE: 03/17/2026			
PHASE: CD			
#	DATE:	DESCRIPTION OF REVISION: ISSUED FOR BID	IT IS A VIOLATION OF THE LAW FOR ANY PERSON TO MAKE UNAUTHORIZED ALTERATIONS OR ADDITIONS TO PLANS

GENERAL NOTES - PLUMBING

REFER TO DWG. EV-P0.1

CONSTRUCTION NOTES - PLUMBING

1. CONNECT SINK TO EXISTING COLD WATER, HOT WATER, SANITARY AND VENT PIPING.
INSTALL EXISTING BOTTLE FILLER

DRAWN BY: CJH
CHECKED BY: JDC
DATE: 03/17/2026
PHASE: CD

DESCRIPTION OF REVISION:
ISSUED FOR BID

DATE: 1 10/12/2026

IT IS A VIOLATION OF THE LAW FOR ANY PERSON TO MAKE UNAUTHORIZED ALTERATIONS OR ADDITIONS TO PLANS
DRAWN BY LICENSED SURVEYOR; ARCHITECT'S SIGNATURE REQUIRED.

HUNT ENGINEERS | ARCHITECTS | SURVEYORS

HORSEHEADS, NY 607-258-1000 ROCHESTER, NY 585-537-7849 TOWNANDA, PA 570-265-4666
BINGHAMTON, NY 607-798-8881 ALBANY, NY 607-798-8881
WWW.HUNTEAS.COM

NY CERTIFICATE NO. 001620 PA CERTIFICATE NO. TSC220013464-1

FIRST FLOOR PLANS - AREA D


2025 ERWIN VALLEY ELEM & ADMIN BUILDING ALTERATIONS

CORNING-PAINTED POST AREA SCHOOL DISTRICT


16 BEARTOWN ROAD, PAINTED POST NY 14870

EV-P1.1


PROJECT NO: 2649-160

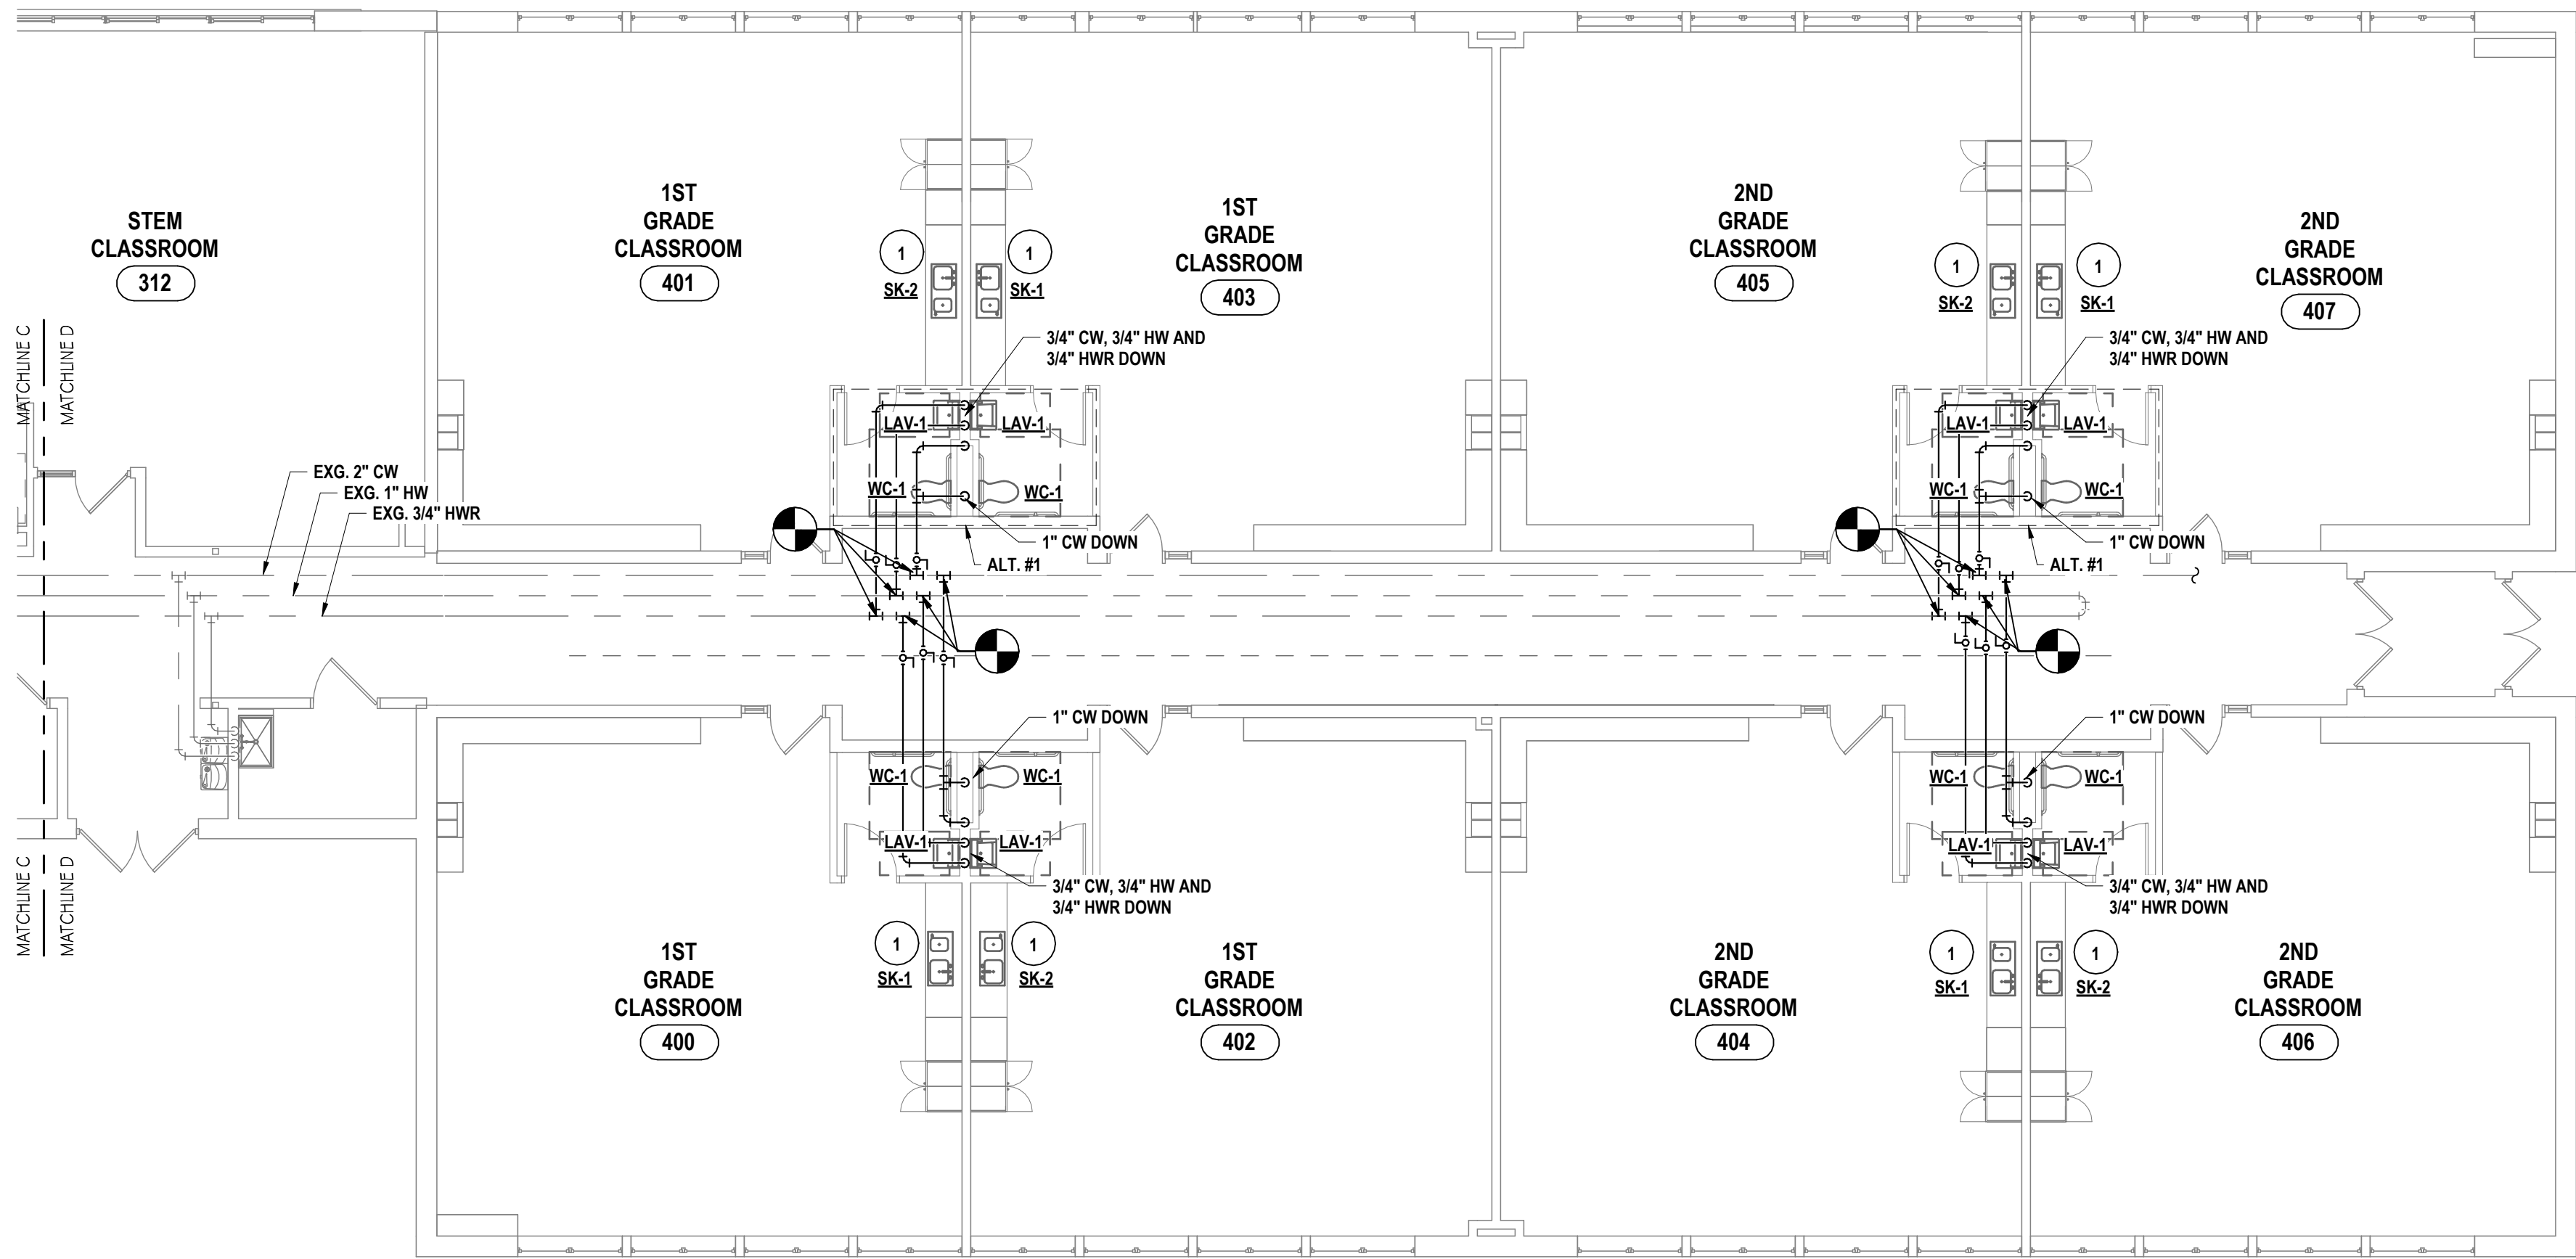


2 FIRST FLOOR DOMESTIC PLAN - AREA D
1/8" = 1'-0"

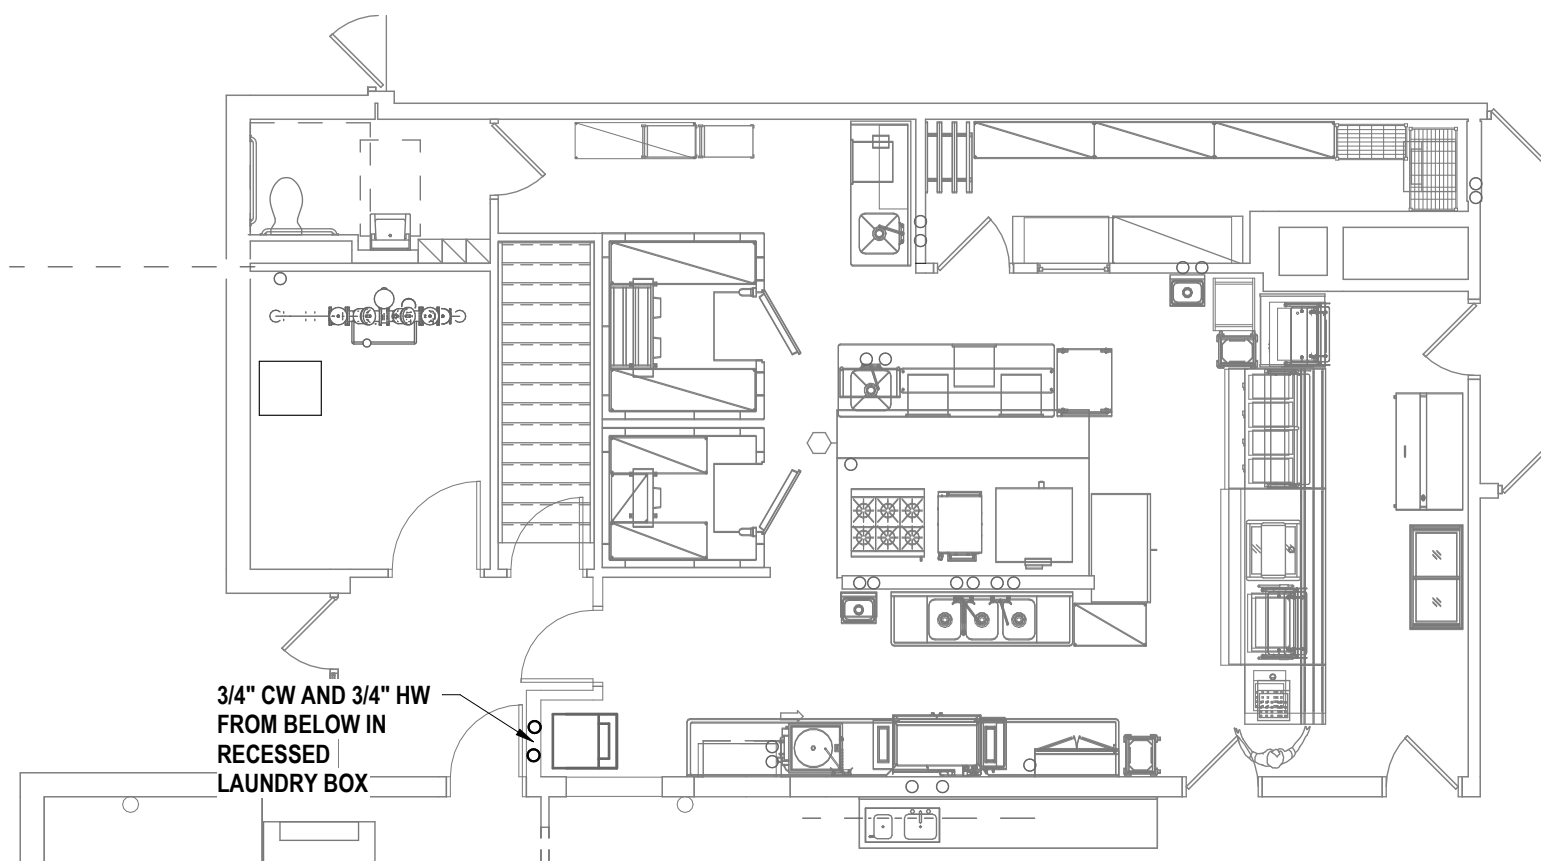


4 KITCHEN DOMESTIC PLAN - AREA B
1/8" = 1'-0"

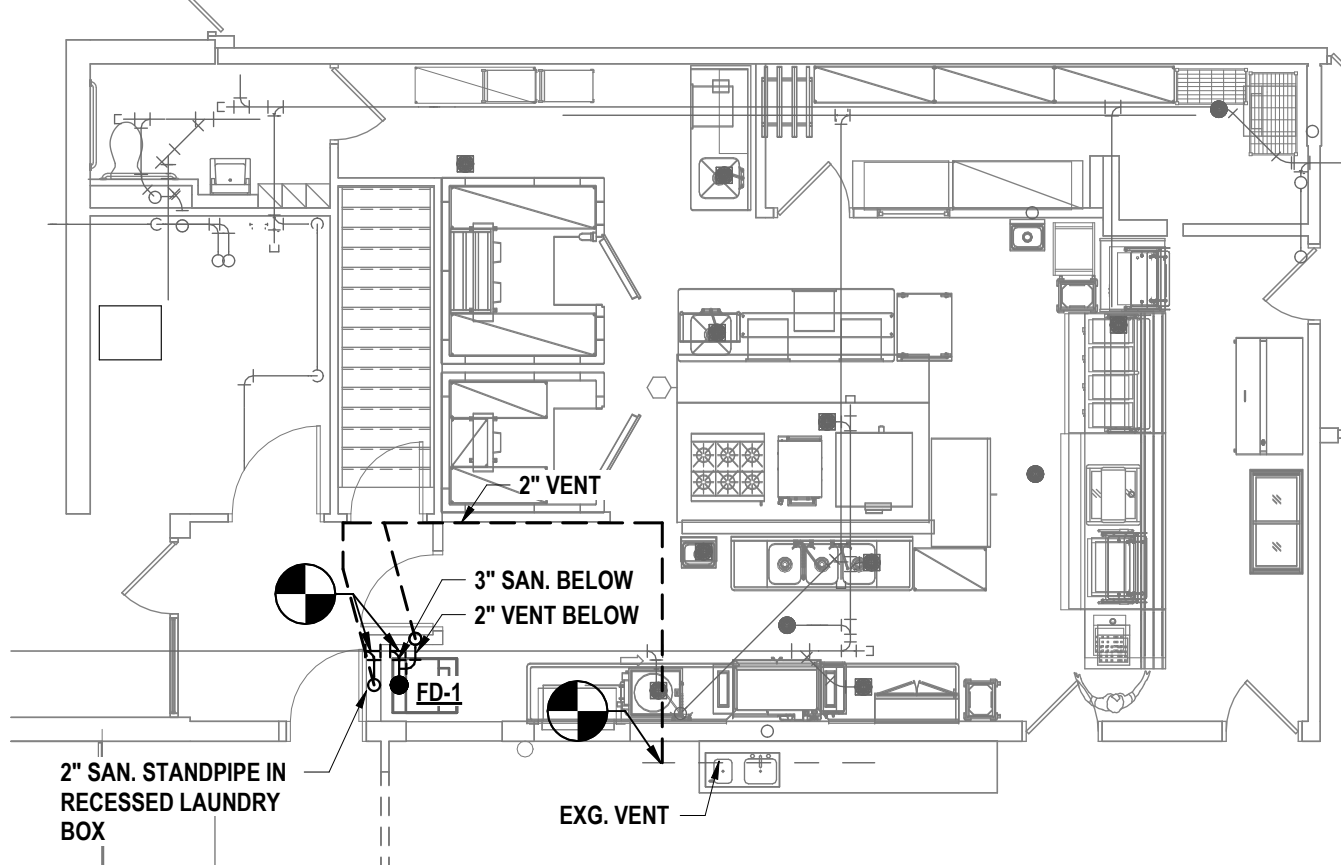

3 KITCHEN SANITARY PLAN - AREA B
1/8" = 1'-0"

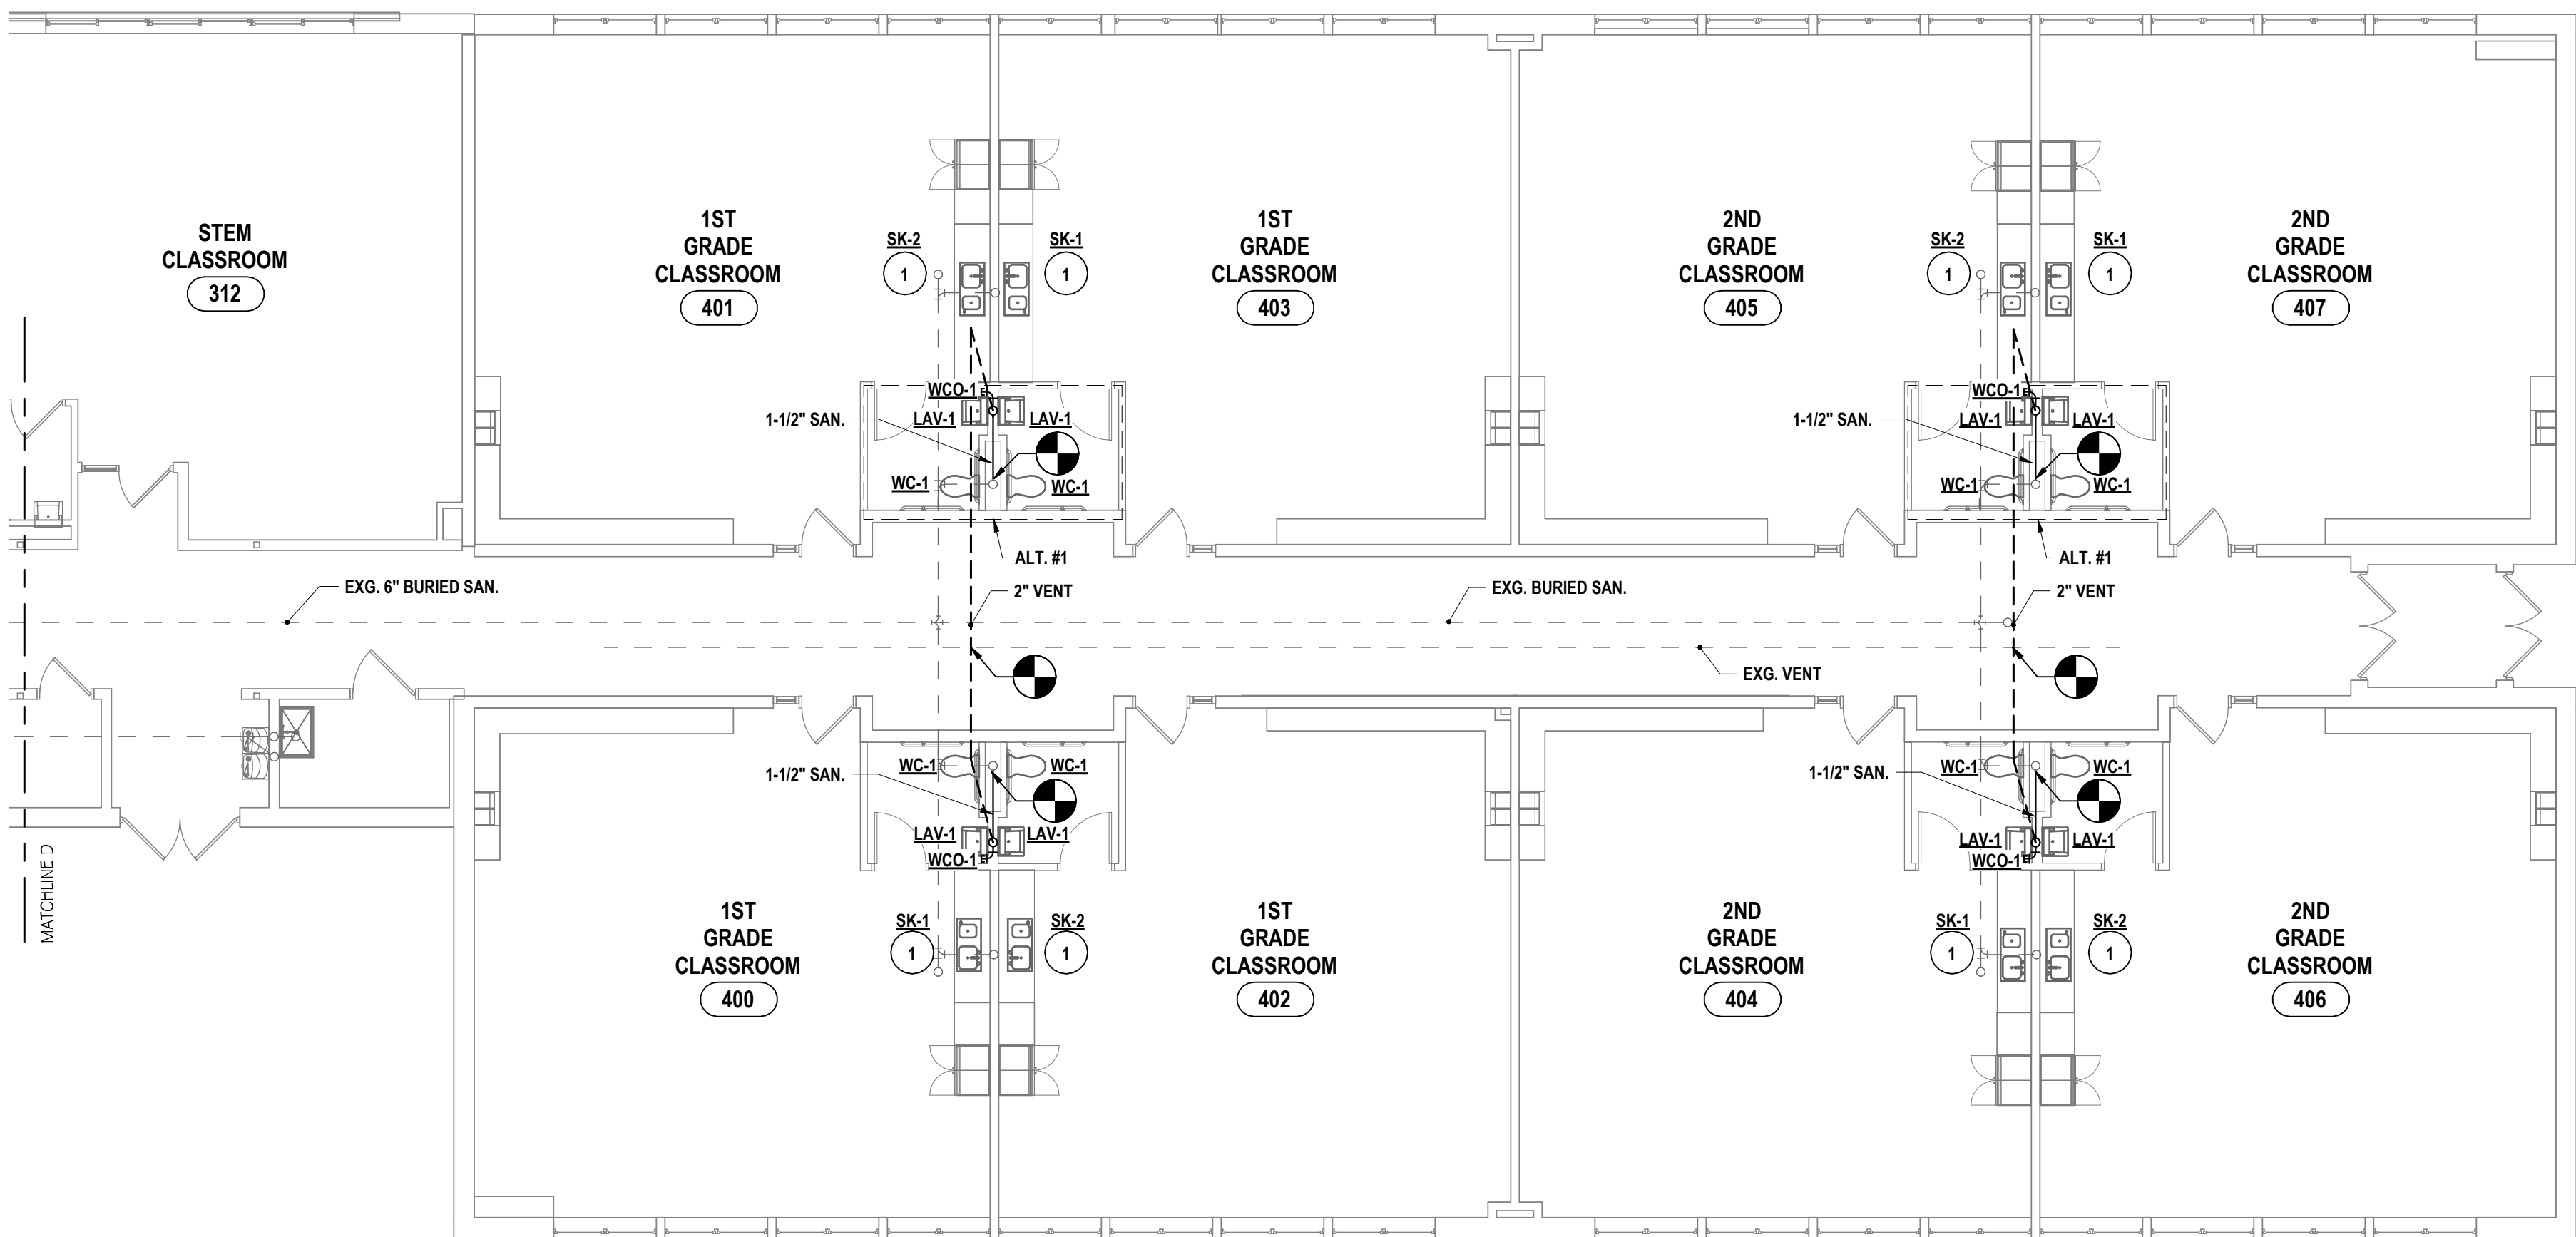

1 FIRST FLOOR SANITARY PLAN - AREA D
1/8" = 1'-0"

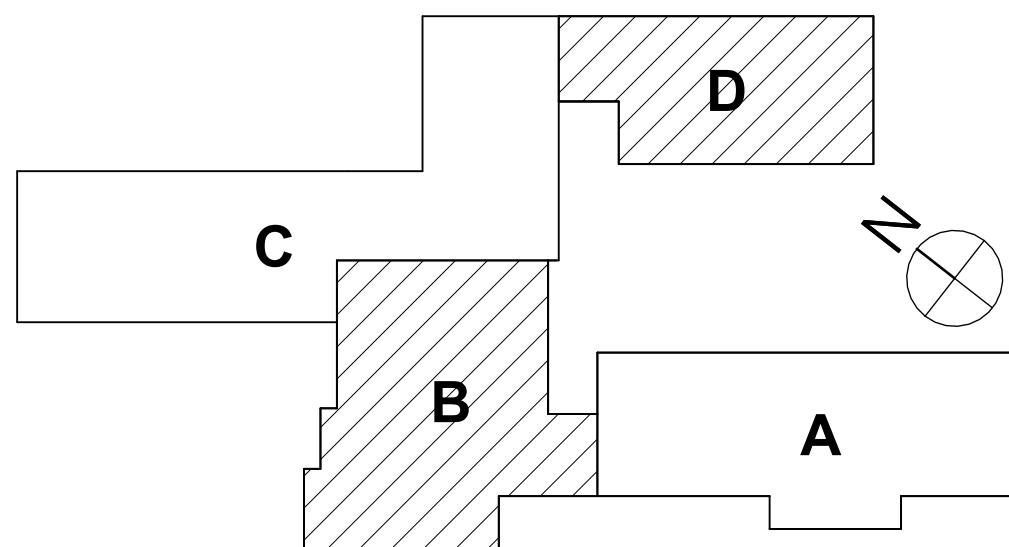



SED NUMBERS EV-1510-00-01-0-009-007, AD-1510-00-01-1-001-013

DRAWN BY: QDW	
CHECKED BY: C.J.H	
DATE: 03/17/2026	
PHASE: CD	
COPY: 1/1	
#	DATE
1	10/12/2026
DESCRIPTION OF REVISION: ISSUED FOR BID	
IT IS A VIOLATION OF THE LAW FOR ANY PERSON TO MAKE UNAUTHORIZED ALTERATIONS OR ADDITIONS TO PLANS DRAWN BY LICENSED SURVEYORS. HUNTERS ARCHITECTS & SURVEYORS, LLC.	

HUNT ENGINEERS | ARCHITECTS | SURVEYORS
HORSEHEADS, NY 607-265-4666
ROCHESTER, NY 585-537-7549
BINGHAMTON, NY 607-798-8881
ALBANY, NY 607-798-8881
WWW.HUNTEAS.COM
NY CERTIFICATE NO. 0016220 PA CERTIFICATE NO. TSC222013/464-1

BASEMENT DOMESTIC PLAN- AREA B
2025 ERWIN VALLEY ELEM & ADMIN BUILDING ALTERATIONS
CORNING-PAINTED POST AREA SCHOOL DISTRICT
16 BEARTOWN ROAD, PAINTED POST, NY 14870

EV-P1.2
PROJECT NO: 2649-160

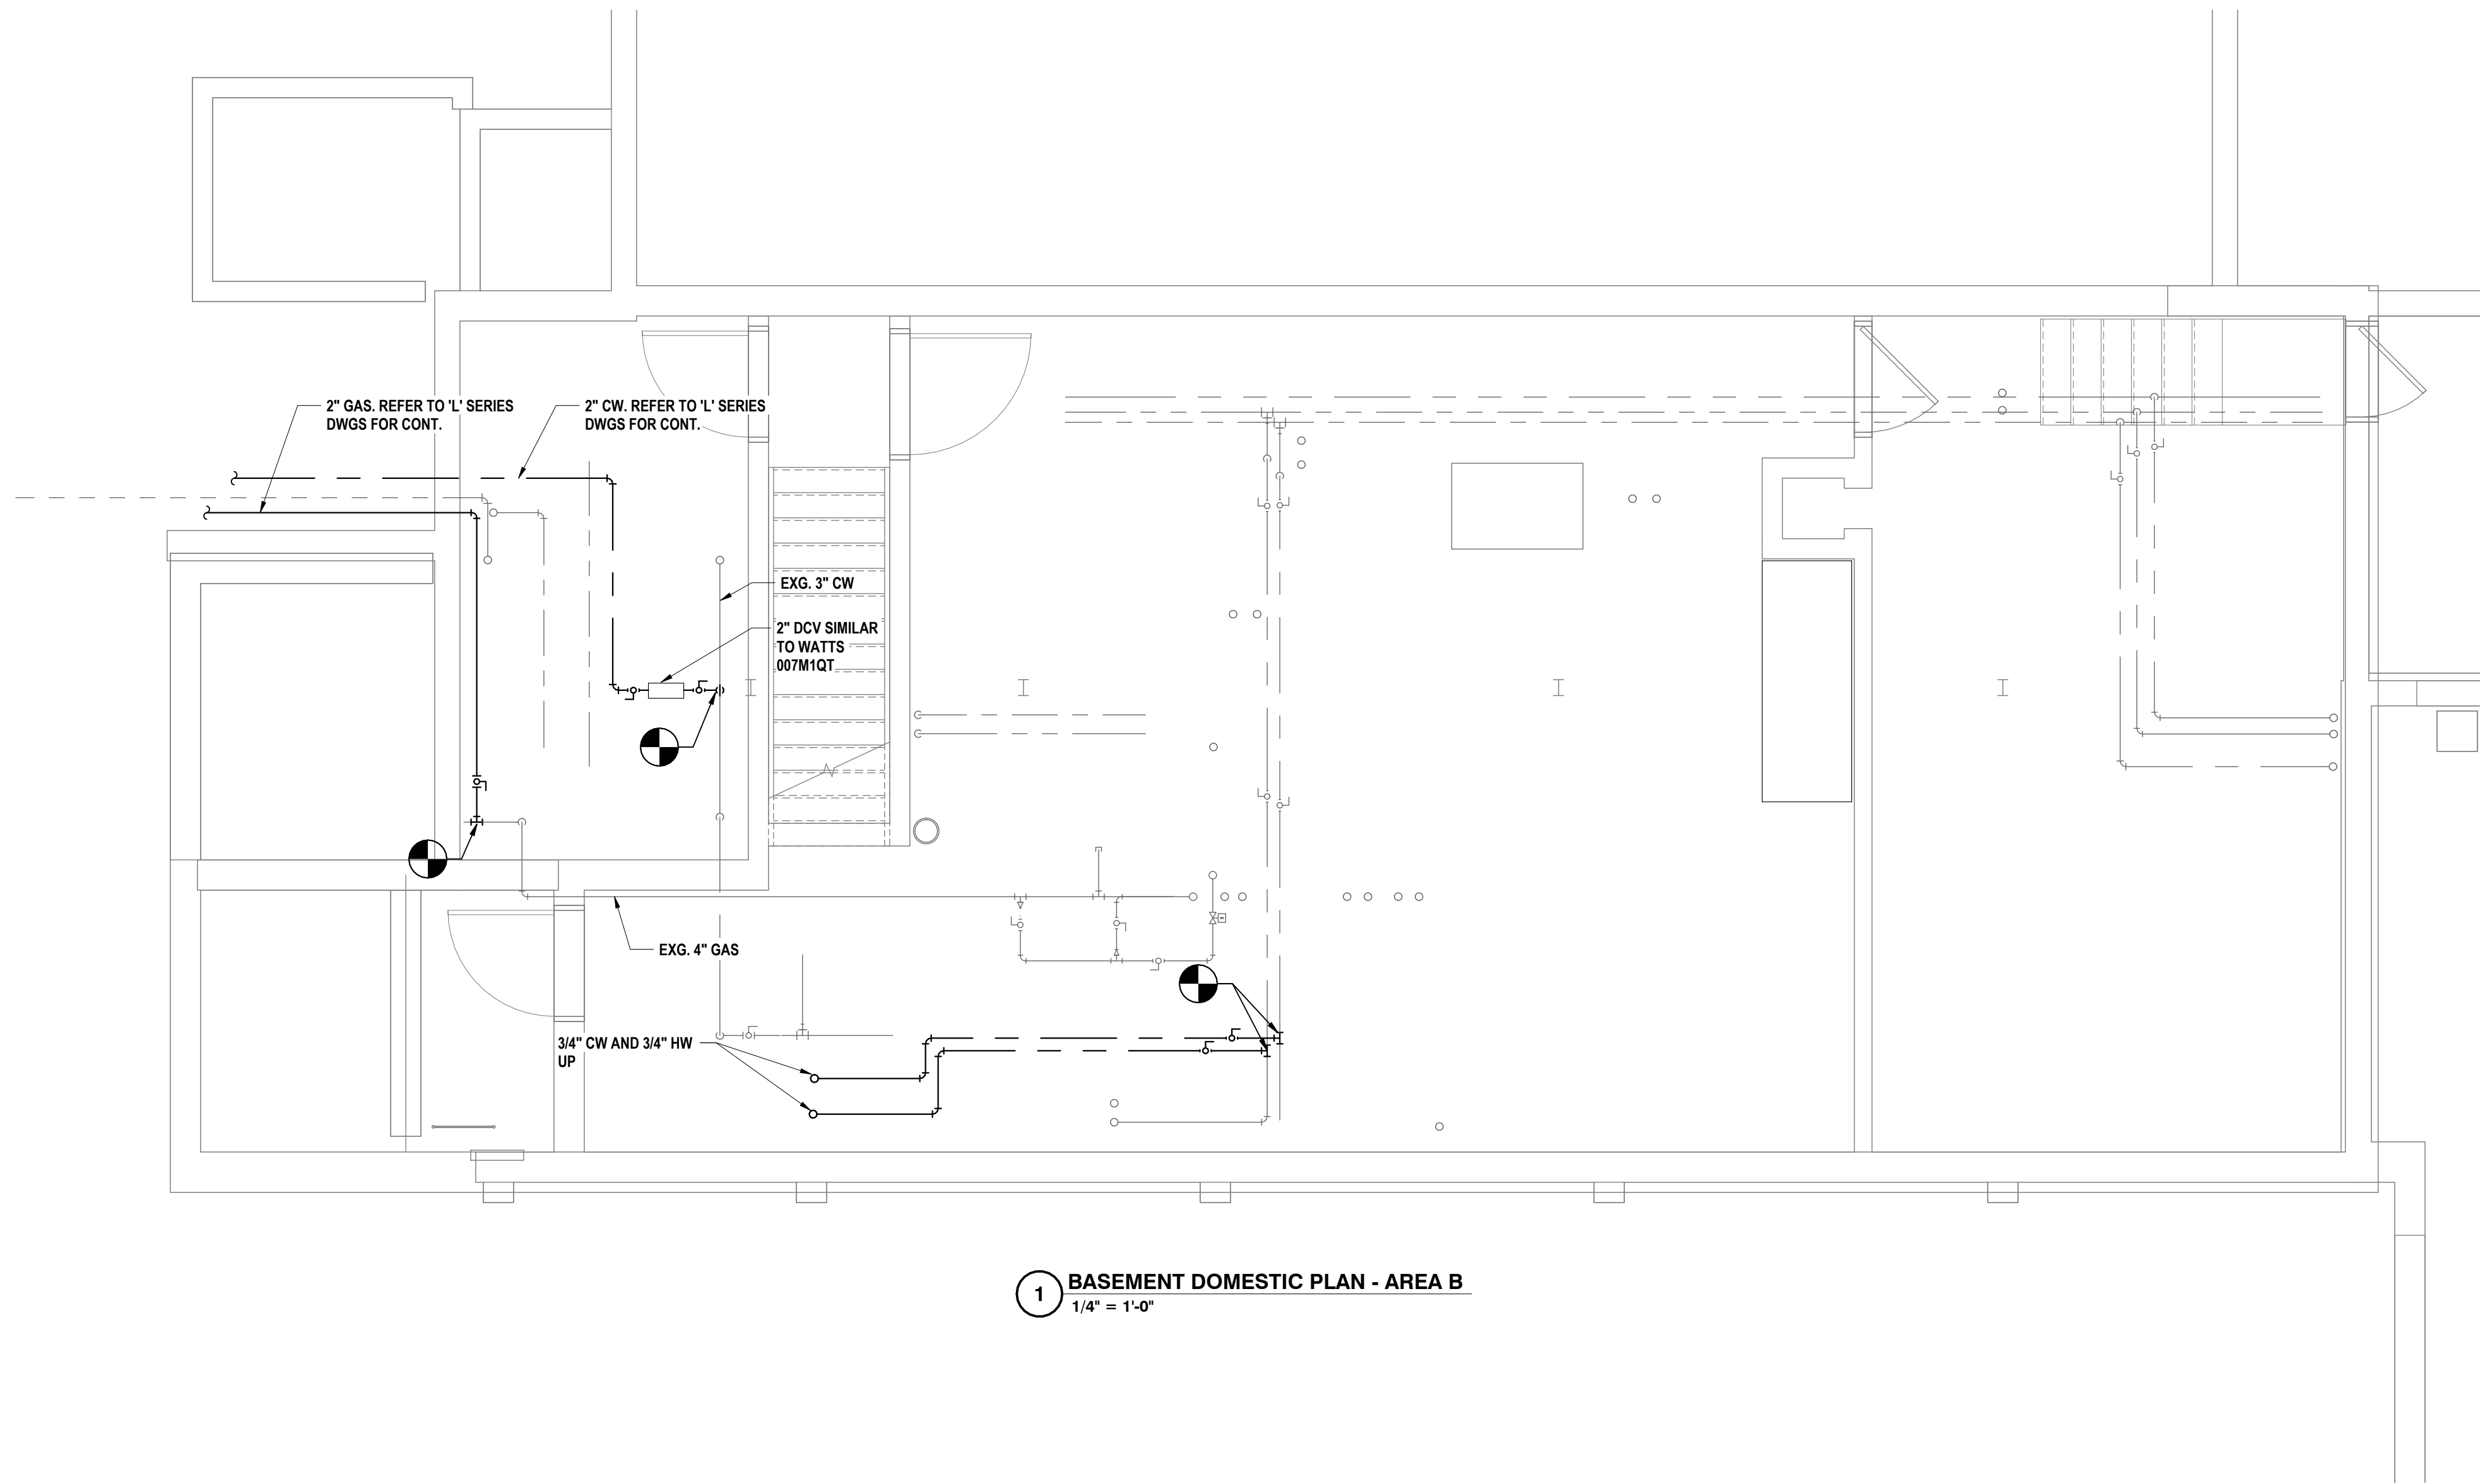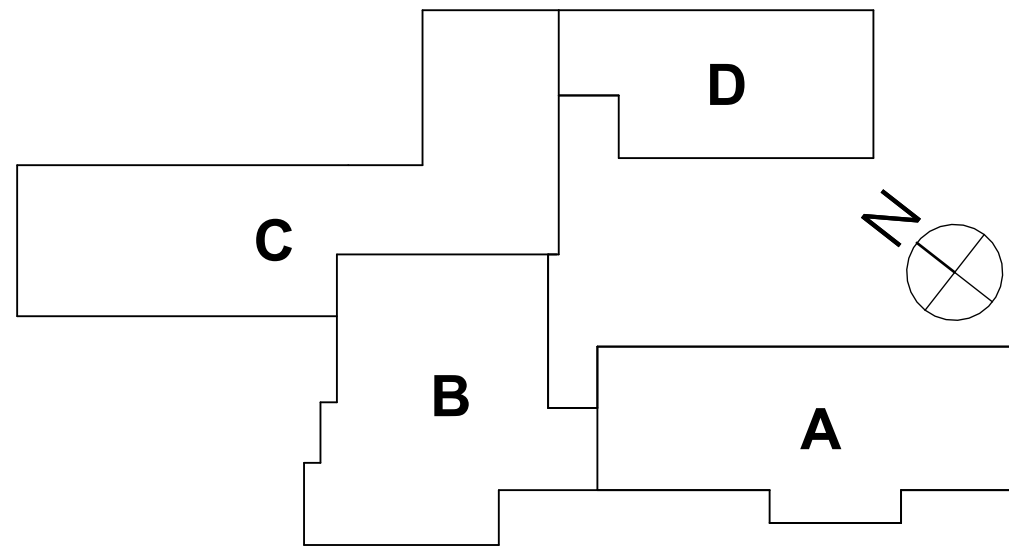

SEE NUMBERS EV-1510-00-01-0-009-027 AD-2716-00-01-1-001-013

PLUMBING FIXTURE ELECTRICAL REQUIREMENTS SCHEDULE												
NO.	TYPE	ELECTRICAL COMPONENT	VOLTS	PHASE	FULL LOAD AMPS	MINIMUM CIRCUIT AMPACITY	MAXIMUM OVER-CURRENT PROTECTION	POWER	RPM	GPM	HEAD FEET	REMARKS
WC-1	WATER CLOSET, ADA, WALL MOUNT	FLUSHOMETER TRANSFORMER	120 OR 240	SINGLE	50 VA	NA	NA	NA	NA	NA	NA	NOTE A, D.
LAV-1	LAVATORY, ADA, WALL MOUNT LAVATORY, WALL MOUNT	FAUCET TRANSFORMER	120	SINGLE	2.0	300 MA	NA	NA	NA	NA	NA	NOTE B, D.

NOTES: A. PROVIDE PER MANUFACTURE, SOLENOID OPERATOR - 24V AC, 60 Hz, TRANSFORMER - SIMILAR TO SLOAN VALVE MODEL EL-154 (120 V). (ONE TRANSFORMER SERVES MAXIMUM 10 WATER CLOSETS/URINALS). COORDINATE TRANSFORMER INSTALLATION, POWER BY AND LOW VOLTAGE CONTROL WIRING.

B. PROVIDE TRANSFORMER - SIMILAR TO CHICAGO FAUCET MODEL 243.260.00.1 (HARD WIRED), (ONE TRANSFORMER SERVES MAXIMUM OF 8 FAUCETS). COORDINATE TRANSFORMER INSTALLATION, POWER, AND LOW VOLTAGE CONTROL WIRING.

C. COORDINATE WIRING OF PUMP THRU AQUASTAT.

FIXTURE PIPE SIZES SCHEDULE				
	COLD WATER	HOT WATER	SANITARY	VENT
WC	1"		4"	2"
LAV	1/2"	1/2"	1-1/2"	1-1/2"
SK	1/2"	1/2"	1-1/2"	1-1/2"

NOTES: A. IF FIXTURE NUMBER IS NOT SPECIFICALLY STATED, PIPE SIZES PERTAIN TO ALL LISTINGS OF FIXTURE TYPE.

PLUMBING FIXTURE SCHEDULE				
NO.	TYPE	MFG./MODEL	TRIM	REMARKS
WC-1	WATER CLOSET, WALL MOUNT, ADA COMPLIANT, COLOR: WHITE	AMERICAN STANDARD 2257.101, 1.28 GPF, 1-1/2 INCH TOP SPUD	FLUSH VALVE: SENSORED (ELECTRIC) SLOAN ROYAL OPTIMA 111-1.28 ESS - TMO, 1.28 GPF, WITH TRUE MECHANICAL OVERRIDE FLUSH BUTTON	
LAV-1	LAVATORY, WALL MOUNT, ADA COMPLIANT, COLOR: WHITE	AMERICAN STANDARD 0355.012 (3 HOLES ON 2" CENTERS)	FAUCET: SENSORED (ELECTRIC) SLOAN ETF-600, 0.50 GPM	PROVIDE METERING HANDLES, GRID DRAIN, P-TRAP, LEAD FREE SUPPLIES, LEAD FREE STOPS & ESCUTCHEON PLATES. PROVIDE OFFSET GRID DRAIN AND PIPE COVERS FOR ADA. SEE 'A' DRAWINGS FOR MOUNTING HEIGHT. NOTE C.
WCO-1	WALL CLEANOOUT	ZURN Z1446		PROVIDE ACCESS COVER.
SK-1	ADA COMPLIANT SINK & FOUNTAIN BASIN, SINK - 16" W X 11-1/2" L X 5-1/2" D, BASIN - 9-1/2" W X 12-1/2" L X 3-1/2" D, LEFT SIDE BOTTLE FILLER, COUNTERTOP MOUNT	JUST DCR-ADA-1737-A-GR-L (SINK & FOUNTAIN BASIN ARE SEPARATED BY A MINIMUM OF 6")	FAUCET: MANUAL, CHICAGO 786-E3ABCP, 2.20 GPM, BOTTLE FILLER: EXISTING STRAINER: JUST J-ADA-15 & J-ADA-35	PROVIDE 4" WRISTBLADE HANDLES, OFFSET GRID DRAIN, P-TRAP, LEAD FREE SUPPLIES, LEAD FREE STOPS & ESCUTCHEON PLATES. LOCATE DRAIN MINIMUM ONE INCH TO REAR OF SINK CENTERLINE.
SK-2	ADA COMPLIANT SINK & FOUNTAIN BASIN, SINK - 16" W X 11-1/2" L X 5-1/2" D, BASIN - 9-1/2" W X 12-1/2" L X 3-1/2" D, RIGHT SIDE BOTTLE FILLER, COUNTERTOP MOUNT	JUST DCR-ADA-1737-A-GR-R (SINK & FOUNTAIN BASIN ARE SEPARATED BY A MINIMUM OF 6")	FAUCET: MANUAL, CHICAGO 786-E3ABCP, 2.20 GPM, BOTTLE FILLER: EXISTING STRAINER: JUST J-ADA-15 & J-ADA-35	PROVIDE 4" WRISTBLADE HANDLES, OFFSET GRID DRAIN, P-TRAP, LEAD FREE SUPPLIES, LEAD FREE STOPS & ESCUTCHEON PLATES. LOCATE DRAIN MINIMUM ONE INCH TO REAR OF SINK CENTERLINE.
FD-1	FLOOR DRAIN, WITH TRAP PRIMER	ZURN ZN-415-B-P	FLUSH WITH FLOOR	PROVIDE NICKEL BRONZE STRAINER. REFER TO PLAN FOR PIPE SIZE. PROVIDE 1/2 INCH TRAP PRIMER CONNECTION. NOTE D, E.

NOTES:

A. REFER TO PLUMBING FIXTURE ELECTRICAL REQUIREMENTS SCHEDULE.


B. PROVIDE LOW LEAD CONTENT THERMOSTATIC MIXING VALVE SIMILAR TO CHICAGO FAUCET MODEL 122-ABNF (SERVES MAXIMUM 8 FAUCETS).


C. PROVIDE CONCEALED ARM FIXTURE SUPPORT FOR NEW LAVATORY WITH UPRIGHT WELDED FEET AND ADJUSTABLE HEADERS, INSTALLED WITHIN WALL / CHASE.

D. VERIFY LOCATION OF FLOOR DRAIN / FLOOR SINK / FLOOR CLEANOOUT APPLY CORRECT APPLICATION, RECESSED FOR TILE, RECESSED FOR TERRAZZO.


E. PROVIDE TRAP PRIMER VALVE SIMILAR TO PRECISION PLUMBING PRODUCT MODEL P FOR FLOOR DRAIN AND FLOOR SINK AND CONNECT VALVE TO NEAREST ACCESSIBLE COLD WATER PIPING. VALVE MUST BE INSTALLED A MINIMUM OF 12 INCHES ABOVE FINISHED FLOOR. PROVIDE PIPING FROM VALVE TO FLOOR DRAIN / FLOOR SINK PER VALVE MANUFACTURERS INSTALLATION INSTRUCTIONS.

F. CONTRACTOR TO EXCAVATE AND PREPARE AREA, MIX AND APPLY FORM RELEASE PRODUCT, ASSEMBLE RAILS, LEGS, FORMS, CLAMPS AND PLACE COMPLETED TRENCH COMPONENTS AT REQUIRED LOCATIONS. CONTRACTOR TO PROVIDE CONCRETE ANCHORING SLAB WALL TO WALL AND END TO END IN BOTTOM OF EXCAVATION COVERING TRENCH DRAIN ULEGS WITH MINIMUM OF 2 INCHES OF CONCRETE. COORDINATE FINISHED FLOOR CONCRETE POUR. CONTRACTOR TO REMOVE ALL FORM MATERIAL FROM TRENCH DRAINS AFTER FINISHED FLOOR CONCRETE HAS DRIED AND INSTALL ALL GRATES. ALL TRENCH DRAIN WORK SHALL BE INSTALLED PER TRENCH DRAIN MANUFACTURERS INSTALLATION INSTRUCTIONS.

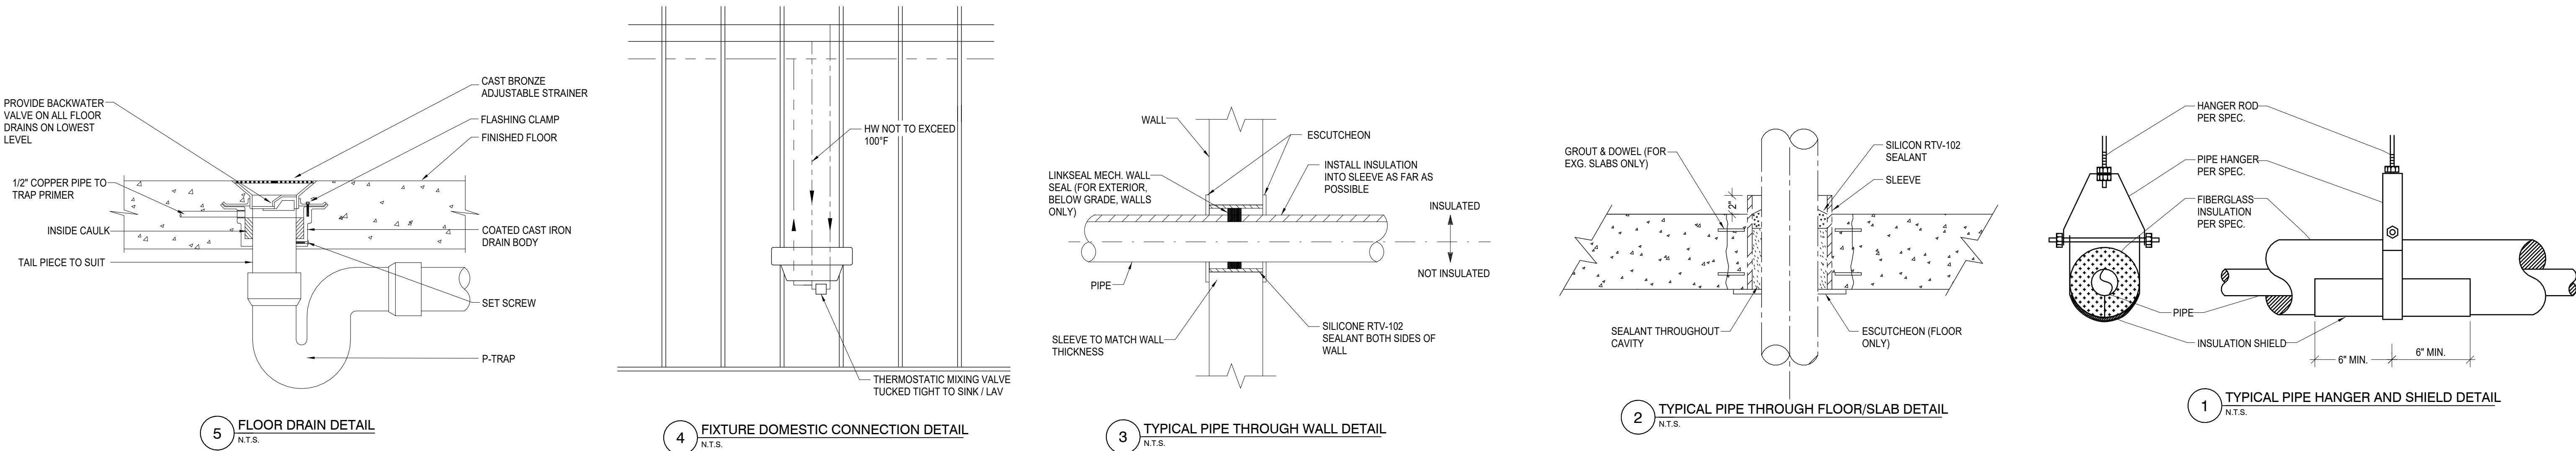


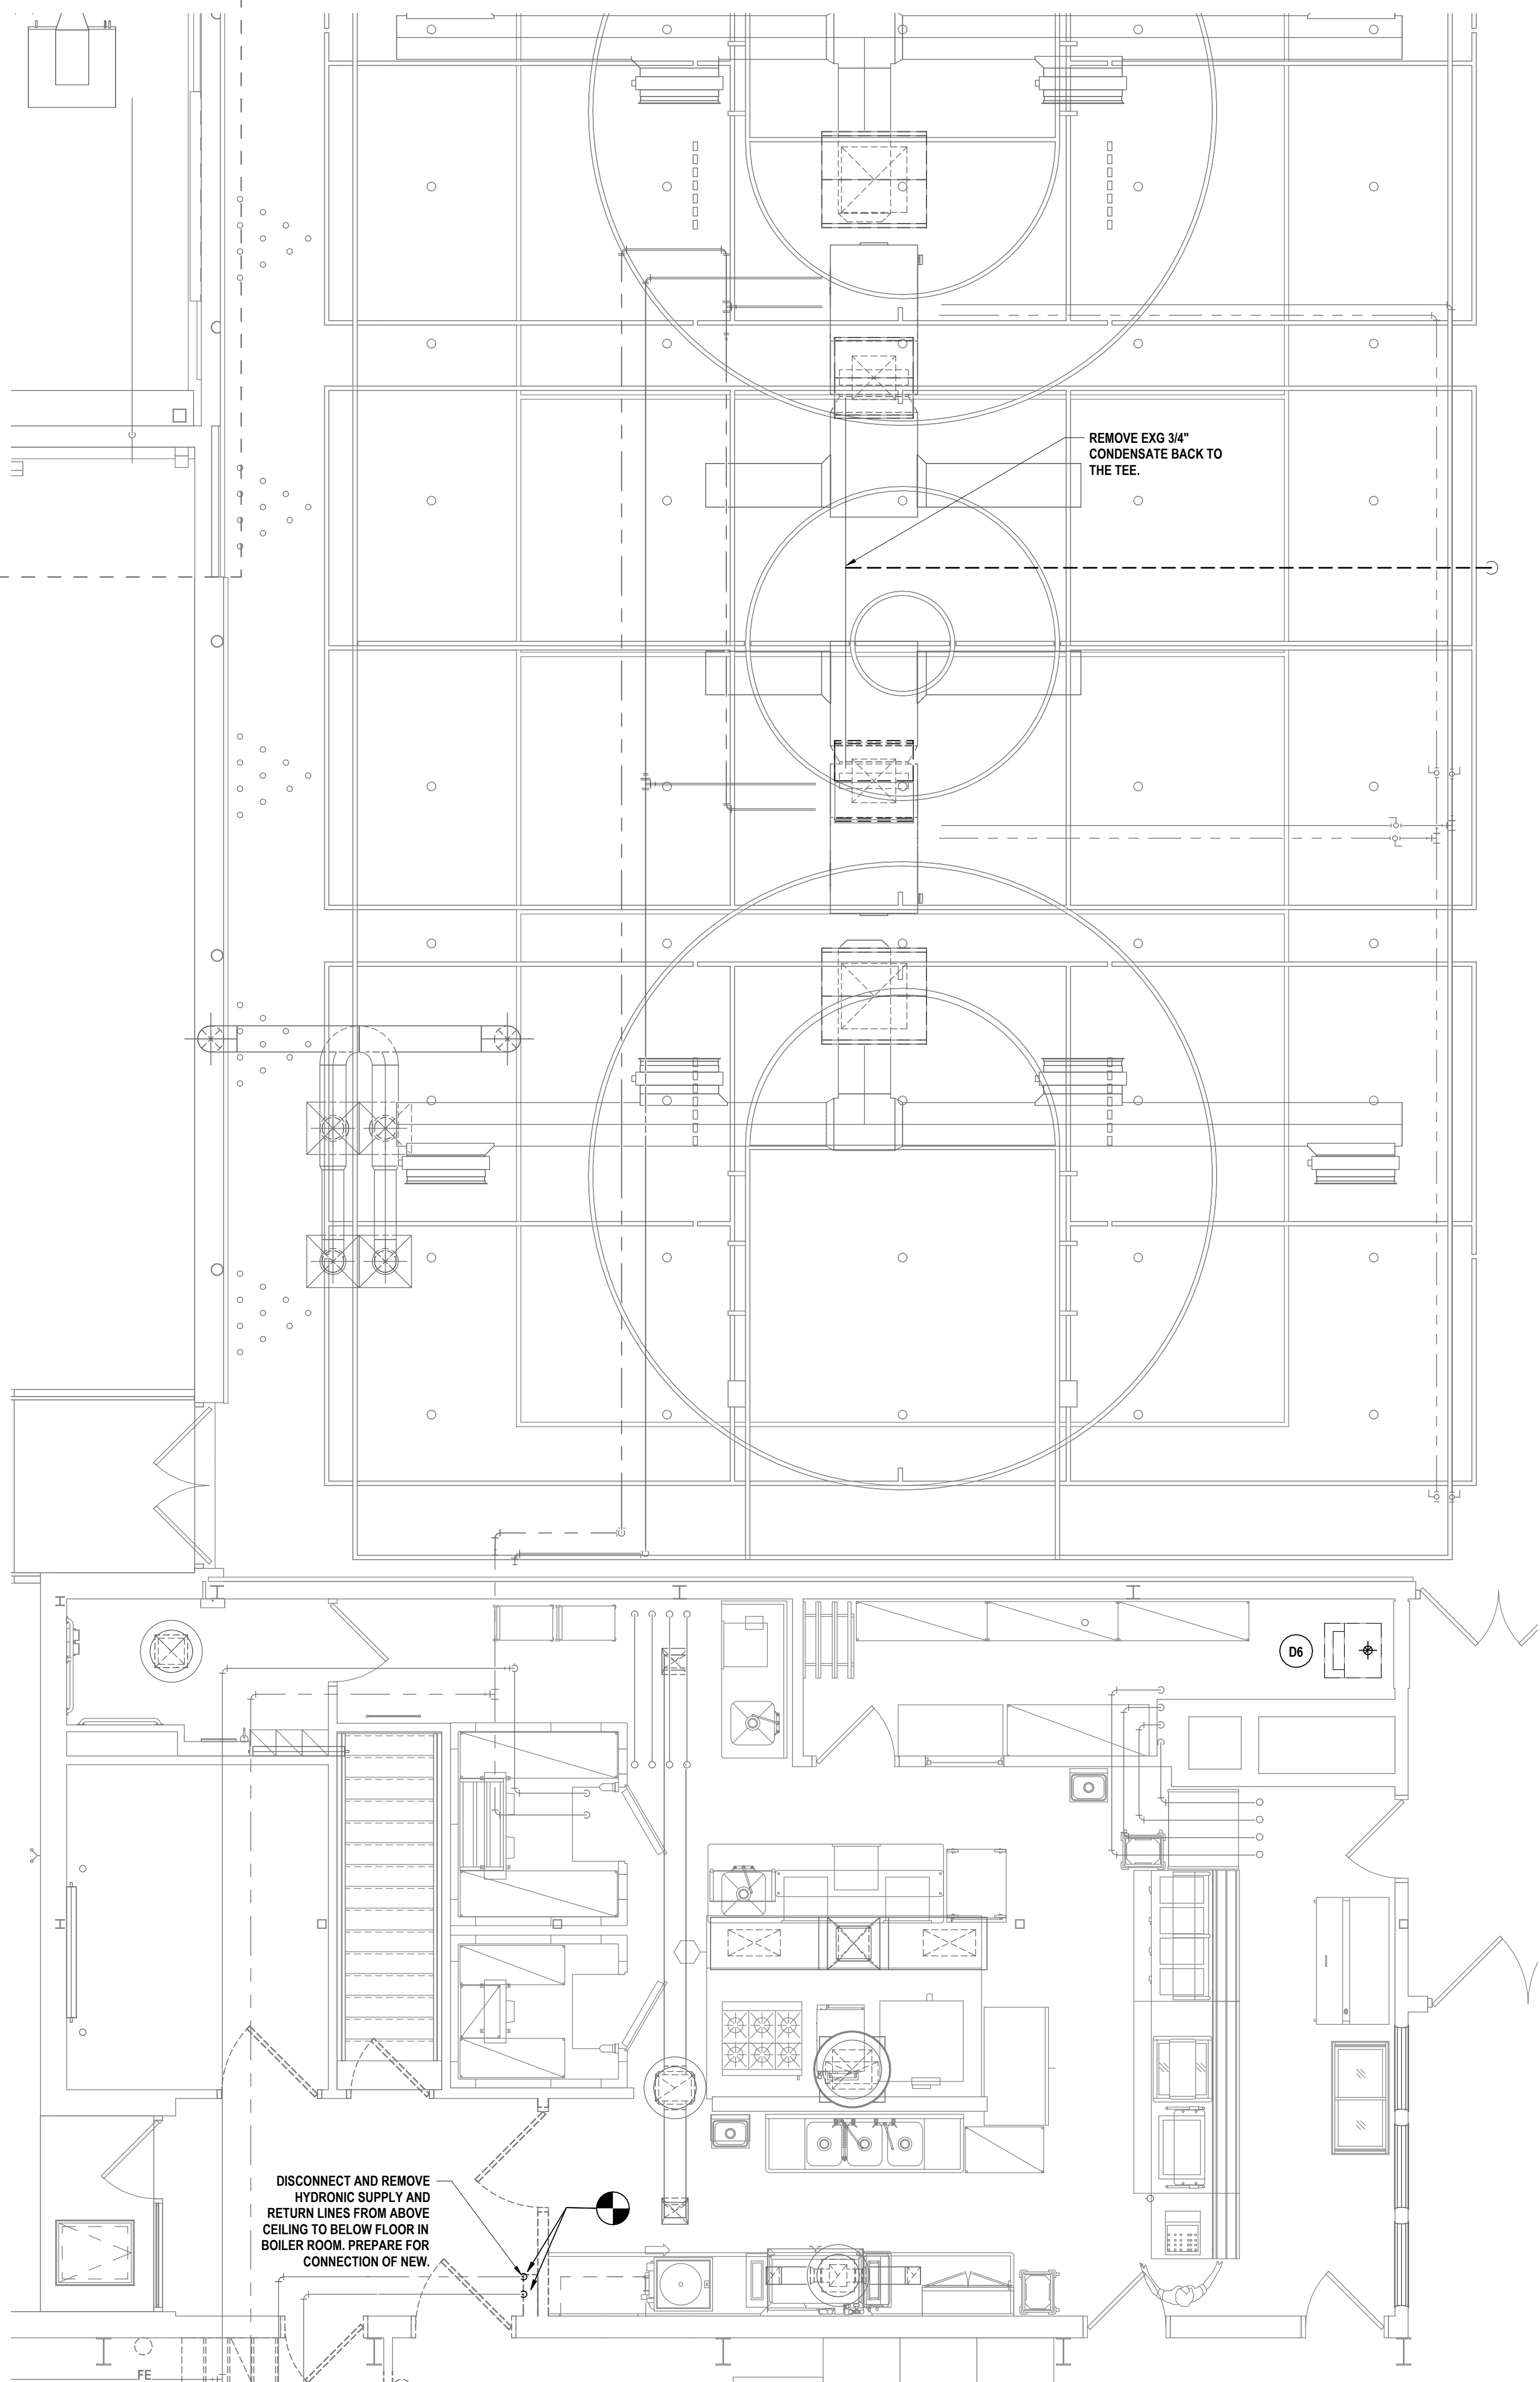


2 FIRST FLOOR HVAC DEMOLITION PLAN - AREA B
1/4" = 1'-0"

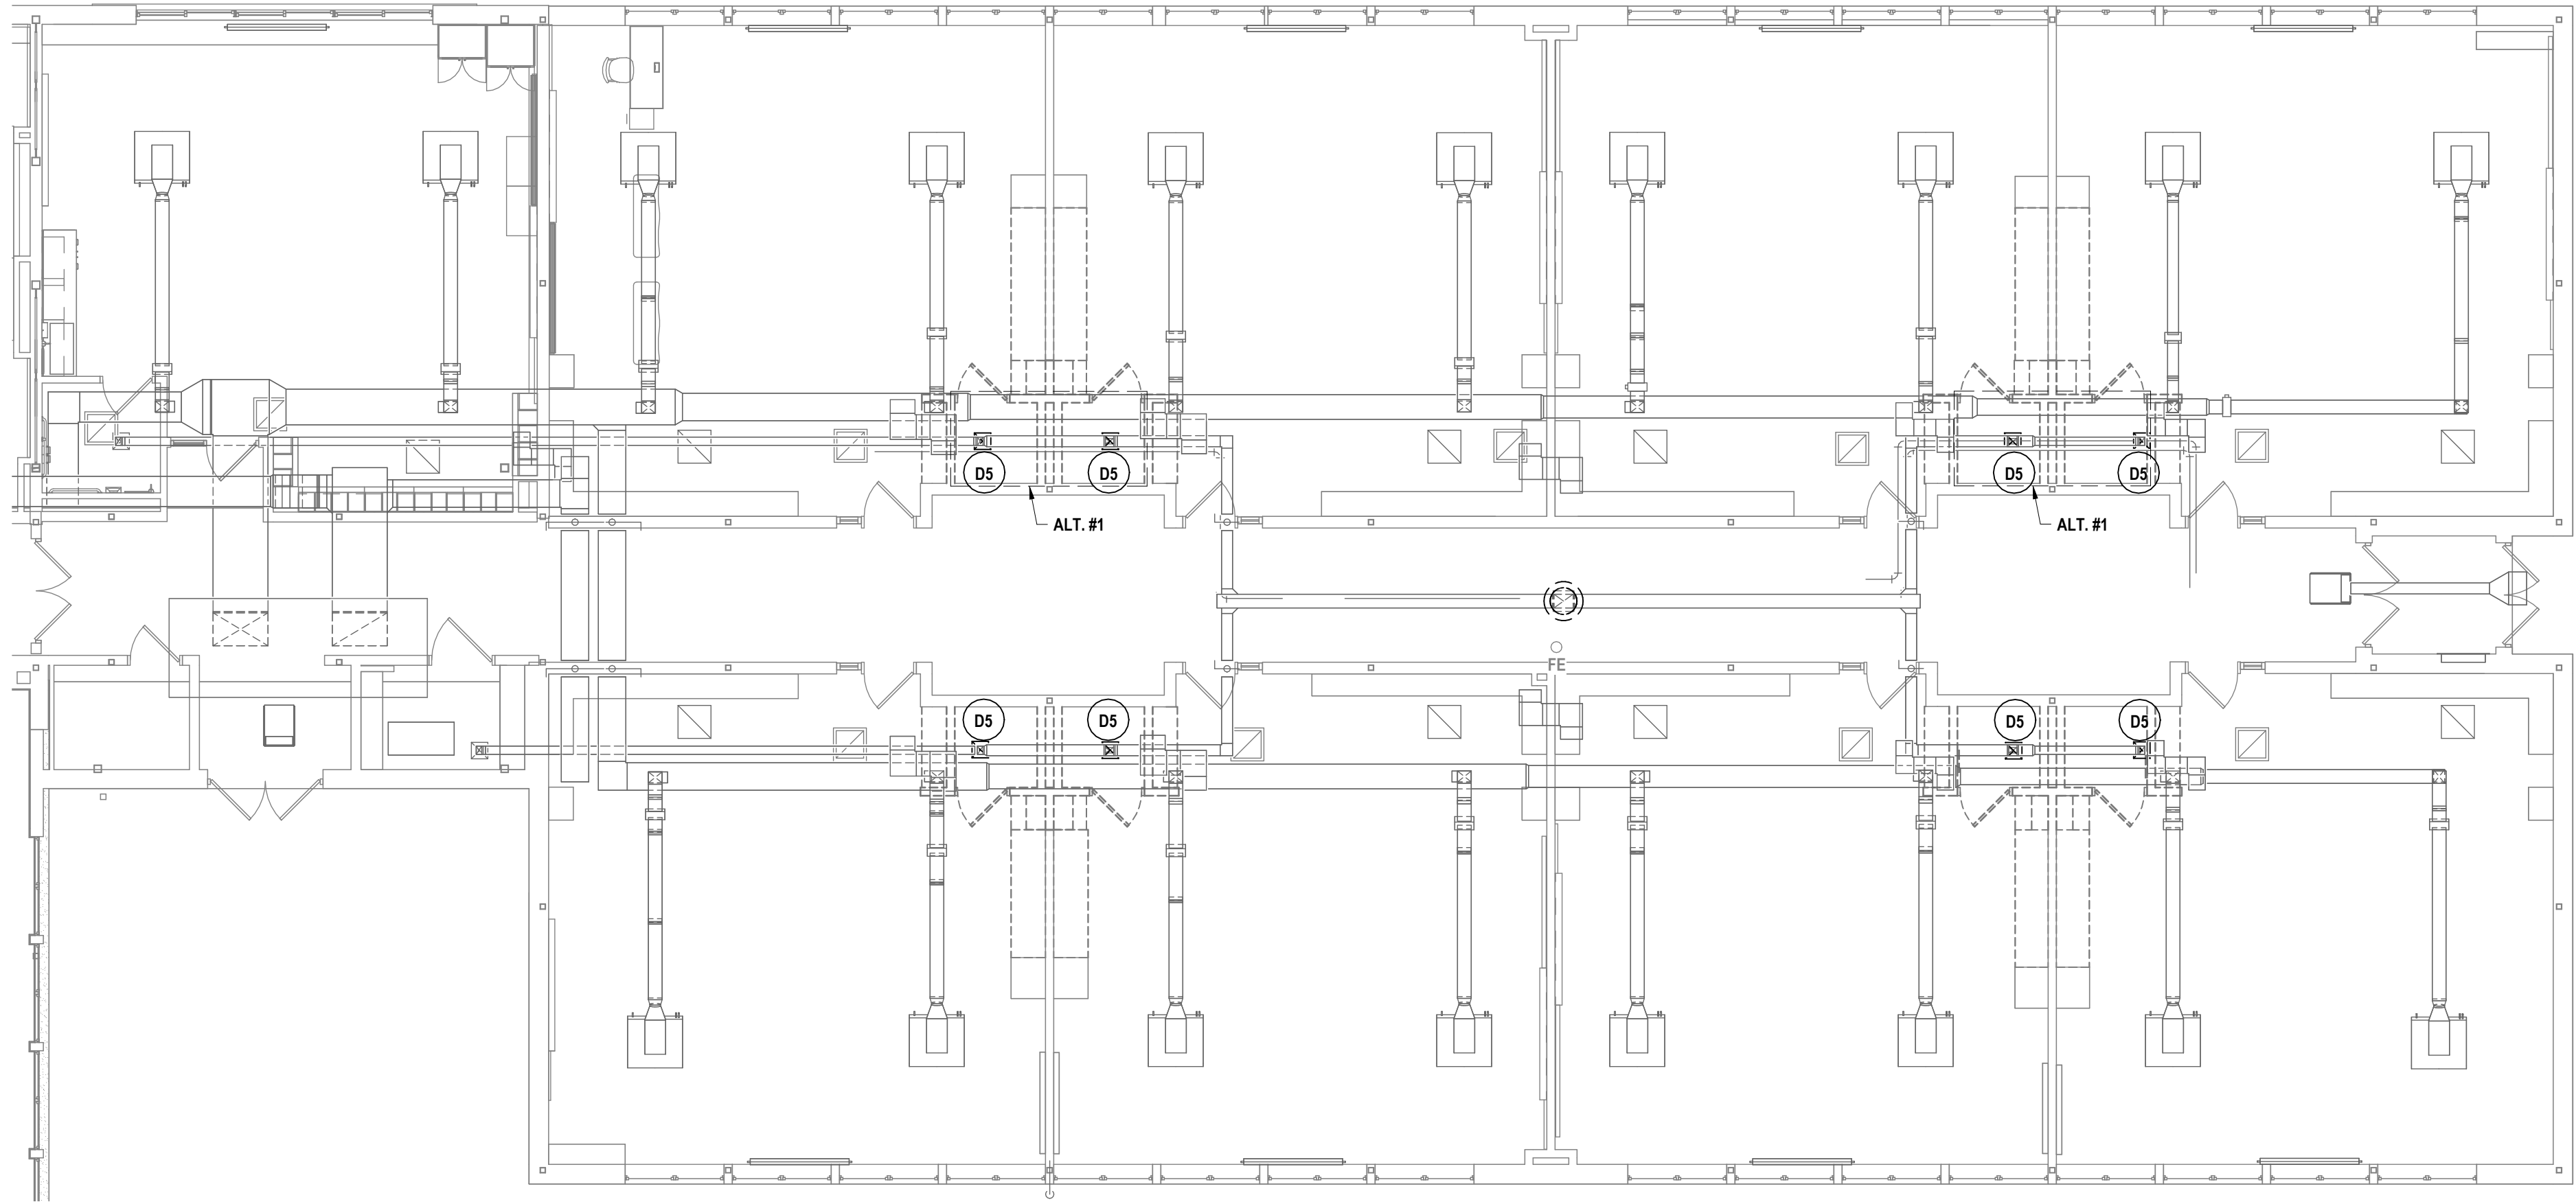

1 FIRST FLOOR HVAC DEMOLITION PLAN - AREA D
1/8" = 1'-0"

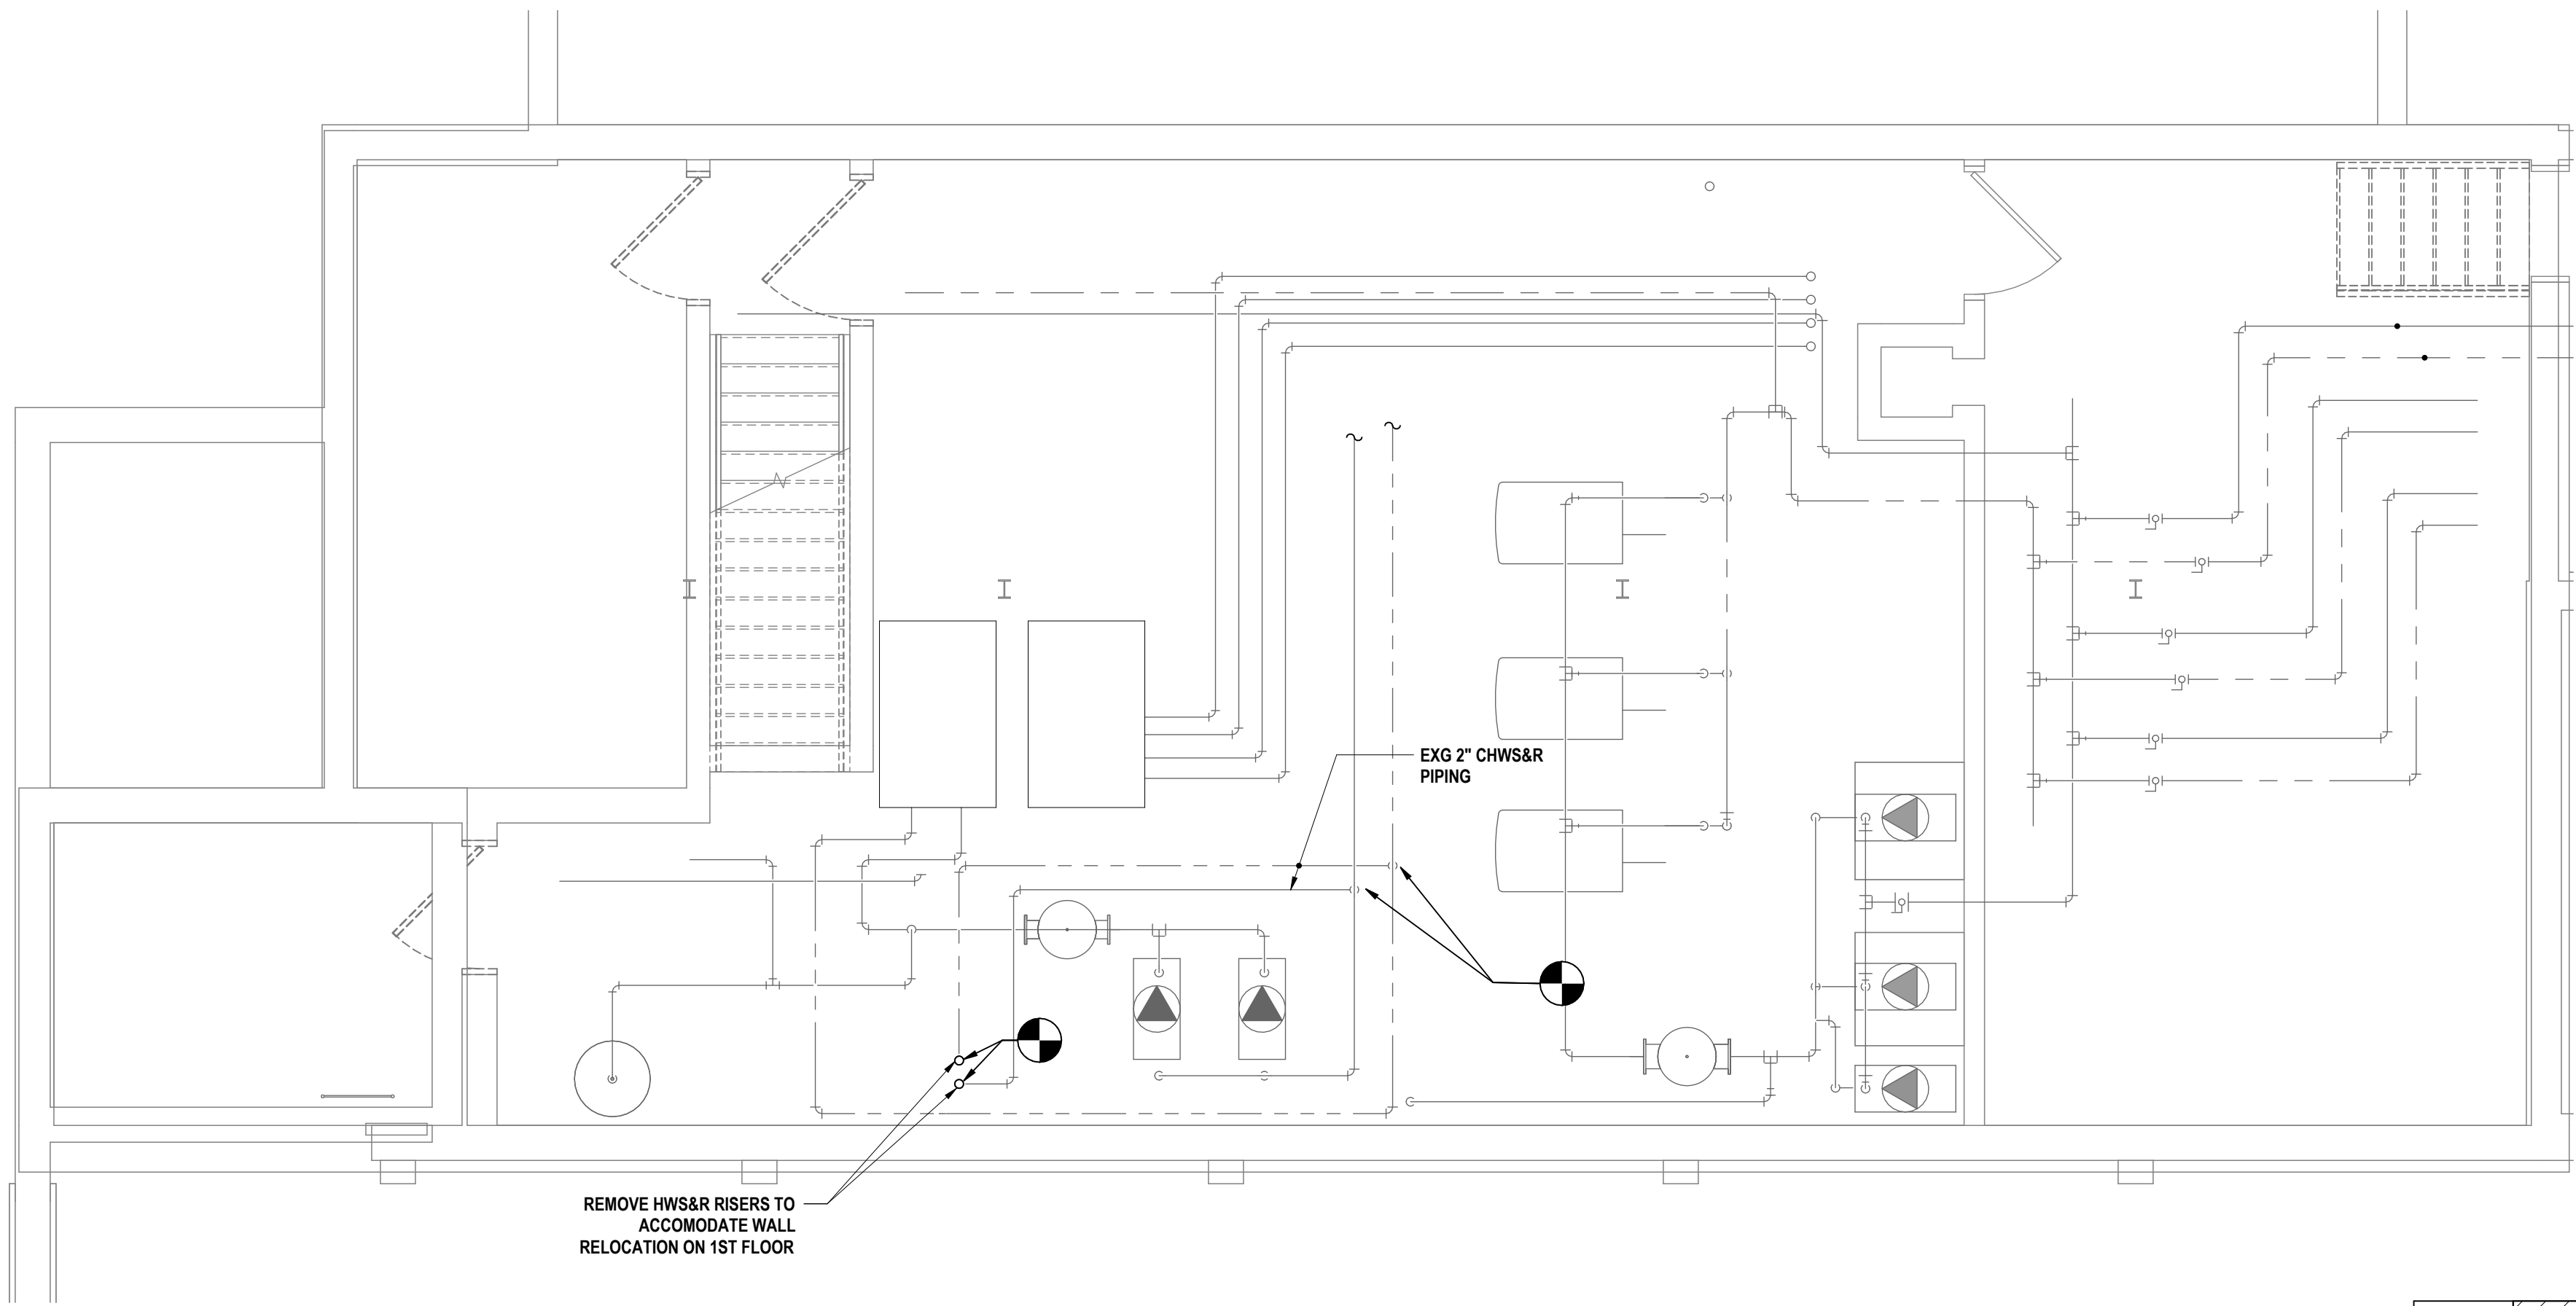

3 BASEMENT PIPING DEMOLITION PLAN - AREA B
1/4" = 1'-0"

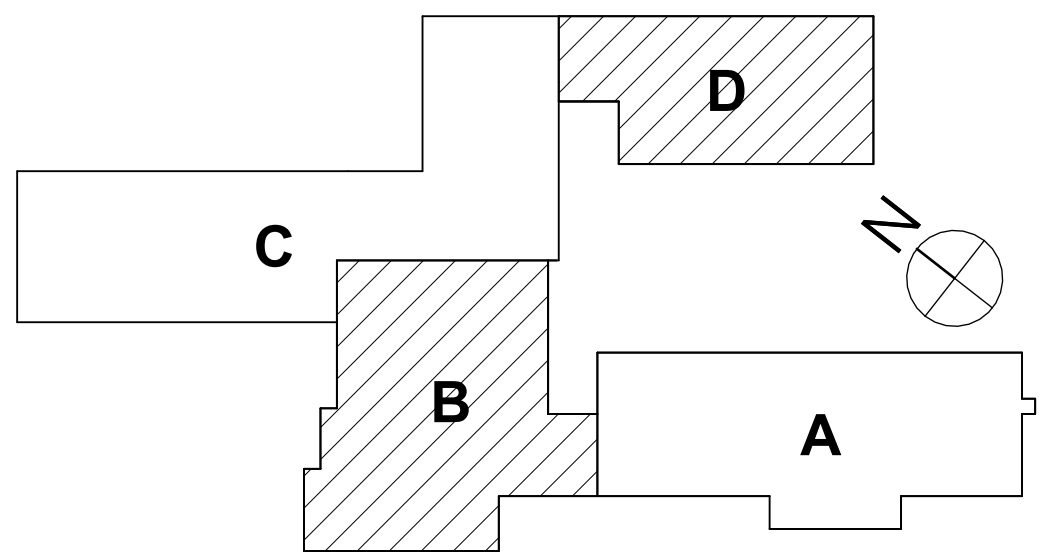

GENERAL NOTES - MECHANICAL

- A ALL WORK ON THIS DRAWING IS THE RESPONSIBILITY OF THE HEATING CONTRACTOR UNLESS CLEARLY INDICATED TO BE PART OF ANOTHER PRIME CONTRACT.
- B THIS DRAWING IS INTENDED TO SHOW THE GENERAL SCOPE OF ITEMS TO BE REMOVED. IT IS NOT INTENDED TO BE ALL INCLUSIVE. THE CONTRACTOR SHALL FIELD VERIFY ALL ITEMS TO BE REMOVED. ANY ITEM IN QUESTION SHOULD BE VERIFIED WITH THE ENGINEER PRIOR TO REMOVAL.
- C ALL ITEMS SCHEDULED FOR DEMOLITION ARE THE PROPERTY OF THE OWNER. THE CONTRACTOR SHALL PLACE WANTED EQUIPMENT IN AREA DESIGNATED, ON SITE BY THE OWNER. ANY ITEM THE OWNER WISHES NOT TO KEEP SHALL BE DISPOSED OF BY THE CONTRACTOR.
- D THE CONTRACTOR WILL BE RESPONSIBLE FOR ALL CUTTING AND PATCHING UNLESS CLEARLY INDICATED TO BE PART OF ANOTHER PRIME CONTRACT. CONTRACTOR TO PATCH TO MATCH THE CONTRACTOR SHALL REMOVE, PROTECT, REPLACE AND/OR REINSTALL ANY CEILING OR GRID DAMAGED OR REMOVED AS A RESULT OF WORK INDICATED ON THESE DRAWINGS.
- E REINSULATE ALL PORTIONS OF EXISTING HVAC SYSTEMS DISTURBED DURING INSTALLATION OF NEW SYSTEMS.
- F PRIOR TO CONSTRUCTION AND INSTALLATION OF NEW WORK, THE CONTRACTOR SHALL FIELD VERIFY ALL EXISTING CONDITIONS (FRAMING, ELECTRICAL, PLUMBING, HVAC, ETC.). NOTIFY ARCHITECT/ENGINEER OF ANY CONFLICTS THAT REQUIRE MODIFICATION TO NEW HVAC SYSTEM INSTALLATION.
- G COORDINATE ALL NEW ROOF, WALL, AND FLOOR PENETRATIONS WITH OTHER TRADES.
- H CONTRACTOR IS RESPONSIBLE FOR INSTALLATION OF EXTERIOR LOUVERS. G.C. TO CAULK.
- I IN PLENUM RETURN SYSTEMS WHERE NO TRANSFER DUCT IS SHOWN, VERIFY IF WALL GOES TO DECK. IF WALL GOES TO DECK PROVIDE OPENING IN WALL TO ALLOW AIR TO TRANSFER ABOVE CEILING BACK TO UNIT.

DEMOLITION NOTES - MECHANICAL

- D1 DISCONNECT AND REMOVE ROOF MOUNTED HOOD. RETAIN FOR REINSTALLATION UP COMPLETION OF ROOF WORK.
- D2 NOT USED.
- D3 DISCONNECT AND REMOVE ACCU. RETAIN FOR REINSTALLATION UPON COMPLETION OF ROOF WORK.
- D4 DISCONNECT AND REMOVE ROOF MOUNTED EXHAUST FAN. RETAIN FOR REINSTALLATION UP COMPLETION OF ROOF WORK.
- D5 DISCONNECT AND REMOVE DIFFUSER FOR FUTURE REINSTALLION.
- D6 DISCONNECT AND REMOVE DRYER FLUE GOOSENECK. IN ITS ENTIRETY.

SED NUMBERS EY-1510-00-01-0-000-007, AD-1510-00-01-1-001-013

MECHANICAL HVAC DEMOLITION PLAN AREA B AND D
2025 ERWIN VALLEY ELEM & ADMIN BUILDING ALTERATIONS
CORNING-PAINTED POST AREA SCHOOL DISTRICT
16 BEARTOWN ROAD, PAINTED POST, NY 14870

EV-H0.1

PROJECT NO: 2649-160

HUNT ENGINEERS | ARCHITECTS | SURVEYORS
HORSEHEADS, NY 607-265-1000 ROCHESTER, NY 585-537-7668 TOWNAND, PA 570-265-4666
BINGHAMTON, NY 607-798-8881 ALBANY, NY 607-798-8801
WWW.HUNTEAS.COM

NY CERTIFICATE NO. 001620 PA CERTIFICATE NO. TSC220313/464-1

DATE: 1 10/17/2026

DESCRIPTION OF REVISION:
ISSUED FOR BID

CHECKED BY: KEQ
DATE: 03/17/2026

PHASE: CD

DRAWN BY: DEF

DATE: 03/17/2026

PROJECT: 2649-160

IT IS A VIOLATION OF THE LAW FOR ANY PERSON TO MAKE UNAUTHORIZED ALTERATIONS OR ADDITIONS TO PLANS
DRAWN AT LICENSED ENGINEER'S OFFICE

GENERAL NOTES - MECHANICAL

REFER TO EV-H0.1

DEMOLITION NOTES - MECHANICAL

- D1 DISCONNECT AND REMOVE ROOF MOUNTED HOOD. RETAIN FOR REINSTALLATION UP COMPLETION OF ROOF WORK.
D2 NOT USED.
D3 DISCONNECT AND REMOVE ACCU. RETAIN FOR REINSTALLATION UPON COMPLETION OF ROOF WORK.
D4 DISCONNECT AND REMOVE ROOF MOUNTED EXHAUST FAN. RETAIN FOR REINSTALLATION UP COMPLETION OF ROOF WORK.
D5 DISCONNECT AND REMOVE DIFFUSER FOR FUTURE REINSTALLION
D6 DISCONNECT AND REMOVE DRYER FLUE GOOSENECK, IN ITS ENTIRETY.

DRAWN BY: DEF
CHECKED BY: KEK
DATE: 03/17/2026
PHASE: CD

#	DATE:	DESCRIPTION OF REVISION:	ISSUED FOR BID
1	10/12/2026		

IT IS A VIOLATION OF THE LAW FOR ANY PERSON TO MAKE UNAUTHORIZED ALTERATIONS OR ADDITIONS TO PLANS DRAWN BY A LICENSED ARCHITECT OR SURVEYOR'S SEAL.


HUNT ENGINEERS | ARCHITECTS | SURVEYORS
HORSEHEADS, NY 607-265-1000 ROCKY HILLS, NY 565-537-7549 TOWNANDA, PA 570-265-4666
BINGHAMTON, NY 607-798-8881 ALBANY, NY 607-798-8881
WWW.HUNTEAS.COM
NY CERTIFICATE NO. 0016220 PA CERTIFICATE NO. TSC2220313/464-1

MECHANICAL ROOF PLAN AREA B AND D
2025 ERWIN VALLEY ELEM & ADMIN BUILDING ALTERATIONS
CORNING-PAINTED POST AREA SCHOOL DISTRICT
16 BEARTOWN ROAD, PAINTED POST, NY 14870


EV-H0.2

PROJECT NO: 2649-160


SEE NUMBERS EV-01/03/04/14/009/027/AD-01/03/04/14/014/13

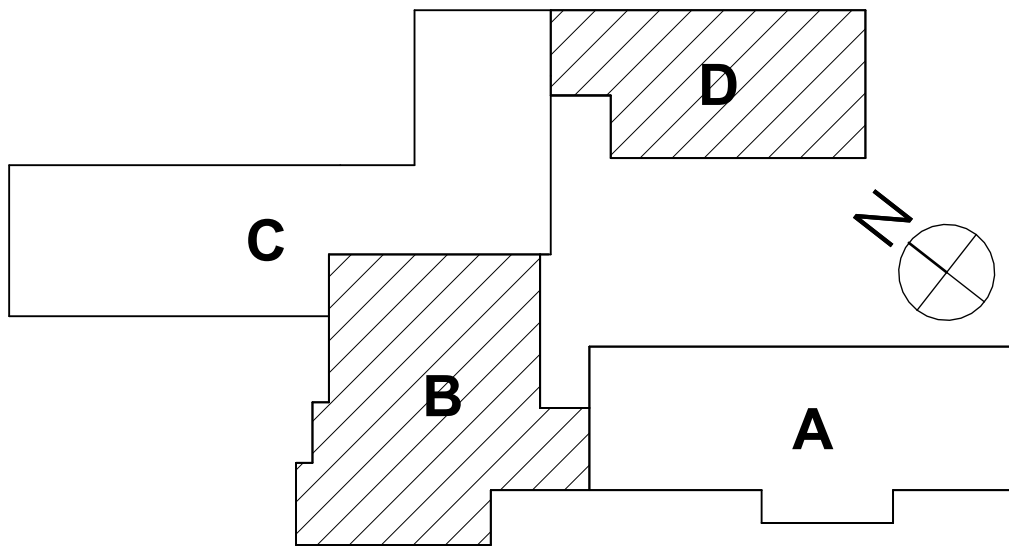


2 ROOF HVAC DEMO PLAN AREA D
1/8" = 1'-0"

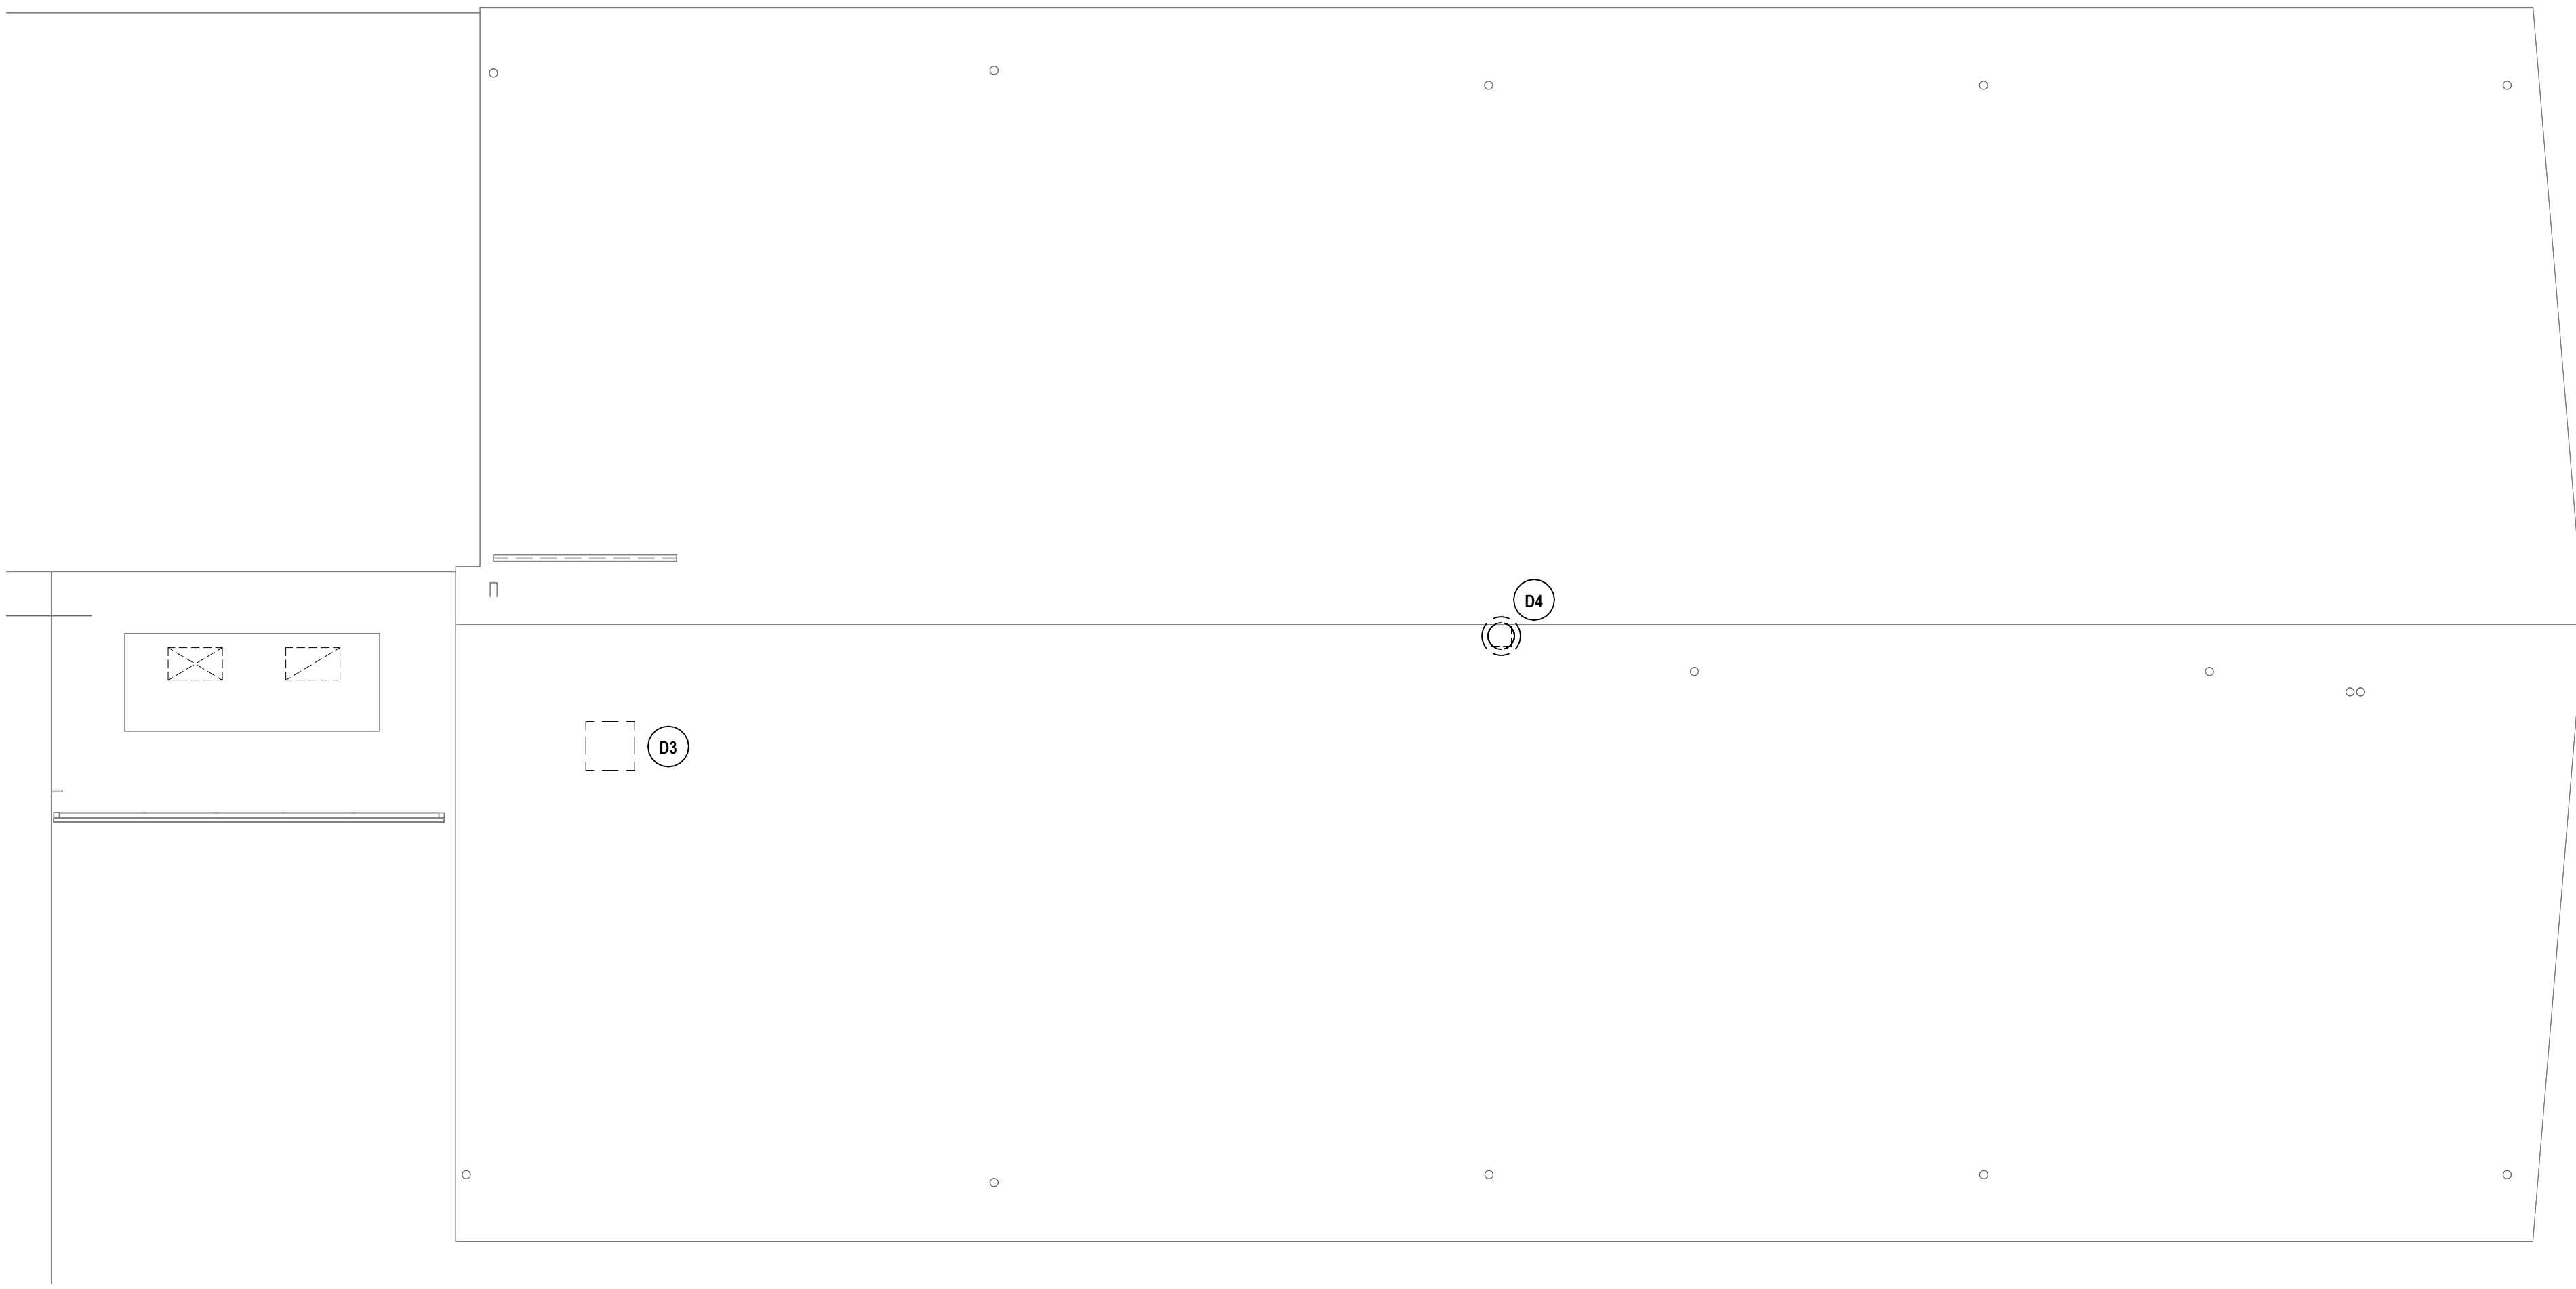


1 ROOF HVAC DEMO PLAN AREA B
1/8" = 1'-0"

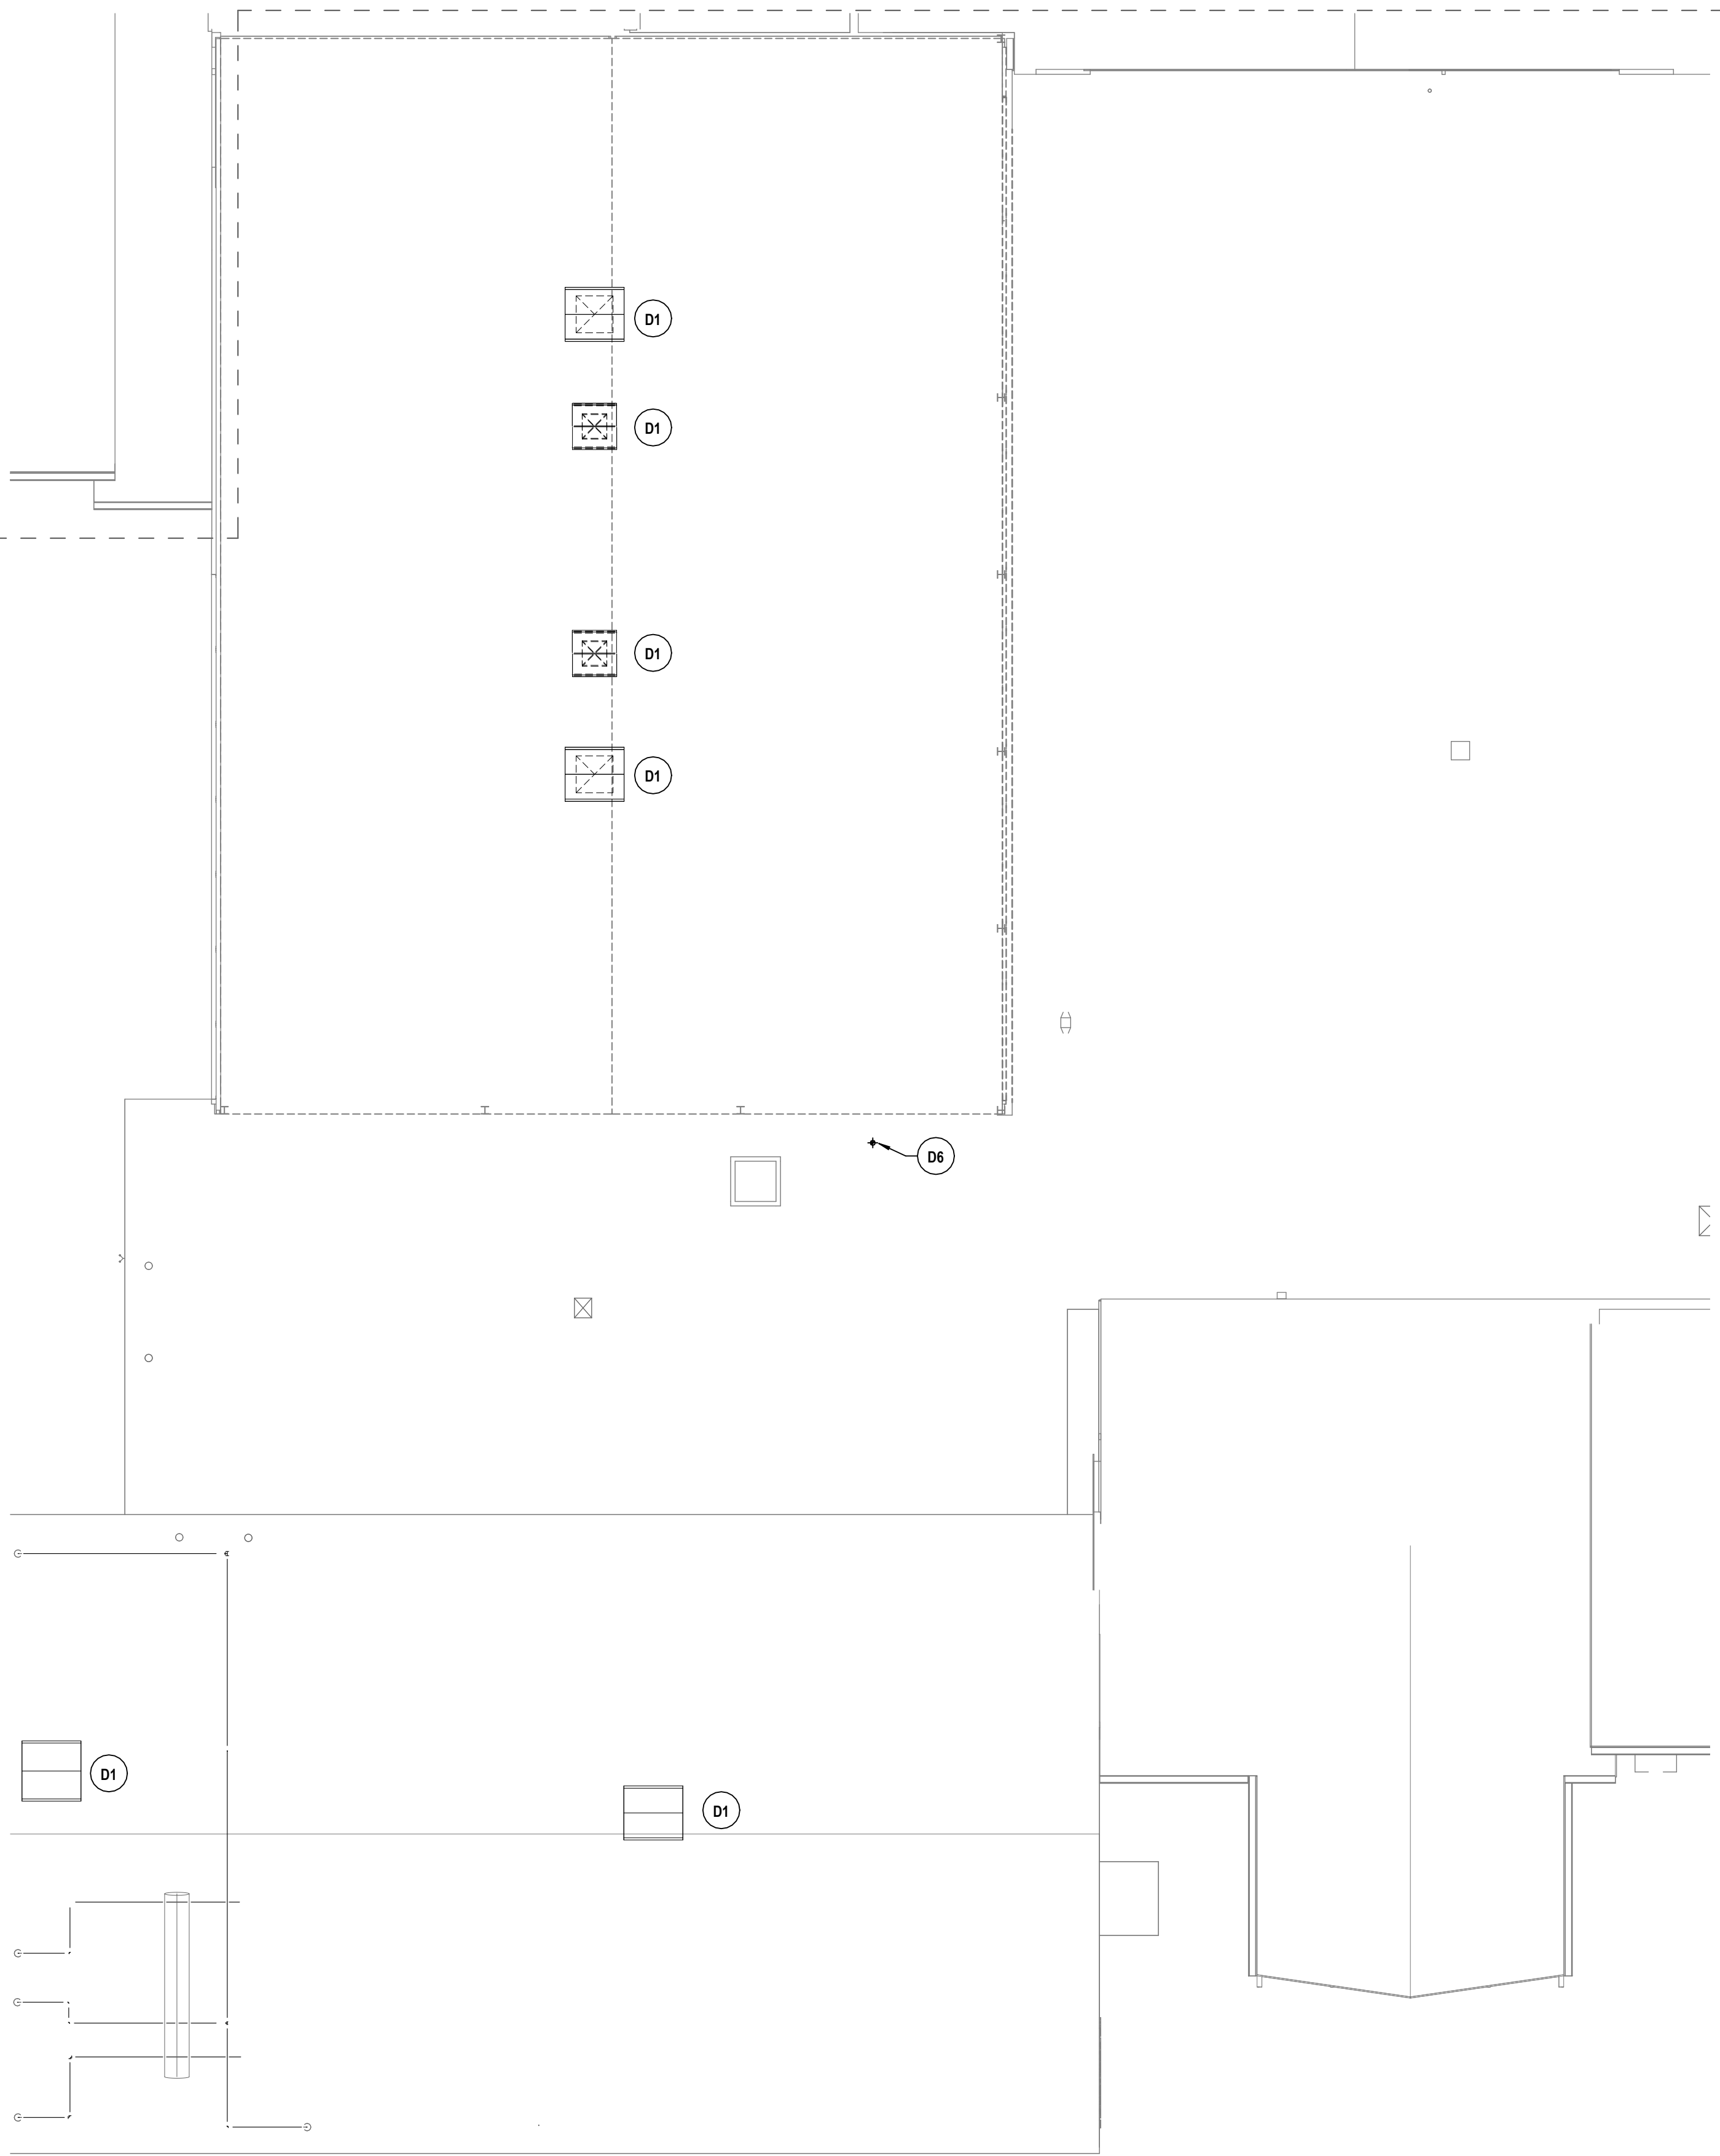


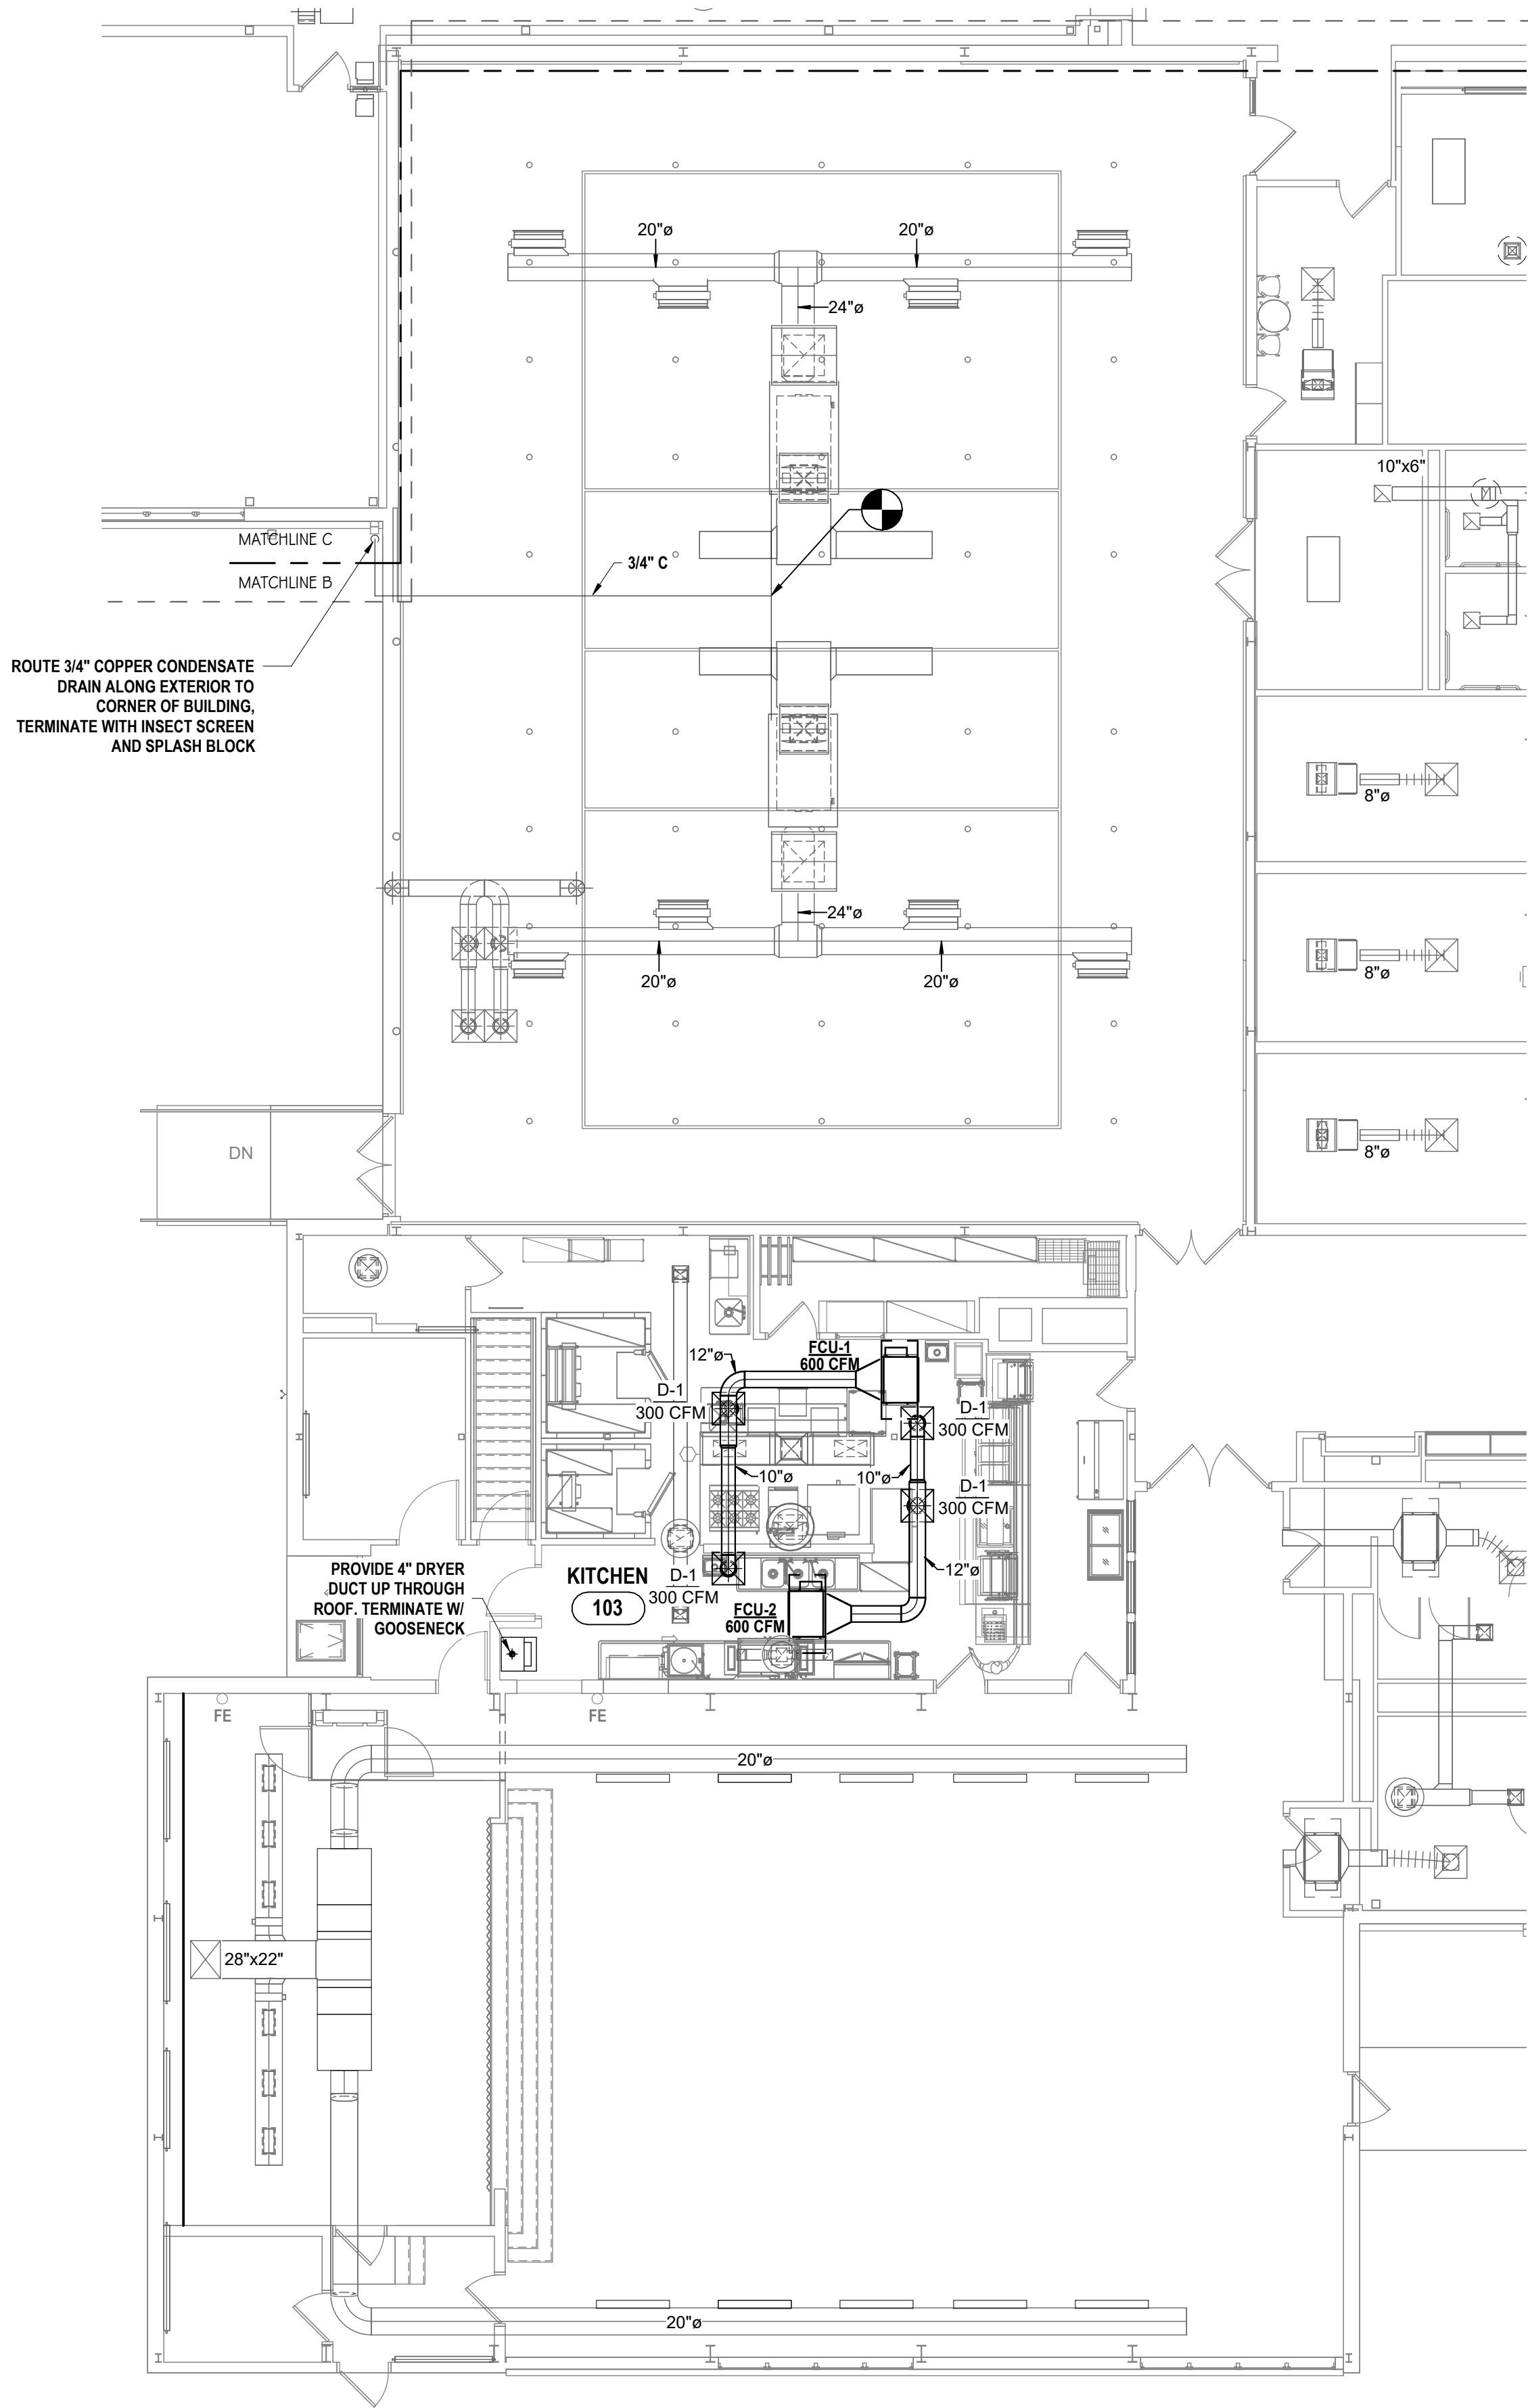

1 FIRST FLOOR NEW WORK PLAN - AREA B
1/8" = 1'-0"

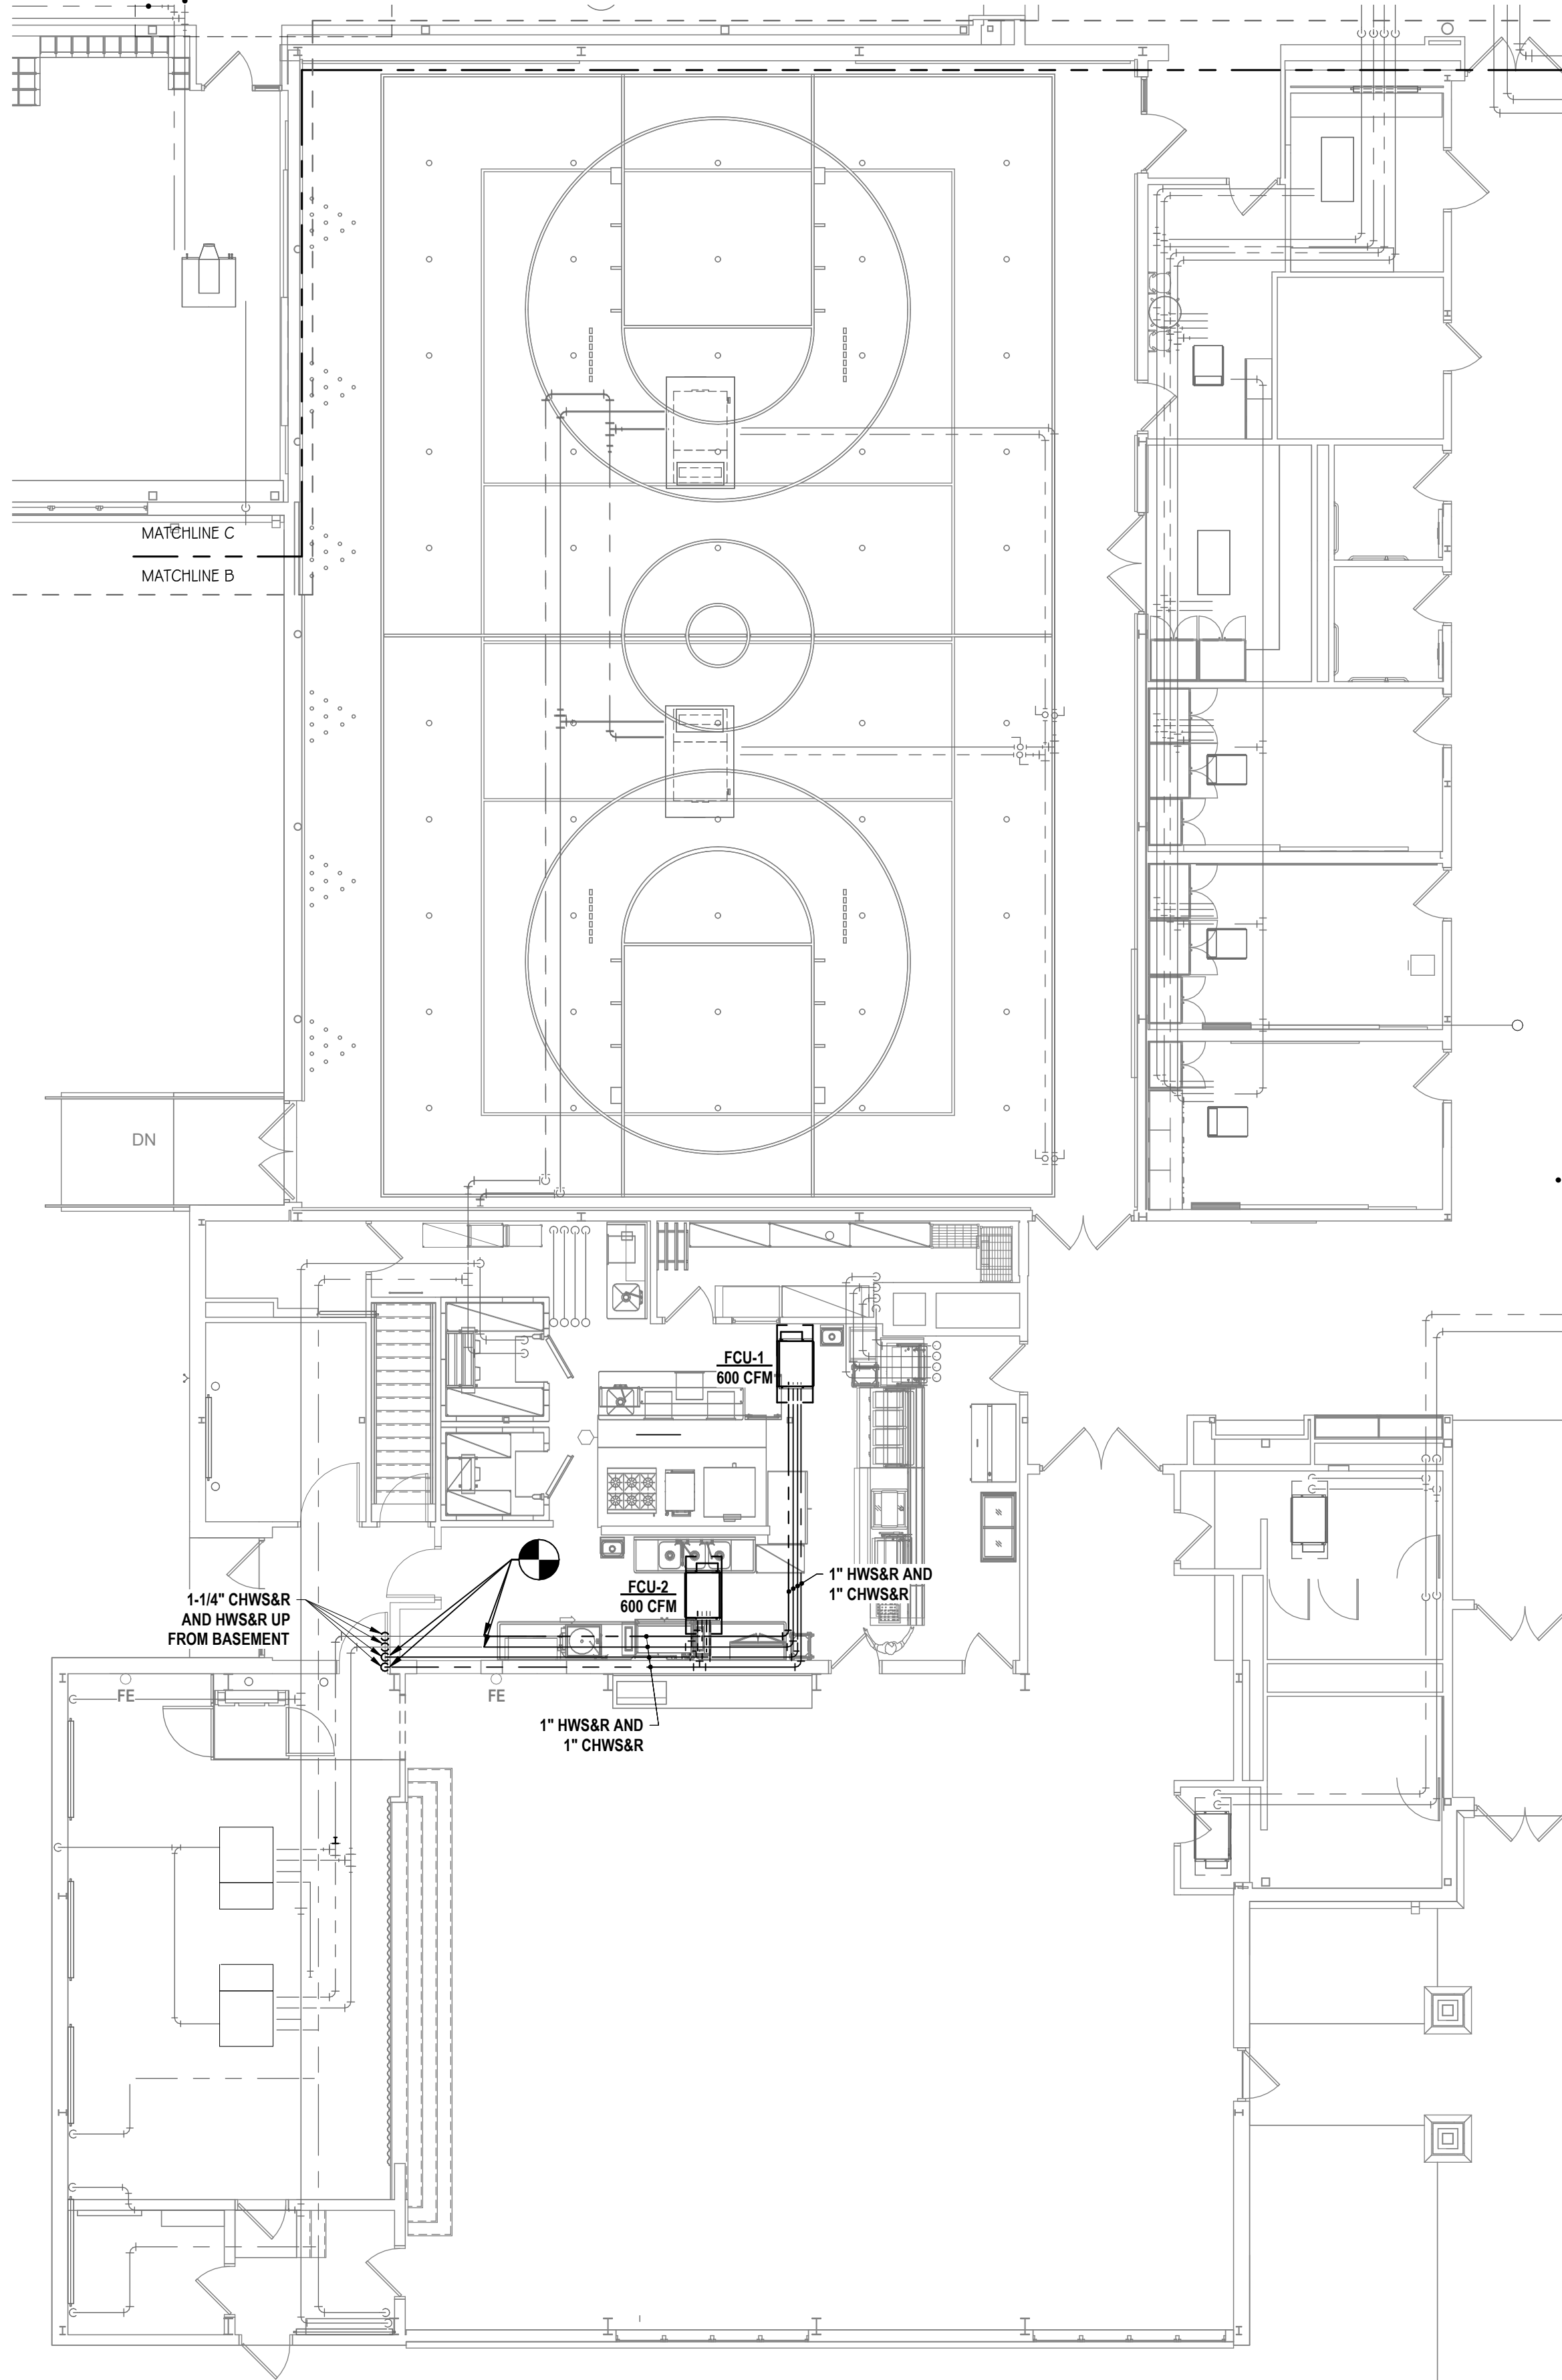

2 FIRST FLOOR PIPING PLAN - AREA B
1/8" = 1'-0"

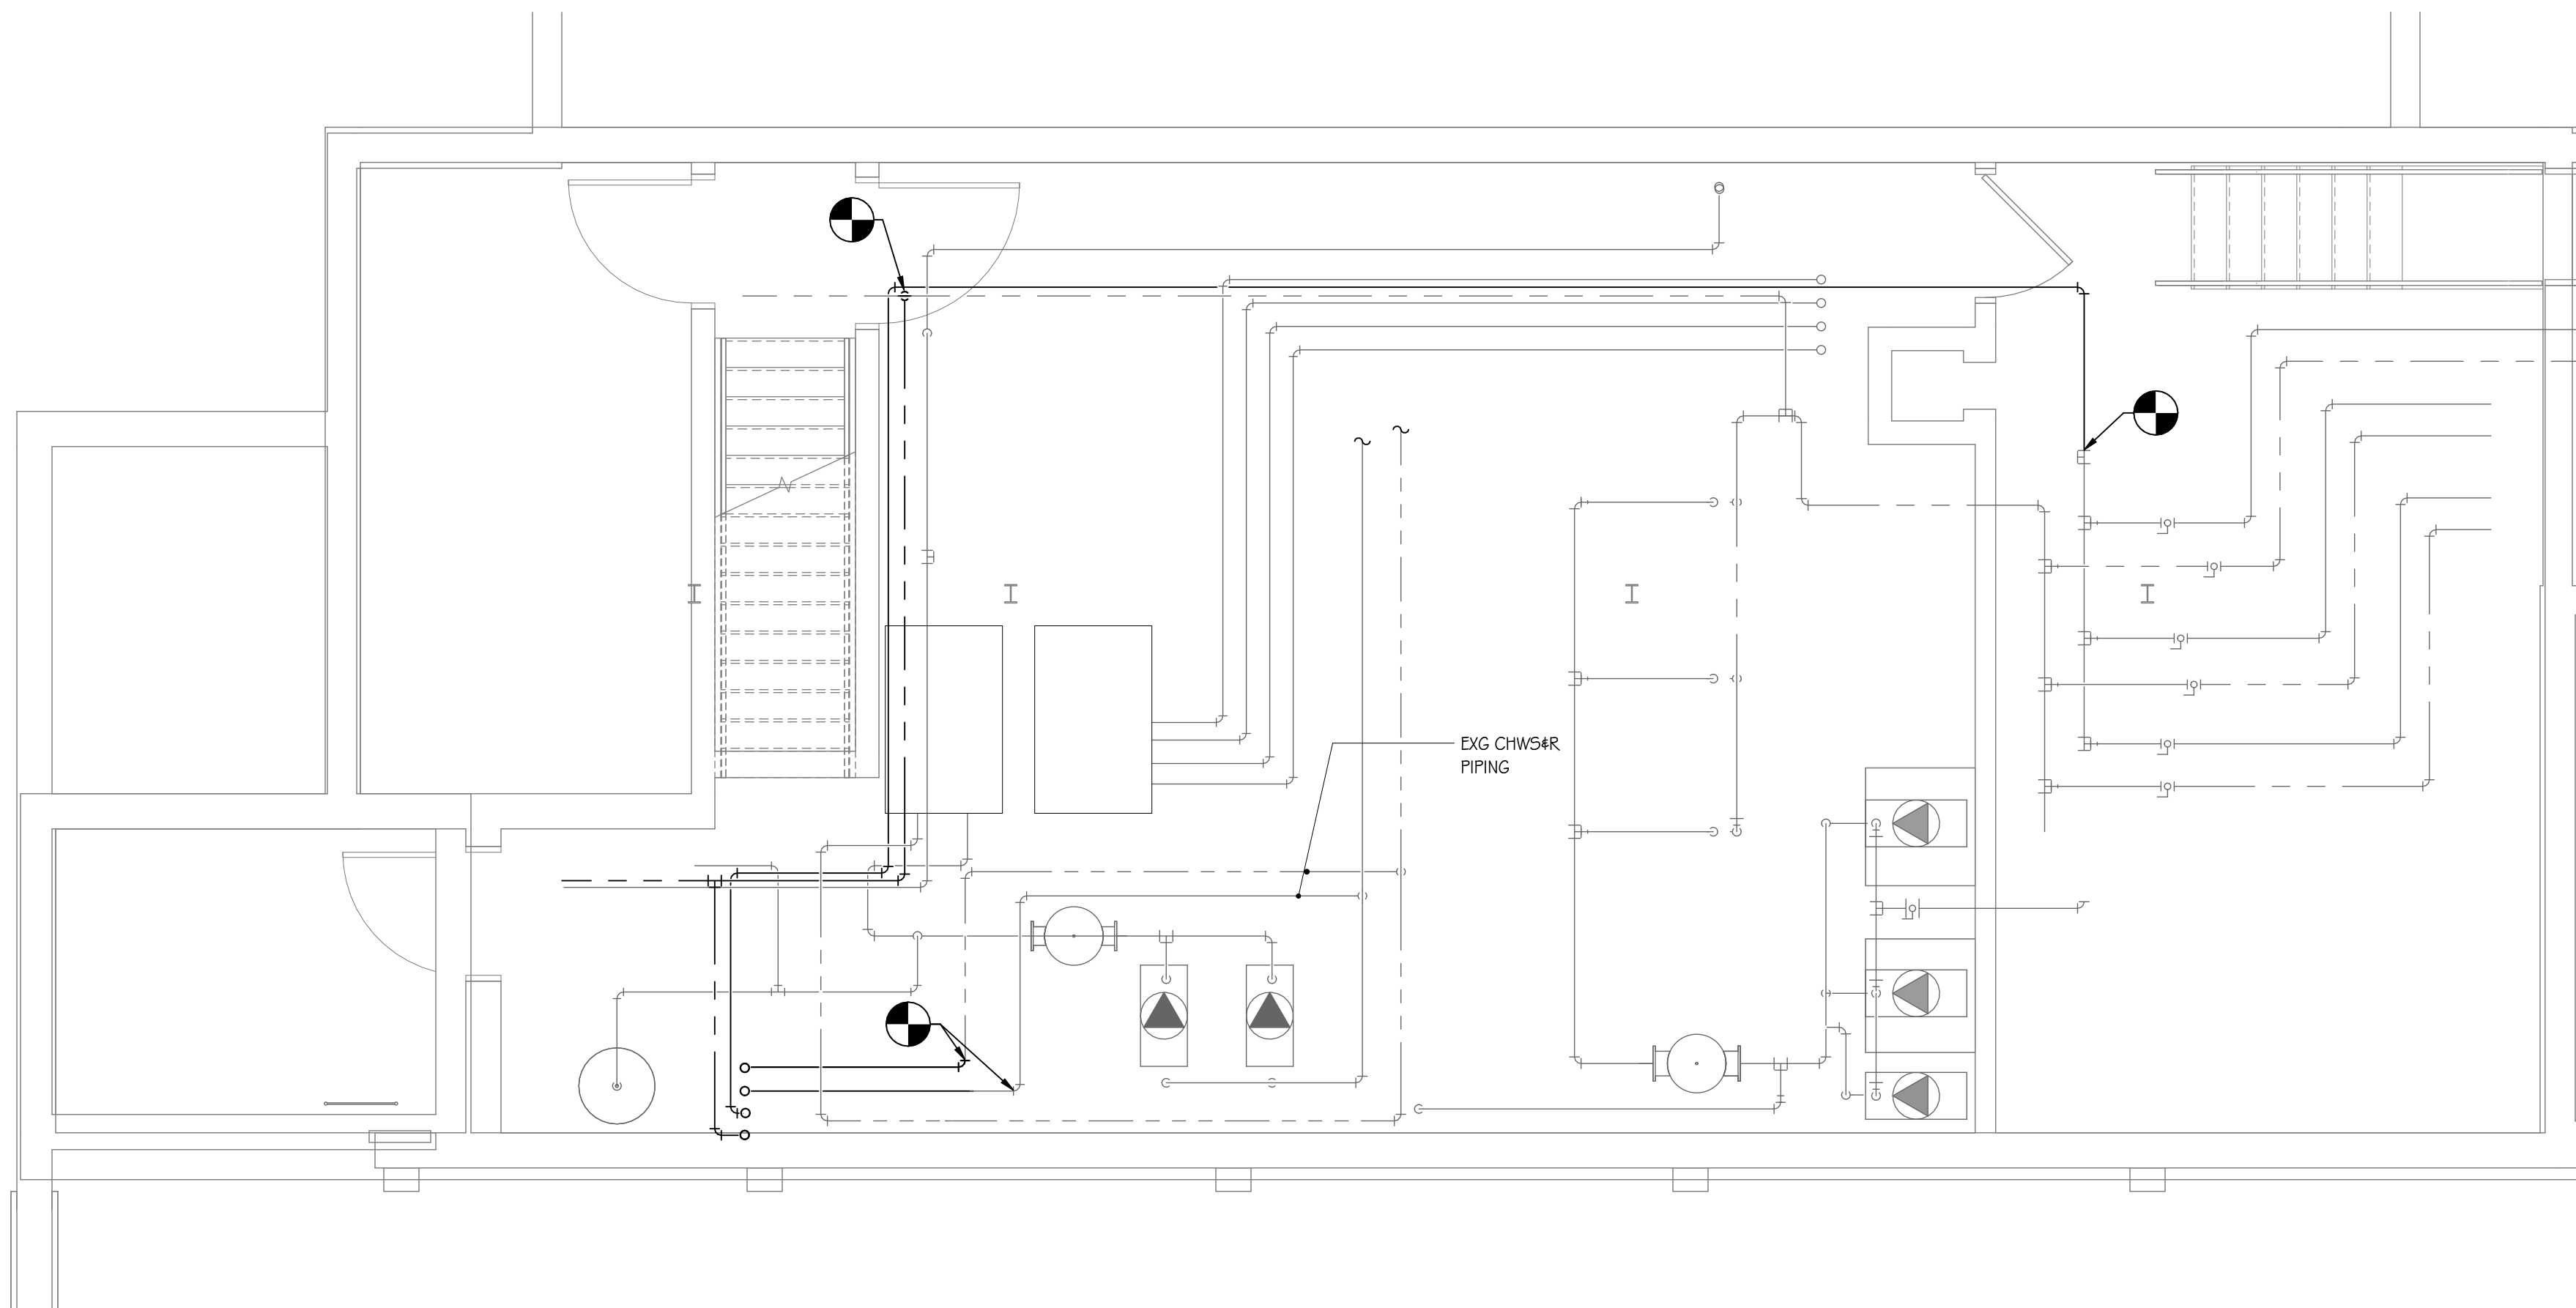

3 BASEMENT PIPING PLAN NEW WORK - AREA B
1/4" = 1'-0"

REFER TO EV-H1.1

GENERAL NOTES - MECHANICAL

CONSTRUCTION NOTES - MECHANICAL

1. REINSTALL EXISTING ROOF TOP HOOD. EXTEND AND RECONNECT DUCTWORK AS NECESSARY.
2. NOT USED.
3. REINSTALL EXISTING ACCU. EXTEND AND RECONNECT REFREGERANT LINES. RECHARGE REFRIGERATION CIRCUITS.
4. REINSTALL EXISTING ROOF TOP EXHAUST FAN. EXTEND AND RECONNECT DUCTWORK AS NECESSARY.
5. REINSTALL EXISTING DIFFUSER
6. REINSTALL EXISTING DIFFUSER

#	DATE:	DESCRIPTION OF REVISION:	DRAWN BY:	DEF
1	10/12/2026	ISSUED FOR BID	KEO	KEO
			CHECKED BY:	KEO
			DATE:	03/17/2026
			PHASE:	CD
IT IS A VIOLATION OF THE LAW FOR ANY PERSON TO MAKE UNAUTHORIZED ALTERATIONS OR ADDITIONS TO PLANS DRAWN BY LICENSED ARCHITECTS OR SURVEYORS ONLY.				

HUNT ENGINEERS | ARCHITECTS | SURVEYORS

HORSEHEADS, NY 607-263-1000
ROCHESTER, NY 585-537-7549
BINGHAMTON, NY 607-738-8881
ALBANY, NY 607-738-8801
TOWANDA, PA 570-265-4666
WWW.HUNTEAS.COM

NY CERTIFICATE NO. 001620 PA CERTIFICATE NO. TSC220013464-1

FIRST FLOOR HVAC PLAN - AREA B
2025 ERWIN VALLEY ELEM & ADMIN BUILDING ALTERATIONS
CORNING-PAINTED POST AREA SCHOOL DISTRICT
16 BEARTOWN ROAD, PAINTED POST NY 14870

SED NUMBERS EV-51-00-001-0-000-007 AD-51-00-001-1-001-013

PROJECT NO: 2649-160

EV-H1.1

GENERAL NOTES - MECHANICAL

REFER TO EV-H0.1

CONSTRUCTION NOTES - MECHANICAL

- 1 REINSTALL EXISTING ROOF TOP HOOD. EXTEND AND RECONNECT DUCTWORK AS NECESSARY.
- 2 NOT USED.
- 3 REINSTALL EXISTING ACCU. EXTEND AND RECONNECT REFRIGERANT LINES. RECHARGE REFRIGERATION CIRCUITS.
- 4 REINSTALL EXISTING ROOF TOP EXHAUST FAN. EXTEND AND RECONNECT DUCTWORK AS NECESSARY.
- 5 REINSTALL EXISTING DIFFUSER
- 6 REINSTALL EXISTING DIFFUSER




DRAWN BY: QDW	
CHECKED BY: KEQ	
DATE: 03/17/2026	
PHASE: CD	
COPYRIGHT: 2026	
DESCRIPTION OF REVISION: ISSUED FOR BID	
#	DATE
1	10/12/2026
IT IS A VIOLATION OF THE LAW FOR ANY PERSON TO MAKE UNAUTHORIZED ALTERATIONS OR ADDITIONS TO PLANS DRAWN BY LICENSED ARCHITECTS OR SURVEYORS.	

HUNT ENGINEERS | ARCHITECTS | SURVEYORS
HORSEHEADS, NY 607-265-1000 ROCKY HILLS, NY 565-537-7549 TONAWANDA, PA 570-265-4666
BINGHAMTON, NY 607-798-8881 ALBANY, NY 607-798-8801 WWW.HUNTEAS.COM
NY CERTIFICATE NO. 0016220 PA CERTIFICATE NO. TSC222013/464-1

MECHANICAL ROOF NEW WORK PLAN AREAS B & D
2025 ERWIN VALLEY ELEM & ADMIN BUILDING ALTERATIONS
CORNING-PAINTED POST AREA SCHOOL DISTRICT
16 BEARTOWN ROAD, PAINTED POST NY 14870

EV-H1.2
PROJECT NO: 2649-160

SEE NUMBERS EV-1510-00-01-0-009-007, AD-2516-00-01-1-001-013

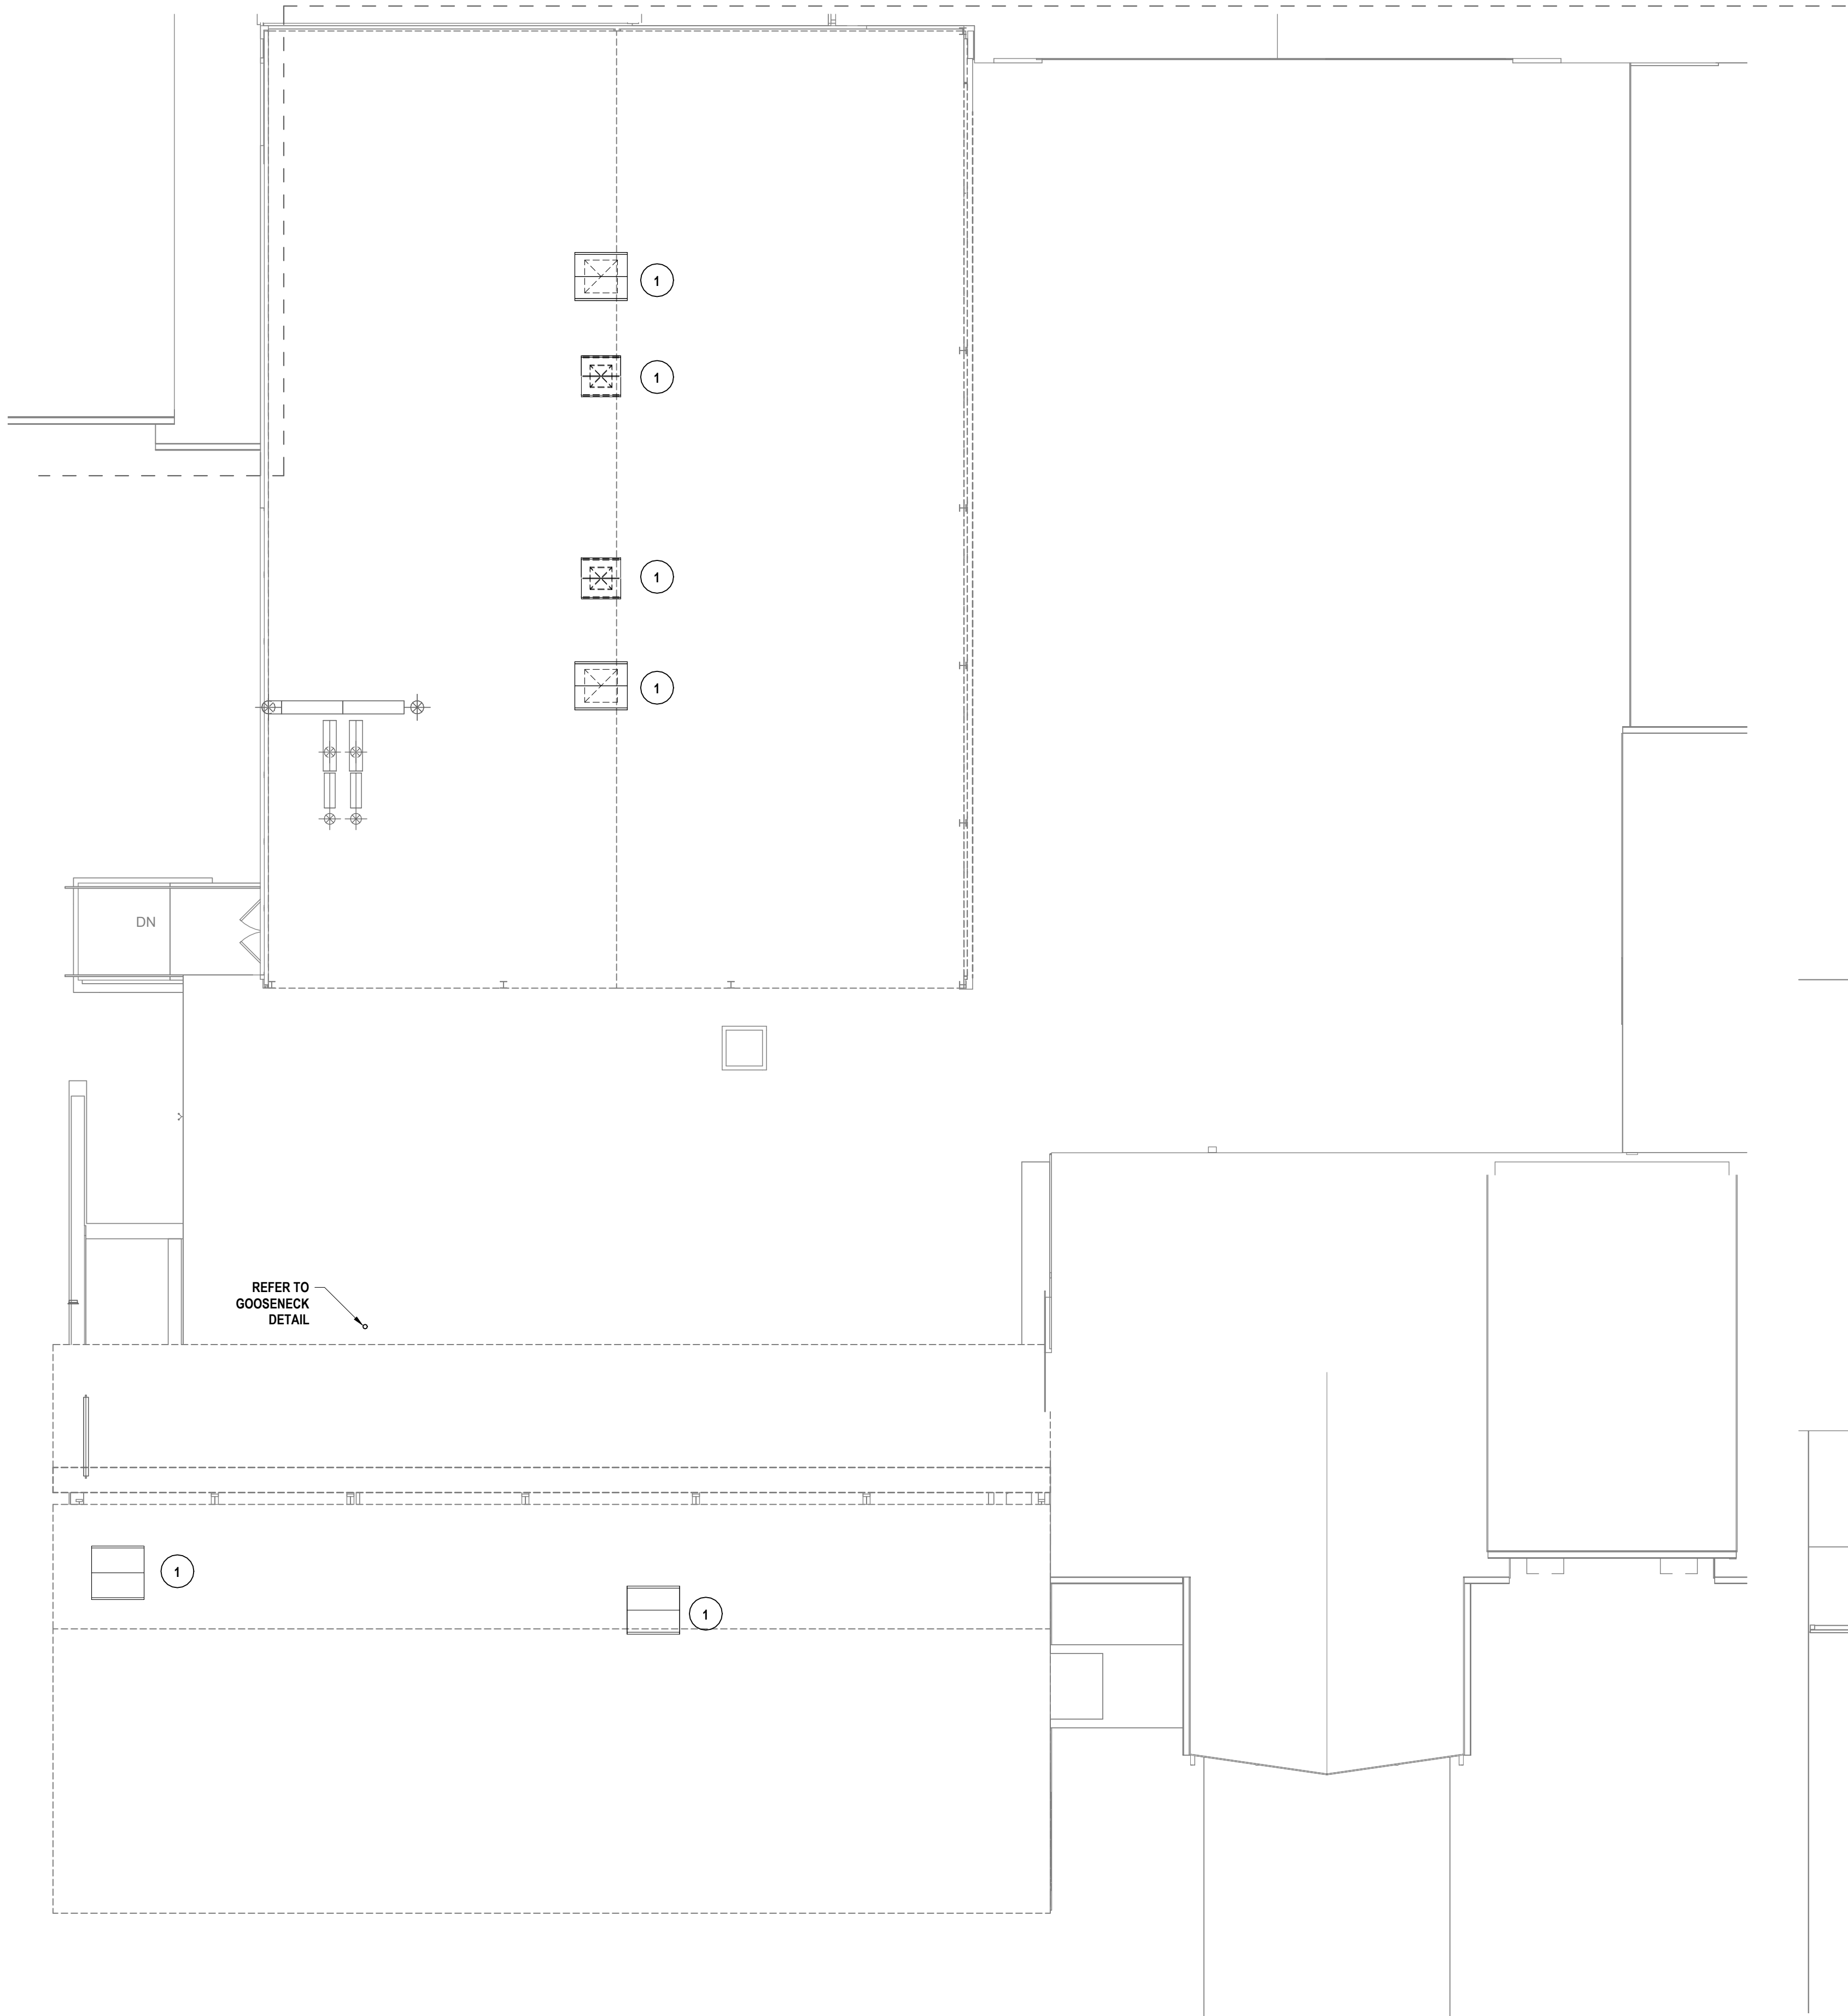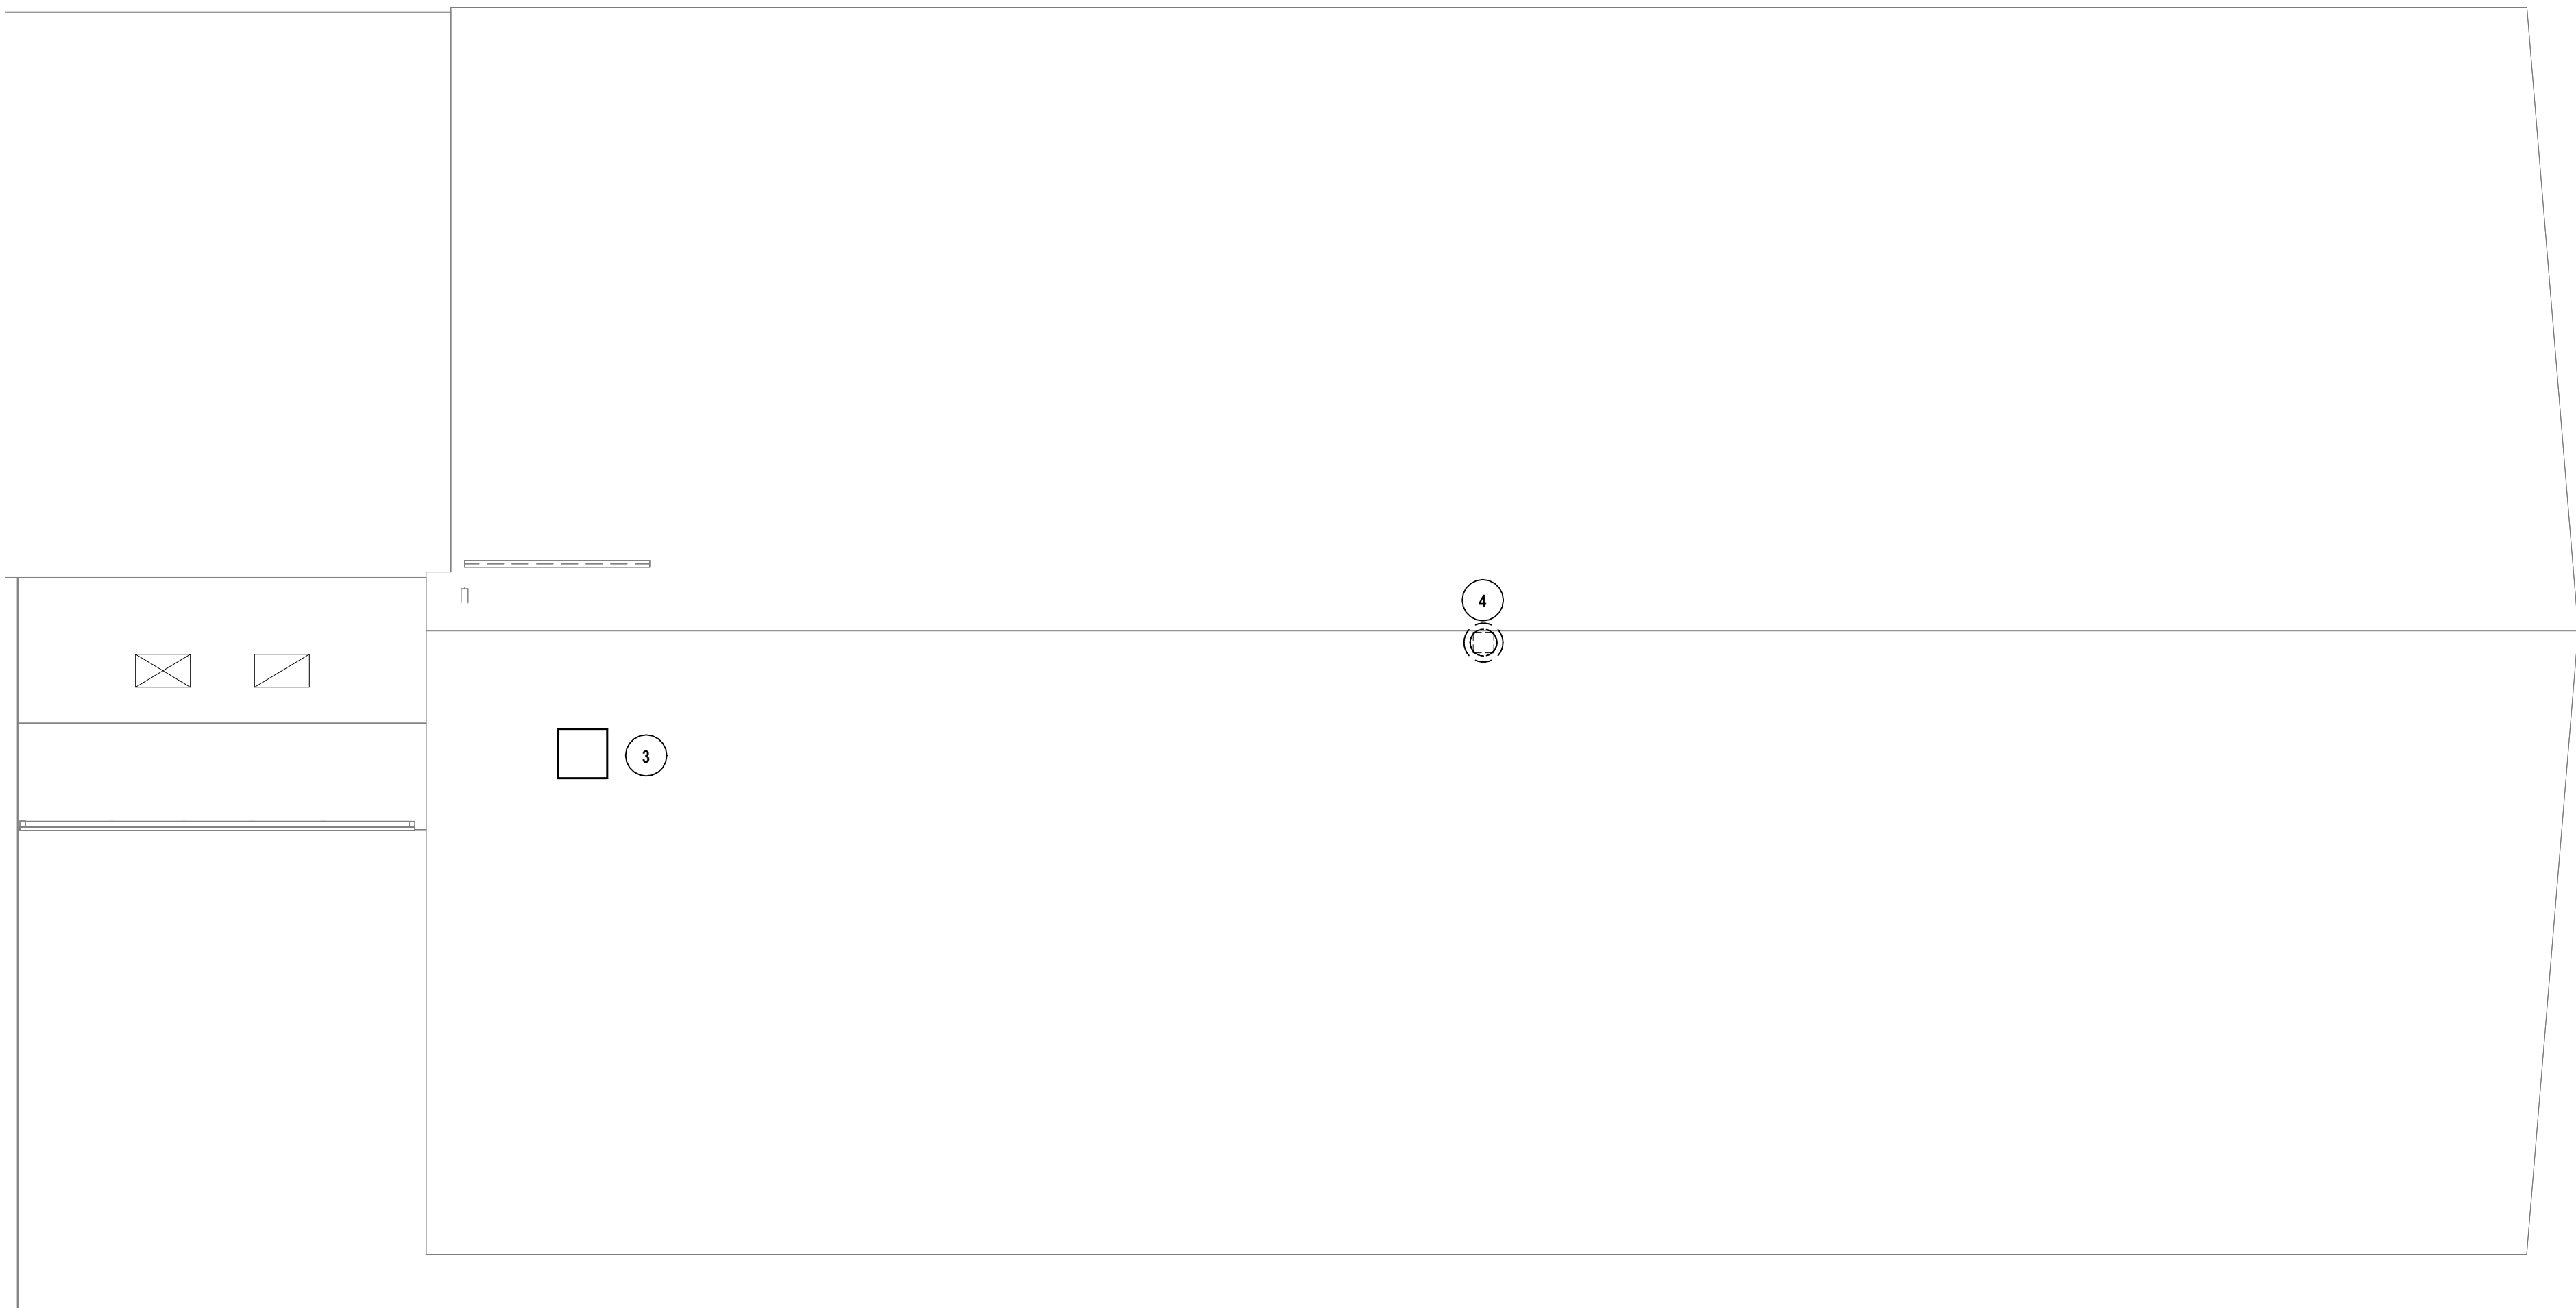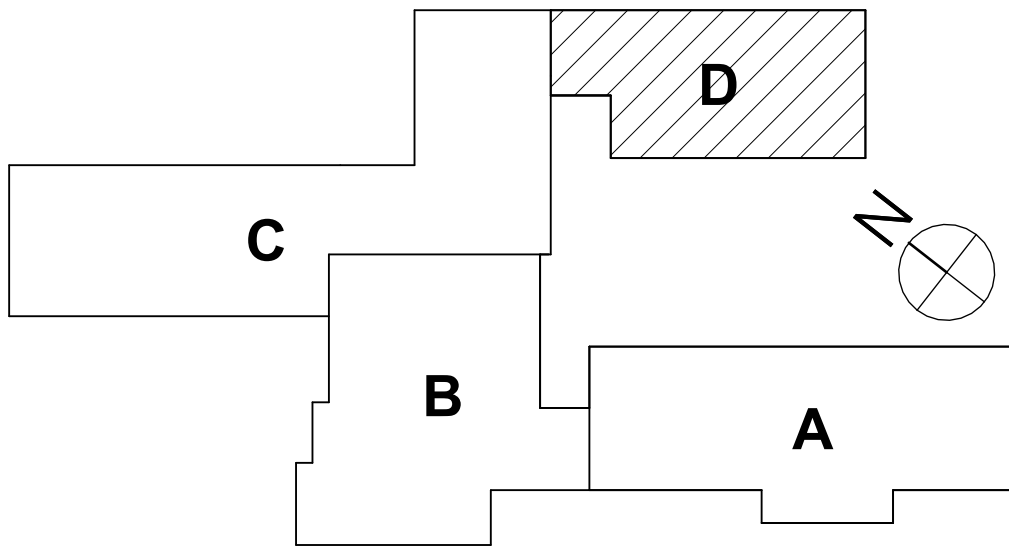


GENERAL NOTES - MECHANICAL


REFER TO EV-H0.1

CONSTRUCTION NOTES - MECHANICAL


- REINSTALL EXISTING ROOF TOP HOOD. EXTEND AND RECONNECT DUCTWORK AS NECESSARY.
- NOT USED.
- REINSTALL EXISTING ACCU. EXTEND AND RECONNECT REFREGERANT LINES. RECHARGE REFRIGERATION CIRCUITS.
- REINSTALL EXISTING ROOF TOP EXHAUST FAN. EXTEND AND RECONNECT DUCTWORK AS NECESSARY.
- REINSTALL EXISTING DIFFUSER
- REINSTALL EXISTING DIFFUSER

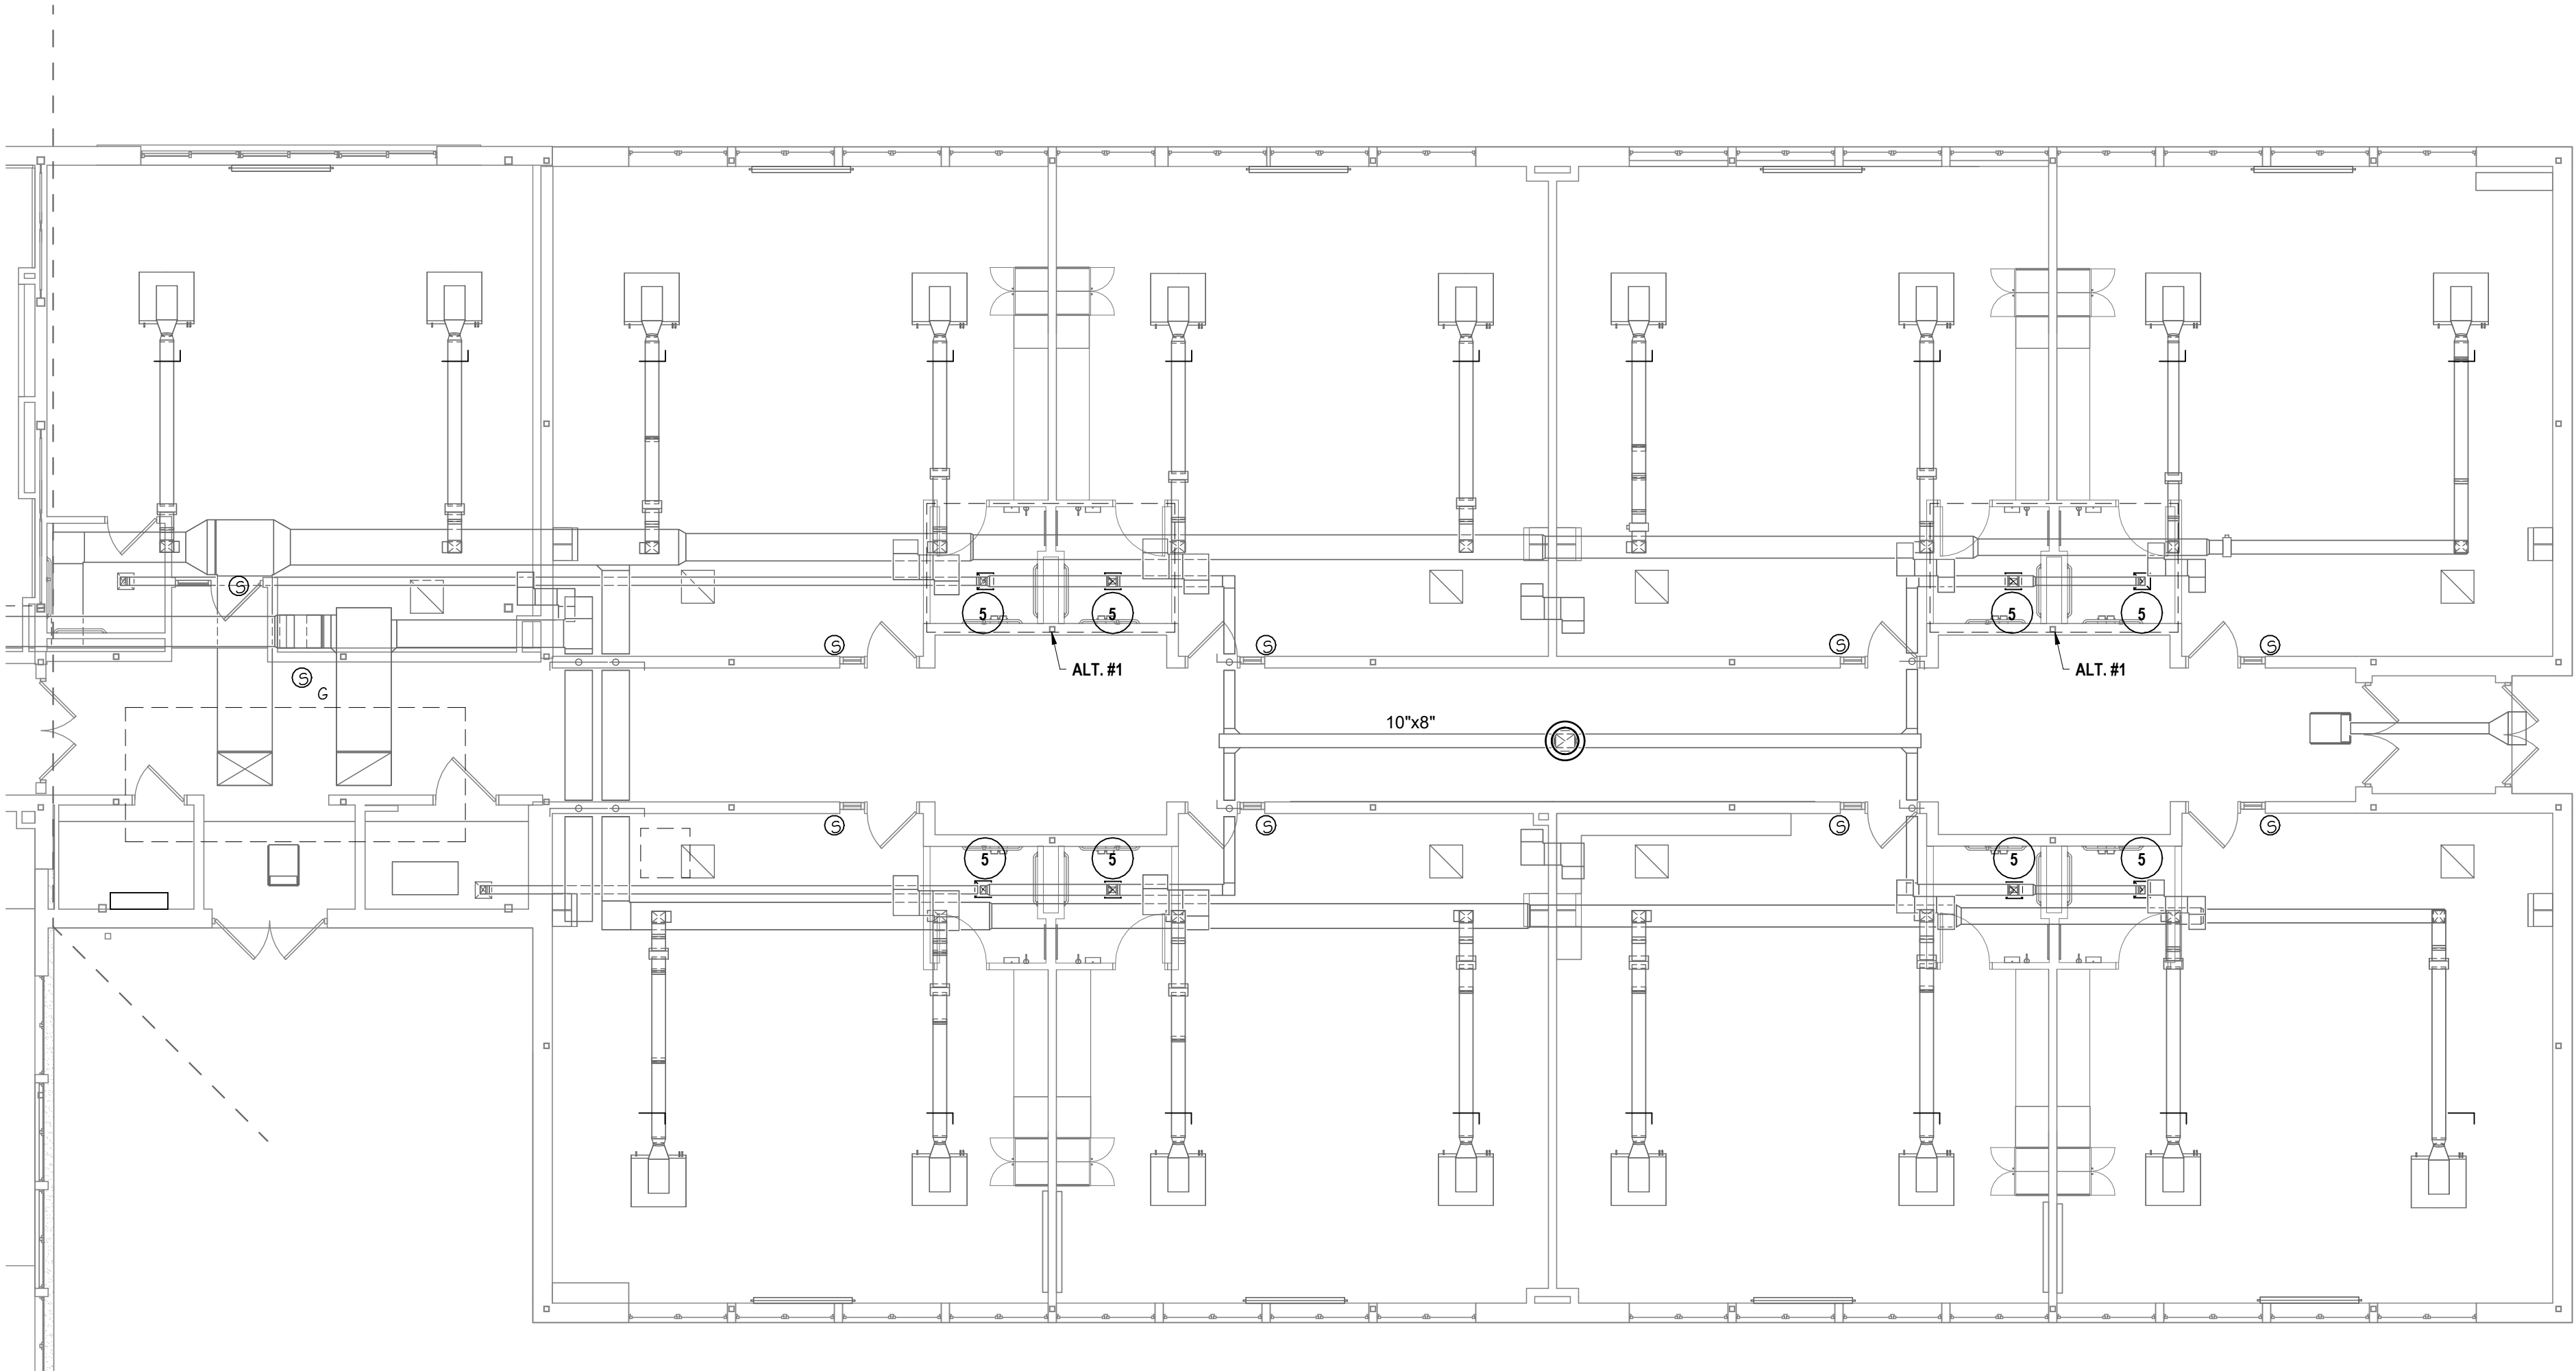

2 FIRST FLOOR NEW WORK PLAN - AREA D
1/8" = 1'-0"

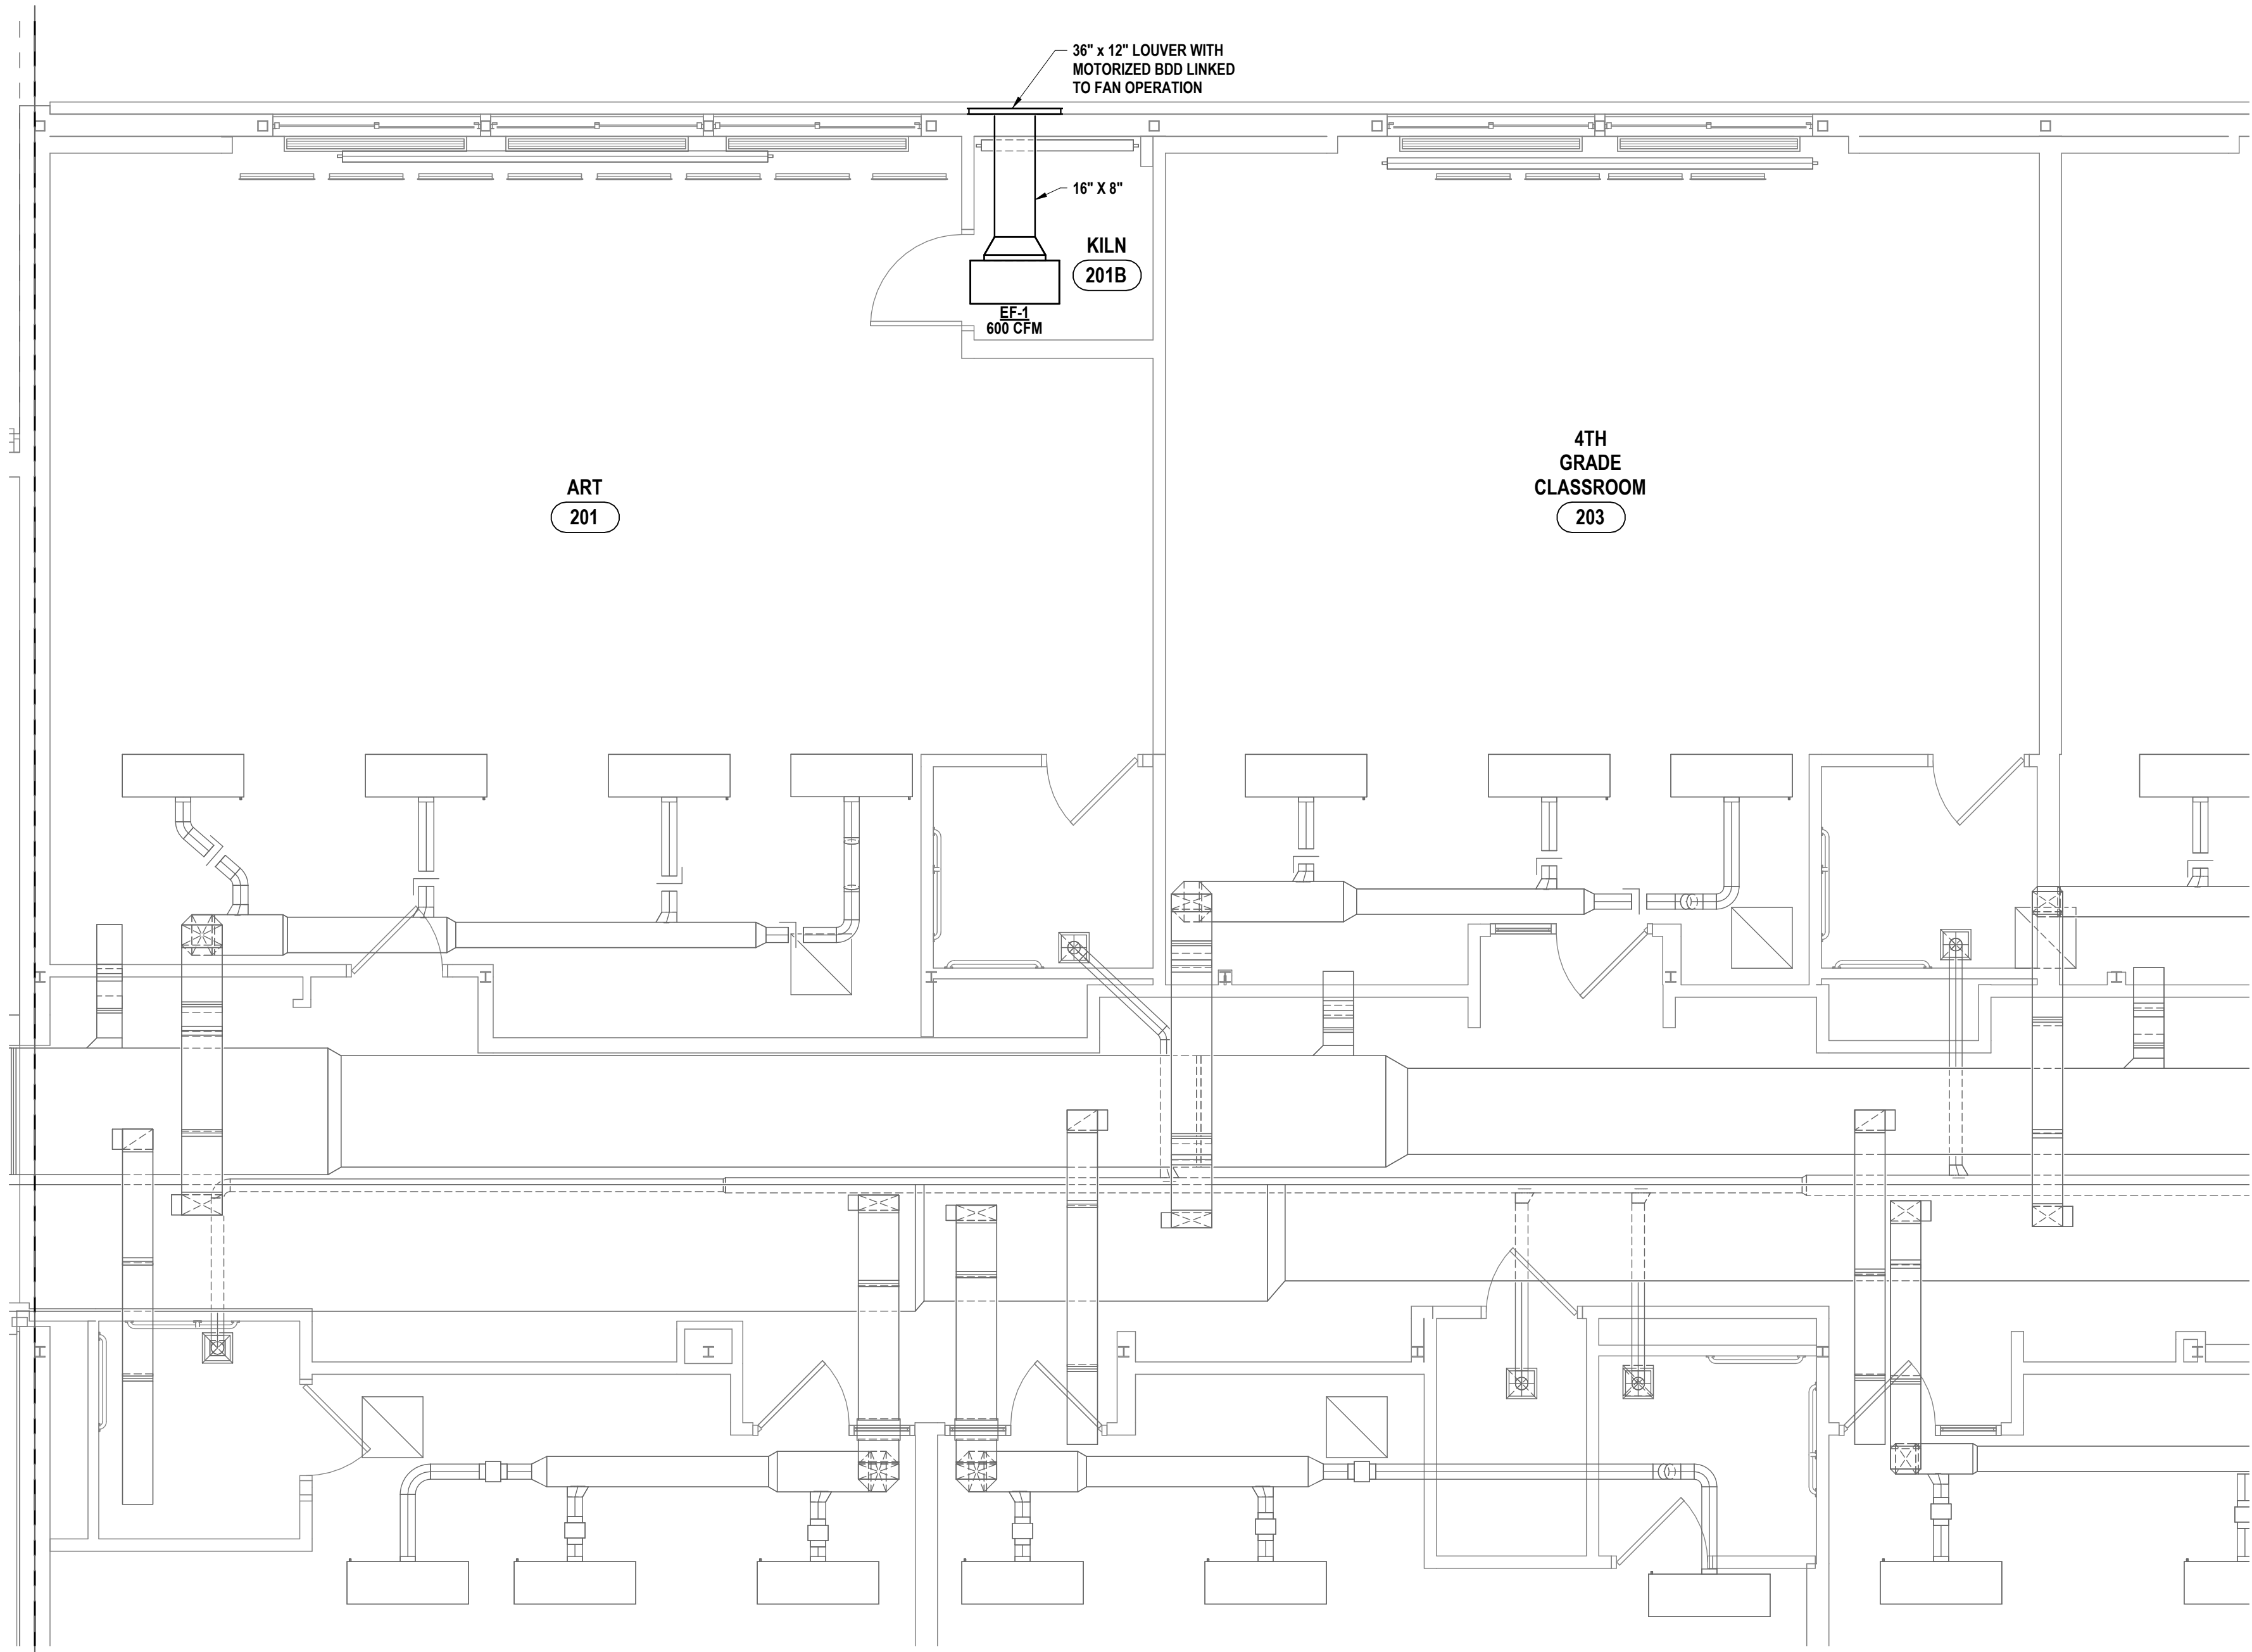

1 FIRST FLOOR NEW WORK PLAN - AREA A
1/4" = 1'-0"

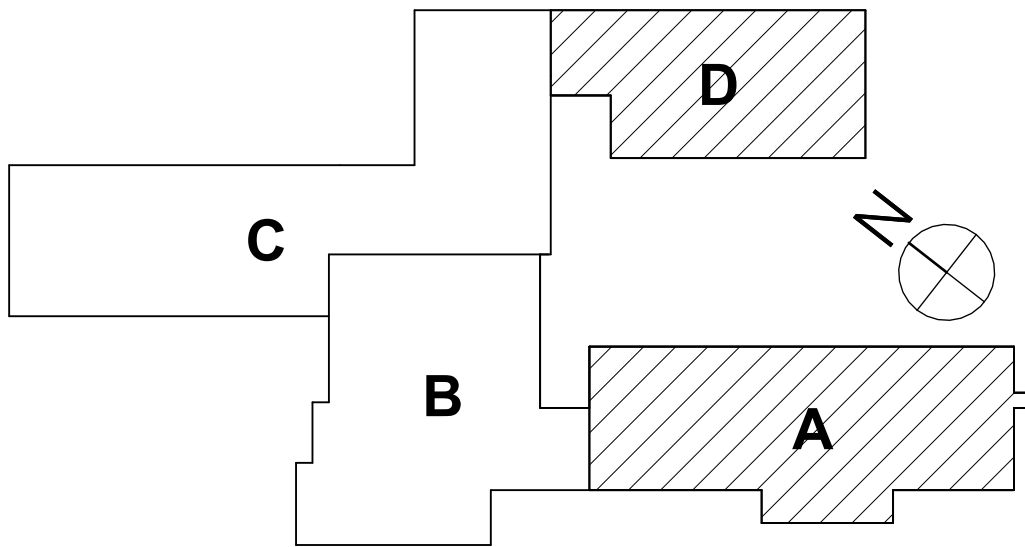

SED NUMBERS EV-5110-00-01-0-009-027 AD-5110-00-01-1-001-013

FIRST FLOOR NEW WORK PLAN- AREA A AND D

2025 ERWIN VALLEY ELEM & ADMIN BUILDING ALTERATIONS
CORNING-PAINTED POST AREA SCHOOL DISTRICT

16 BEARTOWN ROAD, PAINTED POST NY 14870

HUNT ENGINEERS | ARCHITECTS | SURVEYORS

HORSEHEADS, NY 607-263-1000 ROCHESTER, NY 585-537-7849 TOWNAND, PA 570-265-4666

BINGHAMTON, NY 607-798-8881 ALBANY, NY 607-798-8801

WWW.HUNTEAS.COM

NY CERTIFICATE NO. 0016220 PA CERTIFICATE NO. TSC2202013/464-1

DESCRIPTION OF REVISION:
ISSUED FOR BID

DATE:
1 10/12/2026

PHASE:

DRAWN BY:

DEF

CHECKED BY:

KEO

DATE:

03/17/2026

PHASE:





CD

Copyright 2026

IT IS A VIOLATION OF THE LAW FOR ANY PERSON TO MAKE UNAUTHORIZED ALTERATIONS OR ADJUSTMENTS TO PLANS
DRAWN AT LOCATION, DIMENSIONS, MATERIALS, ETC. WITHOUT THE ARCHITECT'S SIGNATURE.

EV-H1.3

PROJECT NO: 2649-160

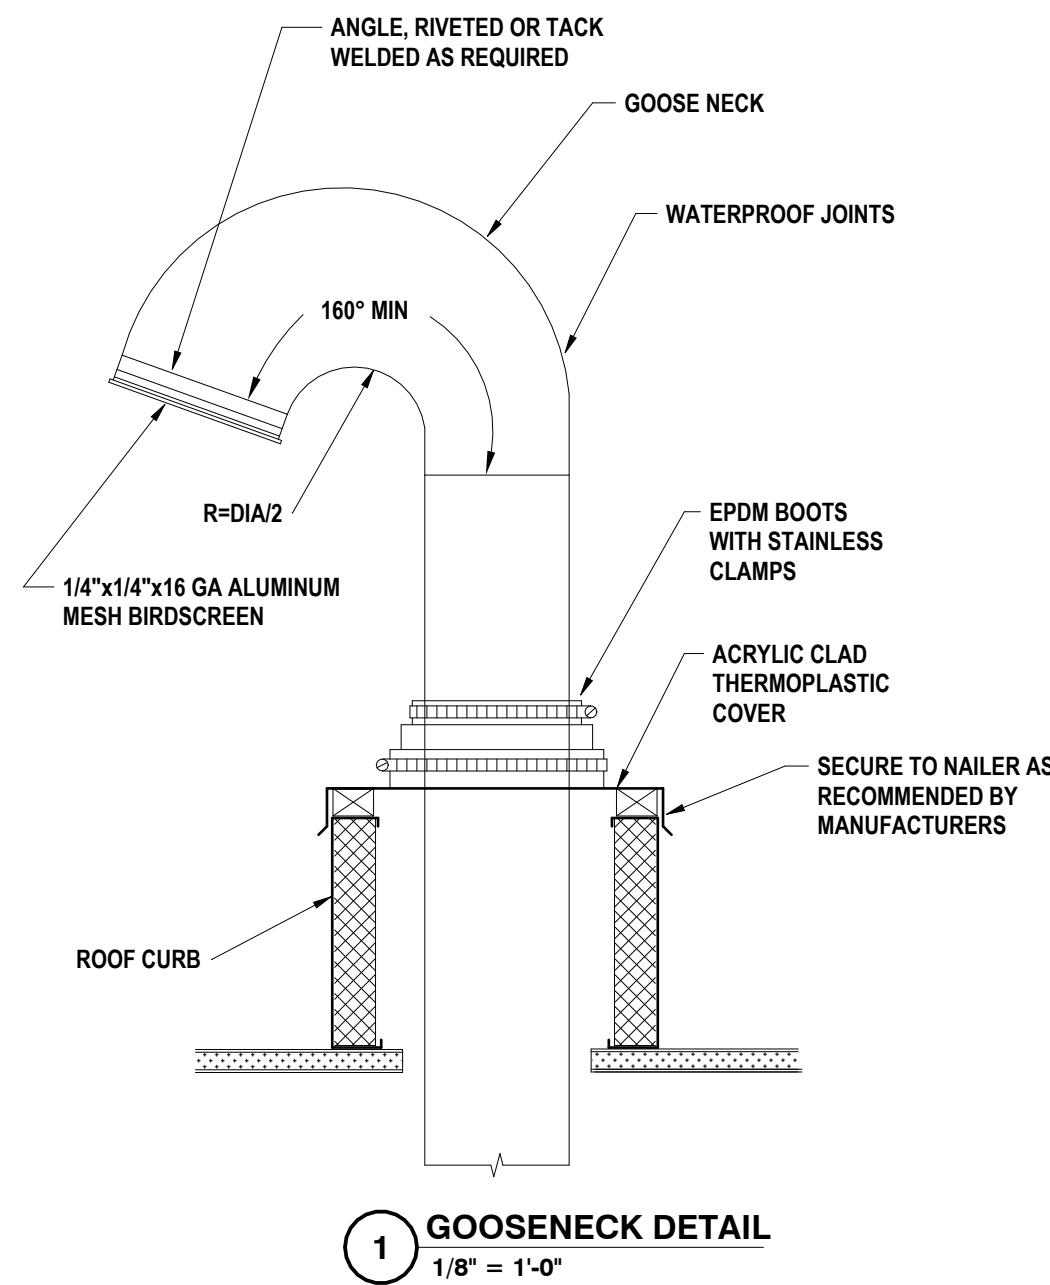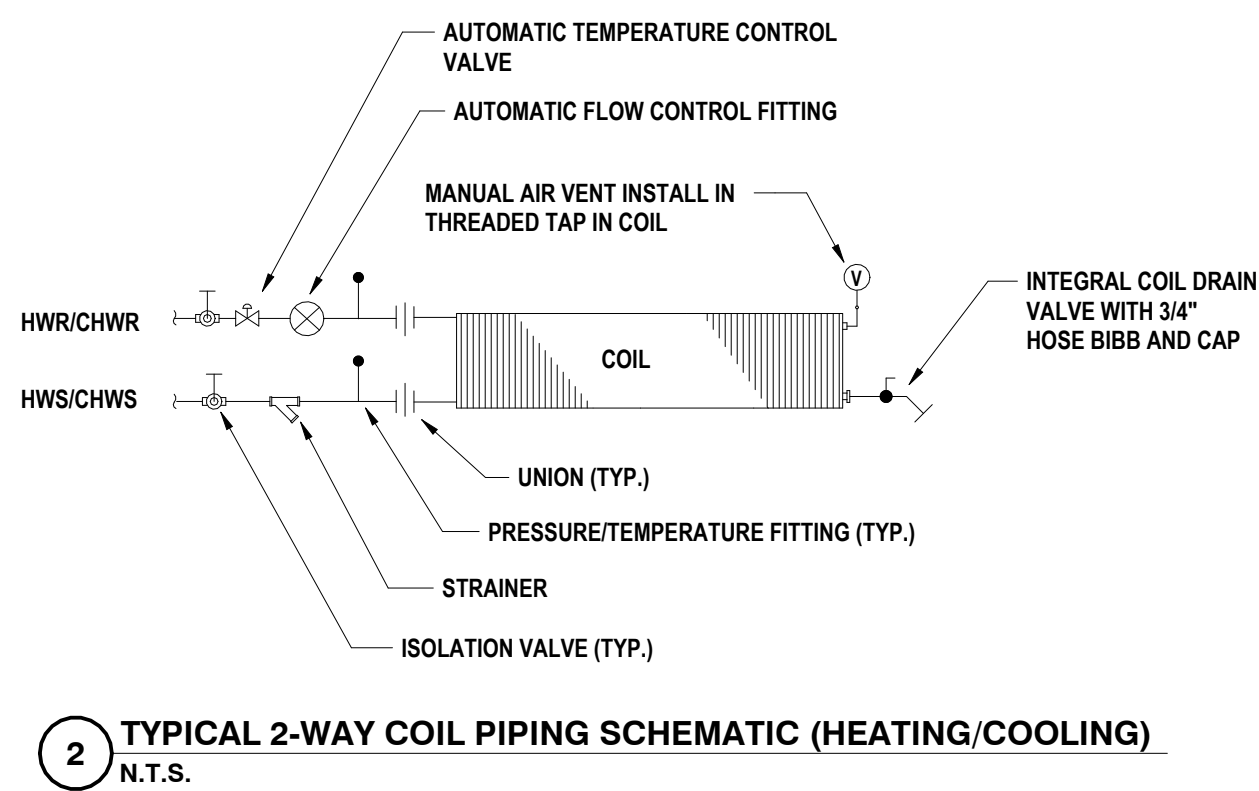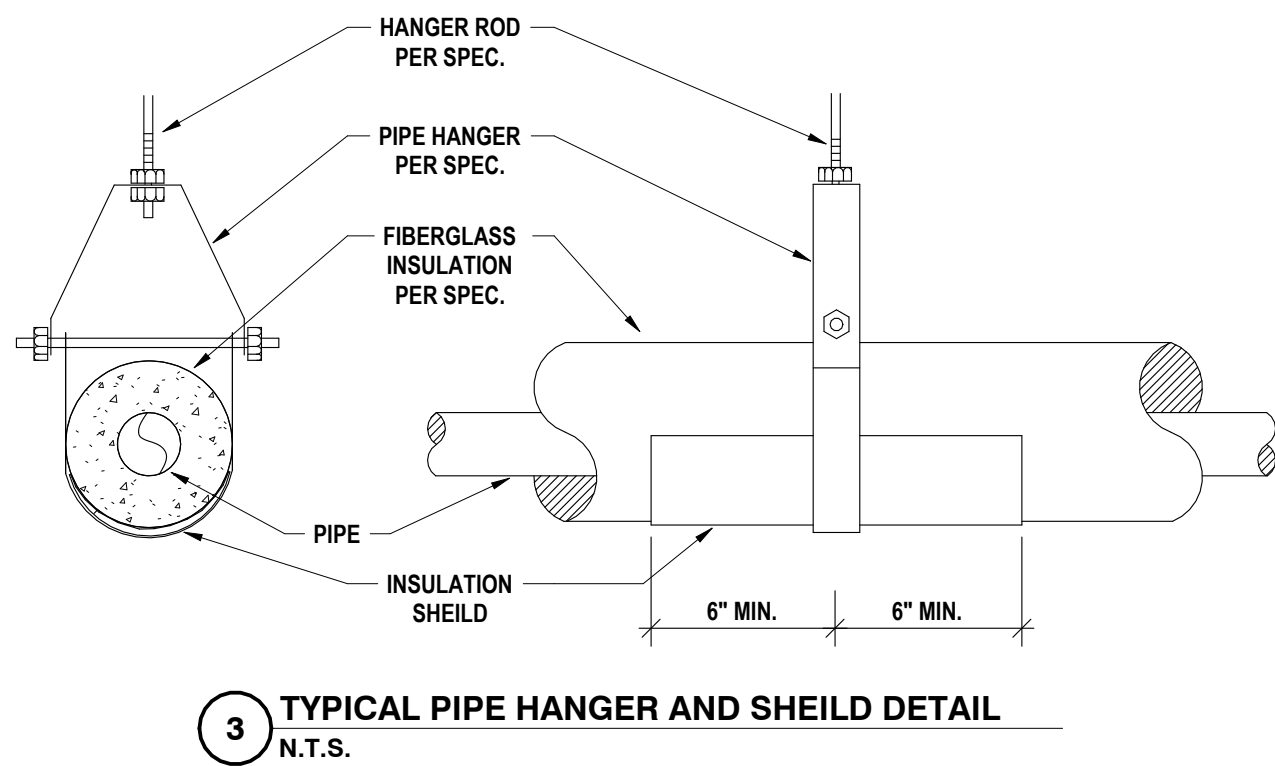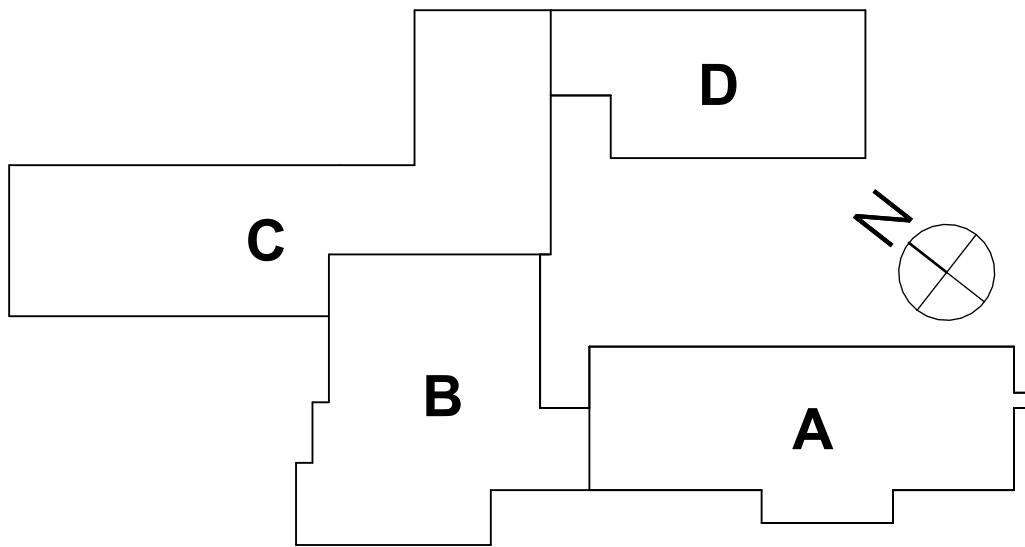

FAN COIL UNIT SCHEDULE MANUFACTURER																			
UNIT #	LOCATION	FAN DATA			HEATING COIL DATA					REQUIRED COOLING COIL DATA				FILTER TYPE	MCA/MOP	VOLTS	PHASE	MANUFACTURER/MODEL #	REMARKS & NOTES
		CFM (TOTAL)	CFM (OA)	EXT. SP (")	EAT	EWT	GPM	MAX WPD	CAP MBH	SENS	TOTAL	EWT	GPM						
FCU-1	H1.1	600	-	.4	68	160	3.5	4.6	38	13	18	45	3.5	THROWAWAY	6/15	120 V	1	TRANE FCEB100	1,2,3,4
FCU-2	H1.1	600	-	.4	68	160	3.5	4.6	38	13	18	45	3.5	THROWAWAY	6/15	120 V	1	TRANE FCEB100	1,2,3,4

- NOTES:
1. PROVIDE HIGH STATIC MOTOR.
 2. PROVIDE FACTORY COLORED DISCONNECT.
 3. UNIT SHALL BE BOTTOM STAMPED RETURN & FRONT DUCT DISCHARGE.
 4. START STOP BY DDC.
 5. PROVIDE CONDENSATE PUMP SIMILAR TO GIANT VCMA-15ULS. ROUTE TO NEAREST FLOOR DRAIN AND TERMINATE ABOVE FLOOR DRAIN GRATE.

EXHAUST FAN SCHEDULE											
FAN #	LOCATION	CFM	MAKE / MODEL	RPM	ELECTRICAL			SONES	SP	DRIVE	REMARKS & NOTES
					HP	VOLTS	PHASE				
EF-1	EV H1.1	600	COOK GEMINI GC-720	1375	.35	115 V	1	-	.25	DIRECT DRIVE	1,2

- NOTES:
1. PROVIDE FACTORY WIRED DISCONNECT.
 2. START/STOP BY TEMP SENSOR. ADJUSTABLE.

SUPPLY DIFFUSER SCHEDULE						
UNIT #	MFG/ MODEL	FACE / NECK SIZE	CFM	MAX. SP	MAX. N.C.	REMARKS & NOTES
D-1	PRICE/SCDA	24X24 / 6"Ø	300	-	20	-

SEE NUMBERS EV-1510-00-01-0-009-007, AD-5716-00-01-1-001-013

SCHEDULES & DETAILS

2025 ERWIN VALLEY ELEM & ADMIN BUILDING ALTERATIONS
CORNING-PAINTED POST AREA SCHOOL DISTRICT

16 BEARTOWN ROAD, PAINTED POST NY 14870

EV-H3.1

PROJECT NO: 2649-160

HUNT ENGINEERS | ARCHITECTS | SURVEYORS

HORSEHEADS, NY 607-265-1000 ROCHESTER, NY 565-537-7649 TOWNANDA, PA 570-265-4668

BINGHAMTON, NY 607-798-8881 ALBANY, NY 607-798-8881

WWW.HUNTEAS.COM

NY CERTIFICATE NO. 0016220 PA CERTIFICATE NO. TSC2220131464-1

DATE: 1 10/12/2026

DESCRIPTION OF REVISION:
ISSUED FOR BID

DRAWN BY: DEF

CHECKED BY: KE0


DATE: 03/17/2026

PHASE:

CD

Copyright 2026

IT IS A VIOLATION OF THE LAW FOR ANY PERSON TO MAKE UNAUTHORIZED ALTERATIONS OR ADDITIONS TO PLANS
DRAWN BY LICENSED ENGINEER, ARCHITECT OR SURVEYOR'S SEAL.

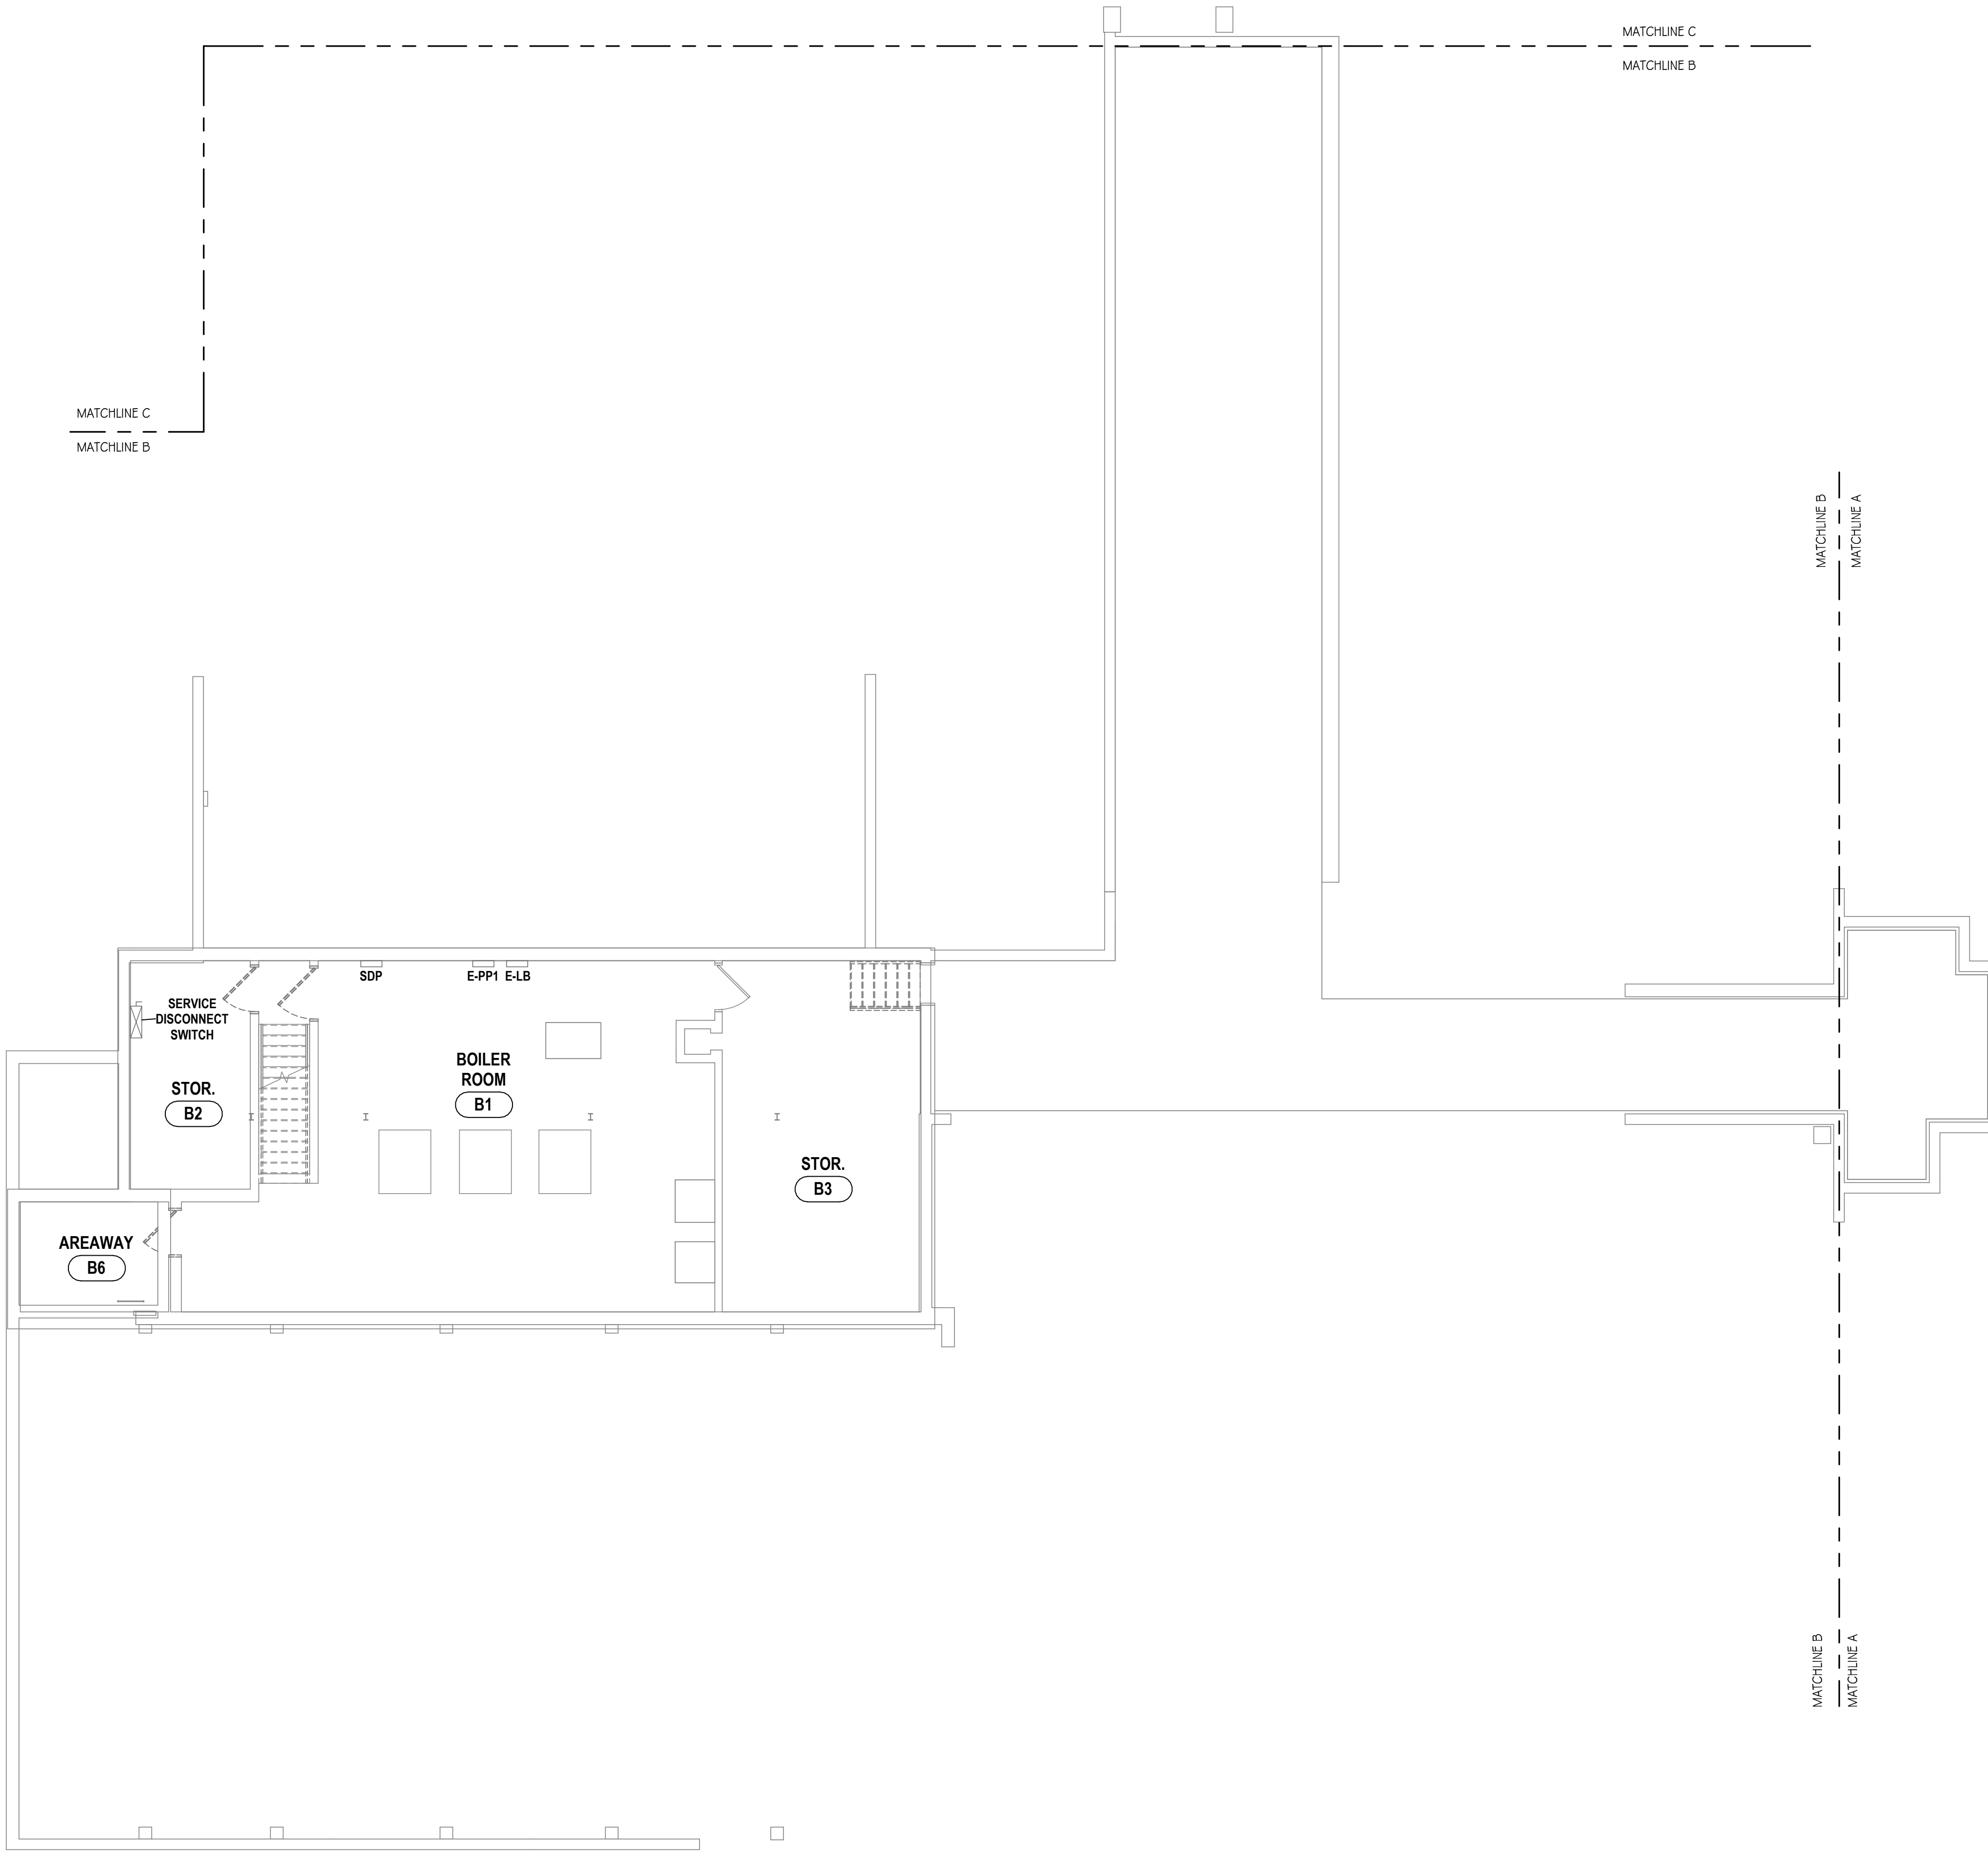


1 BASEMENT ELECTRICAL DEMOLITION PLAN - AREA B
1/8" = 1'-0"

GENERAL NOTES - ELECTRICAL

- A ALL WORK ON THIS DRAWING IS THE RESPONSIBILITY OF THE ELECTRICAL CONTRACTOR (E.C.) UNLESS CLEARLY INDICATED TO BE PART OF ANOTHER PRIME CONTRACT.
- B PRIOR TO CONSTRUCTION AND INSTALLATION, E.C. SHALL VERIFY EXISTING CONDITIONS AND NOTIFY ENGINEER/ARCHITECT OF CONFLICTS AND CONDITIONS WHICH INTERFERE WITH INSTALLATION AS SET FORTH IN CONTRACT DOCUMENTS.
- C E.C. IS RESPONSIBLE FOR ALL NEW WALL OPENINGS, EXCAVATIONS, AND PENETRATIONS, UNLESS SPECIFICALLY NOTED. UPON COMPLETION, ALL PENETRATIONS TO BE SEALED TO MAINTAIN FIRE RATING AS SPECIFIED ON ARCHITECTURAL DRAWINGS.
- D ALL CUTTING AND PATCHING SHALL BE THE RESPONSIBILITY OF THE E.C. UNLESS CLEARLY INDICATED AS PART OF ANOTHER PRIME CONTRACT.
- E MINIMUM CONDUIT SIZE USED ON THIS PROJECT SHALL BE 3/4" UNLESS OTHERWISE NOTED.
- F MINIMUM WIRE SIZE USED ON THIS PROJECT SHALL BE #12 THINWALL UNLESS OTHERWISE NOTED.
- G ALL CABLING INSTALLATIONS AND TERMINATIONS TO ADHERE TO CURRENT NEC CODES AND RELATED ANS/IT/IEA STANDARDS.
- H DURING DEMOLITION OF EXISTING CABLING, ANY DAMAGE TO FUNCTIONING CABLING SYSTEM IS THE RESPONSIBILITY OF AND WILL BE REPAIRED BY THE CONTRACTOR.
- I THE CONTRACTOR SHALL BE AWARE OF THE PRESENCE OF EXISTING ASBESTOS CONTAINING MATERIAL SCHEDULED TO REMAIN IN PLACE WITHIN THE PROJECT SCOPE. ANY WORK REQUIRED THAT HAS THE POTENTIAL TO DISTURB HAZARDOUS MATERIALS SHALL BE COORDINATED DIRECTLY WITH THE OWNER.
- J ELECTRICAL DEVICES, MATERIALS, AND PACKAGED EQUIPMENT SHALL BE LISTED AND LABELED BY UNDERWRITERS LABORATORIES INC. (UL).
- K NEW CIRCUIT BREAKER(S) THAT ARE TO BE ADDED TO EXISTING PANELBOARD(S) SHALL BE LISTED/LABELED FOR USE WITH THE EXISTING PANELBOARD(S).
- L THE SHORT-CIRCUIT RATINGS OF ALL PROTECTIVE DEVICES SHALL BE EQUAL TO OR EXCEED THE AVAILABLE SHORT-CIRCUIT CURRENT.
- M ALL WORK TO CONFORM TO CURRENT NEC AND ALL APPLICABLE CODES.
- N E.C. TO NOTIFY ELECTRICAL ENGINEER FOR INSPECTION OF ALL INSTALLATIONS BEFORE BEING BURIED OR COVERED.
- O ALL ELECTRICAL DEVICES SCHEDULED FOR REMOVAL ARE CONSIDERED PROPERTY OF THE OWNER. ELECTRICAL DEVICES SHALL BE PLACED IN AN AREA DESIGNATED BY THE OWNER. ANY DEVICE THE OWNER WISHES NOT TO KEEP SHALL BE DISPOSED OF BY THE CONTRACTOR.
- P E.C. IS RESPONSIBLE FOR DISCONNECTING POWER TO ANY MECHANICAL/PLUMBING EQUIPMENT SCHEDULED TO BE REMOVED OR REPLACED. COORDINATE WORK WITH MECHANICAL/PLUMBING WORK CONTRACTORS) AND DRAWINGS.
- Q E.C. IS RESPONSIBLE FOR COORDINATING ALL CONDUIT LOCATIONS IN FIREWALLS WITH THE GENERAL CONTRACTOR (G.C.). A MAXIMUM OF ONE PIECE OF CONDUIT IS ALLOWED IN AN UNREINFORCED CORE. NO CONDUIT SHALL BE PLACED IN A VERTICALLY REINFORCED CORE IN A FIREWALL. REFER TO "S-SERIES" DRAWINGS FOR FIREWALL LOCATIONS.
- R ALL NEW ELECTRICAL DEVICES SUCH AS, BUT NOT LIMITED TO, FIRE ALARM DEVICES, SMOKE DETECTORS, LIGHT FIXTURES, EXIT SIGNS, OCCUPANCY/VACANCY SENSORS, AND NON-KEYED SWITCHES ARE REQUIRED TO HAVE IMPACT PROTECTION THROUGH MEANS OF IMPACT RESISTANT COVERS, OR WIRE GUARDS IN LOCKER ROOMS, GYMNASIUMS, WEIGHT ROOMS, FITNESS CENTERS, WRESTLING ROOMS, AND CAFETERIAS.
- S MANY LIGHTING FIXTURES AND DEVICES ARE TO BE DEMOLISHED / FURNISHED & INSTALLED BY OTHERS UNDER A SEPARATE ENERGY PERFORMANCE CONTRACT, AND ARE SHOWN AS REFERENCE ONLY. ALL WORK RELATED TO EMERGENCY LIGHT FIXTURES SHALL BE BY ELECTRICAL CONTRACTOR. OTHERS SHALL DISCONNECT AND REMOVE NORMAL LIGHTING FIXTURES BACK TO A LOCAL JUNCTION POINT. E.C. IS RESPONSIBLE FOR THE REMAINDER OF THE LIGHTING DEMOLITION UPON LIGHT FIXTURE REMOVAL, INCLUDING DISCONNECTION & REMOVAL OF ALL ASSOCIATED WIRE, CONDUIT, BOXES, SWITCHES, SENSORS, ETC. COMPLETELY BACK TO SOURCE. NEW LIGHTING FIXTURES AND DEVICES ARE TO BE FURNISHED & INSTALLED BY OTHERS, UNLESS NOTED OTHERWISE. E.C. TO PROVIDE LIGHTING BRANCH CIRCUIT HOMERUNS FROM ELECTRICAL PANEL(S) INDICATED ON PLANS TO A JUNCTION BOX IN EACH SPACE IDENTIFIED FOR NEW LIGHTING. E.C. TO ALSO PROVIDE APPROPRIATE WALL SWITCH BOX(ES) FOR ASSOCIATED LIGHTING CONTROL SWITCH(ES) IN EACH SPACE IDENTIFIED FOR NEW LIGHTING.

DEMOLITION NOTES - ELECTRICAL

- D1 EXISTING DEVICES ON THIS ENTRY TO BE DISCONNECTED AND STORED IN A SAFE DRY PLACE FOR RE-USE.
- D2 BY BASE BID, REMOVE ALL ELECTRICAL DEVICES IN SPACE. EXISTING FIRE ALARM DEVICES TO BE STORED AND RE-USED.
- D3 BY ALT. #1, REMOVE ALL ELECTRICAL DEVICES IN SPACE. EXISTING FIRE ALARM DEVICES TO BE STORED AND RE-USED.
- D4 DISCONNECT AND REMOVE ALL ELECTRICAL DEVICES IN THIS SPACE. REMOVE ALL WIRE, CONDUIT, RACEWAY, BOXES, AND SUPPORTS COMPLETE BACK TO SOURCE. EXISTING DEVICES TO BE RE-USED.
- D5 DISCONNECT AND REMOVE EXISTING CEILING LIGHT. SECURE EXISTING SWITCHING CIRCUITRY FOR REUSE. TURN OVER LIGHT FIXTURE TO OWNER.

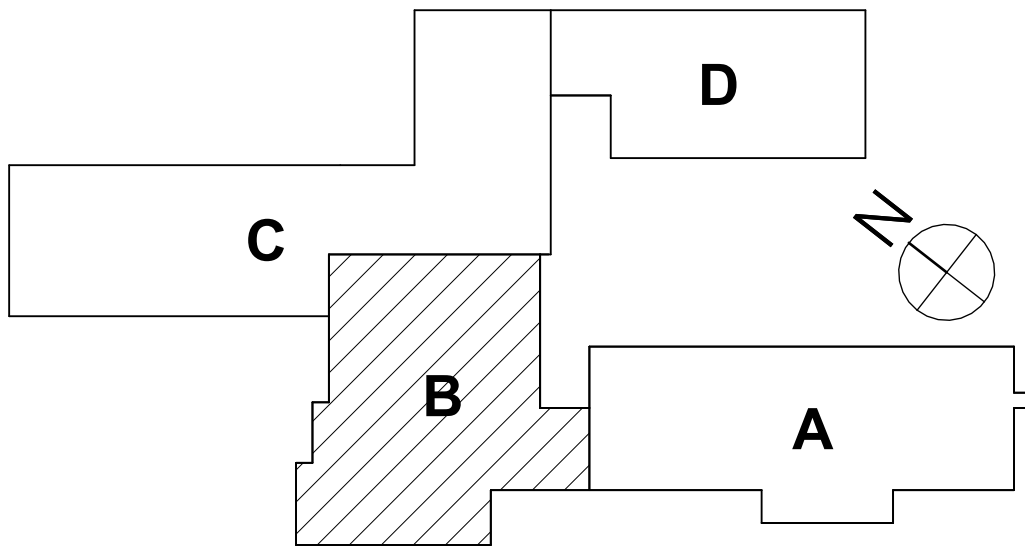

SEE NUMBERS EV-01-00-01-000-007, AD-01-00-01-001-013

BASEMENT DEMOLITION PLAN - AREA B

2025 ERWIN VALLEY ELEM & ADMIN BUILDING ALTERATIONS
CORNING-PAINTED POST AREA SCHOOL DISTRICT

16 BEARTOWN ROAD, PAINTED POST, NY 14870

EV-E0.1

PROJECT NO: 2649-160

DESCRIPTION OF REVISION:
ISSUED FOR BID

DATE:
1 10/12/2026

IT IS A VIOLATION OF THE LAW FOR ANY PERSON TO MAKE UNAUTHORIZED ALTERATIONS OR ADDITIONS TO PLANS
DRAWN BY: TAWO
CHECKED BY: GJB
DATE: 03/17/2026
PHASE: CD

Copyright 2026
HUNT ENGINEERS | ARCHITECTS | SURVEYORS
HORSEHEADS, NY 607-265-1000 ROCHESTER, NY 585-537-7668 TOWNAND, PA 570-265-4668
BINGHAMTON, NY 607-798-8881 ALBANY, NY 607-798-8881
WWW.HUNTEAS.COM
NY CERTIFICATE NO. 001620 PA CERTIFICATE NO. TSC220313/464-1


HUNT ENGINEERS | ARCHITECTS | SURVEYORS

GENERAL NOTES - ELECTRICAL


REFER TO SHEET EV-E0.1

DEMOLITION NOTES - ELECTRICAL

- D1 EXISTING DEVICES ON THIS ENTRY TO BE DISCONNECTED AND STORED IN A SAFE DRY PLACE FOR RE-USE.
D2 BY BASE BID, REMOVE ALL ELECTRICAL DEVICES IN SPACE. EXISTING FIRE ALARM DEVICES TO BE STORED AND RE-USED.
D3 BY ALT. #1, REMOVE ALL ELECTRICAL DEVICES IN SPACE. EXISTING FIRE ALARM DEVICES TO BE STORED AND RE-USED.
D4 DISCONNECT AND REMOVE ALL ELECTRICAL DEVICES IN THIS SPACE. REMOVE ALL WIRE, CONDUIT, RACEWAY, BOXES, AND SUPPORTS COMPLETE BACK TO SOURCE. EXISTING DEVICES TO BE RE-USED.
D5 DISCONNECT AND REMOVE EXISTING CEILING LIGHT. SECURE EXISTING SWITCHING CIRCUITRY FOR REUSE. TURN OVER LIGHT FIXTURE TO OWNER.

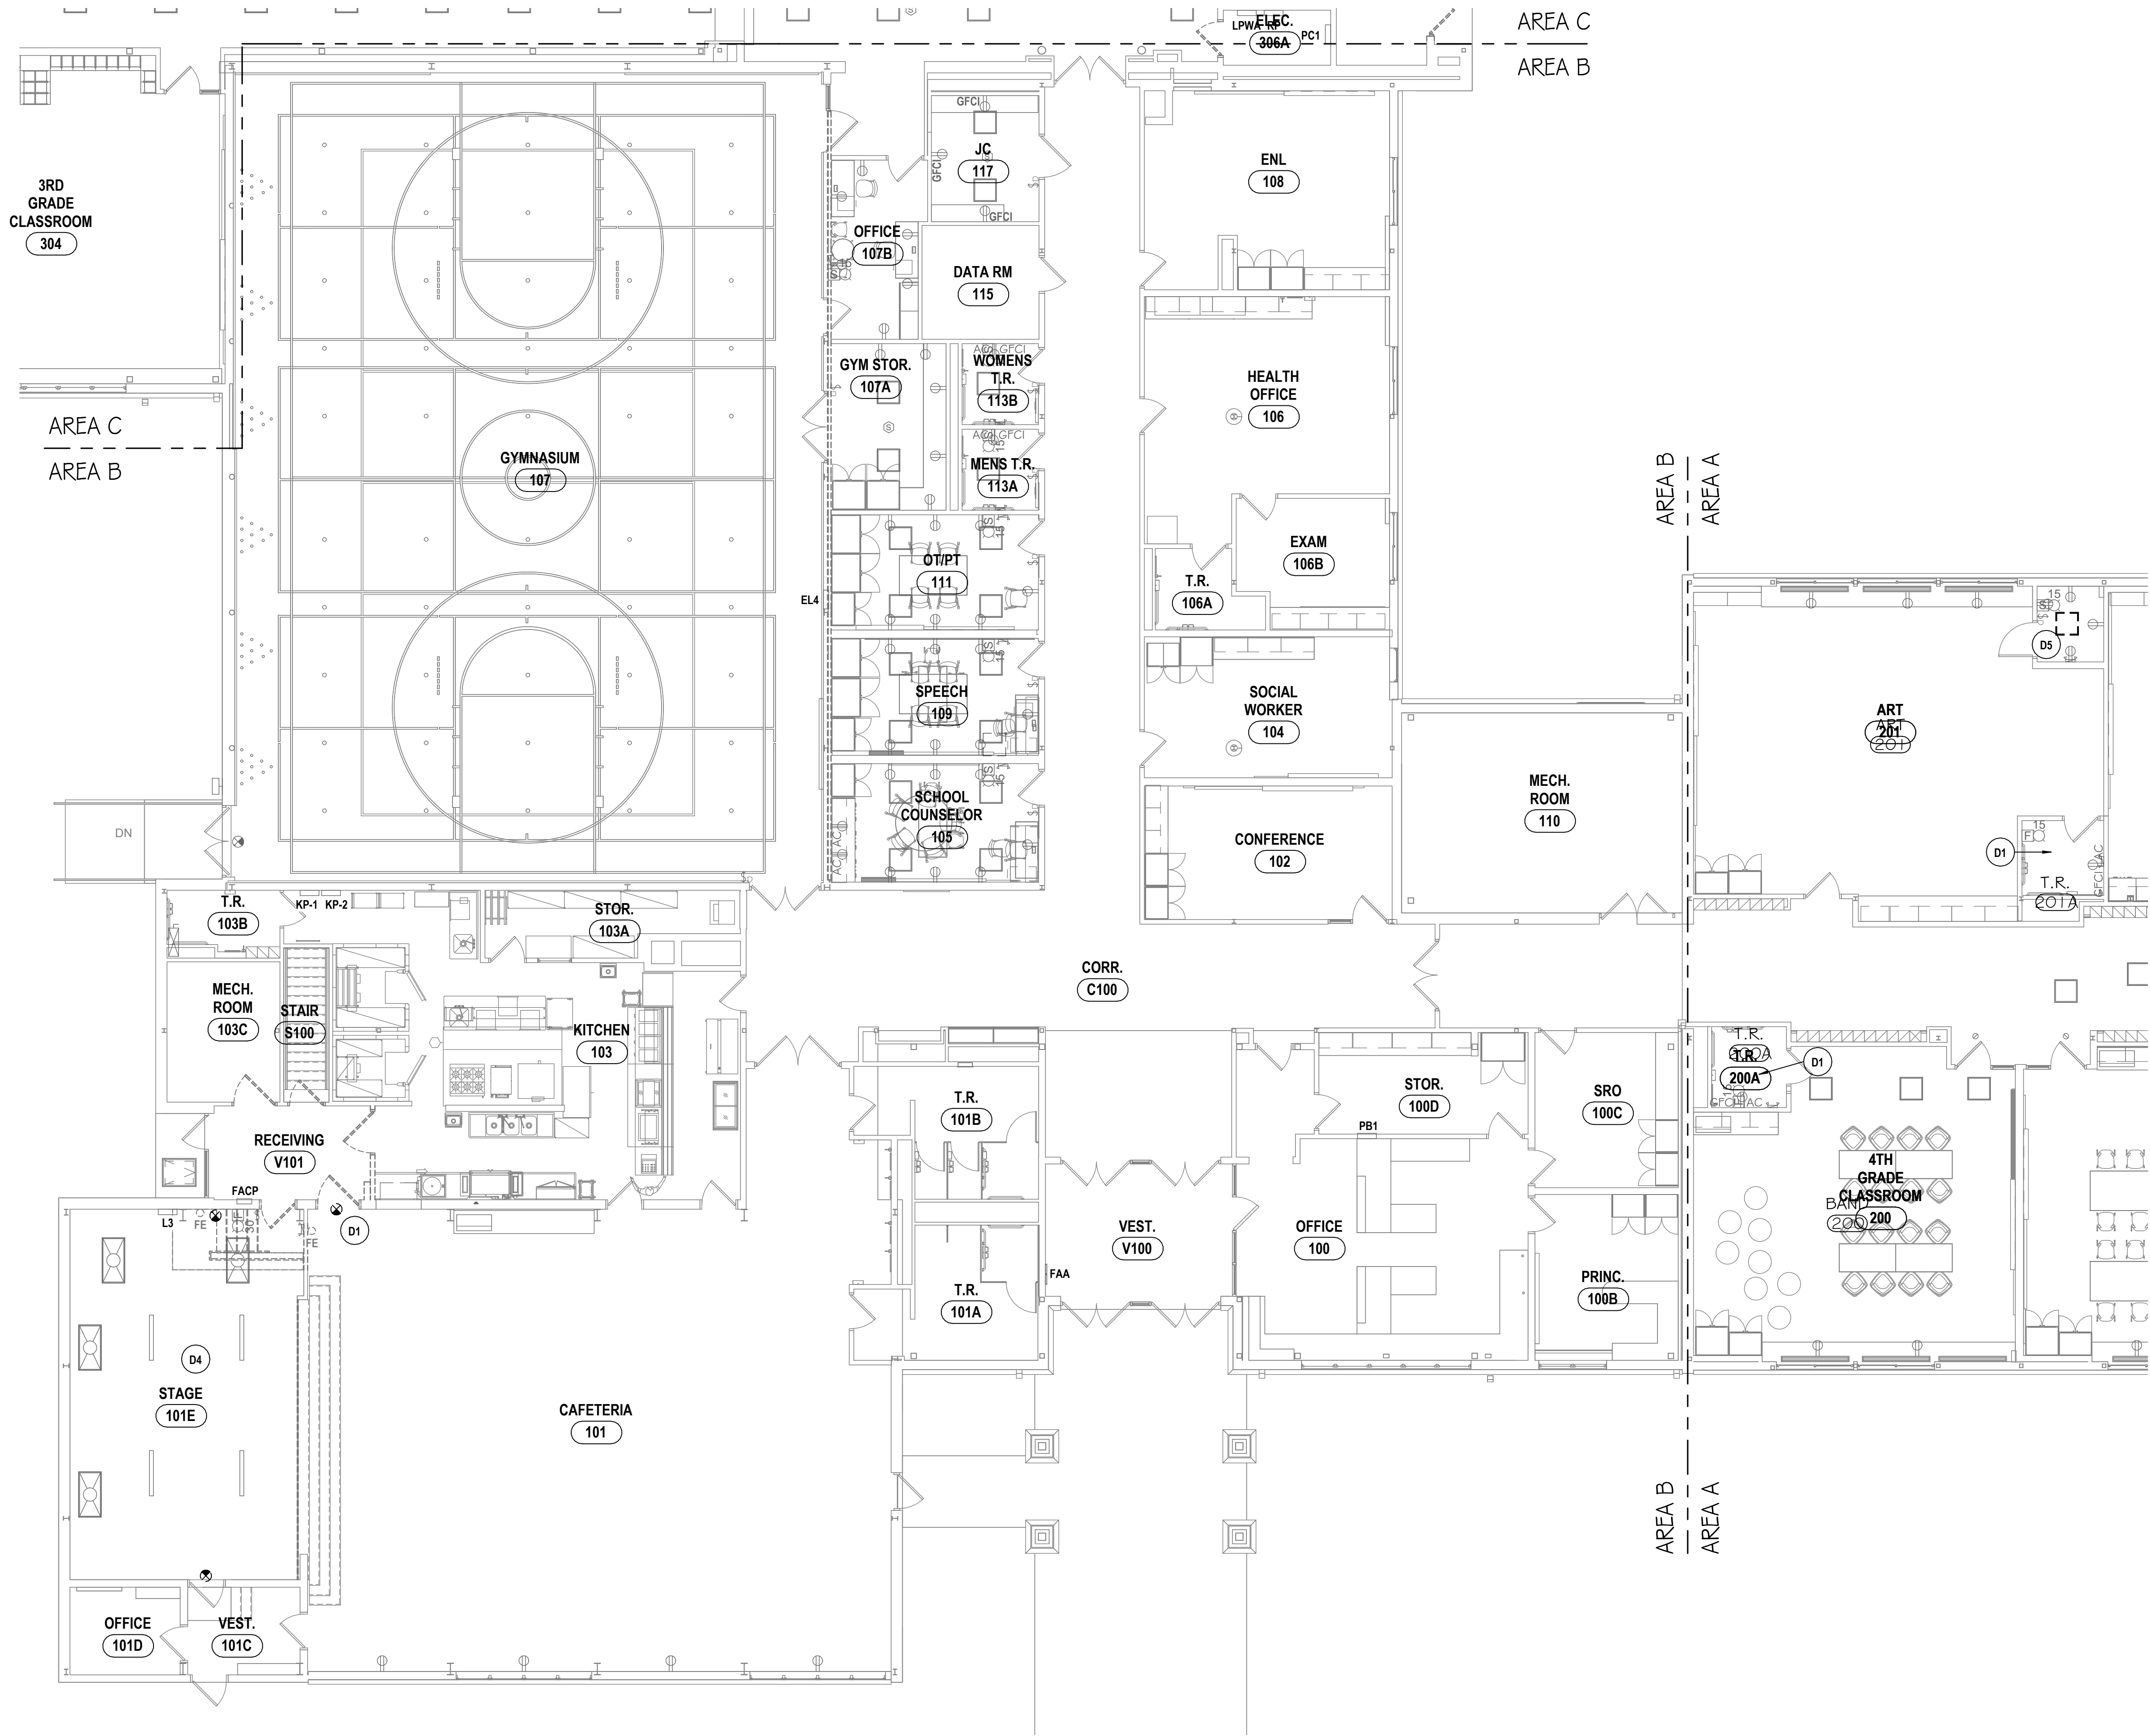

1 FIRST FLOOR ELECTRICAL DEMOLITION PLAN - AREA B
1/8" = 1'-0"

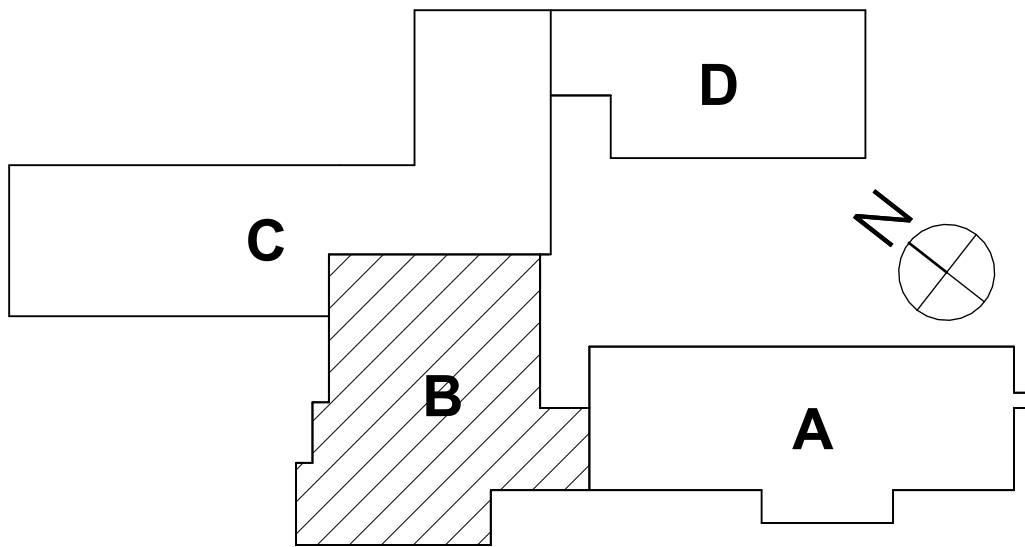

SEE NUMBERS EV-01-00-01-000-007, AD-01-00-01-001-013

FIRST FLOOR DEMOLITION PLAN - AREA B

2025 ERWIN VALLEY ELEM & ADMIN BUILDING ALTERATIONS
CORNING-PAINTED POST AREA SCHOOL DISTRICT

16 BEARTOWN ROAD, PAINTED POST, NY 14870

EV-E0.2

PROJECT NO: 2649-160

HUNT ENGINEERS | ARCHITECTS | SURVEYORS

HORSEHEADS, NY 10803 ROCHESTER, NY 585-537-7849 TOWNANDA, PA 570-265-4668

BINGHAMTON, NY 607-798-8881 ALBANY, NY 607-798-8801

WWW.HUNTEAS.COM

NY CERTIFICATE NO. 001920 PA CERTIFICATE NO. TSC220313464-1

DATE: 1 18/12/2026

DESCRIPTION OF REVISION: ISSUED FOR BID

DRAWN BY: TAWO

CHECKED BY: GJB

DATE: 03/17/2026

PHASE: CP

Copyright 2026


IT IS A VIOLATION OF THE LAW FOR ANY PERSON TO MAKE UNAUTHORIZED ALTERATIONS OR ADDITIONS TO PLANS DRAWN BY LICENSED ENGINEERS, ARCHITECTS OR SURVEYORS.

GENERAL NOTES - ELECTRICAL


REFER TO SHEET EV-E0.1

DEMOLITION NOTES - ELECTRICAL

- D1 EXISTING DEVICES ON THIS ENTRY TO BE DISCONNECTED AND STORED IN A SAFE DRY PLACE FOR RE-USE.
D2 BY BASE BID, REMOVE ALL ELECTRICAL DEVICES IN SPACE. EXISTING FIRE ALARM DEVICES TO BE STORED AND RE-USED.
D3 BY A.L.T. #1, REMOVE ALL ELECTRICAL DEVICES IN SPACE. EXISTING FIRE ALARM DEVICES TO BE STORED AND RE-USED.
D4 DISCONNECT AND REMOVE ALL ELECTRICAL DEVICES IN THIS SPACE. REMOVE ALL WIRE, CONDUIT, RACEWAY, BOXES, AND SUPPORTS COMPLETE BACK TO SOURCE. EXISTING DEVICES TO BE RE-USED.
D5 DISCONNECT AND REMOVE EXISTING CEILING LIGHT. SECURE EXISTING SWITCHING CIRCUITRY FOR REUSE. TURN OVER LIGHT FIXTURE TO OWNER.

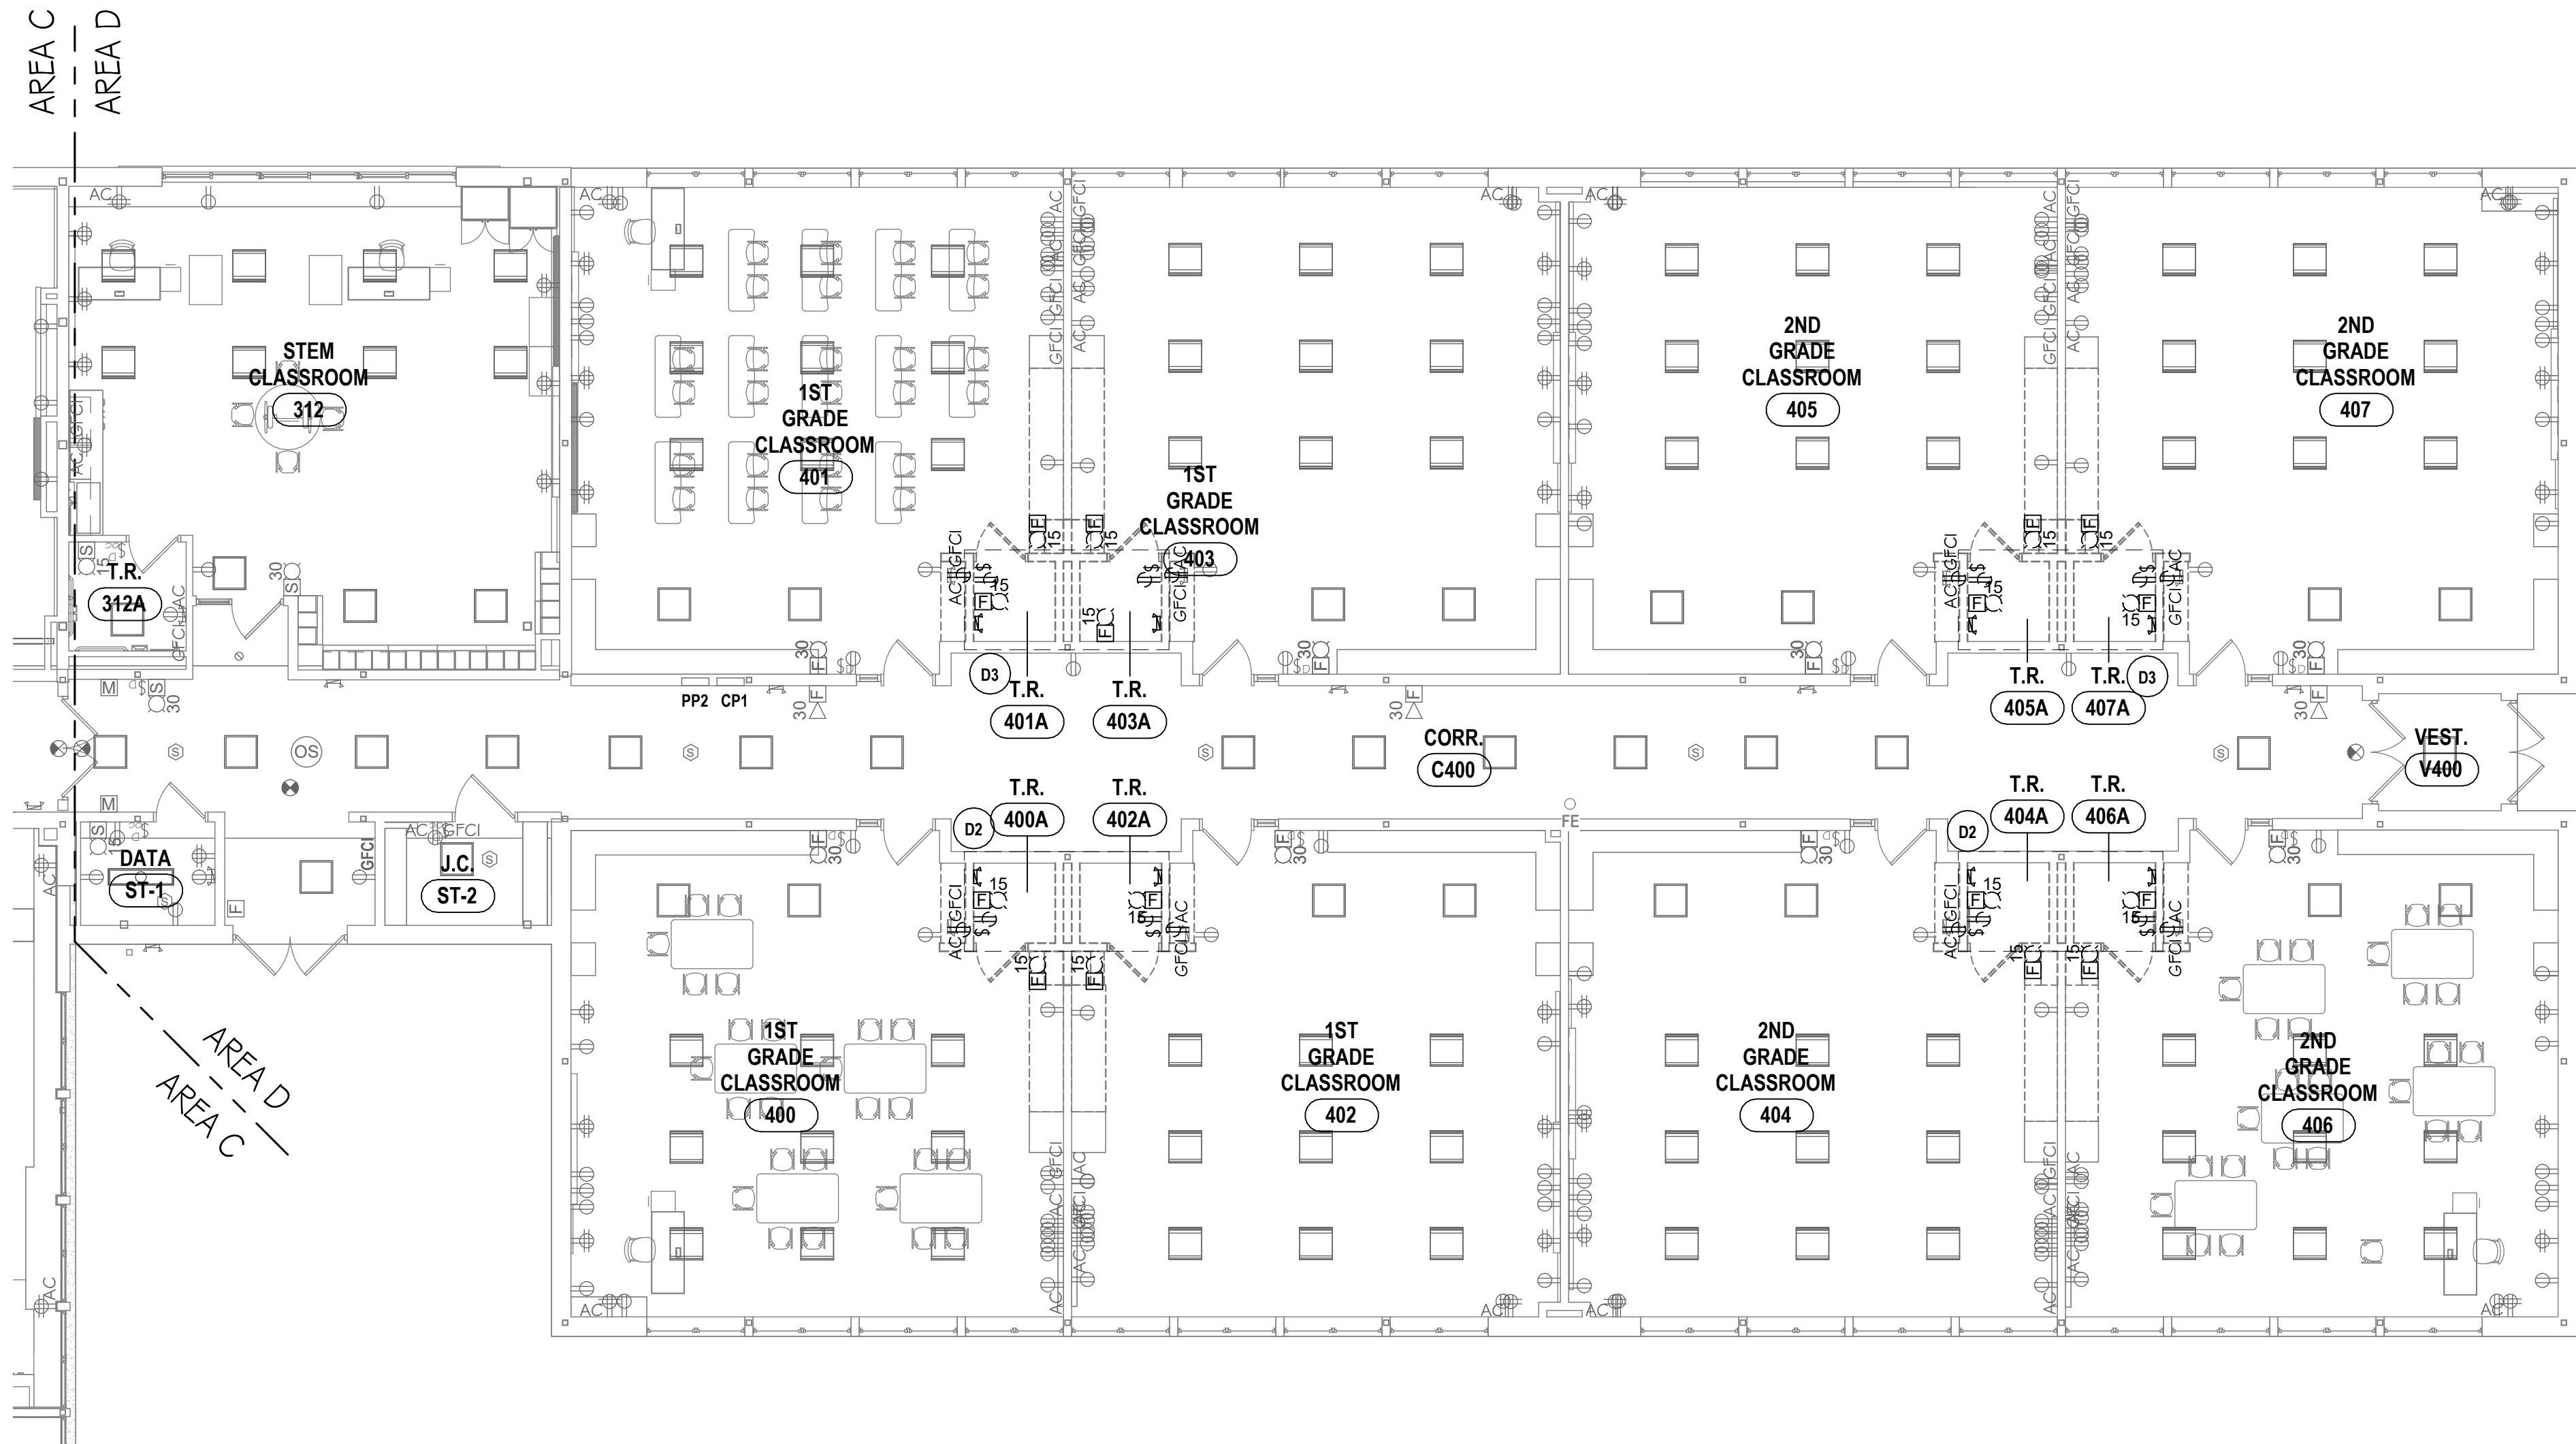

1 FIRST FLOOR ELECTRICAL DEMOLITION PLAN - AREA D
1/8" = 1'-0"

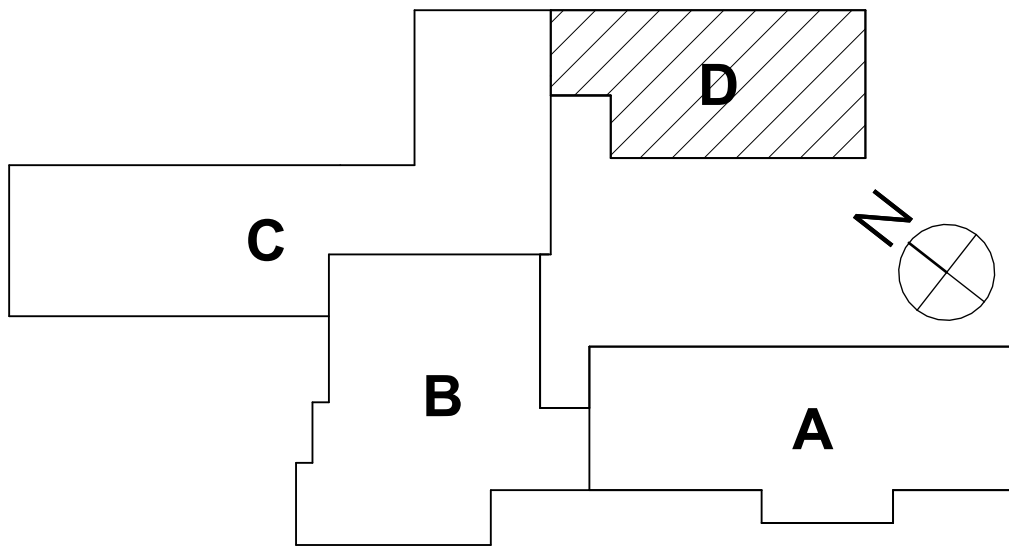

SEE NUMBERS EV-01-00-01-000-007, AD-01-00-01-001-013

FIRST FLOOR DEMOLITION PLAN - AREA D

2025 ERWIN VALLEY ELEM & ADMIN BUILDING ALTERATIONS
CORNING-PAINTED POST AREA SCHOOL DISTRICT

16 BEARTOWN ROAD, PAINTED POST, NY 14870

EV-E0.3

PROJECT NO: 2649-160

HUNT ENGINEERS | ARCHITECTS | SURVEYORS

HORSEHEADS, NY 607-263-1000 ROCHESTER, NY 585-537-7849 TOWNANDA, PA 570-265-4606

BINGHAMTON, NY 607-798-8881 ALBANY, NY 807-788-8801

WWW.HUNTEAS.COM

NY CERTIFICATE NO. 001620 PA CERTIFICATE NO. TSC220313464-1

DESCRIPTION OF REVISION:
ISSUED FOR BID

DATE:
1 10/12/2026

IT IS A VIOLATION OF THE LAW FOR ANY PERSON TO MAKE UNAUTHORIZED ALTERATIONS OR ADDITIONS TO PLANS
DRAWING IS LOCKED. UNLOCKING WILL VOID THE CONTRACT'S WARRANTY.

DRAWN BY:
CHECKED BY:

TAWO
GJB

DATE:
03/17/2026


PHASE:

CP


Copyright 2026

REFER TO SHEET EV-E0.

P1	NEW ATS TO BE LOCATED AFTER MAIN SERVICE DISCONNECT. REFER TO ONE LINE DIAGRAM.
P2	FINAL LOCATION ON KITCHEN SERIES DRAWINGS. REFER TO FINAL LOCATION ON KITCHEN SERIES DRAWINGS.
P3	PROVIDE NEW 30A / 2P BREAKER IN PANEL KP2. NEW OUTLET TO BE 30A / 1PH. REFER TO FINAL LOCATION ON KITCHEN SERIES DRAWINGS. CIRCUIT WITH 2#10, #10G, 3/4"C.
P4	HARDWARE SINK FROM 120V CIRCUIT SERVING T.R.
P5	DISCONNECT/RECONNECT EXISTING CIRCUITRY TO MECHANICAL UNITS TO ACCOMMODATE ROOF WORK.
P6	PROVIDE POWER TO MECHANICAL EQUIPMENT. REFER TO EV-5.1.

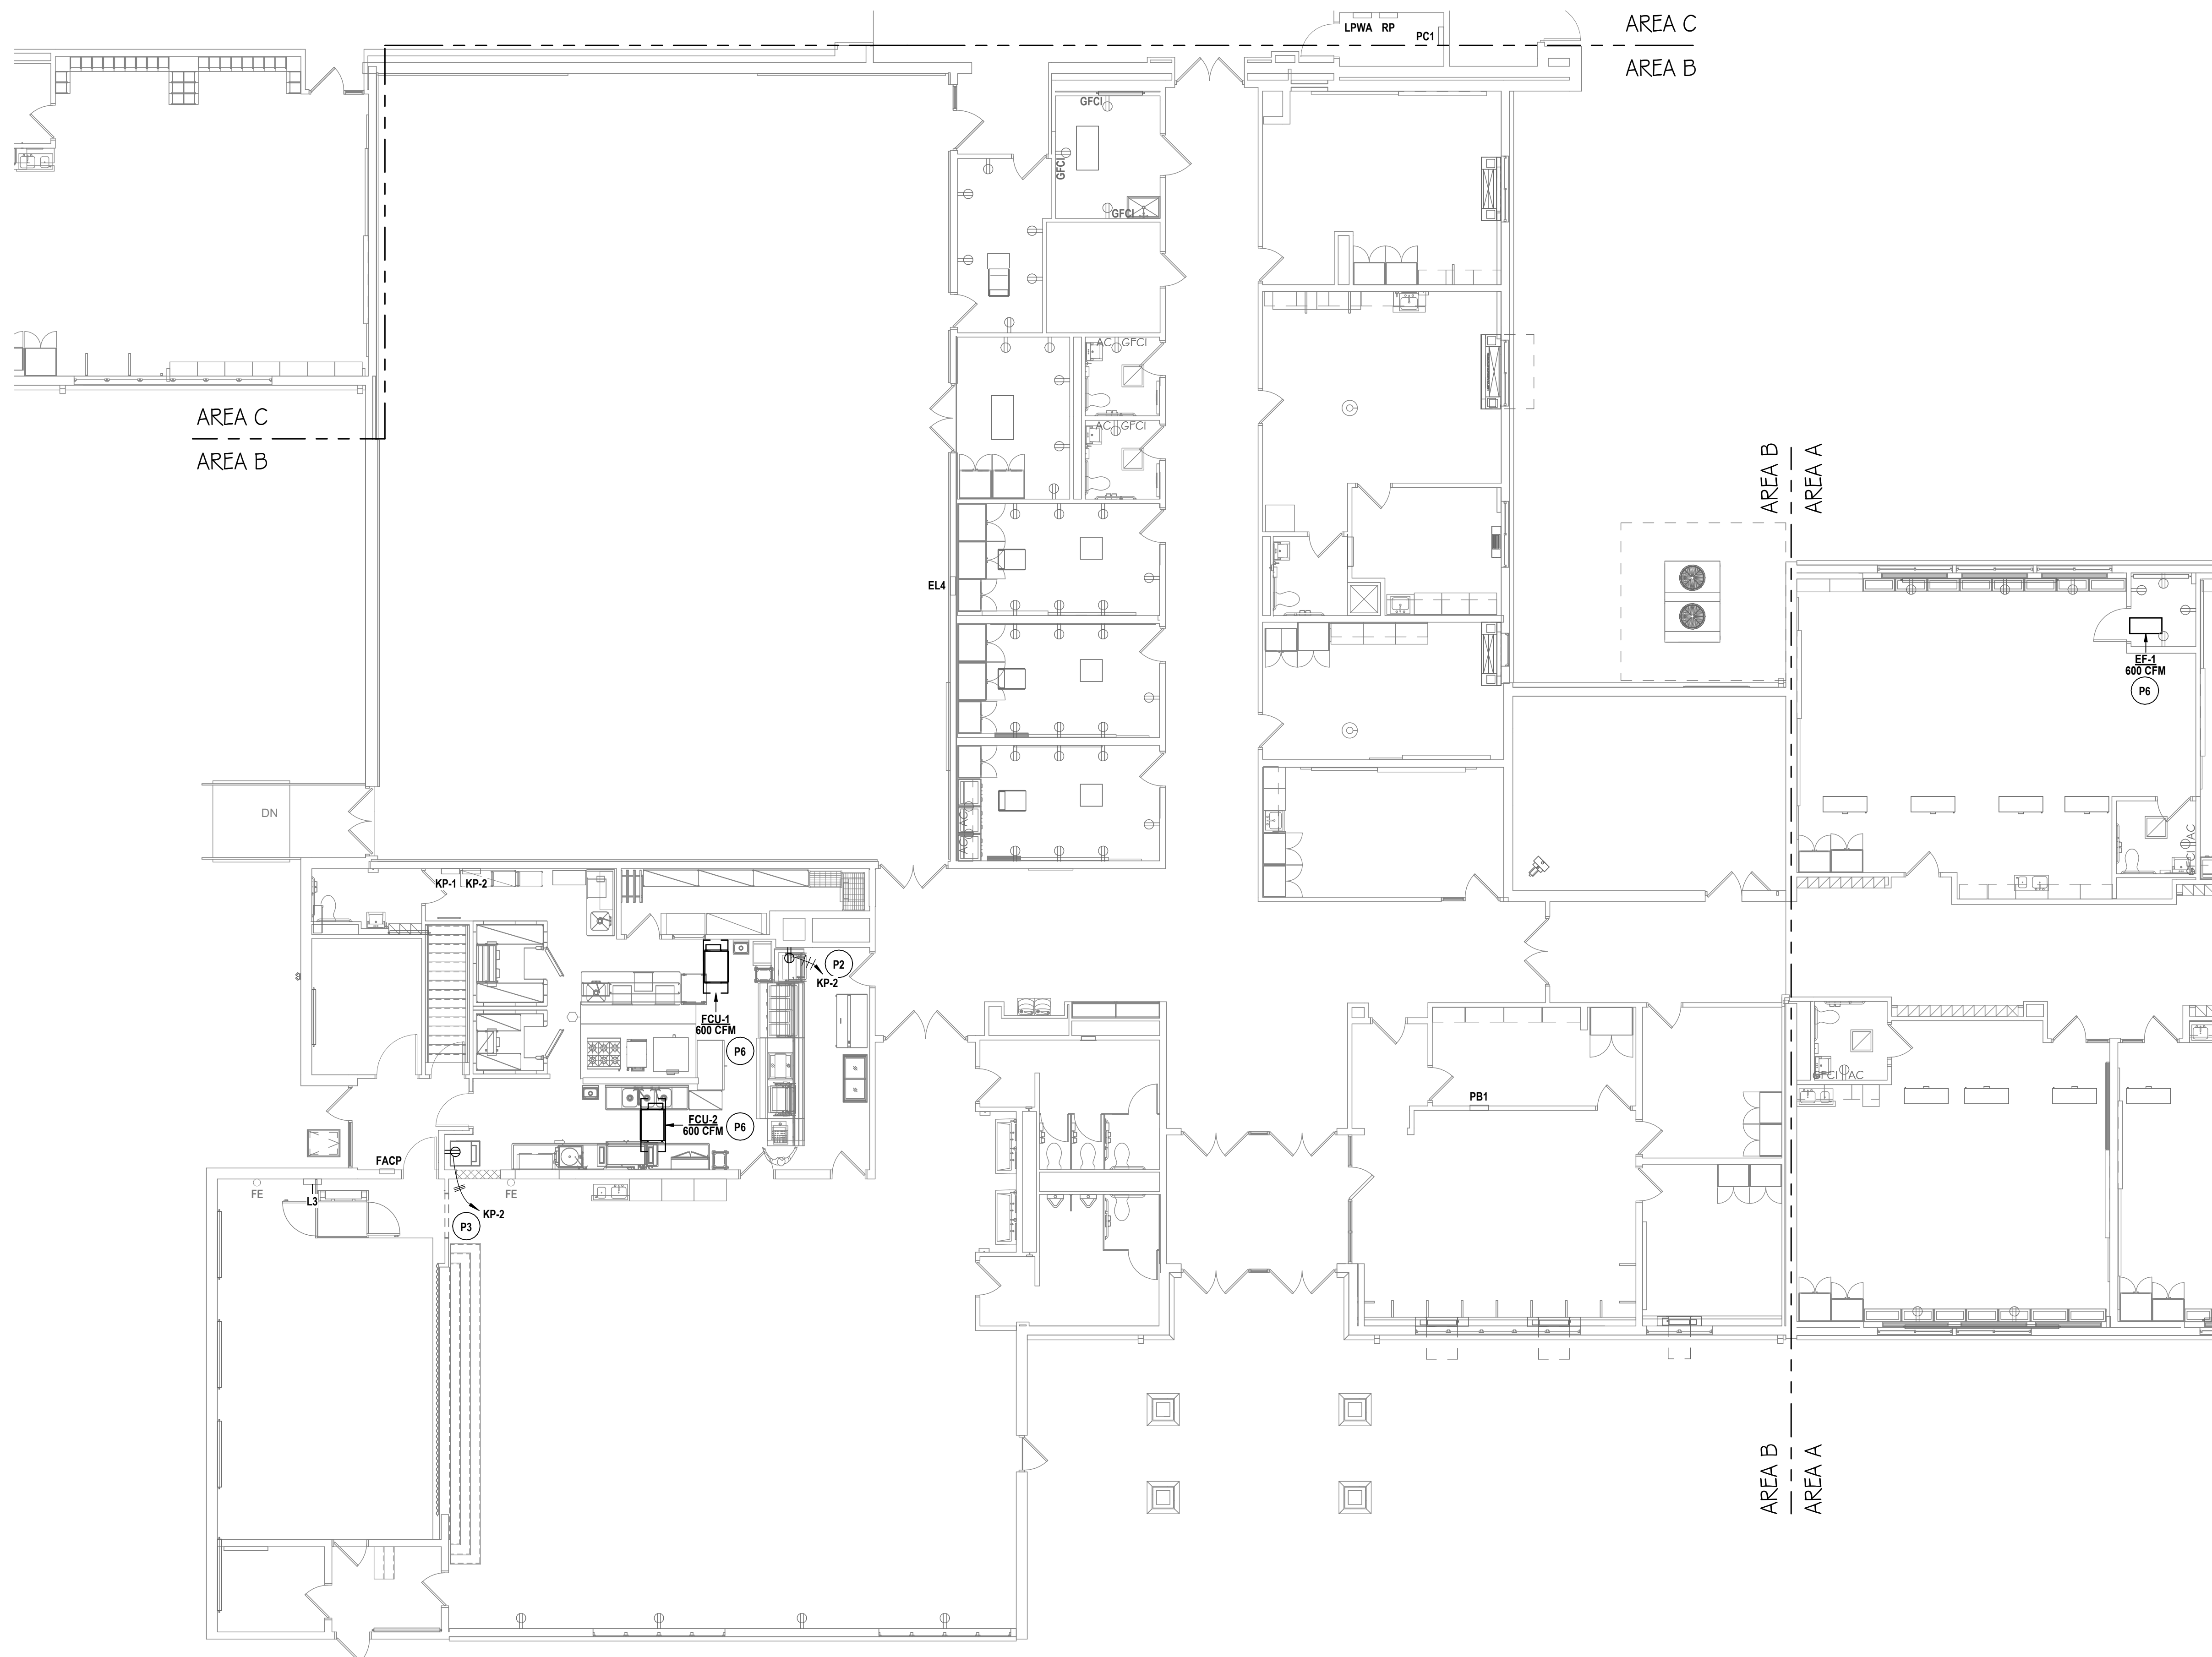

1 FIRST FLOOR POWER PLAN - AREA B
1/8" = 1'-0"

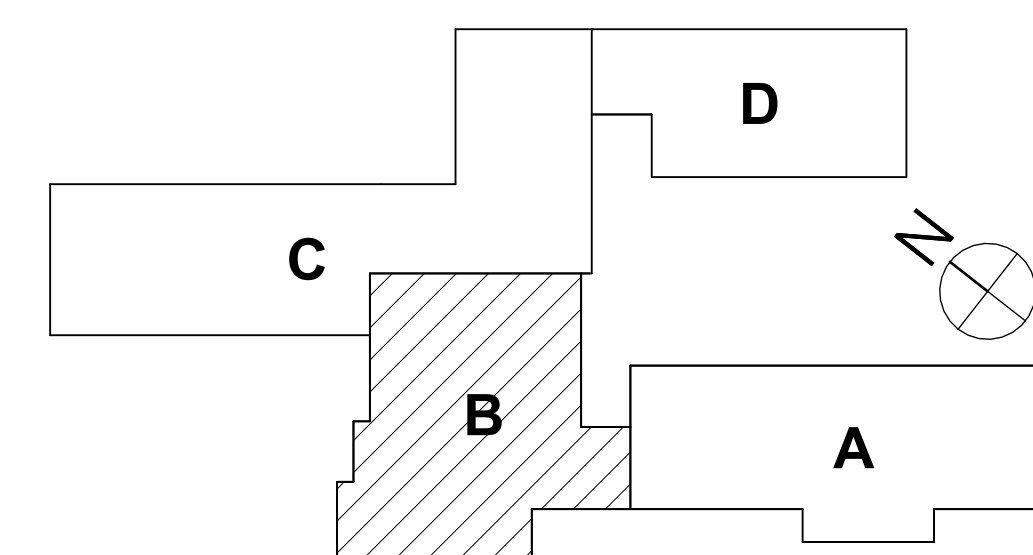

USED NUMBERS EV: 57-10-00-01-0-009-027, AD: 57-10-00-01-1-001-013

2025 ERWIN VALLEY ELEM & ADMIN BUILDING ALTERATIONS
CORNING-PAINTED POST AREA SCHOOL DISTRICT

16 BEARTOWN ROAD, PAINTED POST, NY 14870

EV-E1.2

PROJECT NO: 2649-160

HUNT
ENGINEERS | ARCHITECTS | SURVEYORS

HORSEHEADS, NY 607-358-1000 ROCHESTER, NY 585-327-7949 TOWANDA, PA 570-265-4868

BINGHAMTON, NY 607 - 798 - 8081 ALBANY, NY 607 - 798 - 8081
WWW.HUNT-EAS.COM

NY CERTIFICATE NO. 0018220 PA CERTIFICATE NO. TSC2203131464-1
WWW.HUNT-EAS.COM

#	DATE:	DESCRIPTION OF REVISION:
1	10/12/2026	ISSUED FOR BID

#	DATE:
1	10/12/2026

**DESCRIPTION OF
WORK FOR BID**

REVISION:

--	--

DRAWN
CHECKED
DATE:
PHASE

7


--	--

GENERAL NOTES - ELECTRICAL


REFER TO SHEET EV-E0.1

CONSTRUCTION NOTES - POWER

- P1 NEW ATS TO BE LOCATED AFTER MAIN SERVICE DISCONNECT. REFER TO ONE LINE DIAGRAM.
P2 FINAL LOCATION ON KITCHEN SERIES DRAWINGS. REFER TO FINAL LOCATION ON KITCHEN SERIES DRAWINGS.
P3 PROVIDE NEW 30A / 2P BREAKER IN PANEL KP2. NEW OUTLET TO BE 30A / 1PH. REFER TO FINAL LOCATION ON KITCHEN SERIES DRAWINGS. CIRCUIT WITH 2#10, 1#10G, 3/4"C.
P4 HARDWIRE SINK FROM 120V CIRCUIT SERVING T.R.
P5 DISCONNECT/RECONNECT EXISTING CIRCUITRY TO MECHANICAL UNITS TO ACCOMMODATE ROOF WORK.
P6 PROVIDE POWER TO MECHANICAL EQUIPMENT. REFER TO EV-E5.1.

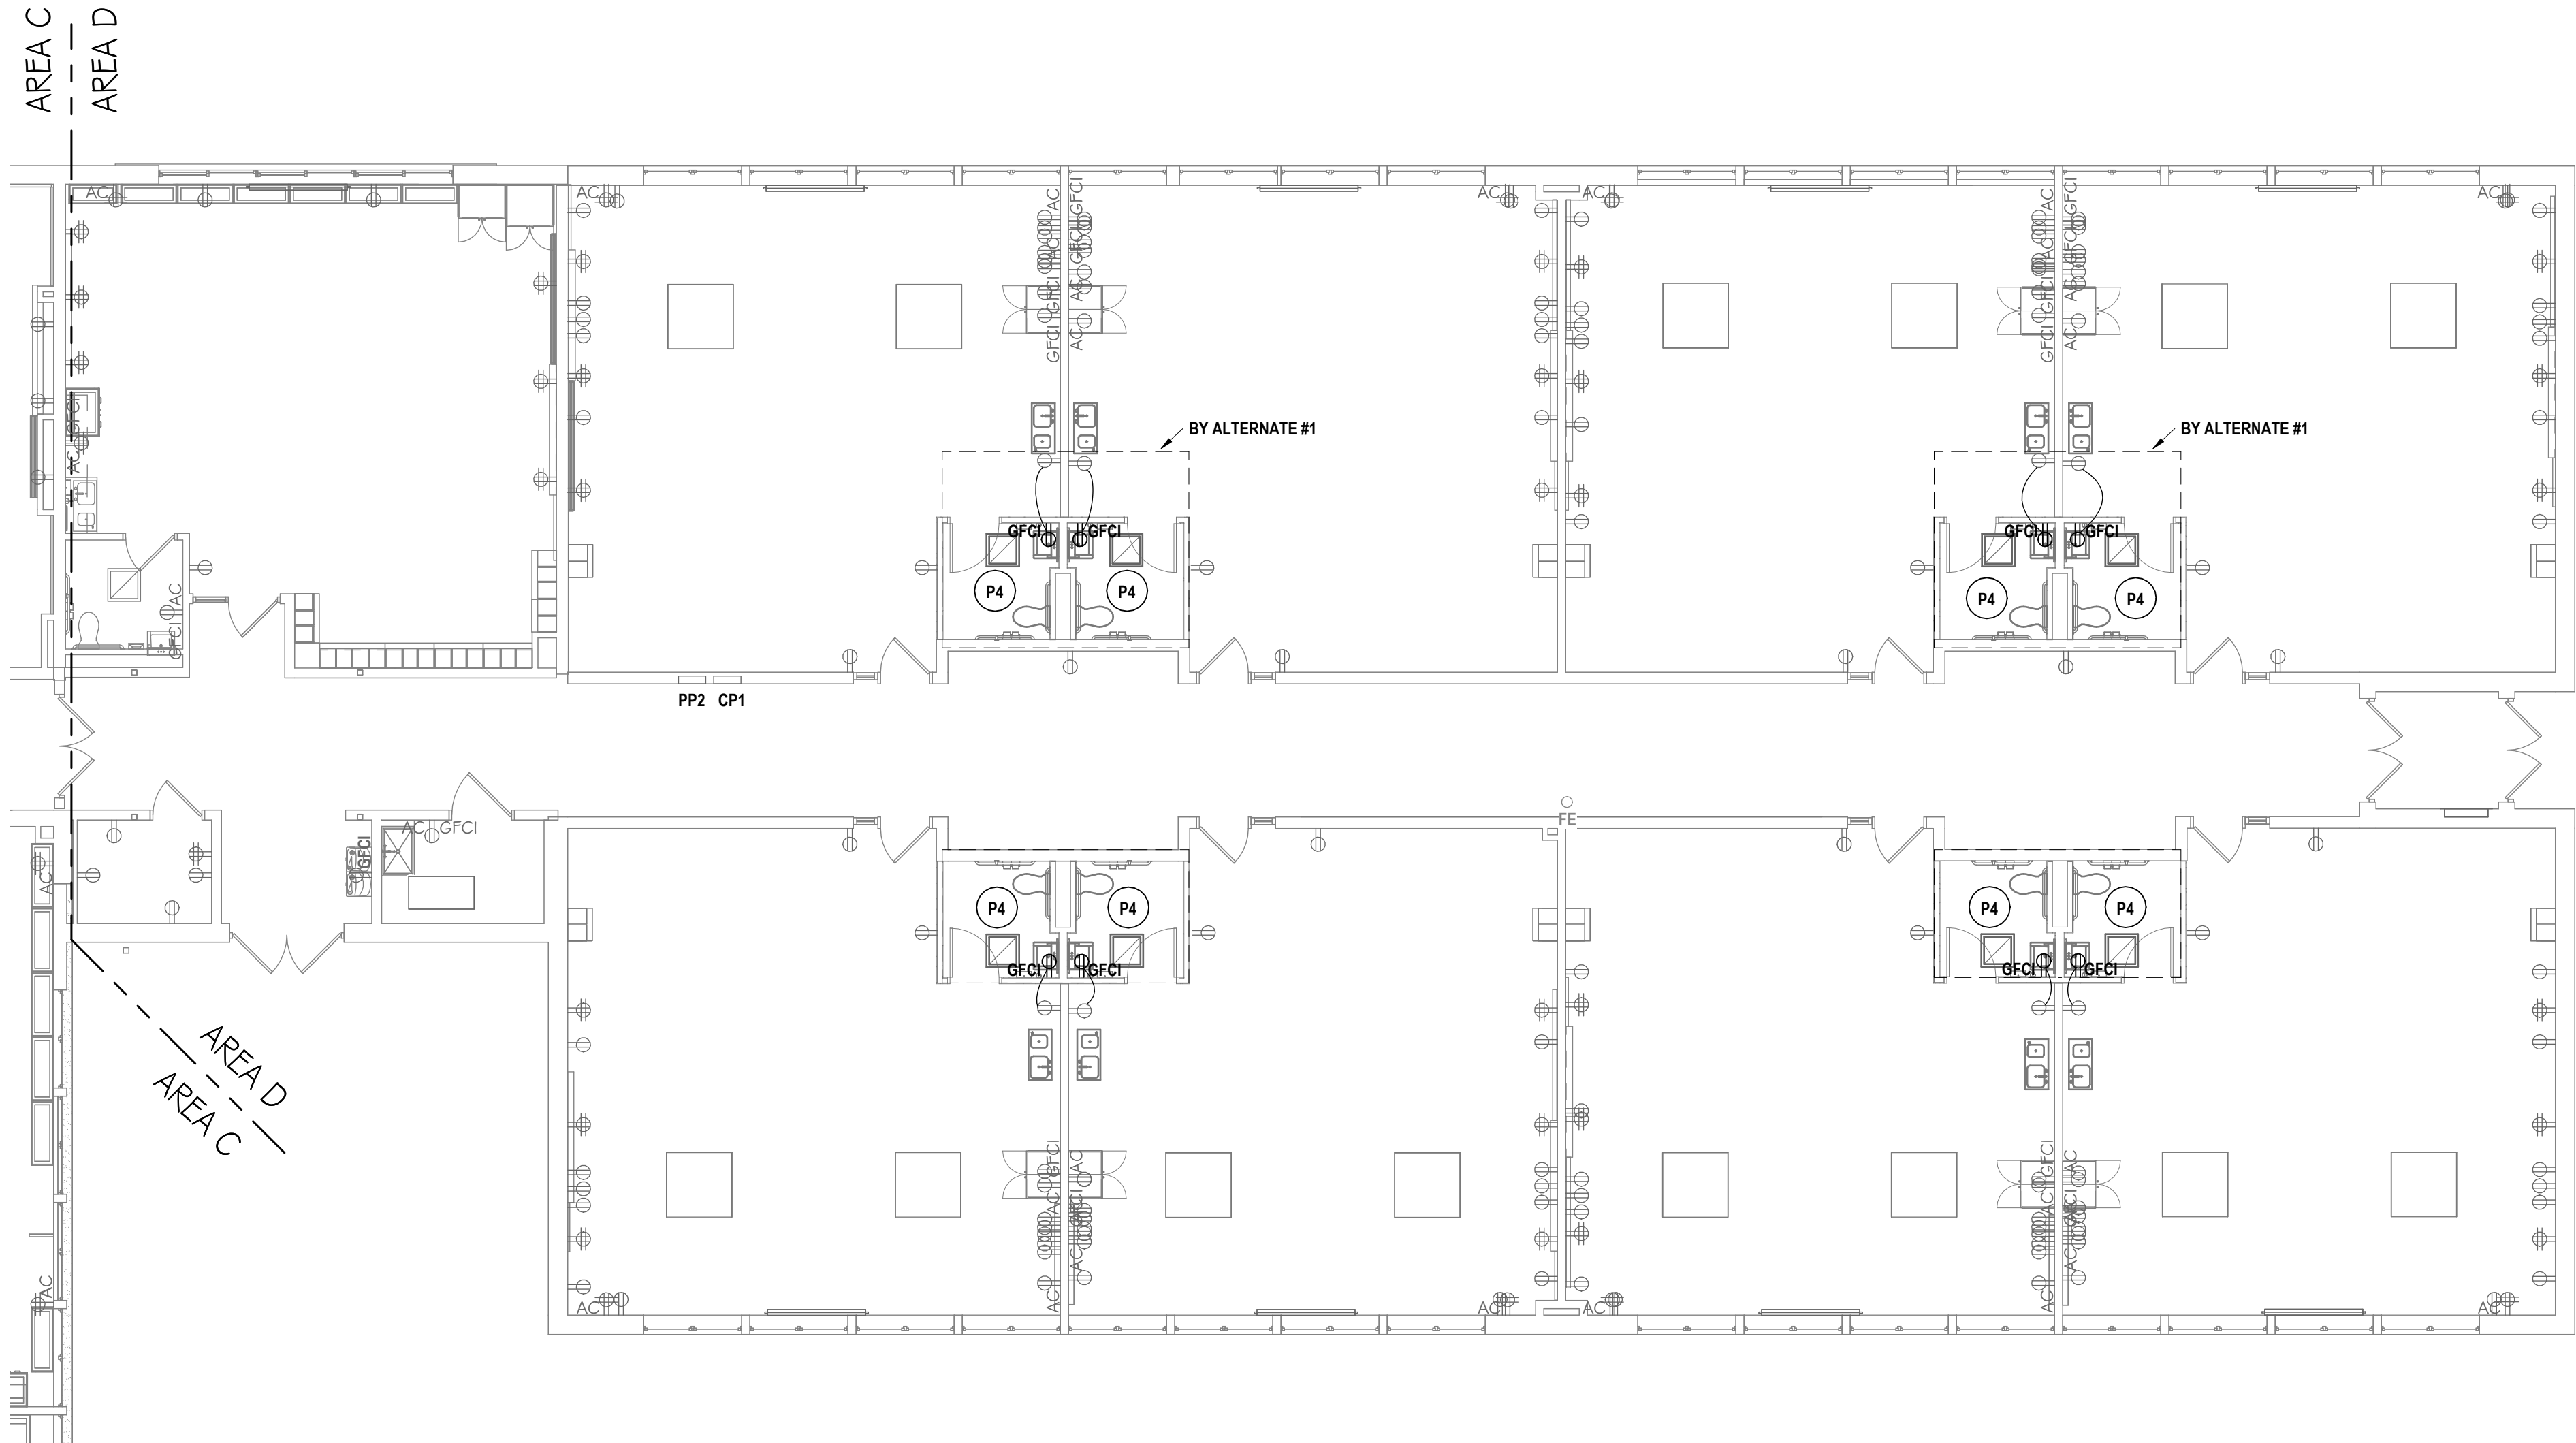

1 FIRST FLOOR POWER PLAN - AREA D
1/8" = 1'-0"

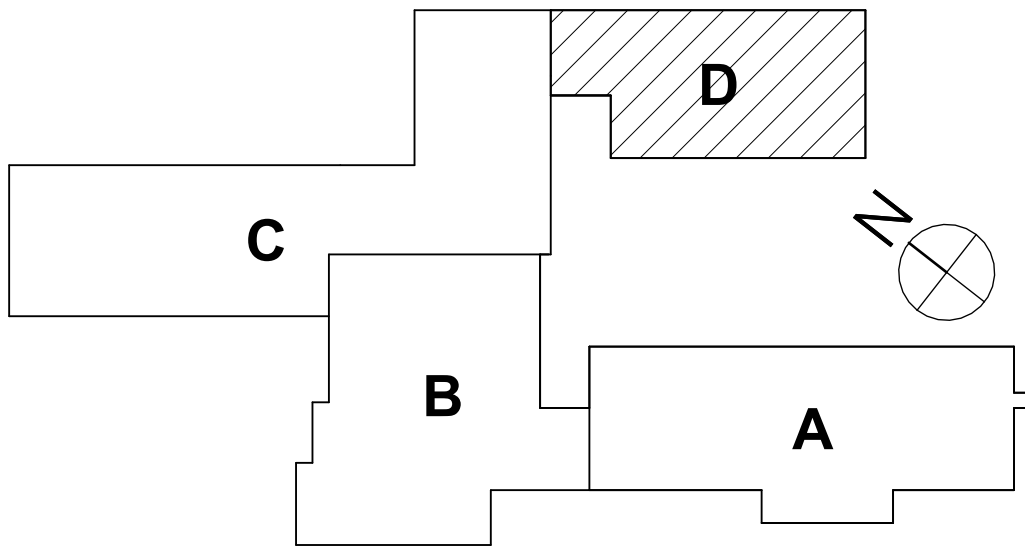

SEE NUMBERS EV-01-00-01-0-009-027, AD-01-00-01-1-001-013

FIRST FLOOR POWER PLAN - AREA D

2025 ERWIN VALLEY ELEM & ADMIN BUILDING ALTERATIONS
CORNING-PAINTED POST AREA SCHOOL DISTRICT

16 BEARTOWN ROAD, PAINTED POST, NY 14870

EV-E1.3

PROJECT NO: 2649-160

HUNT ENGINEERS | ARCHITECTS | SURVEYORS

HORSEHEADS, NY 807-263-1000 ROCHESTER, NY 585-537-7849 TOWNANDA, PA 570-265-4606

BINGHAMTON, NY 807-798-8881 ALBANY, NY 807-798-8801

WWW.HUNTEAS.COM

NY CERTIFICATE NO. 001620 PA CERTIFICATE NO. TSC22013464-1

DATE: 1 10/12/2026

DESCRIPTION OF REVISION:
ISSUED FOR BID

DRAWN BY: TAWO
CHECKED BY: GJB


DATE: 03/17/2026

PHASE: CP

Copy # 263

IT IS A VIOLATION OF THE LAW FOR ANY PERSON TO MAKE UNAUTHORIZED ALTERATIONS OR ADDITIONS TO PLANS
DRAWING IS LOCKED. UNLESS BY ARCHITECT'S OR SURVEYOR'S SEAL.

1 ROOF POWER PLAN - AREA D
1/8" = 1'-0"

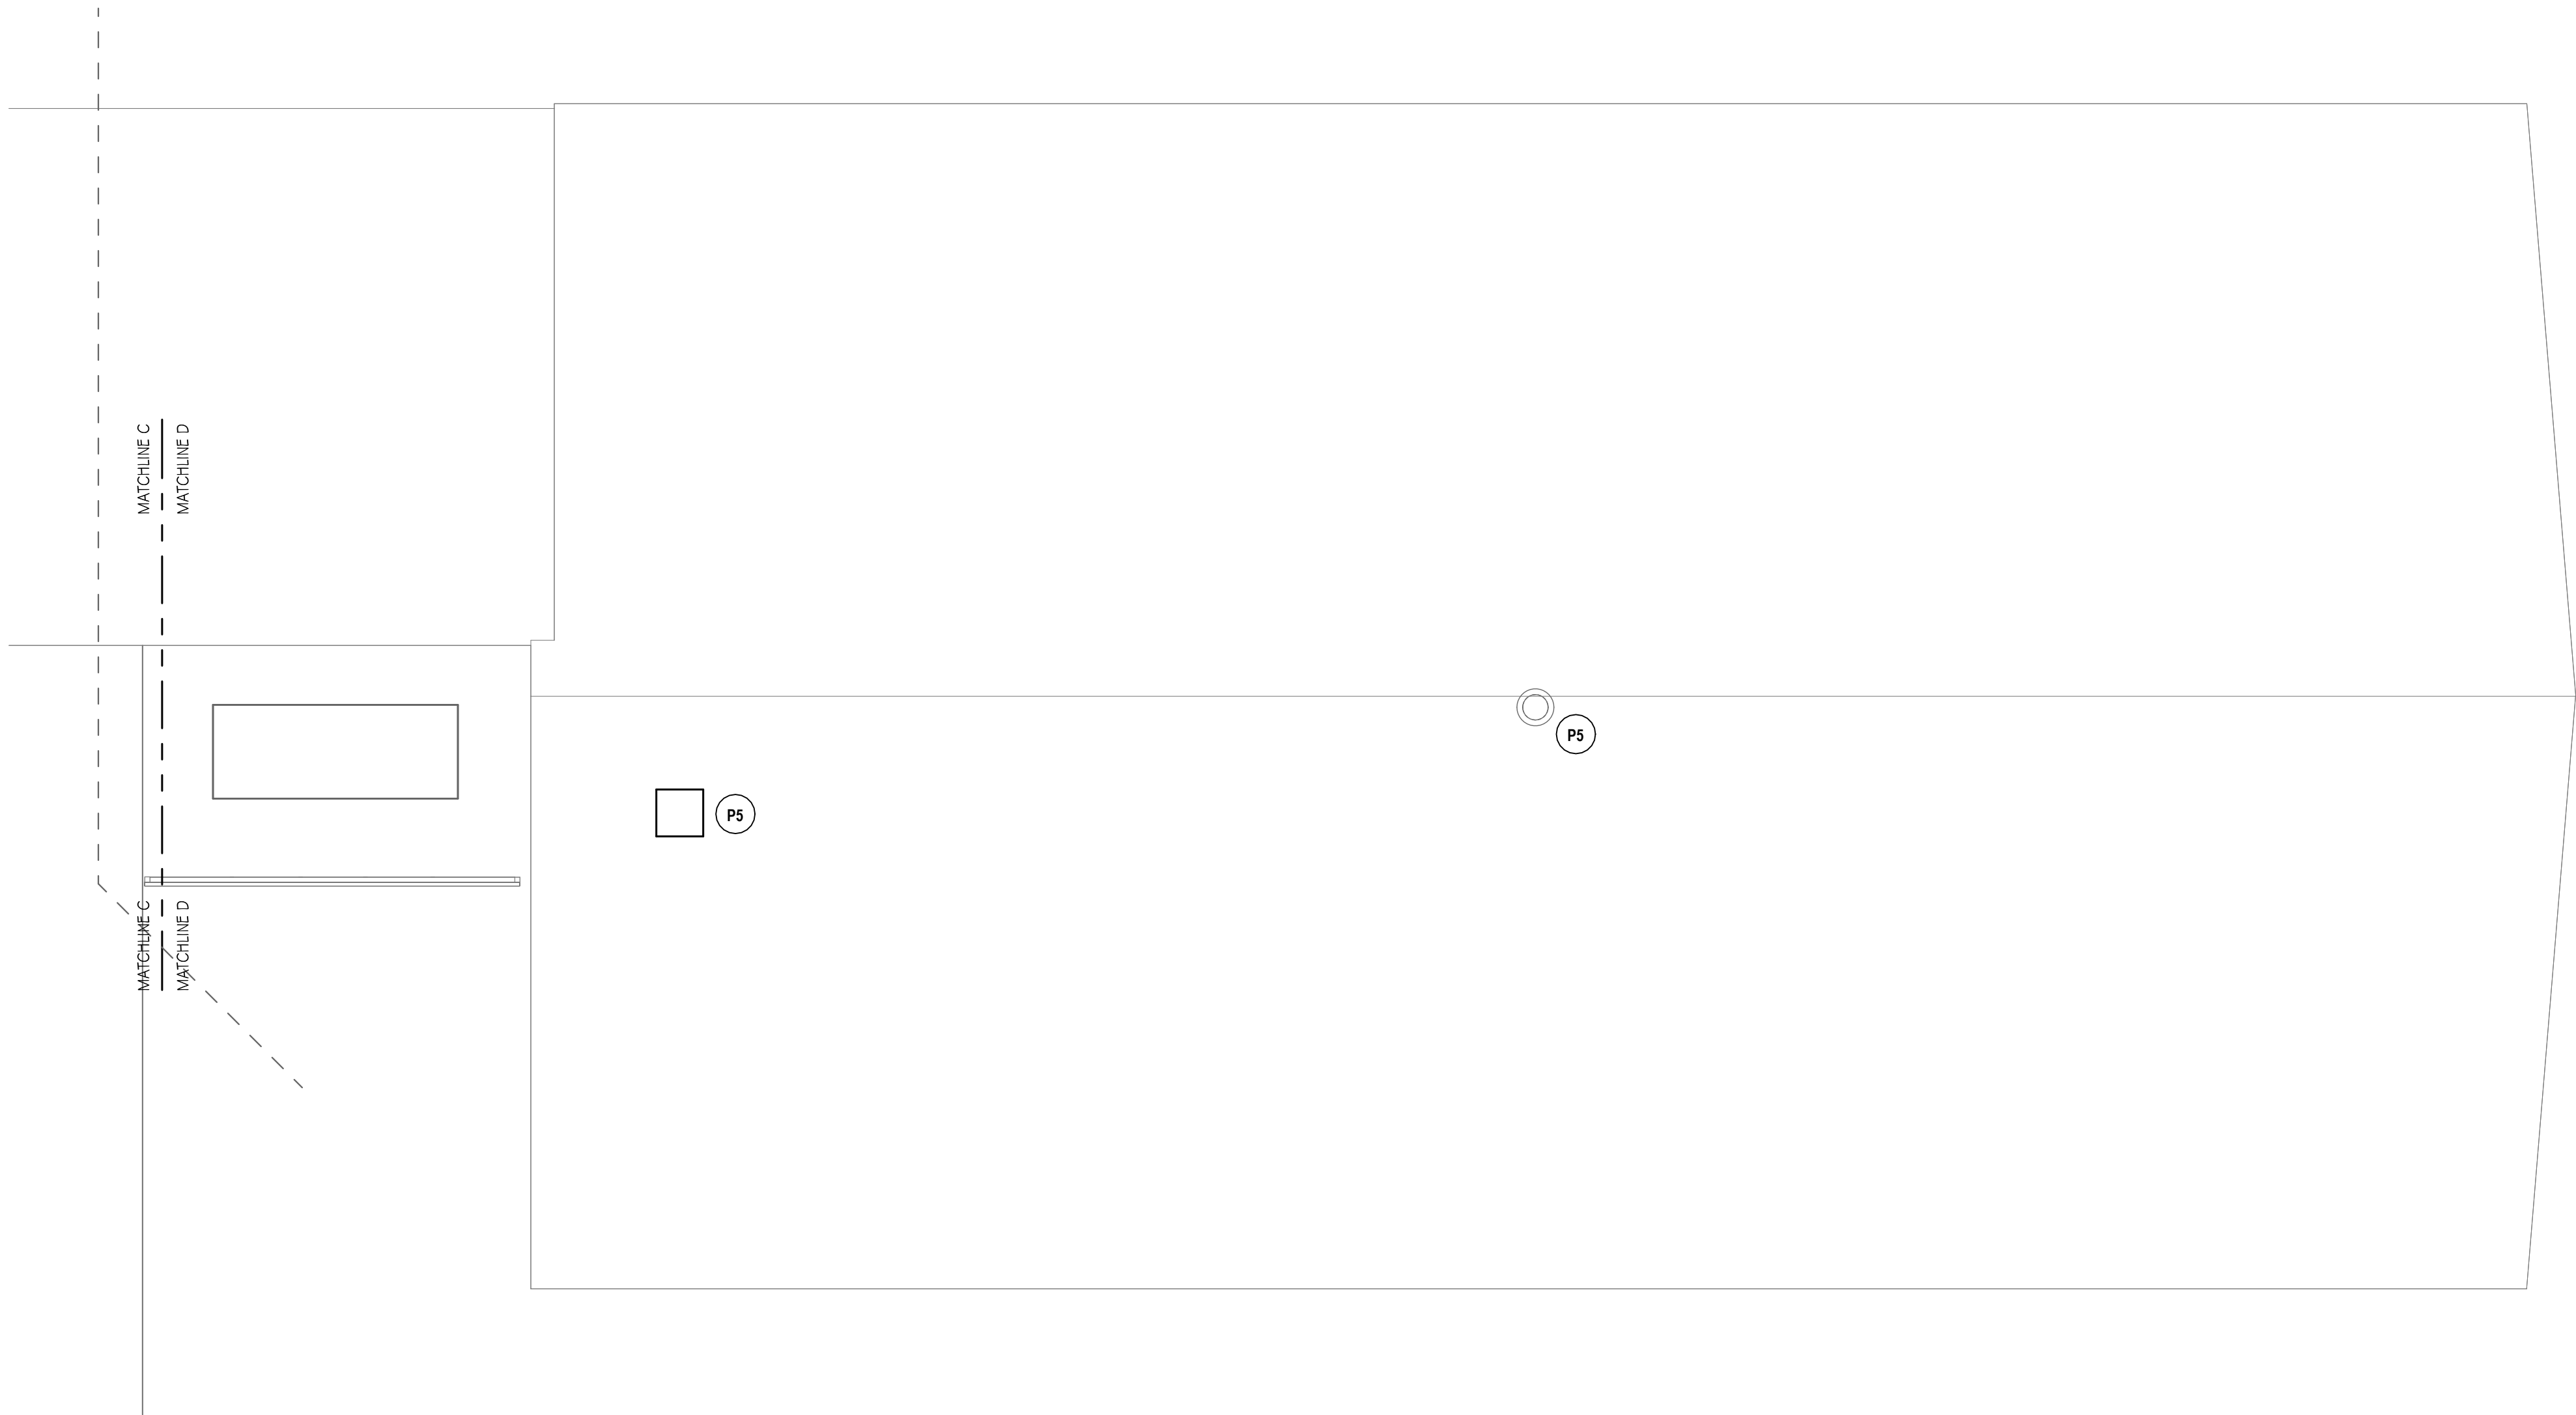

GENERAL NOTES - ELECTRICAL

REFER TO SHEET EV-E0.1

CONSTRUCTION NOTES - POWER

- P1 NEW ATS TO BE LOCATED AFTER MAIN SERVICE DISCONNECT. REFER TO ONE LINE DIAGRAM.
P2 FINAL LOCATION ON KITCHEN SERIES DRAWINGS. REFER TO FINAL LOCATION ON KITCHEN SERIES DRAWINGS.
P3 PROVIDE NEW 30A / 2P BREAKER IN PANEL KP2, NEW OUTLET TO BE 30A / 1PH. REFER TO FINAL LOCATION ON KITCHEN SERIES DRAWINGS. CIRCUIT WITH 2#10, 1#10G, 3/4"C.
P4 HARDWIRE SINK FROM 120V CIRCUIT SERVING T.R.
P5 DISCONNECT/RECONNECT EXISTING CIRCUITRY TO MECHANICAL UNITS TO ACCOMODATE ROOF WORK.
P6 PROVIDE POWER TO MECHANICAL EQUIPMENT. REFER TO EV-E5.1.

SEE NUMBERS EV-01-00-001-0-000-007, AD-01-00-001-1-001-013

ROOF POWER PLAN - AREA D

2025 ERWIN VALLEY ELEM & ADMIN BUILDING ALTERATIONS
CORNING-PAINTED POST AREA SCHOOL DISTRICT

16 BEARTOWN ROAD, PAINTED POST NY 14870

EV-E1.4

PROJECT NO: 2649-160

HUNT ENGINEERS | ARCHITECTS | SURVEYORS

HORSEHEADS, NY 807-265-1000 ROQUESTER, NY 565-537-7549 TONAWANDA, PA 570-265-4666
BINGHAMTON, NY 807-798-8881 ALBANY, NY 807-798-2801
WWW.HUNTEAS.COM

NY CERTIFICATE NO. 001620 PA CERTIFICATE NO. TSC220313464-1

DATE: 1 10/12/2026
DESCRIPTION OF REVISION:
ISSUED FOR BID

PHASE: CP

DATE: 03/17/2026
CHECKED BY: GJB
DRAWN BY: TAWO

IT IS A VIOLATION OF THE LAW FOR ANY PERSON TO MAKE UNAUTHORIZED ALTERATIONS OR ADDITIONS TO PLANS
DRAWN BY LICENSED ARCHITECTS OR ENGINEERS


03/17/2026

GENERAL NOTES - ELECTRICAL


REFER TO SHEET EV-E0.1

CONSTRUCTION NOTES - LIGHTING & FA

- L1 RE-USE EXISTING LIGHTS AND SWITCHING IN THIS SPACE. RECONNECT TO EXISTING HOMERUN CIRCUITRY.
L2 RE-USE EXISTING SWITCHING IN THIS SPACE. RECONNECT TO EXISTING HOMERUN CIRCUITRY.

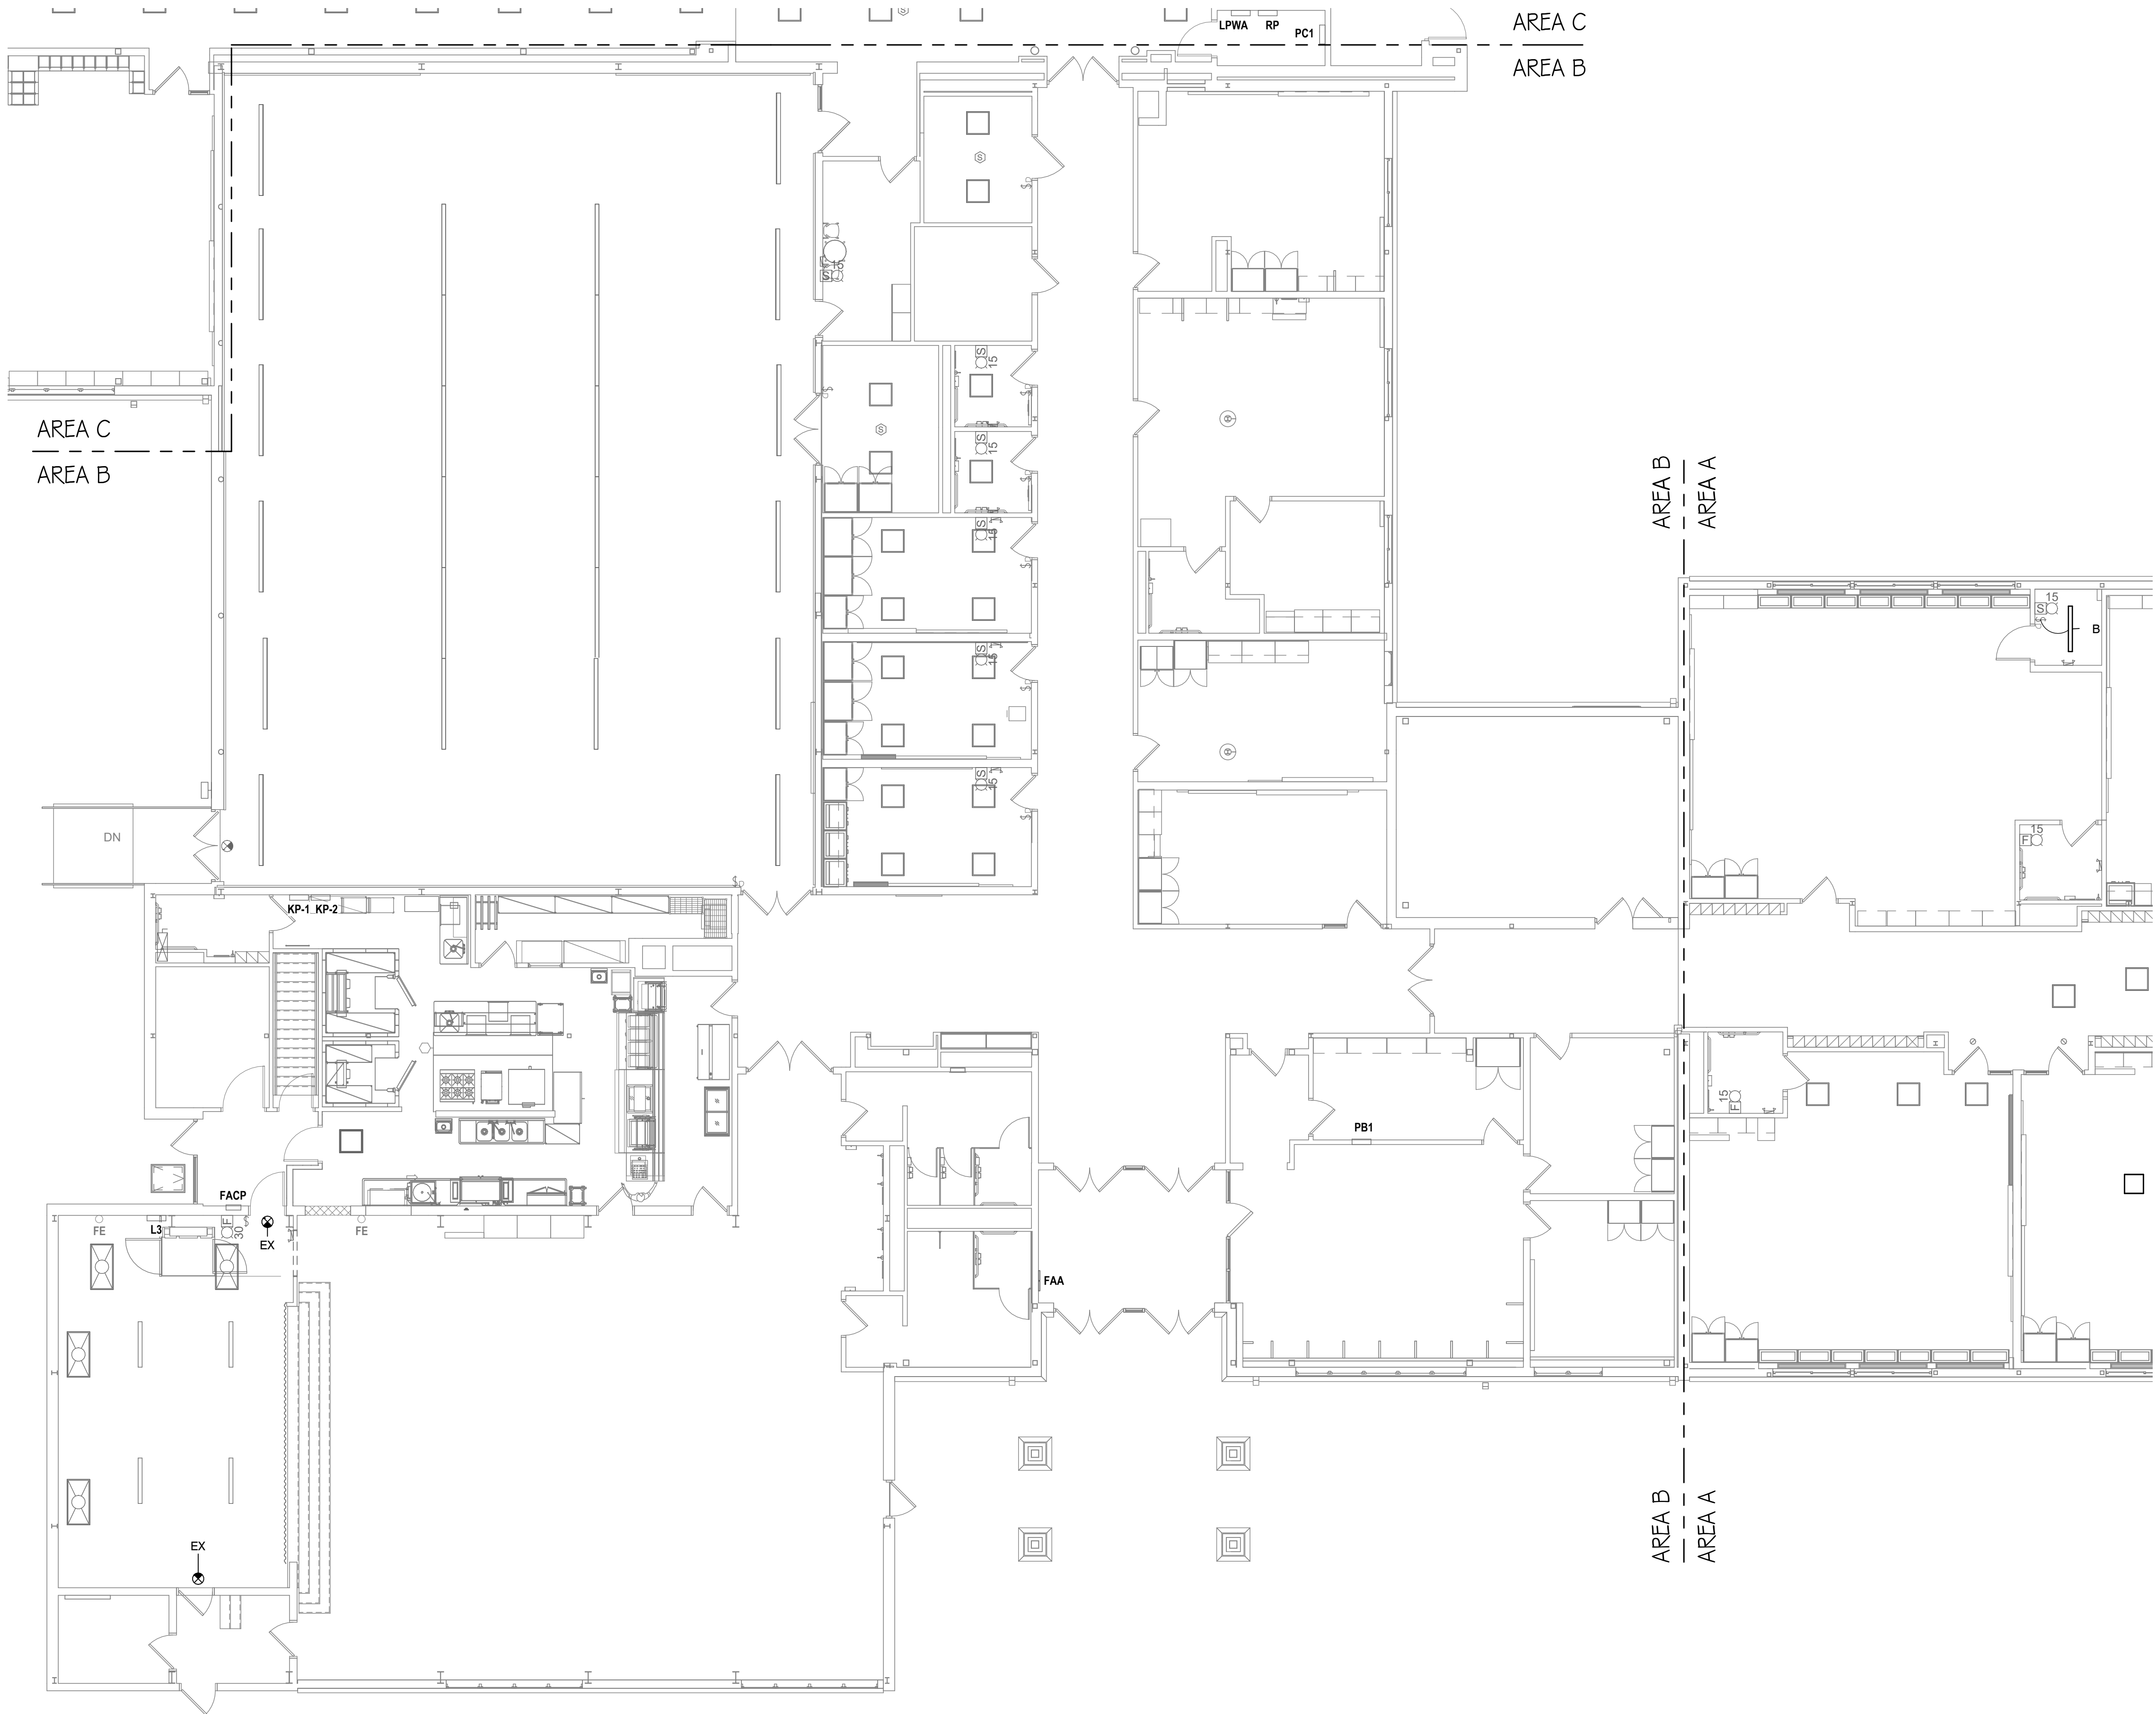

1 FIRST FLOOR LIGHTING & FA PLAN - AREA B
1/8" = 1'-0"

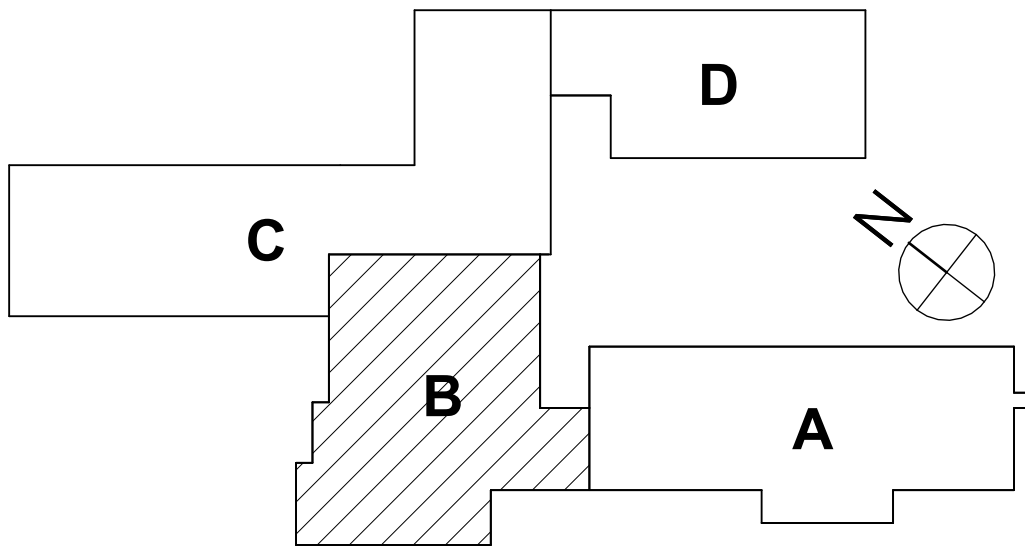

SEE NUMBERS EV-01-00-01-000-007, AD-01-00-01-001-013

FIRST FLOOR LIGHTING & FA PLAN - AREA B

2025 ERWIN VALLEY ELEM & ADMIN BUILDING ALTERATIONS
CORNING-PAINTED POST AREA SCHOOL DISTRICT

16 BEARTOWN ROAD, PAINTED POST, NY 14870

EV-E2.1

PROJECT NO: 2649-160

HUNT ENGINEERS | ARCHITECTS | SURVEYORS
HORSEHEADS, NY 607-253-1000 ROCHESTER, NY 585-537-7549 TOWNAND, PA 570-265-4666
BINGHAMTON, NY 607-798-8881 ALBANY, NY 607-798-8881
WWW.HUNTEAS.COM
NY CERTIFICATE NO. 001620 PA CERTIFICATE NO. TSC220313/464-1

DATE: 1 10/12/2026

DESCRIPTION OF REVISION:
ISSUED FOR BID
IT IS A VIOLATION OF THE LAW FOR ANY PERSON TO MAKE UNAUTHORIZED ALTERATIONS OR ADDITIONS TO PLANS
DRAWN BY: TAWO
CHECKED BY: GJB
DATE: 03/17/2026
PHASE: CD
COPYRIGHT 2026

REFER TO SHEET EV-E0.1

L1 RE-USE EXISTING LIGHTS AND SWITCHING IN THIS SPACE. RECONNECT TO EXISTING HOMERUN CIRCUITRY.
L2 RE-USE EXISTING SWITCHING IN THIS SPACE. RECONNECT TO EXISTING HOMERUN CIRCUITRY.


#	DATE: 1/10/2008	DESCRIPTION OF REVISION: ISSUED FOR BID	DRAWN BY:	TAWC	Copyright: 2008
			CHECKED BY:	GJB	
			DATE:	03/17/2006	
			PHASE:	CD	
			IT IS A VIOLATION OF THE LAW FOR ANY PERSON TO MAKE UNAUTHORIZED ALTERATIONS OR ADDITIONS TO PLANS BEARING A LICENSED ENGINEER, ARCHITECT'S OR SURVEYOR'S SEAL.		

HUNT ENGINEERS | ARCHITECTS | SURVEYORS
HORSEHEADS, NY 607-369-0001 ROCHESTER, NY 585-237-7940 TOWANDIA, PA 256-255-4686
BINGHAMTON, NY 607-738-8381 ALBANY, NY 518-791-9301
WWW.HUNTEAS.COM
NY CERTIFICATE NO. 030225 PACE CERTIFICATE NO. TSC220313464-1


FIRST FLOOR LIGHTING & FA PLAN - AREA D
2025 ERWIN VALLEY ELEM & ADMIN BUILDING ALTERATIONS
CORNING-PAINTED POST AREA SCHOOL DISTRICT
16 BEARTOWN ROAD, PAINTED POST, NY 14870

EV-E2.2


PROJECT NO: 2649-160

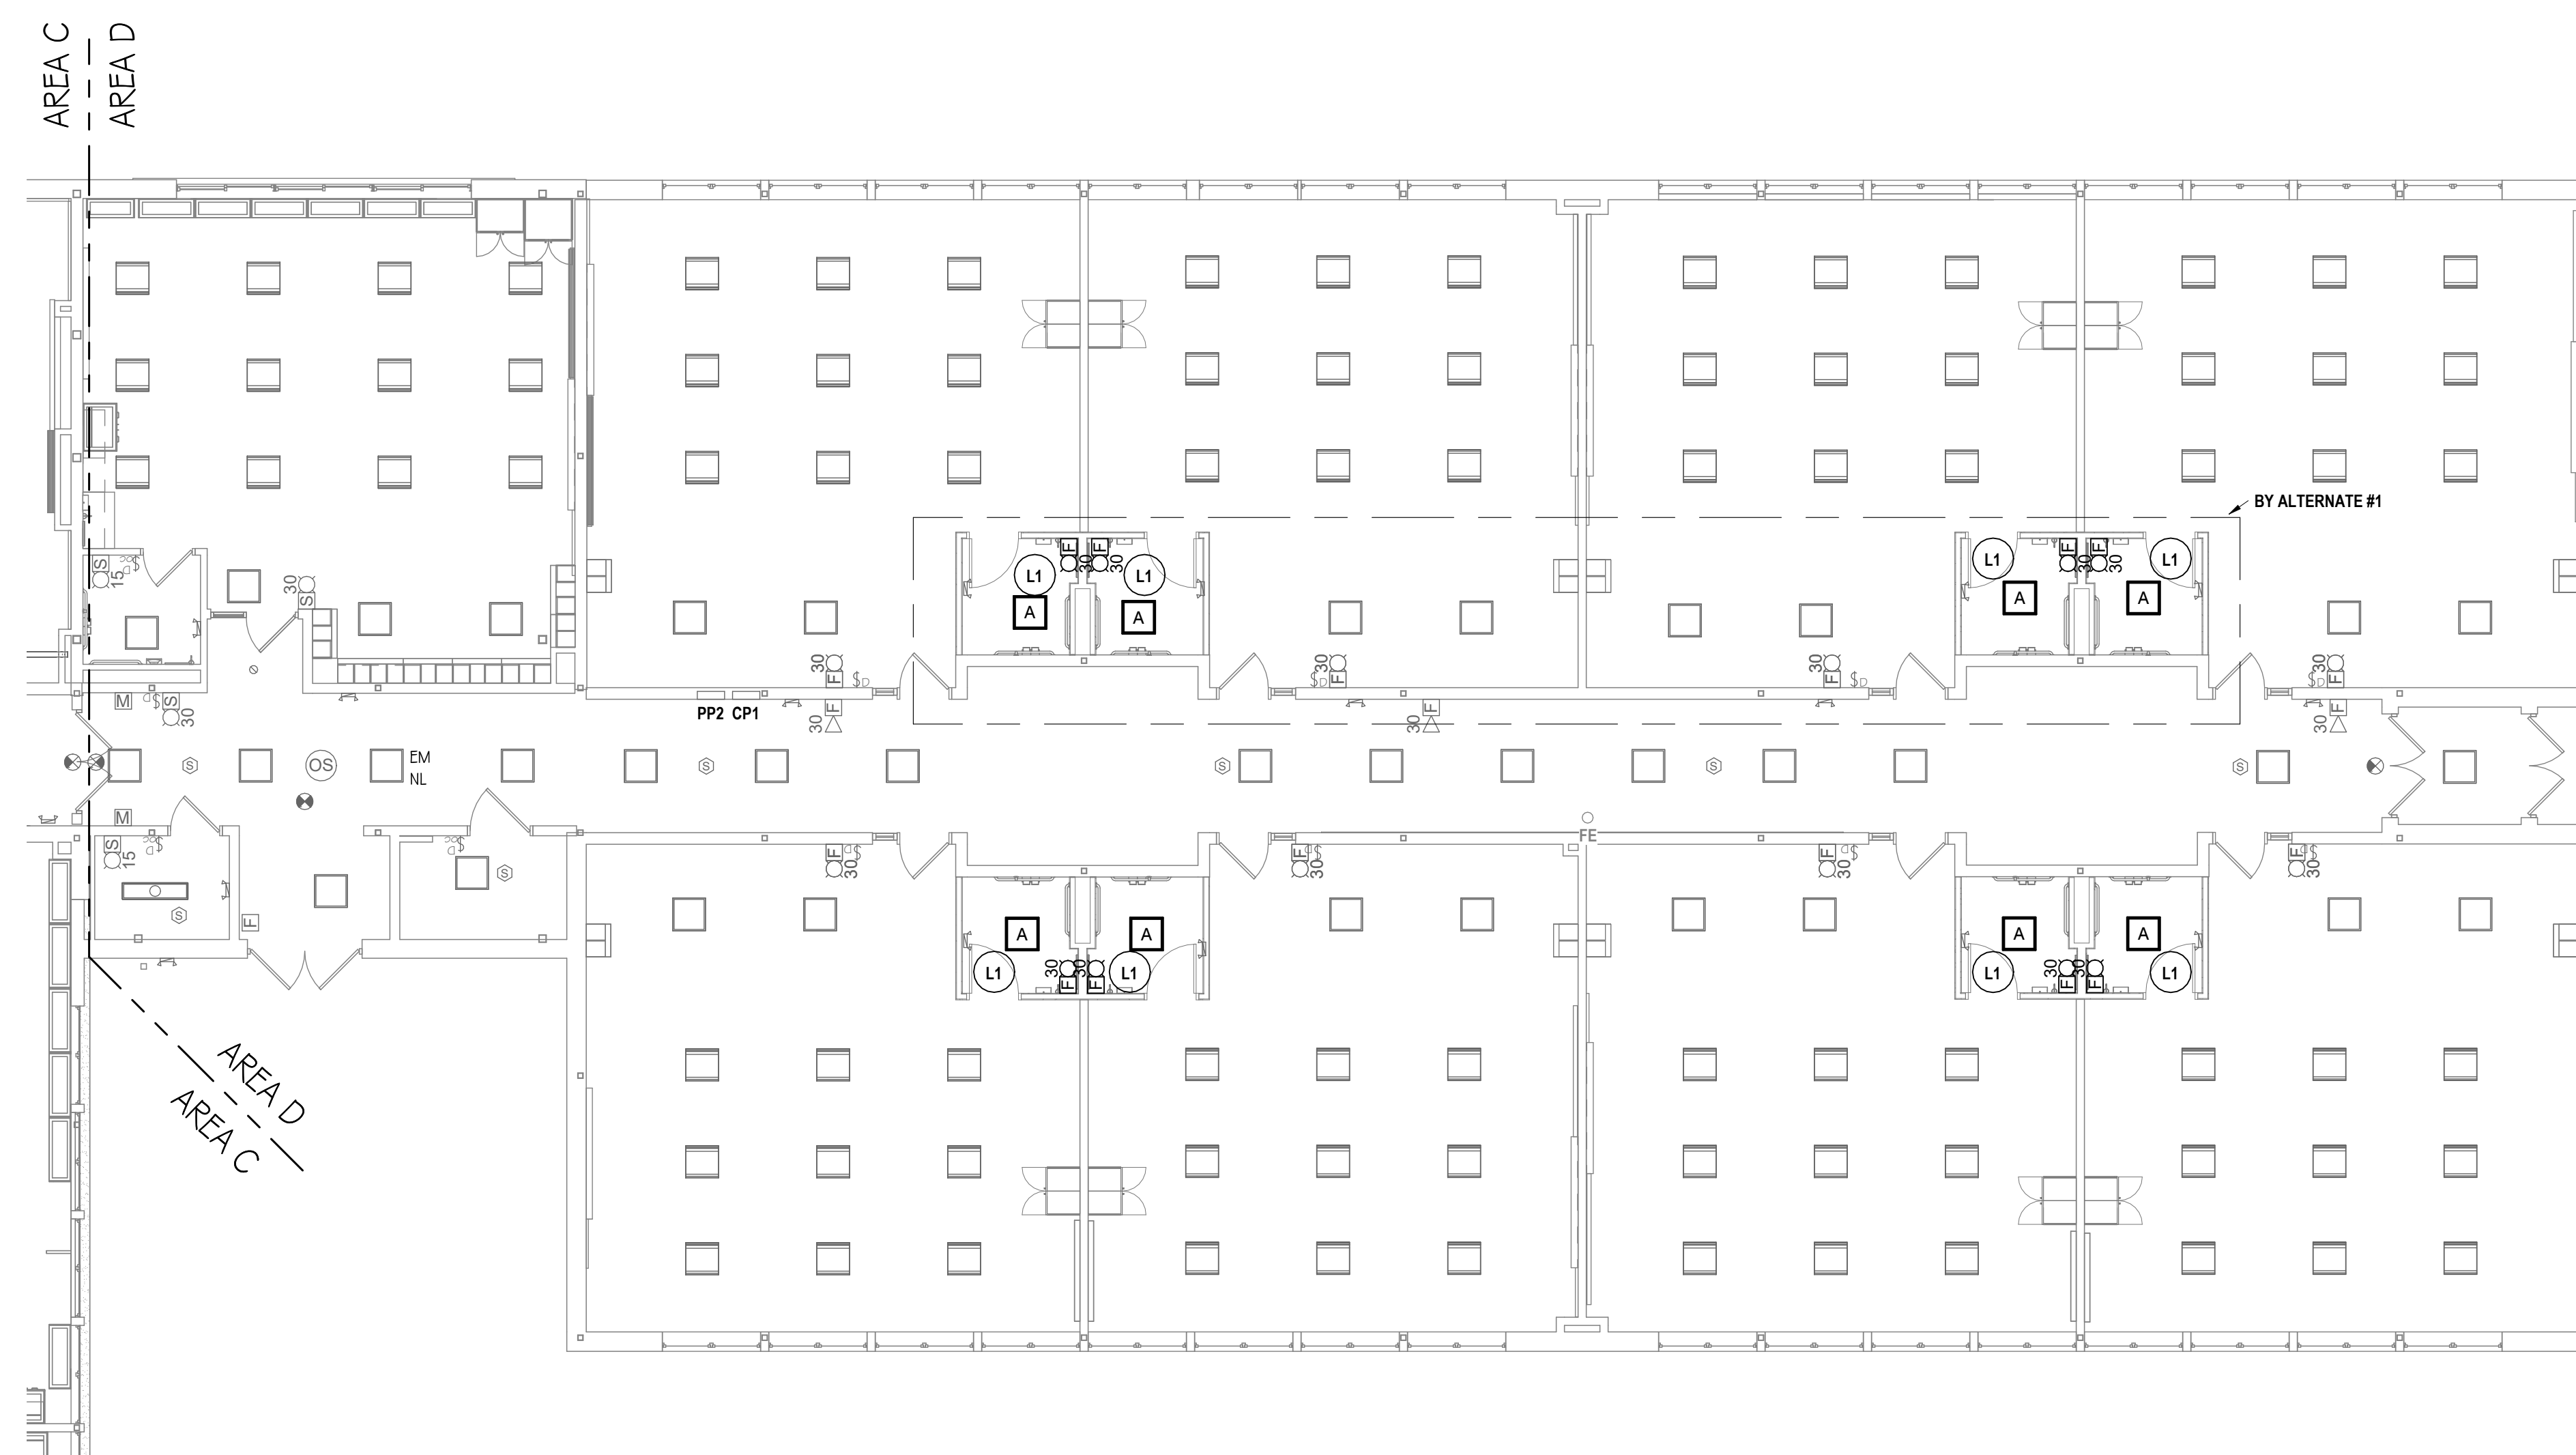


1 FIRST FLOOR LIGHTING & FA PLAN - AREA D
1/8" = 1'-0"

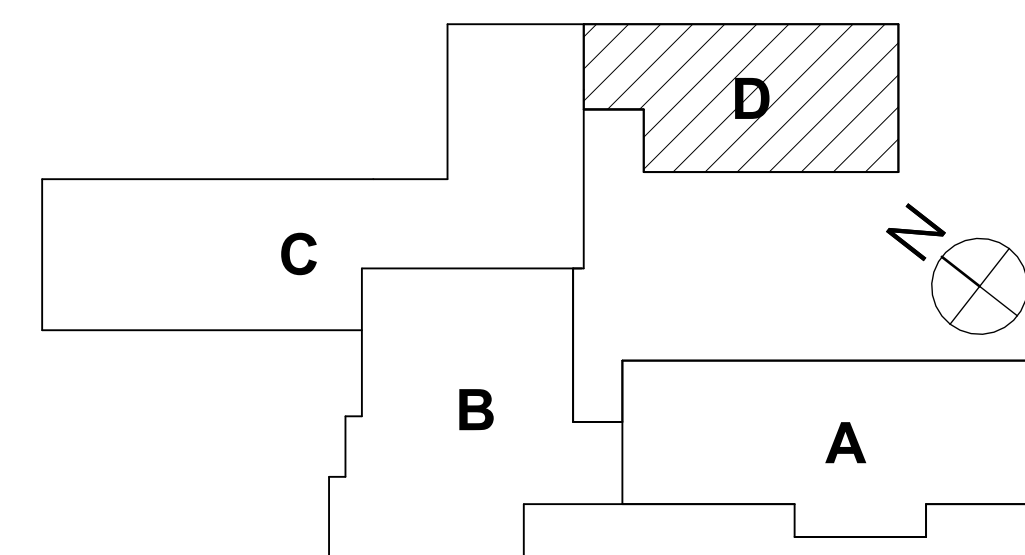

SED NUMBERS EV: 57-10-00-01-0-009-027, AD: 57-10-00-01-1-001-013

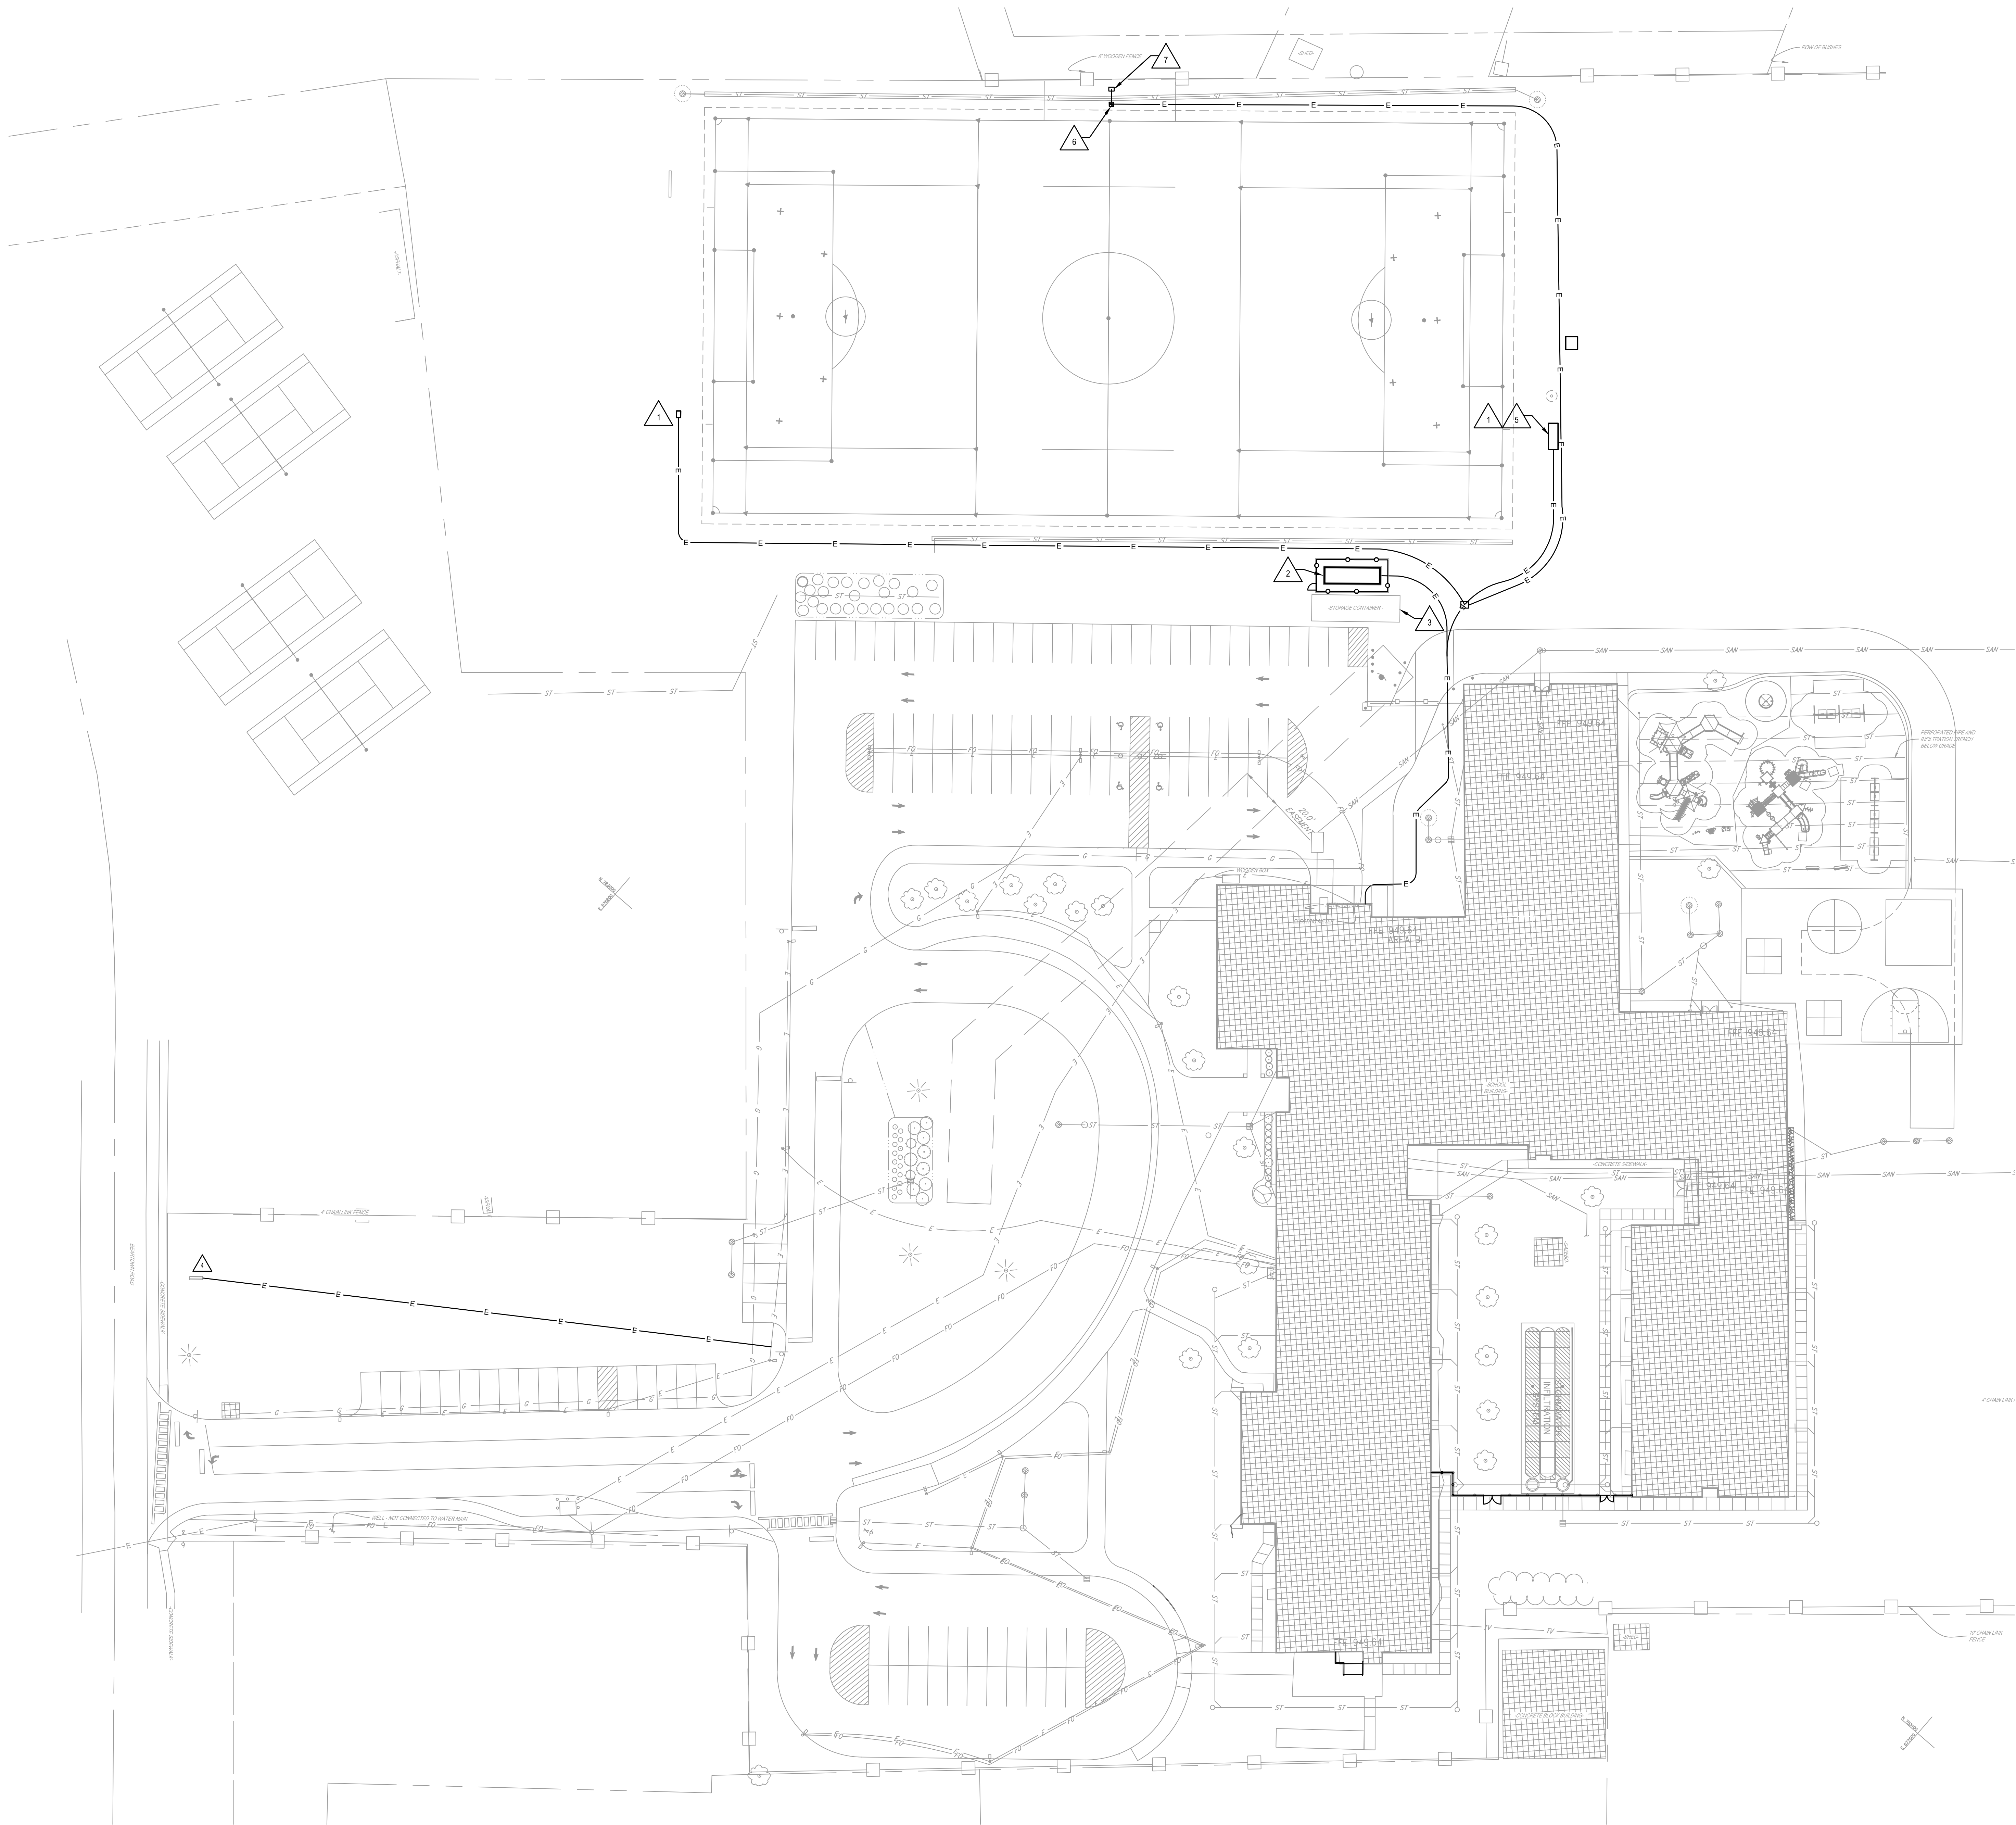

1 SITE ELECTRICAL UTILITY PLAN
SCALE: 1" = 30'

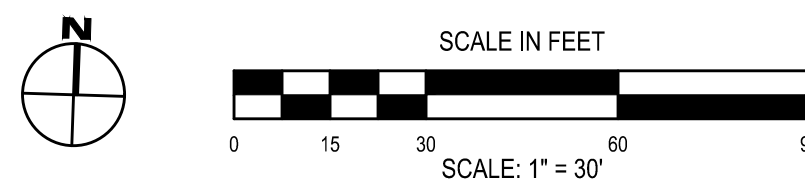


GENERAL NOTES - ELECTRICAL:

REFER TO DWG. EV-E0.1

8 SITE ELECTRICAL NOTES:

1. PROVIDE NEW CIRCUIT FROM KP2 TO SHOT CLOCK. CIRCUIT WITH 2#10, 1#10G, 1" C. PROVIDE 20A/1P NEMA 3R RATED DISCONNECT SWITCH. COORDINATE FINAL CONNECTION REQUIREMENTS WITH MANUFACTURER.
2. PROVIDE NEW GENERATOR PER SPECIFICATIONS. GENERATOR FEEDS TO BE PER E.S. 1. COORDINATE ALL PENETRATIONS THROUGH PAD WITH OTHER TRADES.
3. PROVIDE NEW CIRCUIT FROM KP2 FROM EXISTING 20A 1P BREAKER TO BUILDING. CIRCUIT WITH 2#10, 1#10G, 1" C. EXISTING FEEDERS AND CONDUIT TO BE ABANDONED. RE-CIRCUIT EXISTING RECEPTACLE, SWITCH, AND LIGHTING ONTO NEW CIRCUIT.
4. EXISTING OUTDOOR SIGN IS BEING REPLACED. SECURE EXISTING CIRCUITRY FOR REUSE. AFTER NEW SIGN IS INSTALLED PROVIDE NEW DISCONNECT AND NEW GROUNDING ROD AND GROUND NEW PLATFORM. EXTEND AND ATTACH NEW CIRCUITRY TO NEW SIGNAGE.
5. PROVIDE NEW CIRCUIT FROM KP2 TO EXTERIOR SCOREBOARD. CIRCUIT WITH 2#10, 1#10G, 1" C. PROVIDE 20A/1P NEMA 3R RATED DISCONNECT SWITCH. COORDINATE FINAL CONNECTION REQUIREMENTS WITH MANUFACTURER.
6. PROVIDE OPEN-BOTTOM PULLBOX IN THIS LOCATION. BASIS OF DESIGN QUAZITE 12" L X 12" W. DEPTH SHALL BE BELOW FROST LAYER.
7. PROVIDE POWER PEDESTAL WITH (2) GFCI DUPLEX RECEPTACLES IN THIS LOCATION. CIRCUIT FROM KP-2 USING (2)-4, (1)-4G, IN 1-1/2" C. REFER TO DETAIL 2/E4.1.

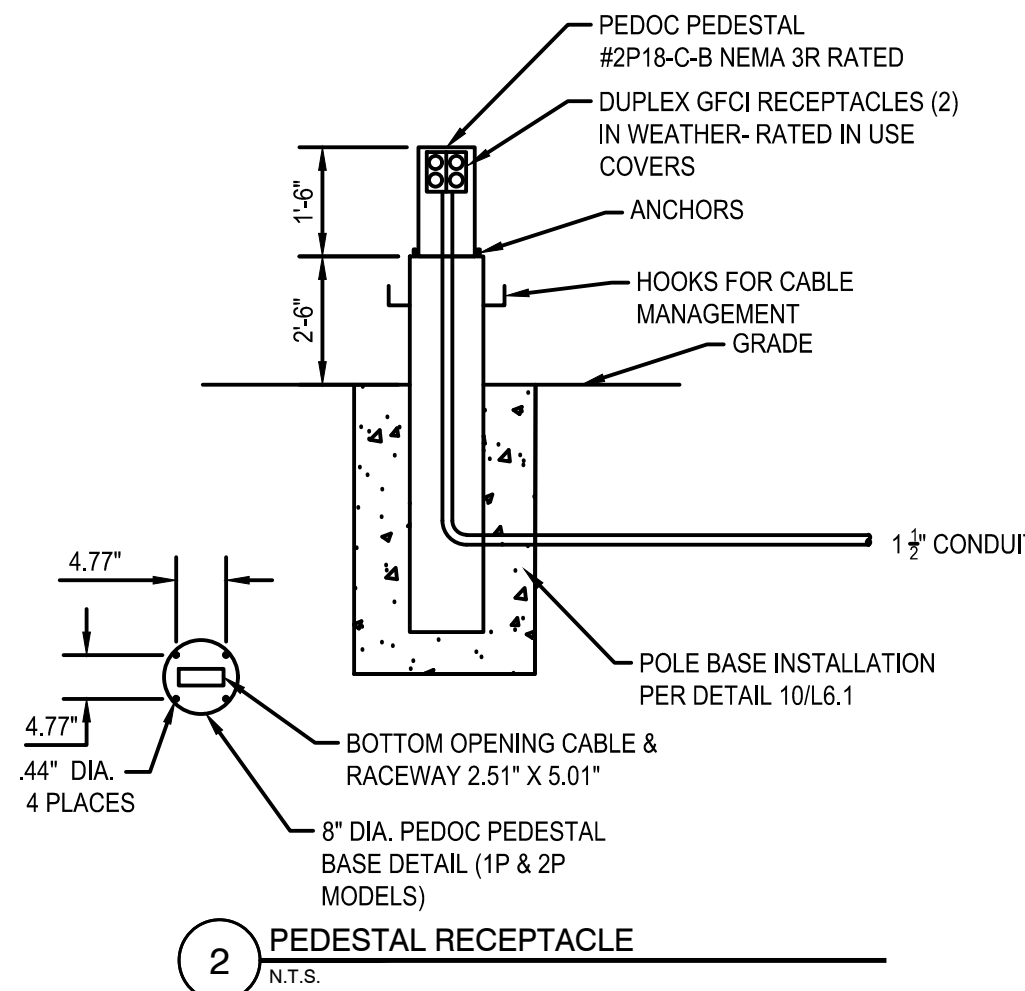

DRAWN BY: TAWC
CHECKED BY: GJB
DATE: 03/17/2020
PHASE: CD

DESCRIPTION OF REVISION:
ISSUED FOR BID

DATE: 10/12/2020
REVISION: 1

IT IS A VIOLATION OF THE LAW FOR ANY PERSON TO MAKE UNAUTHORIZED ALTERATIONS OR ADDITIONS TO PLANS
OR CONTRACT DOCUMENTS WITHOUT THE WRITTEN CONSENT OF THE DESIGN PROFESSIONAL.

PROJECT NO: 2649-160

HUNT
ENGINEERS | ARCHITECTS | SURVEYORS
HORSEHEADS, NY 607-389-1000 • ROCHESTER, NY 585-327-7949 • TOWANDA, PA 570-285-4888
BINGHAMTON, NY 607-798-5081 • ALBANY, NY 607-798-8081
WWW.HUNTEAS.COM
NY CERTIFICATE NO. 016220 PA CERTIFICATE NO. TS2220313164-1

SITE ELECTRICAL UTILITY PLAN
2025 ERWIN VALLEY ELEM & ADMIN BUILDING ALTERATIONS
CORNING-PAINTED POST AREA SCHOOL DISTRICT
16 BEARTOWN ROAD, PAINTED POST, NY 14870

EV-E4.1
PROJECT NO: 2649-160

DATE: 1 10/12/2026

DESCRIPTION OF REVISION:
ISSUED FOR BID

IT IS A VIOLATION OF THE LAW FOR ANY PERSON TO MAKE UNAUTHORIZED ALTERATIONS TO PLANS
DRAWN BY A LICENSED ENGINEER, ARCHITECT, OR SURVEYOR'S SEAL.


DRAWN BY: TAWO
CHECKED BY: GJB
DATE: 03/17/2026
PHASE: CP

Copyright 2026

LIGHT FIXTURE SCHEDULE											
TYPE	DESCRIPTION	SIZE	MOUNTING	VOLTAGE	LUMENS	LED COLOR TEMP	LOAD EA (WATTS)	MANUFACTURER/CATALOG NO.	FINISH	REMARKS	NOTES
A	RECESSED VOLUMETRIC TROFFER	2x2	RECESSED	UNIV.	-	-	-	EXISTING	WHITE	-	-
B	PENDANT LINEAR	1x4	PENDANT	UNIV.	3952	4000	21	PRUDENTIAL # BOLT-PRO-LED4-MO-5-SAL-TMW-UNV-CA48-X3-DM01.	WHITE	-	1,2
C	EXT. SURFACE MOUNT FLOOD	1'X1'	SURFACE/YOKE	UNIV.	4100	3000	38	GARDCO #DSL7-RSP-16L-700-WW-G2-UNV-BK-PCB	BLACK	PROVIDE INTEGRAL PHOTOBUTTON CONTROL.	1

LIGHT FIXTURE SCHEDULE NOTES:

- LIGHT FIXTURE SHALL BE DESIGN LIGHTS CONSORTIUM QUALIFIED.
- FIXTURE SHALL HAVE 0-10V DIMMING CAPABILITY AND BE CONTROLLED BY A COMPATIBLE 0-10V DIMMING SWITCH.

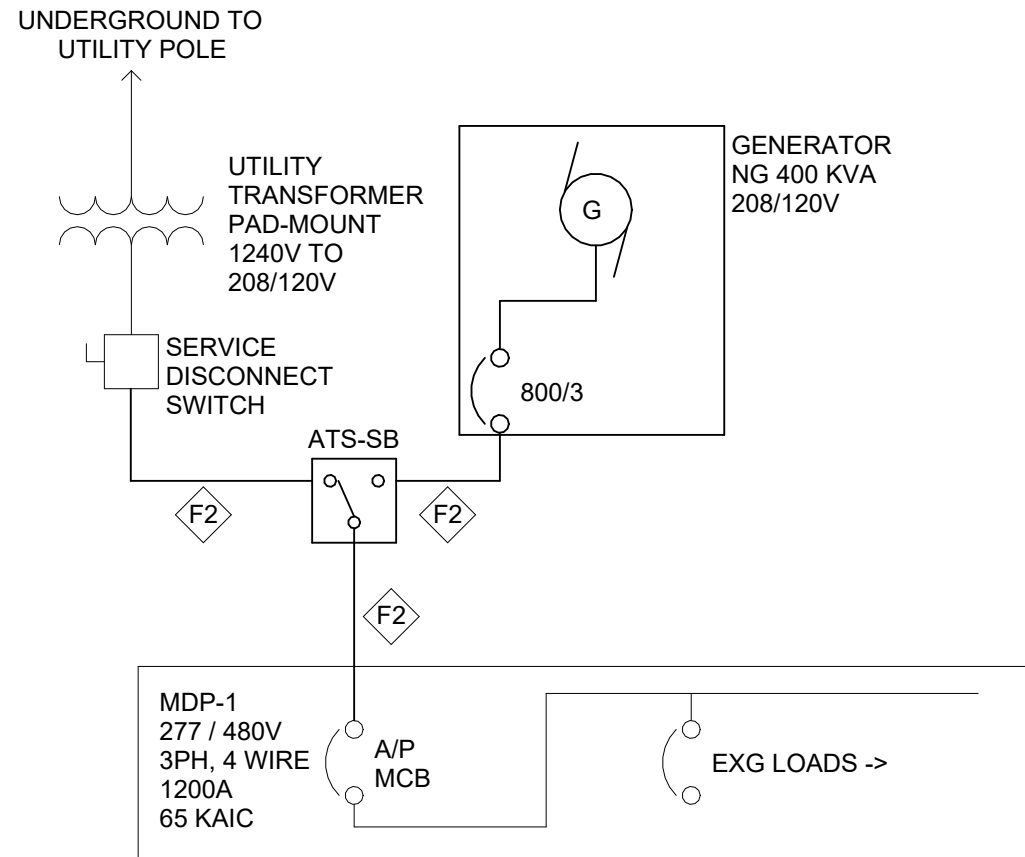

FEEDER SCHEDULE		
NAME	DESCRIPTION	MAX. AMPERAGE ASSUMES NO VOLTAGE DROP
F1	(4-SETS) 4- #600, 4°C.	1600 *
F2	(3-SETS) 4- #600, 4°C.	1200 *
F3	(2-SETS) 4- #600, 1-#3G, 3 1/2°C.	800
F4	(2-SETS) 4-#350, 1-#4G, 3°C	600
F5	4- #600, 4°C.	400
F6	4-#4/0, 1-#4G, 2 1/2°C	225
F7	4-#3/0, 1-#6G, 2 1/2°C	200
F8	4-#2/0, 1-#6G, 2°C	175
F9	4-#1/0, 1-#8G, 2°C	150
F10	4-#1/0, 1-#8G, 2°C	125
F11	4-#1, 1-#8G, 1 1/2°C	100
F12	4-#4, 1-#10G, 1 1/4°C	60
* SERVICE ENTRANCE FEEDER WITH NO GROUND. REFER TO GROUND GRID DETAIL.		


MECHANICAL EQUIPMENT CONNECTION AND CONTROL SCHEDULE

EQUIPMENT						SUPPLY			CONTROL DEVICES MOUNTED IN ROOMS AS SCHEDULED AND AS SHOWN ON PLANS (AU = AT UNIT)																		
IDENTIFICATION / TAG	DESCRIPTION	LOCATION (ROOM #)	HORSEPOWER / KILOWATTS / FLA / MCA	PHASE	VOLTAGE	PANEL OR CONTROL CENTER	CIRCUIT BREAKER	WIRE SIZE	REFERENCE NOTES	DISCONNECT SWITCH (FURNISHED & INSTALLED BY E.C.)	DISCONNECT SWITCH (FURNISHED BY H.C. & INSTALLED BY E.C.)	PREWIRED FACTORY MOUNTED DISCONNECT SWITCH (FURNISHED BY H.C. & INSTALLED BY E.C.)	MANUAL MOTOR STARTER (FURNISHED & INSTALLED BY E.C.)	MAGNETIC STARTER (FURNISHED & INSTALLED BY E.C.)	COMBINATION STARTER (FURNISHED & INSTALLED BY E.C.)	VARIABLE SPEED DRIVE (FURNISHED & INSTALLED BY E.C.)	VFD PACKAGE (FURNISHED & INSTALLED BY H.C. CONNECTED BY E.C.)	VFD WITH CHOKE (FURNISHED BY H.C. & INSTALLED BY E.C.)	PACKAGED CONTROL UNIT	SINGLE POINT CONNECTION	FAN SHUTDOWN UPON FACP ACTIVATION (X>1000CFM)	DUCT SMOKE DETECTOR IN RETURN DUCT (X>2000CFM)	BOILER SHUTDOWN SAFETY SWITCH	LINE VOLTAGE THERMOSTAT (FURNISHED BY H.C. & INSTALLED BY E.C.)	FACTORY MOUNTED STARTER & DISCONNECT (BY MFR.)	CONNECT AQUASTAT	PROVIDE 20AMP, 120V GFCI RECEPTACLE IN WEATHERPROOF ENCLOSURE AT UNIT.
FCU-1	FAN COIL UNIT	KITCHEN	1MCA	1	120	KP1	20/1	(2)-#12 , (1)-#12 G IN 3/4"	-			X															
FCU-2	FAN COIL UNIT	KITCHEN	1MCA	1	120	KP1	20/1	(2)-#12 , (1)-#12 G IN 3/4"	-			X															
EF-1	EXHAUST FAN	KILN 201B	1/6HP	1	120	PB1	20/1	(2)-#12 , (1)-#12 G IN 3/4"	-			X															

NOTE: ALL DEVICES / EQUIPMENT / HARDWARE SHALL BE SUITABLE FOR USE IN THE ENVIRONMENT INDICATED, SEE SPECIFICATIONS FOR FARTHER INFORMATION.

MECHANICAL EQUIPMENT CONNECTION AND CONTROL SCHEDULE REFERENCE NOTES:

A	ALL CABLING INSTALLATION AND TERMINATION TO ADHERE TO CURRENT NEC CODES AND RELATED ANSI/TIA/EIA STANDARDS.
B	INSTALLATION OF CABLING, ANY DAMAGE TO ANY FUNCTIONING CABLING SYSTEM IS THE RESPONSIBILITY OF, AND WILL BE REPAIRED BY THE CONTRACTOR.
C	WHEN INSTALLING CABLING FOR CEILING MOUNTED DEVICES, ADJUST LOCATION TO AVOID OTHER CEILING MOUNTED DEVICES SUCH AS LIGHTS, ETC.
D	DATA CABLE SHALL BE PLENUM RATED PER SPECIFICATIONS.
E	OWNER TO APPROVE FINAL LOCATION AND VIEW OF ALL CAMERAS.
F	ALL ELECTRONIC AND NETWORKING SERVICES NEED TO BE COORDINATED WITH OWNER PRIOR TO REMOVAL AND DISCONNECTION.
G	ALL CEILING MOUNTED DEVICES TO BE SUPPORTED BY STRUCTURE ABOVE. DO NOT USE CEILING GRID AS SOLE SUPPORT MECHANISM.
H	PROTECT WORK EQUIPMENT DURING INSTALLATION OF OTHER TRADES' WORK IN DISTRIBUTION FRAME ROOMS.

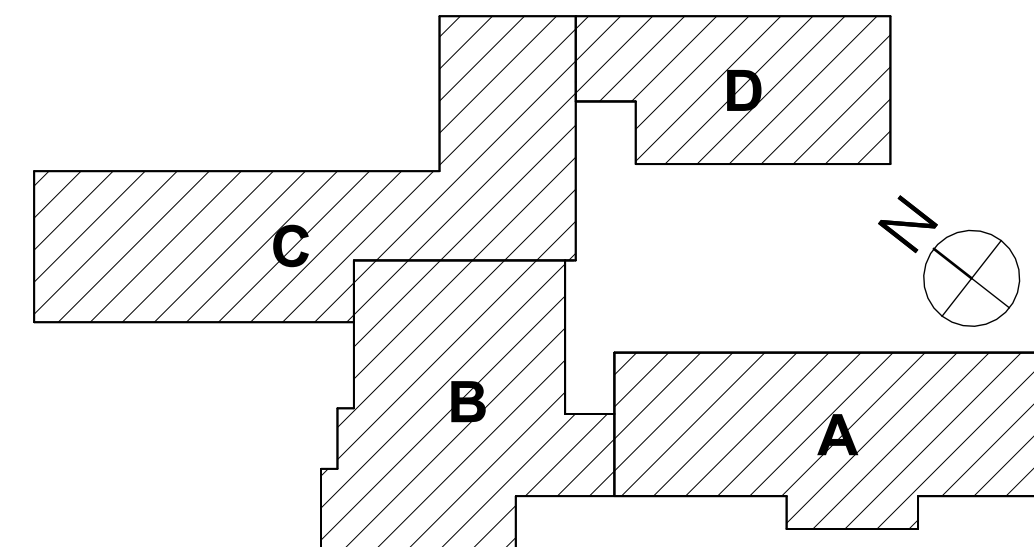

HUNT ENGINEERS | ARCHITECTS | SURVEYORS
HORSEHEADS, NY 607-358-1000 ROCHESTER, NY 585-327-7949 TOWNANDA, PA 570-265-4888
BINGHAMTON, NY 607-733-8888 ALBANY, NY 518-486-8888
WWW.HUNTEAS.COM 607-789-0981
NY CERTIFICATE NO. 0018920 PA CERTIFICATE NO. TSC2203131684-1

FIRST FLOOR TECHNOLOGY DEMO KEYPLAN

EV-T0.1

PROJECT NO: 2649-160

A ALLS CABLE INSTALLATION AND TERMINATION TO ADHERE TO CURRENT NEC CODES AND RELATED ANS/CABLESHA STANDARDS.

B CURRENT INSTALLATION OF CABLEING, ANY DAMAGE TO ANY FUNCTIONING CABLEING SYSTEM IS THE RESPONSIBILITY OF, AND WILL BE REPAIRED BY THE CONTRACTOR.

C WHEN INSTALLING CABLEING FOR CEILING MOUNTED DEVICES, ADJUST LOCATION TO AVOID OTHER CEILING MOUNTED DEVICES SUCH AS LIGHTS, ETC.

D ALL DATA CABLEING SHALL BE PLENUM RATED PER SPECIFICATIONS.

E OWNER TO APPROVE FINAL LOCATION AND VIEW OF ALL CAMERAS.

F ALL ELECTRONIC AND NETWORKING SERVICES NEED TO BE COORDINATED WITH OWNER PRIOR TO REMOVAL AND DISCONNECT.

G ALL CEILING MOUNTED DEVICES TO BE SUPPORTED BY STRUCTURE ABOVE. DO NOT USE CEILING GRID AS SOLE SUPPORT MECHANISM.

H PROVIDE PROTECTIVE EQUIPMENT DURING INSTALLATION OF OTHER TRADES' WORK IN DISTRIBUTION FRAME ROOMS.

D1 EXISTING TELECOMMUNICATIONS OUTLET TO BE REMOVED. REMOVE CABLEING BACK TO SOURCE.
D2 EXISTING WIRELESS ACCESS POINT TO BE REMOVED. RETAIN DEVICE AND ALL RELATED HARDWARE.
D3 FOR REINSTALLATION. REMOVE CABLEING BACK TO SOURCE.
D4 PAGING SPEAKER TO BE REMOVED. REMOVE CABLEING BACK TO SOURCE.
D5 EXISTING TELECOMMUNICATIONS OUTLET TO BE REMOVED. REMOVE CABLEING BACK TO SOURCE.
D6 EXISTING CAMERA TO BE REMOVED. RETAIN DEVICE AND ALL RELATED HARDWARE FOR
D7 REINSTALLATION. PROTECT CABLEING FOR REUSE.
D8 EXISTING DOOR CONTACT TO BE REMOVED. PROTECT SIGNAL CABLEING FOR REUSE.
D9 DOOR STRIKE TO BE REMOVED. PROTECT SIGNAL CABLEING FOR REUSE.
D10 CARD READER TO BE REMOVED. RETAIN DEVICE AND ALL RELATED HARDWARE. PROTECT SIGNAL
D11 CABLEING FOR REUSE.
D12 REQUEST TO BEXT TO BE REMOVED. PROTECT SIGNAL CABLEING FOR REUSE.
D13 EXISTING INTERACTIVE BOARD TO BE REMOVED. RETAIN DEVICE AND ALL RELATED HARDWARE.
D14 EXISTING COAXIAL CABLE OUTLET TO BE REMOVED. REMOVE CABLEING BACK TO SOURCE.
D1 EXISTING PROJECTOR TO BE REMOVED. REMOVE SIGNAL CABLEING BACK TO SOURCE.
D2 EXISTING CLOCK TO BE REMOVED. RETAIN DEVICE FOR REINSTALLATION. REMOVE SIGNAL CABLEING
D3 BACK TO SOURCE.
D4 EXISTING CAMERA TO BE REMOVED. PROTECT CABLEING FOR REUSE.



2025 ERWIN VALLEY ELEM & ADMIN BUILDING ALTERATIONS
CORNING-PAINTED POST AREA SCHOOL DISTRICT

EV-T0.2


PROJECT NO: 2649-160

GENERAL NOTES - TECHNOLOGY


- A ALL CABLING INSTALLATION AND TERMINATION TO ADHERE TO CURRENT NEC CODES AND RELATED ANSITIA/EIA STANDARDS.
- B DURING INSTALLATION OF CABLING, ANY DAMAGE TO ANY FUNCTIONING CABLING SYSTEM IS THE RESPONSIBILITY OF, AND WILL BE REPAIRED BY THE CONTRACTOR.
- C WHEN INSTALLING CABLING FOR CEILING MOUNTED DEVICES, ADJUST LOCATION TO AVOID OTHER CEILING MOUNTED DEVICES SUCH AS EXIT SIGNS, ECT.
- D ALL DATA CABLING SHALL BE PLENUM RATED PER SPECIFICATIONS.
- E OWNER TO APPROVE FINAL LOCATION AND VIEW OF ALL CAMERAS.
- F ALL ELECTRONIC AND NETWORKING SERVICES NEED TO BE COORDINATED WITH OWNER PRIOR TO REMOVAL AND DISCONNECTION.
- G ALL CEILING MOUNTED DEVICES TO BE SUPPORTED BY STRUCTURE ABOVE. DO NOT USE CEILING GRID AS SCALE SUPPORT MECHANISM.
- H PROTECT NETWORK EQUIPMENT DURING INSTALLATION OF OTHER TRADES' WORK IN DISTRIBUTION FRAME ROOMS.

TECHNOLOGY DEMOLITION NOTES


- D1 EXISTING TELECOMMUNICATIONS OUTLET TO BE REMOVED. REMOVE CABLING BACK TO SOURCE.
- D2 EXISTING WIRELESS ACCESS POINT TO BE REMOVED. RETAIN DEVICE AND ALL RELATED HARDWARE FOR REINSTALLATION. REMOVE CABLING BACK TO SOURCE.
- D3 PAGING SPEAKER TO BE REMOVED. REMOVE CABLING BACK TO SOURCE.
- D4 EXISTING TELECOMMUNICATIONS OUTLET TO BE REMOVED. REMOVE CABLING BACK TO SOURCE.
- D5 EXISTING CAMERA TO BE REMOVED. RETAIN DEVICE AND ALL RELATED HARDWARE FOR REINSTALLATION. PROTECT CABLING FOR REUSE.
- D6 EXISTING DOOR CONTACT TO BE REMOVED. PROTECT SIGNAL CABLING FOR REUSE.
- D7 DOOR STRIKE TO BE REMOVED. PROTECT SIGNAL CABLING FOR REUSE.
- D8 CARD READER TO BE REMOVED. RETAIN DEVICE AND ALL RELATED HARDWARE. PROTECT SIGNAL CABLING FOR REUSE.
- D9 REQUEST TO BEIT TO BE REMOVED. PROTECT SIGNAL CABLING FOR REUSE.
- D10 EXISTING INTERACTIVE BOARD TO BE REMOVED. RETAIN DEVICE AND ALL RELATED HARDWARE. REMOVE SIGNAL CABLING BACK TO SOURCE.
- D11 EXISTING COAXIAL CABLE OUTLET TO BE REMOVED. REMOVE CABLING BACK TO SOURCE.
- D12 EXISTING PROJECTOR TO BE REMOVED. REMOVE SIGNAL CABLING BACK TO SOURCE.
- D13 EXISTING CLOCK TO BE REMOVED. RETAIN DEVICE FOR REINSTALLATION. REMOVE SIGNAL CABLING BACK TO SOURCE.
- D14 EXISTING CAMERA TO BE REMOVED. PROTECT CABLING FOR REUSE.

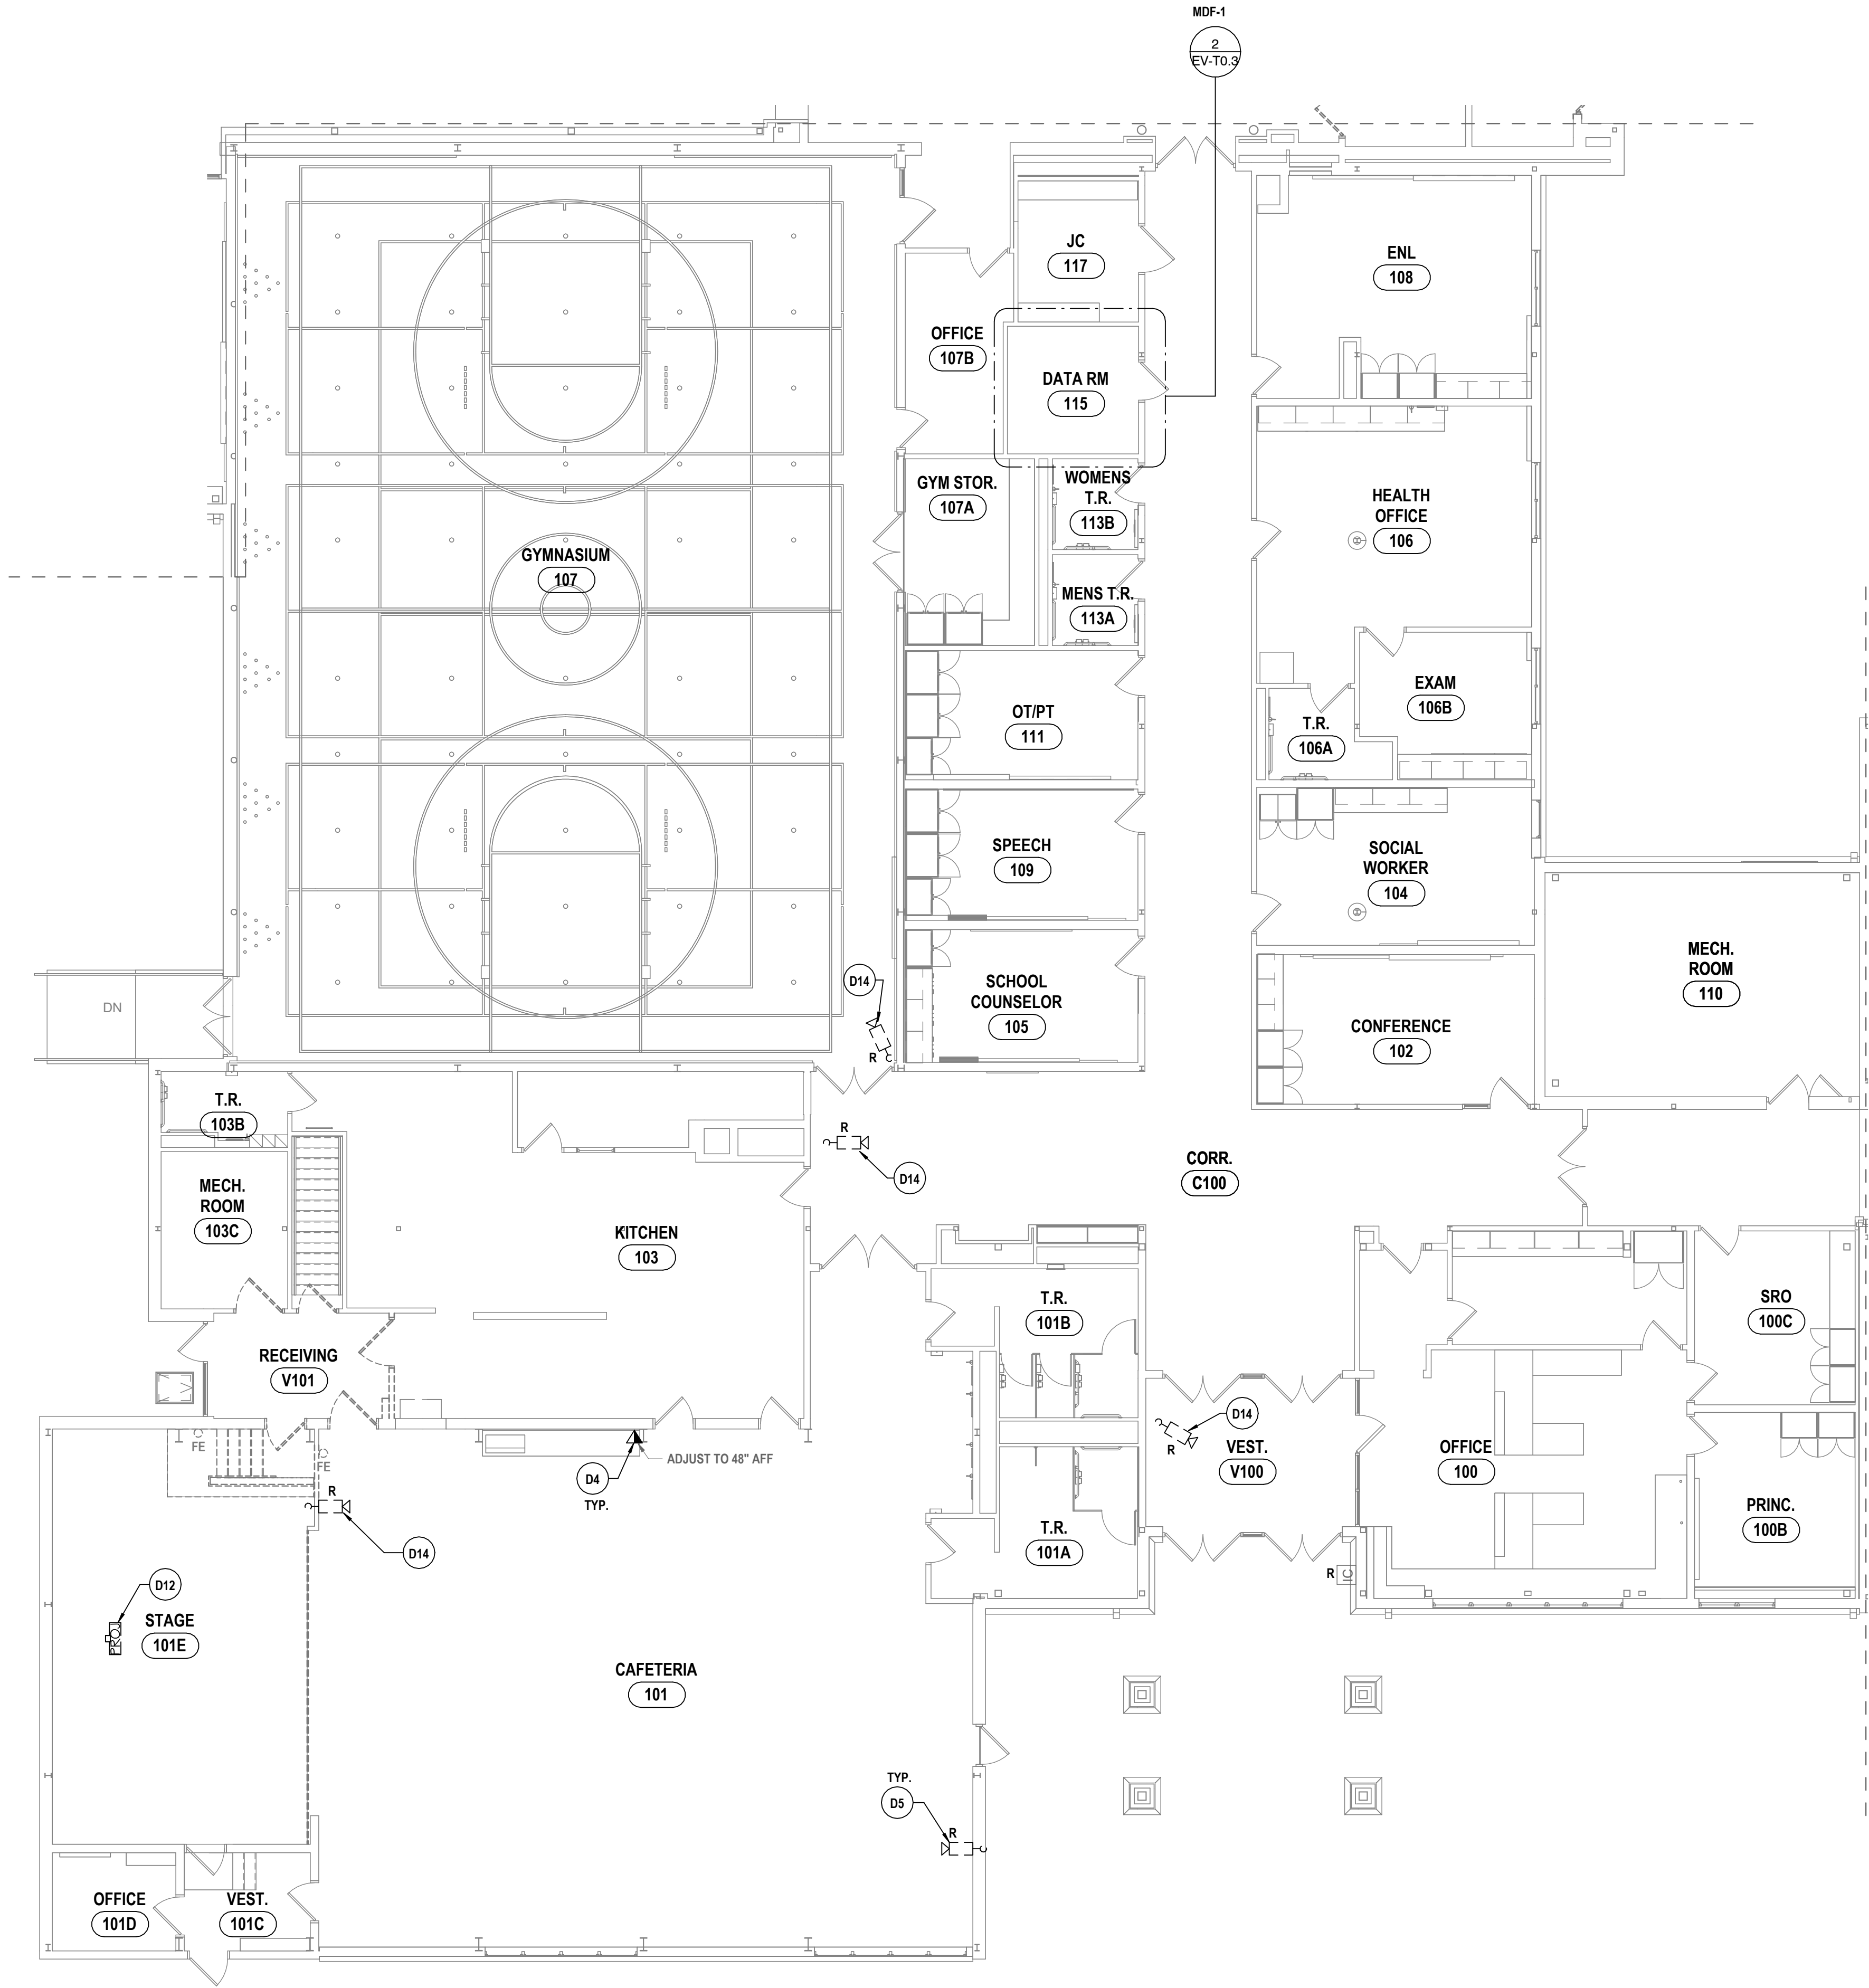


1 FIRST FLOOR TECHNOLOGY DEMOLITION PLAN - AREA B
1/8" = 1'-0"

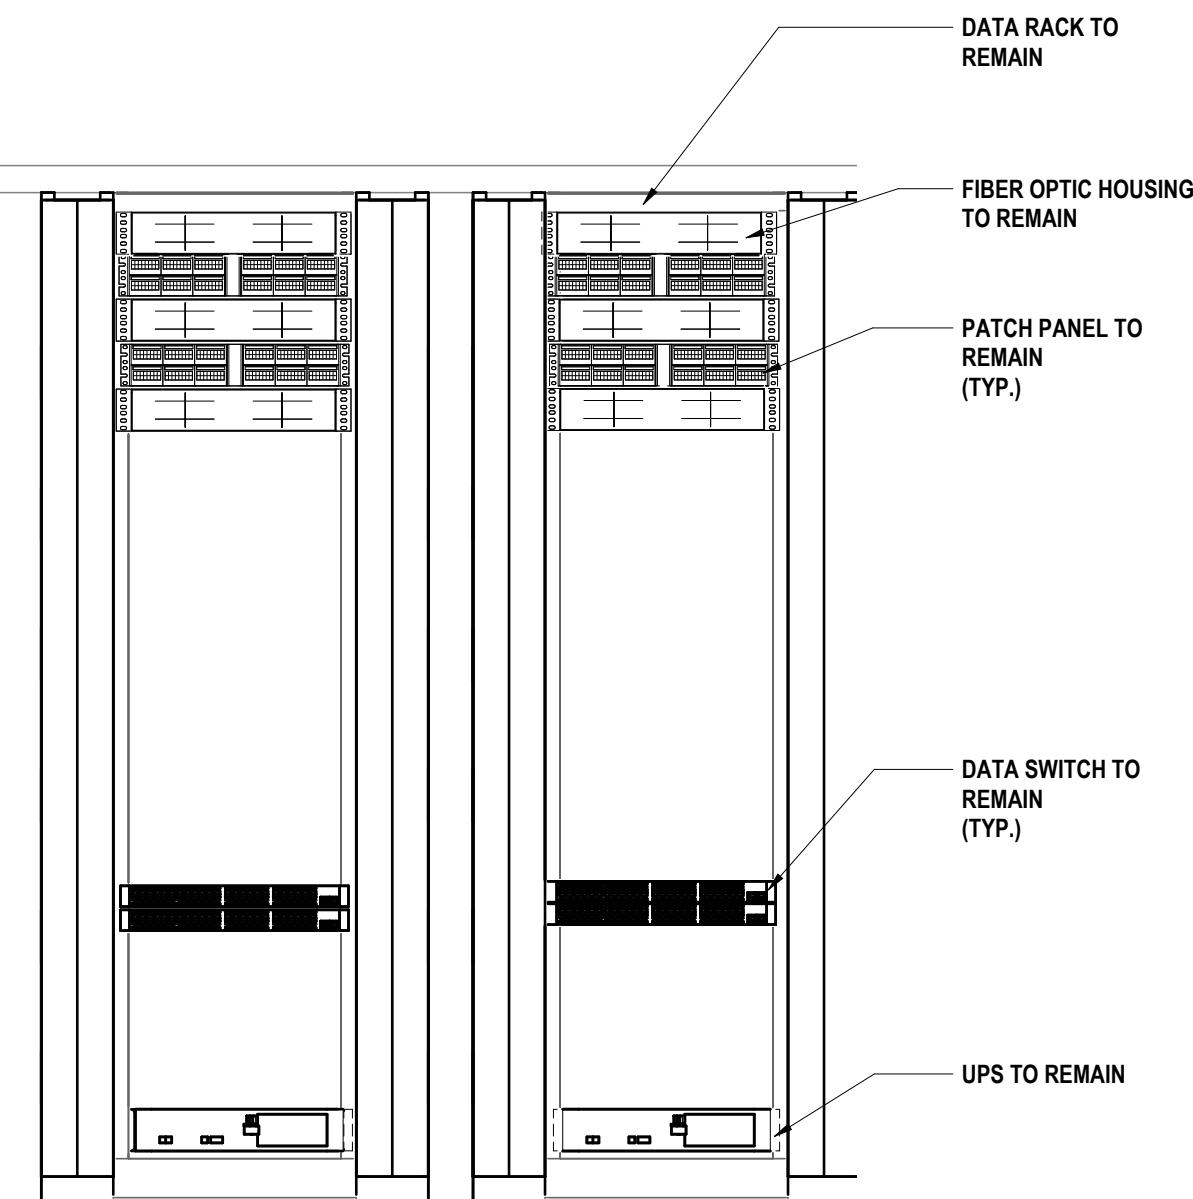

3 MDF ELEVATION DEMO VIEW
3/4" = 1'-0"

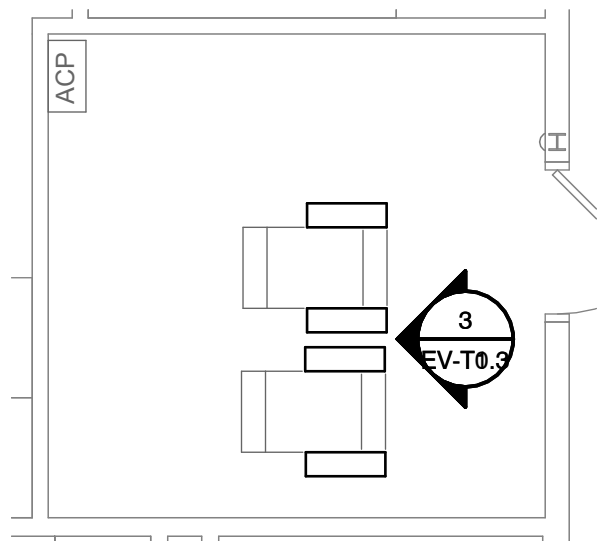

2 MDF RM 113 ENLARGED DEMO VIEW
1/4" = 1'-0"

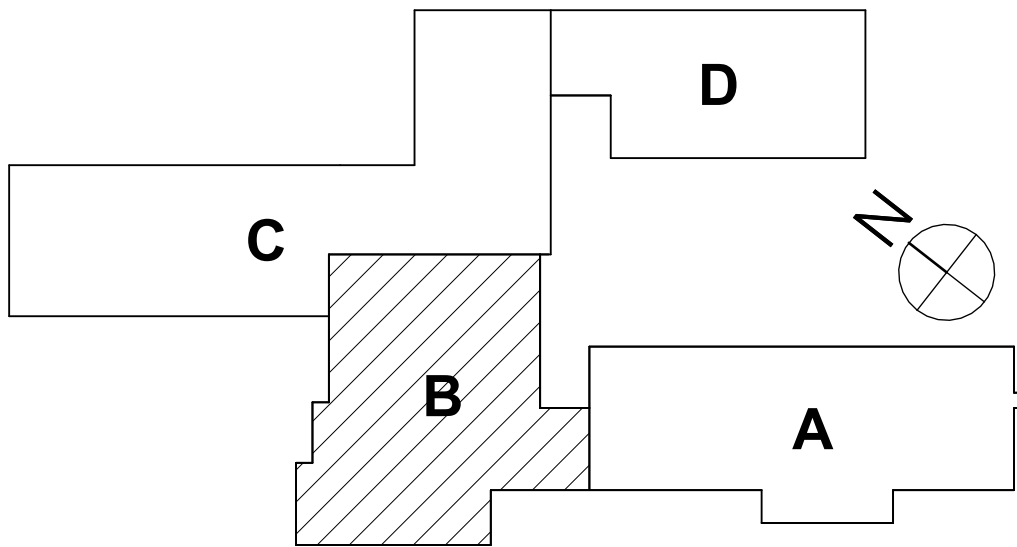

FIRST FLOOR TECHNOLOGY DEMO PLAN - AREA B
2025 ERWIN VALLEY ELEM & ADMIN BUILDING ALTERATIONS
CORNING-PAINTED POST AREA SCHOOL DISTRICT
16 BEARTOWN ROAD, PAINTED POST, NY 14870

EV-T0.3

PROJECT NO: 2649-160

HUNT ENGINEERS | ARCHITECTS | SURVEYORS
HORSEHEADS, NY 13091 ROCHESTER, NY 585-537-7549 TOWNANDA, PA 570-265-4666
BINGHAMTON, NY 607-798-8881 ALBANY, NY 607-798-8881
WWW.HUNTEAS.COM
NY CERTIFICATE NO. 001920 PA CERTIFICATE NO. TSC220313464-1

DESCRIPTION OF REVISION:
ISSUED FOR BID

DATE:
1 10/12/2026

PHASE:

CHECKED BY:

DATE: 03/17/2026

DRAWN BY: TAWO

ISSUED FOR BID

10/12/2026

03/17/2026

TAWO

GJB

CP

10/12/2026

03/17/2026

TAWO

GJB

CP

10/12/2026

03/17/2026

TAWO

GJB

CP

10/12/2026

03/17/2026

TAWO

GJB

CP

10/12/2026

03/17/2026

TAWO

GJB

CP

10/12/2026

03/17/2026

TAWO

GJB

CP

10/12/2026

03/17/2026

TAWO

GJB

CP

10/12/2026

03/17/2026

TAWO

GJB

CP

10/12/2026

03/17/2026

TAWO

GJB

CP

10/12/2026

03/17/2026

TAWO

GJB

CP

10/12/2026

03/17/2026

TAWO

GJB

CP

10/12/2026

03/17/2026

TAWO

GJB

CP

10/12/2026

03/17/2026

TAWO

GJB

CP

10/12/2026

03/17/2026

TAWO

GJB

CP

10/12/2026

03/17/2026

TAWO

GJB

CP

10/12/2026

03/17/2026

TAWO

GJB

CP

10/12/2026

03/17/2026

TAWO

GJB

CP

10/12/2026

03/17/2026

TAWO

GJB

CP

10/12/2026

03/17/2026

TAWO

GJB

CP

10/12/2026

03/17/2026

TAWO

GJB

CP

10/12/2026

03/17/2026

TAWO

GJB

CP

10/12/2026

03/17/2026

TAWO

GJB

CP

10/12/2026

03/17/2026

TAWO

GJB

CP

10/12/2026

03/17/2026

TAWO

GJB

CP

10/12/2026

03/17/2026

TAWO

GJB

CP

10/12/2026

03/17/2026

TAWO

GJB

CP

10/12/2026

03/17/2026

TAWO

GJB

CP

10/12/2026

03/17/2026

TAWO

GJB

CP

10/12/2026

03/17/2026

TAWO

GJB

CP

10/12/2026

03/17/2026

TAWO

GJB

CP

10/12/2026

03/17/2026

TAWO

GJB

CP

10/12/2026

03/17/2026

TAWO

GJB

CP

10/12/2026

03/17/2026

TAWO

GJB

CP

10/12/2026

03/17/2026

TAWO

GJB

CP

10/12/2026

03/17/2026

TAWO

GJB

CP

10/12/2026

03/17/2026

TAWO

GJB

CP

10/12/2026

03/17/2026

TAWO

GJB

CP

10/12/2026

03/17/2026

TAWO

GJB

CP

10/12/2026

03/17/2026

TAWO

GJB

CP

10/12/2026

03/17/2026

TAWO

GJB

CP

10/12/2026

03/17/2026

TAWO

GJB

CP

10/12/2026

03/17/2026

TAWO

GJB

CP

10/12/2026

03/17/2026

TAWO

GJB

CP

10/12/2026

03/17/2026

TAWO

GJB

CP

10/12/2026

03/17/2026

TAWO

GJB

CP

10/12/2026

03/17/2026

TAWO

GJB

CP

10/12/2026

03/17/2026

TAWO

GJB

CP

10/12/2026

03/17/2026

TAWO

GJB

CP

10/12/2026

03/17/2026

TAWO

GJB

CP

10/12/2026

03/17/2026

TAWO

GJB

CP

10/12/2026

03/17/2026

TAWO

GJB

CP

10/12/2026

03/17/2026

TAWO

GJB

CP

10/12/2026

03/17/2026

TAWO

GJB

CP

10/12/2026

03/17/2026

TAWO

GJB

CP

10/12/2026

03/17/2026

TAWO

GJB

CP

10/12/2026

03/17/2026

TAWO

GJB

GENERAL NOTES - TECHNOLOGY


- A ALL CABLING INSTALLATION AND TERMINATION TO ADHERE TO CURRENT NEC CODES AND RELATED ANSITIA/EIA STANDARDS.
- B DURING INSTALLATION OF CABLING, ANY DAMAGE TO ANY FUNCTIONING CABLING SYSTEM IS THE RESPONSIBILITY OF; AND WILL BE REPAIRED BY THE CONTRACTOR.
- C WHEN INSTALLING CABLING FOR CEILING MOUNTED DEVICES, ADJUST LOCATION TO AVOID OTHER CEILING MOUNTED DEVICES SUCH AS EXIT SIGNS, ECT.
- D ALL DATA CABLING SHALL BE PLENUM RATED PER SPECIFICATIONS.
- E OWNER TO APPROVE FINAL LOCATION AND VIEW OF ALL CAMERAS.
- F ALL ELECTRONIC AND NETWORKING SERVICES NEED TO BE COORDINATED WITH OWNER PRIOR TO REMOVAL AND DISCONNECTION.
- G ALL CEILING MOUNTED DEVICES TO BE SUPPORTED BY STRUCTURE ABOVE. DO NOT USE CEILING GRID AS SOLE SUPPORT MECHANISM.
- H PROTECT NETWORK EQUIPMENT DURING INSTALLATION OF OTHER TRADES' WORK IN DISTRIBUTION FRAME ROOMS.

TECHNOLOGY DEMOLITION NOTES

- D1 EXISTING TELECOMMUNICATIONS OUTLET TO BE REMOVED. REMOVE CABLING BACK TO SOURCE.
- D2 EXISTING WIRELESS ACCESS POINT TO BE REMOVED. RETAIN DEVICE AND ALL RELATED HARDWARE FOR REINSTALLATION. REMOVE CABLING BACK TO SOURCE.
- D3 PAGING SPEAKER TO BE REMOVED. REMOVE CABLING BACK TO SOURCE.
- D4 EXISTING TELECOMMUNICATIONS OUTLET TO BE REMOVED. REMOVE CABLING BACK TO SOURCE.
- D5 EXISTING CAMERA TO BE REMOVED. RETAIN DEVICE AND ALL RELATED HARDWARE FOR REINSTALLATION. PROTECT CABLING FOR REUSE.
- D6 EXISTING DOOR CONTACT TO BE REMOVED. PROTECT SIGNAL CABLING FOR REUSE.
- D7 DOOR STRIKE TO BE REMOVED. PROTECT SIGNAL CABLING FOR REUSE.
- D8 CARD READER TO BE REMOVED. RETAIN DEVICE AND ALL RELATED HARDWARE. PROTECT SIGNAL CABLING FOR REUSE.
- D9 REQUEST TO BEIT TO BE REMOVED. PROTECT SIGNAL CABLING FOR REUSE.
- D10 EXISTING INTERACTIVE BOARD TO BE REMOVED. RETAIN DEVICE AND ALL RELATED HARDWARE. REMOVE SIGNAL CABLING BACK TO SOURCE.
- D11 EXISTING COAXIAL CABLE OUTLET TO BE REMOVED. REMOVE CABLING BACK TO SOURCE.
- D12 EXISTING PROJECTOR TO BE REMOVED. REMOVE SIGNAL CABLING BACK TO SOURCE.
- D13 EXISTING CLOCK TO BE REMOVED. RETAIN DEVICE FOR REINSTALLATION. REMOVE SIGNAL CABLING BACK TO SOURCE.
- D14 EXISTING CAMERA TO BE REMOVED. PROTECT CABLING FOR REUSE.



1 FIRST FLOOR TECHNOLOGY DEMOLITION PLAN - AREA C
1/8" = 1'-0"

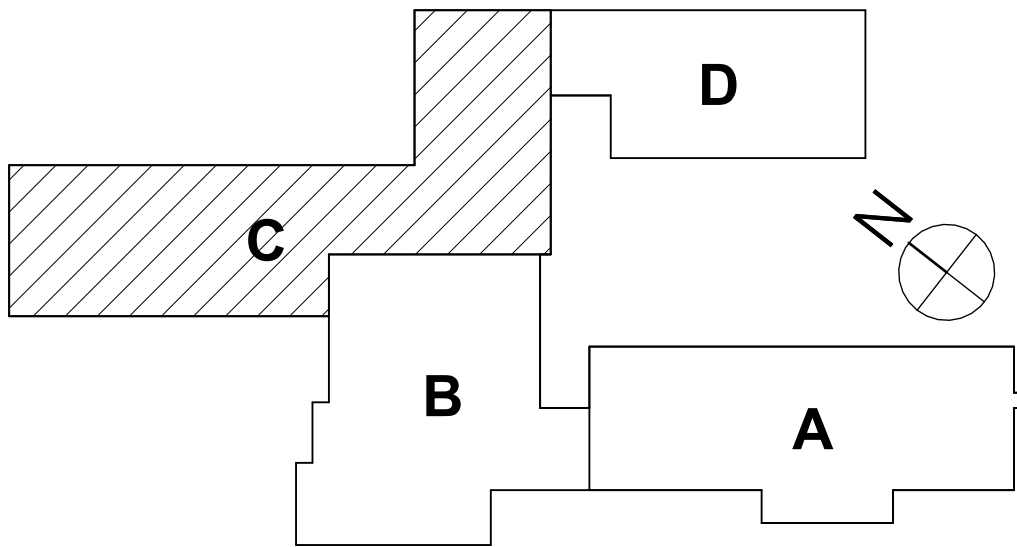

SEE NUMBERS EV-1510-00-01-000-007, AD-1510-00-01-1-001-013

FIRST FLOOR TECHNOLOGY DEMO PLAN - AREA C

2025 ERWIN VALLEY ELEM & ADMIN BUILDING ALTERATIONS
CORNING-PAINTED POST AREA SCHOOL DISTRICT

16 BEARTOWN ROAD, PAINTED POST NY 14870

EV-T0.4

PROJECT NO: 2649-160

HUNT ENGINEERS | ARCHITECTS | SURVEYORS

HORSEHEADS, NY 607-263-1000 ROCHESTER, NY 585-537-7868 TOWNANDA, PA 570-265-4668

BINGHAMTON, NY 607-798-8881 ALBANY, NY 607-798-8881

WWW.HUNTEAS.COM

NY CERTIFICATE NO. 001620 PA CERTIFICATE NO. TSC220313/464-1

DESCRIPTION OF REVISION:
ISSUED FOR BID

DATE:
1 10/12/2026

PHASE:

CP

CHECKED BY:

GJB

DATE:


03/17/2026

DRAWN BY:


TAWO

Copyright 2025


IT IS A VIOLATION OF THE LAW FOR ANY PERSON TO MAKE UNAUTHORIZED ALTERATIONS OR ADDITIONS TO PLANS
DRAWN BY LICENSED ENGINEER; ARCHITECT; SURVEYOR'S SEAL.

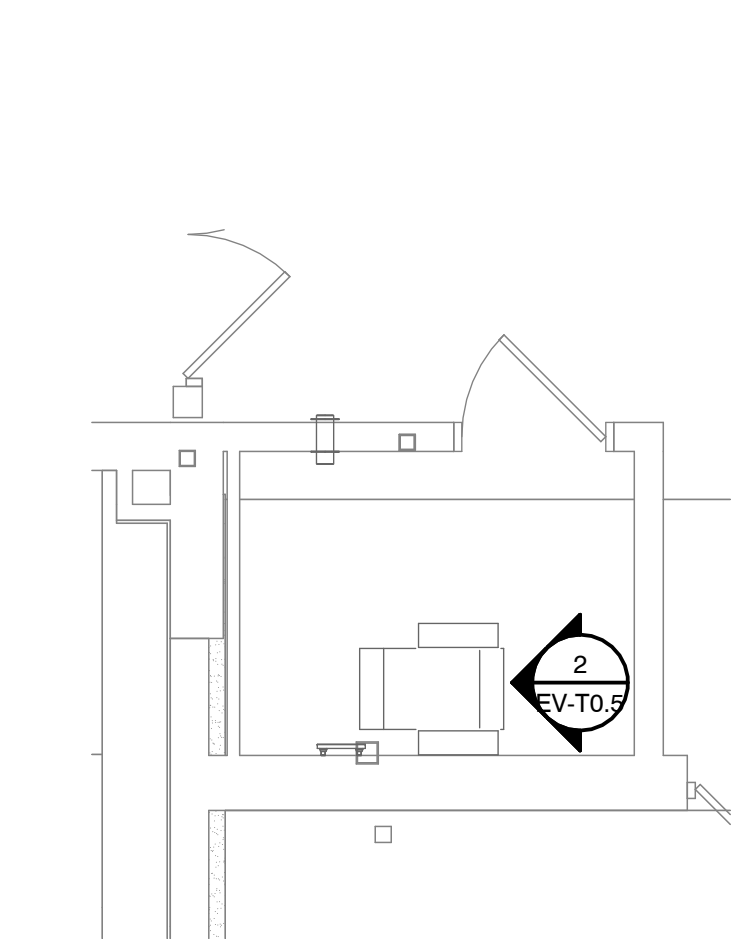

3 IDF-3 RM ST-1 ENLARGED DEMO VIEW
1/4" = 1'-0"

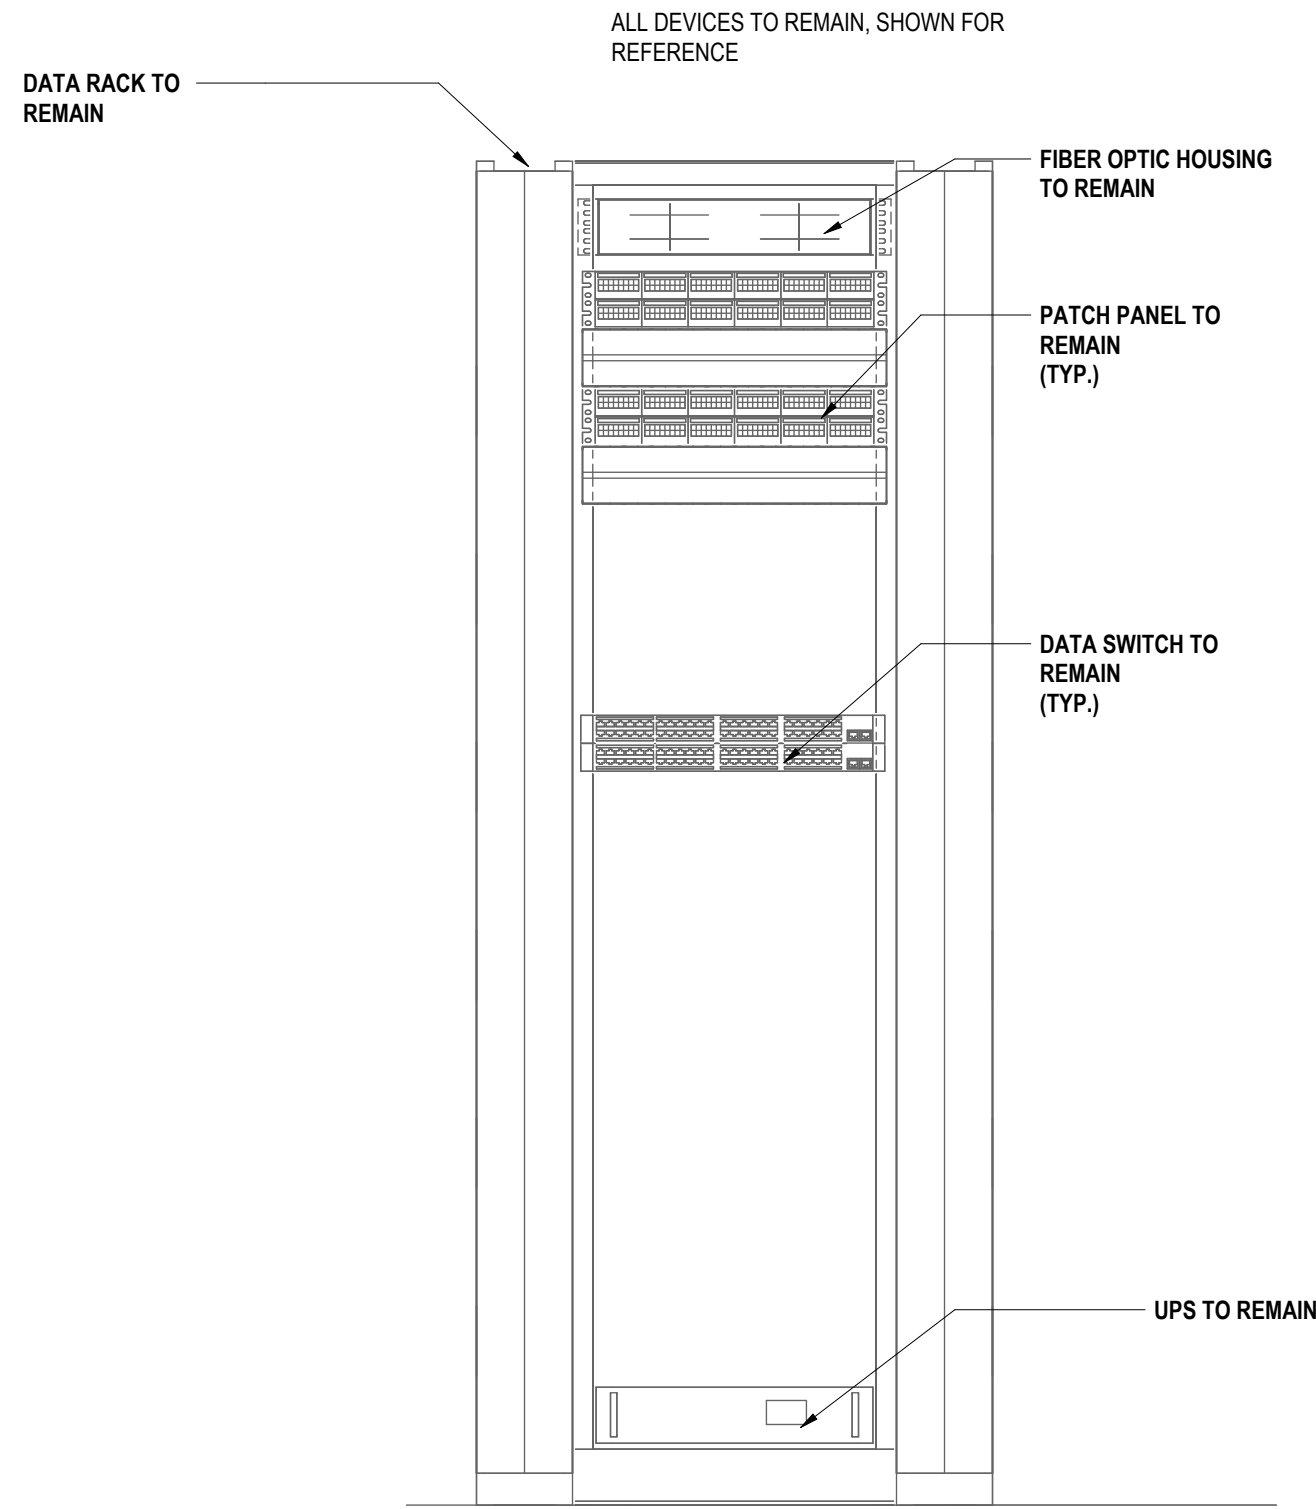

2 IDF-3 ELEVATION DEMO VIEW
1" = 1'-0"

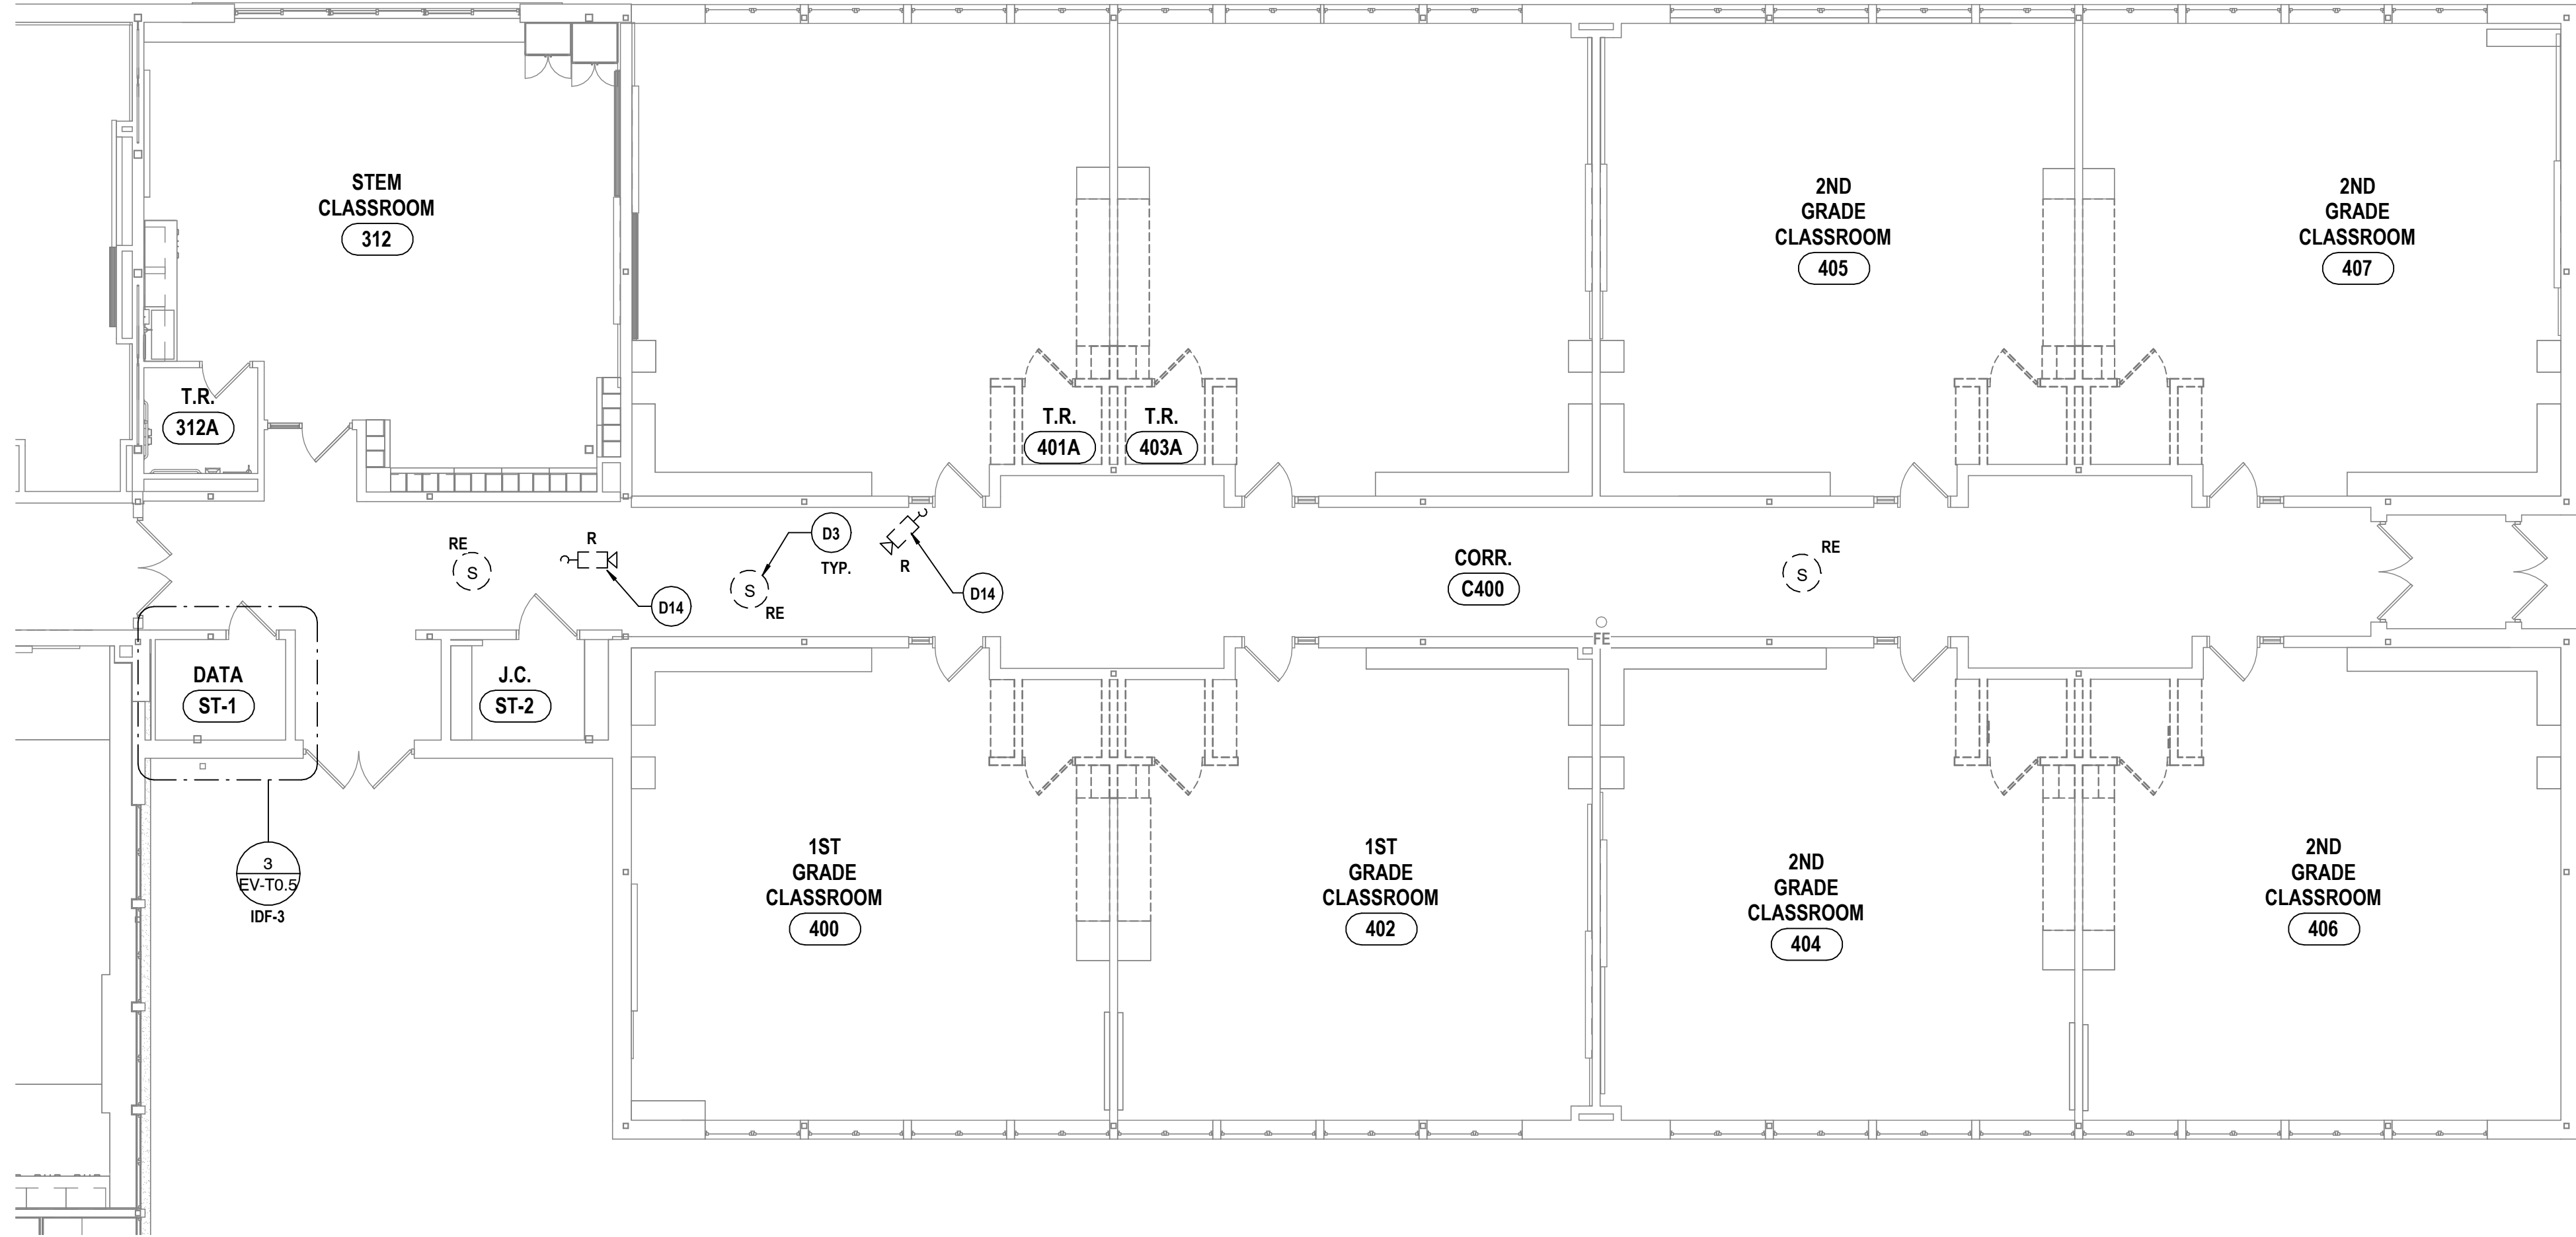

1 FIRST FLOOR TECHNOLOGY DEMOLITION PLAN - AREA D
1/8" = 1'-0"

GENERAL NOTES - TECHNOLOGY

- A ALL CABLING INSTALLATION AND TERMINATION TO ADHERE TO CURRENT NEC CODES AND RELATED ANSITIA/EIA STANDARDS.
- B DURING INSTALLATION OF CABLING, ANY DAMAGE TO ANY FUNCTIONING CABLING SYSTEM IS THE RESPONSIBILITY OF; AND WILL BE REPAIRED BY THE CONTRACTOR.
- C WHEN INSTALLING CABLING FOR CEILING MOUNTED DEVICES, ADJUST LOCATION TO AVOID OTHER CEILING MOUNTED DEVICES SUCH AS EXIT SIGNS, ECT.
- D ALL DATA CABLING SHALL BE PLENUM RATED PER SPECIFICATIONS.
- E OWNER TO APPROVE FINAL LOCATION AND VIEW OF ALL CAMERAS.
- F ALL ELECTRONIC AND NETWORKING SERVICES NEED TO BE COORDINATED WITH OWNER PRIOR TO REMOVAL AND DISCONNECTION.
- G ALL CEILING MOUNTED DEVICES TO BE SUPPORTED BY STRUCTURE ABOVE. DO NOT USE CEILING GRID AS SCALE SUPPORT MECHANISM.
- H PROTECT NETWORK EQUIPMENT DURING INSTALLATION OF OTHER TRADES' WORK IN DISTRIBUTION FRAME ROOMS.

- D1 EXISTING TELECOMMUNICATIONS OUTLET TO BE REMOVED. REMOVE CABLING BACK TO SOURCE.
- D2 EXISTING WIRELESS ACCESS POINT TO BE REMOVED. RETAIN DEVICE AND ALL RELATED HARDWARE FOR REINSTALLATION. REMOVE CABLING BACK TO SOURCE.
- D3 PAGING SPEAKER TO BE REMOVED. REMOVE CABLING BACK TO SOURCE.
- D4 EXISTING TELECOMMUNICATIONS OUTLET TO BE REMOVED. REMOVE CABLING BACK TO SOURCE.
- D5 EXISTING CAMERA TO BE REMOVED. RETAIN DEVICE AND ALL RELATED HARDWARE FOR REINSTALLATION. PROTECT CABLING FOR REUSE.
- D6 EXISTING DOOR CONTACT TO BE REMOVED. PROTECT SIGNAL CABLING FOR REUSE.
- D7 DOOR STRIKE TO BE REMOVED. PROTECT SIGNAL CABLING FOR REUSE.
- D8 CARD READER TO BE REMOVED. RETAIN DEVICE AND ALL RELATED HARDWARE. PROTECT SIGNAL CABLING FOR REUSE.
- D9 REQUEST TO BEIT TO BE REMOVED. PROTECT SIGNAL CABLING FOR REUSE.
- D10 EXISTING INTERACTIVE BOARD TO BE REMOVED. RETAIN DEVICE AND ALL RELATED HARDWARE. REMOVE SIGNAL CABLING BACK TO SOURCE.
- D11 EXISTING COAXIAL CABLE OUTLET TO BE REMOVED. REMOVE CABLING BACK TO SOURCE.
- D12 EXISTING PROJECTOR TO BE REMOVED. REMOVE SIGNAL CABLING BACK TO SOURCE.
- D13 EXISTING CLOCK TO BE REMOVED. RETAIN DEVICE FOR REINSTALLATION. REMOVE SIGNAL CABLING BACK TO SOURCE.
- D14 EXISTING CAMERA TO BE REMOVED. PROTECT CABLING FOR REUSE.

TECHNOLOGY DEMOLITION NOTES

DRAWN BY: TAWO	
CHECKED BY: GJB	
DATE: 03/17/2026	
PHASE: CP	
#	DATE:
1	03/17/2026
DESCRIPTION OF REVISION: ISSUED FOR BID	
IT IS A VIOLATION OF THE LAW FOR ANY PERSON TO MAKE UNAUTHORIZED ALTERATIONS OR ADDITIONS TO PLANS DRAWN BY LICENSED ARCHITECTS OR ENGINEERS. CONTRACTORS SHALL PROTECT SURVEYORS' BUILT.	

HUNT ENGINEERS | ARCHITECTS | SURVEYORS


HORSEHEADS, NY 607-268-1000 ROCHESTER, NY 585-537-7649 TOWNHALL, PA 570-265-4666
BINGHAMTON, NY 607-798-8881 ALBANY, NY 607-798-8881
WWW.HUNTEAS.COM

NY CERTIFICATE NO. 001620 PA CERTIFICATE NO. TSC220313464-1


FIRST FLOOR TECHNOLOGY DEMO PLAN - AREA D
2025 ERWIN VALLEY ELEM & ADMIN BUILDING ALTERATIONS
CORNING-PAINTED POST AREA SCHOOL DISTRICT
16 BEARTOWN ROAD, PAINTED POST, NY 14870

EV-T0.5

PROJECT NO: 2649-160

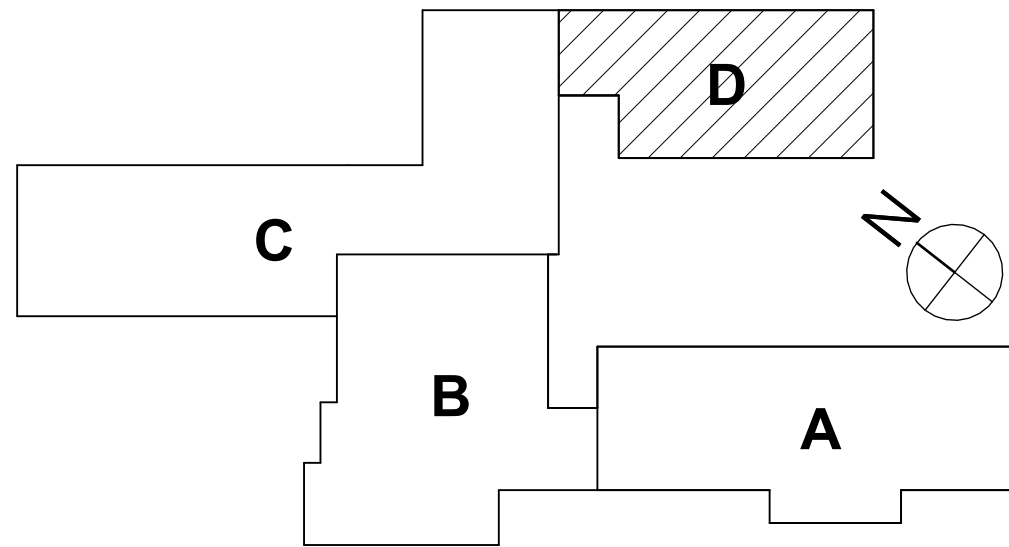

SED NUMBERS EV-51-00-00-01-000-007, AD-51-00-00-01-001-013

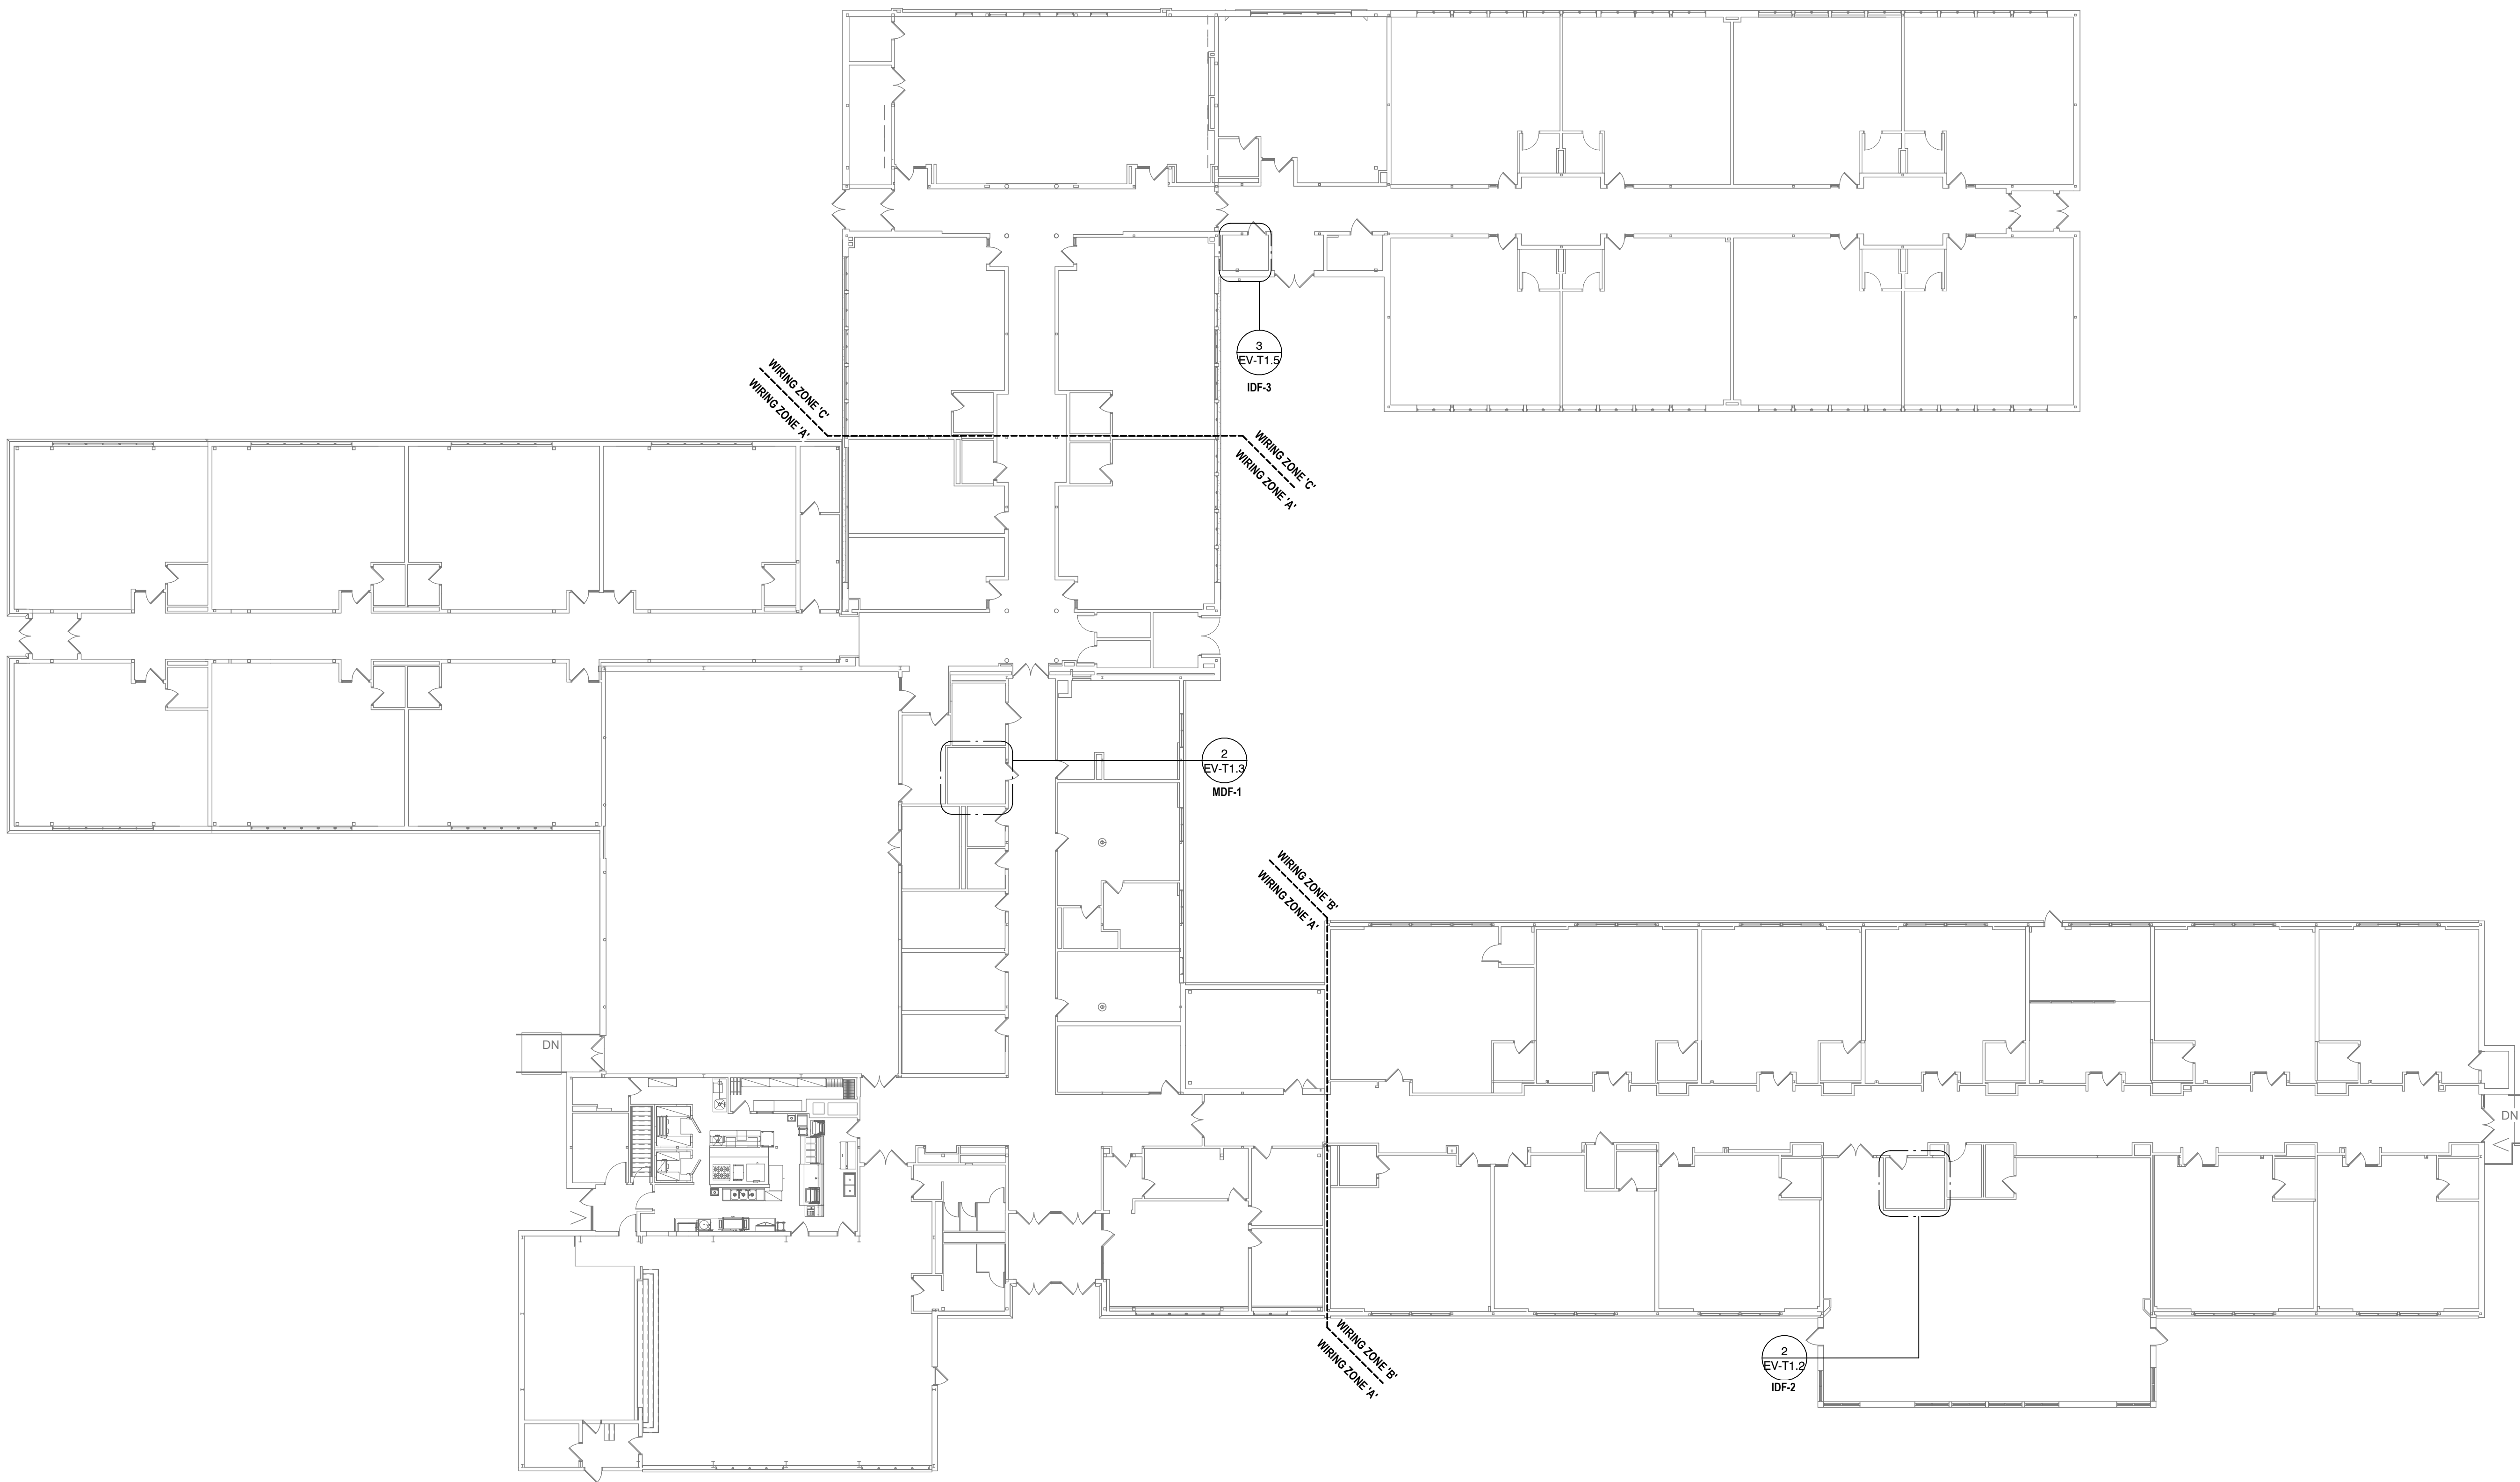

1 FIRST FLOOR TECHNOLOGY KEYPLAN
1/16" = 1'-0"

GENERAL NOTES - TECHNOLOGY

- A ALL CABLING INSTALLATION AND TERMINATION TO ADHERE TO CURRENT NEC CODES AND RELATED ANSITIA/EIA STANDARDS
- B DURING INSTALLATION OF CABLING, ANY DAMAGE TO ANY FUNCTIONING CABLING SYSTEM IS THE RESPONSIBILITY OF, AND WILL BE REPAIRED BY THE CONTRACTOR.
- C WHEN INSTALLING CABLING FOR CEILING MOUNTED DEVICES, ADJUST LOCATION TO AVOID OTHER CEILING MOUNTED DEVICES SUCH AS EXIT SIGNS, ECT.
- D ALL DATA CABLING SHALL BE PLENUM RATED PER SPECIFICATIONS.
- E OWNER TO APPROVE FINAL LOCATION AND VIEW OF ALL CAMERAS.
- F ALL ELECTRONIC AND NETWORKING SERVICES NEED TO BE COORDINATED WITH OWNER PRIOR TO REMOVAL AND DISCONNECTION.
- G ALL CEILING MOUNTED DEVICES TO BE SUPPORTED BY STRUCTURE ABOVE. DO NOT USE CEILING GRID AS SOLE SUPPORT MECHANISM.
- H PROTECT NETWORK EQUIPMENT DURING INSTALLATION OF OTHER TRADES' WORK IN DISTRIBUTION FRAME ROOMS.

DRAWN BY: TAWW	
CHECKED BY: GJB	
DATE: 03/17/2026	
PHASE: CP	
DESCRIPTION OF REVISION: ISSUED FOR BID	
#	DATE:
1	10/12/2026
IT IS A VIOLATION OF THE LAW FOR ANY PERSON TO MAKE UNAUTHORIZED ALTERATIONS OR ADDITIONS TO PLANS OR ANY PART THEREOF. ANY SUCH ALTERATIONS, ADDITIONS, OR DELETIONS SHALL BE AT THE USER'S SOLE RISK.	

HUNT ENGINEERS | ARCHITECTS | SURVEYORS
HORSEHEADS, NY 807-265-1000 ROCKY HILLS, NY 565-537-7549 TOWANDA, PA 570-265-4666
BINGHAMTON, NY 607-798-8881 ALBANY, NY 607-798-8881 WWW.HUNTEAS.COM
NY CERTIFICATE NO. 001620 PA CERTIFICATE NO. TSC220313464-1

FIRST FLOOR TECHNOLOGY KEYPLAN
2025 ERWIN VALLEY ELEM & ADMIN BUILDING ALTERATIONS
CORNING-PAINTED POST AREA SCHOOL DISTRICT
16 BEARTOWN ROAD, PAINTED POST, NY 14870

EV-T1.1

PROJECT NO: 2649-160


SEE NUMBERS EV-1510-00-01-0-009-007, AD-2516-00-01-1-001-013

GENERAL NOTES - TECHNOLOGY

- A ALL CABLING INSTALLATION AND TERMINATION TO ADHERE TO CURRENT NEC CODES AND RELATED ANSII/TIA/EIA STANDARDS.
- B DURING INSTALLATION OF CABLING, ANY DAMAGE TO ANY FUNCTIONING CABLING SYSTEM IS THE RESPONSIBILITY OF, AND WILL BE REPAIRED BY THE CONTRACTOR.
- C WHEN INSTALLING CABLING FOR CEILING MOUNTED DEVICES, ADJUST LOCATION TO AVOID OTHER CEILING MOUNTED DEVICES SUCH AS EXIT SIGNS, ECT.
- D ALL DATA CABLING SHALL BE PLENUM RATED PER SPECIFICATIONS.
- E OWNER TO APPROVE FINAL LOCATION AND VIEW OF ALL CAMERAS.
- F ALL ELECTRONIC AND NETWORKING SERVICES NEED TO BE COORDINATED WITH OWNER PRIOR TO REMOVAL AND DISCONNECTION.
- G ALL CEILING MOUNTED DEVICES TO BE SUPPORTED BY STRUCTURE ABOVE. DO NOT USE CEILING GRID AS SOLE SUPPORT MECHANISM.
- H PROTECT NETWORK EQUIPMENT DURING INSTALLATION OF OTHER TRADES' WORK IN DISTRIBUTION FRAME ROOMS.

TECHNOLOGY CONSTRUCTION NOTES

- 1 SURVEILLANCE CAMERA. REQUIRES CABLING AND INSTALLATION PER DETAILS & SPECIFICATIONS.
- 2 REQUEST TO EXIT. REQUIRES CABLING AND INSTALLATION PER DETAILS & SPECIFICATIONS.
- 3 CARD READER. REQUIRES CABLING AND INSTALLATION PER DETAILS & SPECIFICATIONS.
- 4 DOOR CONTACT. REQUIRES CABLING AND INSTALLATION PER DETAILS & SPECIFICATIONS.
- 5 ASSISTED LISTENING SPEAKER. REQUIRES CABLING AND INSTALLATION PER DETAILS & SPECIFICATIONS.
- 6 DOOR STRIKE. REQUIRES CABLING AND INSTALLATION PER DETAILS & SPECIFICATIONS.
- 7 ASSISTED LISTENING CONTROLLER LOCATION. REQUIRES CABLING & INSTALLATION PER DETAILS & SPECIFICATIONS.
- 8 GROUNDING IMPROVEMENTS. IDENTIFY AND LABLE GROUNDING CONDUCTORS.
- 9 REPLACE ALL EXISTING PATCH CABLES WITH 28 AWG PATCH CABLES PER SPECIFICATIONS. TURN PATCH CABLES OVER TO OWNER FOR INSTALLATION.
- 10 CABLE SUPPORT BRACKETS TO BE INSTALLED AT EACH EXISTING AND NEW PATCH PANEL PER SPECIFICATIONS.
- 11 ENVIRONMENTAL MONITOR DEVICE. REQUIRES CABLING PER SPECIFICATIONS & DETAILS.
- 12 FLOOR MARKING TAPE TO BE INSTALLED OUTLING A 3 FOOT CLEARANCE FROM ALL SIDES OF THE DATA RACK.
- 13 INTERCOM. REQUIRES INSTALLATION PER SPECIFICATIONS & DETAILS. REUSE EXISTING SIGNAL CABLING.
- 14 WALL TELEPHONE OUTLET. REQUIRES CABLING PER SPECIFICATIONS & DETAILS. COORDINATE FINAL LOCATION WITH OWNER.

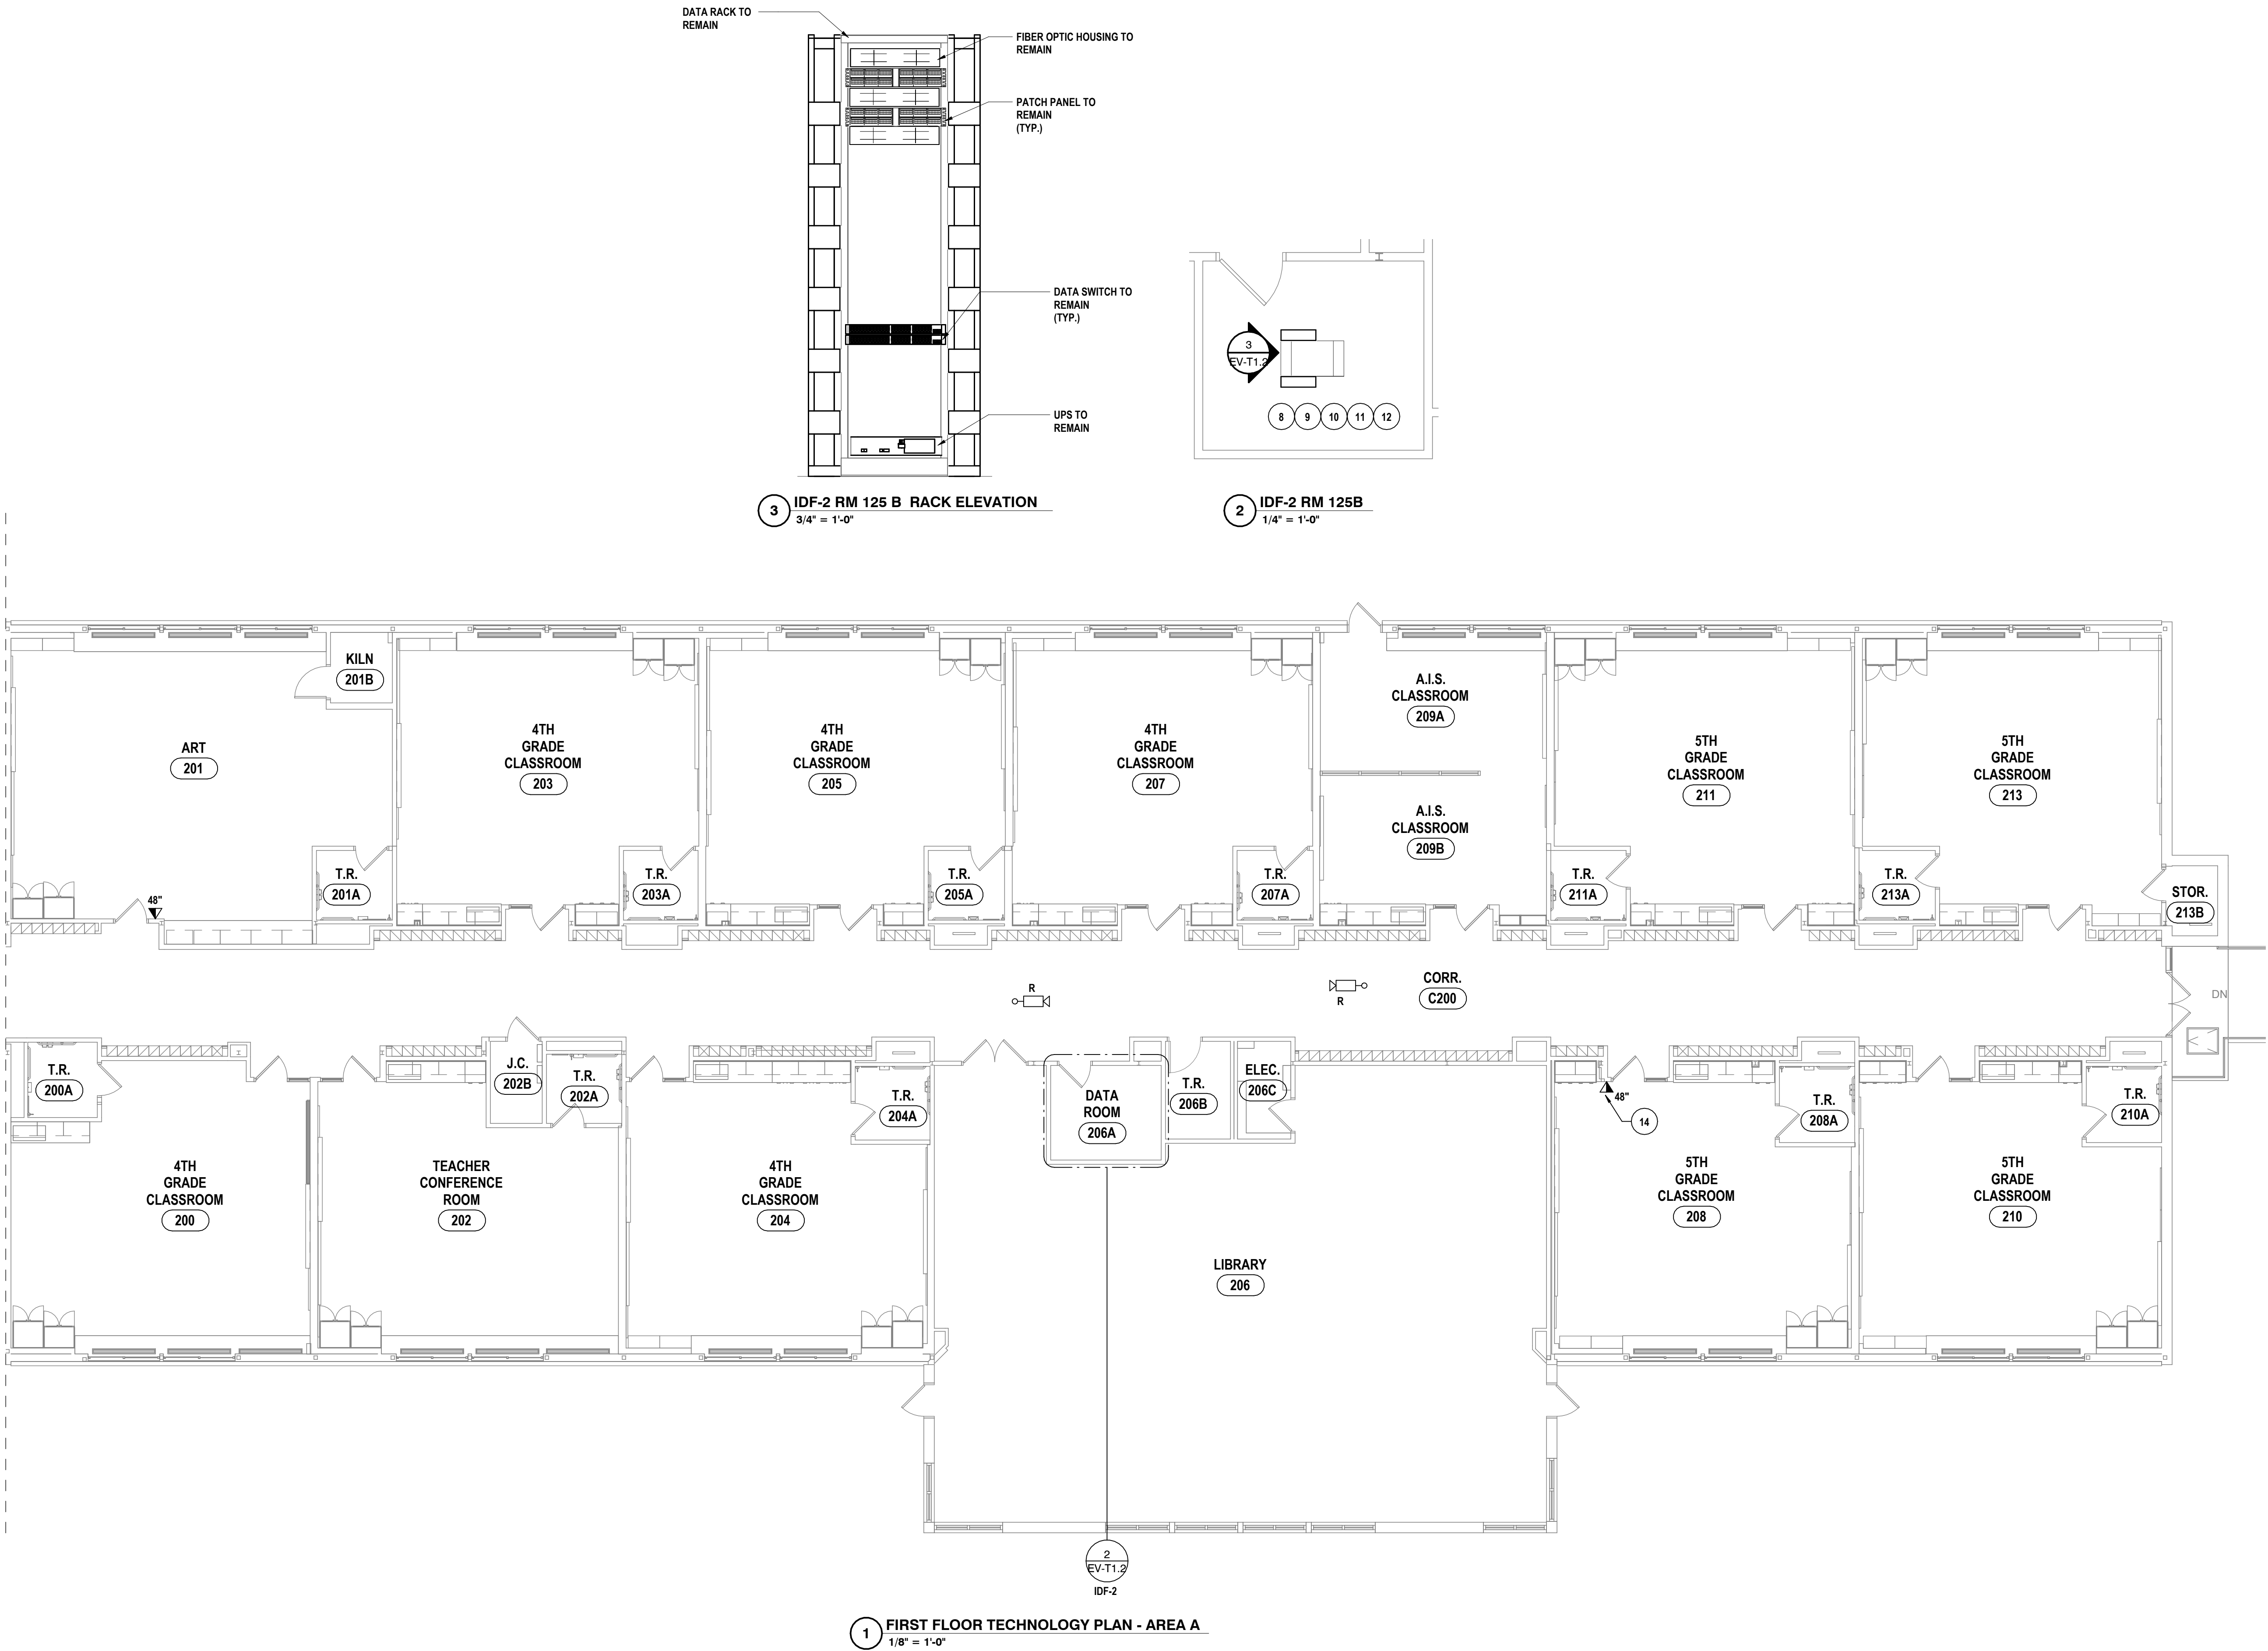

SED NUMBERS EV-1510-00-01-000-007 AD-1510-00-01-001-013

FIRST FLOOR TECHNOLOGY PLAN - AREA A
2025 ERWIN VALLEY ELEM & ADMIN BUILDING ALTERATIONS
CORNING-PAINTED POST AREA SCHOOL DISTRICT
16 BEARTOWN ROAD, PAINTED POST NY 14870

EV-T1.2
PROJECT NO: 2649-160

HUNT ENGINEERS | ARCHITECTS | SURVEYORS
HORSEHEADS, NY 807-263-1000 ROCHESTER, NY 585-337-7668 TOWNANDA, PA 570-265-4668
BINGHAMTON, NY 807-798-8881 ALBANY, NY 807-798-8881
WWW.HUNTEAS.COM
NY CERTIFICATE NO. 001620 PA CERTIFICATE NO. TSC2202013/464-1


DATE: 1 10/12/2026
DESCRIPTION OF REVISION:
ISSUED FOR BID
IT IS A VIOLATION OF THE LAW FOR ANY PERSON TO MAKE UNAUTHORIZED ALTERATIONS OR ADDITIONS TO PLANS
DRAWN BY: TAWO
CHECKED BY: GJB
DATE: 03/17/2026
PHASE: CD

GENERAL NOTES - TECHNOLOGY


- A ALL CABLING INSTALLATION AND TERMINATION TO ADHERE TO CURRENT NEC CODES AND RELATED ANSII/TIA/EIA STANDARDS.
- B DURING INSTALLATION OF CABLING, ANY DAMAGE TO ANY FUNCTIONING CABLING SYSTEM IS THE RESPONSIBILITY OF, AND WILL BE REPAIRED BY THE CONTRACTOR.
- C WHEN INSTALLING CABLING FOR CEILING MOUNTED DEVICES, ADJUST LOCATION TO AVOID OTHER CEILING MOUNTED DEVICES SUCH AS EXIT SIGNS, ECT.
- D ALL DATA CABLING SHALL BE PLENUM RATED PER SPECIFICATIONS.
- E OWNER TO APPROVE FINAL LOCATION AND VIEW OF ALL CAMERAS.
- F ALL ELECTRONIC AND NETWORKING SERVICES NEED TO BE COORDINATED WITH OWNER PRIOR TO REMOVAL AND DISCONNECTION.
- G ALL CEILING MOUNTED DEVICES TO BE SUPPORTED BY STRUCTURE ABOVE. DO NOT USE CEILING GRID AS SOLE SUPPORT MECHANISM.
- H PROTECT NETWORK EQUIPMENT DURING INSTALLATION OF OTHER TRADES' WORK IN DISTRIBUTION FRAME ROOMS.

TECHNOLOGY CONSTRUCTION NOTES

- 1 SURVEILLANCE CAMERA. REQUIRES CABLING AND INSTALLATION PER DETAILS & SPECIFICATIONS.
- 2 REQUEST TO EXIT. REQUIRES CABLING AND INSTALLATION PER DETAILS & SPECIFICATIONS.
- 3 CARD READER. REQUIRES CABLING AND INSTALLATION PER DETAILS & SPECIFICATIONS.
- 4 DOOR CONTACT. REQUIRES CABLING AND INSTALLATION PER DETAILS & SPECIFICATIONS.
- 5 ASSISTED LISTENING SPEAKER. REQUIRES CABLING AND INSTALLATION PER DETAILS & SPECIFICATIONS.
- 6 DOOR STRIKE. REQUIRES CABLING AND INSTALLATION PER DETAILS & SPECIFICATIONS.
- 7 ASSISTED LISTENING CONTROLLER LOCATION. REQUIRES CABLING & INSTALLATION PER DETAILS & SPECIFICATIONS.
- 8 GROUNDING IMPROVEMENTS. IDENTIFY AND LABEL GROUNDING CONDUCTORS.
- 9 REPLACE ALL EXISTING PATCH CABLES WITH 28 AWG PATCH CABLES PER SPECIFICATIONS. TURN PATCH CABLES OVER TO OWNER FOR INSTALLATION.
- 10 CABLE SUPPORT BRACKETS TO BE INSTALLED AT EACH EXISTING AND NEW PATCH PANEL PER SPECIFICATIONS.
- 11 ENVIRONMENTAL MONITOR DEVICE. REQUIRES CABLING PER SPECIFICATIONS & DETAILS.
- 12 FLOOR MARKING TAPE TO BE INSTALLED OUTLING A 3 FOOT CLEARANCE FROM ALL SIDES OF THE DATA RACK.
- 13 INTERCOM. REQUIRES INSTALLATION PER SPECIFICATIONS & DETAILS. REUSE EXISTING SIGNAL CABLING.
- 14 WALL TELEPHONE OUTLET. REQUIRES CABLING PER SPECIFICATIONS & DETAILS. COORDINATE FINAL LOCATION WITH OWNER.

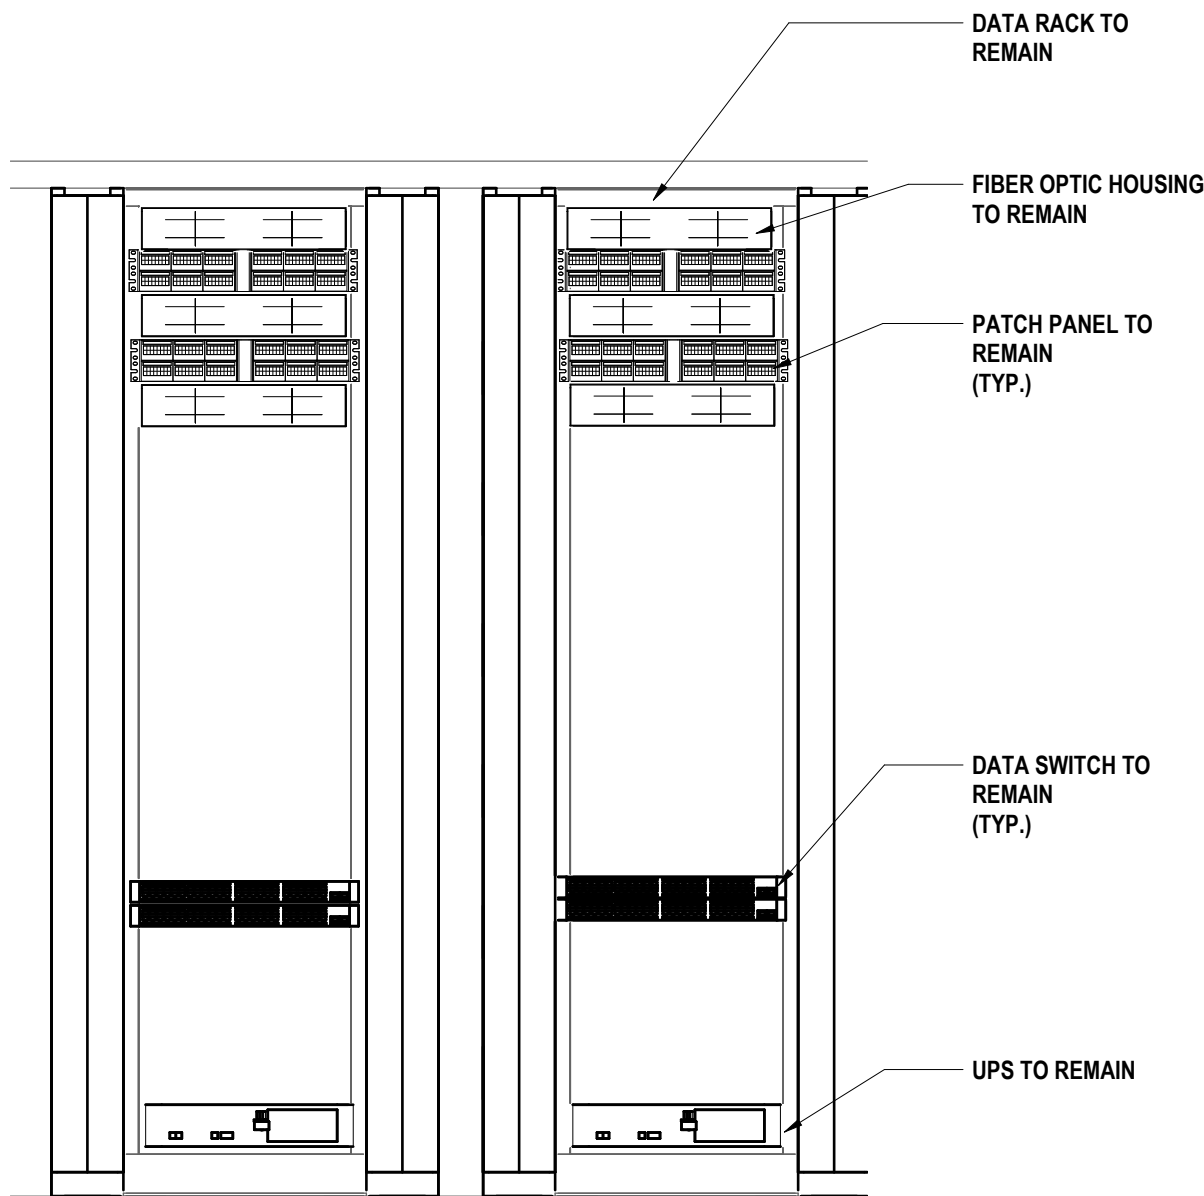


3 MDF-1 ELEVATION VIEW
3/4" = 1'-0"

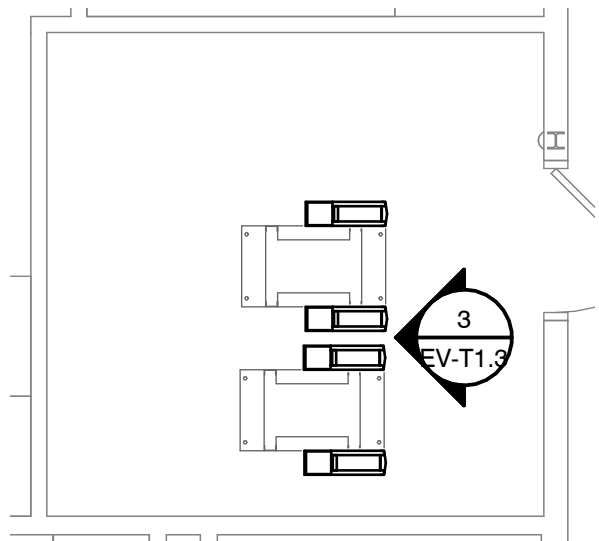

2 MDF RM 113
1/4" = 1'-0"



1 FIRST FLOOR TECHNOLOGY PLAN - AREA B
1/8" = 1'-0"

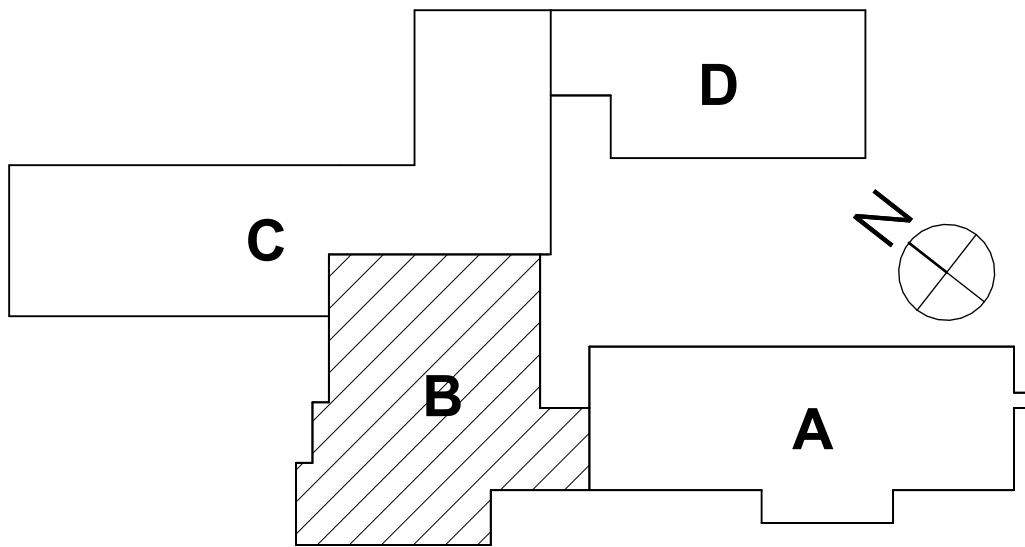

SED NUMBERS: EV-1510-00-01-0-000-007, AD-1510-00-01-1-001-013

FIRST FLOOR TECHNOLOGY PLAN - AREA B

2025 ERWIN VALLEY ELEM & ADMIN BUILDING ALTERATIONS
CORNING-PAINTED POST AREA SCHOOL DISTRICT

16 BEARTOWN ROAD, PAINTED POST, NY 14870

EV-T1.3

PROJECT NO: 2649-160

HUNT ENGINEERS | ARCHITECTS | SURVEYORS

HORSEHEADS, NY 607-263-1000 ROCHESTER, NY 585-537-7668 TOWNHALL, PA 670-265-4666

BINGHAMTON, NY 607-798-8881 ALBANY, NY 607-798-8801

WWW.HUNTEAS.COM

NY CERTIFICATE NO. 001620 PA CERTIFICATE NO. TSC220313464-1

DESCRIPTION OF REVISION:
ISSUED FOR BID

DATE:
1 10/12/2026


DRAWN BY:
TAWO

CHECKED BY:
GJB

DATE:
03/17/2026

PHASE:
CD

IT IS A VIOLATION OF THE LAW FOR ANY PERSON TO MAKE UNAUTHORIZED ALTERATIONS OR ADDITIONS TO PLANS
DRAWN BY LICENSED SURVEYOR; CONTRACT NO. 2025-0001

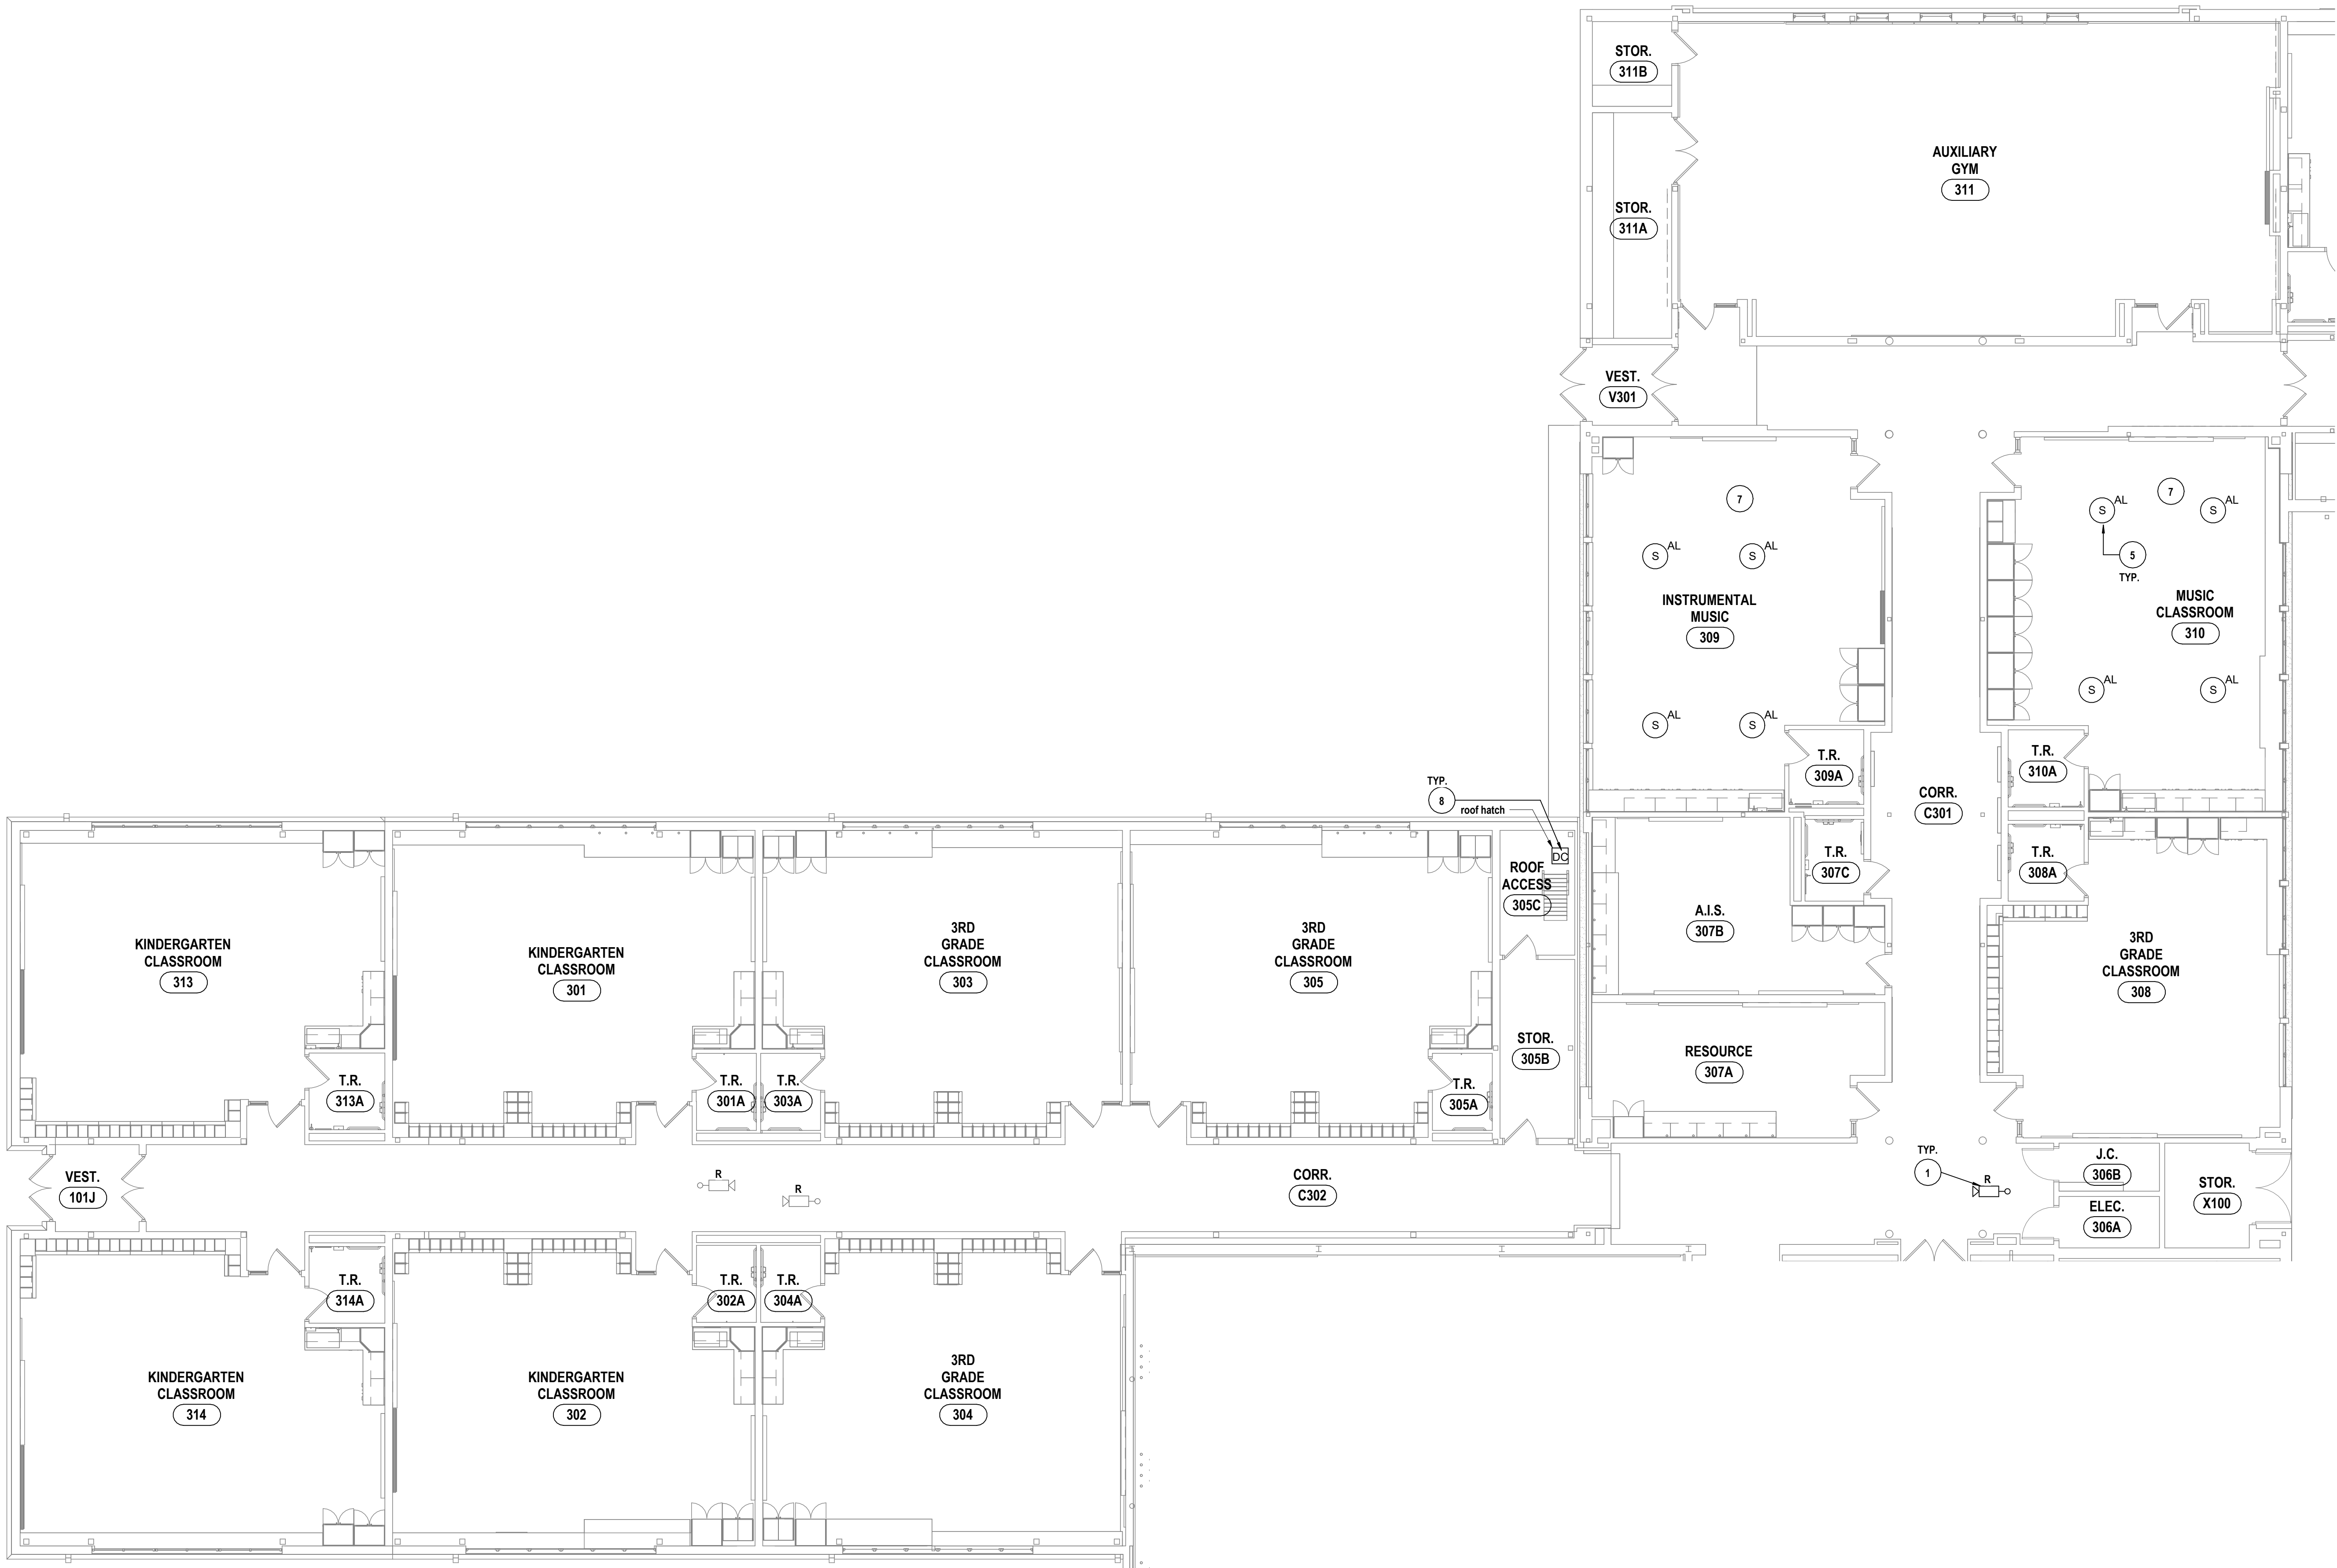


1 FIRST FLOOR TECHNOLOGY PLAN - AREA C
1/8" = 1'-0"

GENERAL NOTES - TECHNOLOGY

- A ALL CABLING INSTALLATION AND TERMINATION TO ADHERE TO CURRENT NEC CODES AND RELATED ANSII/TIA/EIA STANDARDS.
- B DURING INSTALLATION OF CABLING, ANY DAMAGE TO ANY FUNCTIONING CABLING SYSTEM IS THE RESPONSIBILITY OF, AND WILL BE REPAIRED BY THE CONTRACTOR.
- C WHEN INSTALLING CABLING FOR CEILING MOUNTED DEVICES, ADJUST LOCATION TO AVOID OTHER CEILING MOUNTED DEVICES SUCH AS EXIT SIGNS, ECT.
- D ALL DATA CABLING SHALL BE PLENUM RATED PER SPECIFICATIONS.
- E OWNER TO APPROVE FINAL LOCATION AND VIEW OF ALL CAMERAS.
- F ALL ELECTRONIC AND NETWORKING SERVICES NEED TO BE COORDINATED WITH OWNER PRIOR TO REMOVAL AND DISCONNECTION.
- G ALL CEILING MOUNTED DEVICES TO BE SUPPORTED BY STRUCTURE ABOVE. DO NOT USE CEILING GRID AS SOLE SUPPORT MECHANISM.
- H PROTECT NETWORK EQUIPMENT DURING INSTALLATION OF OTHER TRADES' WORK IN DISTRIBUTION FRAME ROOMS.

TECHNOLOGY CONSTRUCTION NOTES

- 1 SURVEILLANCE CAMERA. REQUIRES CABLING AND INSTALLATION PER DETAILS & SPECIFICATIONS.
- 2 REQUEST TO EXIT. REQUIRES CABLING AND INSTALLATION PER DETAILS & SPECIFICATIONS.
- 3 CARD READER. REQUIRES CABLING AND INSTALLATION PER DETAILS & SPECIFICATIONS.
- 4 DOOR CONTACT. REQUIRES CABLING AND INSTALLATION PER DETAILS & SPECIFICATIONS.
- 5 ASSISTED LISTENING SPEAKER. REQUIRES CABLING AND INSTALLATION PER DETAILS & SPECIFICATIONS.
- 6 DOOR STRIKE. REQUIRES CABLING AND INSTALLATION PER DETAILS & SPECIFICATIONS.
- 7 ASSISTED LISTENING CONTROLLER LOCATION. REQUIRES CABLING & INSTALLATION PER DETAILS & SPECIFICATIONS.
- 8 GROUNDING IMPROVEMENTS. IDENTIFY AND LABEL GROUNDING CONDUCTORS.
- 9 REPLACE ALL EXISTING PATCH CABLES WITH 28 AWG PATCH CABLES PER SPECIFICATIONS. TURN PATCH CABLES OVER TO OWNER FOR INSTALLATION.
- 10 CABLE SUPPORT BRACKETS TO BE INSTALLED AT EACH EXISTING AND NEW PATCH PANEL PER SPECIFICATIONS.
- 11 ENVIRONMENTAL MONITOR DEVICE. REQUIRES CABLING PER SPECIFICATIONS & DETAILS.
- 12 FLOOR MARKING TAPE TO BE INSTALLED OUTLING A 3 FOOT CLEARANCE FROM ALL SIDES OF THE DATA RACK.
- 13 INTERCOM. REQUIRES INSTALLATION PER SPECIFICATIONS & DETAILS. REUSE EXISTING SIGNAL CABLING.
- 14 WALL TELEPHONE OUTLET. REQUIRES CABLING PER SPECIFICATIONS & DETAILS. COORDINATE FINAL LOCATION WITH OWNER.

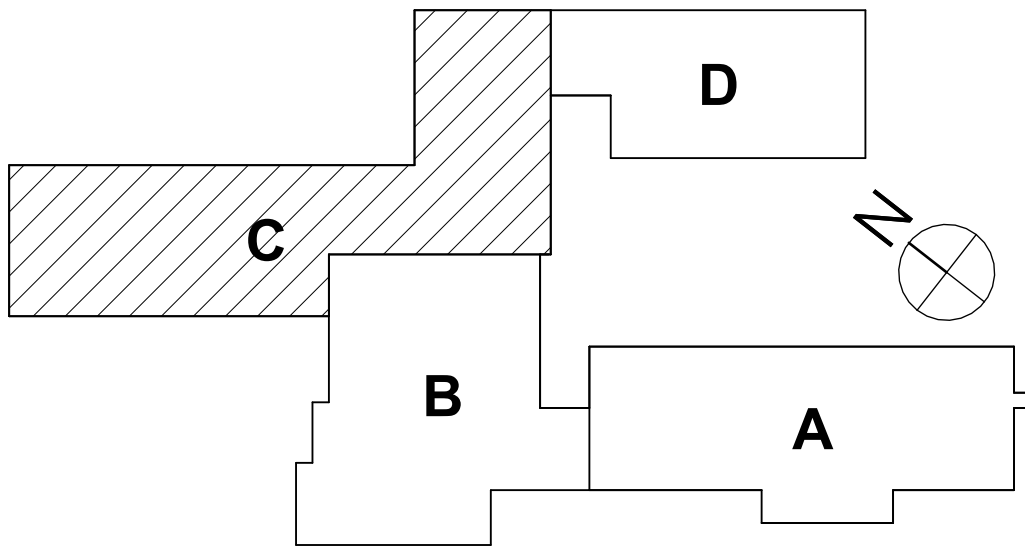

SEE NUMBERS EV-10-00-01-000-007, AD-57-00-00-01-001-013

FIRST FLOOR TECHNOLOGY PLAN - AREA C
2025 ERWIN VALLEY ELEM & ADMIN BUILDING ALTERATIONS
CORNING-PAINTED POST AREA SCHOOL DISTRICT
16 BEARTOWN ROAD, PAINTED POST NY 14870

EV-T1.4

PROJECT NO: 2649-160

HUNT ENGINEERS | ARCHITECTS | SURVEYORS
HORSEHEADS, NY 607-263-1000 ROCHESTER, NY 565-537-7668 TOWNHALL, PA 670-265-4668
BINGHAMTON, NY 607-738-8881 ALBANY, NY 607-738-8801
WWW.HUNTEAS.COM
NY CERTIFICATE NO. 001620 PA CERTIFICATE NO. TSC220013464-1

DATE: 1 10/12/2026

DESCRIPTION OF REVISION:
ISSUED FOR BID


DRAWN BY: TAWO

CHECKED BY: GJB


DATE: 03/17/2026

PHASE: CD


IT IS A VIOLATION OF THE LAW FOR ANY PERSON TO MAKE UNAUTHORIZED ALTERATIONS OR ADDITIONS TO PLANS
DRAWING IS LOCKED. UNLOCKING OR CHANGING OF ANY PART OF THE DRAWING IS PROHIBITED.

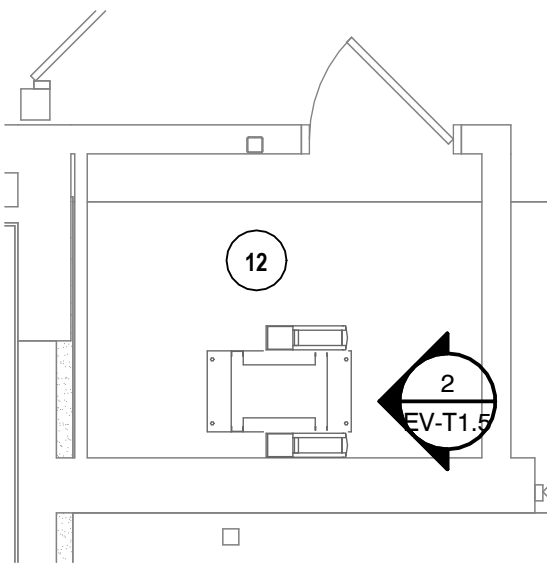

3 IDF-3 RM ST-1
1/4" = 1'-0"

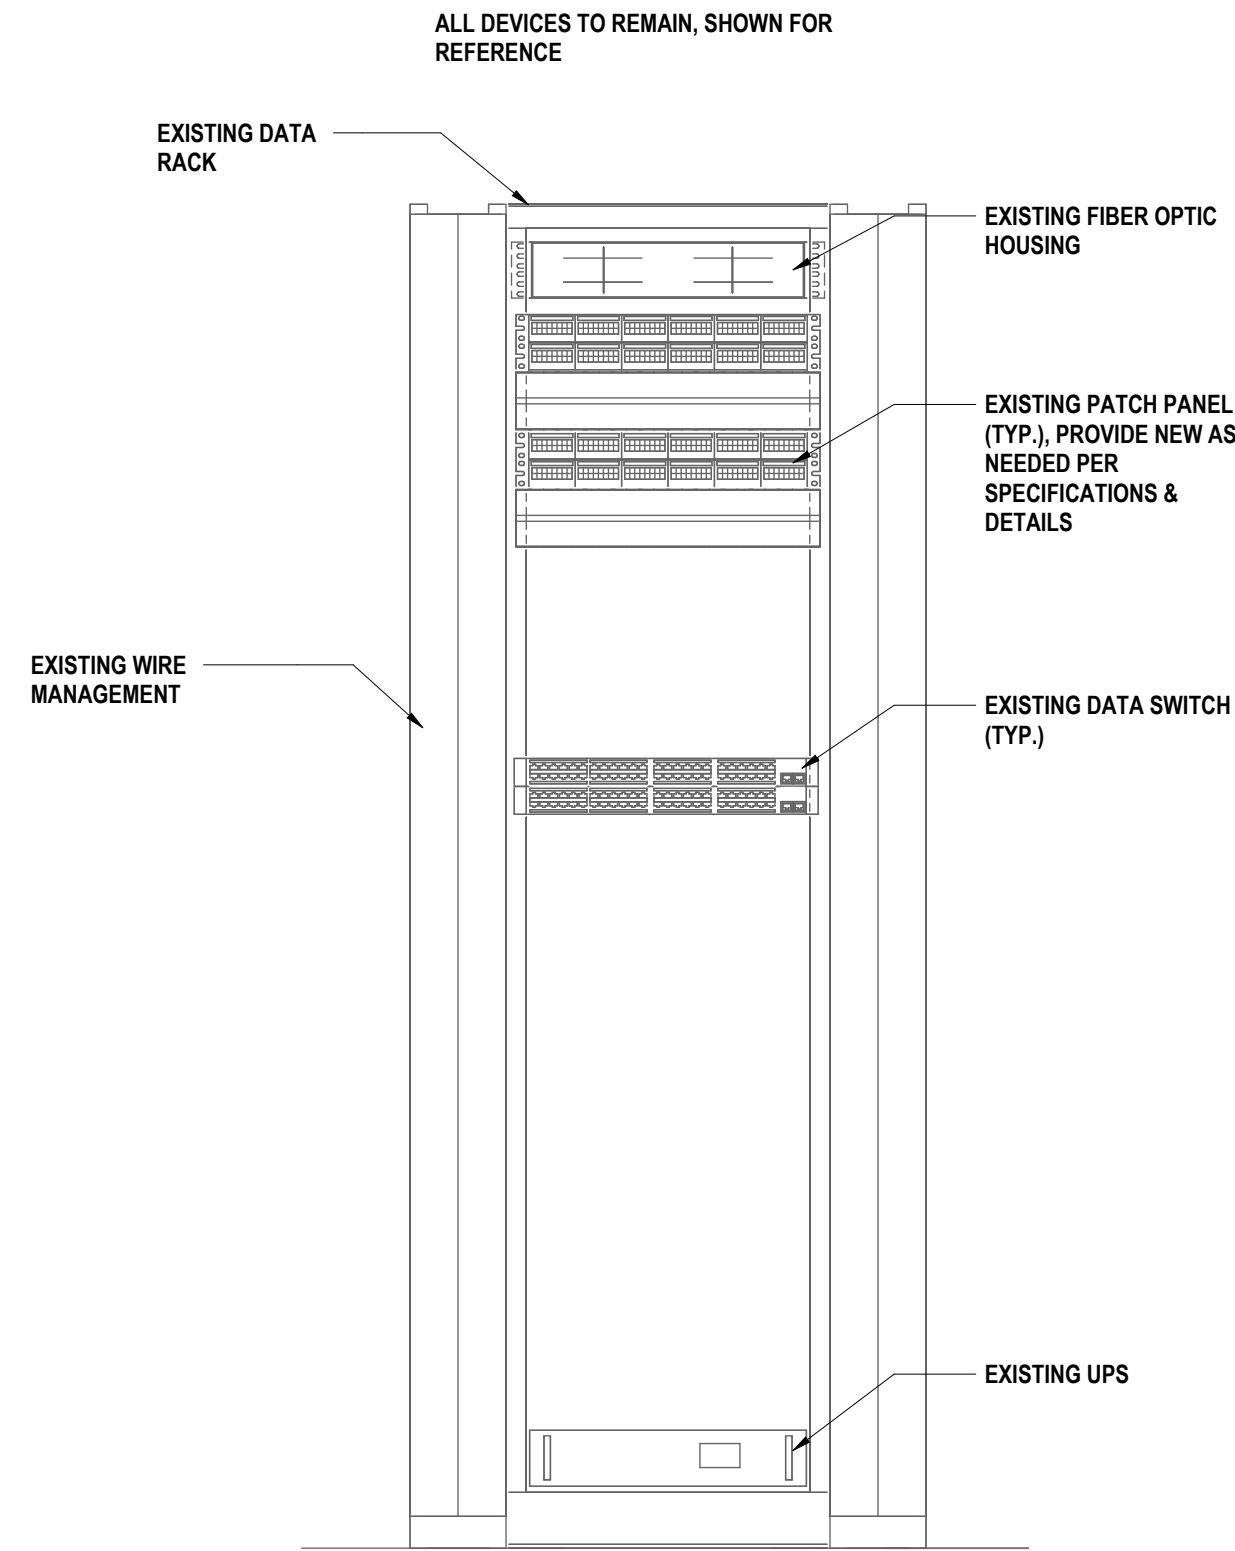

2 IDF-3 ELEVATION VIEW
1" = 1'-0"

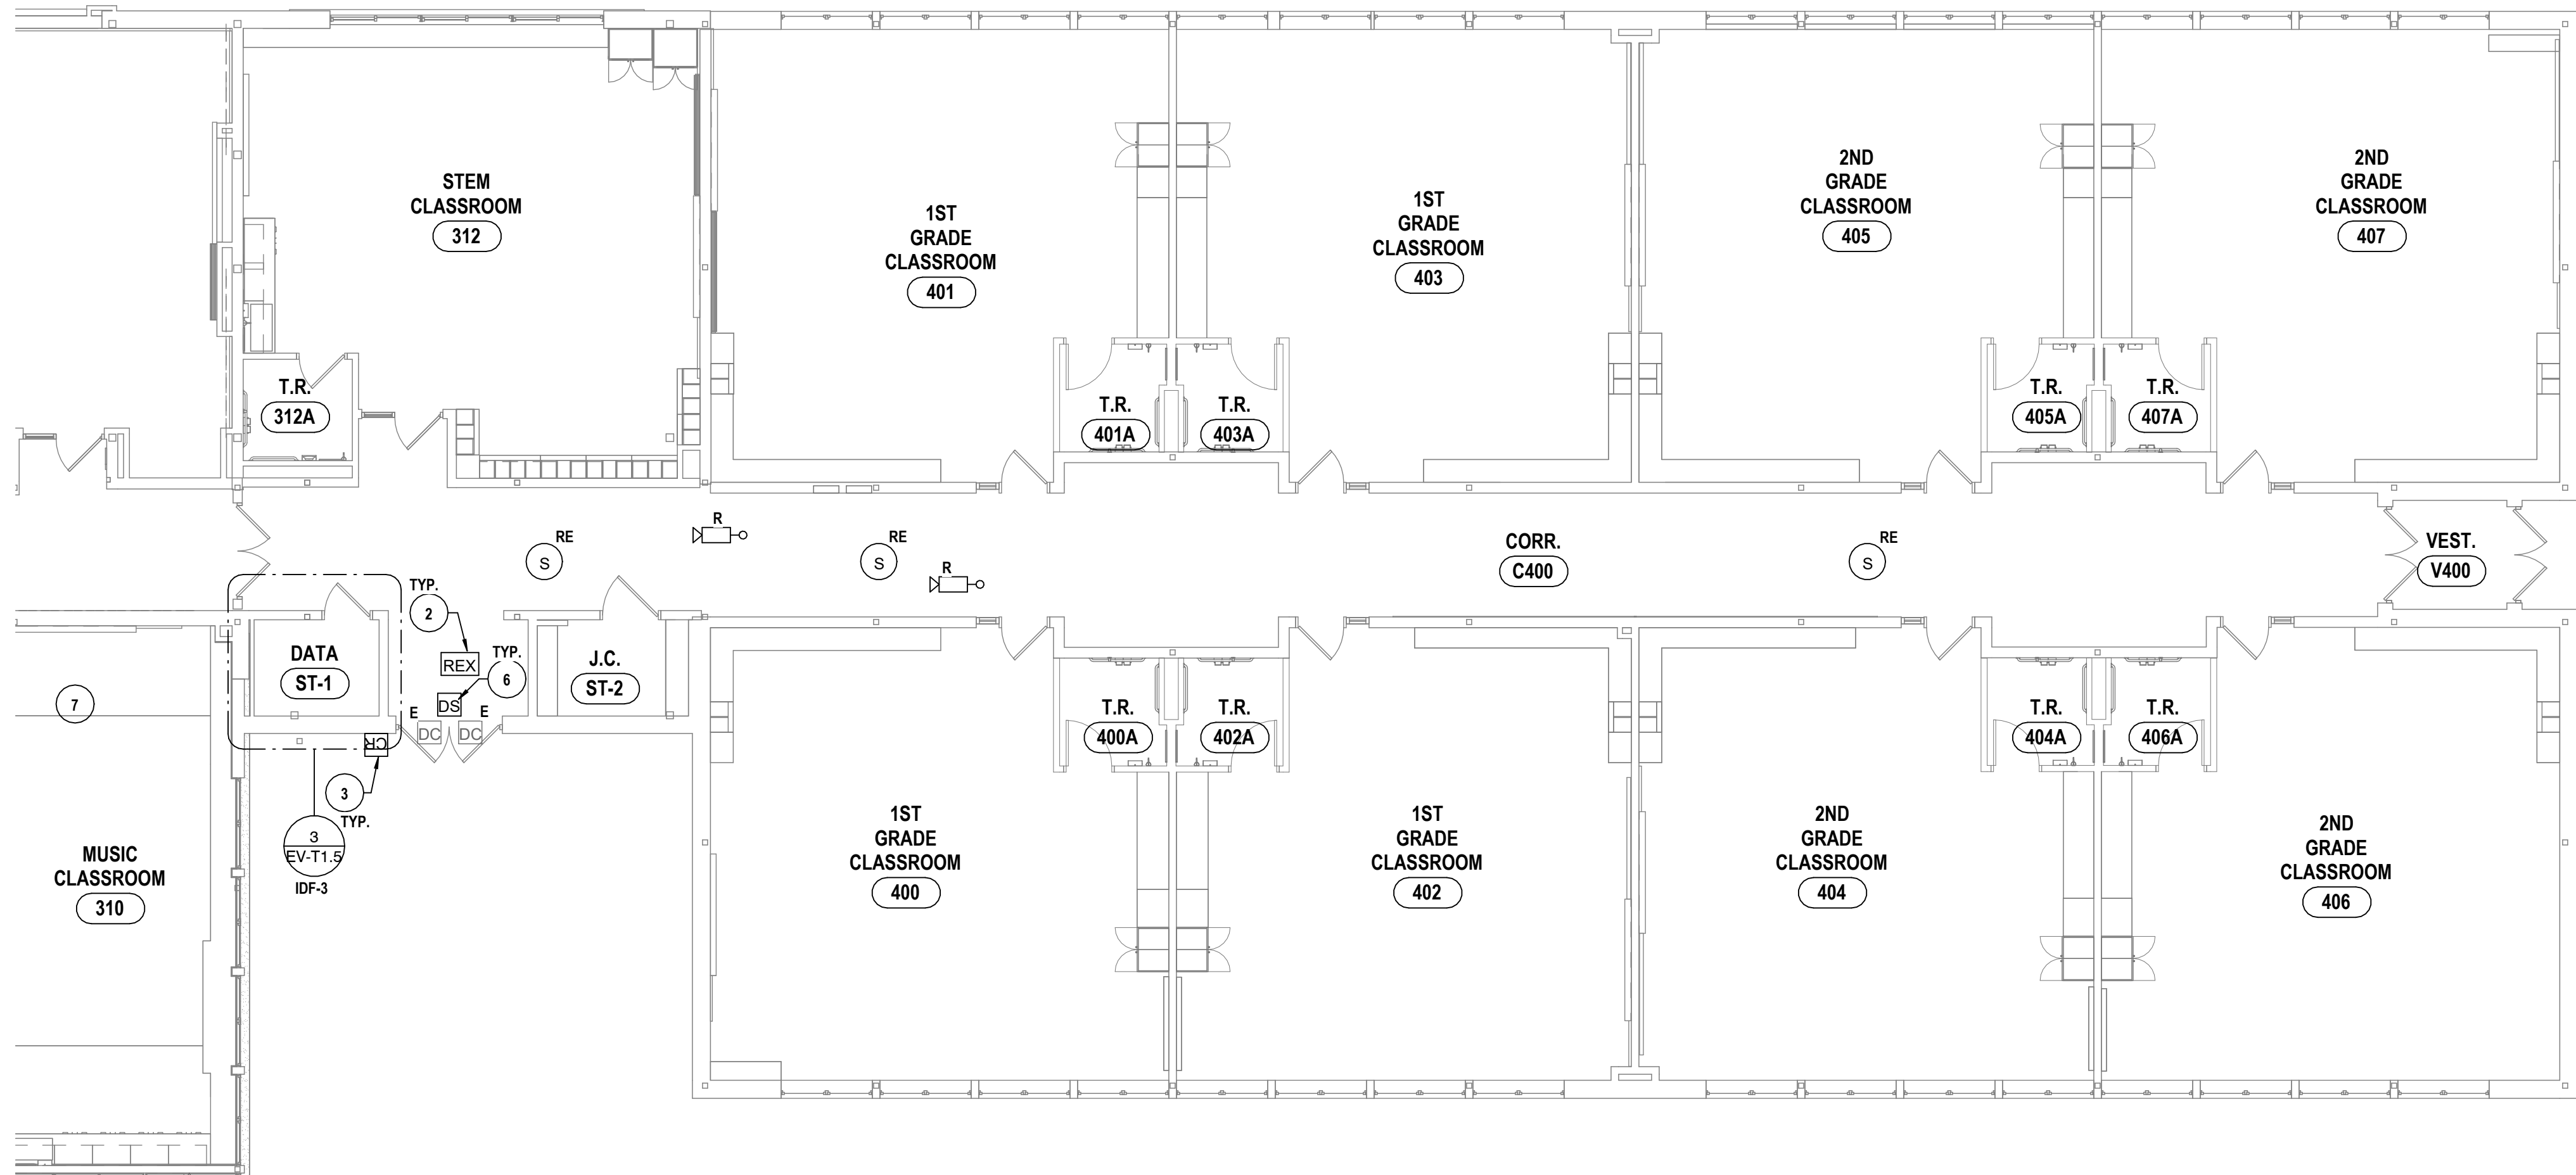

1 FIRST FLOOR TECHNOLOGY PLAN - AREA D
1/8" = 1'-0"

GENERAL NOTES - TECHNOLOGY

- A ALL CABLING INSTALLATION AND TERMINATION TO ADHERE TO CURRENT NEC CODES AND RELATED ANSITIA/EIA STANDARDS.
B DURING INSTALLATION OF CABLING, ANY DAMAGE TO ANY FUNCTIONING CABLING SYSTEM IS THE RESPONSIBILITY OF, AND WILL BE REPAIRED BY THE CONTRACTOR.
C WHEN INSTALLING CABLING FOR CEILING MOUNTED DEVICES, ADJUST LOCATION TO AVOID OTHER CEILING MOUNTED DEVICES SUCH AS EXIT SIGNS, ECT.
D ALL DATA CABLING SHALL BE PLENUM RATED PER SPECIFICATIONS.
E OWNER TO APPROVE FINAL LOCATION AND VIEW OF ALL CAMERAS.
F ALL ELECTRONIC AND NETWORKING SERVICES NEED TO BE COORDINATED WITH OWNER PRIOR TO REMOVAL AND DISCONNECTION.
G ALL CEILING MOUNTED DEVICES TO BE SUPPORTED BY STRUCTURE ABOVE. DO NOT USE CEILING GRID AS SOLE SUPPORT MECHANISM.
H PROTECT NETWORK EQUIPMENT DURING INSTALLATION OF OTHER TRADES' WORK IN DISTRIBUTION FRAME ROOMS.

TECHNOLOGY CONSTRUCTION NOTES

- 1 SURVEILLANCE CAMERA. REQUIRES CABLING AND INSTALLATION PER DETAILS & SPECIFICATIONS.
2 REQUEST TO EXIT. REQUIRES CABLING AND INSTALLATION PER DETAILS & SPECIFICATIONS.
3 CARD READER. REQUIRES CABLING AND INSTALLATION PER DETAILS & SPECIFICATIONS.
4 DOOR CONTACT. REQUIRES CABLING AND INSTALLATION PER DETAILS & SPECIFICATIONS.
5 ASSISTED LISTENING SPEAKER. REQUIRES CABLING AND INSTALLATION PER DETAILS & SPECIFICATIONS.
6 DOOR STRIKE. REQUIRES CABLING AND INSTALLATION PER DETAILS & SPECIFICATIONS.
7 ASSISTED LISTENING CONTROLLER LOCATION. REQUIRES CABLING & INSTALLATION PER DETAILS & SPECIFICATIONS.
8 GROUNDING IMPROVEMENTS. IDENTIFY AND LABEL GROUNDING CONDUCTORS.
9 REPLACE ALL EXISTING PATCH CABLES WITH 28 AWG PATCH CABLES PER SPECIFICATIONS. TURN PATCH CABLES OVER TO OWNER FOR INSTALLATION.
10 CABLE SUPPORT BRACKETS TO BE INSTALLED AT EACH EXISTING AND NEW PATCH PANEL PER SPECIFICATIONS.
11 ENVIRONMENTAL MONITOR DEVICE. REQUIRES CABLING PER SPECIFICATIONS & DETAILS.
12 FLOOR MARKING TAPE TO BE INSTALLED OUTLING A 3 FOOT CLEARANCE FROM ALL SIDES OF THE DATA RACK.
13 INTERCOM. REQUIRES INSTALLATION PER SPECIFICATIONS & DETAILS. REUSE EXISTING SIGNAL CABLING.
14 WALL TELEPHONE OUTLET. REQUIRES CABLING PER SPECIFICATIONS & DETAILS. COORDINATE FINAL LOCATION WITH OWNER.

DRAWN BY:		TAWC	Copyright, 2026
CHECKED BY:		GJB	
DATE:		03/17/2026	
PHASE:		CD	
#	DATE:	DESCRIPTION OF REVISION:	"IT IS A VIOLATION OF THE LAW FOR ANY PERSON TO MAKE UNAUTHORIZED ALTERATIONS OR ADDITIONS TO PLANS BEARING A LICENSED ENGINEER'S, ARCHITECT'S OR SURVEYOR'S SEAL."
1	10/12/2026	ISSUED FOR BID	


HUNT ENGINEERS | ARCHITECTS | SURVEYORS

HORSEHEADS, NY 607-263-1000 ROCHESTER, NY 585-537-7668 TOWNANDA, PA 570-265-4668
BINGHAMTON, NY 607-798-8881 ALBANY, NY 607-798-8801
WWW.HUNTEAS.COM
NY CERTIFICATE NO. 001620 PA CERTIFICATE NO. TSC22013464-1


FIRST FLOOR TECHNOLOGY PLAN - AREA D
2025 ERWIN VALLEY ELEM & ADMIN BUILDING ALTERATIONS
CORNING-PAINTED POST AREA SCHOOL DISTRICT
16 BEARTOWN ROAD, PAINTED POST, NY 14870

EV-T1.5

PROJECT NO: 2649-160

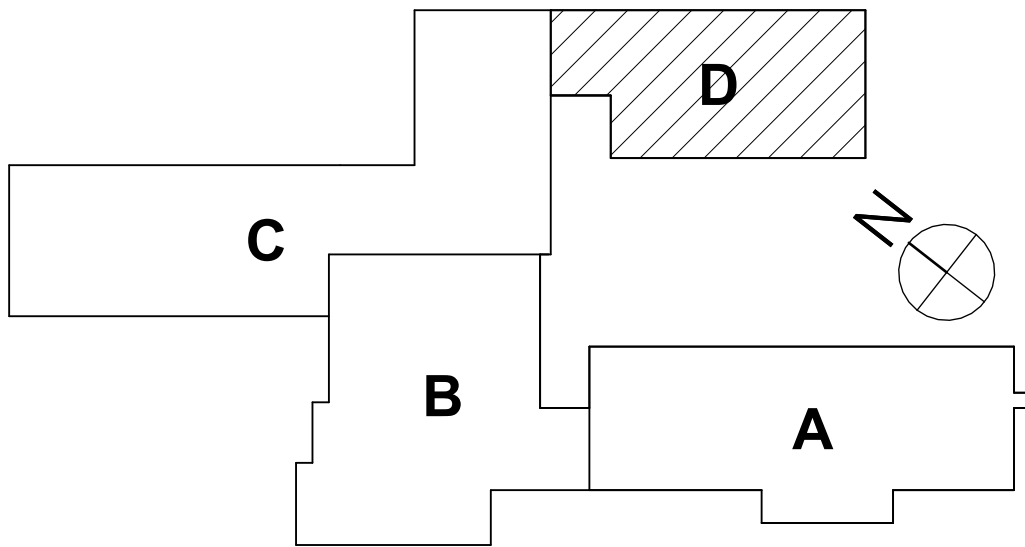

SEE NUMBERS EV-01-00-001-000-007, AD-01-00-001-001-013

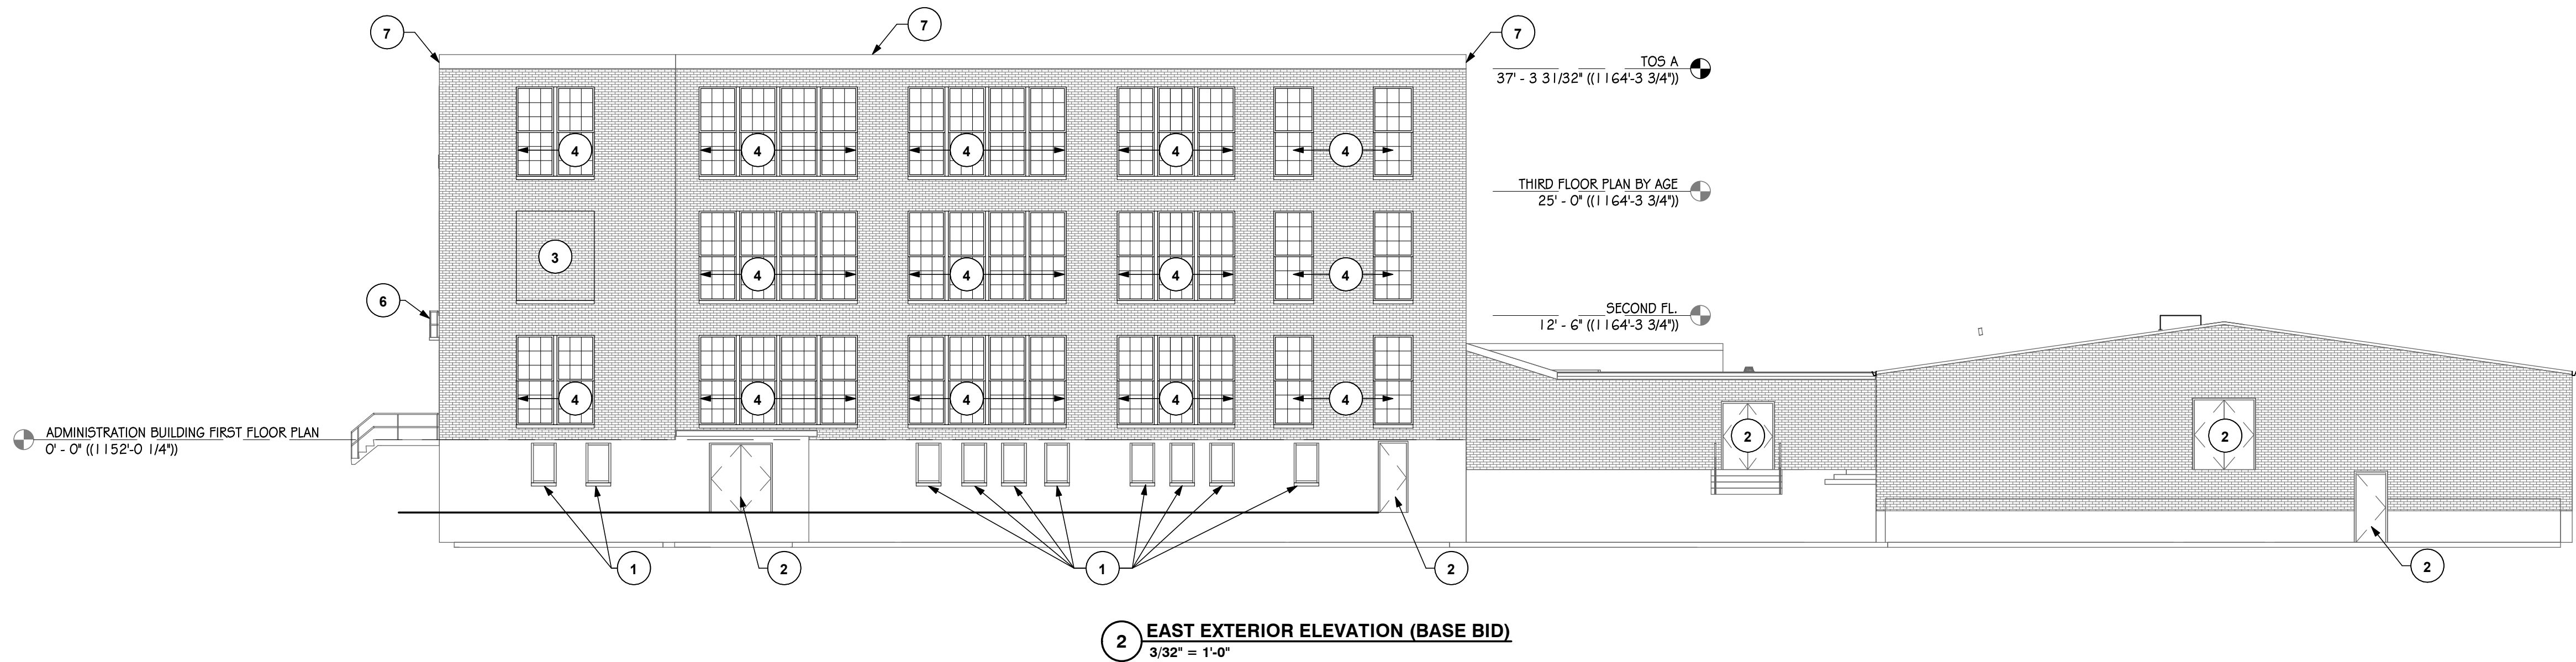


GENERAL NOTES - EXTERIOR PAINTING:

- A EXISTING WINDOW MUNTINS ARE ASSUMED TO BE ACM AND ARE NOT PART OF THE WORK SCOPE. PAINT WINDOW FRAMES ONLY.
- B REMOVE EXISTING WINDOW AIR CONDITIONERS AND STORM WINDOWS (WHERE OCCURS, V.I.F.) AND REINSTALL AS REQUIRED TO PERFORM NEW WORK.
- C EXISTING PAINT ASSUMED TO BE LEAD CONTAINING - SEE SPECIFICATION SECTION 02 83 10 - LEAD SAFE WORK PRACTICES.
- D DO NOT PAINT VINYL WINDOWS. PAINT WOOD PANELS AROUND WINDOW (WHERE OCCURS).

EXTERIOR ELEVATION NOTES:

- 1 EXISTING WINDOW NOT PART OF WORK SCOPE.
- 2 EXISTING DOOR NOT PART OF WORK SCOPE.
- 3 PREVIOUSLY REMOVED WINDOW NOW INFILLED WITH BRICK NOT PART OF WORK SCOPE.
- 4 PREP AND PAINT EXISTING WOOD WINDOW FRAMES.
- 5 PREP AND PAINT EXISTING DECORATIVE DOOR AND FRAME. WINDOW MUNTINS NOT PART OF ROOF SCOPE.
- 6 PREP AND PAINT METAL ROOF RAILS (BLACK).
- 7 PREP AND PAINT EXISTING WOOD ROOF CORNICE AND FASCIA - CORNER TO CORNER.
- 8 PREP AND PAINT EXISTING WOOD ROOF CORNICE AND SOFFIT - CORNER TO CORNER.
- 9 PREP AND PAINT EXISTING DECORATIVE DOOR, WOOD PANELS AND FRAME.
- 10 PREP AND PAINT EXISTING WOOD CORNICE - CORNER TO CORNER.
- 11 NO CORNICE PAINTING IN THIS AREA.
- 12 PREP AND PAINT FACADE AND DECORATIVE WOOD TRIM.
- 13 EXISTING FACE MOUNTED LETTERING TO REMAIN. PAINT AROUND IN PLACE.
- 14 PREP & PAINT EXISTING WOOD COLUMN.
- 15 PREP & PAINT EXISTING FACADE CEILING.
- 16 EXISTING DISPLAY CASE NOT PART OF WORK SCOPE.
- 17 PREP AND PAINT EXISTING DECORATIVE WINDOW AND FRAME.
- 18 STAIR TOWER - SECOND FLOOR DOOR NOT PART OF WORK SCOPE.
- 19 PREP AND PAINT WOOD PANELS IN THIS WINDOW CONFIGURATION.
- 20 PREP AND PAINT EXISTING HOLLOW METAL DOOR AND FRAME.
- 21 PREP AND PAINT WOOD COLUMN CAPS AND TRIM (TYPICAL OF 6 COLUMNS) - REPAIR OR REPLACE DETERIORATED CAPS AND TRIM. SEE ASSORTED COLUMN CAP PHOTOS.

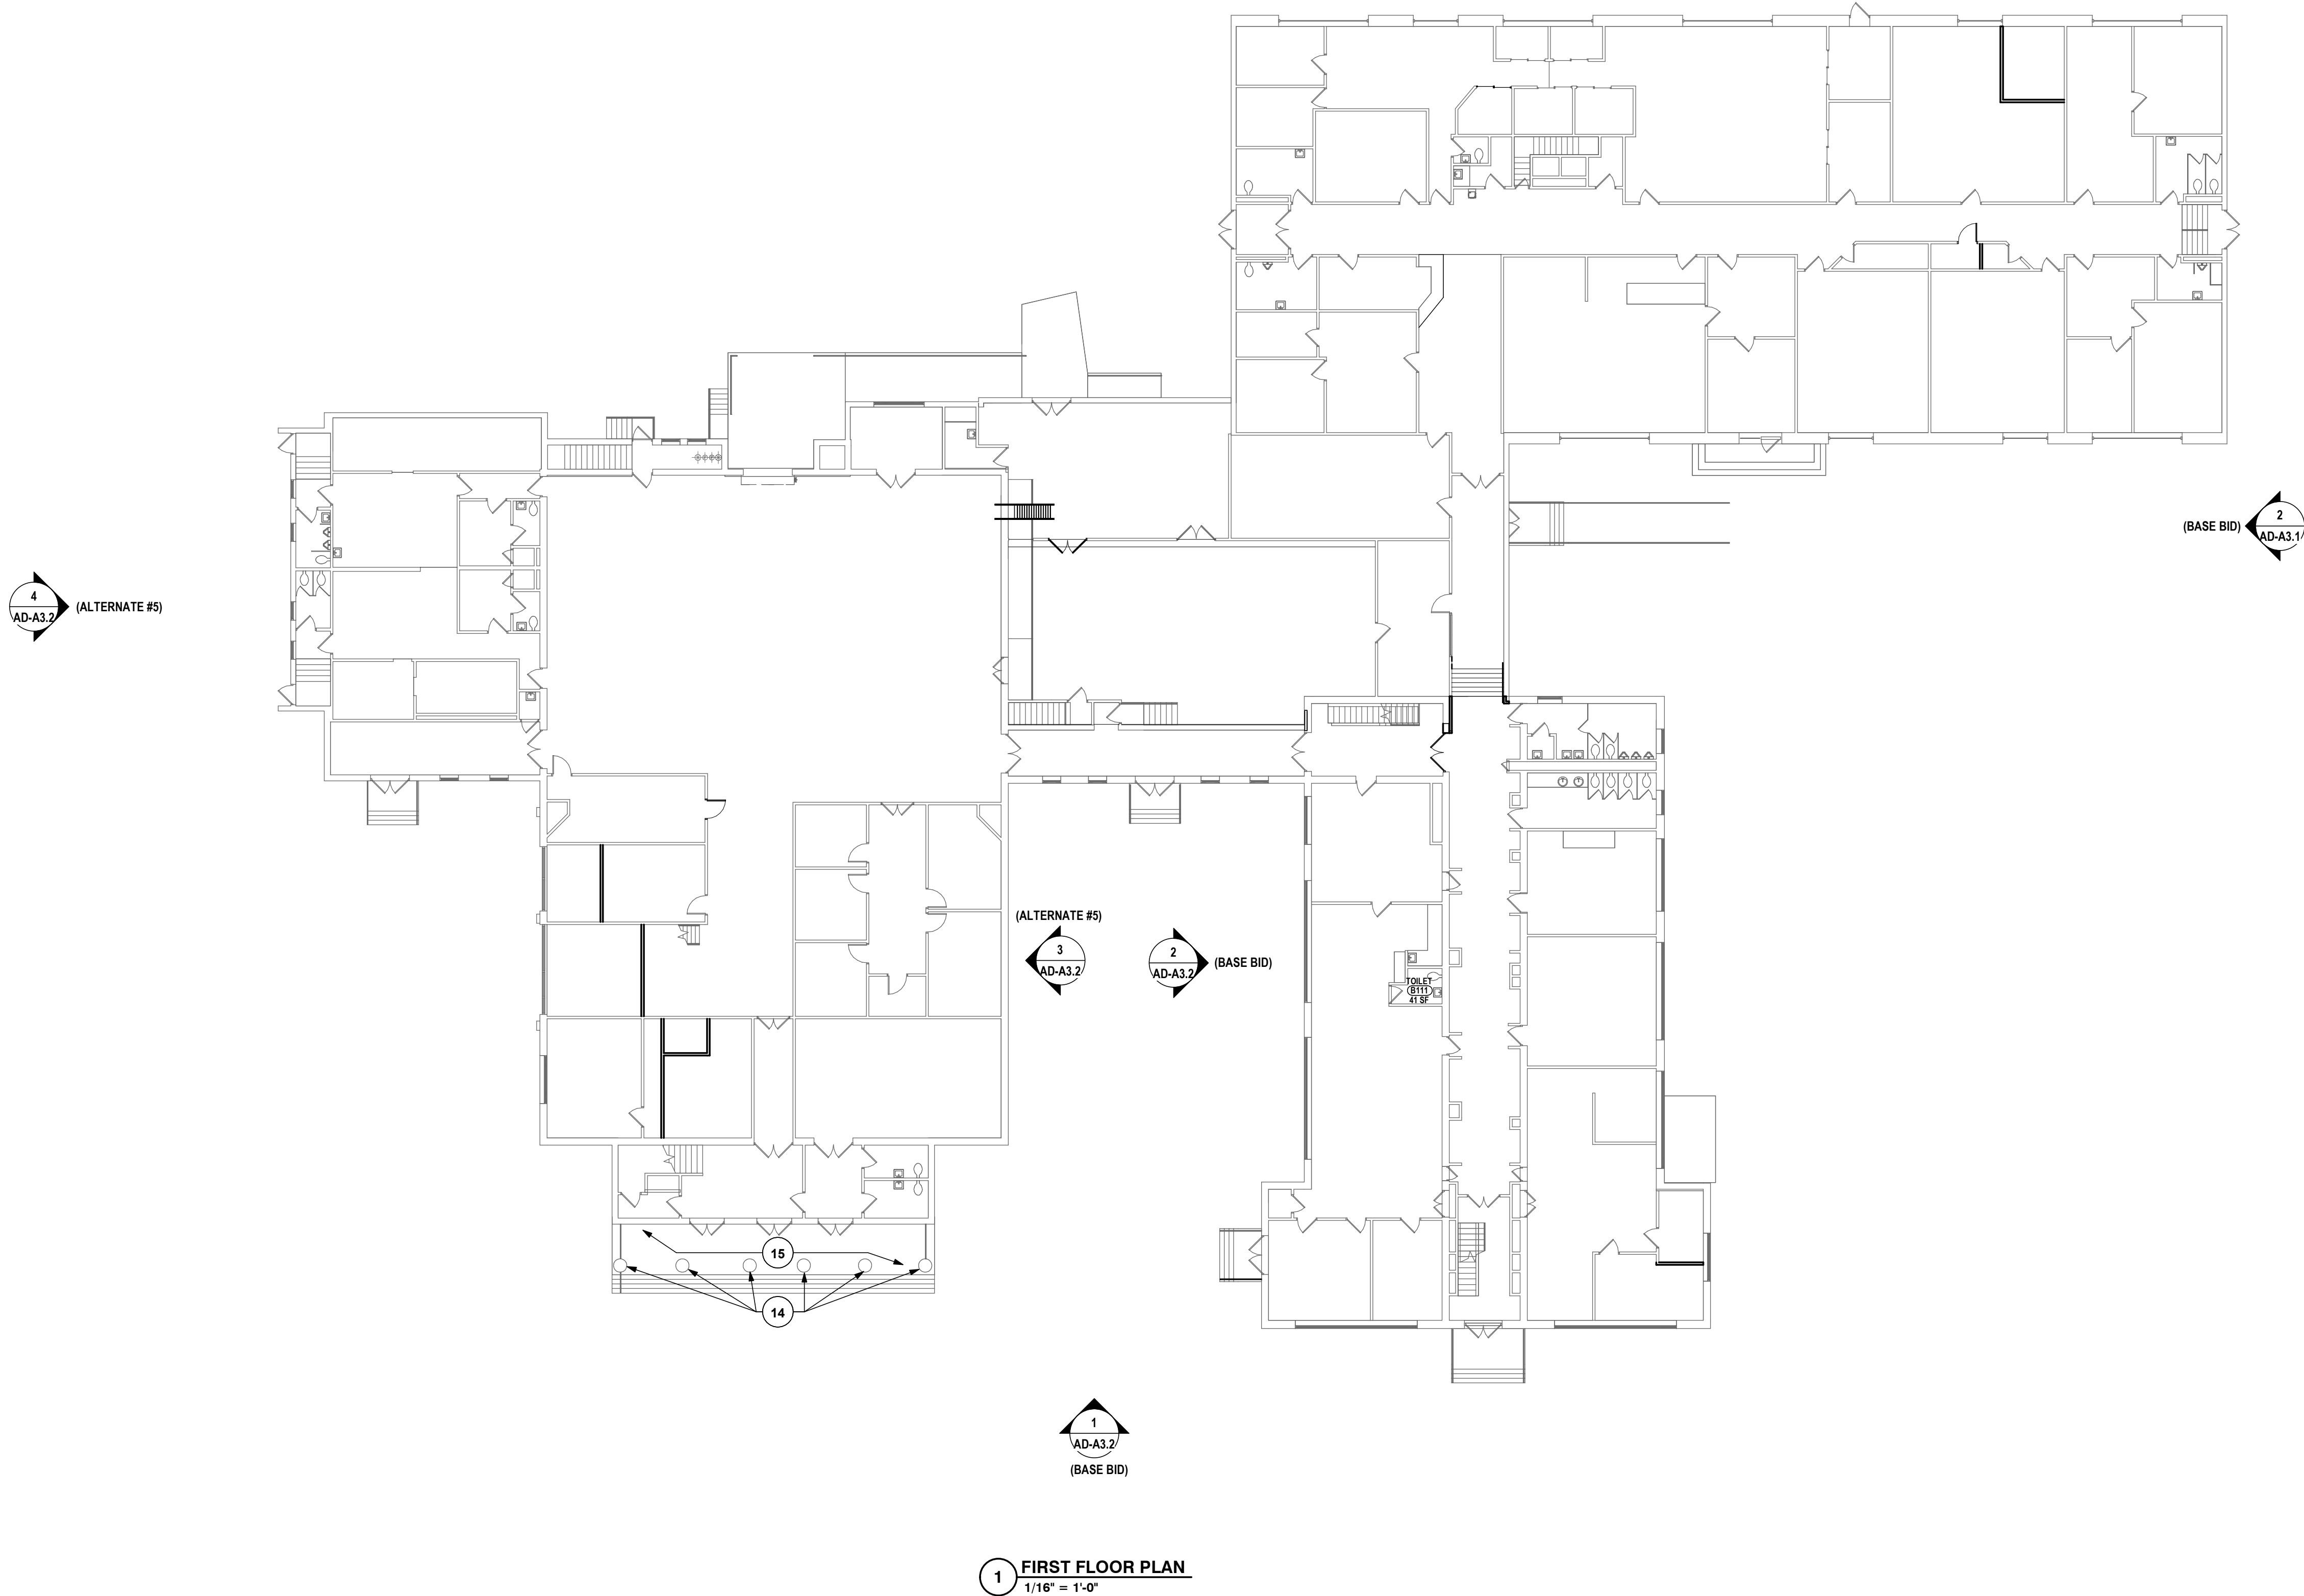

S&P NO.: ERWIN VALLEY - 57-10-00-01-009-027; ADMIN. BUILDING - 57-10-00-01-009-013

EXTERIOR PAINTING FLOOR PLAN AND ELEVATION

2025 ERWIN VALLEY ELEM & ADMIN BUILDING ALTERATIONS

CORNING - PAINTED POST AREA SCHOOL DISTRICT

16 BEARTOWN ROAD PAINTED POST, NY 14870

AD-A3.1

PROJECT NO: 2649-160

HUNT ENGINEERS | ARCHITECTS | SURVEYORS

HORSEHEADS, NY 607-265-1000 ROCHESTER, NY 585-537-7549 TOWANDA, PA 570-265-4666

BINGHAMTON, NY 607-738-8881 ALBANY, NY 607-758-1805

WWW.HUNT-EAS.COM

NY CERTIFICATE NO. 001620 PA CERTIFICATE NO. TSC22013464-1

DATE: 1 10/12/2026

DESCRIPTION OF REVISION:

ISSUE FOR BID

IT IS A VIOLATION OF THE LAW FOR ANY PERSON TO MAKE UNAUTHORIZED ALTERATIONS OR ADDITIONS TO PLANS DRAWN BY A LICENSED ENGINEER, ARCHITECT OR SURVEYOR.

DRAWN BY: TMR

CHECKED BY: JMR

DATE: 03/17/2026

PHASE: CD

Copyright 2025




ASSORTED COLUMN CAP PHOTOS

GENERAL NOTES - EXTERIOR PAINTING:


- A. EXISTING WINDOW MUNTINS ARE ASSUMED TO BE ACM AND ARE NOT PART OF THE WORK SCOPE. PAINT WINDOW FRAMES ONLY.
- B. REMOVE EXISTING WINDOW AIR CONDITIONERS AND STORM WINDOWS (WHERE OCCURS, V.I.F.) AND REINSTALL AS REQUIRED TO PERFORM NEW WORK.
- C. EXISTING PAINT ASSUMED TO BE LEAD CONTAINING - SEE SPECIFICATION SECTION 02 83 19 - LEAD SAFE WORK PRACTICES.
- D. DO NOT PAINT VINYL WINDOWS. PAINT WOOD PANELS AROUND WINDOW (WHERE OCCURS).

EXTERIOR ELEVATION NOTES:


- 1. EXISTING WINDOW NOT PART OF WORK SCOPE.
- 2. EXISTING DOOR NOT PART OF WORK SCOPE.
- 3. PREVIOUSLY REMOVED WINDOW NOW INFILLED WITH BRICK NOT PART OF WORK SCOPE.
- 4. PREP AND PAINT EXISTING WOOD WINDOW FRAMES.
- 5. PREP AND PAINT EXISTING DECORATIVE DOOR AND FRAME. WINDOW MUNTINS NOT PART OF ROOF SCOPE.
- 6. PREP AND PAINT METAL ROOF RAILS (BLACK).
- 7. PREP AND PAINT EXISTING WOOD ROOF CORNICE AND FASCIA - CORNER TO CORNER.
- 8. PREP AND PAINT EXISTING WOOD ROOF CORNICE AND SOFFIT - CORNER TO CORNER.
- 9. PREP AND PAINT EXISTING DECORATIVE DOOR, WOOD PANELS AND FRAME.
- 10. PREP AND PAINT EXISTING WOOD CORNICE - CORNER TO CORNER.
- 11. NO CORNICE PAINTING IN THIS AREA.
- 12. PREP AND PAINT FACADE AND DECORATIVE WOOD TRIM.
- 13. EXISTING FACE MOUNTED LETTERING TO REMAIN. PAINT AROUND IN PLACE.
- 14. PREP & PAINT EXISTING WOOD COLUMN.
- 15. PREP & PAINT EXISTING FACADE CEILING.
- 16. EXISTING DISPLAY CASE NOT PART OF WORK SCOPE.
- 17. PREP AND PAINT EXISTING DECORATIVE WINDOW AND FRAME.
- 18. STAIR TOWER - SECOND FLOOR DOOR NOT PART OF WORK SCOPE.
- 19. PREP AND PAINT WOOD PANELS IN THIS WINDOW CONFIGURATION.
- 20. PREP AND PAINT EXISTING HOLLOW METAL DOOR AND FRAME.
- 21. PREP AND PAINT WOOD COLUMN CAPS AND TRIM (TYPICAL OF 6 COLUMNS) - REPAIR OR REPLACE DETERIORATED CAPS AND TRIM. SEE ASSORTED COLUMN CAP PHOTOS.

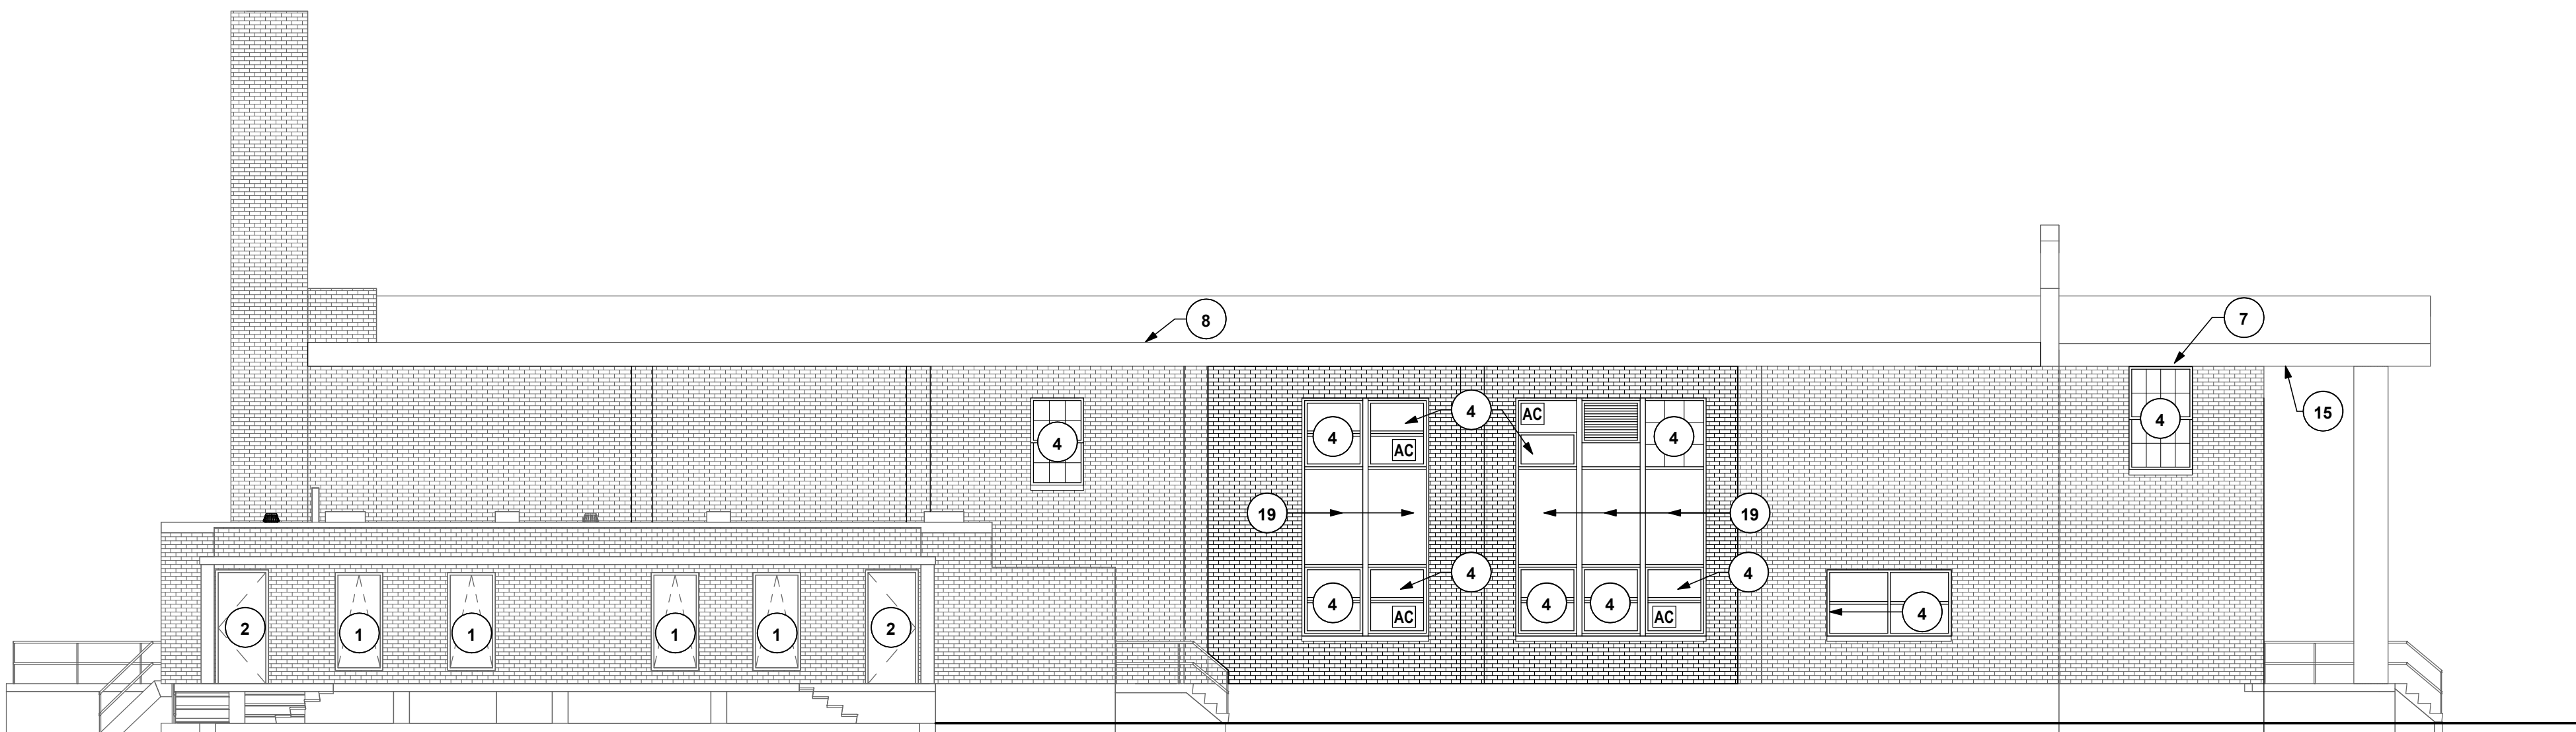


4 WEST ELEVATION (ALTERNATE #5)
1/8" = 1'-0"

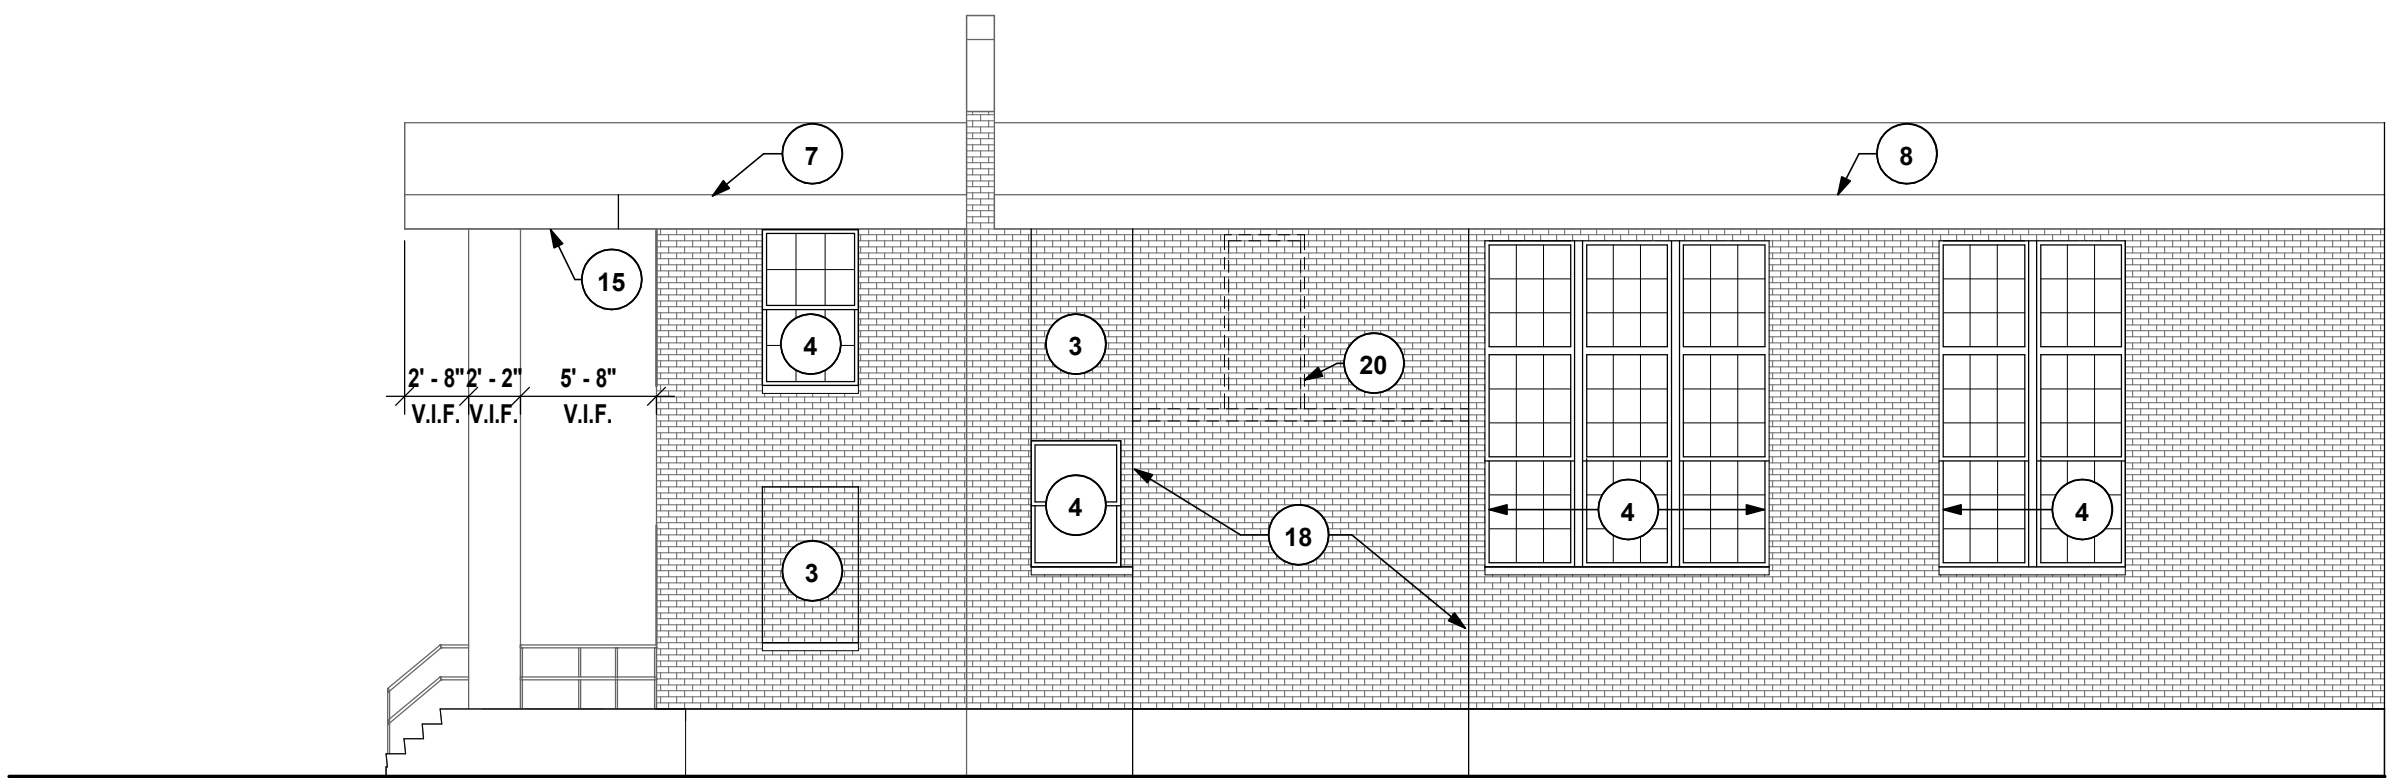



3 COURTYARD WEST ELEVATION (ALTERNATE #5)
1/8" = 1'-0"

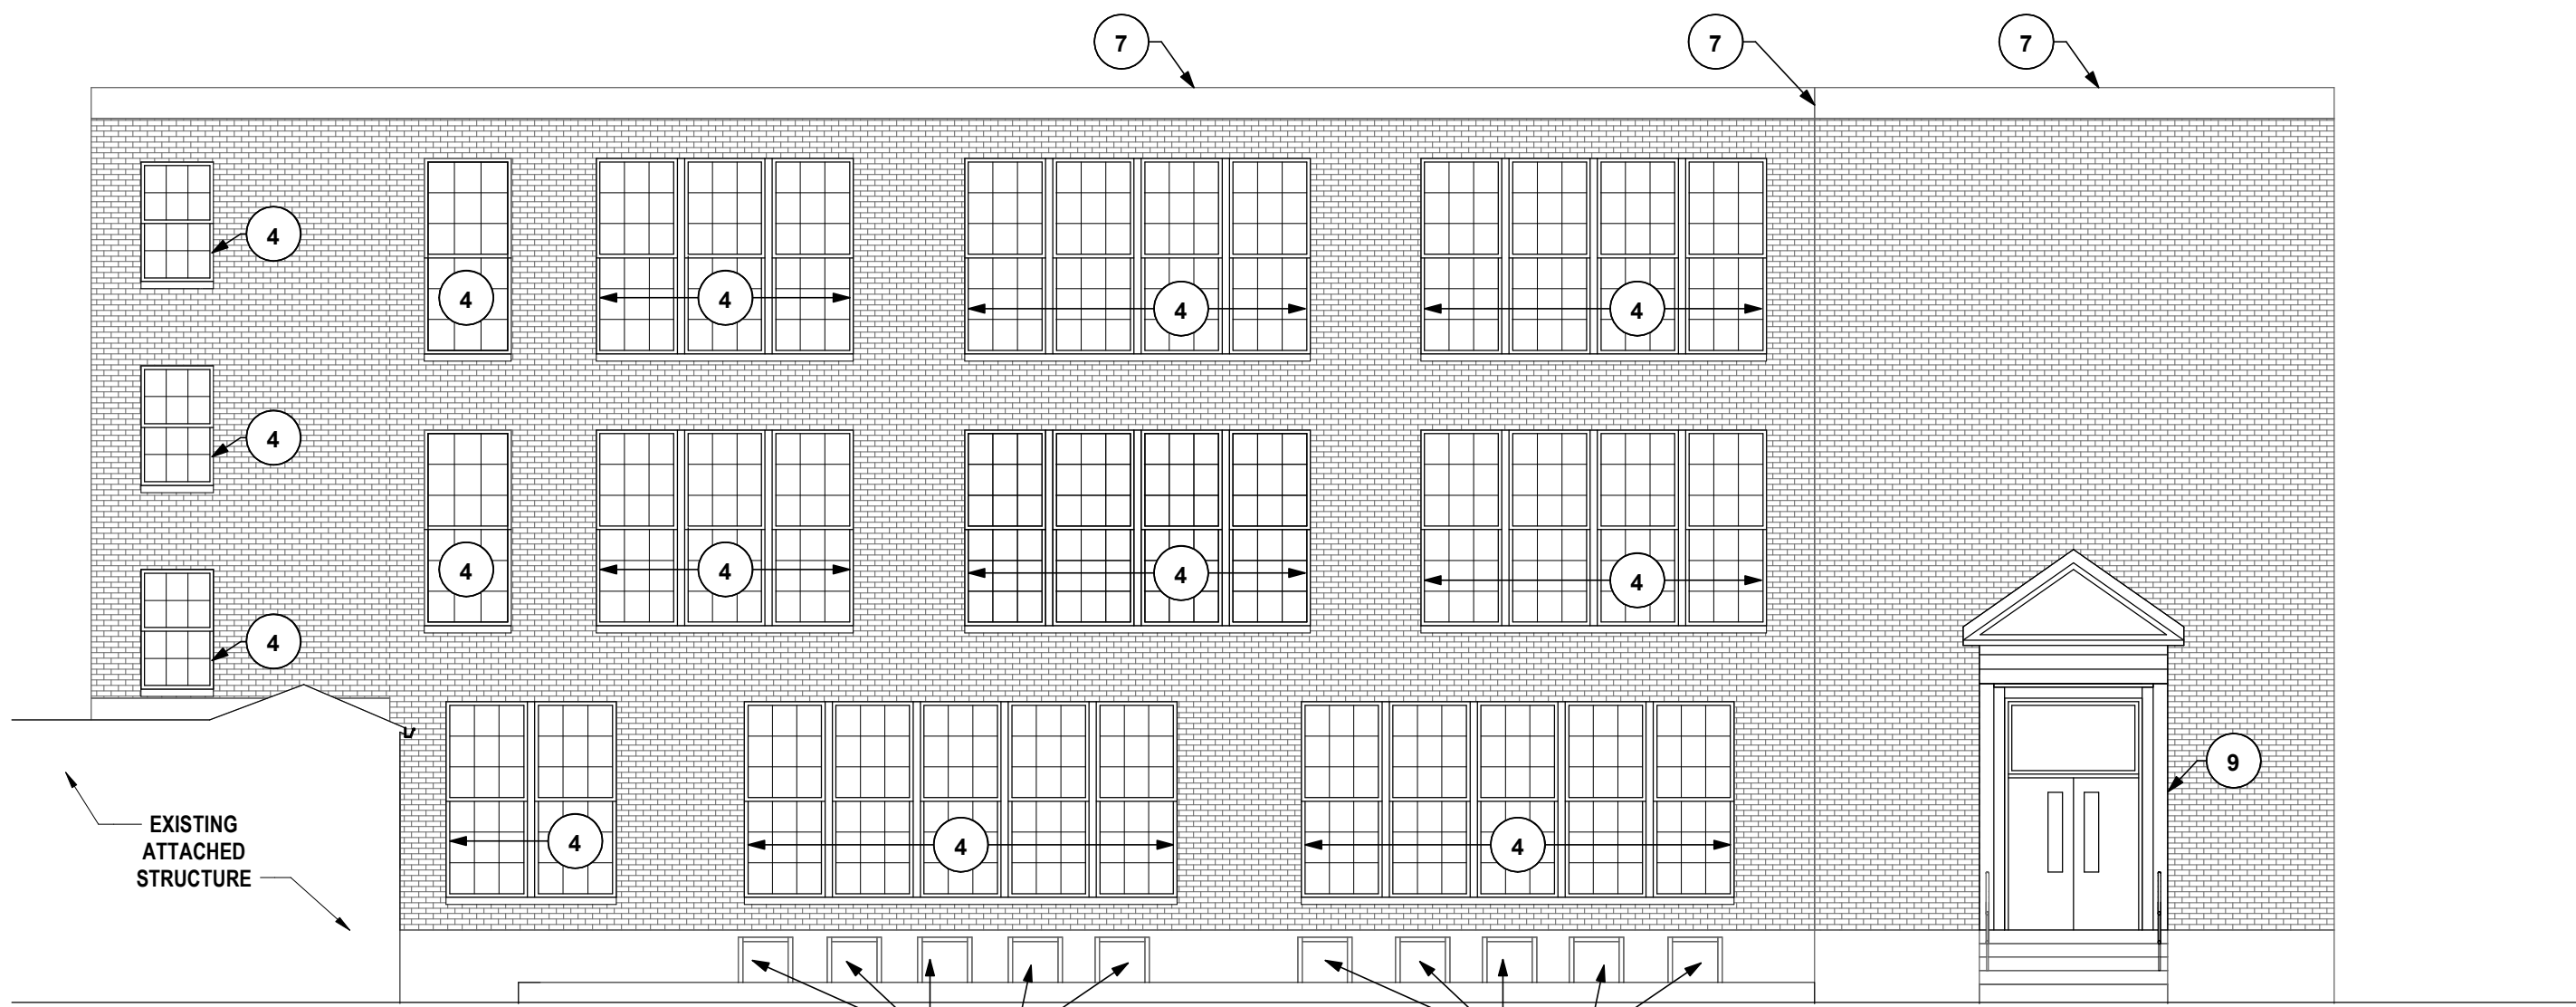

2 COURTYARD EAST ELEVATION (BASE BID)
1/8" = 1'-0"

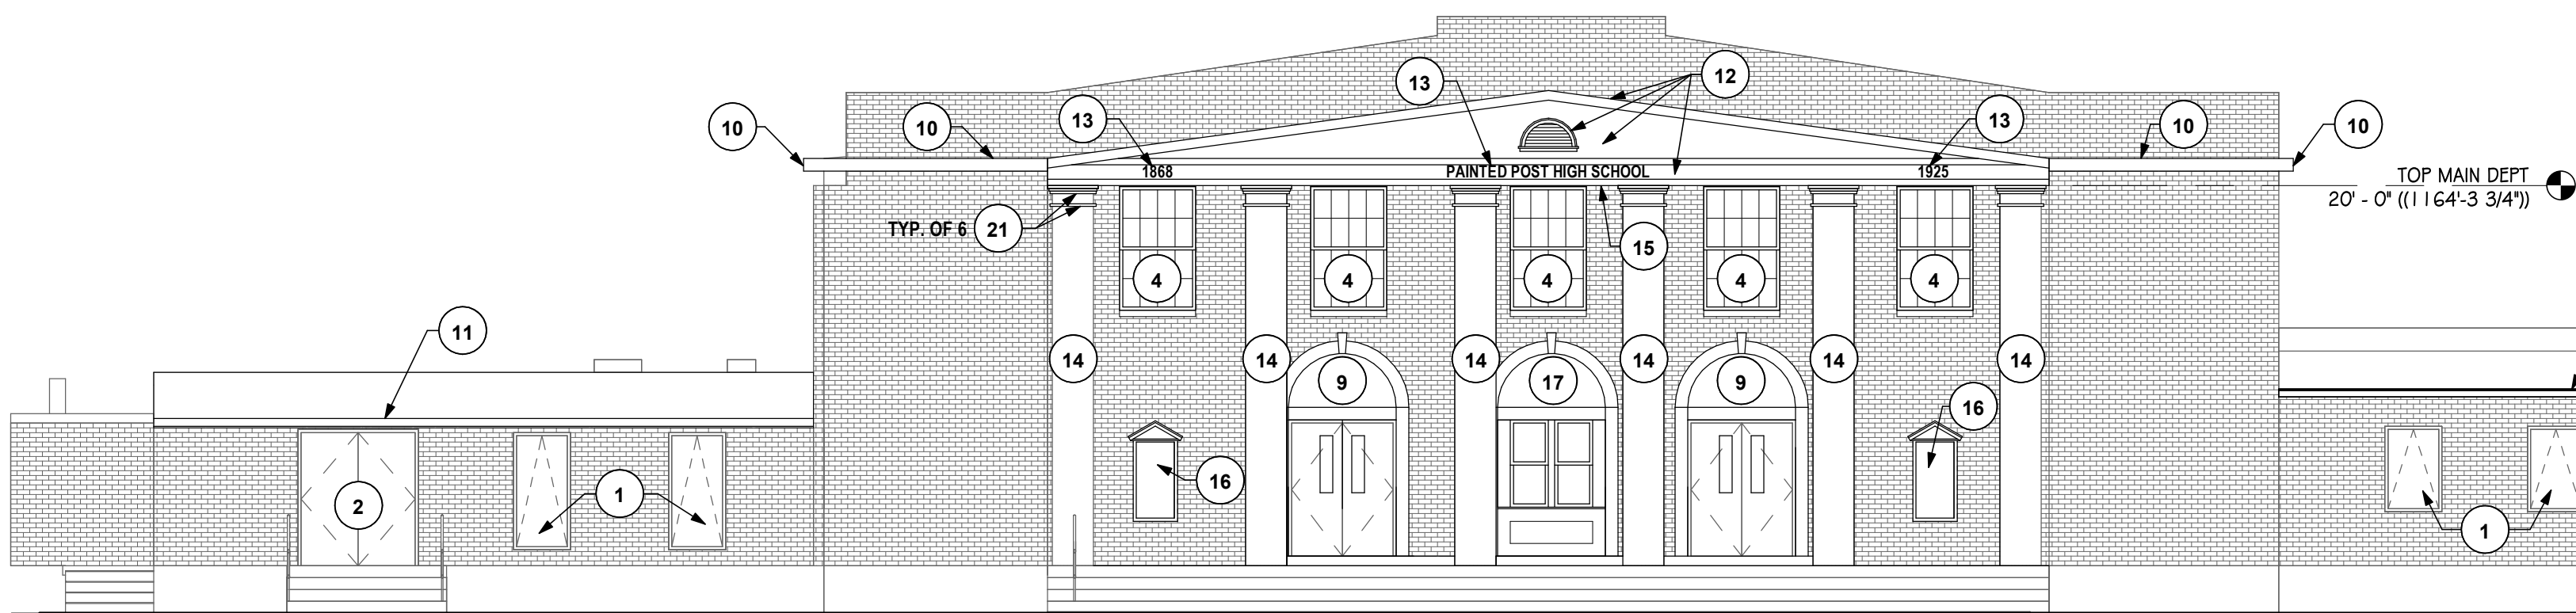

1 SOUTH ELEVATION (BASE BID)
1/8" = 1'-0"

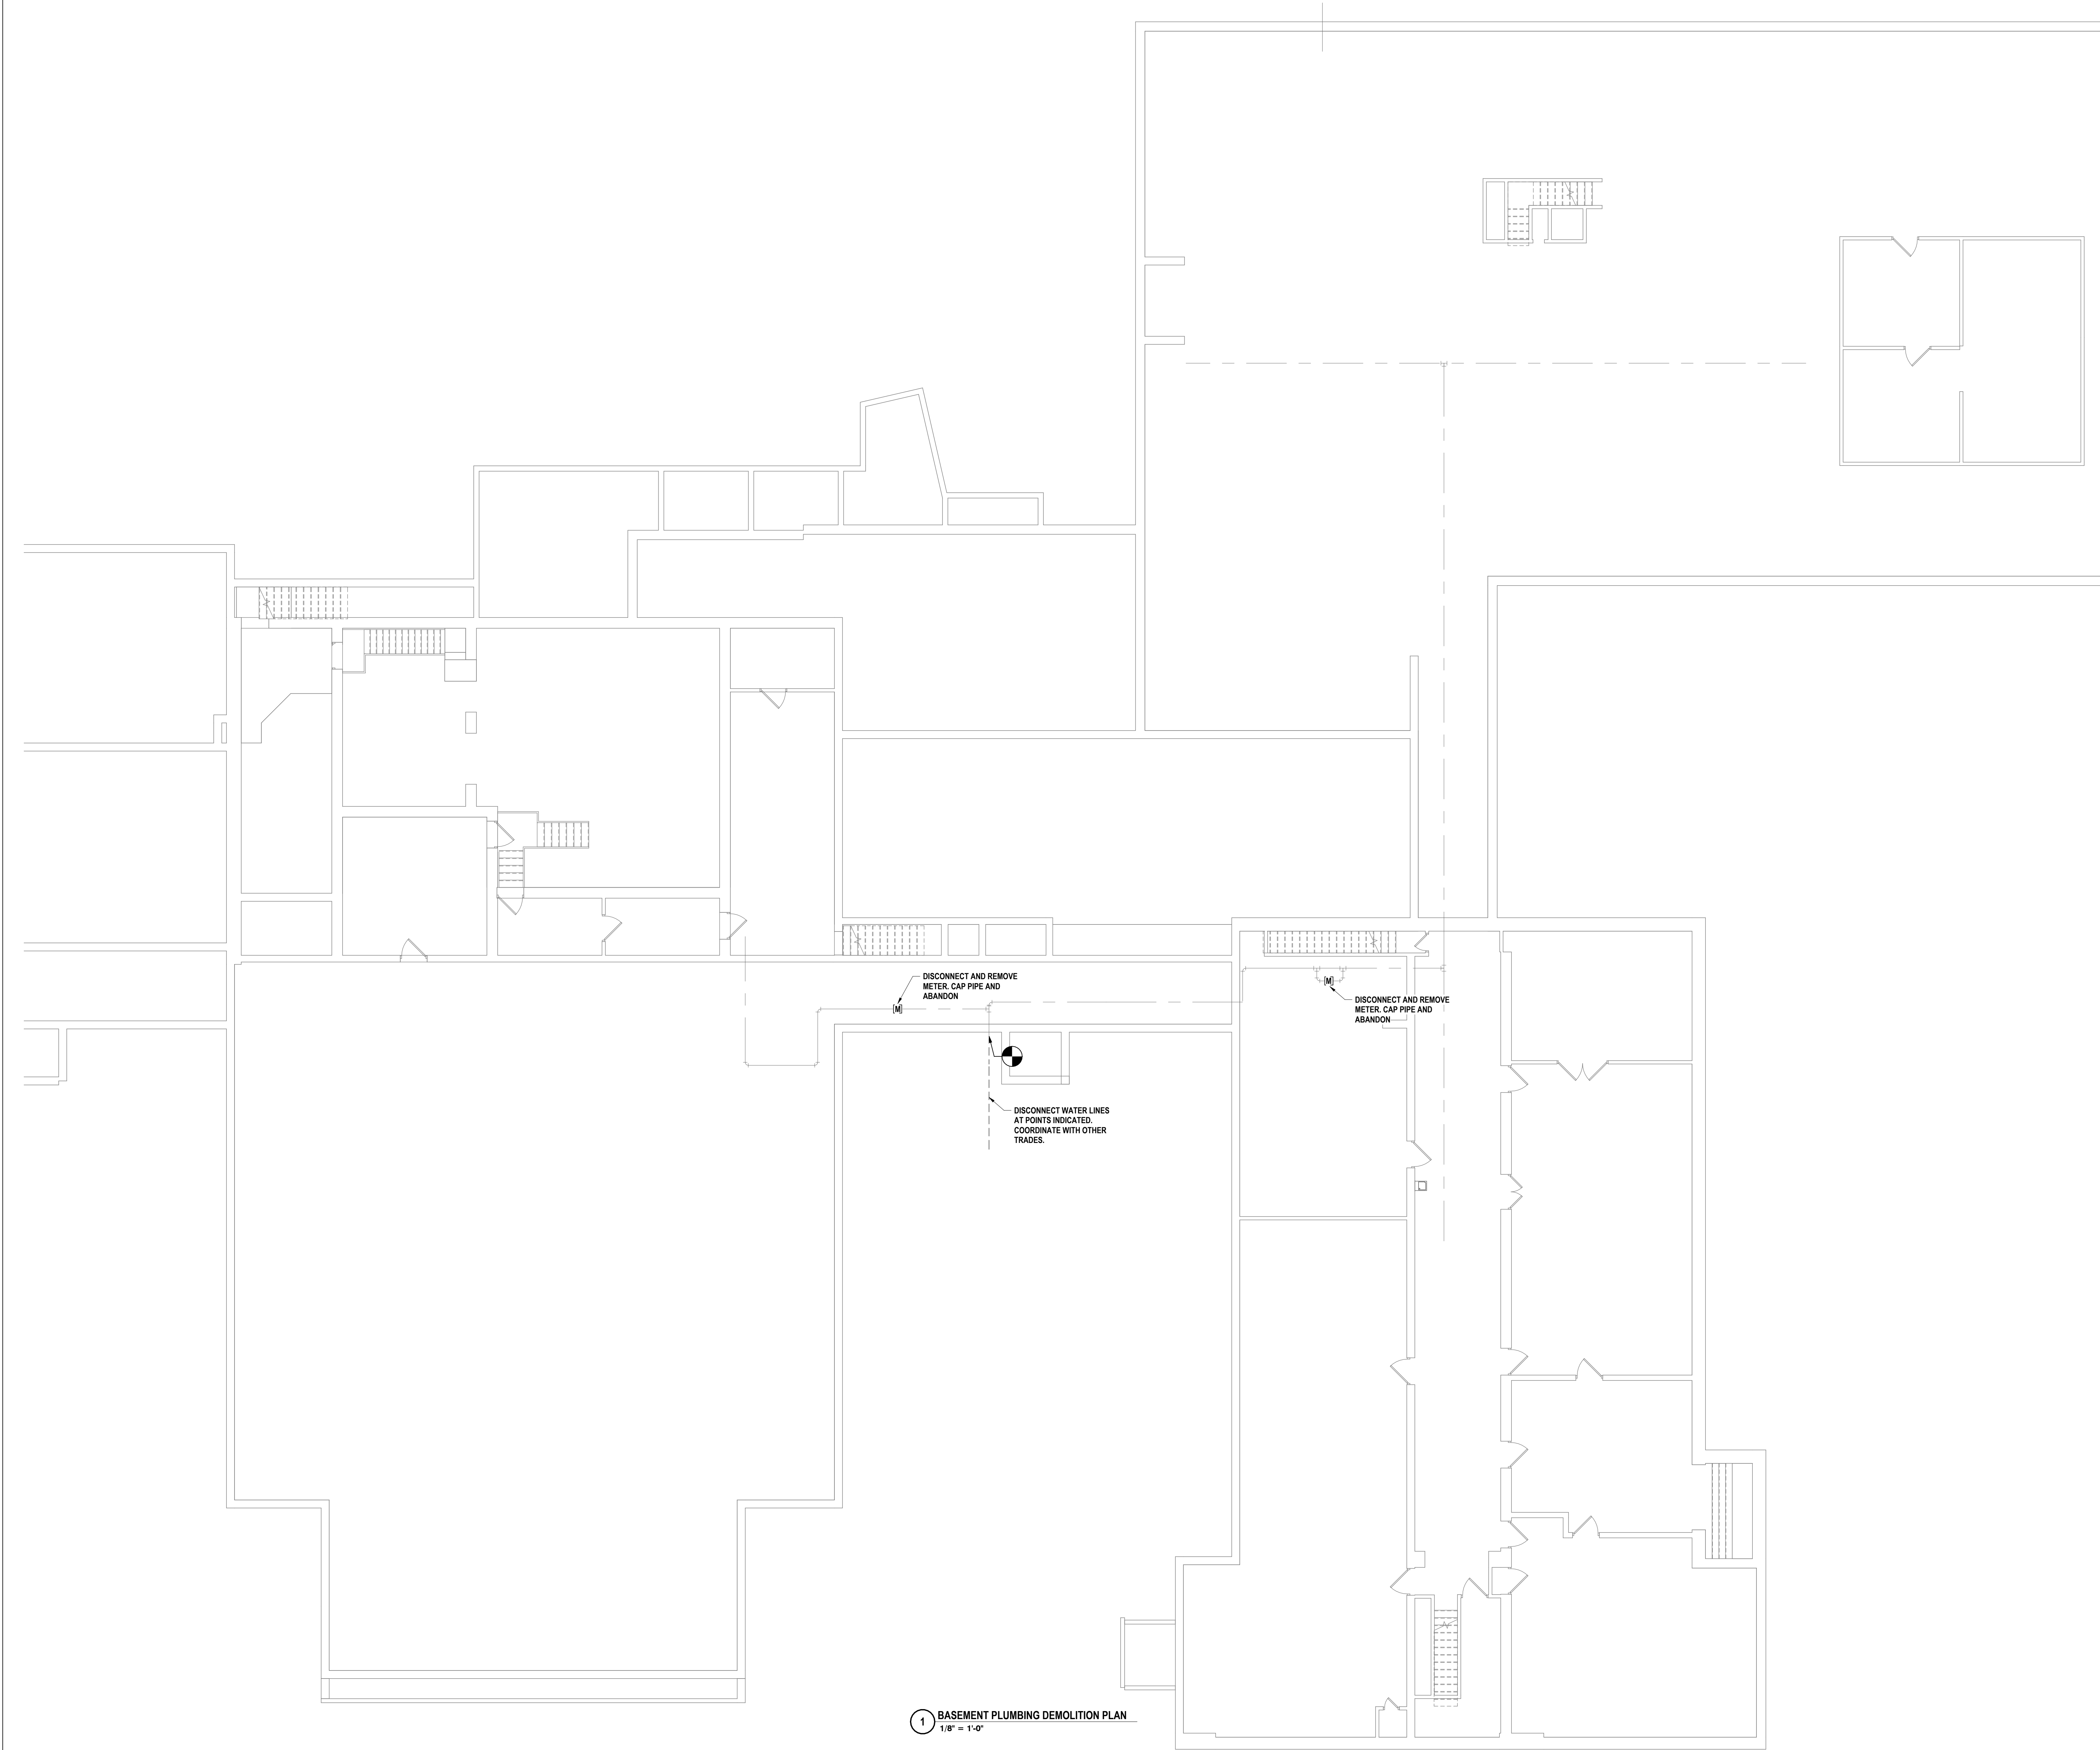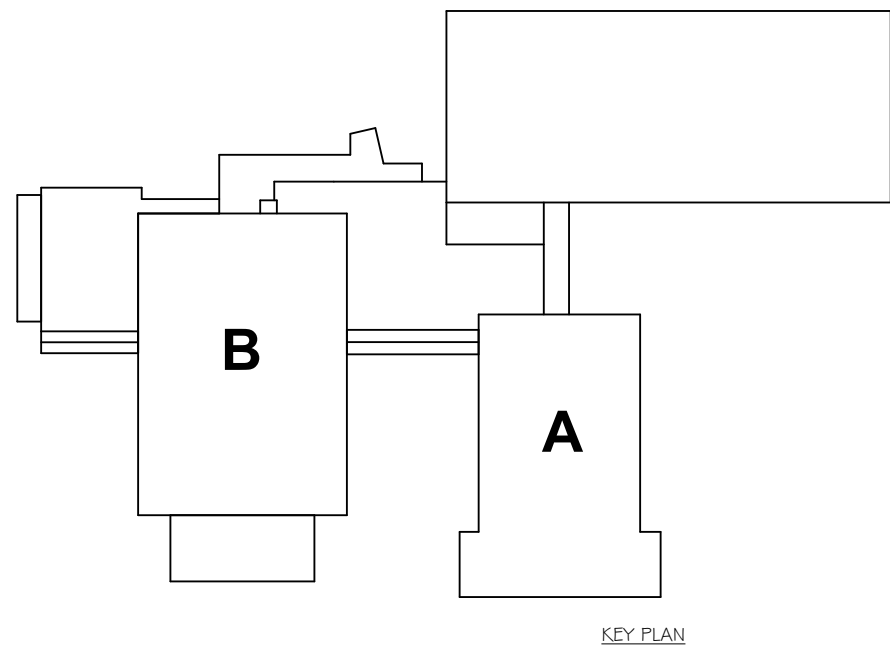

GENERAL NOTES - PLUMBING

- A ALL WORK ON THIS DRAWING IS THE RESPONSIBILITY OF THE PLUMBING CONTRACTOR UNLESS CLEARLY INDICATED TO BE PART OF ANOTHER CONTRACT.
- B THESE DRAWINGS ARE INTENDED TO SHOW THE GENERAL SCOPE OF ITEMS TO BE REMOVED. IT IS NOT INTENDED TO BE ALL INCLUSIVE. THE CONTRACTOR SHALL FIELD VERIFY ALL ITEMS TO BE REMOVED. ANY ITEM IN QUESTION SHOULD BE VERIFIED WITH ENGINEER PRIOR TO REMOVAL.
- C ALL ITEMS SCHEDULED FOR DEMOLITION ARE THE PROPERTY OF THE OWNER. THE CONTRACTOR SHALL PLACE WANTED EQUIPMENT IN AREA DESIGNATED ON SITE BY OWNER. ANY ITEM THE OWNER WISHES NOT TO KEEP SHALL BE PROPERLY DISPOSED OF BY THE CONTRACTOR.
- D THE CONTRACTOR SHALL REMOVE, PROTECT, REPLACE AND/OR REINSTALL ANY CEILING OR GRID DAMAGED OR REMOVED AS A RESULT OF EXECUTION OF CONTRACT SCOPE. UNLESS OTHERWISE INDICATED TO BE PART OF ANOTHER PRIME CONTRACT.
- E THE PLUMBING CONTRACTOR SHALL FIELD VERIFY ALL EXISTING CONDITIONS (FRAMING, ELECTRICAL, PLUMBING, HVAC, ETC) PRIOR TO CONSTRUCTION AND INSTALLATION OF NEW WORK. NOTIFY ARCHITECT/ENGINEER OF ANY CONFLICTS THAT REQUIRE MODIFICATION TO NEW PLUMBING SYSTEM INSTALLATION.
- F THE CONTRACTOR IS TO REINSULATE ALL PORTIONS OF EXISTING PLUMBING SYSTEM DISTURBED DURING EXECUTION OF CONTRACT SCOPE.
- G THE PLUMBING CONTRACTOR WILL BE RESPONSIBLE FOR ALL NEW FLOOR OPENINGS, EXCAVATIONS OF EXISTING SUBSTRATES AND WALL PENETRATIONS TO INSTALL NEW PIPING. UNLESS OTHERWISE NOTED, ALL PIPE PENETRATIONS THROUGH WALLS AND FLOORS WILL BE SEALED WITH FIRE-STOPPING.
- H UNLESS NOTED OTHERWISE THE PLUMBING CONTRACTOR IS RESPONSIBLE FOR INSTALLATION OF ALL PIPING WITHIN 5 FEET FROM BUILDING. COORDINATE CONNECTIONS.
- I THE PLUMBING CONTRACTOR WILL BE RESPONSIBLE FOR PATCHING AND SEALING OF ALL DISTURBED SUBSTRATE, WALLS AND CEILING TO EXISTING FINISHES UNLESS OTHERWISE NOTED.
- J THE PLUMBING CONTRACTOR TO COORDINATE ALL NEW ROOF, WALL & FLOOR PENETRATIONS.
- K INVERT DIMENSION IS TO BOTTOM OF PIPE.
- L ALL PIPING TO BE ROUTED AS HIGH AND AS TIGHT TO STEEL STRUCTURE AS POSSIBLE.
- M THE CONTRACTOR WILL BE RESPONSIBLE FOR FINAL CONNECTION OF PLUMBING UTILITIES TO ALL EQUIPMENT REQUIRING SAID UTILITIES, INCLUDING THOSE PROVIDED BY OTHERS. COORDINATE AS REQUIRED.
- N THE CONTRACTOR IS TO PROVIDE ADA COMPLIANT VINYL PIPE COVER ON EXPOSED COLD WATER, HOT WATER AND SANITARY PIPING BELOW ADA LAVATORY/SINK. SANITARY PIPE COVER SHALL BE INSTALLED UP TO BOTTOM OF FIXTURE.
- O REFER TO ARCH DRAWINGS FOR INDICATION OF ADA FIXTURES & ACCESSORIES, & ASSOCIATED MOUNTING HEIGHTS.

SEE NUMBERS EY-15-10-00-14-009-027, AD-15-10-00-01-1-001-415

BASEMENT DEMOLITION PLAN
2025 ERWIN VALLEY ELEM & ADMIN BUILDING ALTERATIONS
CORNING-PAINTED POST AREA SCHOOL DISTRICT
16 BEARTOWN ROAD, PAINTED POST NY 14870

AD-P0.1
PROJECT NO: 2649-160

HUNT ENGINEERS | ARCHITECTS | SURVEYORS
HORSEHEADS, NY 607-268-1000 ROCHESTER, NY 585-537-7849 TOWNANDA, PA 670-265-4666
BINGHAMTON, NY 607-798-8881 ALBANY, NY 607-798-8801
WWW.HUNTEAS.COM
NY CERTIFICATE NO. 001620 PA CERTIFICATE NO. TSC220313464-1


DRAWN BY: C.JH			Copyright: 2025
CHECKED BY: JDC			
DATE: 03/17/2026			
PHASE: CD			
#	DATE:	DESCRIPTION OF REVISION: ISSUED FOR BID	
1	10/12/2026		
			"IT IS A VIOLATION OF THE LAW FOR ANY PERSON TO MAKE UNAUTHORIZED ALTERATIONS OR ADDITIONS TO PLANS DRAWN BY A LICENSED ENGINEER, ARCHITECT, OR SURVEYOR'S SEAL."



1 BASEMENT PLAN
1/8" = 1'-0"

2 INTERIOR PIPING PROFILE
SCALE: N.T.S.

- PLUMBING NOTES:
1. PROVIDE 2" WATER SERVICE PIPE. SUPPORT WITH HANGERS AS NECESSARY. IF LINEAR PIPE LENGTH BETWEEN WALL AND BACKFLOW PREVENTER IS GREATER THAN 10', EXPOSED PIPING SHALL BE LABELED 'FEED LINE TO BACKFLOW PREVENTER'. DO NOT TAP AT 9' INTERVALS.
 2. PROVIDE 2" BACKFLOW PREVENTER ASSEMBLY. DESIGN BASIS: WATT'S LF009. BACKFLOW PREVENTER TO BE MOUNTED WITH CLEARANCE AS DESCRIBED IN THE NEW YORK STATE DEPARTMENT OF HEALTH GUIDELINES, UNLESS OTHERWISE SPECIFIED. CLEARANCES TO BE:
 - 2.1. 12" CLEAR SPACE ABOVE ASSEMBLY;
 - 2.2. 18" CLEAR SPACE BELOW ASSEMBLY;
 - 2.3. 30" CLEAR SPACE AHEAD; AND
 - 2.4. 8" CLEAR SPACE BEHIND.
 - 2.5. BACKFLOW PREVENTER TO BE INSTALLED WITH CENTERLINE 30" MIN. ABOVE FLOOR AND 60" MAX.
 3. PROVIDE 4" PVC DRAIN WITH BACKWATER VALVE FOR RPZ ASSEMBLY. 4" AIR GAP MINIMUM BETWEEN RPZ OUTLET AND DRAIN PIPE. CONNECT DRAIN PIPE TO OUTSIDE STORM DRAIN SHOWN ON SITE PLAN. SLOPE DRAIN PIPE TO ENSURE FLOW TO SANITARY SEWER WITH INVERT ELEVATION 938.1.
 4. CONNECT NEW 2" WATER SERVICE PIPE TO EXISTING 2" WATER SERVICE PIPE.
 5. PROVIDE NEW 2" WATER METER.

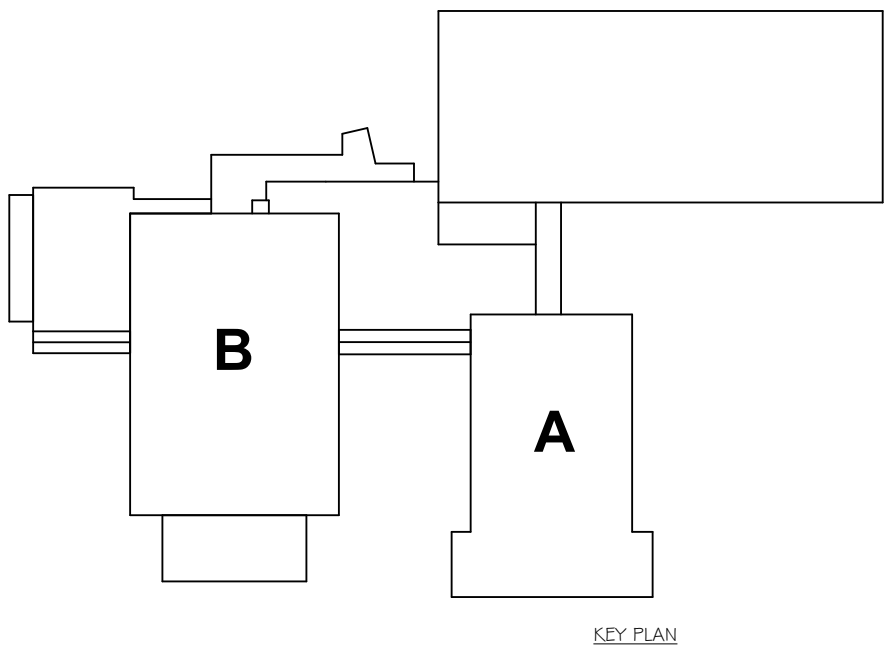

GENERAL NOTES - PLUMBING
REFER TO AD-P0.1

#	DATE:	DESCRIPTION OF REVISION:	DRAWN BY:	CJH
1	10/12/2026	ISSUED FOR BID	CHECKED BY:	JDO
			DATE:	03/17/2026
			PHASE:	CD
				CD

HUNT ENGINEERS | ARCHITECTS | SURVEYORS

HORSEHEADS, NY 10763-1000 ROCHESTER, NY 585-537-7549 TOWNHALL, PA 670-265-4668
BINGHAMTON, NY 607-738-8881 ALBANY, NY 607-738-8881 ALBANY, NY 607-738-8881
WWW.HUNTEAS.COM

NY CERTIFICATE NO. 001620 PA CERTIFICATE NO. 1SC220313464-1

BASEMENT PLANS

2025 ERWIN VALLEY ELEM & ADMIN BUILDING ALTERATIONS
CORNING-PAINTED POST AREA SCHOOL DISTRICT

16 BEARTOWN ROAD, PAINTED POST, NY 14870

AD-P1.1


PROJECT NO: 2649-160

GENERAL NOTES - ELECTRICAL


REFER TO SHEET EV-E1.1

CONSTRUCTION NOTES - POWER


- P5 PROVIDE NEW OR MODIFIED GROUNDING AND BONDING CONNECTIONS AS REQUIRED TO MAINTAIN CODE-COMPLIANT GROUNDING ELECTRODE SYSTEM FOLLOWING REPLACEMENT OF THE EXISTING WATER SERVICE.
- P6 RECONNECT AFFECTED GROUNDING AND BONDING CONDUCTORS UPON COMPLETION OF THE NEW GROUNDING ELECTRODE SYSTEM.

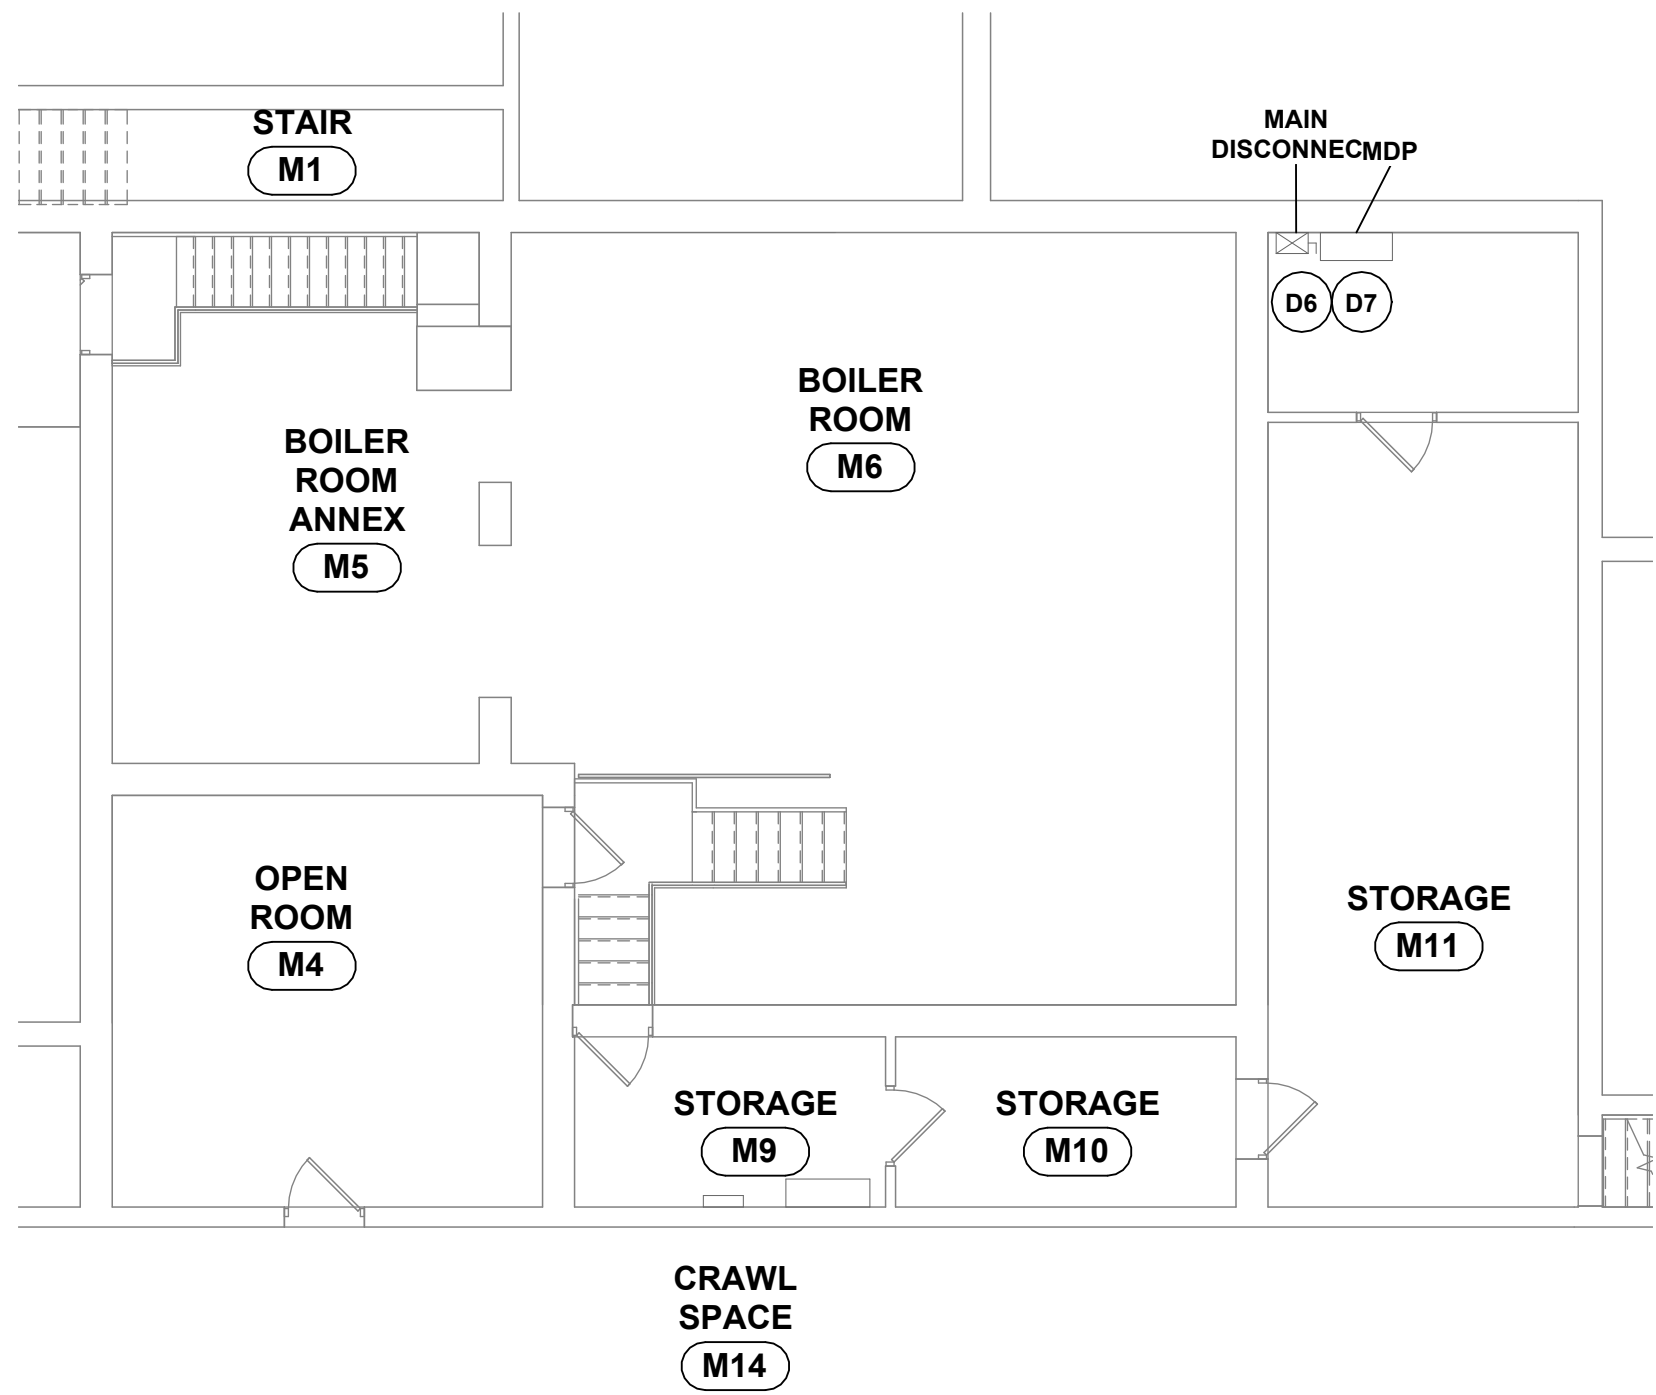

2 BASEMENT ELECTRICAL DEMOLITION PLAN
1/8" = 1'-0"

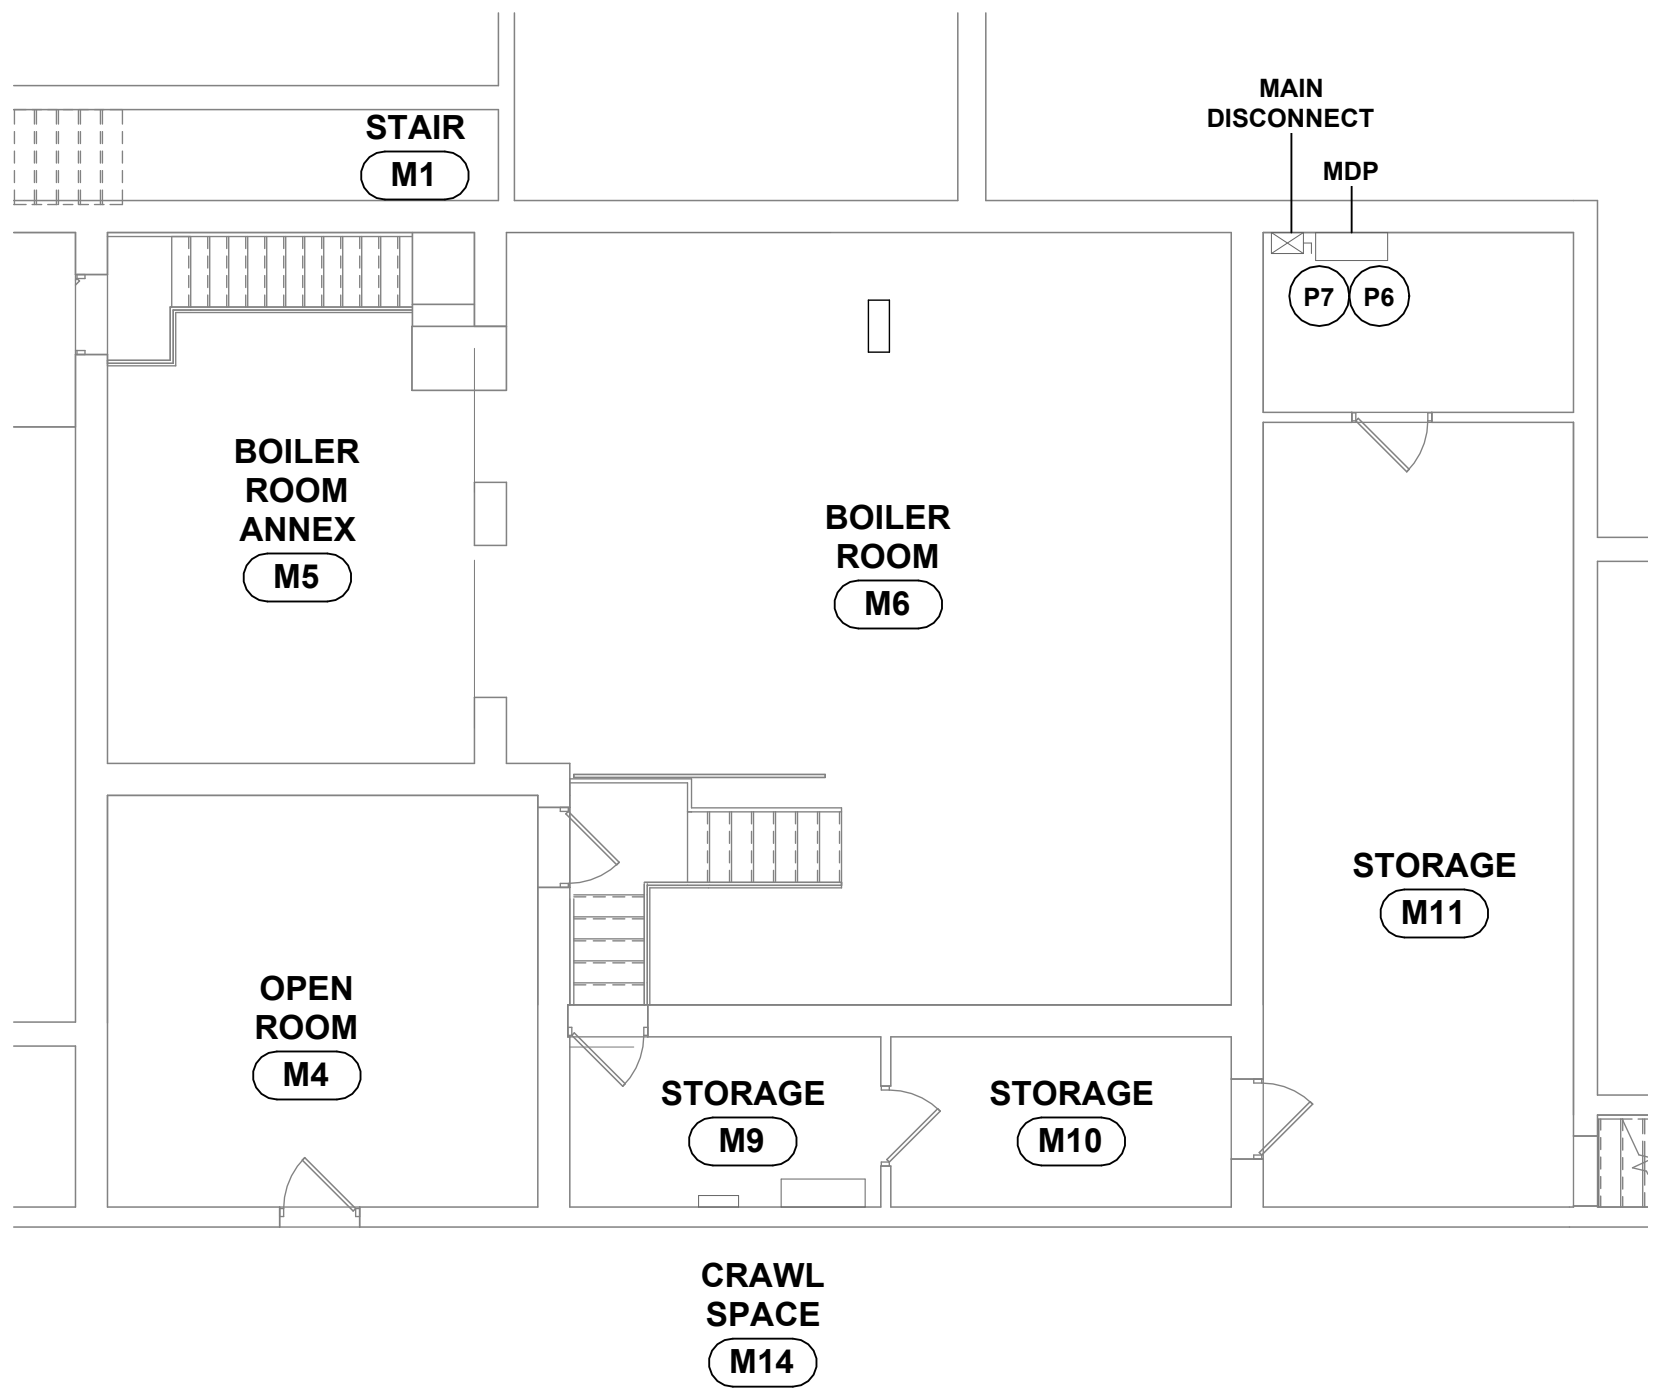

1 GROUND FLOOR ELECTRICAL POWER PLAN
1/8" = 1'-0"

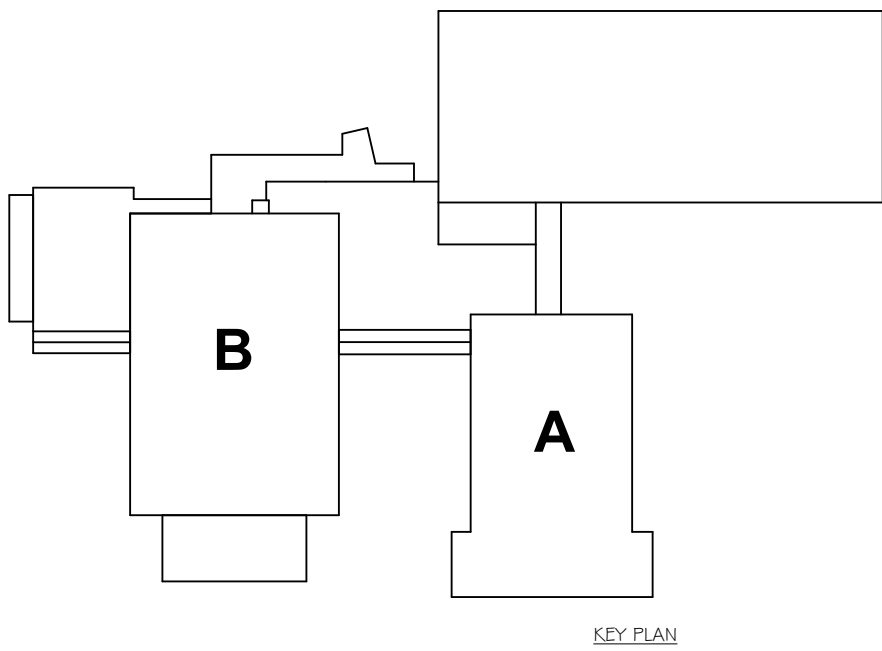

S&P NUMBERS EV-1510-00-014-000-007, AD-2510-00-011-001-015

GROUND FLOOR ELECTRICAL PLAN

2025 ERWIN VALLEY ELEM & ADMIN BUILDING ALTERATIONS
CORNING-PAINTED POST AREA SCHOOL DISTRICT

16 BEARTOWN ROAD, PAINTED POST, NY 14870

AD-E1.1

PROJECT NO: 2649-160

HUNT ENGINEERS | ARCHITECTS | SURVEYORS

HORSEHEADS, NY 607-268-1000 ROCHESTER, NY 565-537-7549 TOWNHALL, PA 570-265-4666
BINGHAMTON, NY 607-798-8881 ALBANY, NY 607-798-8801
WWW.HUNTEAS.COM

NY CERTIFICATE NO. 001620 PA CERTIFICATE NO. TSC22013464-1

#	DATE:	DESCRIPTION OF REVISION:	ISSUED FOR BID
1	10/12/2026		
		IT IS A VIOLATION OF THE LAW FOR ANY PERSON TO MAKE UNAUTHORIZED ALTERATIONS OR ADDITIONS TO PLANS DRAWN BY A LICENSED ENGINEER OR ARCHITECT'S SURVEYOR'S SEAL.	

DRAWN BY:	GDY
CHECKED BY:	TAWO
DATE:	03/17/2026
PHASE:	CD

Copyright 2026